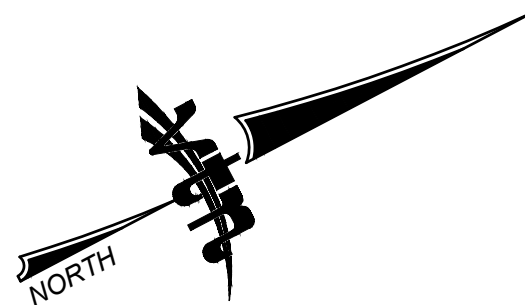
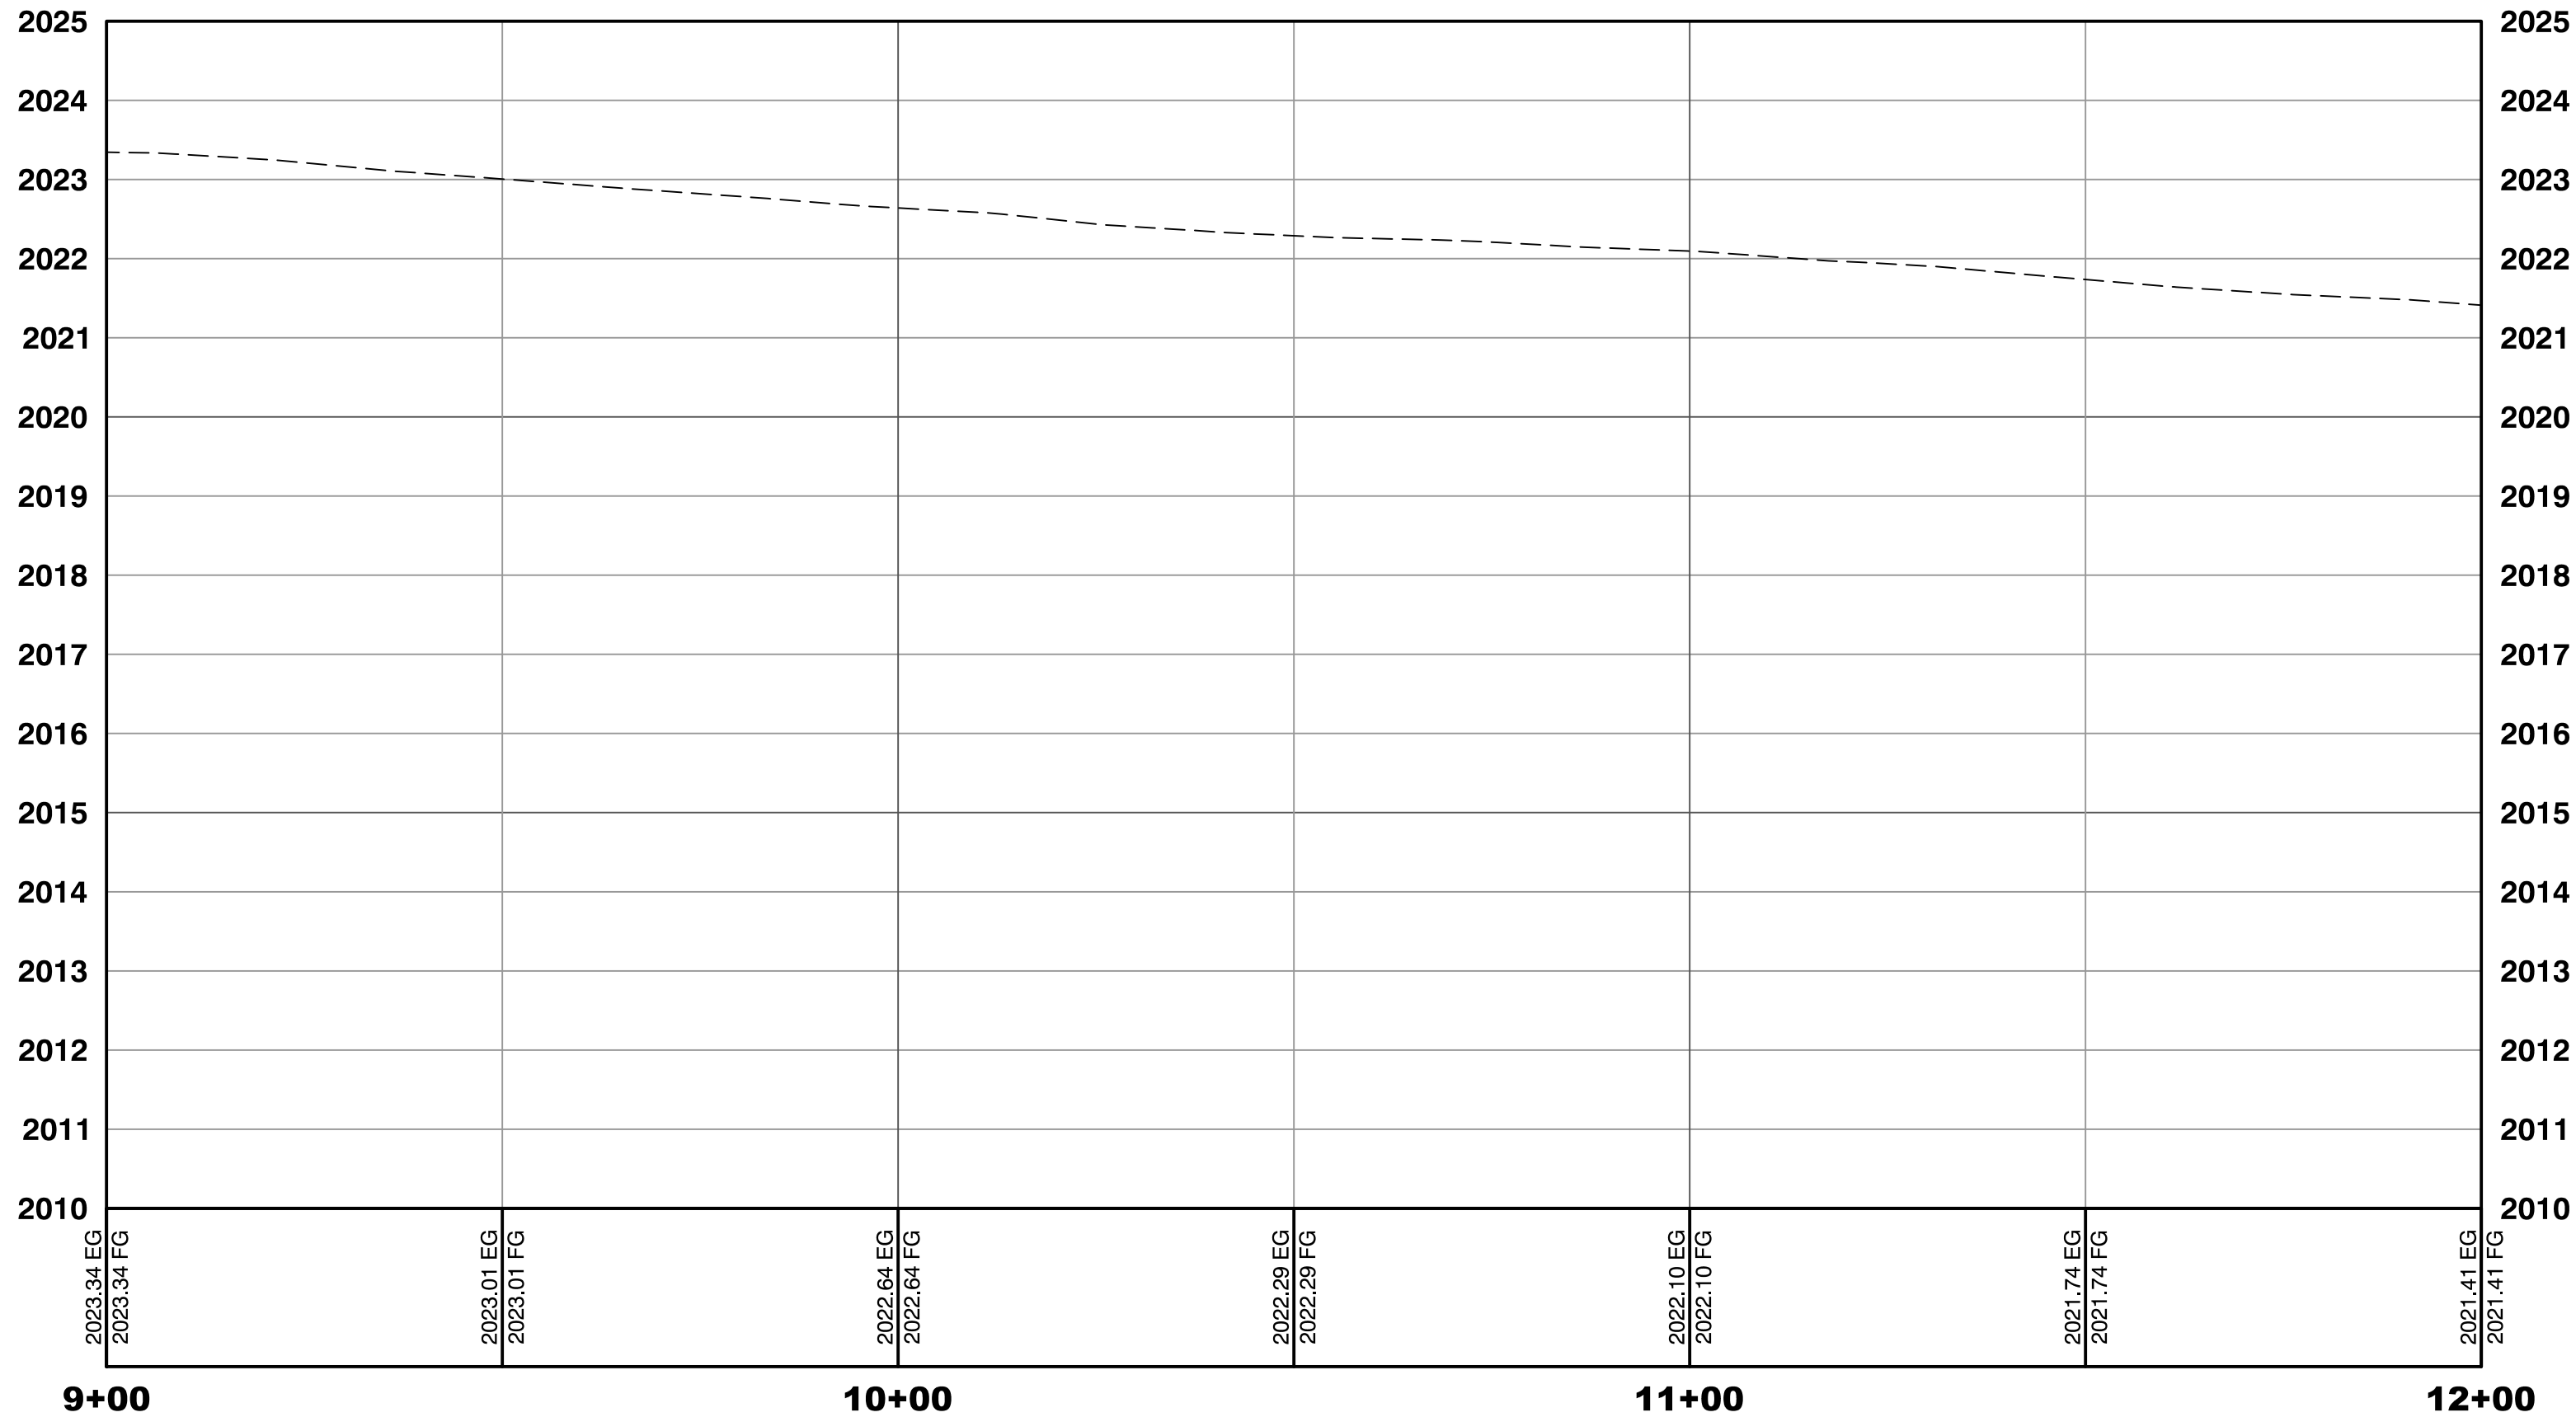



LEGEND	
	DRIVEWAY LIMITS
	PROPOSED AEP
	PAVERS
	SPECIALTY CONCRETE
	PLANTING HATCH
	TURF HATCH
	EXISTING PARKING METER TO BE RELOCATED, CONTRACTOR TO COORDINATE WITH THE CITY.
	EXISTING LIGHT POLE
	EXISTING UTILITY POLE
	EXISTING WATER VALVE
W=M	EXISTING WATER METER
	EXISTING FIRE HYDRANT
	EXISTING UTILITY BOX
	EXISTING OVERHEAD ELECTRIC
	EXISTING STREETLIGHT CONDUIT
	EXISTING FENCE
	EXISTING CURB
	EXISTING SIDEWALK
	RIGHT-OF-WAY LINE
	EXISTING PROPERTY LINE
	PROPOSED CURB
	PROPOSED LIP
	PROPOSED FLOWLINE

ROADWAY & PAVING NOTES



6	SURVEY MONUMENT, P.I.P.
7	SAWCUT AND MATCH EX. AC.
10	INSTALL 24" R" TYPE CURB & GUTTER PER CCUSD NO. 217 S2
3A	INSTALL 5" AC PAVEMENT OVER 14" TYPE II AGGREGATE BASE OR MATCH EXISTING PAVEMENT SECTION, WHICHEVER IS GREATER. SEE TYPICAL SECTIONS FOR DETAILS.
3B	INSTALL PAVERS OVER 14" TYPE II AGGREGATE BASE OR MATCH EXISTING PAVEMENT SECTION, WHICHEVER IS GREATER. SEE HARDSCAPE PLANS FOR DETAILS.
17	INSTALL 8" CROSS GUTTER PER USD NO. 228.
35	RELOCATED FIRE HYDRANT. SEE WATER RELOCATION PLANS

CURVE TABLE				
CURVE	RADIUS	DELTA	LENGTH	TANGENT
C20	25.00'	90°00'34"	39.27'	25.00'
C21	25.01'	91°06'02"	39.76'	25.49'
C22	25.00'	89°59'26"	39.27'	25.00'
C23	25.00'	90°01'33"	39.28'	25.01'
C53	10.00'	49°01'17"	8.56'	4.56'
C54	10.00'	48°16'57"	8.43'	4.48'
C55	10.00'	49°28'31"	8.64'	4.61'
C56	10.00'	49°23'35"	8.62'	4.60'
C57	10.00'	49°31'24"	8.64'	4.61'
C58	10.00'	49°31'24"	8.64'	4.61'
C59	10.00'	49°28'42"	8.63'	4.60'
C60	10.00'	49°26'42"	8.63'	4.60'

REFERENCE NOTES 1. SEE HARDSCAPE PLANS FOR PLANTER BOX LOCATIONS. 2. REFER TO STREET LIGHTING PLANS FOR NEW STREET LIGHT LOCATIONS.
LAS VEGAS VALLEY WATER DISTRICT REMOVAL NOTE RELOCATED SERVICES WITH LESS THAN 1" LATERALS MUST HAVE A MINIMUM OF 1" LATERALS.
LAS VEGAS VALLEY WATER DISTRICT APPROVAL APPROVED FOR CONSTRUCTION
LAS VEGAS VALLEY WATER DISTRICT ENGINEERING SERVICES MANAGER DATE: _____ PROJECT: ##### LVVWD APPROVED FIRE FLOW ##### GPM AT 20 P.S.I. RESIDUAL

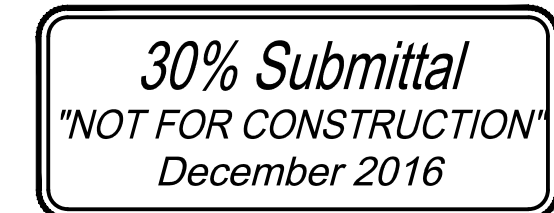

	SHEET R10 22 OF 61 DRAWING NO. _____	DOWNTOWN PEDESTRIAN AND BICYCLE IMPROVEMENTS 3RD STREET-PHASE 2 CHARLESTON TO BONNEVILLE		ROADWAY PLAN & PROFILE		CITY OF LAS VEGAS		PREPARED BY  2727 SOUTH RAINBOW BOULEVARD LAS VEGAS, NV 89146-5148 PH. (702) 872-7500 FAX (702) 362-2597 WEB SITE WWW.VTVN.VM.COM		NO. DATE REVISIONS	
		SHEET		H# 54616		BID# ----		DESIGNED BY: MD		DEPARTMENT OF PUBLIC WORKS 333 N. RANCHO DRIVE LAS VEGAS, NV 89106 702-229-6275	
		DATE: --		SUBMITTAL STAGE:		DRAWN BY: ND		CHECKED BY: LL		30% Submittal	
		30% Submittal		30% Submittal		30% Submittal		30% Submittal		30% Submittal	

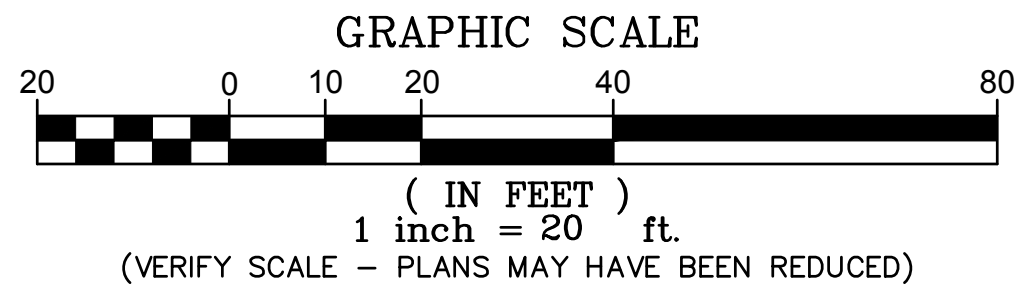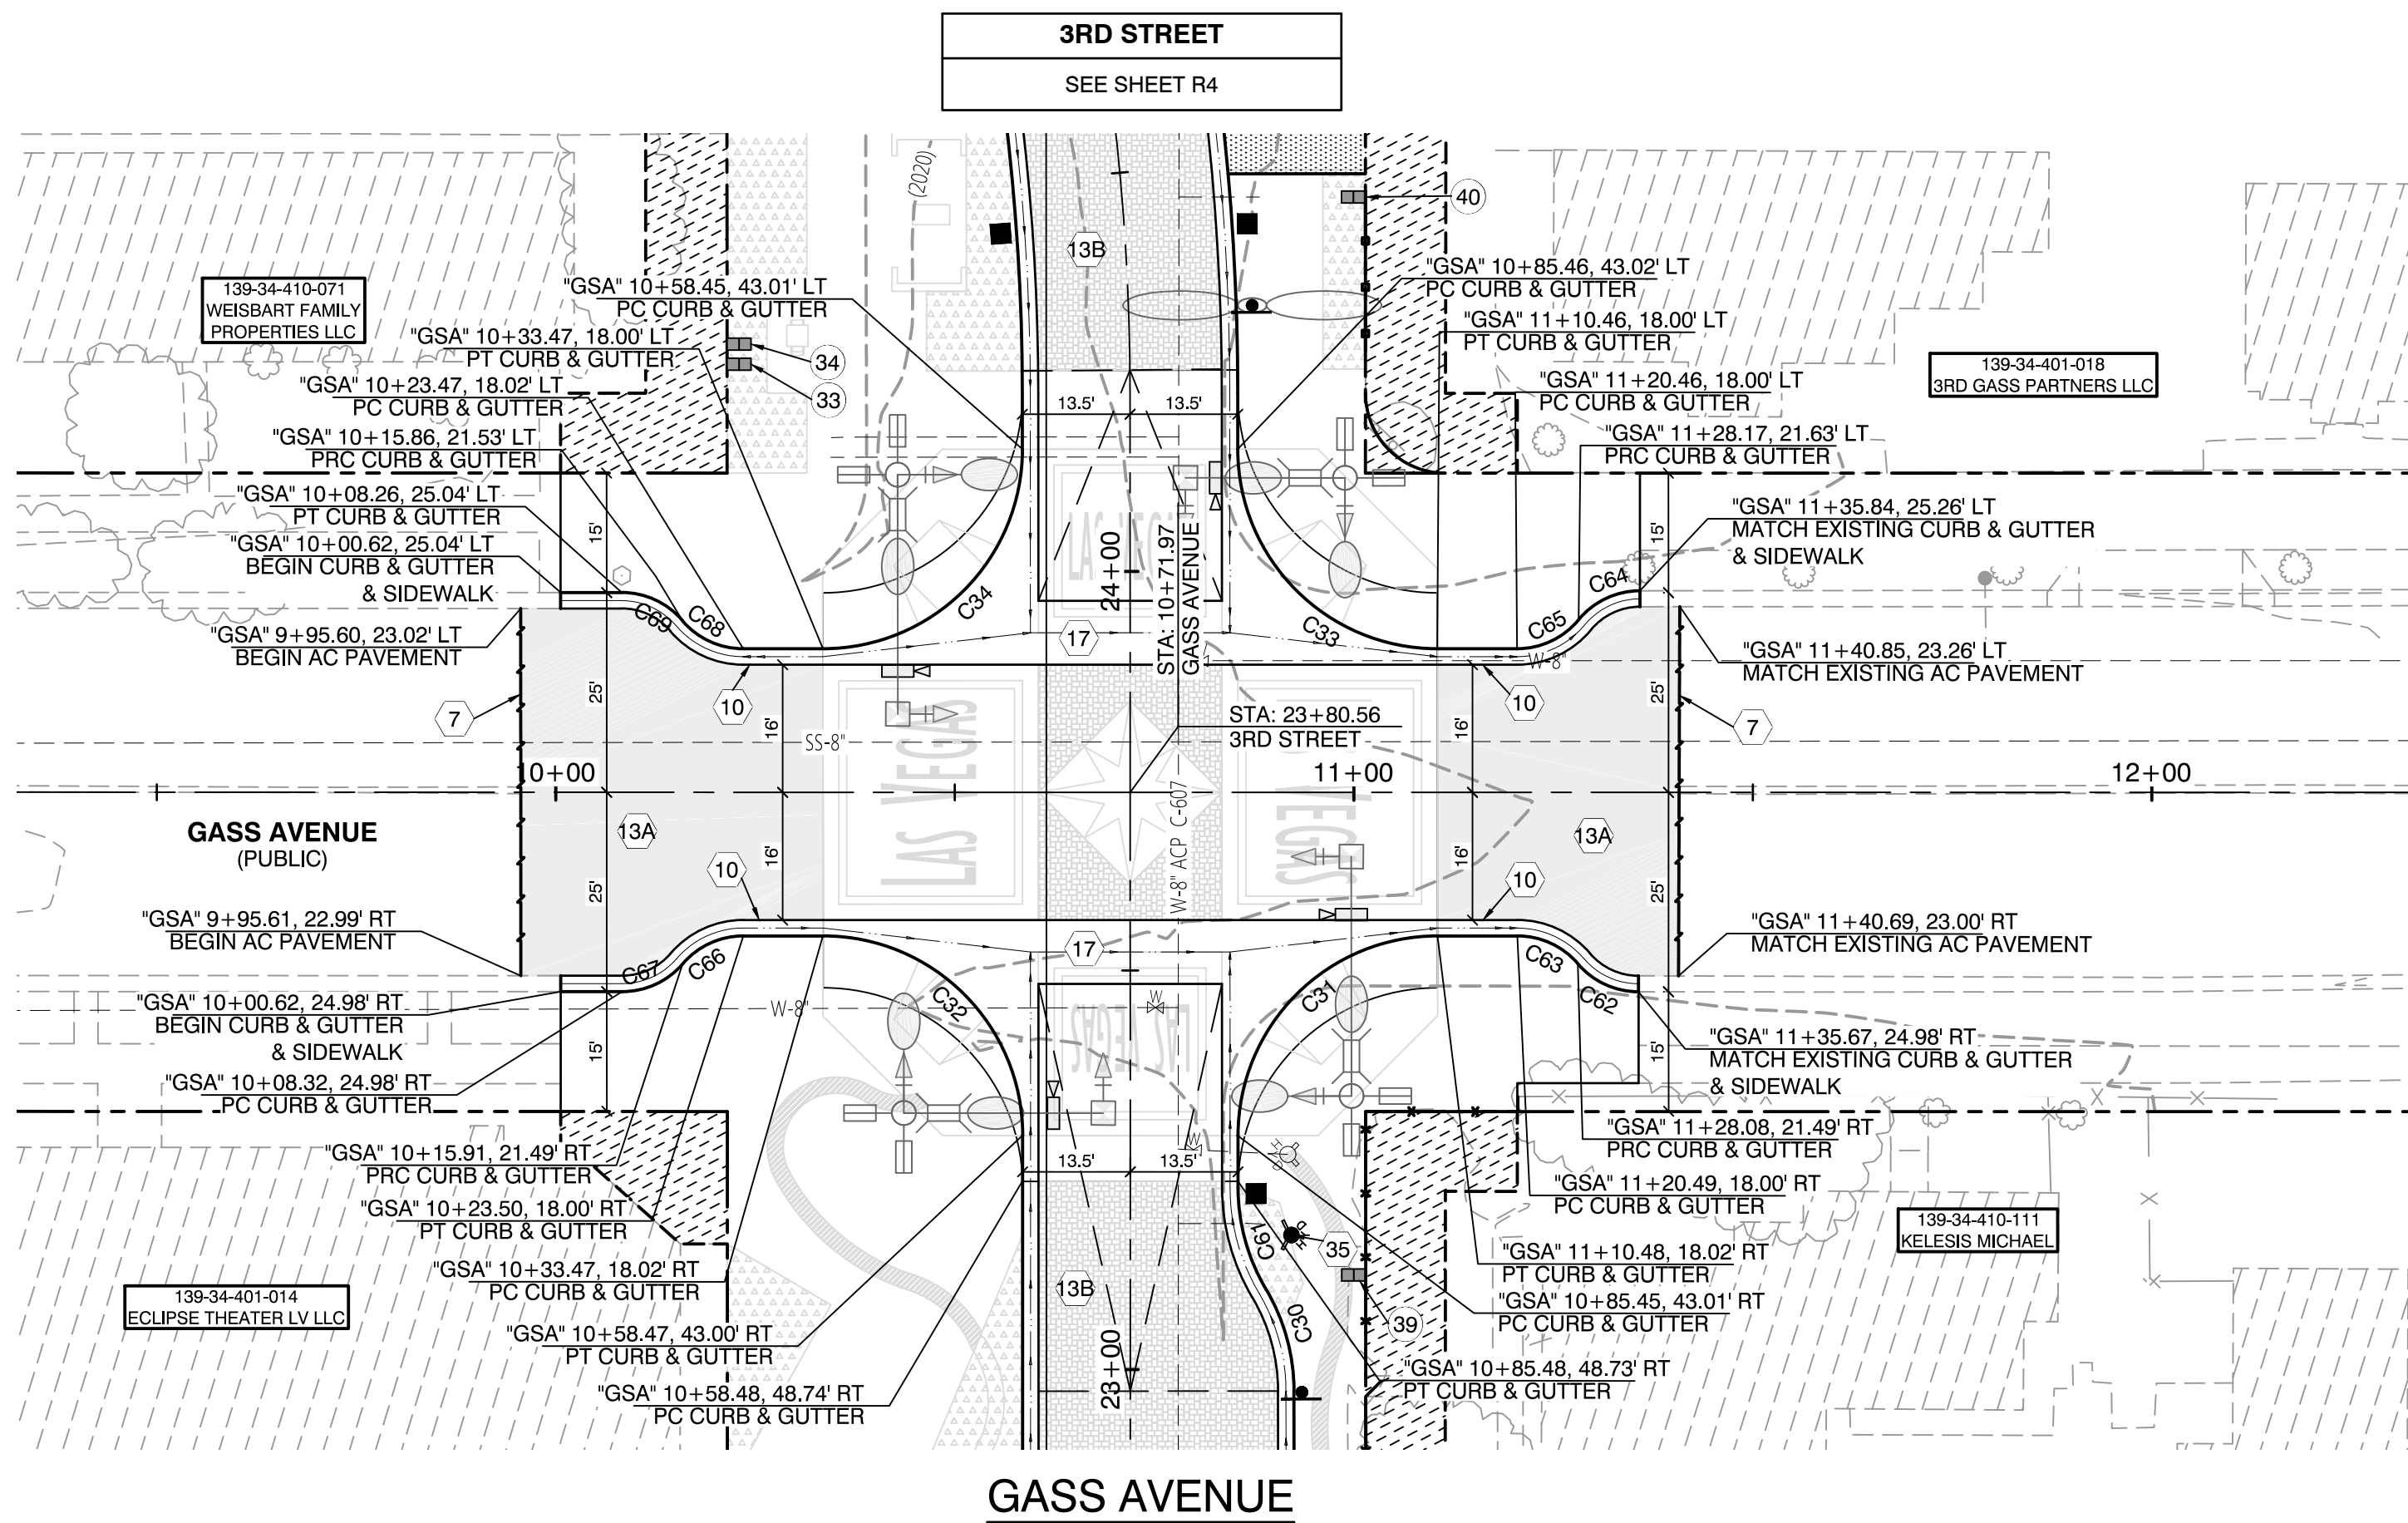

- LEGEND**
- DRIVEWAY LIMITS
 - PROPOSED AEP
 - PAVERS
 - SPECIALTY CONCRETE
 - PLANTING HATCH
 - TURF HATCH
 - EXISTING PARKING METER TO BE RELOCATED. CONTRACTOR TO COORDINATE WITH THE CITY.
 - EXISTING LIGHT POLE
 - EXISTING UTILITY POLE
 - EXISTING WATER VALVE
 - EXISTING WATER METER
 - EXISTING FIRE HYDRANT
 - EXISTING UTILITY BOX
 - EXISTING OVERHEAD ELECTRIC
 - EXISTING STREETLIGHT CONDUIT
 - EXISTING FENCE
 - EXISTING CURB
 - EXISTING SIDEWALK
 - RIGHT-OF-WAY LINE
 - EXISTING PROPERTY LINE
 - PROPOSED CURB
 - PROPOSED LIP
 - PROPOSED FLOWLINE

- ROADWAY & PAVING NOTES**
- SAWCUT AND MATCH EX. AC.
 - INSTALL 24" "R" TYPE CURB & GUTTER PER CCUSD NO. 217 S2.
 - INSTALL 5" AC PAVEMENT OVER 14" TYPE II AGGREGATE BASE OR MATCH EXISTING PAVEMENT SECTION, WHICHEVER IS GREATER. SEE TYPICAL SECTIONS FOR DETAILS.
 - INSTALL PAVERS OVER 14" TYPE II AGGREGATE BASE OR MATCH EXISTING PAVEMENT SECTION, WHICHEVER IS GREATER. SEE HARDSCAPE PLANS FOR DETAILS.
 - INSTALL 8" CROSS GUTTER PER USD NO. 228.
 - RELOCATED FIRE HYDRANT. SEE WATER RELOCATION PLANS.

CURVE TABLE				
CURVE	RADIUS	DELTA	LENGTH	TANGENT
C30	25.00'	30°41'00"	13.39'	6.86'
C31	25.00'	90°01'00"	39.28'	25.01'
C32	25.00'	89°58'16"	39.26'	24.99'
C33	25.00'	89°59'00"	39.26'	24.99'
C34	25.00'	90°01'44"	39.28'	25.01'
C61	25.00'	30°41'00"	13.39'	6.86'
C62	10.00'	49°23'24"	8.62'	4.60'
C63	10.00'	49°23'49"	8.62'	4.60'
C64	10.00'	50°19'26"	8.78'	4.70'
C65	10.00'	50°25'06"	8.80'	4.71'
C66	10.00'	49°22'56"	8.62'	4.60'
C67	10.00'	49°22'36"	8.62'	4.60'
C68	10.00'	49°32'04"	8.65'	4.61'
C69	10.00'	49°31'44"	8.64'	4.61'

WATER SERVICE INFORMATION	
33	ACCT #149405, MTR #957286, 5/8" MTR W/ 1" DCVA
34	ACCT #149406, MTR #903002
39	ACCT #3833, MTR #615774, 5/8" MTR W/ 1" DCVA
40	ACCT #3583, MTR #701176, 5/8" MTR W/ 1" DCVA


REFERENCE NOTES	
1.	SEE HARDSCAPE PLANS FOR PLANTER BOX LOCATIONS.
2.	REFER TO STREET LIGHTING PLANS FOR NEW STREET LIGHT LOCATIONS.

LAS VEGAS VALLEY WATER DISTRICT REMOVAL NOTE	
RELOCATED SERVICES WITH LESS THAN 1" LATERALS MUST HAVE A MINIMUM OF 1" LATERALS.	

LAS VEGAS VALLEY WATER DISTRICT APPROVAL	
APPROVED FOR CONSTRUCTION	
LAS VEGAS VALLEY WATER DISTRICT ENGINEERING SERVICES MANAGER	
DATE: _____	PROJECT:####
LVVWD APPROVED FIRE FLOW #### GPM AT 20 P.S.I. RESIDUAL	



30% Submittal
"NOT FOR CONSTRUCTION"
December 2016

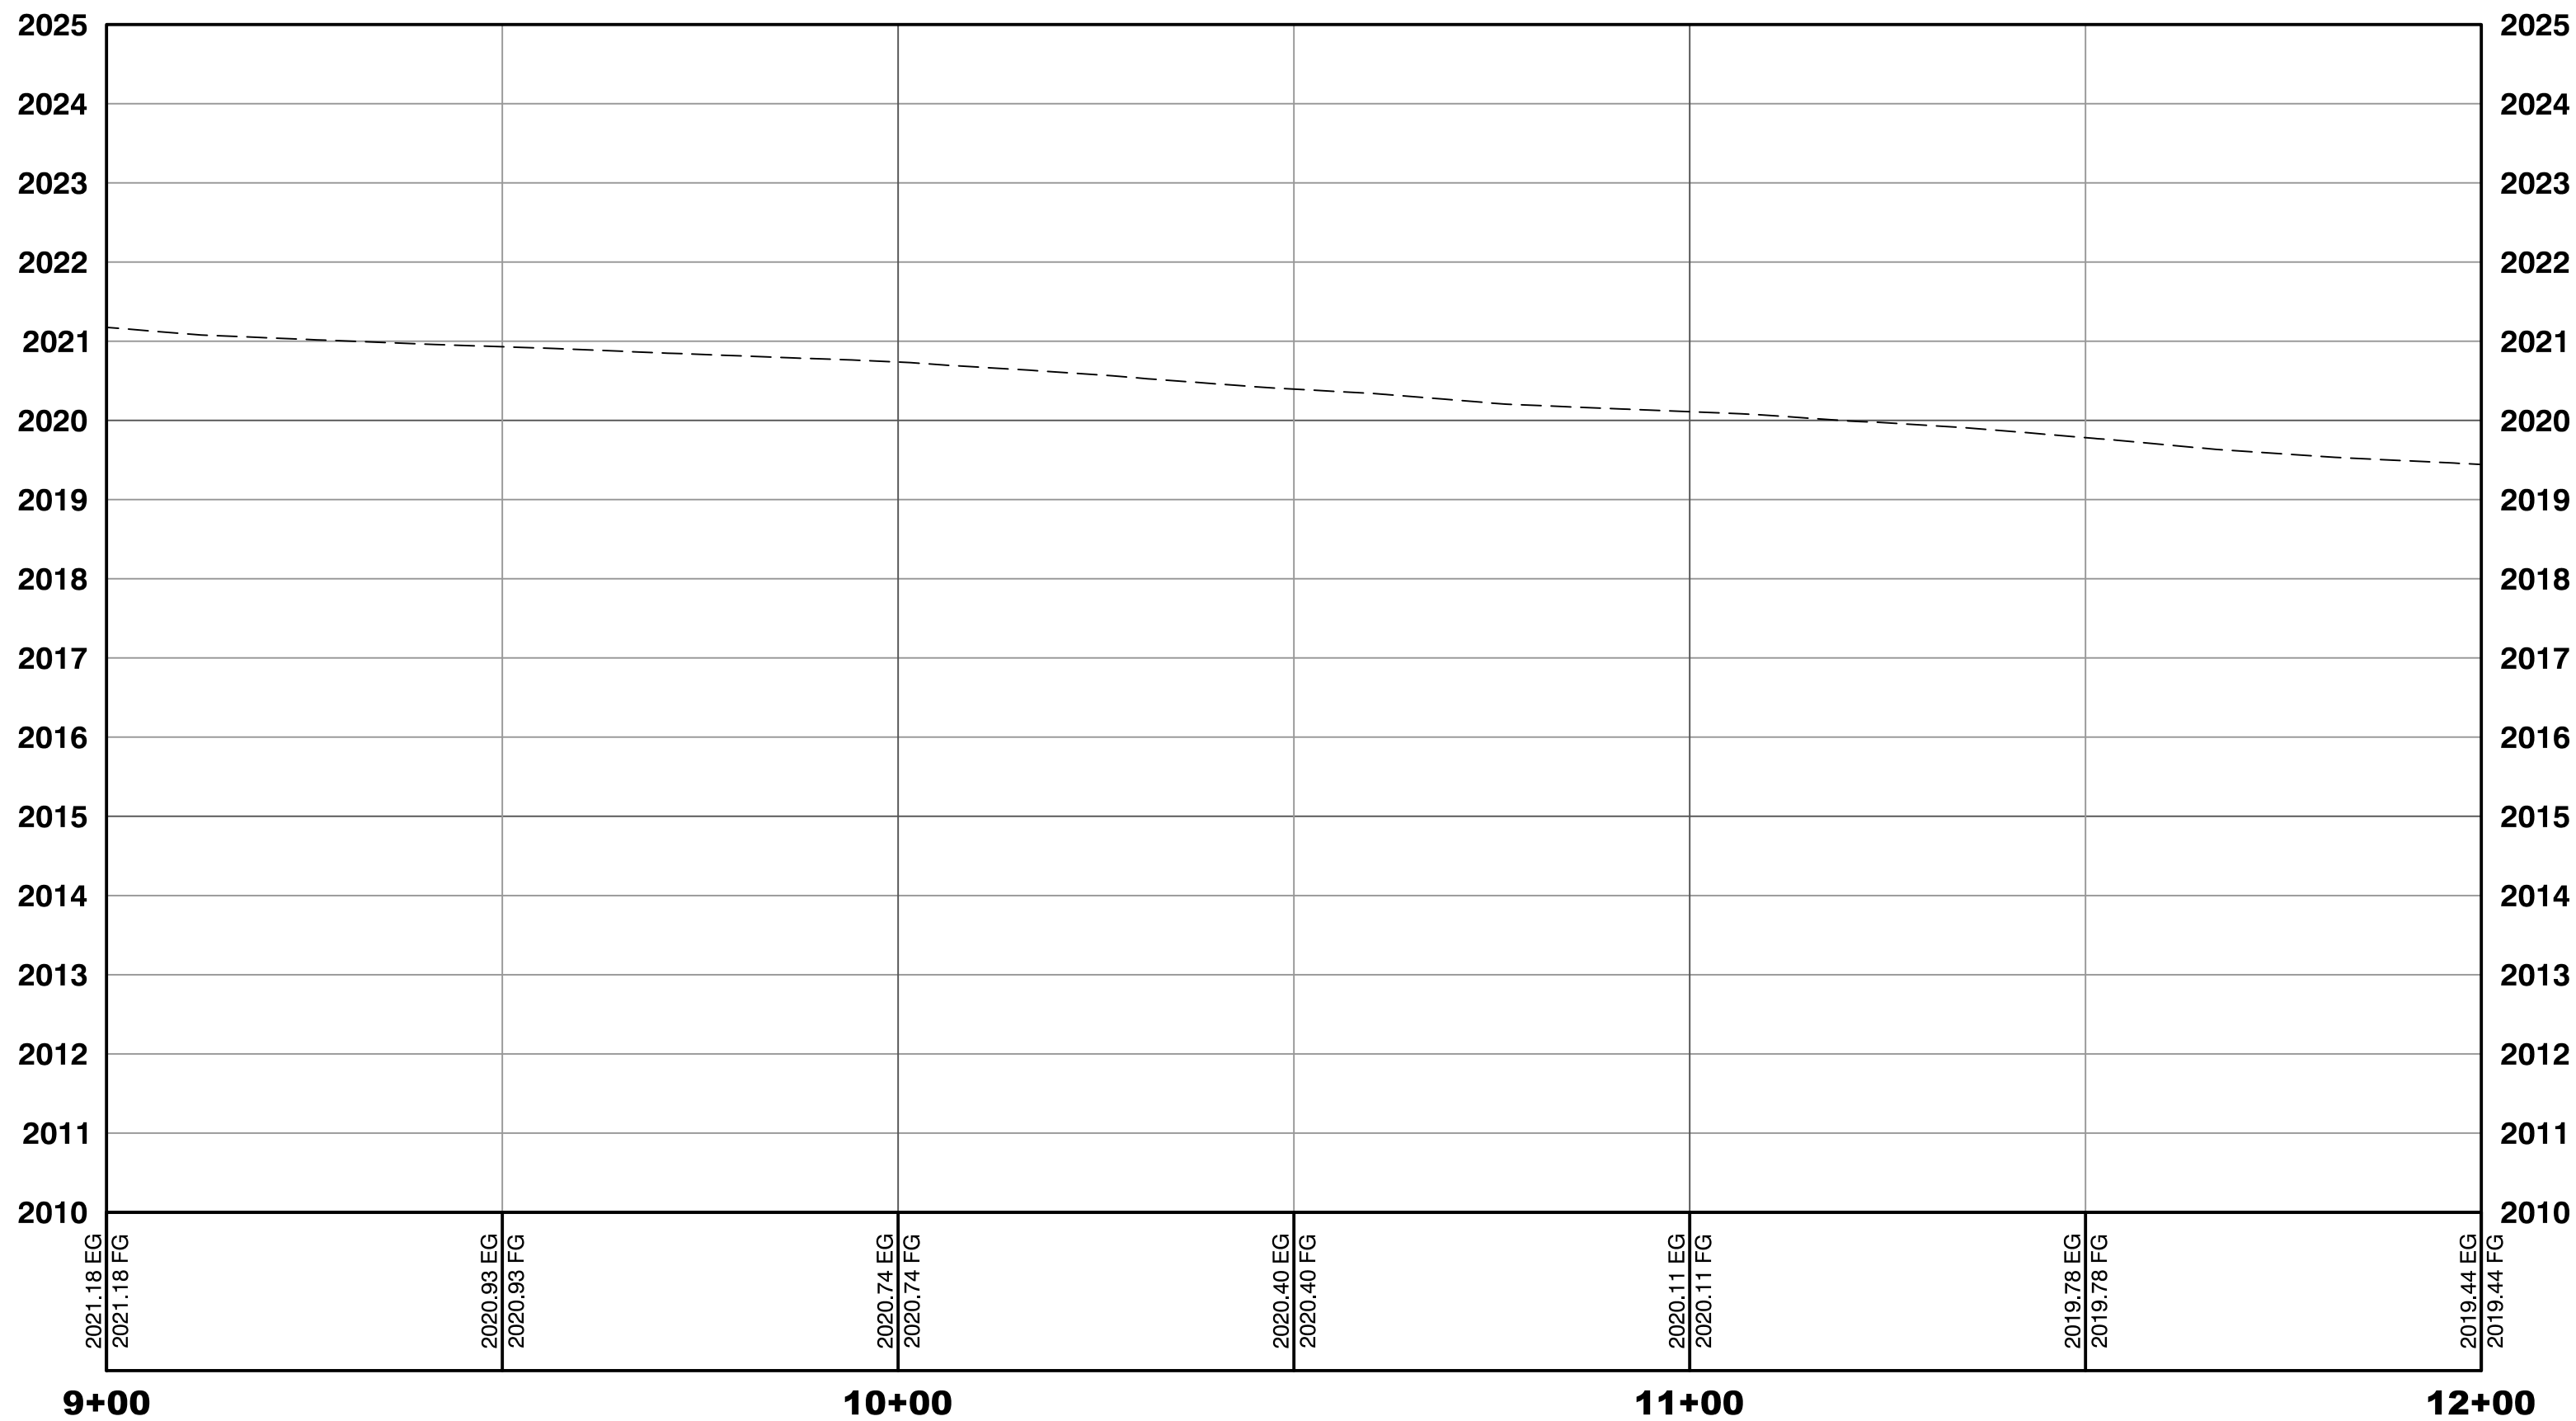

2727 SOUTH RAINBOW BOULEVARD
LAS VEGAS, NEVADA 89146-5148
PH: (702) 879-7550
FAX: (702) 879-7551
WWW.VTVN.VM.COM

DEPARTMENT OF PUBLIC WORKS
333 N. RANCHO DRIVE
LAS VEGAS, NEVADA 89101-0805
702-229-8272

PREPARED BY
CITY OF LAS VEGAS

BID# ---
DESIGNED BY: MD
DRAWN BY: ND
CHECKED BY: LL

PREPARED FOR
CITY OF LAS VEGAS

BID# 54616
DATE: --
SUBMITTAL STAGE:
30% Submittal

DOWNTOWN PEDESTRIAN AND BICYCLE IMPROVEMENTS
3RD STREET-PHASE 2
CHARLESTON TO BONNEVILLE

ROADWAY PLAN & PROFILE


SHEET

NOT FOR CONSTRUCTION
PROFESSIONAL ENGINEER
ROBERT HOSKINS III
06/06/2017
CIVIL
No. 10112



R11

23 OF 61

DRAWING NO.

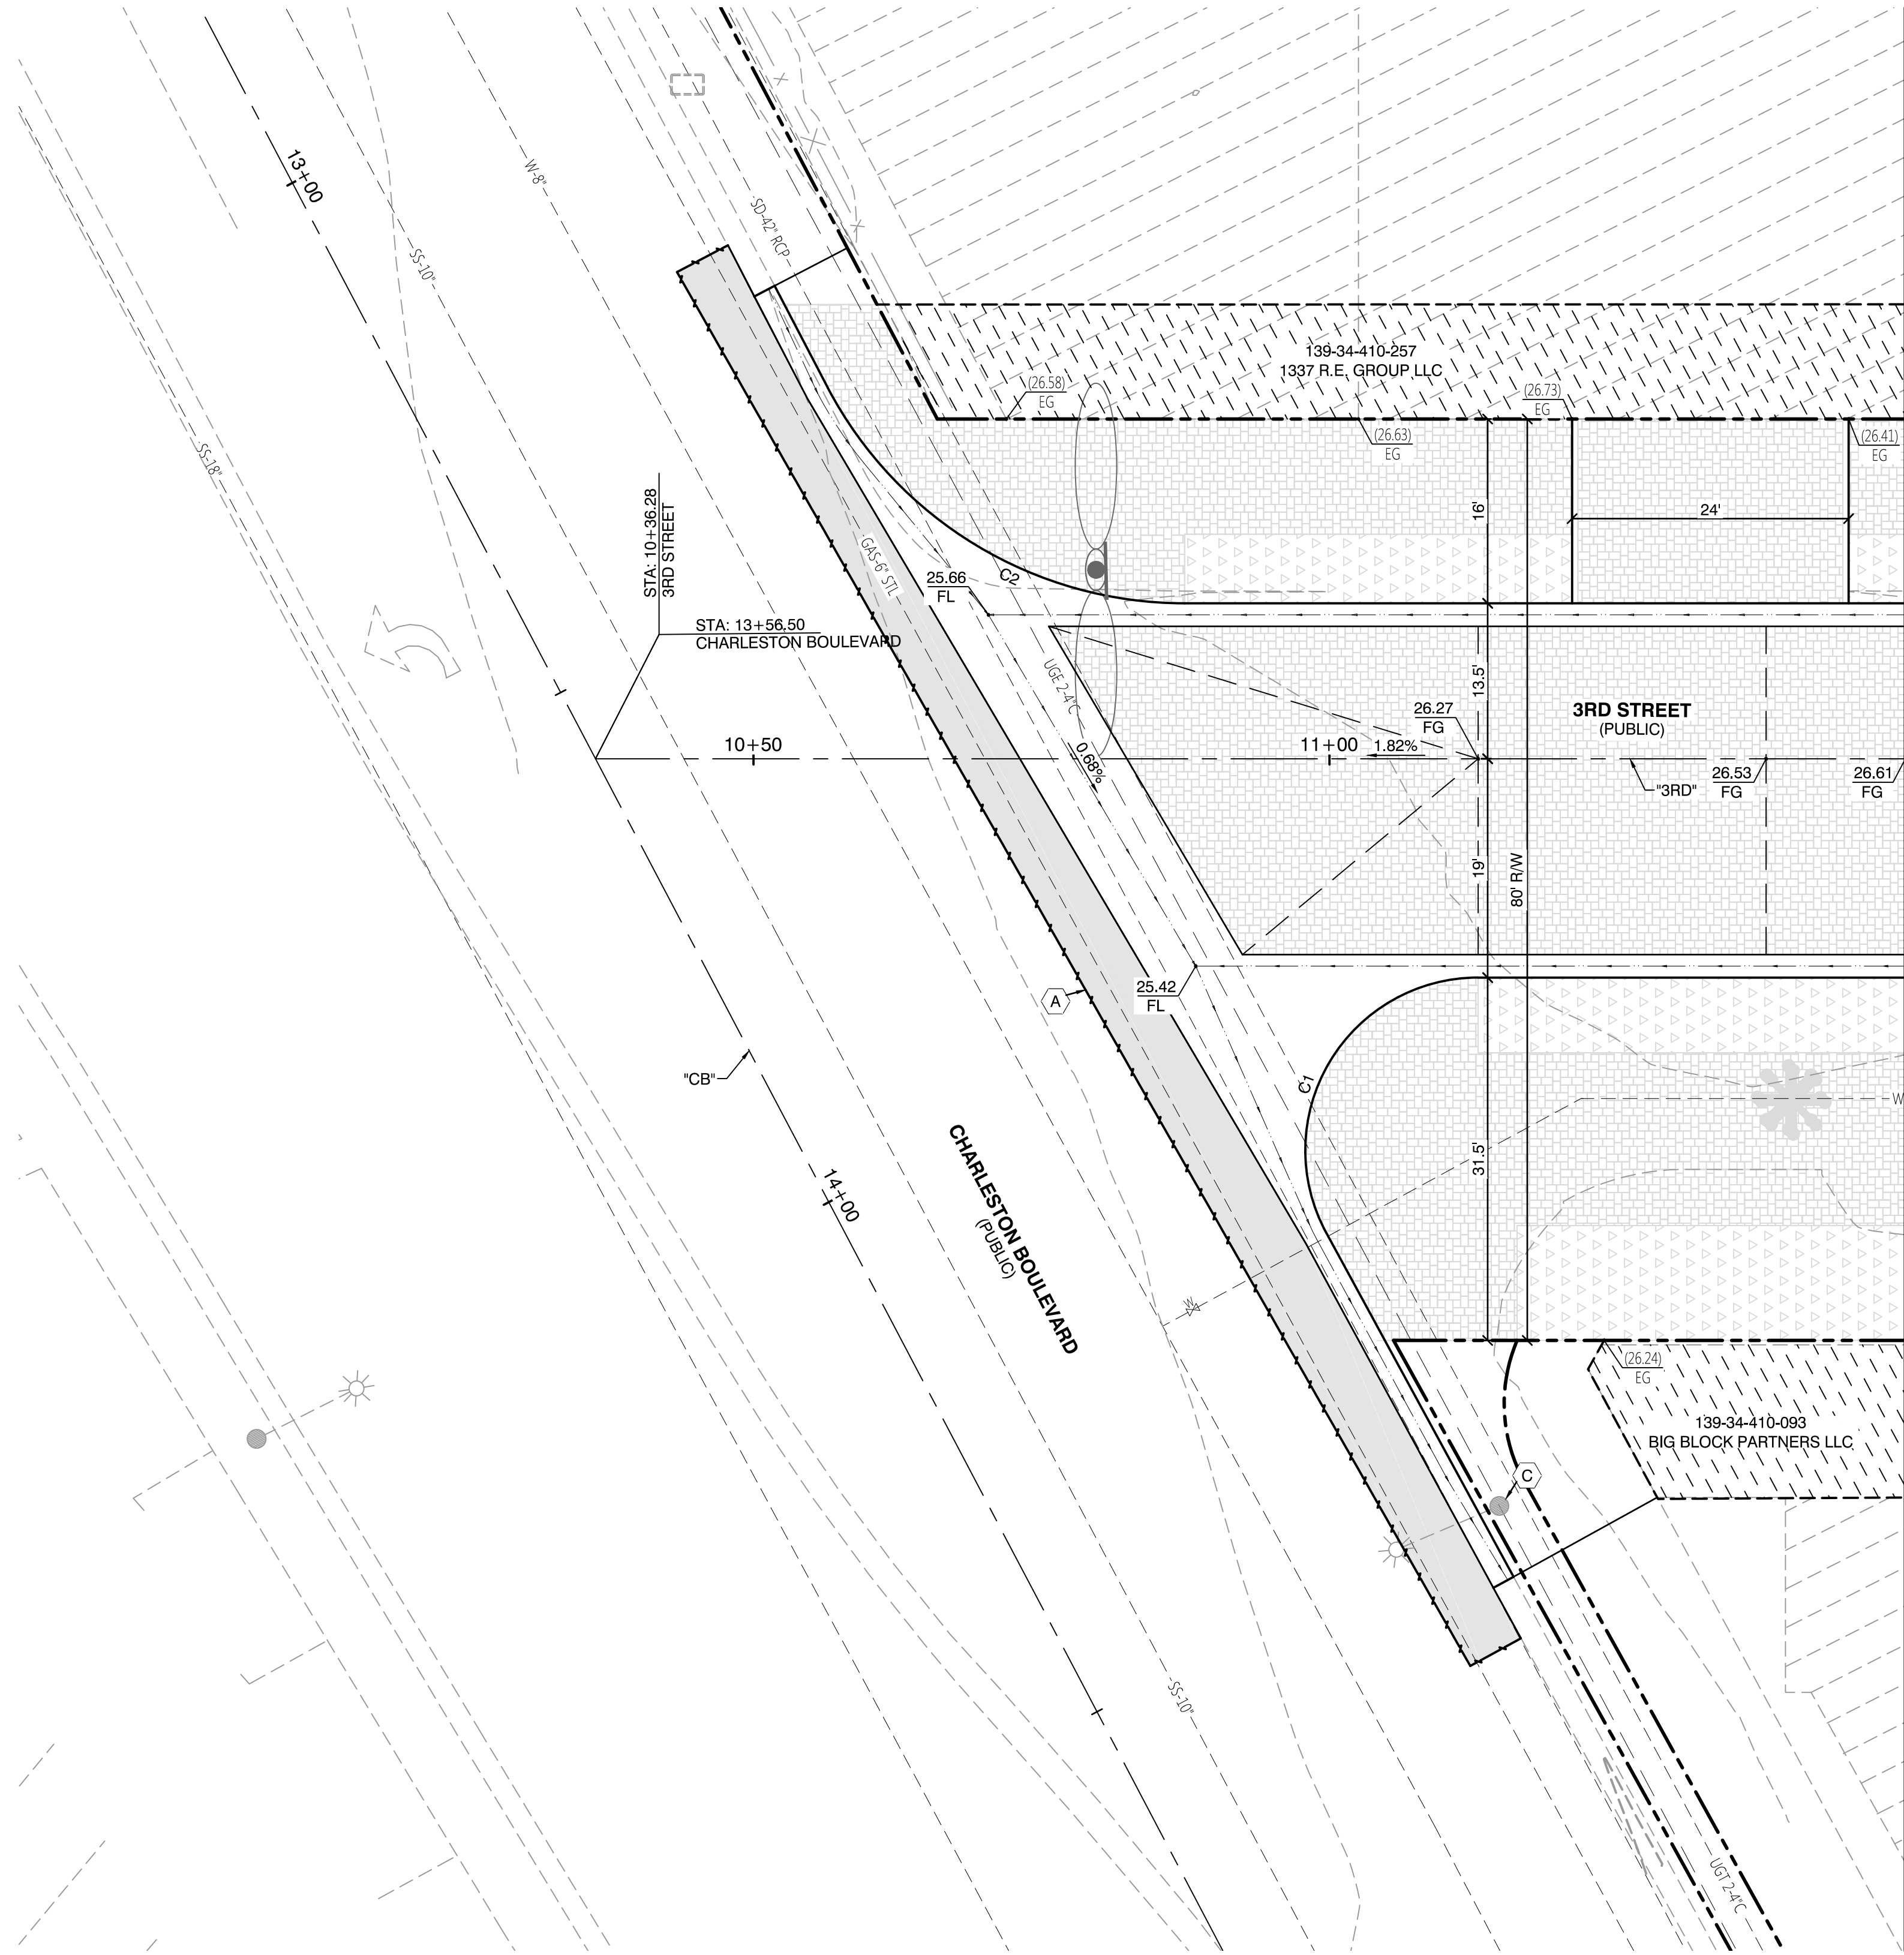

MATCHLINE STA 11 + 50.00 SEE SHEET PD2

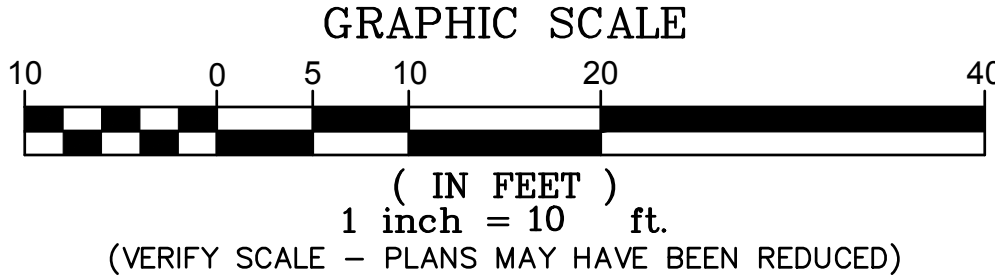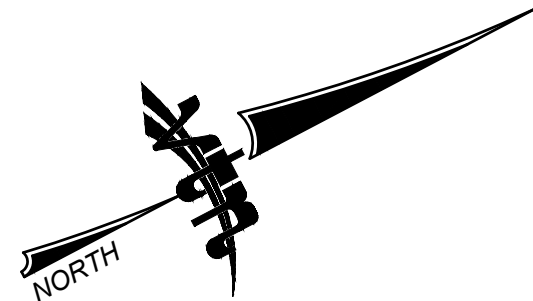

LEGEND

PAVEMENT LIMITS

PROPOSED AEP

PAVERS

PLANTING HATCH

EXISTING PARKING METER TO BE RELOCATED. CONTRACTOR TO COORDINATE WITH THE CITY.

EXISTING LIGHT POLE

EXISTING UTILITY POLE

EXISTING WATER VALVE

EXISTING WATER METER

EXISTING FIRE HYDRANT

EXISTING UTILITY BOX

EXISTING OVERHEAD ELECTRIC

EXISTING STREETLIGHT CONDUIT

EXISTING FENCE

EXISTING CURB

EXISTING SIDEWALK

RIGHT-OF-WAY LINE

EXISTING PROPERTY LINE

PROPOSED CURB

PROPOSED LIP

PROPOSED FLOWLINE

CONSTRUCTION NOTES

A

SAWCUT AND MATCH EXISTING PAVEMENT

B

EXISTING POWER POLE, P.I.P.

C

EXISTING STREETLIGHT, P.I.P.

D

EXISTING SIGN, P.I.P.

E

EXISTING UTILITY. ADJUST TO GRADE. SEE ROADWAY PLANS.

F

EXISTING UTILITY, P.I.P.

CURVE TABLE

CURVE	RADIUS	DELTA	LENGTH	TANGENT
C1	15.00'	118°33'50"	31.04'	25.24'
C2	35.00'	62°14'41"	38.02'	21.13'

30% Submittal
"NOT FOR CONSTRUCTION"
December 2016

PROJECT BENCHMARK

PROJECT DATUM: NORTH AMERICAN VERTICAL DATUM OF 1988 (NAVD88) (2008 ADJUSTMENT)

CITY OF LAS VEGAS BENCHMARK: 1LV01-34NW6
NAVD88 ELEVATION: 617.329 METERS (2025.353 FEET)

3" NDOT BRASS CAP IN TOP OF CURB AT SE CORNER OF MAIN AND BRIDGER.

BASIS OF BEARINGS AND COORDINATES

GRID NORTH AS DEFINED BY THE CENTRAL MERIDIAN OF THE NEVADA COORDINATE REFERENCE SYSTEM (NCRS), LAS VEGAS ZONE, NORTH AMERICAN DATUM OF 1983; SAID MERIDIAN BEING COINCIDENT WITH 114°58' WEST OF THE GREENWICH MERIDIAN.

LINEAR UNIT: US SURVEY FOOT (FTUS)

DATUM (REFERENCE FRAME): NAD 1983 (CORS 96) EPOCH 2002.0

SYSTEM: NEVADA COORDINATE REFERENCE SYSTEM (NCRS)

ZONE: LAS VEGAS

PROJECTION: TRANSVERSE MERCATOR
STANDARD PARALLEL (AND LATITUDE OF GRID ORIGIN): 36°15'00"N
LONGITUDE OF CENTRAL MERIDIAN: 114°58'00"W
NORTHING AT GRID ORIGIN: 200,000.000 M (656,166.6667 FTUS)
EASTING AT CENTRAL MERIDIAN: 100,000.000 M (328,083.3333 FTUS)
SCALE FACTOR ON CENTRAL MERIDIAN: 1.0001 (EXACT)

NOTES:
1. ALL DISTANCES AND BEARINGS SHOWN HEREON ARE PROJECTED (GRID) VALUES BASED ON THE PRECEDING PROJECTION DEFINITION. THE PROJECTION WAS DEFINED SUCH THAT PROJECTED (GRID) DISTANCES ARE EQUIVALENT TO 'GROUND' DISTANCES IN THE PROJECT AREA.
2. GRID BEARINGS SHOWN HEREON (OR IMPLIED BY GRID COORDINATES) DO NOT EQUAL GEODETIC BEARINGS DUE TO MERIDIAN CONVERGENCE.

CALL BEFORE YOU DIG
1-702-227-2929

Call before you dig
811
1-702-432-5300

FAST
Call before you dig
UnderGround
1-702-432-5300

PREPARED BY

2727 SOUTH RAINBOW BOULEVARD
LAS VEGAS, NEVADA 89146-5148
PH: (702) 879-7550
FAX: (702) 879-7550
WWW.VMMV.COM

DESIGNED BY: MD
DRAWN BY: ND
CHECKED BY: LL

CITY OF LAS VEGAS

H# 54616
DATE: --
SUBMITTAL STAGE:
30% Submittal

DOWNTOWN PEDESTRIAN AND BICYCLE IMPROVEMENTS
3RD STREET-PHASE 2
CHARLESTON TO BONNEVILLE

PROPERTY DETAILS


SHEET

PD1
24 OF 61
DRAWING NO.



2727 SOUTH RAINBOW BOULEVARD
LAS VEGAS, NEVADA 89146-5148
PH: (702) 879-7550
FAX: (702) 879-7550
WWW.VMMV.COM

DEPARTMENT OF PUBLIC WORKS
333 N. RANCHO DRIVE
LAS VEGAS, NV 89101
702-529-8272

MATCHLINE STA 11 + 50.00 SEE SHEET PD1

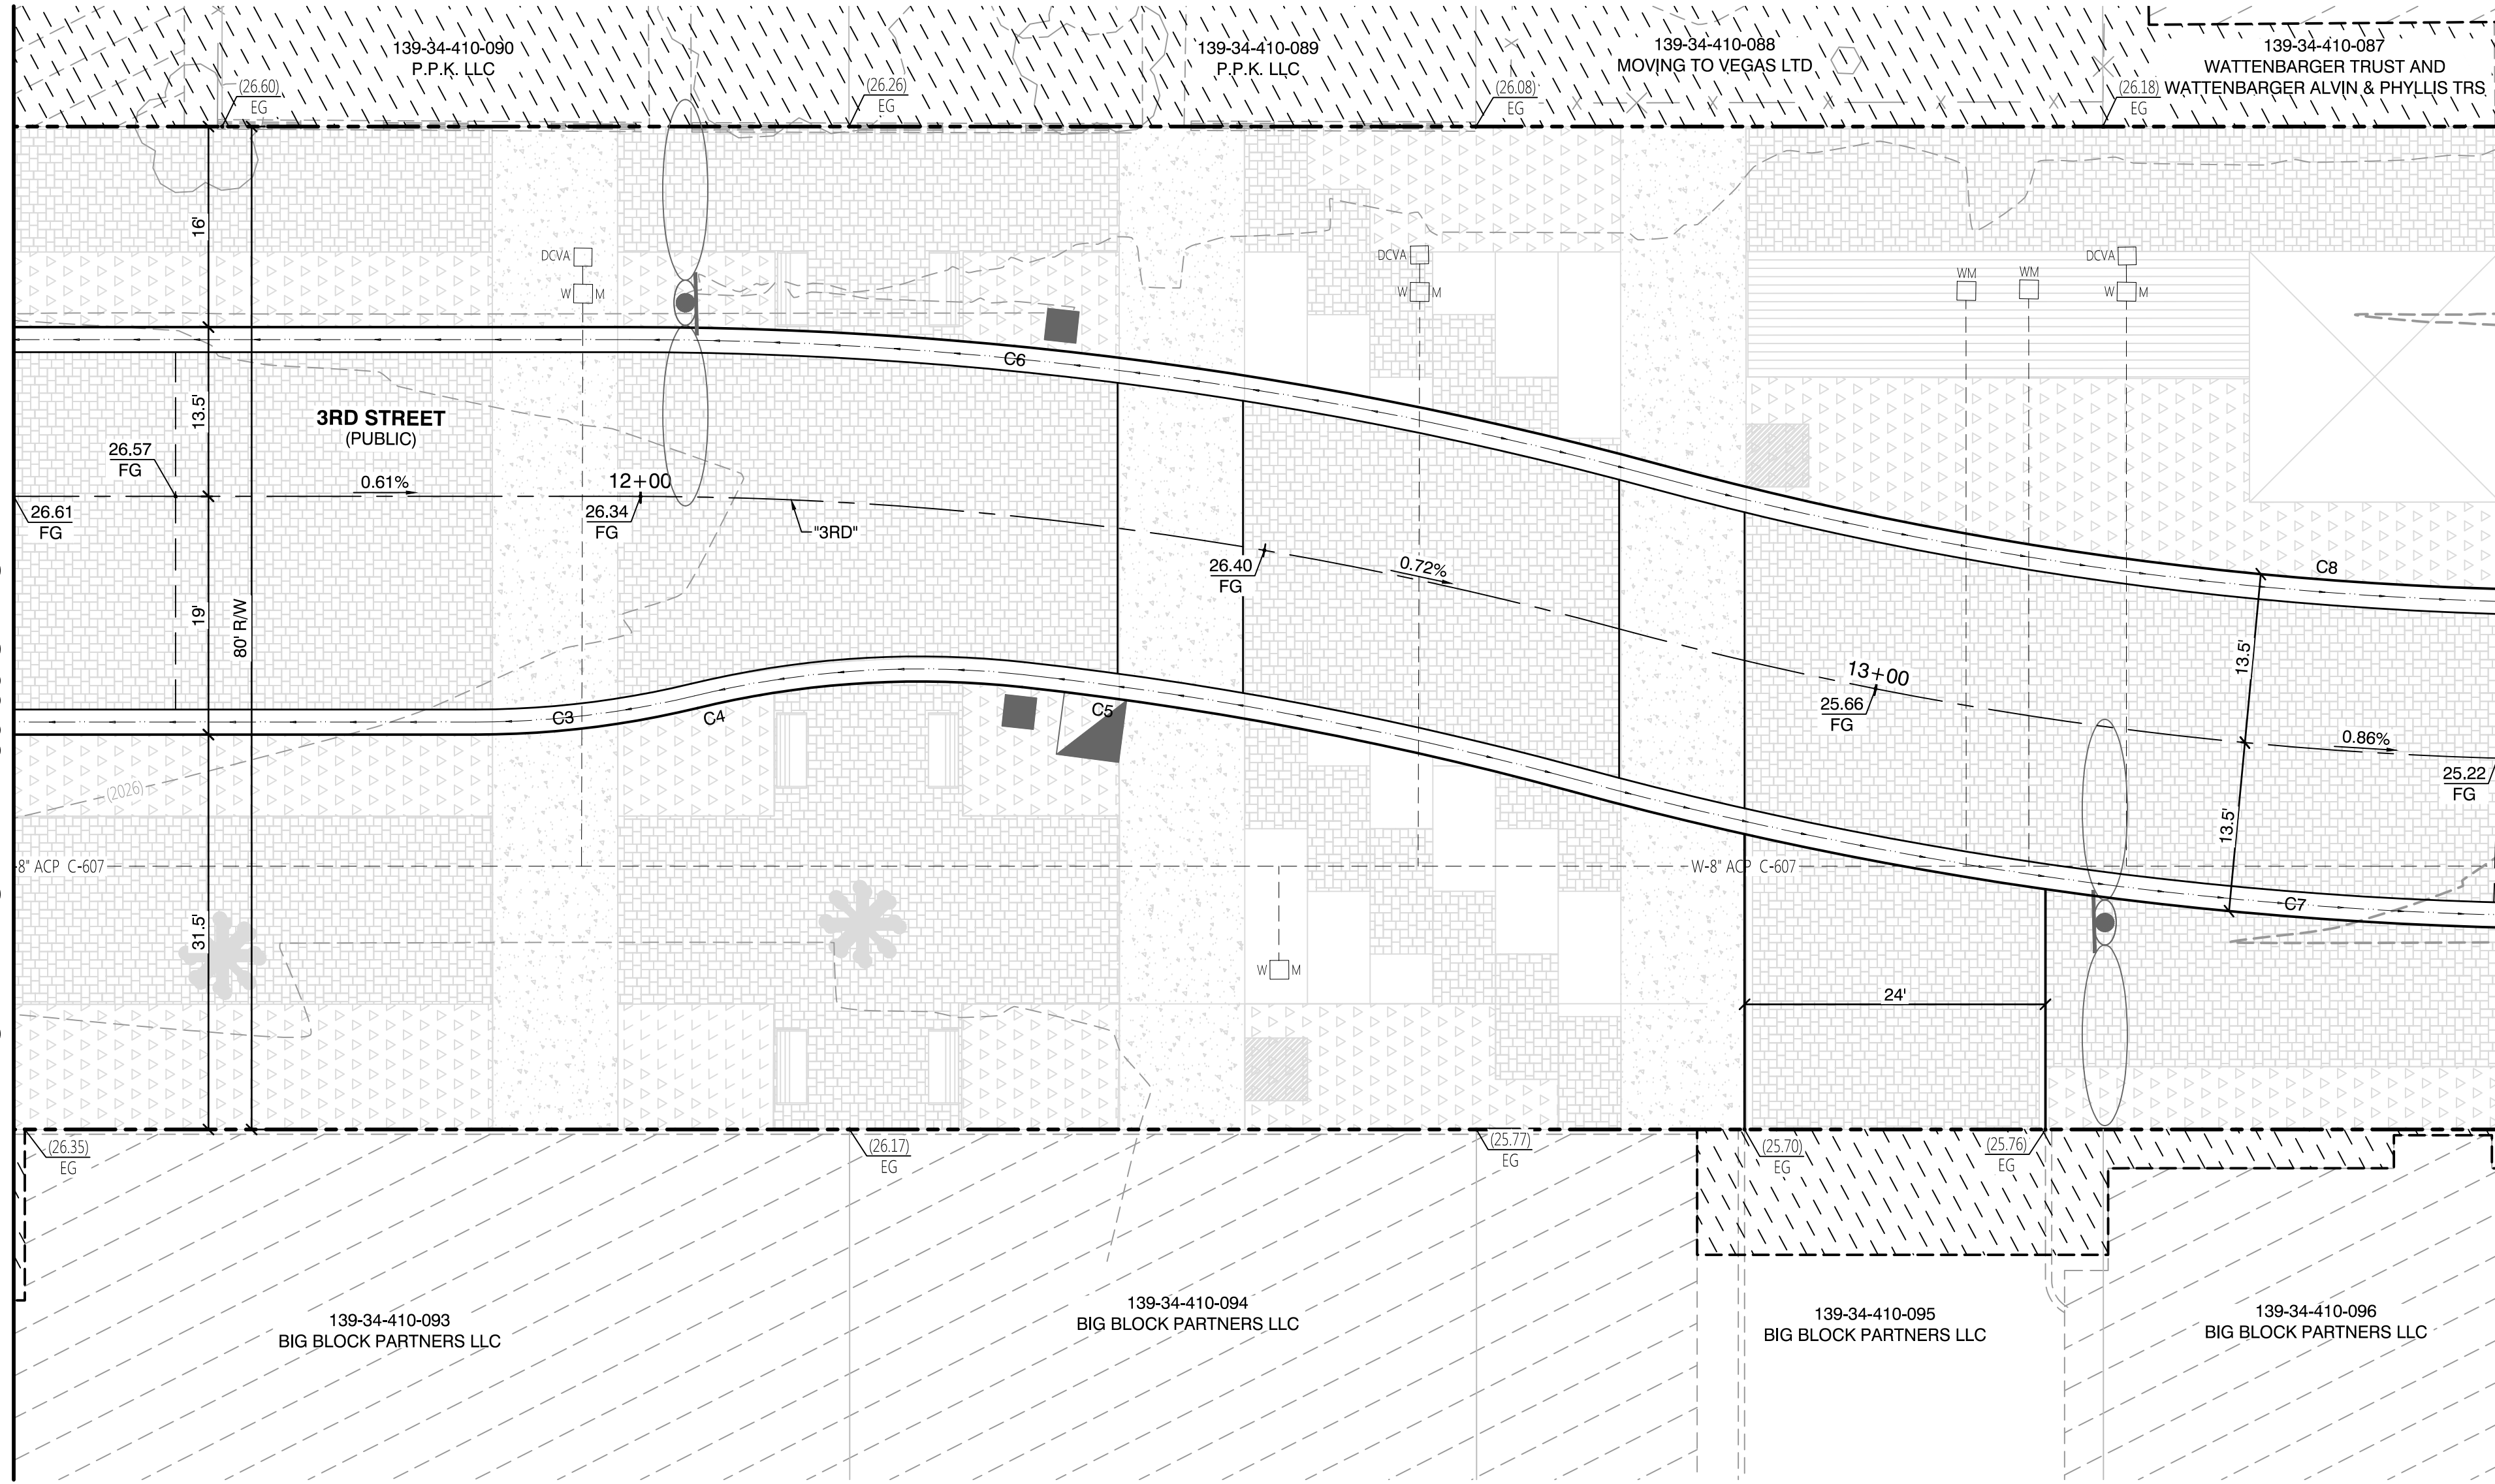

MATCHLINE STA 13 + 50.00 SEE SHEET PD3

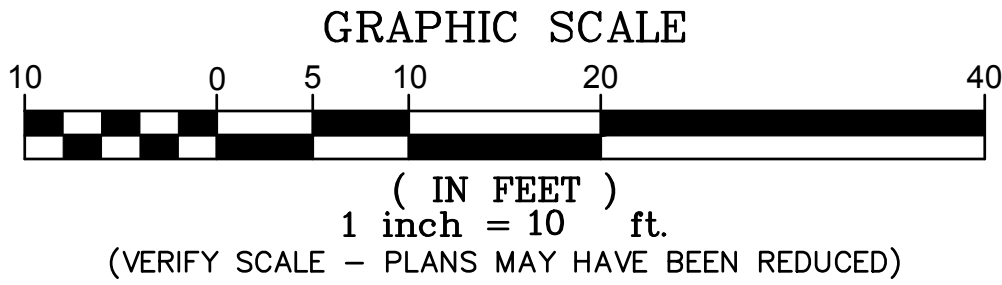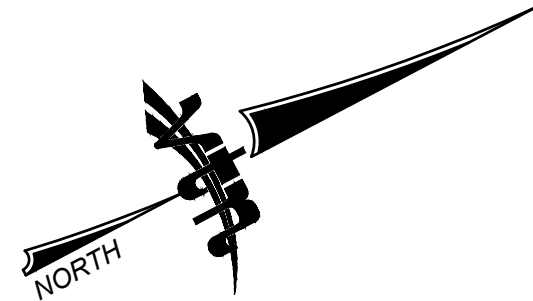

- LEGEND**
- PROPOSED AEP
 - PAVERS
 - PAVERS (2)
 - SPECIALTY CONCRETE
 - PLANTING HATCH
 - EXISTING PARKING METER TO BE RELOCATED. CONTRACTOR TO COORDINATE WITH THE CITY.
 - EXISTING LIGHT POLE
 - EXISTING UTILITY POLE
 - EXISTING WATER VALVE
 - EXISTING WATER METER
 - EXISTING FIRE HYDRANT
 - EXISTING UTILITY BOX
 - EXISTING OVERHEAD ELECTRIC
 - EXISTING STREETLIGHT CONDUIT
 - EXISTING FENCE
 - EXISTING CURB
 - EXISTING SIDEWALK
 - RIGHT-OF-WAY LINE
 - EXISTING PROPERTY LINE
 - PROPOSED CURB
 - PROPOSED LIP
 - PROPOSED FLOWLINE

- CONSTRUCTION NOTES**
- SAWCUT AND MATCH EXISTING PAVEMENT
 - EXISTING POWER POLE, P.I.P.
 - EXISTING STREETLIGHT, P.I.P.
 - EXISTING SIGN, P.I.P.
 - EXISTING UTILITY. ADJUST TO GRADE. SEE ROADWAY PLANS.
 - EXISTING UTILITY, P.I.P.

CURVE TABLE				
CURVE	RADIUS	DELTA	LENGTH	TANGENT
C3	75.00'	13°38'42"	17.86'	8.97'
C4	75.00'	19°55'05"	26.07'	13.17'
C5	286.50'	8°55'50"	44.66'	22.37'
C6	313.50'	15°12'13"	83.19'	41.84'
C7	313.50'	15°12'13"	83.19'	41.84'
C8	286.50'	15°12'13"	76.02'	38.24'

BASIS OF BEARINGS AND COORDINATES

GRID NORTH AS DEFINED BY THE CENTRAL MERIDIAN OF THE NEVADA COORDINATE REFERENCE SYSTEM (NCRS), LAS VEGAS ZONE, NORTH AMERICAN DATUM OF 1983; SAID MERIDIAN BEING COINCIDENT WITH 114°58' WEST OF THE GREENWICH MERIDIAN.

LINEAR UNIT: US SURVEY FOOT (FTUS)

DATUM (REFERENCE FRAME): NAD 1983 (CORS 96) EPOCH 2002.0

SYSTEM: NEVADA COORDINATE REFERENCE SYSTEM (NCRS)

ZONE: LAS VEGAS

PROJECTION: TRANSVERSE MERCATOR
STANDARD PARALLEL (AND LATITUDE OF GRID ORIGIN): 36°15'00"N
LONGITUDE OF CENTRAL MERIDIAN: 114°58'00"W
NORTHING AT GRID ORIGIN: 200,000,000 M (656,166,667 FTUS)
EASTING AT CENTRAL MERIDIAN: 100,000,000 M (328,083,333 FTUS)
SCALE FACTOR ON CENTRAL MERIDIAN: 1.0001 (EXACT)

NOTES:
1. ALL DISTANCES AND BEARINGS SHOWN HEREON ARE PROJECTED (GRID) VALUES BASED ON THE PRECEDING PROJECTION DEFINITION. THE PROJECTION WAS DEFINED SUCH THAT PROJECTED (GRID) DISTANCES ARE EQUIVALENT TO 'GROUND' DISTANCES IN THE PROJECT AREA.
2. GRID BEARINGS SHOWN HEREON (OR IMPLIED BY GRID COORDINATES) DO NOT EQUAL GEODETIC BEARINGS DUE TO MERIDIAN CONVERGENCE.


30% Submittal
"NOT FOR CONSTRUCTION"
December 2016

PROJECT BENCHMARK

PROJECT DATUM: NORTH AMERICAN VERTICAL DATUM OF 1988 (NAVD88) (2008 ADJUSTMENT)

CITY OF LAS VEGAS BENCHMARK: 1LV01-34NW6
NAVD88 ELEVATION: 617.329 METERS (2025.353 FEET)

3" NDOT BRASS CAP IN TOP OF CURB AT SE CORNER OF MAIN AND BRIDGER.

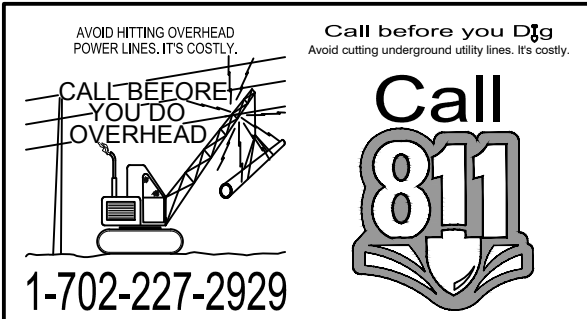

PREPARED BY
CITY OF LAS VEGAS

DESIGNED BY: MD
DRAWN BY: ND
CHECKED BY: LL

2727 SOUTH RAINBOW BOULEVARD
LAS VEGAS, NEVADA 89146-5148
PH: (702) 879-7550
FAX: (702) 879-7550
WWW.VTNV.COM

DEPARTMENT OF PUBLIC WORKS
333 N. RANCHO DRIVE
LAS VEGAS, NV 89101
702-529-8272


DOWNTOWN PEDESTRIAN AND BICYCLE IMPROVEMENTS
3RD STREET-PHASE 2
CHARLESTON TO BONNEVILLE

PROPERTY DETAILS



30% Submittal

PD2
25 OF 61

MATCHLINE STA 13+50.00 SEE SHEET PD2

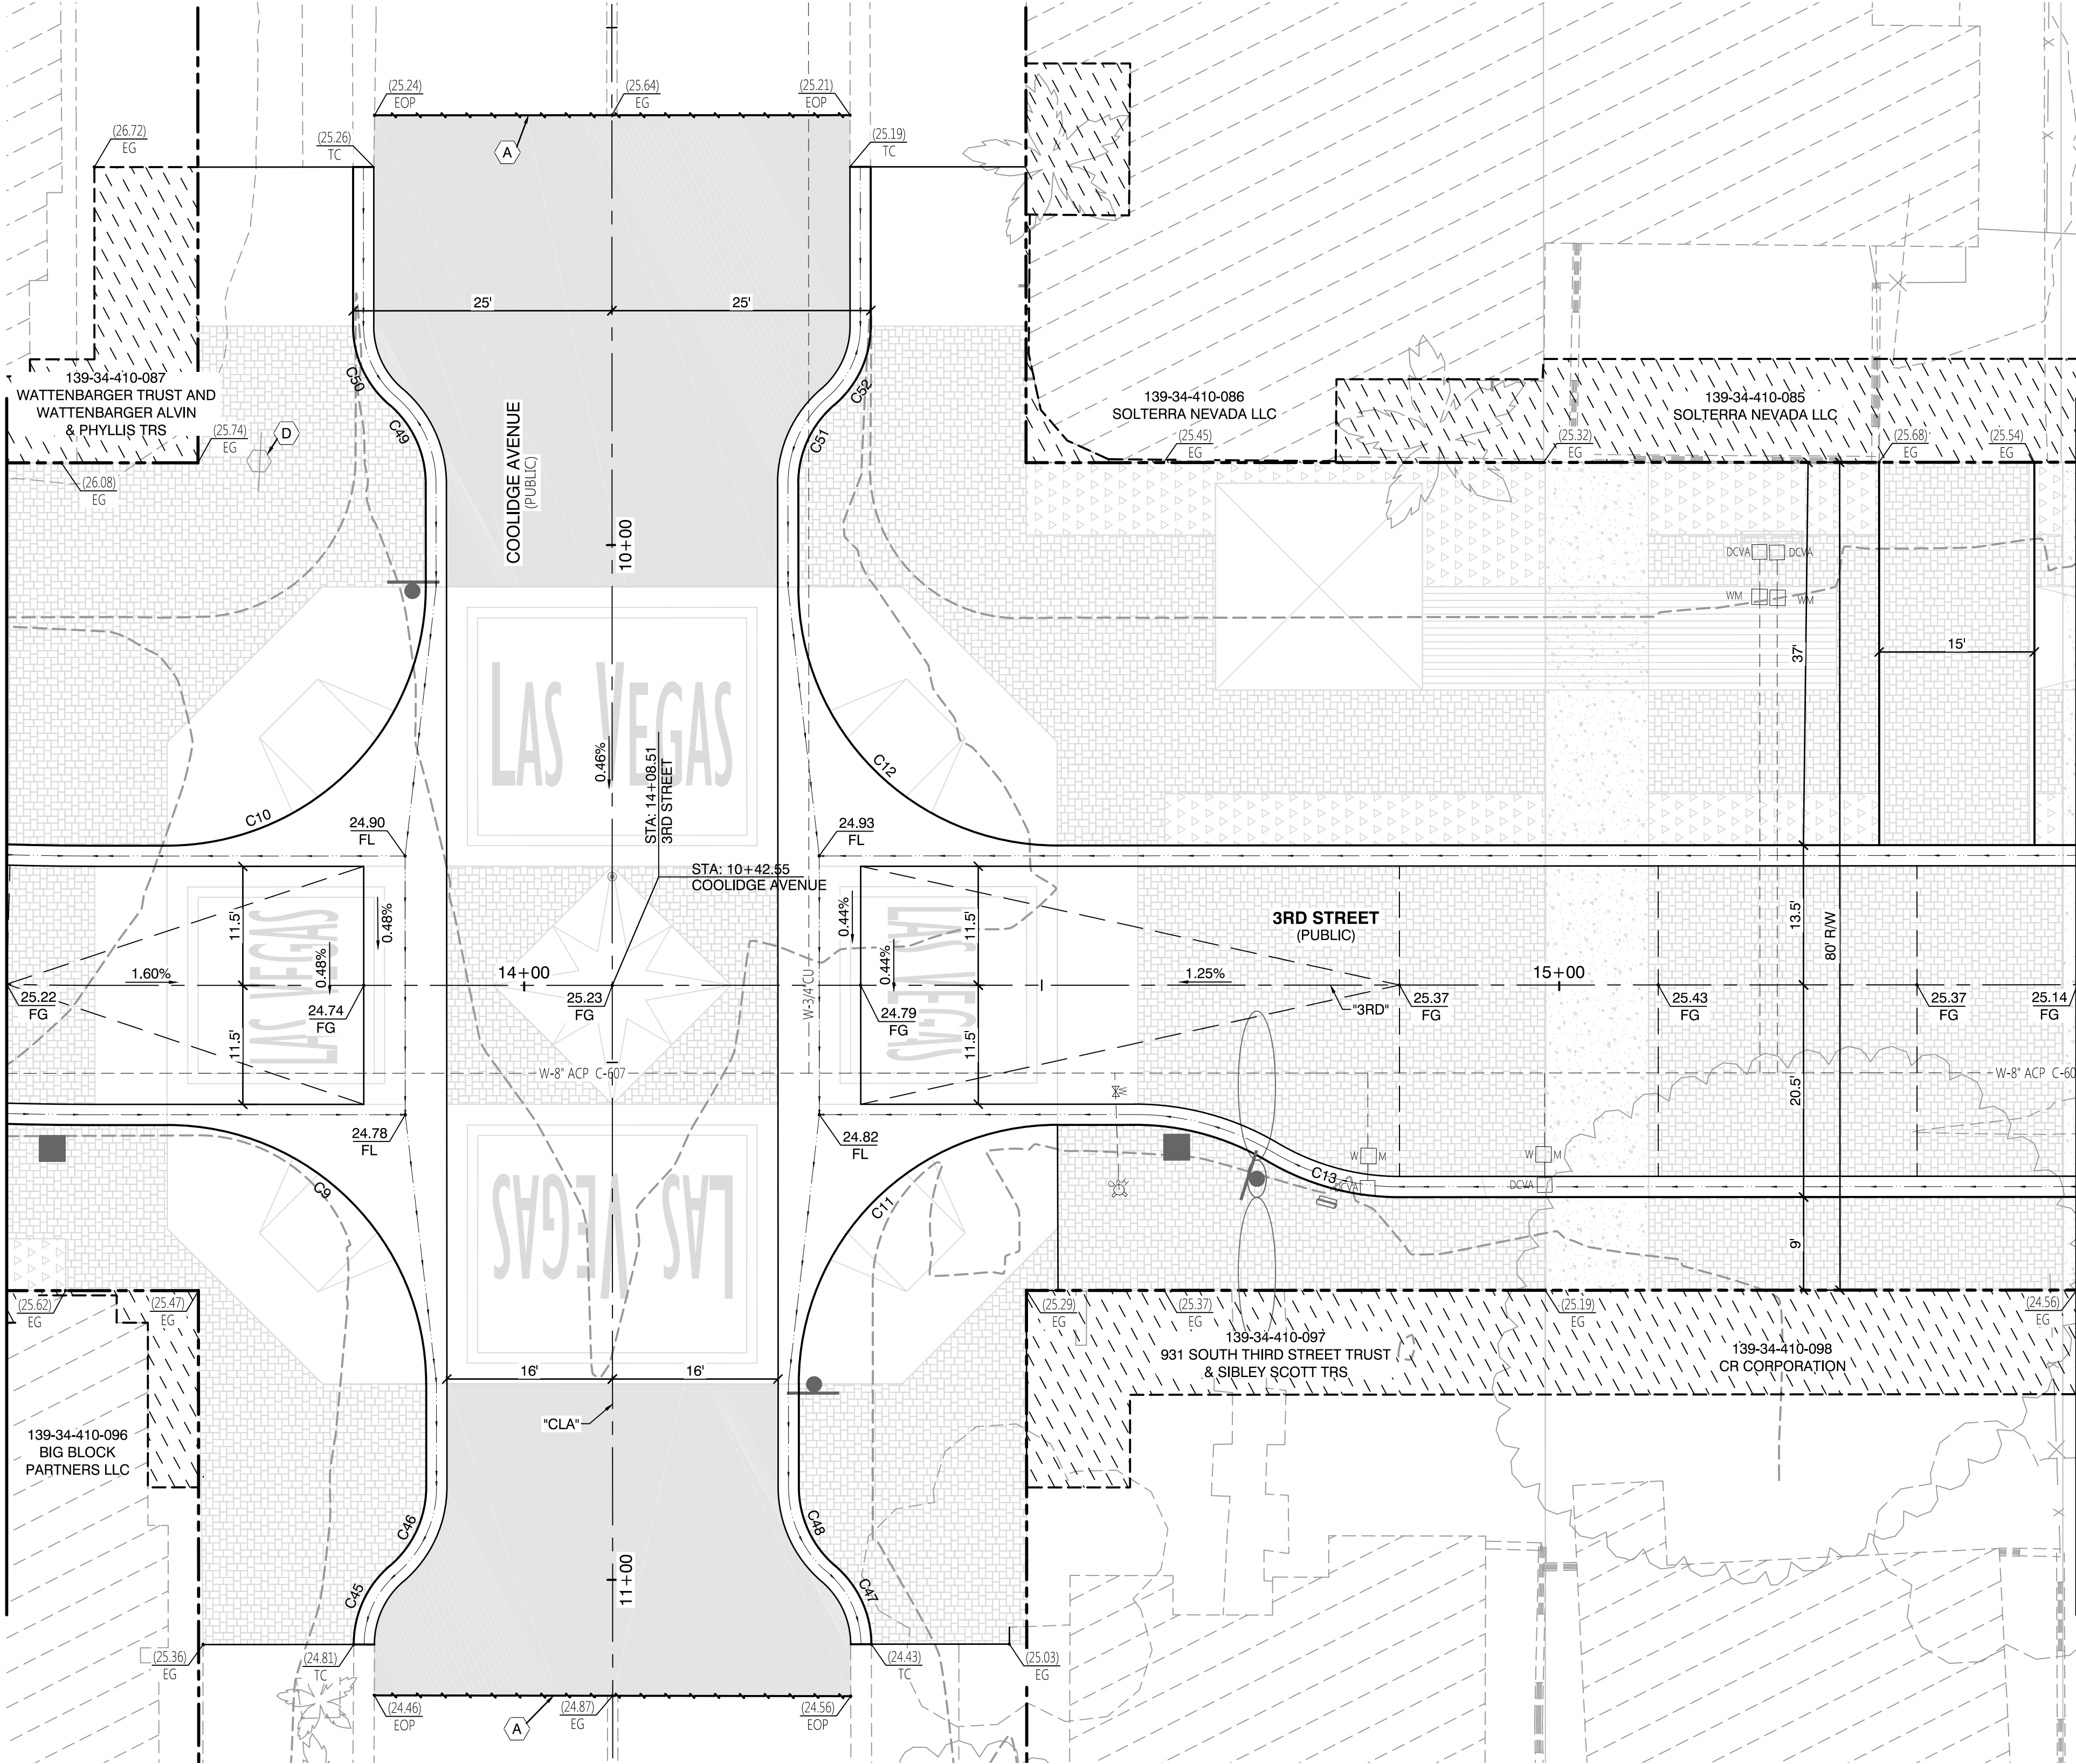

MATCHLINE STA 15+50.00 SEE SHEET PD4

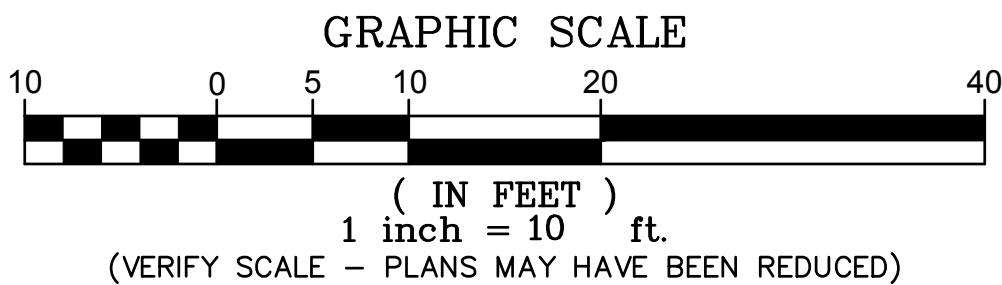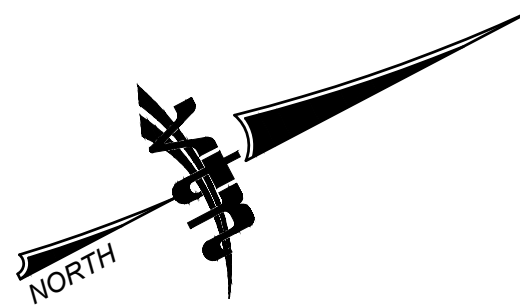

- LEGEND**
- PAVEMENT LIMITS
 - PROPOSED AEP
 - PAVERS
 - SPECIALTY CONCRETE
 - PLANTING HATCH
 - EXISTING PARKING METER TO BE RELOCATED. CONTRACTOR TO COORDINATE WITH THE CITY.
 - EXISTING LIGHT POLE
 - EXISTING UTILITY POLE
 - EXISTING WATER VALVE
 - EXISTING WATER METER
 - EXISTING FIRE HYDRANT
 - EXISTING UTILITY BOX
 - EXISTING OVERHEAD ELECTRIC
 - EXISTING STREETLIGHT CONDUIT
 - EXISTING FENCE
 - EXISTING CURB
 - EXISTING SIDEWALK
 - RIGHT-OF-WAY LINE
 - EXISTING PROPERTY LINE
 - PROPOSED CURB
 - PROPOSED LIP
 - PROPOSED FLOWLINE

- CONSTRUCTION NOTES**
- SAWCUT AND MATCH EXISTING PAVEMENT
 - EXISTING POWER POLE, P.I.P.
 - EXISTING STREETLIGHT, P.I.P.
 - EXISTING SIGN, P.I.P.
 - EXISTING UTILITY. ADJUST TO GRADE. SEE ROADWAY PLANS.
 - EXISTING UTILITY, P.I.P.

CURVE TABLE				
CURVE	RADIUS	DELTA	LENGTH	TANGENT
C9	25.00'	89°57'53"	39.25'	24.98'
C10	25.00'	90°01'21"	39.28'	25.01'
C11	25.00'	90°00'48"	39.28'	25.01'
C12	25.00'	89°59'58"	39.27'	25.00'
C13	25.00'	30°41'00"	13.39'	6.86'
C45	10.00'	49°29'21"	8.64'	4.61'
C46	10.00'	49°29'21"	8.64'	4.61'
C47	10.00'	49°20'13"	8.61'	4.59'
C48	10.00'	49°25'39"	8.63'	4.60'
C49	10.00'	49°29'28"	8.64'	4.61'
C50	10.00'	49°29'49"	8.64'	4.61'
C51	10.00'	49°27'30"	8.63'	4.61'
C52	10.00'	49°27'30"	8.63'	4.61'

BASIS OF BEARINGS AND COORDINATES

GRID NORTH AS DEFINED BY THE CENTRAL MERIDIAN OF THE NEVADA COORDINATE REFERENCE SYSTEM (NCRS), LAS VEGAS ZONE, NORTH AMERICAN DATUM OF 1983; SAID MERIDIAN BEING COINCIDENT WITH 114°58' WEST OF THE GREENWICH MERIDIAN.

LINEAR UNIT: US SURVEY FOOT (FTUS)

DATUM (REFERENCE FRAME): NAD 1983 (CORS 96) EPOCH 2002.0

SYSTEM: NEVADA COORDINATE REFERENCE SYSTEM (NCRS)

ZONE: LAS VEGAS

PROJECTION: TRANSVERSE MERCATOR
STANDARD PARALLEL (AND LATITUDE OF GRID ORIGIN): 36°15'00"N
LONGITUDE OF CENTRAL MERIDIAN: 114°58'00"W
NORTHING AT GRID ORIGIN: 200,000,000 M (656,166,666.7 FTUS)
EASTING AT CENTRAL MERIDIAN: 100,000,000 M (328,083,333.3 FTUS)
SCALE FACTOR ON CENTRAL MERIDIAN: 1.0001 (EXACT)

NOTES:

1. ALL DISTANCES AND BEARINGS SHOWN HEREON ARE PROJECTED (GRID) VALUES BASED ON THE PRECEDING PROJECTION DEFINITION. THE PROJECTION WAS DEFINED SUCH THAT PROJECTED (GRID) DISTANCES ARE EQUIVALENT TO 'GROUND' DISTANCES IN THE PROJECT AREA.

2. GRID BEARINGS SHOWN HEREON (OR IMPLIED BY GRID COORDINATES) DO NOT EQUAL GEODETIC BEARINGS DUE TO MERIDIAN CONVERGENCE.

30% Submittal
"NOT FOR CONSTRUCTION"
December 2016

PROJECT BENCHMARK

PROJECT DATUM: NORTH AMERICAN VERTICAL DATUM OF 1988 (NAVD88) (2008 ADJUSTMENT)

CITY OF LAS VEGAS BENCHMARK: 1LV01-34NW6
NAVD88 ELEVATION: 617.329 METERS (2025.353 FEET)

3" NDOT BRASS CAP IN TOP OF CURB AT SE CORNER OF MAIN AND BRIDGER.



PREPARED BY
CITY OF LAS VEGAS
2727 SOUTH RAINBOW BOULEVARD
LAS VEGAS, NEVADA 89146-5148
PH: (702) 879-7550
FAX: (702) 879-7550
WWW.VTNV.COM

DESIGNED BY: MD
DRAWN BY: ND
CHECKED BY: LL

DATE: --
SUBMITTAL STAGE:
30% Submittal

DOWNTOWN PEDESTRIAN AND BICYCLE IMPROVEMENTS
3RD STREET-PHASE 2
CHARLESTON TO BONNEVILLE


PROPERTY DETAILS

SHEET
PD3
26 OF 61
DRAWING NO.



REVISIONS

NO.	DATE	REVISIONS

MATCHLINE STA 15+50.00 SEE SHEET PD3

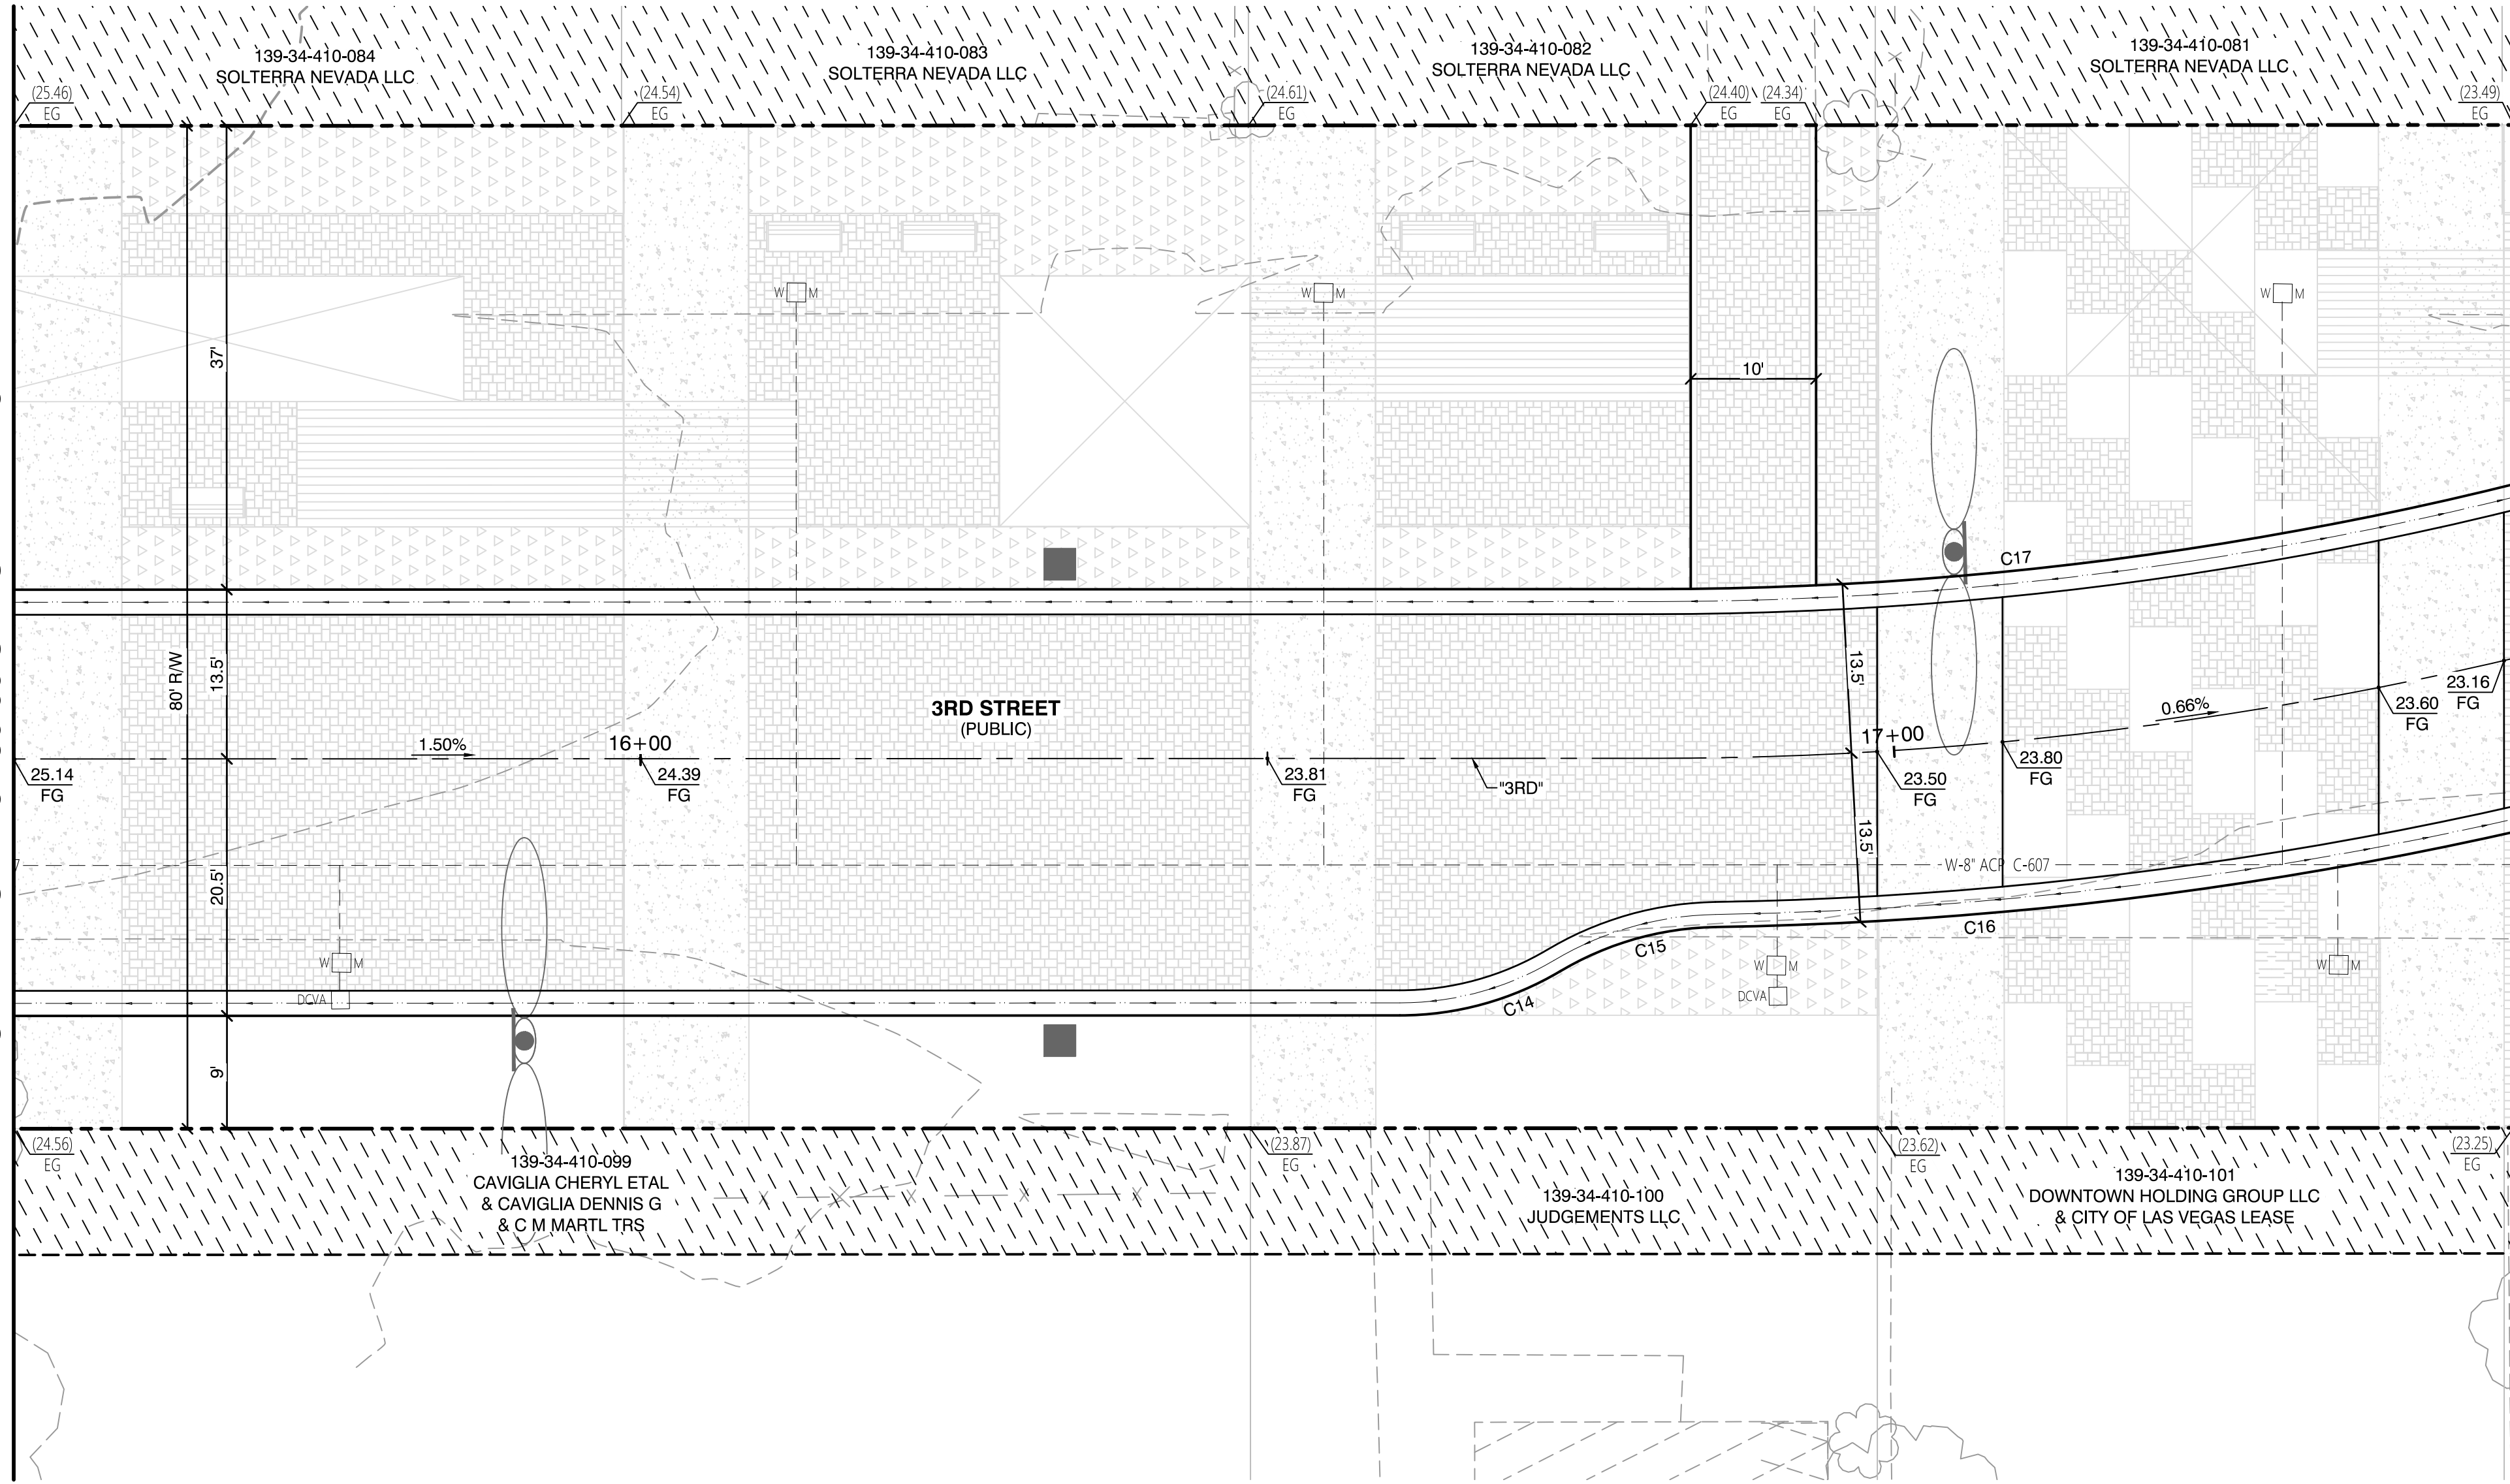

MATCHLINE STA 17+50.00 SEE SHEET PD5

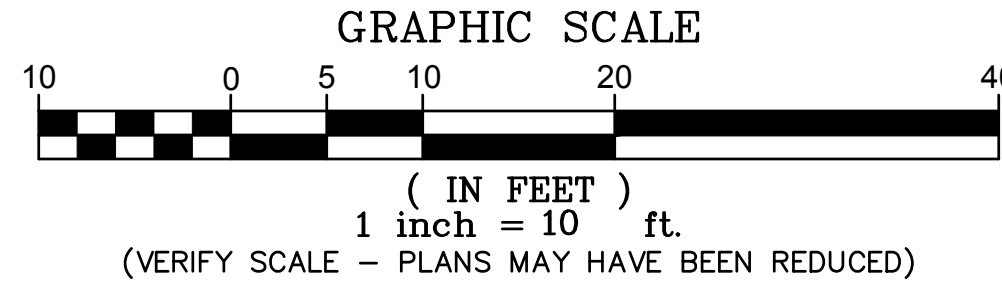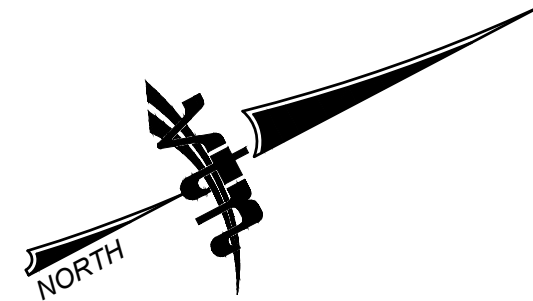

- LEGEND**
- PROPOSED AEP
 - PAVERS
 - PAVERS (2)
 - SPECIALTY CONCRETE
 - PLANTING HATCH
 - EXISTING PARKING METER TO BE RELOCATED. CONTRACTOR TO COORDINATE WITH THE CITY.
 - EXISTING LIGHT POLE
 - EXISTING UTILITY POLE
 - EXISTING WATER VALVE
 - EXISTING WATER METER
 - EXISTING FIRE HYDRANT
 - EXISTING UTILITY BOX
 - EXISTING OVERHEAD ELECTRIC
 - EXISTING STREETLIGHT CONDUIT
 - EXISTING FENCE
 - EXISTING CURB
 - EXISTING SIDEWALK
 - RIGHT-OF-WAY LINE
 - EXISTING PROPERTY LINE
 - PROPOSED CURB
 - PROPOSED LIP
 - PROPOSED FLOWLINE

- CONSTRUCTION NOTES**
- A SAWCUT AND MATCH EXISTING PAVEMENT
 - B EXISTING POWER POLE, P.I.P.
 - C EXISTING STREETLIGHT, P.I.P.
 - D EXISTING SIGN, P.I.P.
 - E EXISTING UTILITY. ADJUST TO GRADE. SEE ROADWAY PLANS.
 - F EXISTING UTILITY, P.I.P.

CURVE TABLE				
CURVE	RADIUS	DELTA	LENGTH	TANGENT
C14	25.00'	30°46'41"	13.43'	6.88'
C15	25.00'	29°52'25"	13.03'	6.67'
C16	313.50'	14°17'58"	78.24'	39.32'
C17	286.50'	15°12'13"	76.02'	38.24'

BASIS OF BEARINGS AND COORDINATES

GRID NORTH AS DEFINED BY THE CENTRAL MERIDIAN OF THE NEVADA COORDINATE REFERENCE SYSTEM (NCRS), LAS VEGAS ZONE, NORTH AMERICAN DATUM OF 1983; SAID MERIDIAN BEING COINCIDENT WITH 114°58' WEST OF THE GREENWICH MERIDIAN.

LINEAR UNIT: US SURVEY FOOT (FTUS)

DATUM (REFERENCE FRAME): NAD 1983 (CORS 96) EPOCH 2002.0

SYSTEM: NEVADA COORDINATE REFERENCE SYSTEM (NCRS)

ZONE: LAS VEGAS

PROJECTION: TRANSVERSE MERCATOR
STANDARD PARALLEL (AND LATITUDE OF GRID ORIGIN): 36°15'00"N
LONGITUDE OF CENTRAL MERIDIAN: 114°58'00"W
NORTHING AT GRID ORIGIN: 200,000,000 M (656,166,666.7 FTUS)
EASTING AT CENTRAL MERIDIAN: 100,000,000 M (328,083,333.3 FTUS)
SCALE FACTOR ON CENTRAL MERIDIAN: 1.0001 (EXACT)

NOTES:
1. ALL DISTANCES AND BEARINGS SHOWN HEREON ARE PROJECTED (GRID) VALUES BASED ON THE PRECEDING PROJECTION DEFINITION. THE PROJECTION WAS DEFINED SUCH THAT PROJECTED (GRID) DISTANCES ARE EQUIVALENT TO 'GROUND' DISTANCES IN THE PROJECT AREA.
2. GRID BEARINGS SHOWN HEREON (OR IMPLIED BY GRID COORDINATES) DO NOT EQUAL GEODETIC BEARINGS DUE TO MERIDIAN CONVERGENCE.

30% Submittal
"NOT FOR CONSTRUCTION"
December 2016

PROJECT BENCHMARK

PROJECT DATUM: NORTH AMERICAN VERTICAL DATUM OF 1988 (NAVD88) (2008 ADJUSTMENT)

CITY OF LAS VEGAS BENCHMARK: 1LV01-34NW6
NAVD88 ELEVATION: 617.329 METERS (2025.353 FEET)

3" NDOT BRASS CAP IN TOP OF CURB AT SE CORNER OF MAIN AND BRIDGER.



PREPARED BY
CITY OF LAS VEGAS
2727 SOUTH RAINBOW BOULEVARD
LAS VEGAS, NEVADA 89146-5148
PH: (702) 879-7550
FAX: (702) 879-7550
WWW.VTNV.COM

DESIGNED BY: MD
DRAWN BY: ND
CHECKED BY: LL

DATE: --
SUBMITTAL STAGE: 30% Submittal

PREPARED FOR
CITY OF LAS VEGAS
2727 SOUTH RAINBOW BOULEVARD
LAS VEGAS, NEVADA 89146-5148
PH: (702) 879-7550
FAX: (702) 879-7550
WWW.VTNV.COM

DESIGNED BY: MD
DRAWN BY: ND
CHECKED BY: LL

DATE: --
SUBMITTAL STAGE: 30% Submittal

PREPARED BY
CITY OF LAS VEGAS
2727 SOUTH RAINBOW BOULEVARD
LAS VEGAS, NEVADA 89146-5148
PH: (702) 879-7550
FAX: (702) 879-7550
WWW.VTNV.COM


DESIGNED BY: MD
DRAWN BY: ND
CHECKED BY: LL

DATE: --
SUBMITTAL STAGE: 30% Submittal

PREPARED FOR
CITY OF LAS VEGAS
2727 SOUTH RAINBOW BOULEVARD
LAS VEGAS, NEVADA 89146-5148
PH: (702) 879-7550
FAX: (702) 879-7550
WWW.VTNV.COM


DESIGNED BY: MD
DRAWN BY: ND
CHECKED BY: LL

DATE: --
SUBMITTAL STAGE: 30% Submittal


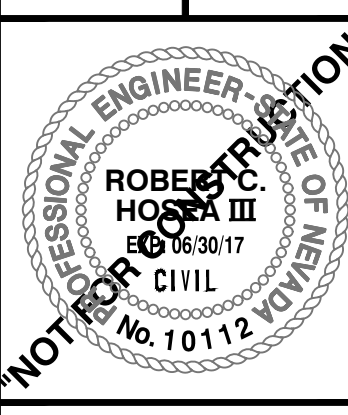


SHEET
PD4
27 OF 61
DRAWING NO.

MATCHLINE STA 17+50.00 SEE SHEET PD4

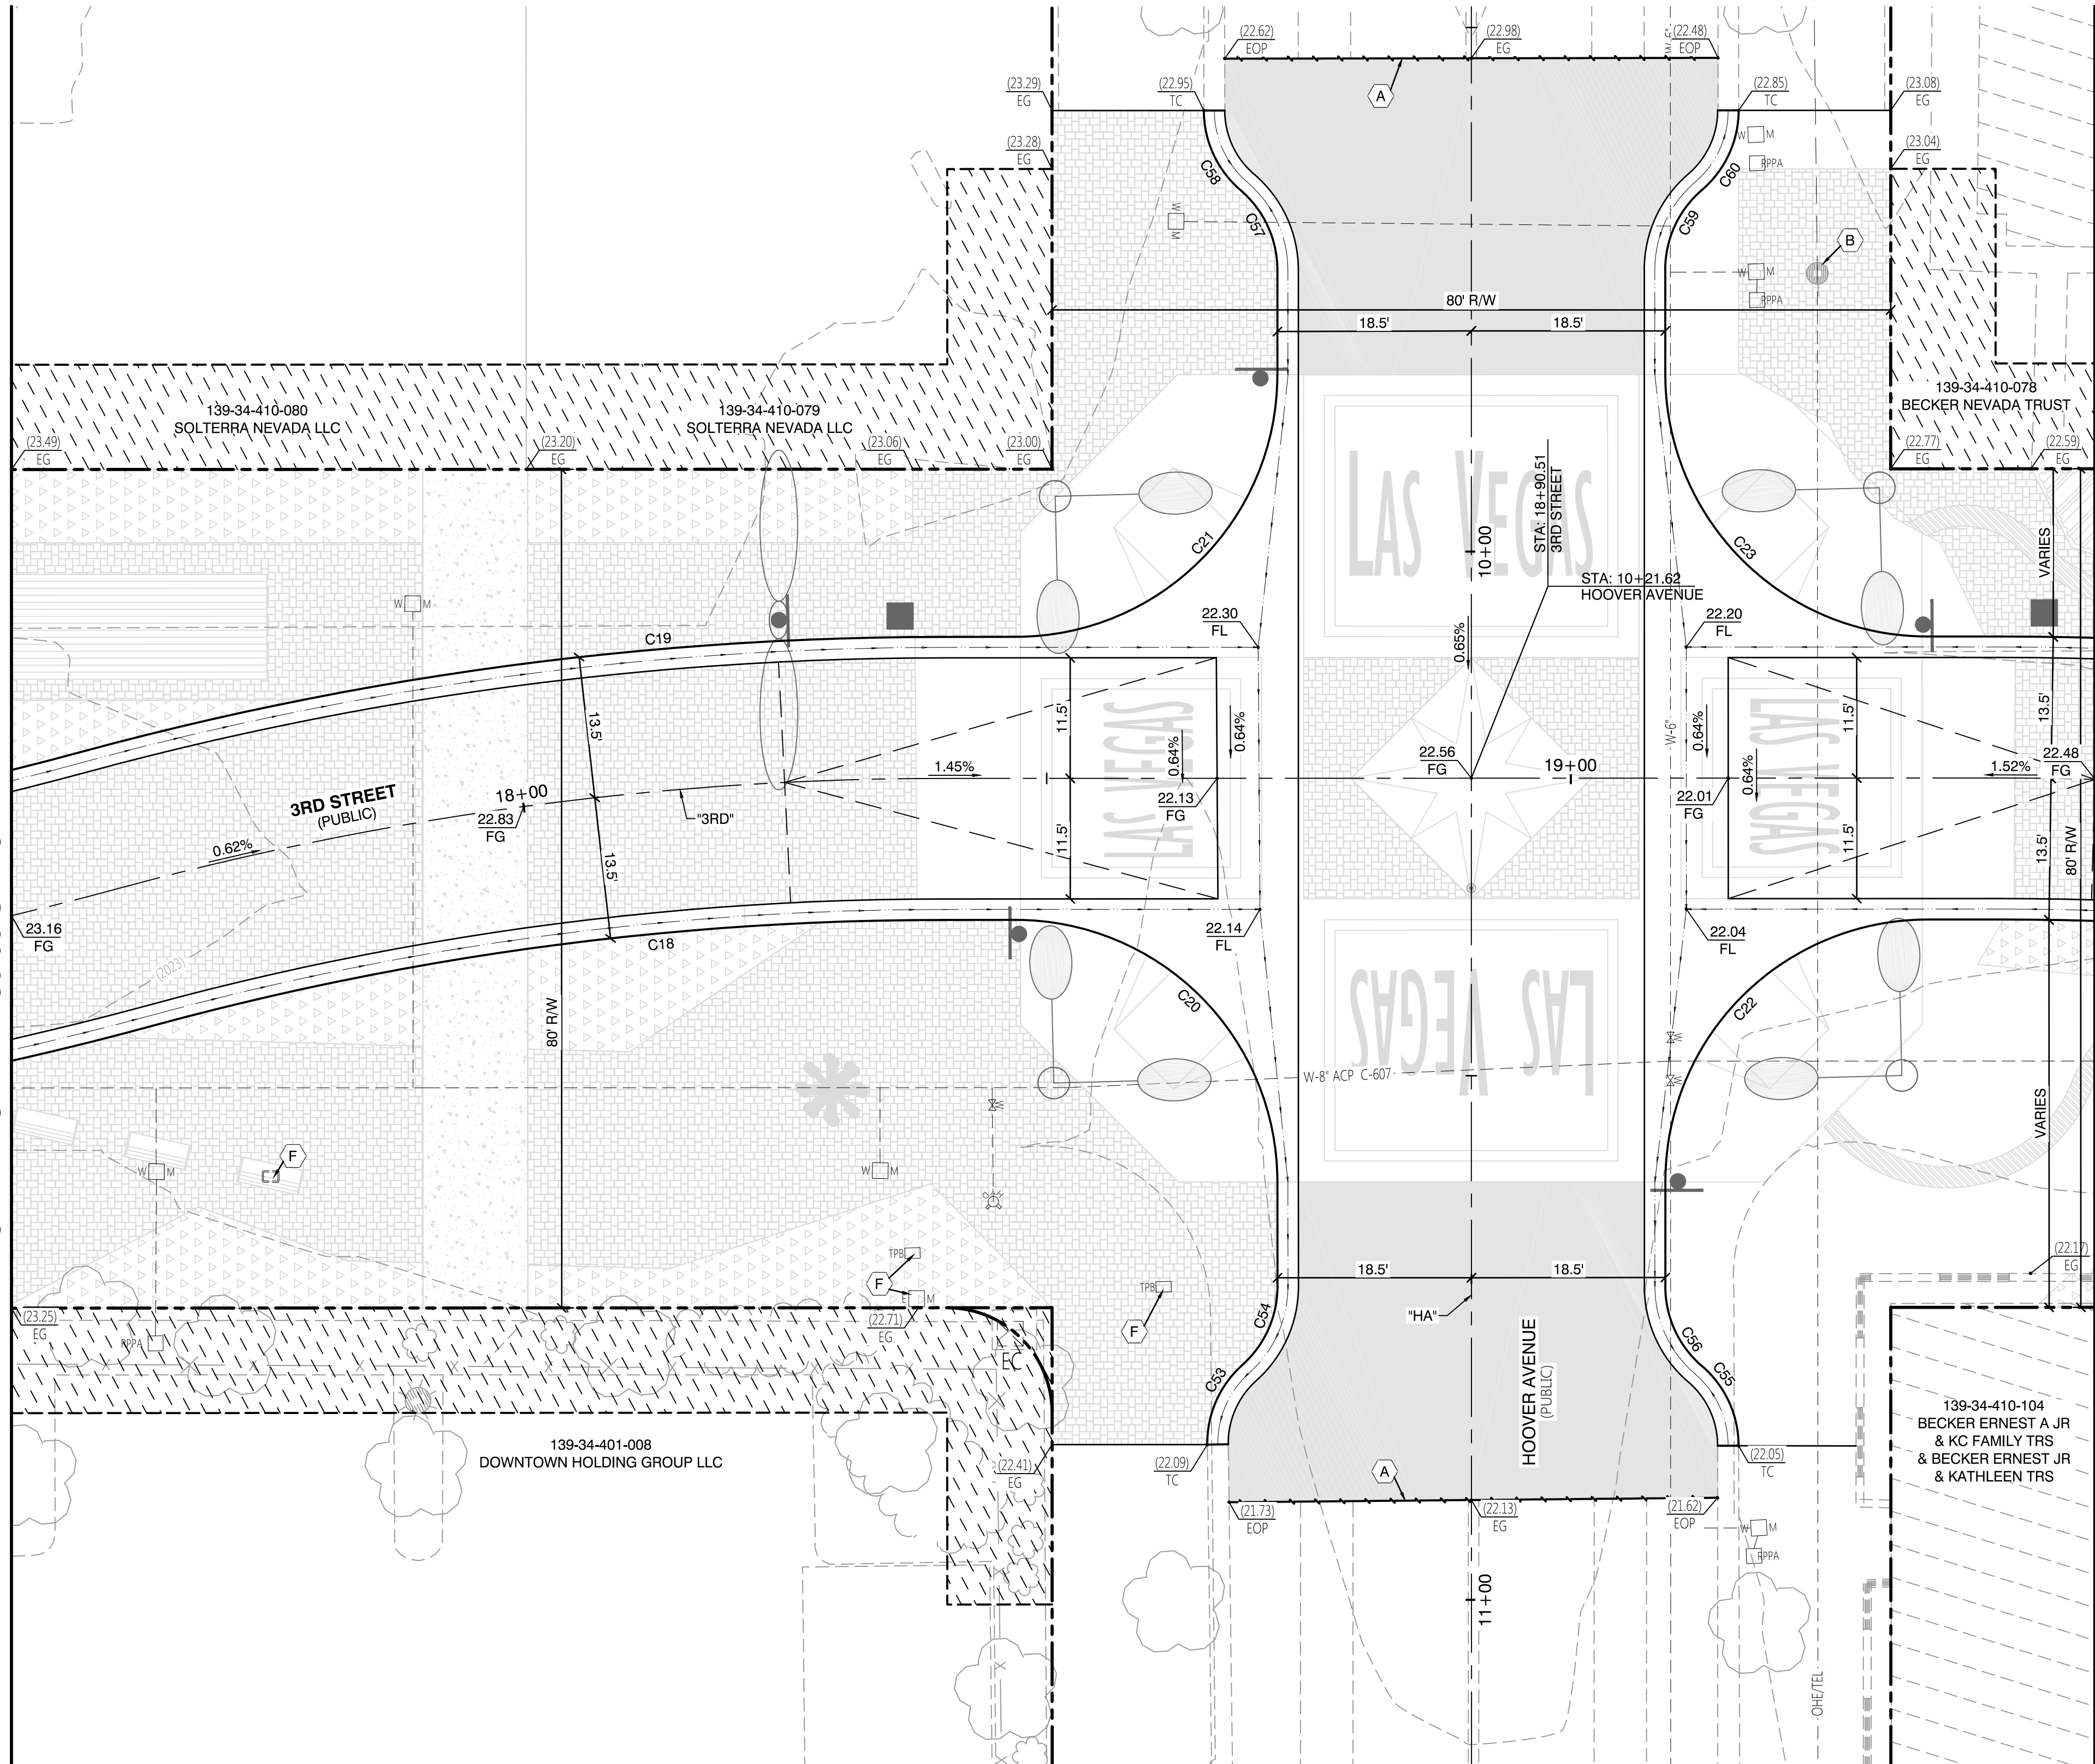

MATCHLINE STA 19+50.00 SEE SHEET PD6

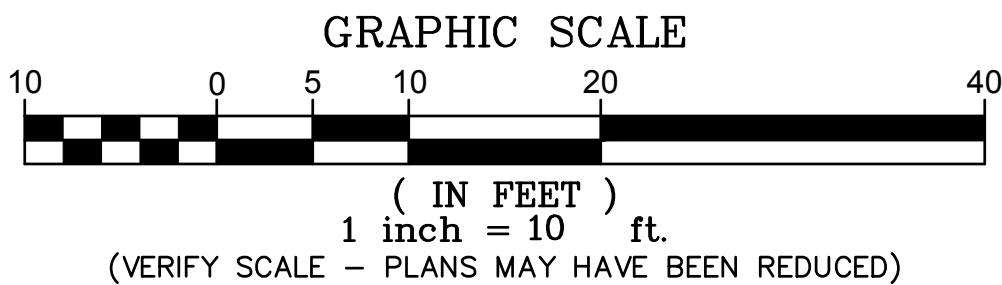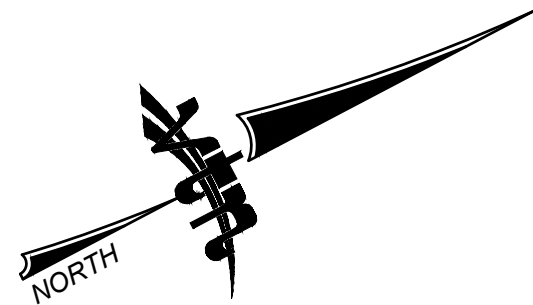

- LEGEND**
- PAVEMENT LIMITS
 - PROPOSED AEP
 - PAVERS
 - SPECIALTY CONCRETE
 - PLANTING HATCH
 - EXISTING PARKING METER TO BE RELOCATED. CONTRACTOR TO COORDINATE WITH THE CITY.
 - EXISTING LIGHT POLE
 - EXISTING UTILITY POLE
 - EXISTING WATER VALVE
 - EXISTING WATER METER
 - EXISTING FIRE HYDRANT
 - EXISTING UTILITY BOX
 - EXISTING OVERHEAD ELECTRIC
 - EXISTING STREETLIGHT CONDUIT
 - EXISTING FENCE
 - EXISTING CURB
 - EXISTING SIDEWALK
 - RIGHT-OF-WAY LINE
 - EXISTING PROPERTY LINE
 - PROPOSED CURB
 - PROPOSED LIP
 - PROPOSED FLOWLINE

- CONSTRUCTION NOTES**
- A SAWCUT AND MATCH EXISTING PAVEMENT
 - B EXISTING POWER POLE, P.I.P.
 - C EXISTING STREETLIGHT, P.I.P.
 - D EXISTING SIGN, P.I.P.
 - E EXISTING UTILITY. ADJUST TO GRADE. SEE ROADWAY PLANS.
 - F EXISTING UTILITY, P.I.P.

CURVE TABLE				
CURVE	RADIUS	DELTA	LENGTH	TANGENT
C18	286.50'	15°12'13"	76.02'	38.24'
C19	313.50'	15°12'13"	83.19'	41.84'
C20	25.00'	90°00'34"	39.27'	25.00'
C21	25.00'	89°58'27"	39.26'	24.99'
C22	25.00'	89°59'26"	39.27'	25.00'
C23	25.00'	90°01'33"	39.28'	25.01'
C53	10.00'	49°01'17"	8.56'	4.56'
C54	10.00'	48°16'57"	8.43'	4.48'
C55	10.00'	49°28'31"	8.64'	4.61'
C56	10.00'	49°23'35"	8.62'	4.60'
C57	10.00'	49°31'24"	8.64'	4.61'
C58	10.00'	49°31'24"	8.64'	4.61'
C59	10.00'	49°26'42"	8.63'	4.60'
C60	10.00'	49°26'42"	8.63'	4.60'

BASIS OF BEARINGS AND COORDINATES

GRID NORTH AS DEFINED BY THE CENTRAL MERIDIAN OF THE NEVADA COORDINATE REFERENCE SYSTEM (NCRS), LAS VEGAS ZONE, NORTH AMERICAN DATUM OF 1983; SAID MERIDIAN BEING COINCIDENT WITH 114°58' WEST OF THE GREENWICH MERIDIAN.

LINEAR UNIT: US SURVEY FOOT (FTUS)

DATUM (REFERENCE FRAME): NAD 1983 (CORS 96) EPOCH 2002.0

SYSTEM: NEVADA COORDINATE REFERENCE SYSTEM (NCRS)

ZONE: LAS VEGAS


PROJECTION: TRANSVERSE MERCATOR
STANDARD PARALLEL (AND LATITUDE OF GRID ORIGIN): 36°15'00"N
LONGITUDE OF CENTRAL MERIDIAN: 114°58'00"W
NORTHING AT GRID ORIGIN: 200,000,000 M (656,166,666.7 FTUS)
EASTING AT CENTRAL MERIDIAN: 100,000,000 M (328,083,333.3 FTUS)
SCALE FACTOR ON CENTRAL MERIDIAN: 1.0001 (EXACT)

NOTES:

1. ALL DISTANCES AND BEARINGS SHOWN HEREON ARE PROJECTED (GRID) VALUES BASED ON THE PRECEDING PROJECTION DEFINITION. THE PROJECTION WAS DEFINED SUCH THAT PROJECTED (GRID) DISTANCES ARE EQUIVALENT TO 'GROUND' DISTANCES IN THE PROJECT AREA.

2. GRID BEARINGS SHOWN HEREON (OR IMPLIED BY GRID COORDINATES) DO NOT EQUAL GEODETIC BEARINGS DUE TO MERIDIAN CONVERGENCE.

30% Submittal
"NOT FOR CONSTRUCTION"
December 2016

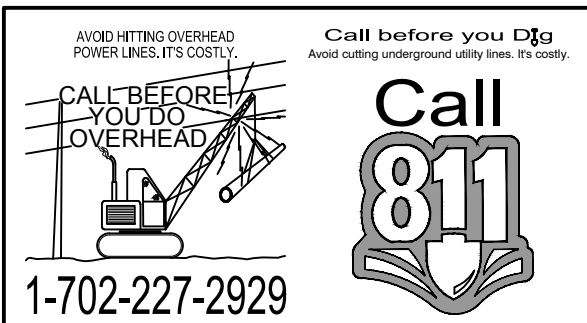

PROJECT BENCHMARK

PROJECT DATUM: NORTH AMERICAN VERTICAL DATUM OF 1988 (NAVD88) (2008 ADJUSTMENT)

CITY OF LAS VEGAS BENCHMARK: 1LV01-34NW6
NAVD88 ELEVATION: 617.329 METERS (2025.353 FEET)

3" NDOT BRASS CAP IN TOP OF CURB AT SE CORNER OF MAIN AND BRIDGER.

PREPARED BY
CITY OF LAS VEGAS
2727 SOUTH RAINBOW BOULEVARD
LAS VEGAS, NEVADA 89146-5148
PH: (702) 879-7550
FAX: (702) 879-7550
WWW.VTNV.COM

DESIGNED BY: MD
DRAWN BY: ND
CHECKED BY: LL

DATE: --
SUBMITTAL STAGE: 30% Submittal

DESIGNED BY: MD
DRAWN BY: ND
CHECKED BY: LL

PREPARED FOR
CITY OF LAS VEGAS
2727 SOUTH RAINBOW BOULEVARD
LAS VEGAS, NEVADA 89146-5148
PH: (702) 879-7550
FAX: (702) 879-7550
WWW.VTNV.COM

DESIGNED BY: MD
DRAWN BY: ND
CHECKED BY: LL

DATE: --
SUBMITTAL STAGE: 30% Submittal

DESIGNED BY: MD
DRAWN BY: ND
CHECKED BY: LL

PREPARED FOR
CITY OF LAS VEGAS
2727 SOUTH RAINBOW BOULEVARD
LAS VEGAS, NEVADA 89146-5148
PH: (702) 879-7550
FAX: (702) 879-7550
WWW.VTNV.COM

DESIGNED BY: MD
DRAWN BY: ND
CHECKED BY: LL

DATE: --
SUBMITTAL STAGE: 30% Submittal

DESIGNED BY: MD
DRAWN BY: ND
CHECKED BY: LL

PREPARED FOR
CITY OF LAS VEGAS
2727 SOUTH RAINBOW BOULEVARD
LAS VEGAS, NEVADA 89146-5148
PH: (702) 879-7550
FAX: (702) 879-7550
WWW.VTNV.COM

DESIGNED BY: MD
DRAWN BY: ND
CHECKED BY: LL

DATE: --
SUBMITTAL STAGE: 30% Submittal

DESIGNED BY: MD
DRAWN BY: ND
CHECKED BY: LL

PROFESSIONAL ENGINEER
ROBERT HOSKINS III
No. 10112
CIVIL

NOT FOR CONSTRUCTION




12/21/16

PD5
28 OF 61

DRAWING NO.

MATCHLINE STA 19+50.00 SEE SHEET PD5

MATCHLINE STA 21+50.00 SEE SHEET PD7

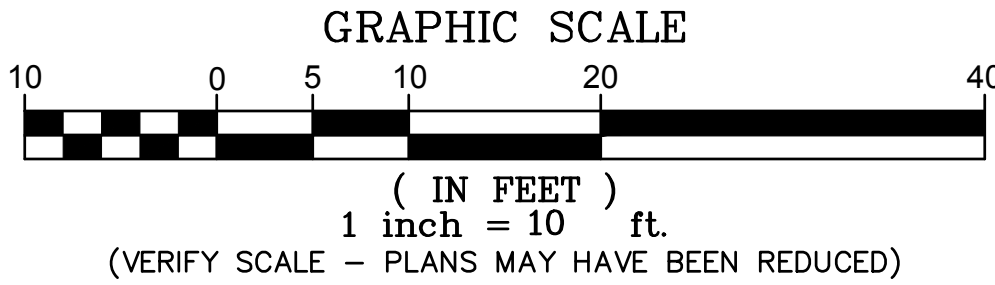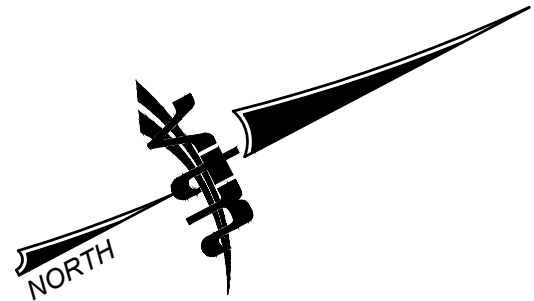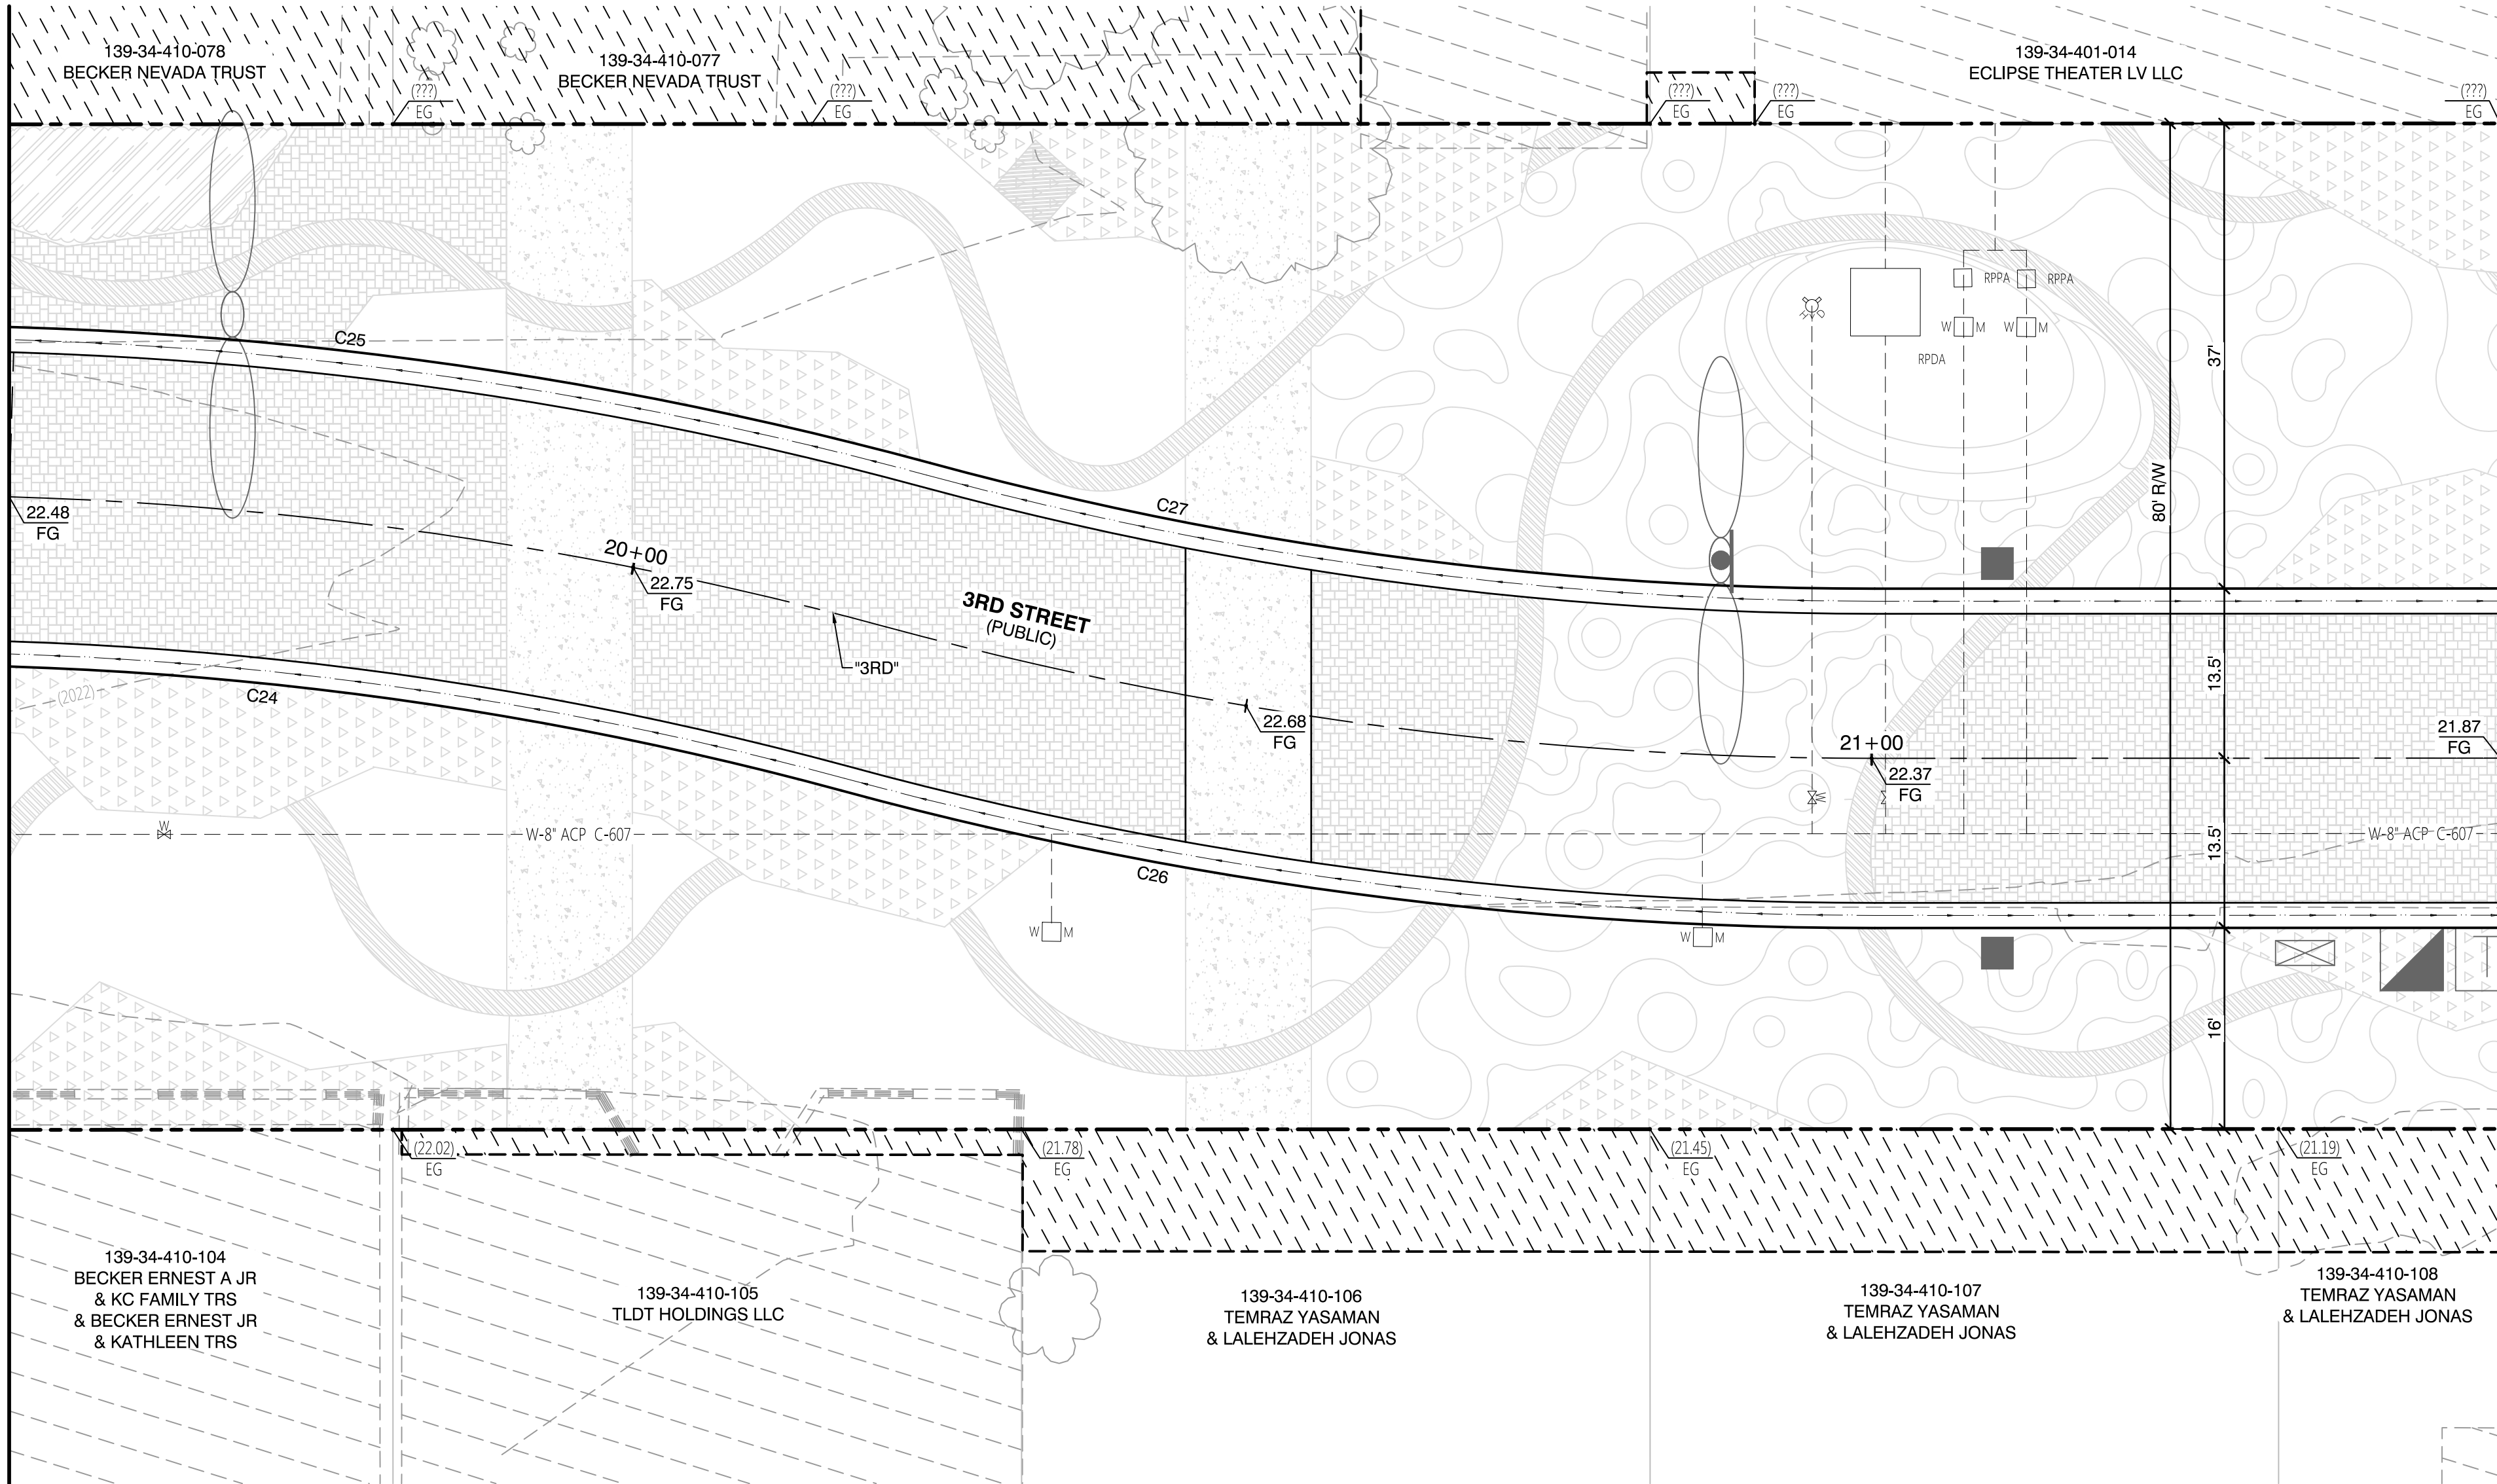

- LEGEND**
- PROPOSED AEP
 - PAVERS
 - PAVERS (3)
 - SPECIALTY CONCRETE
 - PLANTING HATCH
 - EJ HATCH
 - EXISTING PARKING METER TO BE RELOCATED. CONTRACTOR TO COORDINATE WITH THE CITY.
 - EXISTING LIGHT POLE
 - EXISTING UTILITY POLE
 - EXISTING WATER VALVE
 - EXISTING WATER METER
 - EXISTING FIRE HYDRANT
 - EXISTING UTILITY BOX
 - EXISTING OVERHEAD ELECTRIC
 - EXISTING STREETLIGHT CONDUIT
 - EXISTING FENCE
 - EXISTING CURB
 - EXISTING SIDEWALK
 - RIGHT-OF-WAY LINE
 - EXISTING PROPERTY LINE
 - PROPOSED CURB
 - PROPOSED LIP
 - PROPOSED FLOWLINE

- CONSTRUCTION NOTES**
- SAWCUT AND MATCH EXISTING PAVEMENT
 - EXISTING POWER POLE, P.I.P.
 - EXISTING STREETLIGHT, P.I.P.
 - EXISTING SIGN, P.I.P.
 - EXISTING UTILITY. ADJUST TO GRADE. SEE ROADWAY PLANS.
 - EXISTING UTILITY, P.I.P.

CURVE TABLE				
CURVE	RADIUS	DELTA	LENGTH	TANGENT
C24	286.50'	15°12'13"	76.02'	38.24'
C25	313.50'	15°12'13"	83.19'	41.84'
C26	313.50'	15°12'13"	83.19'	41.84'
C27	286.50'	15°12'13"	76.02'	38.24'

BASIS OF BEARINGS AND COORDINATES

GRID NORTH AS DEFINED BY THE CENTRAL MERIDIAN OF THE NEVADA COORDINATE REFERENCE SYSTEM (NCRS), LAS VEGAS ZONE, NORTH AMERICAN DATUM OF 1983; SAID MERIDIAN BEING COINCIDENT WITH 114°58' WEST OF THE GREENWICH MERIDIAN.

LINEAR UNIT: US SURVEY FOOT (FTUS)

DATUM (REFERENCE FRAME): NAD 1983 (CORS 96) EPOCH 2002.0


SYSTEM: NEVADA COORDINATE REFERENCE SYSTEM (NCRS)

ZONE: LAS VEGAS

PROJECTION: TRANSVERSE MERCATOR
STANDARD PARALLEL (AND LATITUDE OF GRID ORIGIN): 36°15'00"N
LONGITUDE OF CENTRAL MERIDIAN: 114°58'00"W
NORTHING AT GRID ORIGIN: 200,000,000 M (656,166,667 FTUS)
EASTING AT CENTRAL MERIDIAN: 100,000,000 M (328,083,333 FTUS)
SCALE FACTOR ON CENTRAL MERIDIAN: 1.0001 (EXACT)

NOTES:
1. ALL DISTANCES AND BEARINGS SHOWN HEREON ARE PROJECTED (GRID) VALUES BASED ON THE PRECEDING PROJECTION DEFINITION. THE PROJECTION WAS DEFINED SUCH THAT PROJECTED (GRID) DISTANCES ARE EQUIVALENT TO 'GROUND' DISTANCES IN THE PROJECT AREA.
2. GRID BEARINGS SHOWN HEREON (OR IMPLIED BY GRID COORDINATES) DO NOT EQUAL GEODETIC BEARINGS DUE TO MERIDIAN CONVERGENCE.

30% Submittal
"NOT FOR CONSTRUCTION"
December 2016

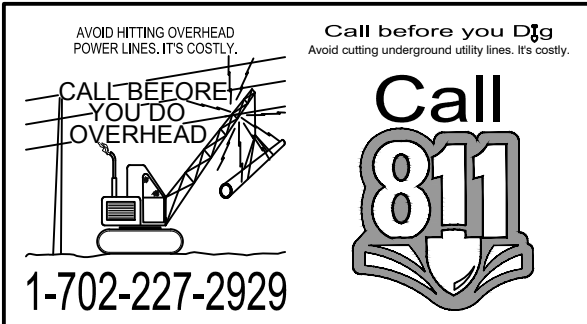

PROJECT BENCHMARK

PROJECT DATUM: NORTH AMERICAN VERTICAL DATUM OF 1988 (NAVD88) (2008 ADJUSTMENT)

CITY OF LAS VEGAS BENCHMARK: 1LV01-34NW6
NAVD88 ELEVATION: 617.329 METERS (2025.353 FEET)

3" NDOT BRASS CAP IN TOP OF CURB AT SE CORNER OF MAIN AND BRIDGER.

PREPARED BY
CITY OF LAS VEGAS
2727 SOUTH RAINBOW BOULEVARD
LAS VEGAS, NEVADA 89146-5148
PH: (702) 879-7550
FAX: (702) 879-7551
WWW.VTNV.COM

DESIGNED BY: MD
DRAWN BY: ND
CHECKED BY: LL

BID# ---
DATE: --
SUBMITTAL STAGE:
30% Submittal

PREPARED FOR
CITY OF LAS VEGAS
2727 SOUTH RAINBOW BOULEVARD
LAS VEGAS, NEVADA 89146-5148
PH: (702) 879-7550
FAX: (702) 879-7551
WWW.VTNV.COM

DESIGNED BY: MD
DRAWN BY: ND
CHECKED BY: LL

BID# ---
DATE: --
SUBMITTAL STAGE:
30% Submittal

PREPARED BY
CITY OF LAS VEGAS
2727 SOUTH RAINBOW BOULEVARD
LAS VEGAS, NEVADA 89146-5148
PH: (702) 879-7550
FAX: (702) 879-7551
WWW.VTNV.COM

DESIGNED BY: MD
DRAWN BY: ND
CHECKED BY: LL

BID# ---
DATE: --
SUBMITTAL STAGE:
30% Submittal

PREPARED FOR
CITY OF LAS VEGAS
2727 SOUTH RAINBOW BOULEVARD
LAS VEGAS, NEVADA 89146-5148
PH: (702) 879-7550
FAX: (702) 879-7551
WWW.VTNV.COM

DESIGNED BY: MD
DRAWN BY: ND
CHECKED BY: LL

BID# ---
DATE: --
SUBMITTAL STAGE:
30% Submittal

PROFESSIONAL ENGINEER
ROBERT HOSKINS III
No. 10112
CIVIL

NOT FOR CONSTRUCTION

12/21/16

PROPERTY DETAILS

3RD STREET-PHASE 2
CHARLESTON TO BONNEVILLE


30% Submittal

PD6



29 OF 61

DRAWING NO.

MATCHLINE STA 21 + 50.00 SEE SHEET PD6

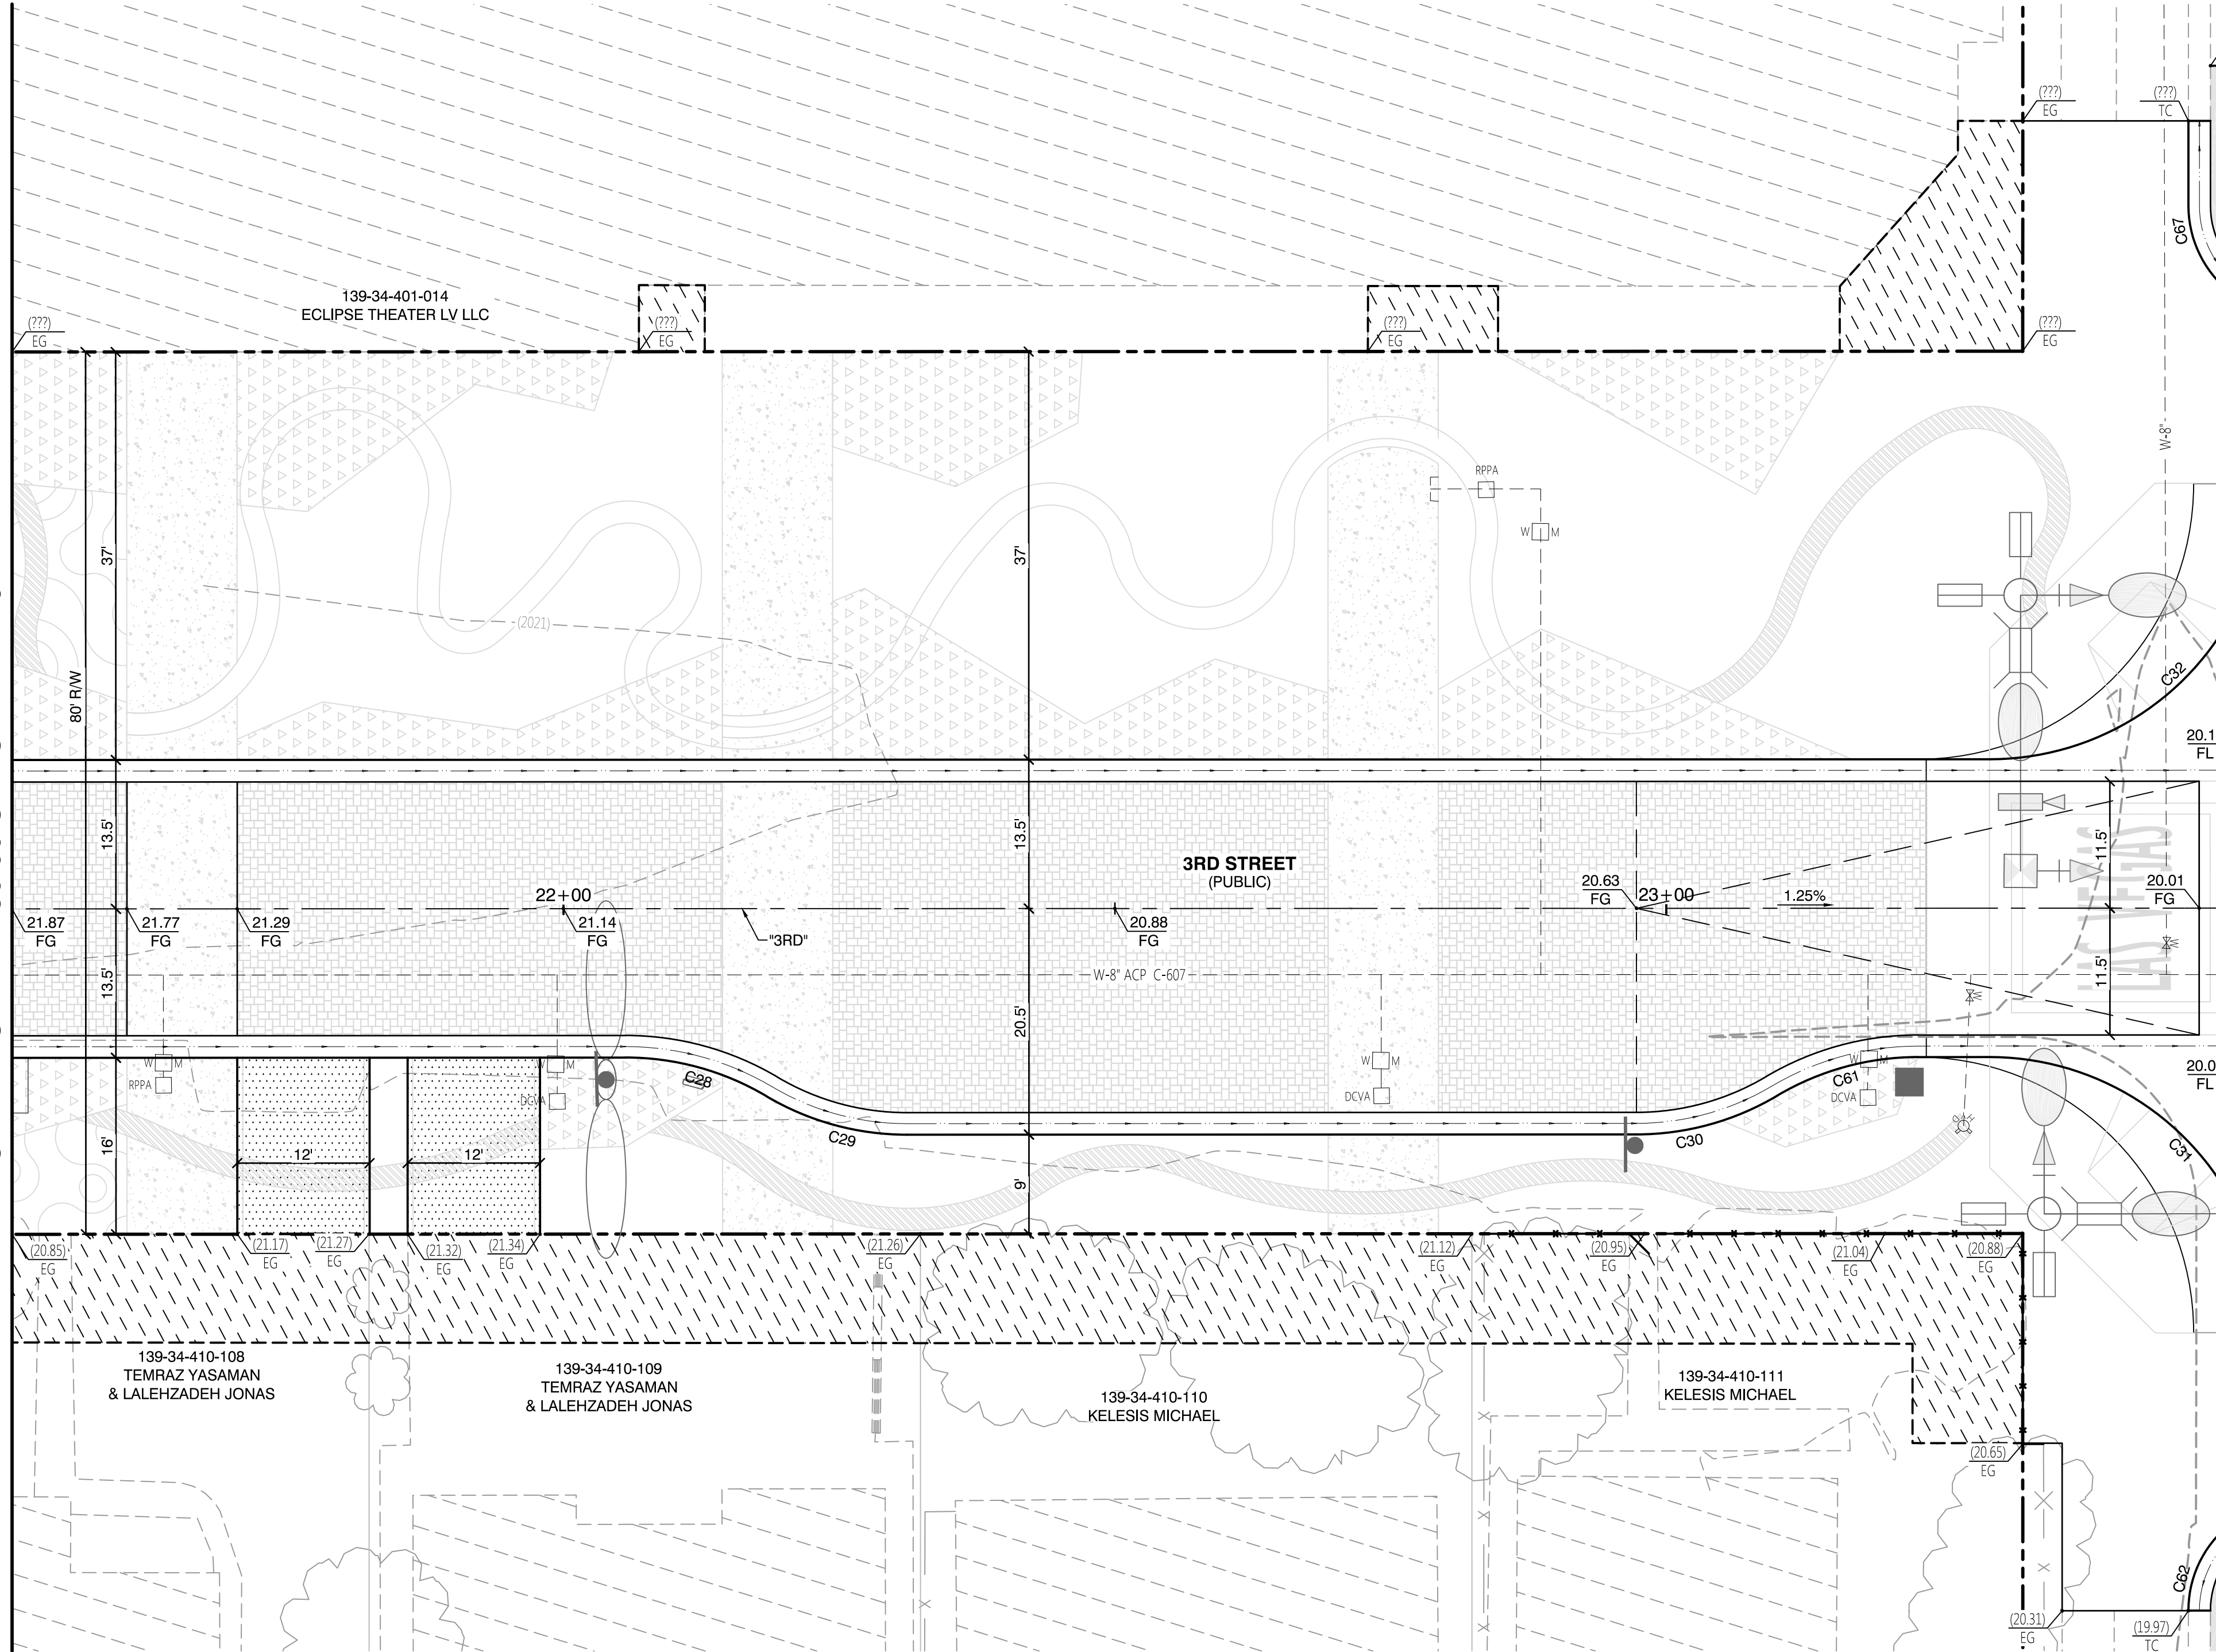

MATCHLINE STA 23 + 50.00 SEE SHEET PD8

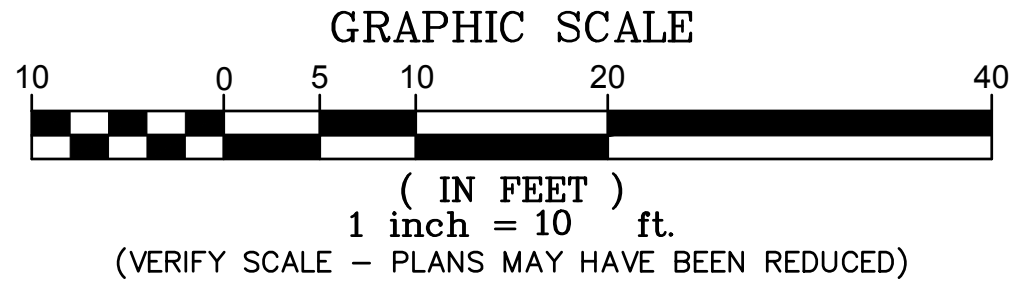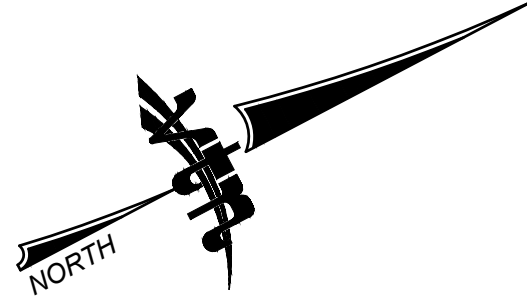

- LEGEND**
- PROPOSED AEP
 - DRIVEWAY LIMITS
 - PAVERS
 - PAVERS (3)
 - SPECIALTY CONCRETE
 - PLANTING HATCH
 - EJ HATCH
 - EXISTING PARKING METER TO BE RELOCATED. CONTRACTOR TO COORDINATE WITH THE CITY.
 - EXISTING LIGHT POLE
 - EXISTING UTILITY POLE
 - EXISTING WATER VALVE
 - EXISTING WATER METER
 - EXISTING FIRE HYDRANT
 - EXISTING UTILITY BOX
 - EXISTING OVERHEAD ELECTRIC
 - EXISTING STREETLIGHT CONDUIT
 - EXISTING FENCE
 - EXISTING CURB
 - EXISTING SIDEWALK
 - RIGHT-OF-WAY LINE
 - EXISTING PROPERTY LINE
 - PROPOSED CURB
 - PROPOSED LIP
 - PROPOSED FLOWLINE

- CONSTRUCTION NOTES**
- A SAWCUT AND MATCH EXISTING PAVEMENT
 - B EXISTING POWER POLE, P.I.P.
 - C EXISTING STREETLIGHT, P.I.P.
 - D EXISTING SIGN, P.I.P.
 - E EXISTING UTILITY. ADJUST TO GRADE. SEE ROADWAY PLANS.
 - F EXISTING UTILITY, P.I.P.

CURVE TABLE				
CURVE	RADIUS	DELTA	LENGTH	TANGENT
C28	25.00'	30°41'00"	13.39'	6.86'
C29	25.00'	30°41'00"	13.39'	6.86'
C30	25.00'	30°41'00"	13.39'	6.86'
C31	25.00'	90°01'00"	39.28'	25.01'
C32	25.00'	89°58'16"	39.26'	24.99'
C61	25.00'	30°41'00"	13.39'	6.86'
C62	10.00'	49°23'24"	8.62'	4.60'
C67	10.00'	49°22'36"	8.62'	4.60'

BASIS OF BEARINGS AND COORDINATES

GRID NORTH AS DEFINED BY THE CENTRAL MERIDIAN OF THE NEVADA COORDINATE REFERENCE SYSTEM (NCRS), LAS VEGAS ZONE, NORTH AMERICAN DATUM OF 1983; SAID MERIDIAN BEING COINCIDENT WITH 114°58' WEST OF THE GREENWICH MERIDIAN.

LINEAR UNIT: US SURVEY FOOT (FTUS)

DATUM (REFERENCE FRAME): NAD 1983 (CORS 96) EPOCH 2002.0


SYSTEM: NEVADA COORDINATE REFERENCE SYSTEM (NCRS)

ZONE: LAS VEGAS

PROJECTION: TRANSVERSE MERCATOR
STANDARD PARALLEL (AND LATITUDE OF GRID ORIGIN): 36°15'00"N
LONGITUDE OF CENTRAL MERIDIAN: 114°58'00"W
NORTHING AT GRID ORIGIN: 200,000,000 M (656,166,667 FTUS)
EASTING AT CENTRAL MERIDIAN: 100,000,000 M (328,083,333 FTUS)
SCALE FACTOR ON CENTRAL MERIDIAN: 1.0001 (EXACT)

NOTES:
1. ALL DISTANCES AND BEARINGS SHOWN HEREON ARE PROJECTED (GRID) VALUES BASED ON THE PRECEDING PROJECTION DEFINITION. THE PROJECTION WAS DEFINED SUCH THAT PROJECTED (GRID) DISTANCES ARE EQUIVALENT TO 'GROUND' DISTANCES IN THE PROJECT AREA.
2. GRID BEARINGS SHOWN HEREON (OR IMPLIED BY GRID COORDINATES) DO NOT EQUAL GEODETIC BEARINGS DUE TO MERIDIAN CONVERGENCE.

30% Submittal
"NOT FOR CONSTRUCTION"
December 2016

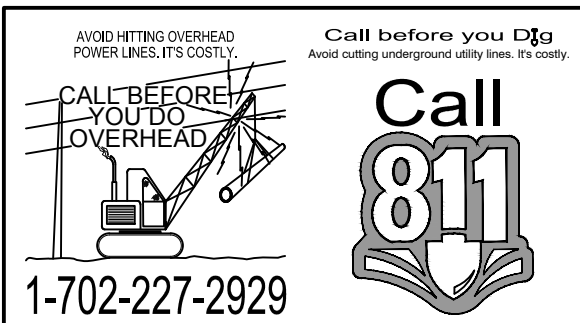

PROJECT BENCHMARK

PROJECT DATUM: NORTH AMERICAN VERTICAL DATUM OF 1988 (NAVD88) (2008 ADJUSTMENT)

CITY OF LAS VEGAS BENCHMARK: 1LV01-34NW6
NAVD88 ELEVATION: 617.329 METERS (2025.353 FEET)

3" NDOT BRASS CAP IN TOP OF CURB AT SE CORNER OF MAIN AND BRIDGER.

PREPARED BY
CITY OF LAS VEGAS
2727 SOUTH RAINBOW BOULEVARD
LAS VEGAS, NEVADA 89146-5148
PH: (702) 879-7550
FAX: (702) 879-7550
WWW.VTNV.COM

DESIGNED BY: MD
DRAWN BY: ND
CHECKED BY: LL

DATE: --
SUBMITTAL STAGE: 30% Submittal

DOWNTOWN PEDESTRIAN AND BICYCLE IMPROVEMENTS
3RD STREET-PHASE 2
CHARLESTON TO BONNEVILLE

PROPERTY DETAILS

2727 SOUTH RAINBOW BOULEVARD
LAS VEGAS, NEVADA 89146-5148
PH: (702) 879-7550
FAX: (702) 879-7550
WWW.VTNV.COM

DEPARTMENT OF PUBLIC WORKS
333 N. RANCHO DRIVE
LAS VEGAS, NV 89101
702-229-8272

PROFESSIONAL ENGINEER
ROBERT HOSKINS III
No. 10112




NOT FOR CONSTRUCTION

SHEET

PD7
30 OF 61

DRAWING NO.

MATCHLINE STA 23+50.00 SEE SHEET PD7

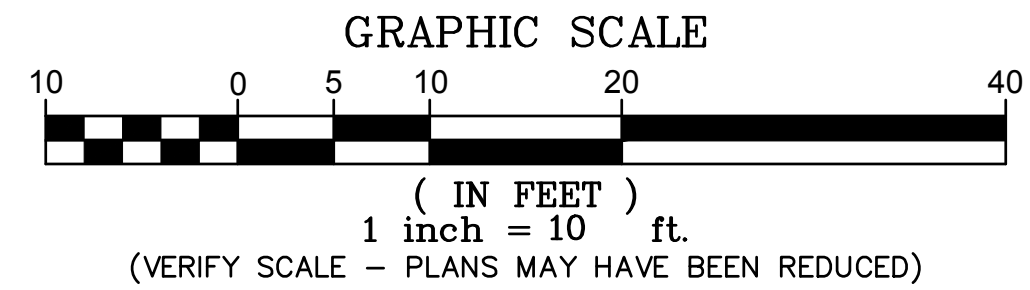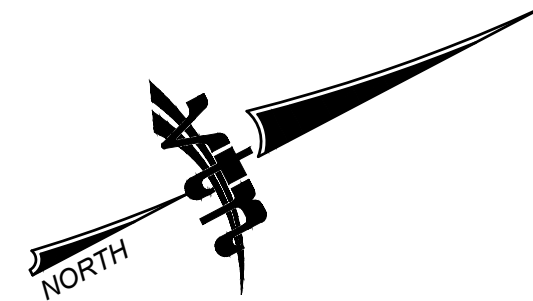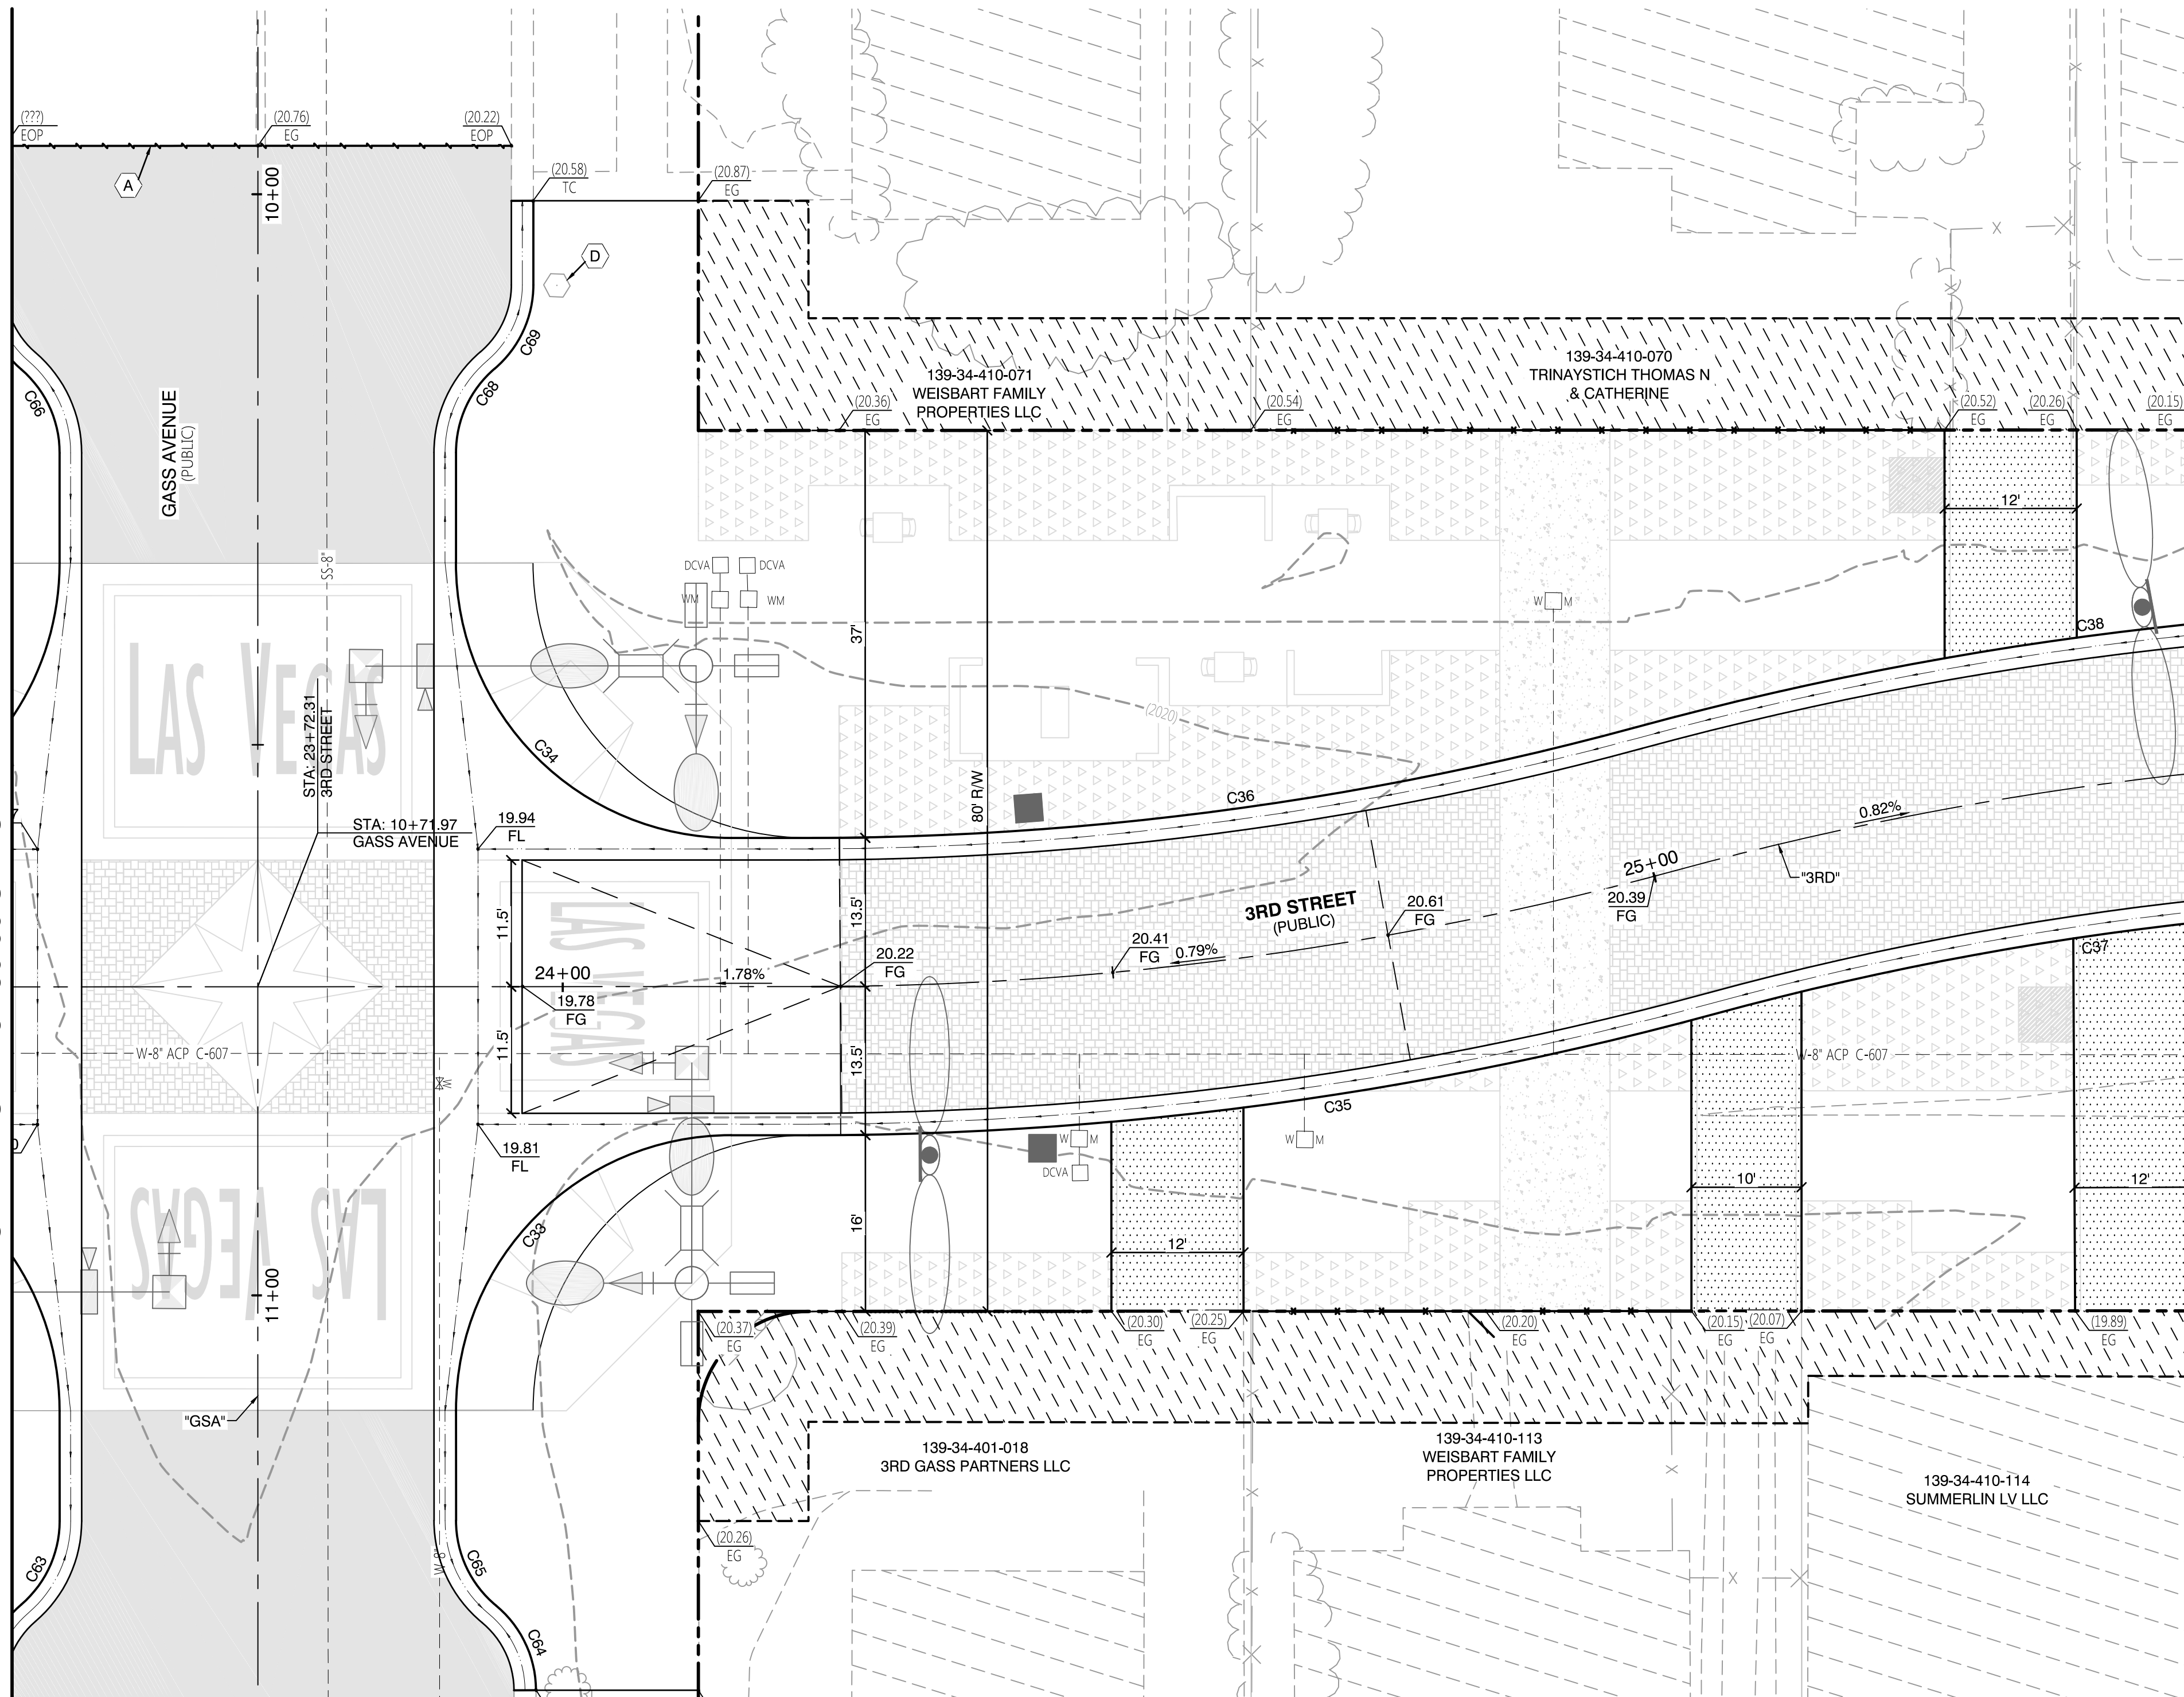

LEGEND		CONSTRUCTION NOTES	
	PAVEMENT LIMITS		SAWCUT AND MATCH EXISTING PAVEMENT
	DRIVEWAY LIMITS		EXISTING POWER POLE, P.I.P.
	PROPOSED AEP		EXISTING STREETLIGHT, P.I.P.
	PAVERS		EXISTING SIGN, P.I.P.
	SPECIALTY CONCRETE		EXISTING UTILITY. ADJUST TO GRADE. SEE ROADWAY PLANS.
	PLANTING HATCH		EXISTING UTILITY, P.I.P.
	EXISTING PARKING METER TO BE RELOCATED. CONTRACTOR TO COORDINATE WITH THE CITY.		
	EXISTING LIGHT POLE		
	EXISTING UTILITY POLE		
	EXISTING WATER VALVE		
WOM	EXISTING WATER METER		
	EXISTING FIRE HYDRANT		
	EXISTING UTILITY BOX		
--- GHE ---	EXISTING OVERHEAD ELECTRIC		
--- STL ---	EXISTING STREETLIGHT CONDUIT		
— X —	EXISTING FENCE		
----	EXISTING CURB		
-----	EXISTING SIDEWALK		
-----	RIGHT-OF-WAY LINE		
-----	EXISTING PROPERTY LINE		
-----	PROPOSED CURB		
-----	PROPOSED LIP		
-----	PROPOSED FLOWLINE		


CURVE TABLE				
CURVE	RADIUS	DELTA	LENGTH	TANGENT
C33	25.00'	89°59'00"	39.26'	24.99'
C34	25.00'	90°01'44"	39.28'	25.01'
C35	313.50'	15°12'13"	83.19'	41.84'
C36	286.50'	15°12'41"	76.06'	38.26'
C37	286.50'	15°12'13"	76.02'	38.24'
C38	313.50'	15°12'13"	83.19'	41.84'
C63	10.00'	49°23'49"	8.62'	4.60'
C64	10.00'	50°19'26"	8.78'	4.70'
C65	10.00'	50°25'06"	8.80'	4.71'
C66	10.00'	49°22'56"	8.62'	4.60'
C68	10.00'	49°32'04"	8.65'	4.61'
C69	10.00'	49°31'44"	8.64'	4.61'

BASIS OF BEARINGS AND COORDINATES
GRID NORTH AS DEFINED BY THE CENTRAL MERIDIAN OF THE NEVADA COORDINATE REFERENCE SYSTEM (NCRS) LAS VEGAS ZONE, NORTH AMERICAN DATUM OF 1983; SAID MERIDIAN BEING COINCIDENT WITH 114°58' WEST OF THE GREENWICH MERIDIAN.
LINEAR UNIT: US SURVEY FOOT (FTUS)
DATUM (REFERENCE FRAME): NAD 1983 (CORS 96) EPOCH 2002.0
SYSTEM: NEVADA COORDINATE REFERENCE SYSTEM (NCRS)
ZONE: LAS VEGAS
PROJECTION: CENTRAL MERCATOR STANDARD PARALLEL (AND LATITUDE OF GRID ORIGIN): 36°15'00"N LONGITUDE OF CENTRAL MERIDIAN: 114°58'00"W NORTHING AT GRID ORIGIN: 200,000,000 M (656,166.6667 FTUS) EASTING AT CENTRAL MERIDIAN: 100,000,000 M (328,083.3333 FTUS) SCALE FACTOR ON CENTRAL MERIDIAN: 1.0001 (EXACT)
NOTES: 1. ALL DISTANCES AND BEARINGS SHOWN HEREON ARE PROJECTED GRID VALUES BASED ON THE PRECEDING PROJECTION DEFINITION. THE PROJECTION WAS DEFINED SUCH THAT PROJECTED (GRID) DISTANCES ARE EQUIVALENT TO "GROUND" DISTANCES IN THE PROJECT AREA. 2. GRID BEARINGS SHOWN HEREON (OR IMPLIED BY GRID COORDINATES) DO NOT EQUAL GEODETIC BEARINGS DUE TO MERIDIAN CONVERGENCE.

30% Submittal
"NOT FOR CONSTRUCTION"
December 2016

PROJECT BENCHMARK
PROJECT DATUM: NORTH AMERICAN VERTICAL DATUM OF 1988 (NAVD88) (2008 ADJUSTMENT)
CITY OF LAS VEGAS BENCHMARK: 1LV01-34NW6 NAVD88 ELEVATION: 617.329 METERS (2025.353 FEET)
3" NDOT BRASS CAP IN TOP OF CURB AT SE CORNER OF MAIN AND BRIDGER.

 **AVOID HITTING OVERHEAD
POWER LINES. IT'S COSTLY.**



1-702-227-2929

 
Call before you Dig
Avoid hitting underground utilities. It's costly.





FAST



Call
before you
UnderGround
1-702-432-5300
FREEWAY AND ARTERIAL
SYSTEM OF TRANSPORTATION

	SHEET PD8 31 OF 61 DRAWING NO.		DOWNTOWN PEDESTRIAN AND BICYCLE IMPROVEMENTS 3RD STREET-PHASE 2 CHARLESTON TO BONNEVILLE		PREPARED FOR CITY OF LAS VEGAS		PREPARED BY 		2727 SOUTH RAINBOW BOULEVARD SUITE 100 LAS VEGAS, NV 89102 PH. (702) 873-5176 FAX (702) 342-2597 WEB SITE WWW.VTH.NV.COM						
	SHEET		PROPERTY DETAILS		H# 54616		BID# -----		DEPARTMENT OF PUBLIC WORKS 300 N. LAS VEGAS BLVD. LAS VEGAS, NV 89101 702-228-8272						
				DATE: --		DESIGNED BY: MD									
				SUBMITTAL STAGE: 30% Submittal		DRAWN BY: ND		NO. DATE							
						CHECKED BY: LL		REVISIONS							

  

	PROPOSED AEP
	DRIVEWAY LIMITS
	PAVERS
	PAVERS (2)
	SPECIALTY CONCRETE
	PLANTING HATCH
	TURF HATCH
	EXISTING PARKING METER TO BE RELOCATED. CONTRACTOR TO COORDINATE WITH THE CITY.
	EXISTING LIGHT POLE
	EXISTING UTILITY POLE
	EXISTING WATER VALVE
W=M	EXISTING WATER METER
	EXISTING FIRE HYDRANT
	EXISTING UTILITY BOX
— GHE —	EXISTING OVERHEAD ELECTRIC
— STL —	EXISTING STREETLIGHT CONDUIT
— X —	EXISTING FENCE
— — — — —	EXISTING CURB
— — — — —	EXISTING SIDEWALK
— — — — —	RIGHT-OF-WAY LINE
— — — — —	EXISTING PROPERTY LINE
— — — — —	PROPOSED CURB
— — — — —	PROPOSED LIP
— — — — —	PROPOSED FLOWLINE

A	SAWCUT AND MATCH EXISTING PAVEMENT
B	EXISTING POWER POLE, P.I.P.
C	EXISTING STREETLIGHT, P.I.P.
D	EXISTING SIGN, P.I.P.
E	EXISTING UTILITY. ADJUST TO GRADE. SEE ROADWAY PLANS.
F	EXISTING UTILITY, P.I.P.

CURVE TABLE				
CURVE	RADIUS	DELTA	LENGTH	TANGENT
C39	286.50'	10°44'05"	53.68'	26.92'
C40	313.50'	10°44'05"	58.74'	29.45'

MATCHLINE STA 27+50.00 SEE SHEET PD10

TH AS DEFINED BY THE CENTRAL MERIDIAN OF THE NEVADA
ATE REFERENCE SYSTEM (NCRS), LAS VEGAS ZONE, NORTH
D DATUM OF 1983; SAID MERIDIAN BEING COINCIDENT WITH
ST OF THE GREENWICH MERIDIAN.

UT: US SURVEY FOOT (FTUS)

ERENCE FRAME): NAD 1983 (CORS 96) EPOCH 2002.0


EVADA COORDINATE REFERENCE SYSTEM (NCRS)

S VEGAS

ON: TRANSVERSE MERCATOR
D PARALLEL (AND LATITUDE OF GRID ORIGIN): 36°15'00"N
DE OF CENTRAL MERIDIAN: 114°58'00"W
G AT GRID ORIGIN: 200,000,000 M (656,166,667 FTUS)
G AT CENTRAL MERIDIAN: 100,000,000 M (328,083.3333 FTUS)
CTOR ON CENTRAL MERIDIAN: 1.0001 (EXACT)

DISTANCES AND BEARINGS SHOWN HEREON ARE PROJECTED
UES BASED ON THE PRECEDING PROJECTION DEFINITION.
ECTION WAS DEFINED SUCH THAT PROJECTED (GRID)
S ARE EQUIVALENT TO "GROUND" DISTANCES IN THE PROJECT




BEARINGS SHOWN HEREON (OR IMPLIED BY GRID
ATES) DO NOT EQUAL GEODETIC BEARINGS DUE TO MERIDIAN
ENCE.

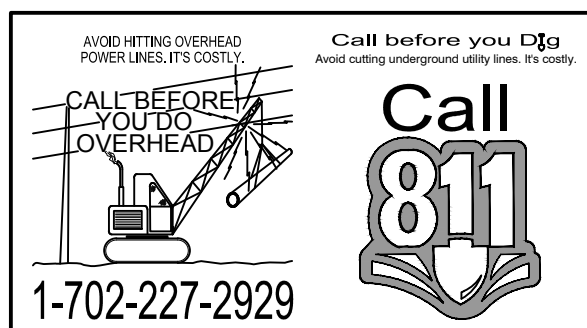

30% Submittal
"NOT FOR CONSTRUCTION"
December 2016

PROJECT BENCHMARK
PROJECT DATUM: NORTH AMERICAN VERTICAL DATUM OF 1988 (NAVD88) (2008 ADJUSTMENT)
CITY OF LAS VEGAS BENCHMARK: 1LV01-34NW6 NAVD88 ELEVATION: 617.329 METERS (2025.353 FEET)
3" NDOT BRASS CAP IN TOP OF CURB AT SE CORNER OF MAIN AND BRIDG

[illegible]

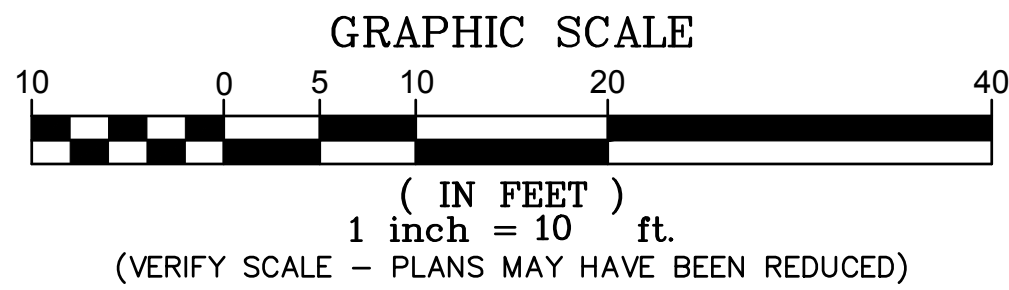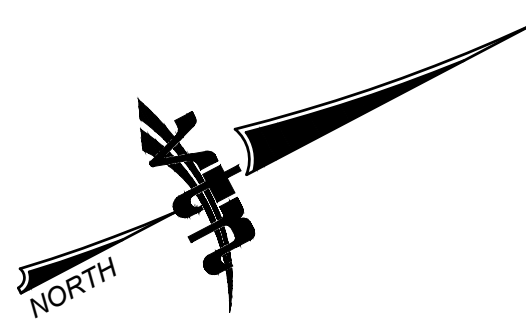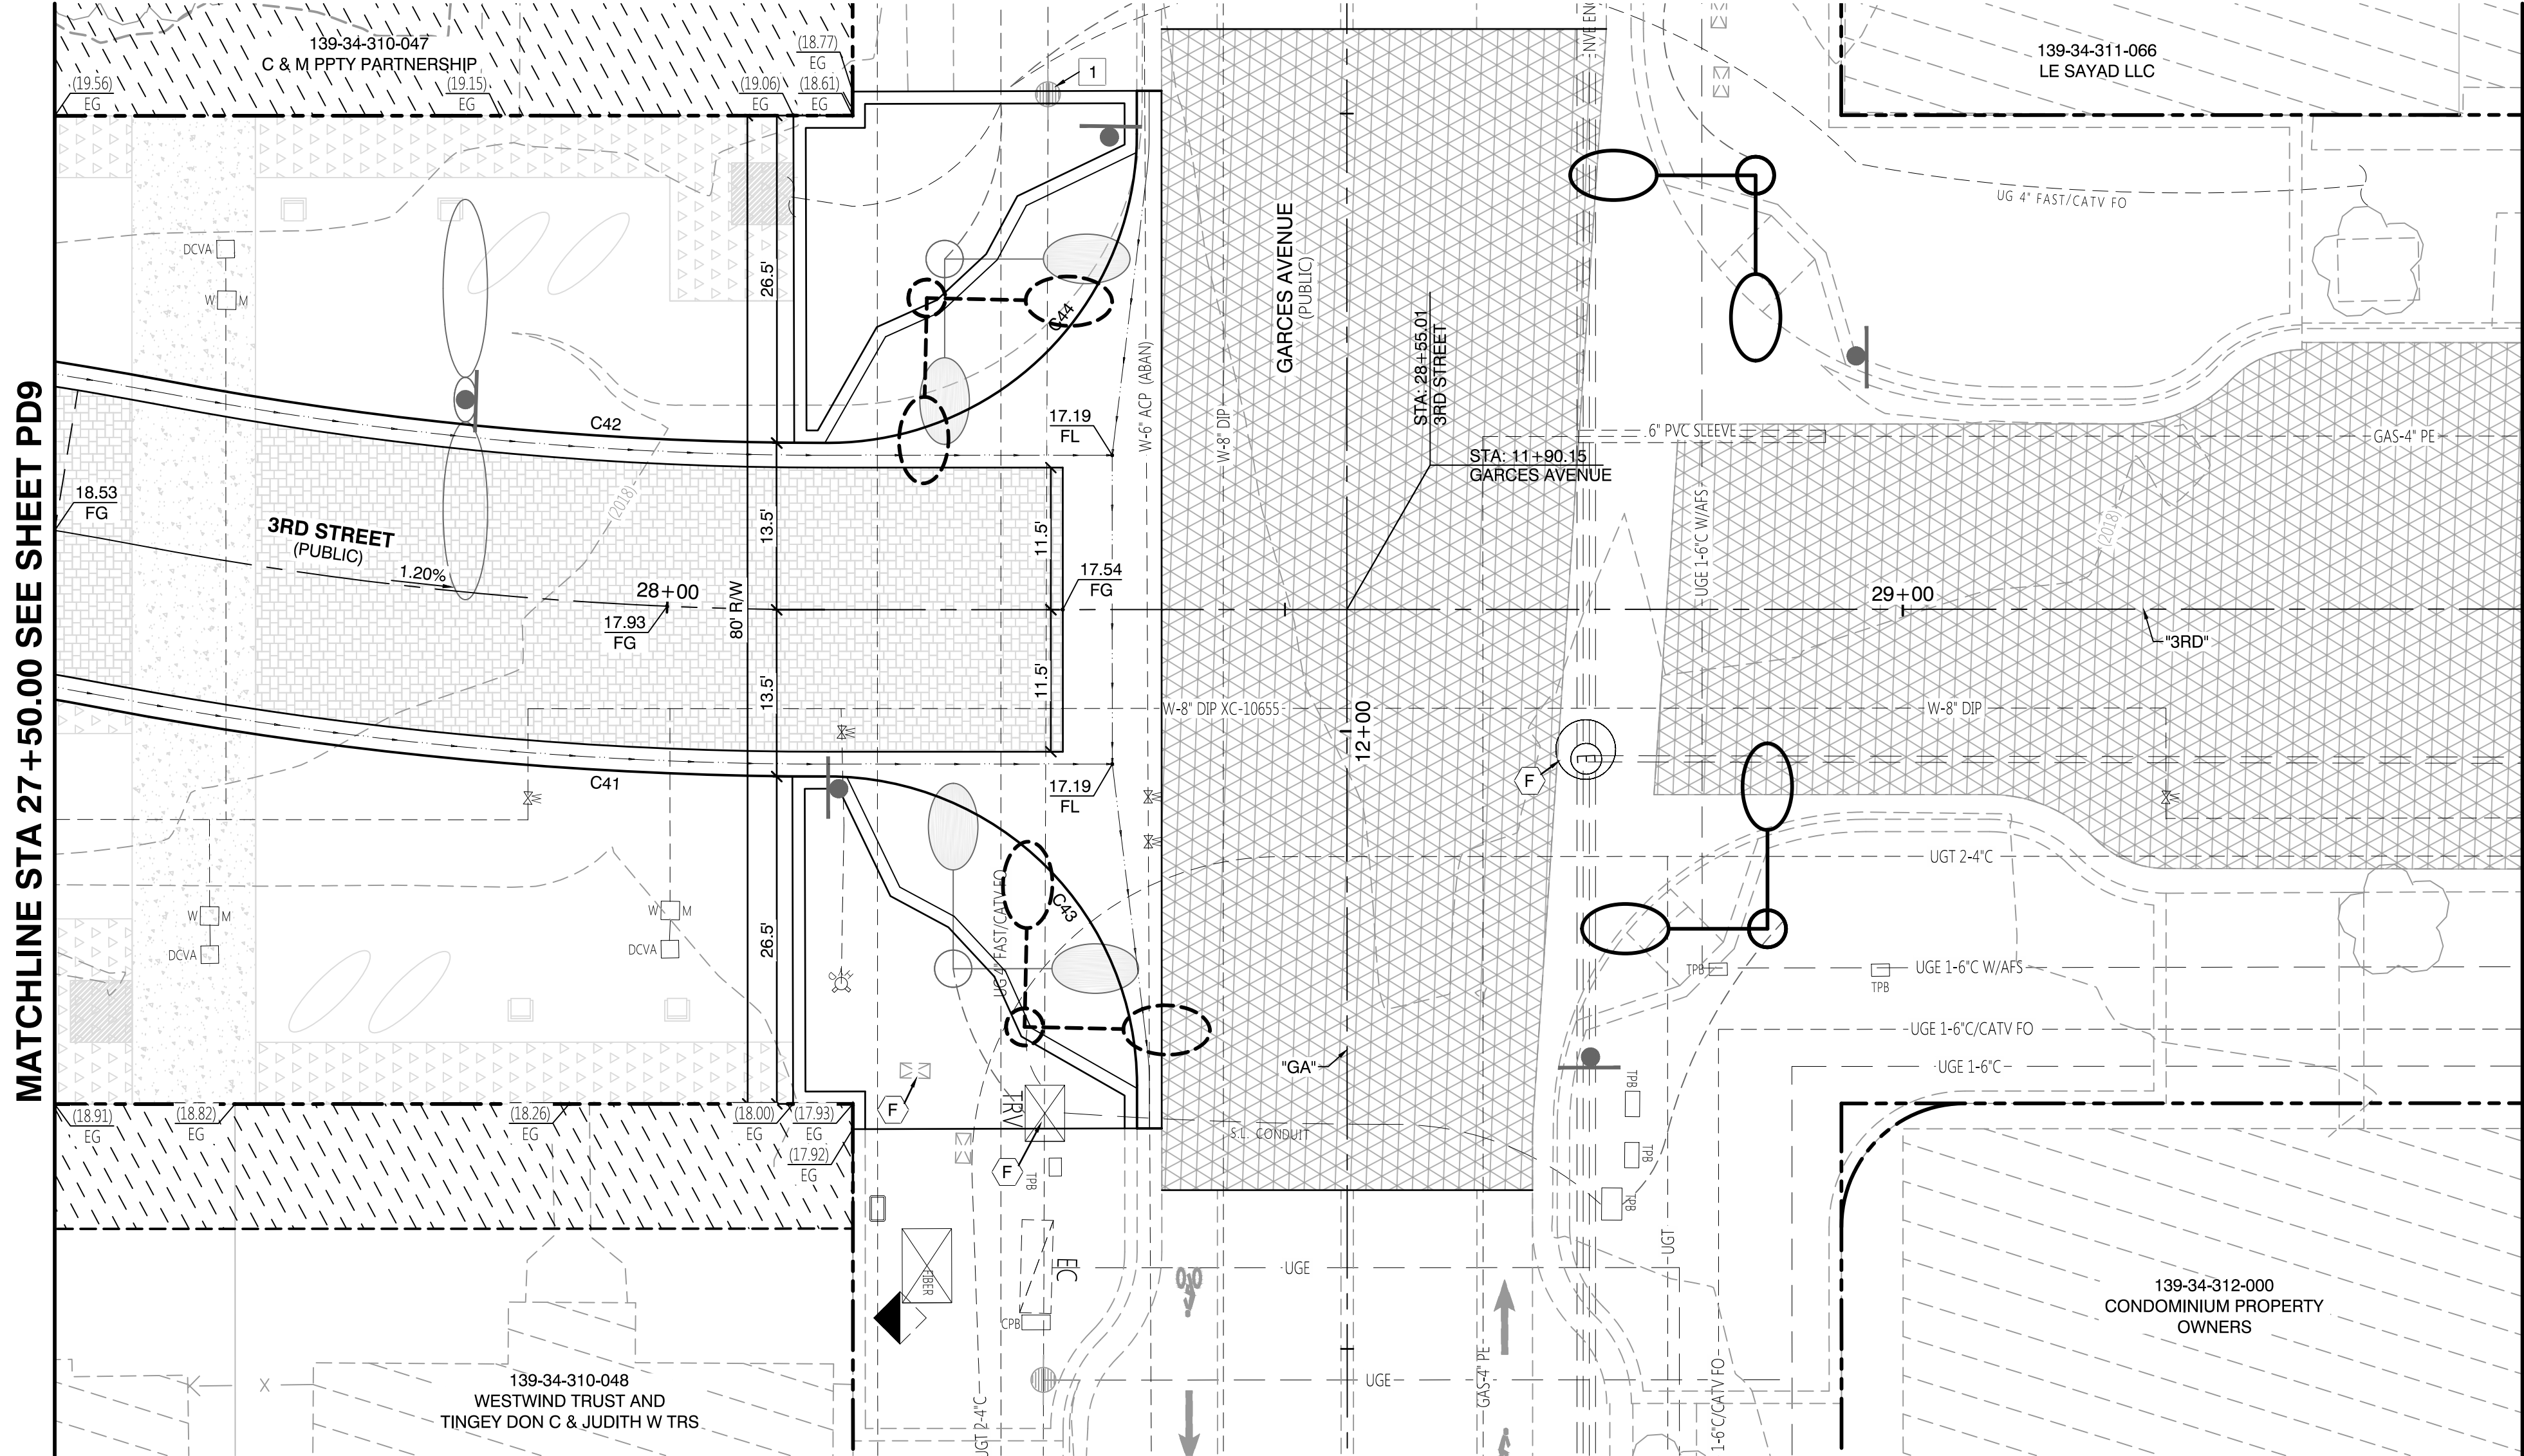

- LEGEND**
- PAVER LIMITS
 - PROPOSED AEP
 - PAVERS
 - SPECIALTY CONCRETE
 - PLANTING HATCH
 - EXISTING PARKING METER TO BE RELOCATED. CONTRACTOR TO COORDINATE WITH THE CITY.
 - EXISTING LIGHT POLE
 - EXISTING UTILITY POLE
 - EXISTING WATER VALVE
 - EXISTING WATER METER
 - EXISTING FIRE HYDRANT
 - EXISTING UTILITY BOX
 - EXISTING OVERHEAD ELECTRIC
 - EXISTING STREETLIGHT CONDUIT
 - EXISTING FENCE
 - EXISTING CURB
 - EXISTING SIDEWALK
 - RIGHT-OF-WAY LINE
 - EXISTING PROPERTY LINE
 - PROPOSED CURB
 - PROPOSED LIP
 - PROPOSED FLOWLINE

- CONSTRUCTION NOTES**
- A SAWCUT AND MATCH EXISTING PAVEMENT
 - B EXISTING POWER POLE, P.I.P.
 - C EXISTING STREETLIGHT, P.I.P.
 - D EXISTING SIGN, P.I.P.
 - E EXISTING UTILITY. ADJUST TO GRADE. SEE ROADWAY PLANS.
 - F EXISTING UTILITY, P.I.P.

CURVE TABLE				
CURVE	RADIUS	DELTA	LENGTH	TANGENT
C41	313.50'	10°44'01"	58.73'	29.45'
C42	286.50'	10°44'10"	53.69'	26.92'
C43	25.00'	90°00'35"	39.27'	25.00'
C44	25.00'	89°59'55"	39.27'	25.00'

BASIS OF BEARINGS AND COORDINATES

GRID NORTH AS DEFINED BY THE CENTRAL MERIDIAN OF THE NEVADA COORDINATE REFERENCE SYSTEM (NCRS), LAS VEGAS ZONE, NORTH AMERICAN DATUM OF 1983; SAID MERIDIAN BEING COINCIDENT WITH 114°58' WEST OF THE GREENWICH MERIDIAN.

LINEAR UNIT: US SURVEY FOOT (FTUS)

DATUM (REFERENCE FRAME): NAD 1983 (CORS 96) EPOCH 2002.0

SYSTEM: NEVADA COORDINATE REFERENCE SYSTEM (NCRS)

ZONE: LAS VEGAS

PROJECTION: TRANSVERSE MERCATOR
STANDARD PARALLEL (AND LATITUDE OF GRID ORIGIN): 36°15'00"N
LONGITUDE OF CENTRAL MERIDIAN: 114°58'00"W
NORTHING AT GRID ORIGIN: 200,000,000 M (656,166,667 FTUS)
EASTING AT CENTRAL MERIDIAN: 100,000,000 M (328,083,333 FTUS)
SCALE FACTOR ON CENTRAL MERIDIAN: 1.0001 (EXACT)

NOTES:
1. ALL DISTANCES AND BEARINGS SHOWN HEREON ARE PROJECTED (GRID) VALUES BASED ON THE PRECEDING PROJECTION DEFINITION. THE PROJECTION WAS DEFINED SUCH THAT PROJECTED (GRID) DISTANCES ARE EQUIVALENT TO 'GROUND' DISTANCES IN THE PROJECT AREA.
2. GRID BEARINGS SHOWN HEREON (OR IMPLIED BY GRID COORDINATES) DO NOT EQUAL GEODETIC BEARINGS DUE TO MERIDIAN CONVERGENCE.


30% Submittal
"NOT FOR CONSTRUCTION"
December 2016

PROJECT BENCHMARK

PROJECT DATUM: NORTH AMERICAN VERTICAL DATUM OF 1988 (NAVD88) (2008 ADJUSTMENT)

CITY OF LAS VEGAS BENCHMARK: 1LV01-34NW6
NAVD88 ELEVATION: 617.329 METERS (2025.353 FEET)

3" NDOT BRASS CAP IN TOP OF CURB AT SE CORNER OF MAIN AND BRIDGER.

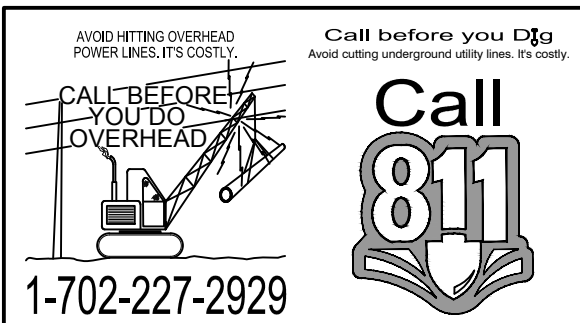

PREPARED BY
CITY OF LAS VEGAS
2727 SOUTH RAINBOW BOULEVARD
LAS VEGAS, NEVADA 89146-5148
PH: (702) 879-7550
FAX: (702) 879-7550
WWW.VTNV.COM

DESIGNED BY: MD
DRAWN BY: ND
CHECKED BY: LL

DATE: --
SUBMITTAL STAGE:
30% Submittal

DOWNTOWN PEDESTRIAN AND BICYCLE IMPROVEMENTS
3RD STREET-PHASE 2
CHARLESTON TO BONNEVILLE


PROPERTY DETAILS

SHEET
PD10
33 OF 61
DRAWING NO.



REVISIONS

NO.	DATE	REVISIONS
-----	------	-----------

MATCHLINE STA 29+50.00 SEE SHEET PD10

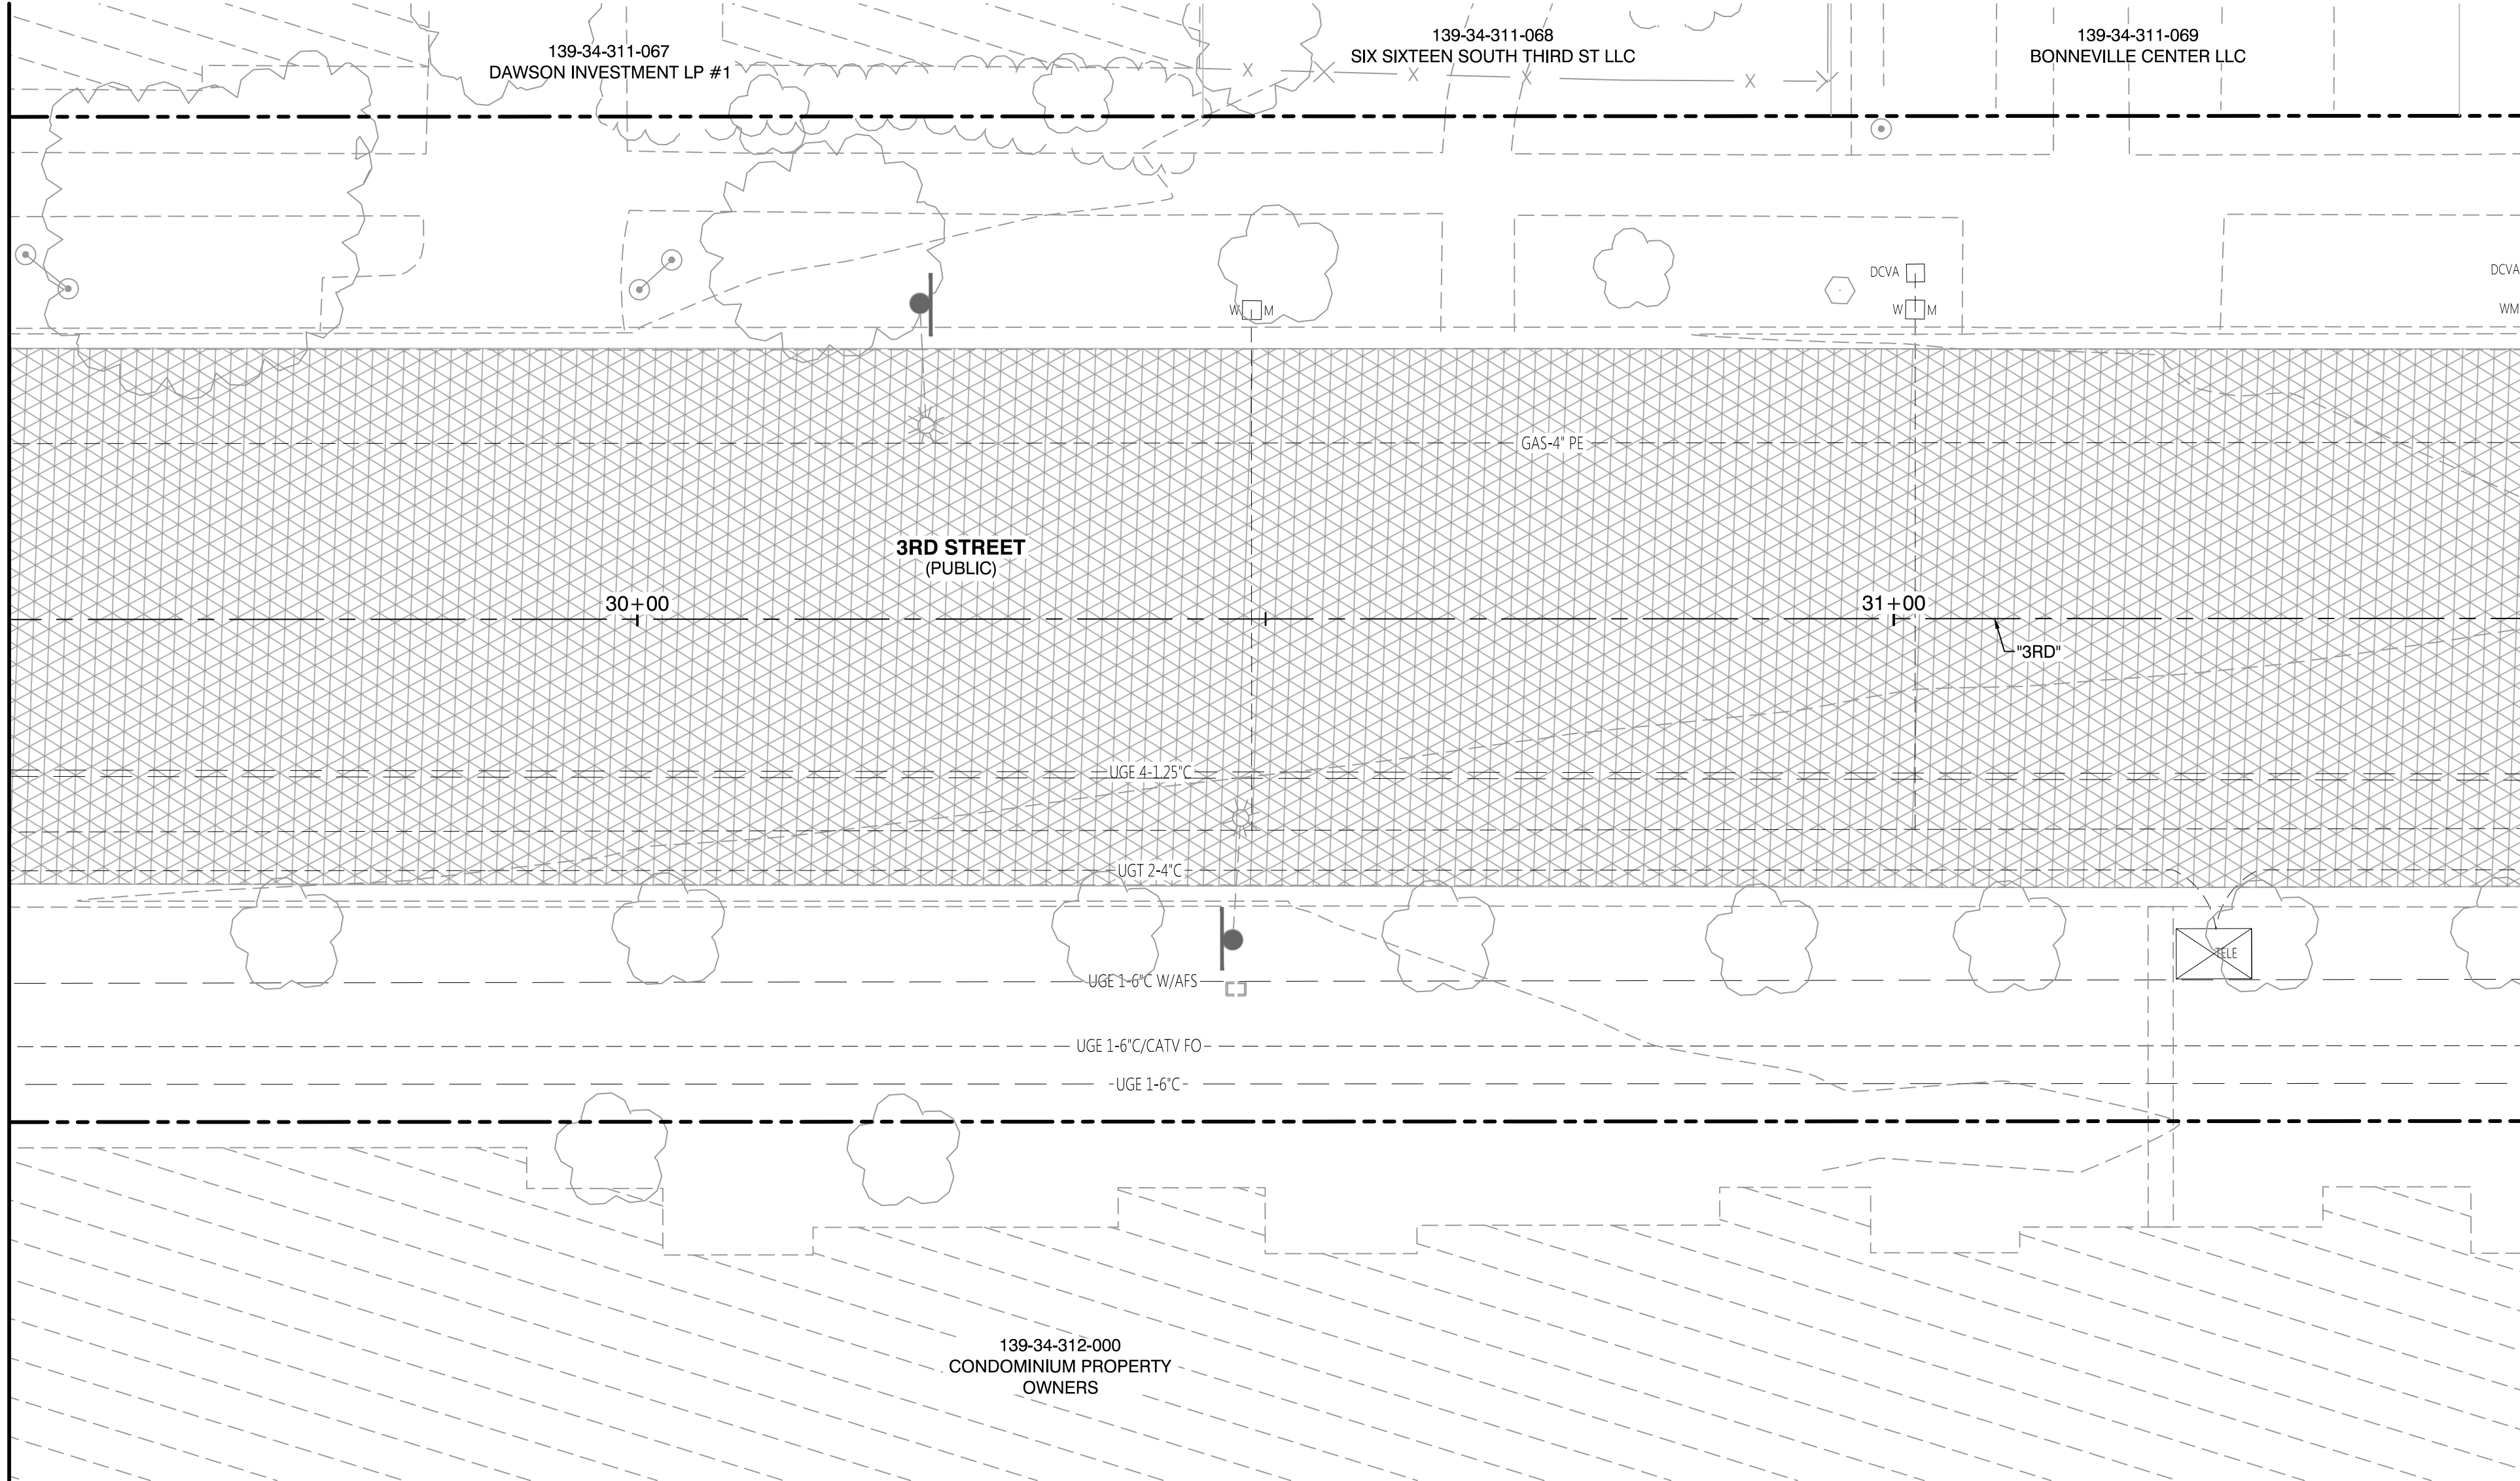


MATCHLINE STA 31+50.00 SEE SHEET PD12

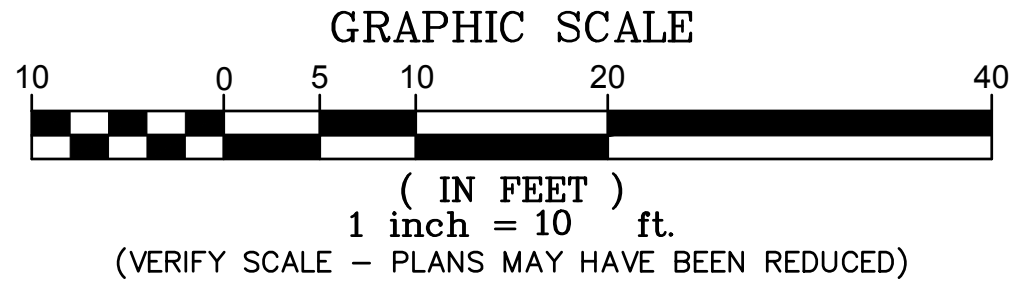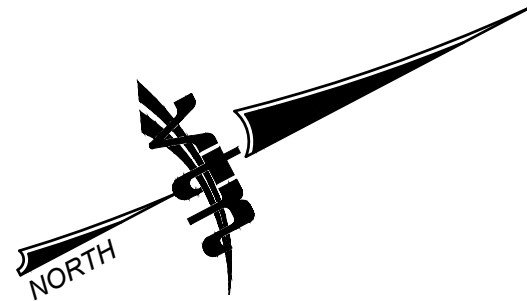

LEGEND		CONSTRUCTION NOTES	
	EXISTING PARKING METER TO BE RELOCATED. CONTRACTOR TO COORDINATE WITH THE CITY.	(A)	SAWCUT AND MATCH EXISTING PAVEMENT
	EXISTING LIGHT POLE	(B)	EXISTING POWER POLE, P.I.P.
	EXISTING UTILITY POLE	(C)	EXISTING STREETLIGHT, P.I.P.
	EXISTING WATER VALVE	(D)	EXISTING SIGN, P.I.P.
	EXISTING WATER METER	(E)	EXISTING UTILITY. ADJUST TO GRADE. SEE ROADWAY PLANS.
	EXISTING FIRE HYDRANT	(F)	EXISTING UTILITY, P.I.P.
	EXISTING UTILITY BOX		
	EXISTING OVERHEAD ELECTRIC		
	EXISTING STREETLIGHT CONDUIT		
	EXISTING FENCE		
	EXISTING CURB		
	EXISTING SIDEWALK		
	RIGHT-OF-WAY LINE		
	EXISTING PROPERTY LINE		
	PROPOSED CURB		
	PROPOSED LIP		
	PROPOSED FLOWLINE		




30% Submittal
"NOT FOR CONSTRUCTION"
December 2016

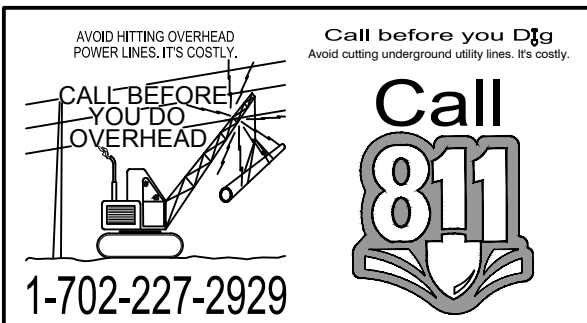

PROJECT BENCHMARK
PROJECT DATUM: NORTH AMERICAN VERTICAL DATUM OF 1988 (NAVD88) (2008 ADJUSTMENT)
CITY OF LAS VEGAS BENCHMARK: 1LV01-34NW6 NAVD88 ELEVATION: 617.329 METERS (2025.353 FEET)
3" NDOT BRASS CAP IN TOP OF CURB AT SE CORNER OF MAIN AND BRIDGER.


BASIS OF BEARINGS AND COORDINATES
GRID NORTH AS DEFINED BY THE CENTRAL MERIDIAN OF THE NEVADA COORDINATE REFERENCE SYSTEM (NCRS), LAS VEGAS ZONE, NORTH AMERICAN DATUM OF 1983; SAID MERIDIAN BEING COINCIDENT WITH 114°58' WEST OF THE GREENWICH MERIDIAN.
LINEAR UNIT: US SURVEY FOOT (FTUS)
DATUM (REFERENCE FRAME): NAD 1983 (CORS 96) EPOCH 2002.0
SYSTEM: NEVADA COORDINATE REFERENCE SYSTEM (NCRS)
ZONE: LAS VEGAS
PROJECTION: TRANSVERSE MERCATOR STANDARD PARALLEL (AND LATITUDE OF GRID ORIGIN): 36°15'00"N LONGITUDE OF CENTRAL MERIDIAN: 114°58'00"W NORTHING AT GRID ORIGIN: 200,000,000 M (656,166,667 FTUS) EASTING AT CENTRAL MERIDIAN: 100,000,000 M (328,083,333 FTUS) SCALE FACTOR ON CENTRAL MERIDIAN: 1.0001 (EXACT)
NOTES: 1. ALL DISTANCES AND BEARINGS SHOWN HEREON ARE PROJECTED (GRID) VALUES BASED ON THE PRECEDING PROJECTION DEFINITION. THE PROJECTION WAS DEFINED SUCH THAT PROJECTED (GRID) DISTANCES ARE EQUIVALENT TO "GROUND" DISTANCES IN THE PROJECT AREA. 2. GRID BEARINGS SHOWN HEREON (OR IMPLIED BY GRID COORDINATES) DO NOT EQUAL GEODETIC BEARINGS DUE TO MERIDIAN CONVERGENCE.

PREPARED BY CITY OF LAS VEGAS		DESIGNED BY: MD		CHECKED BY: LL			
H# 54616		DATE: --		SUBMITTAL STAGE: 30% Submittal			
DOWNTOWN PEDESTRIAN AND BICYCLE IMPROVEMENTS 3RD STREET-PHASE 2 CHARLESTON TO BONNEVILLE		PROPERTY DETAILS					
SHEET		NOT FOR CONSTRUCTION					
90% SUBMITTAL		NO. 10112					
SHEET		PD11					
34 OF 61		DRAWING NO.					
12/21/16		REVISIONS					

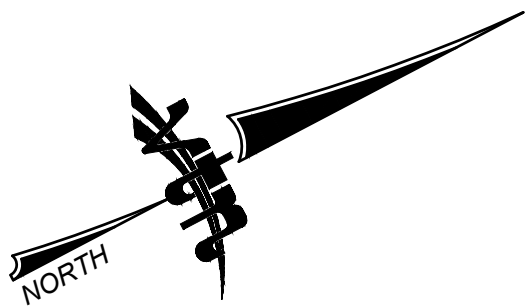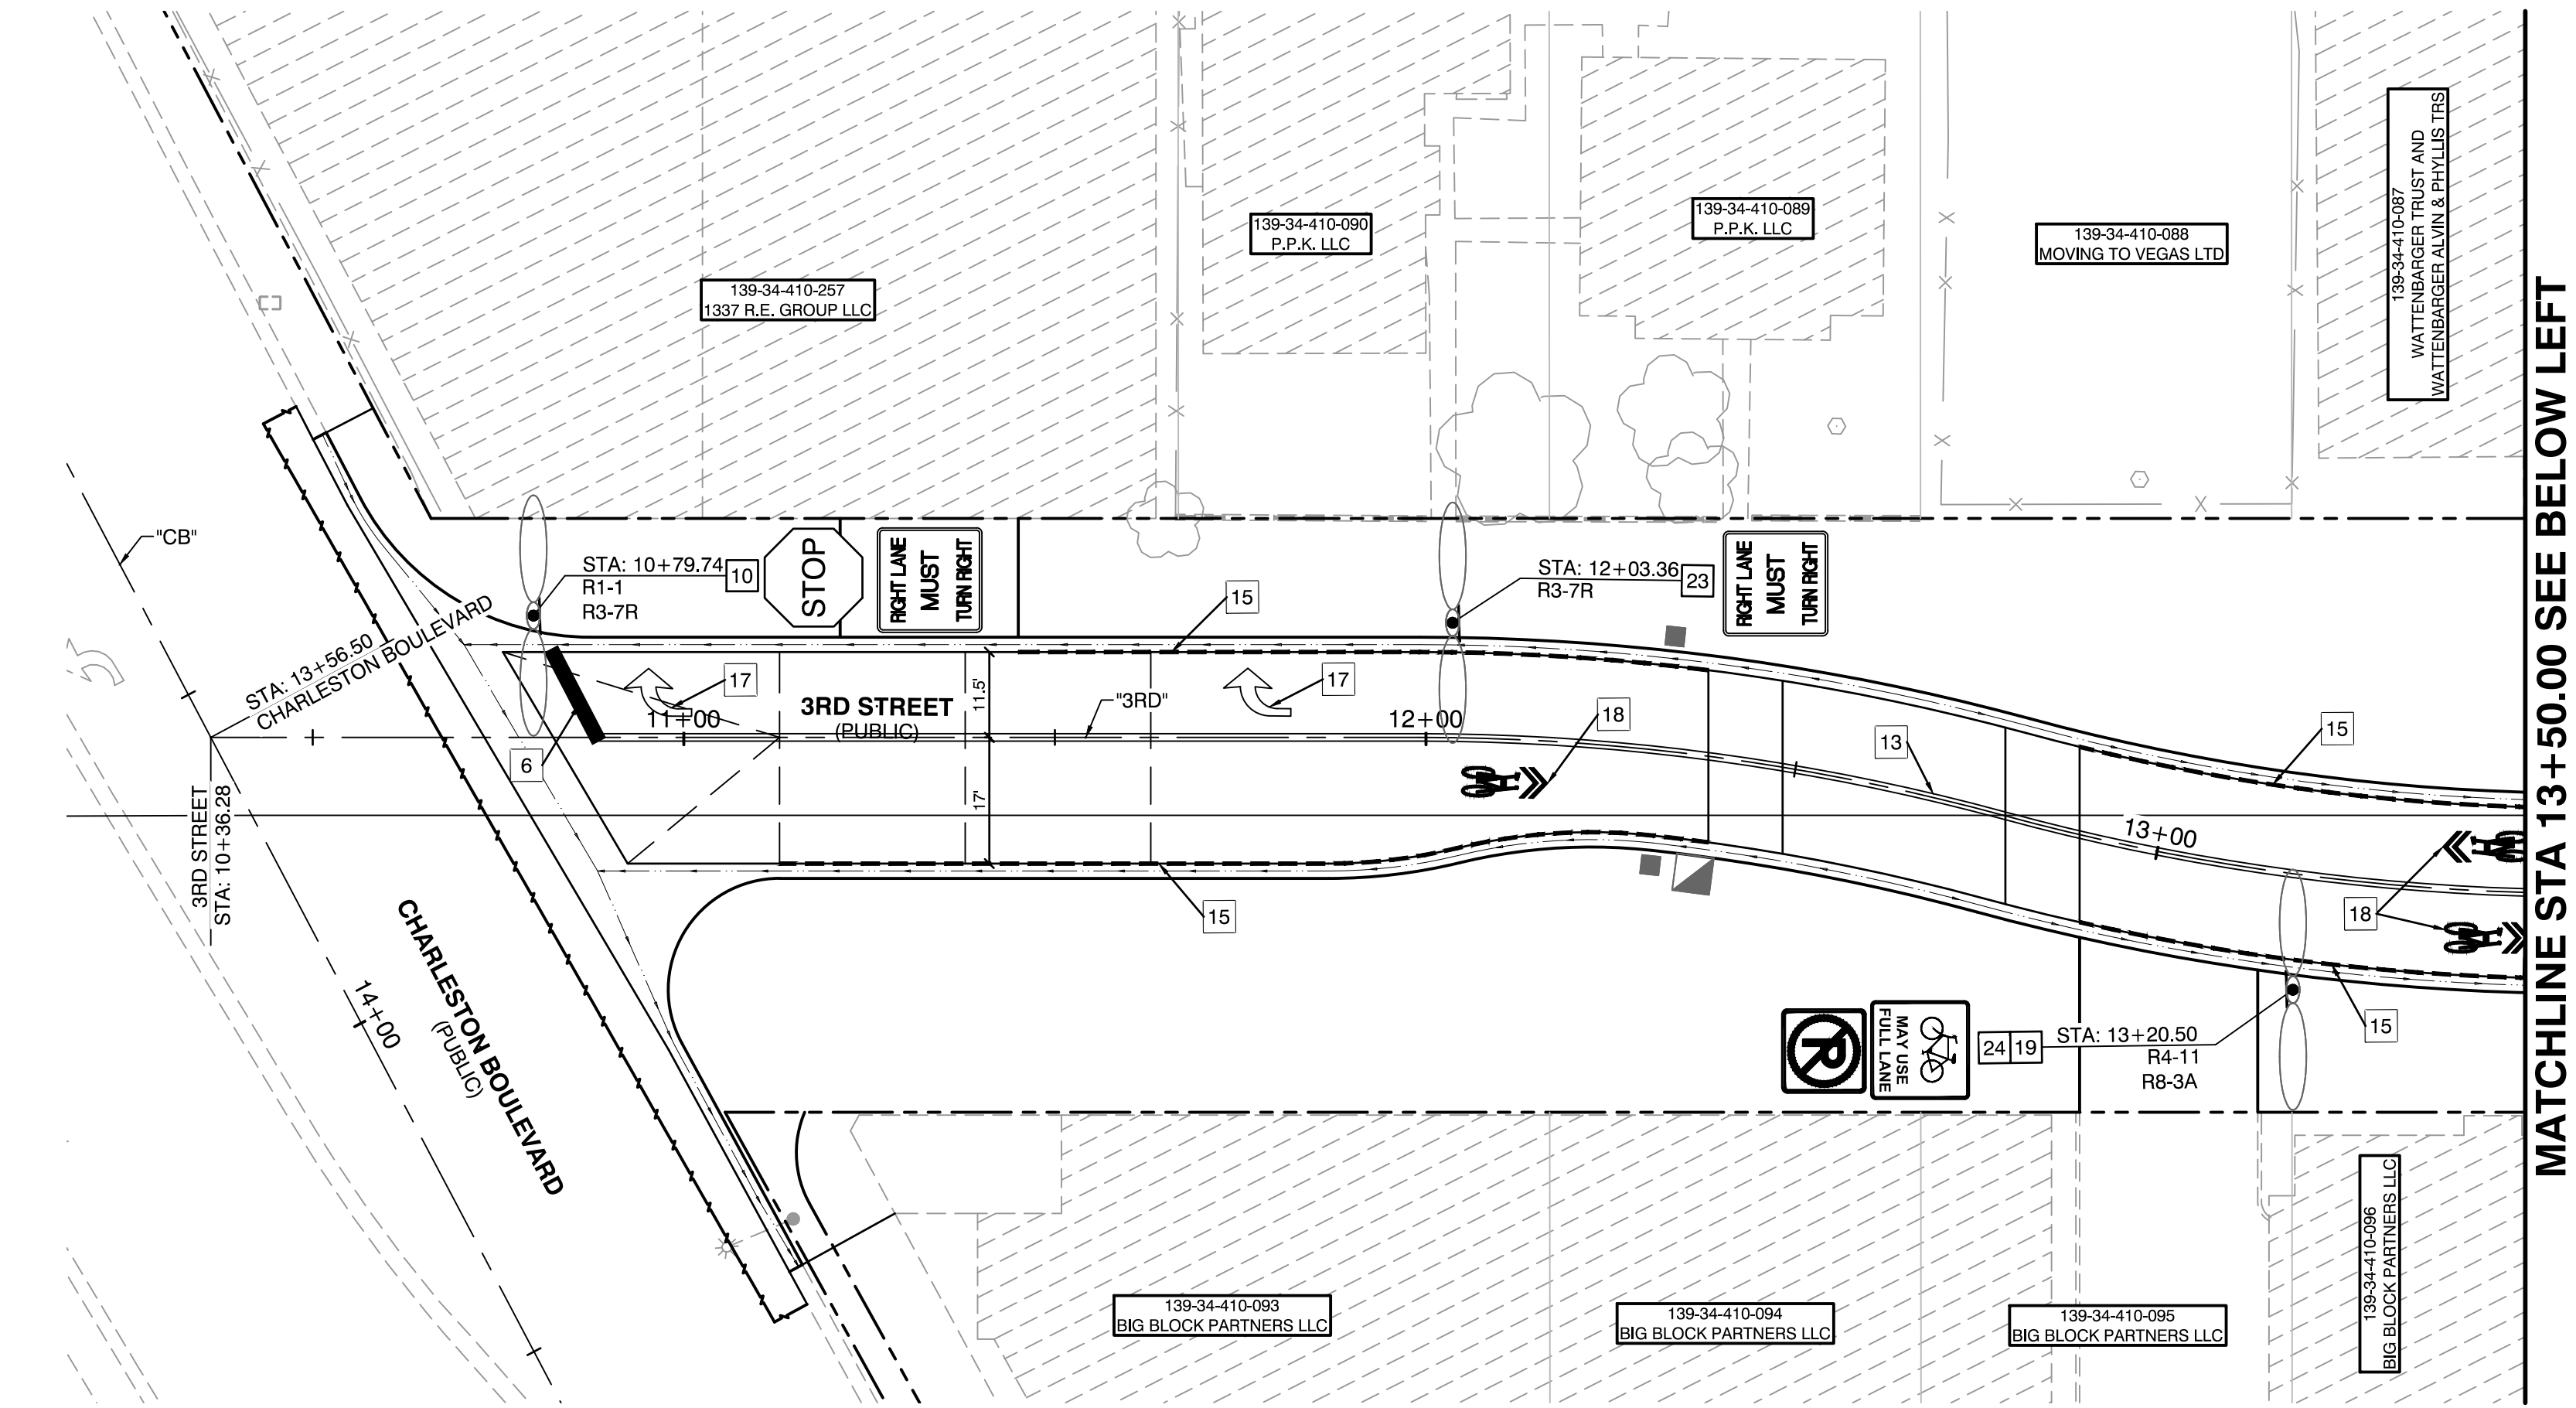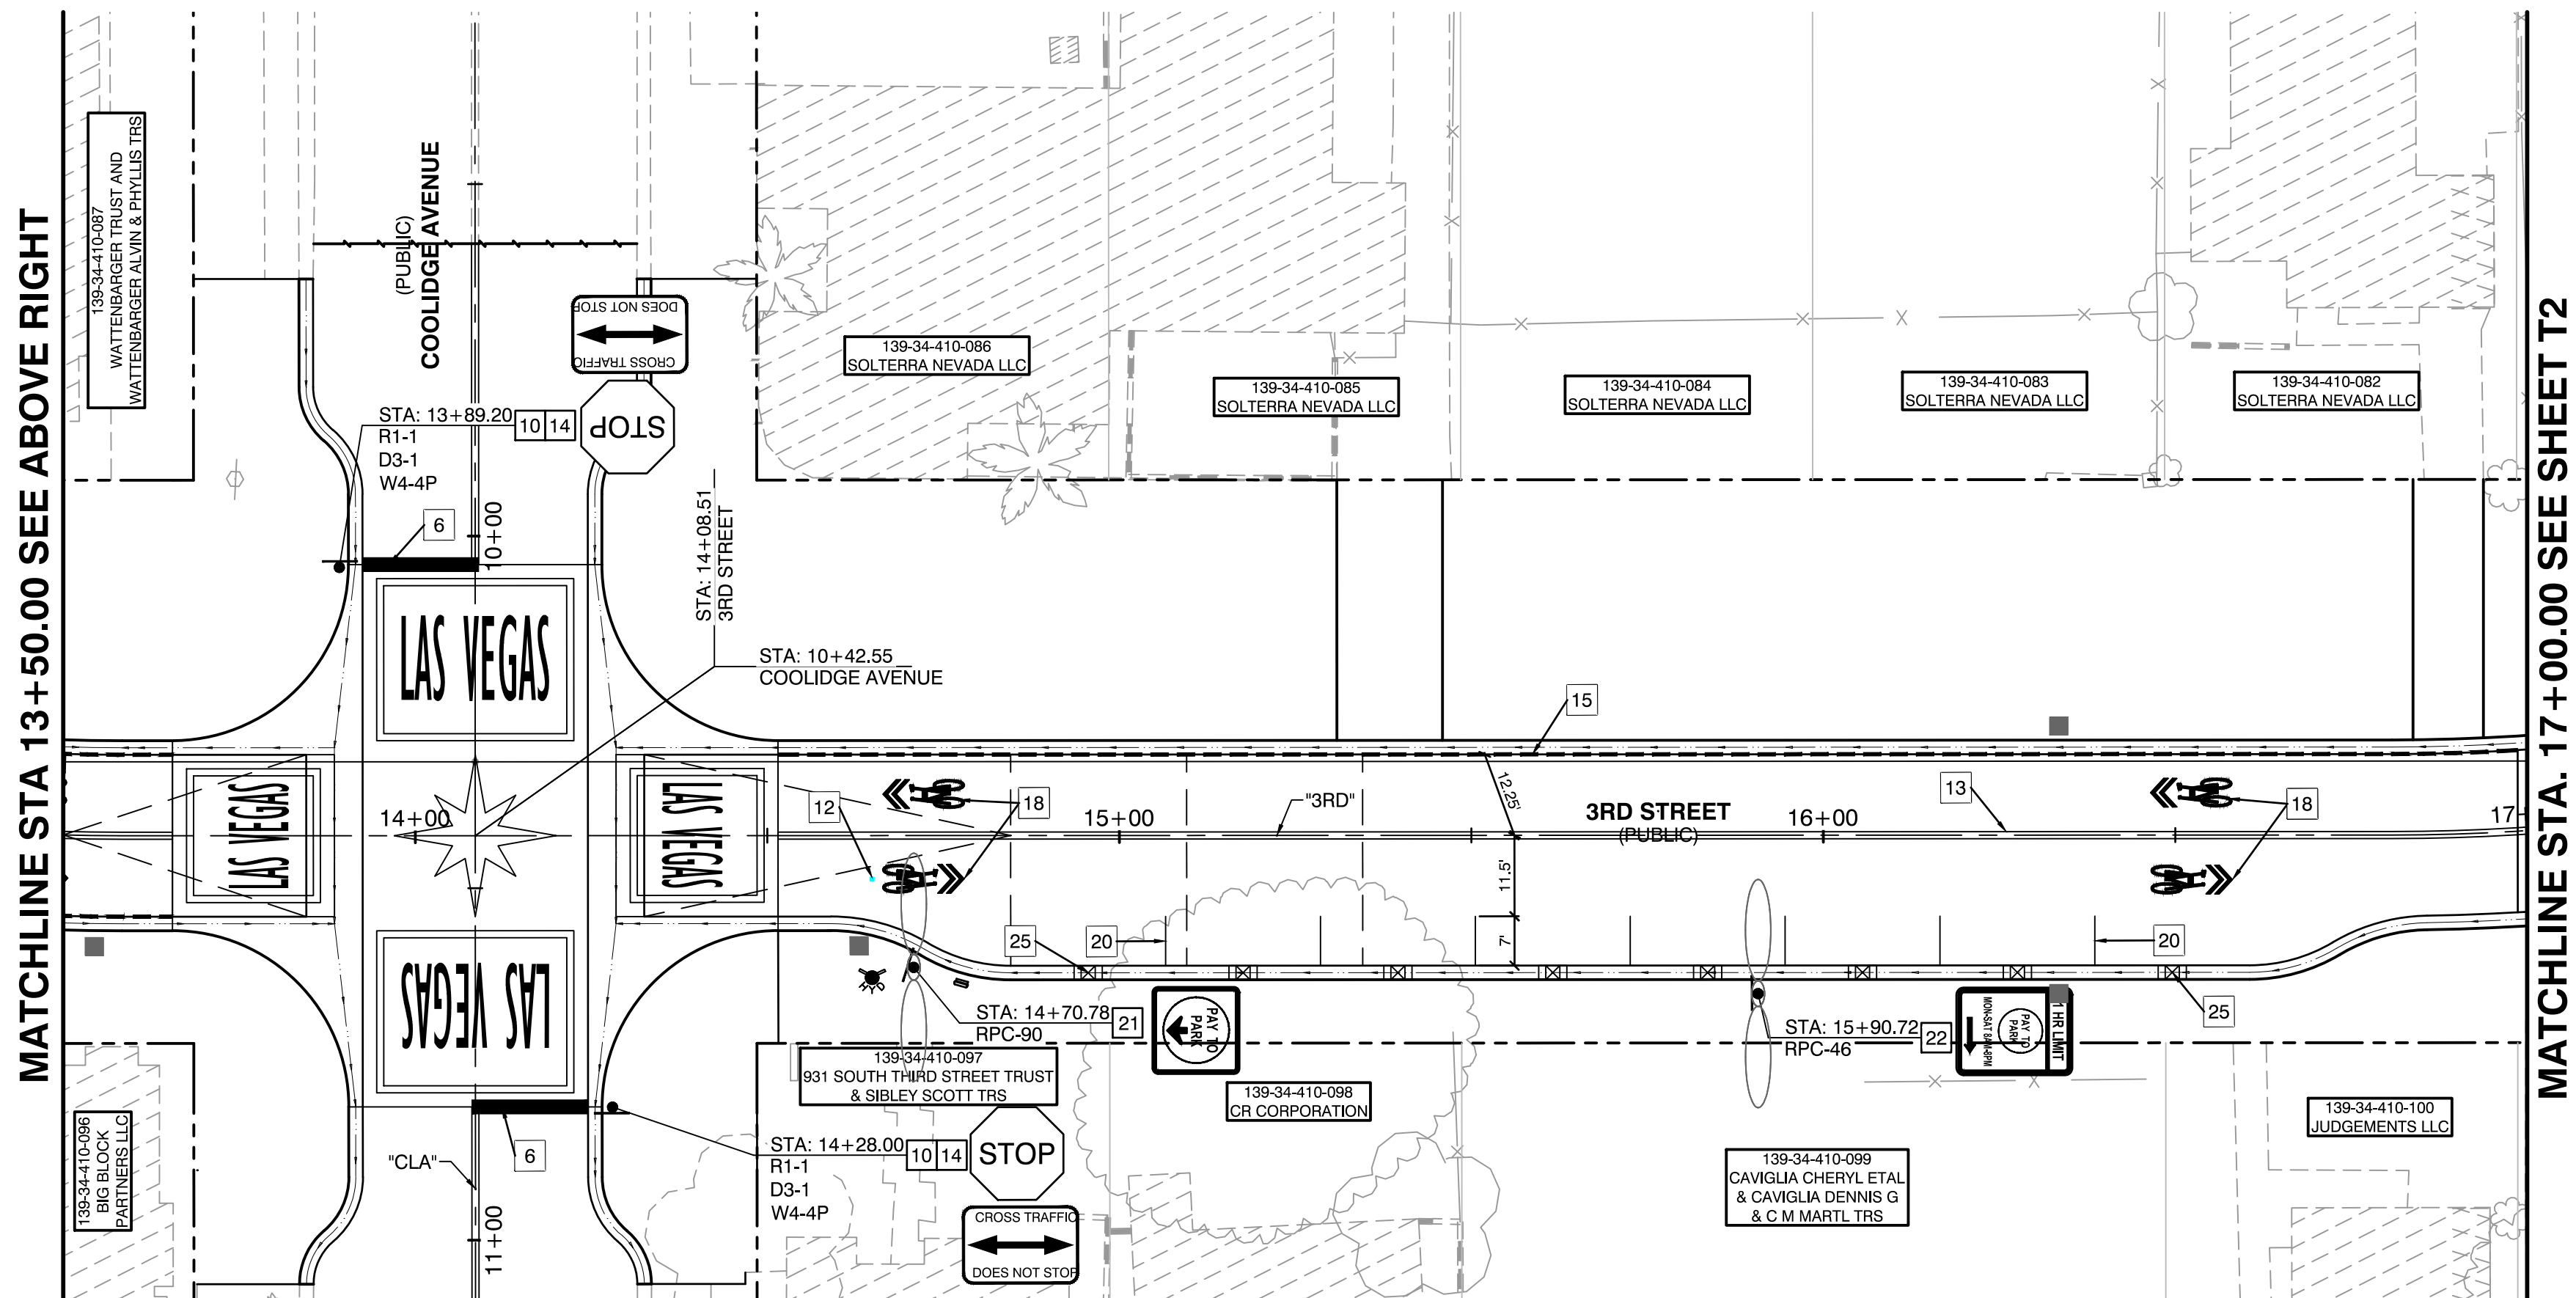


LEGEND	
	'NO PARKING' FIRE LANE. PAINT CURBS WITH INDUSTRIAL STRENGTH ENAMEL (SAFETY RED) WHERE INDICATED
	RIGHT-OF-WAY LINE
	110/160 WATT LED STREET LIGHTS
	160 WATT LED STREET LIGHT
	EXISTING LIGHT POLE
	EXISTING UTILITY POLE
	EXISTING FIRE HYDRANT
	PROPOSED SIGN
	5' X 5' TREE WELL (REFER TO HARDSCAPE PLANS)
	TRASH ENCLOSURE
	BENCH (REFER TO HARDSCAPE PLANS)
	PLANTER (REFER TO HARDSCAPE PLANS)




SIGNAGE LEGEND	
	R1-1 30" X 30"
	R8-3A 18" X 18"
	R4-11 30" X 30"
	RPC-90 24" X 24"
	W4-4P 24" X 12"
	R3-7R 30" X 30"
	RPC-46 18" X 24"

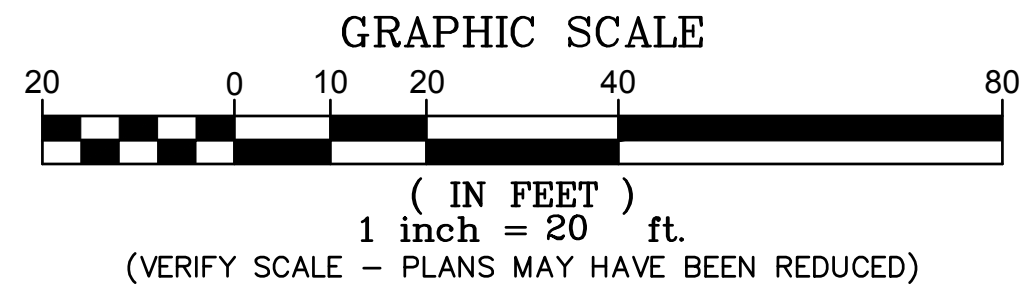

TRAFFIC STRIPING & SIGNAGE LEGEND	
6	INSTALL 24" SOLID WHITE STOP BAR PER CCAUSD NO. 254 (FILM)
10	INSTALL "STREET NAME" SIGN (D3-1) & "STOP SIGN" (R1-1) PER CCAUSD NO. 249.1 OR MOUNT ON STREETLIGHT POLE, SEE PLANS.
12	INSTALL BLUE REFLECTIVE MARKER 8" FROM BACK OF CURB PER CLARK COUNTY FIRE DEPARTMENT STANDARDS
13	INSTALL TYPE I CENTERLINE PER USD NO. 244 (POLYUREA).
14	INSTALL "CROSS TRAFFIC DOES NOT STOP" SIGN (W4-4P) PER CCAUSD NO. 249.1 OR MOUNT ON STREETLIGHT POLE. SEE PLANS.
15	INSTALL "NO PARKING" FIRE LANE BY PAINTING CURBS WITH INDUSTRIAL STRENGTH ENAMEL (SAFETY RED).
17	INSTALL "ARROWS" AND/OR "ONLY" USING WHITE TYPE 1 PAVEMENT MARKING FILM PER USD NO. 246.
18	INSTALL SHARED BIKE LANE LEGEND. SEE MUTCD FIG. 9C-9 (FILM).
19	INSTALL R8-3A "NO PARKING" SIGN PER CCAUSD NO. 249.1 OR MOUNT ON STREETLIGHT POLE. SEE PLANS.
20	INSTALL 8'X20' PARKING STALLS USING 4" SOLID WHITE PARKING LINE (POLYUREA). CONTRACTOR TO COORDINATE WITH CLV FOR LOCATIONS OF THE PARKING SPACES.
21	INSTALL "PAY TO PARK" SIGN (RPC-90) PER CCAUSD NO. 249.1. SEE PLANS.
22	INSTALL "1 HR LIMIT PAY TO PARK" SIGN (RPC-46) PER CCAUSD NO. 249.1. SEE PLANS.
23	INSTALL R3-7R "RIGHT LANE MUST TURN RIGHT" SIGN PER CCAUSD NO. 249.1 OR MOUNT ON STREETLIGHT POLE. SEE PLANS.
24	INSTALL R4-11 "MAY USE FULL LANE" SIGN PER CCAUSD NO. 249.1 OR MOUNT ON STREETLIGHT POLE. SEE PLANS.
25	PARKING NUMBER AND MARKER TO BE INSTALLED BY CITY OF LAS VEGAS PARKING ENFORCEMENT.
26	INSTALL STAMPED CONCRETE CROSSWALK.

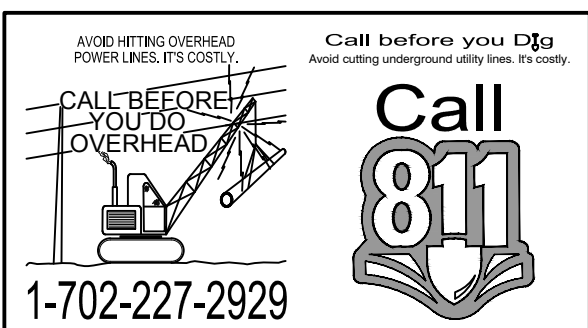

PREPARED FOR CITY OF LAS VEGAS		2727 SOUTH RAINBOW BOULEVARD LAS VEGAS, NEVADA 89146-5148 PH: (702) 875-7550 FAX: (702) 875-7550 WWW.VTNV.COM			
DESIGNED BY: MD		DEPARTMENT OF PUBLIC WORKS 333 N. RANCHO DRIVE LAS VEGAS, NV 89101 702-229-8272			
DATE: --		NO. DATE			
SUBMITTAL STAGE:		REVISIONS			
30% Submittal					
DOWNTOWN PEDESTRIAN AND BICYCLE IMPROVEMENTS 3RD STREET-PHASE 2 CHARLESTON TO BONNEVILLE					
SHEET					
SIGNAGE & STRIPING PLANS					
T1 36 OF 61 DRAWING NO.					

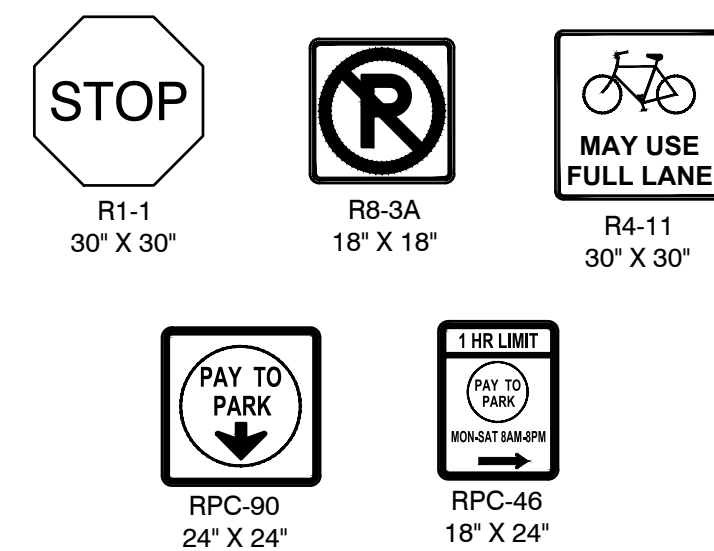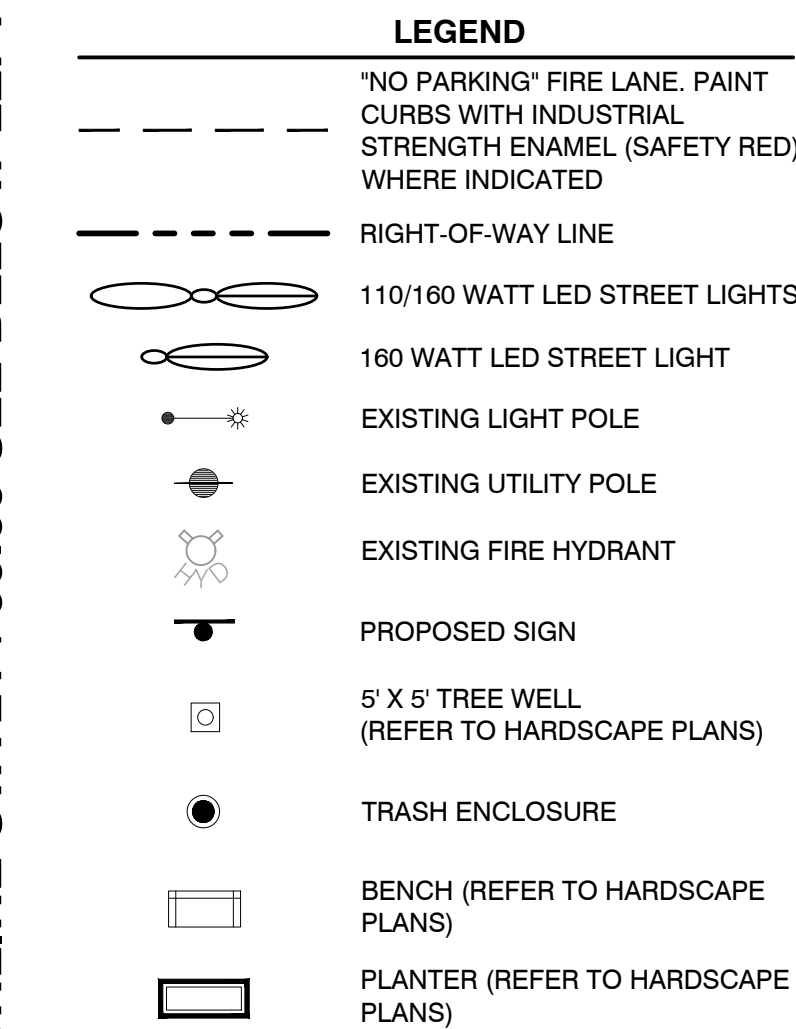 

30% Submittal
"NOT FOR CONSTRUCTION"
December 2016



PROFESSIONAL ENGINEER-STATE OF NEVADA
 ROBERT C. HOSFA III
 Exp. 06/30/17
 CIVIL
 No. 10112

SHEET

T2

37 OF 61

DRAWING NO.

**DOWNTOWN PEDESTRIAN AND BICYCLE IMPROVEMENTS
3RD STREET-PHASE 2
CHARLESTON TO BONNEVILLE**

SIGNAGE & STRIPING PLANS

PREPARED FOR
CITY OF LAS VEGAS

30% Submittal	BID #	----
	DESIGNED BY:	MD
	DRAWN BY:	ND
	CHECKED BY:	LL




PREPARED BY

2727 SOUTH RAINBOW BOULEVARD
LAS VEGAS, NEVADA 89146-5148
PH. (702) 873-7550

WWW.VTNNV.COM


DEPARTMENT OF PUBLIC WORKS
333 N. RANCHO DRIVE
LAS VEGAS, NV 89106
702-229-6272

The seal of the City of Las Vegas, featuring a circular design with "CITY OF LAS VEGAS" and "NEVADA" around the perimeter, and a central emblem depicting a landscape with a mountain, a river, and a sun.[illegible]

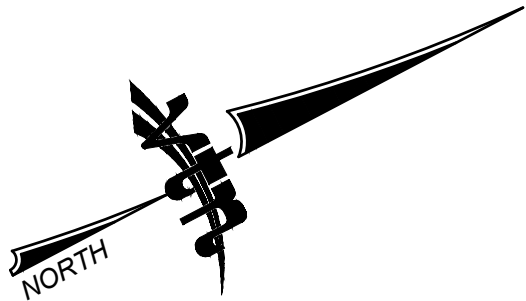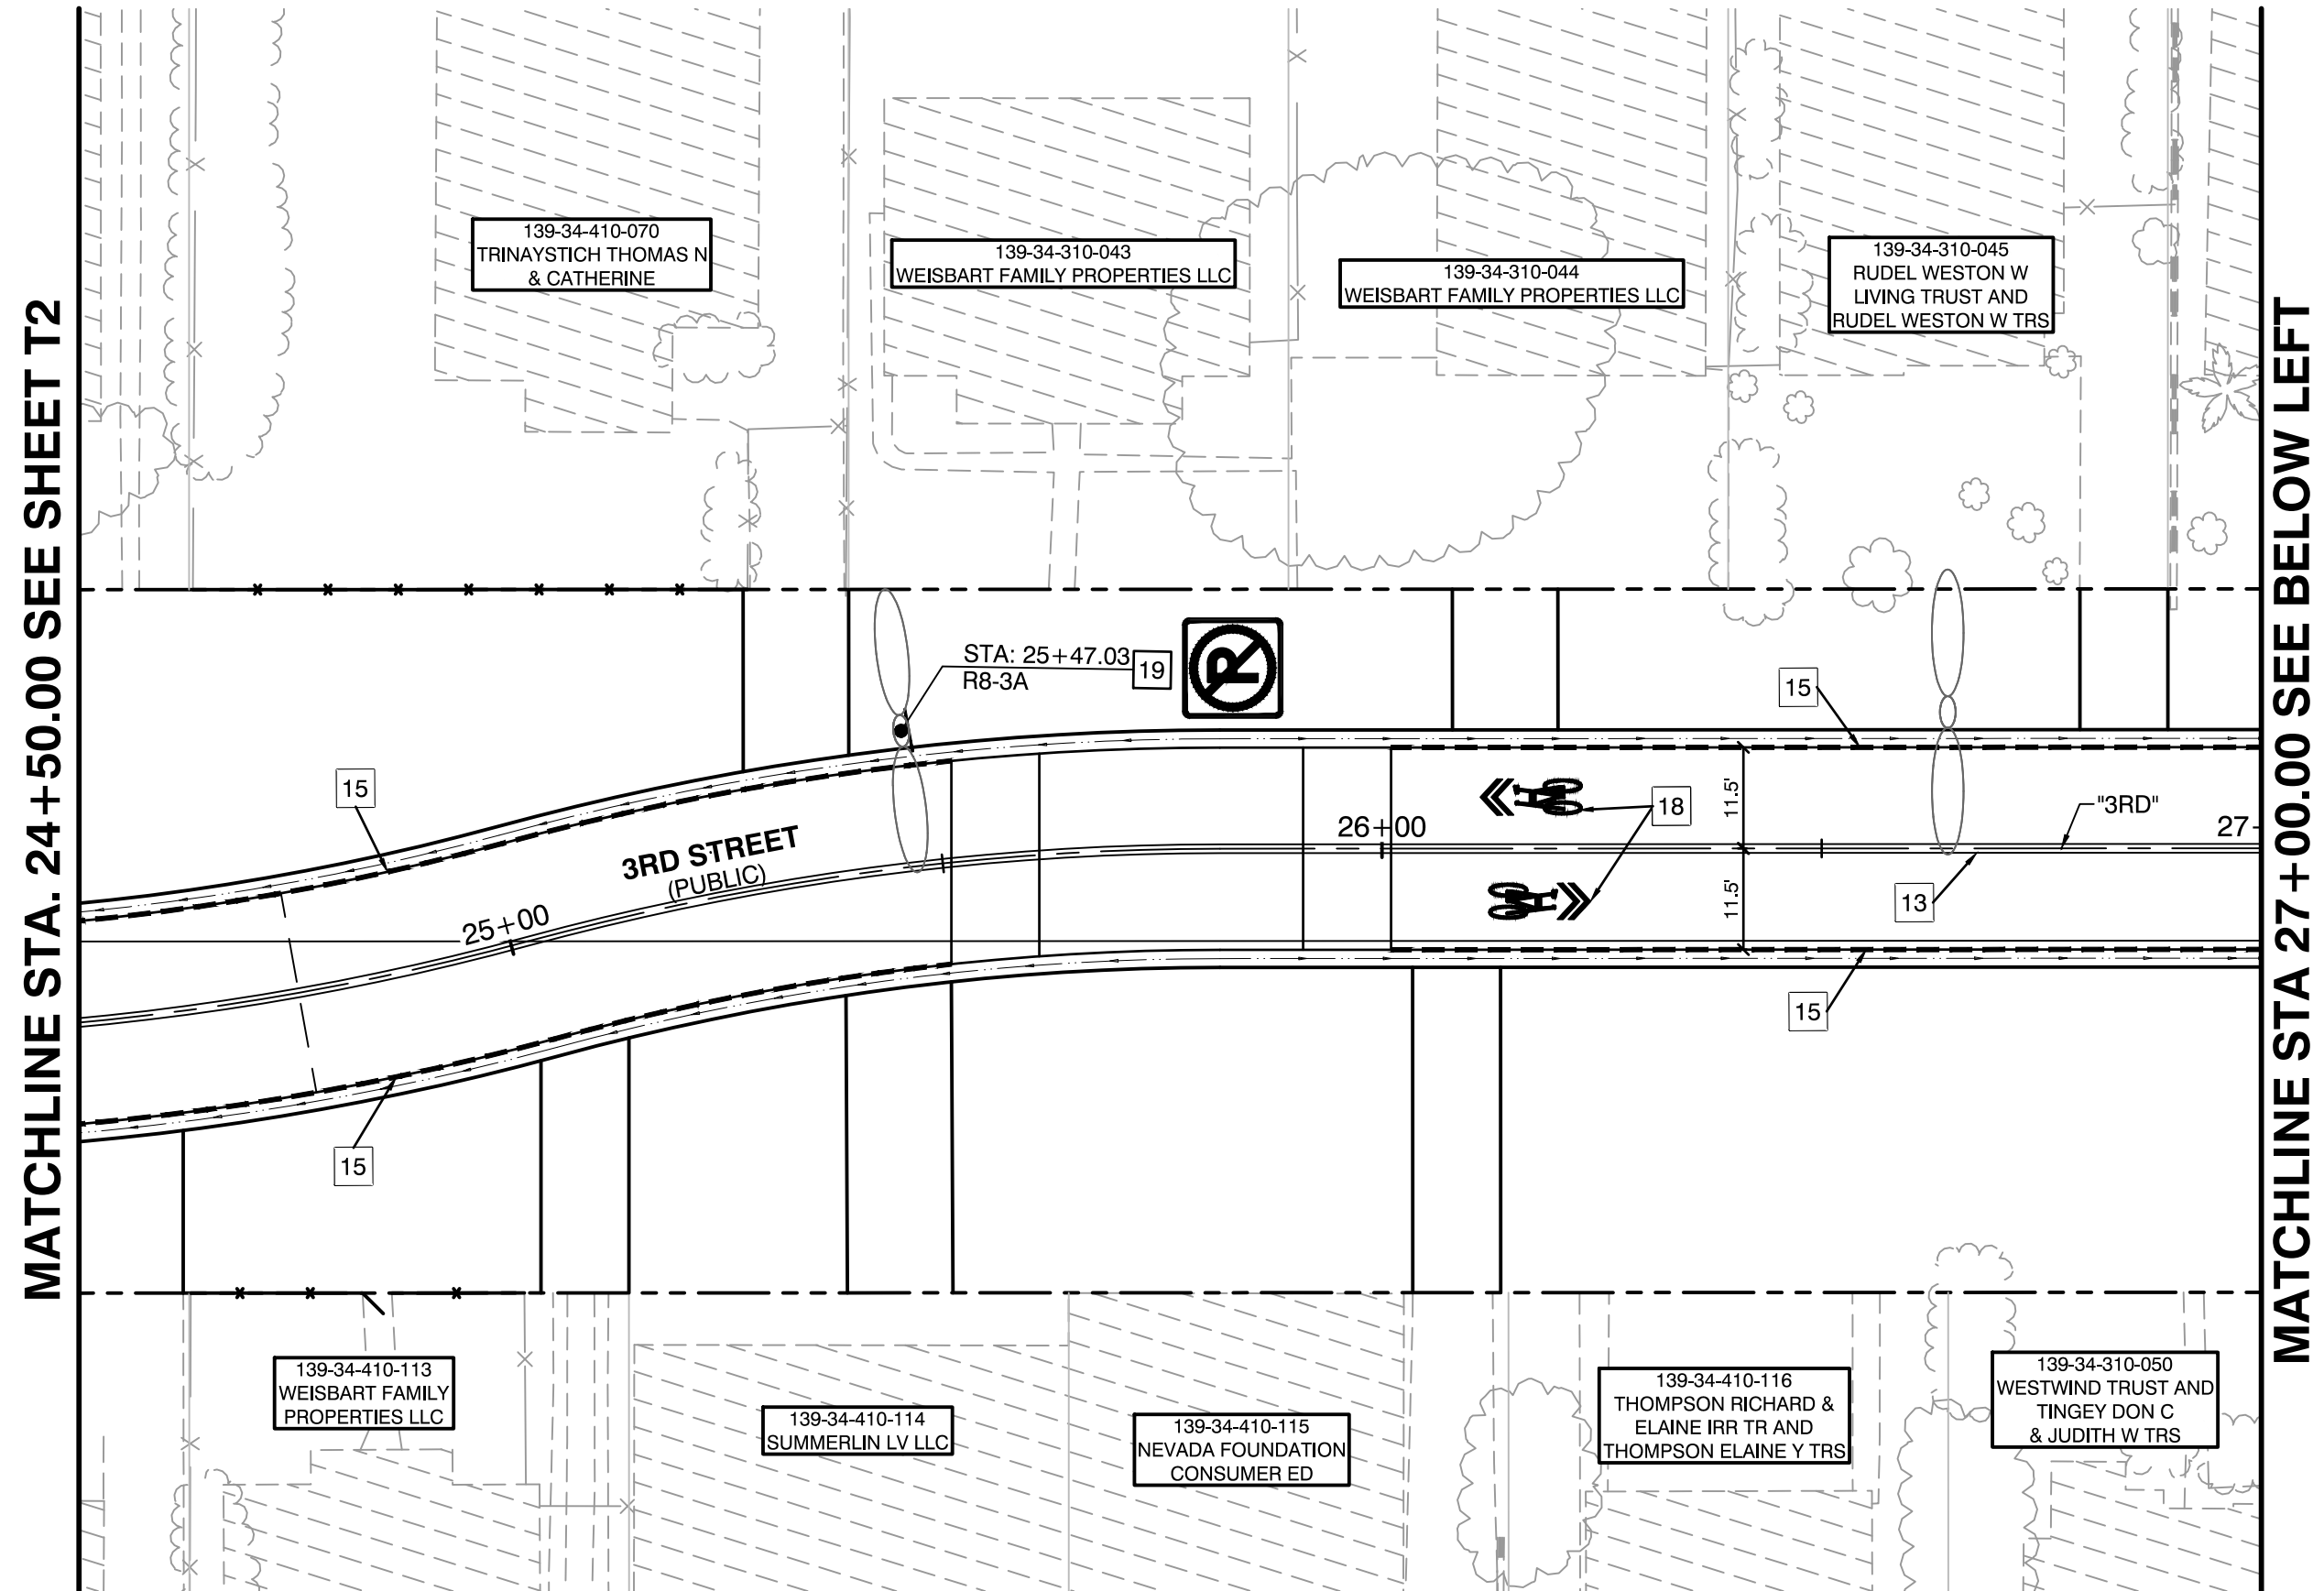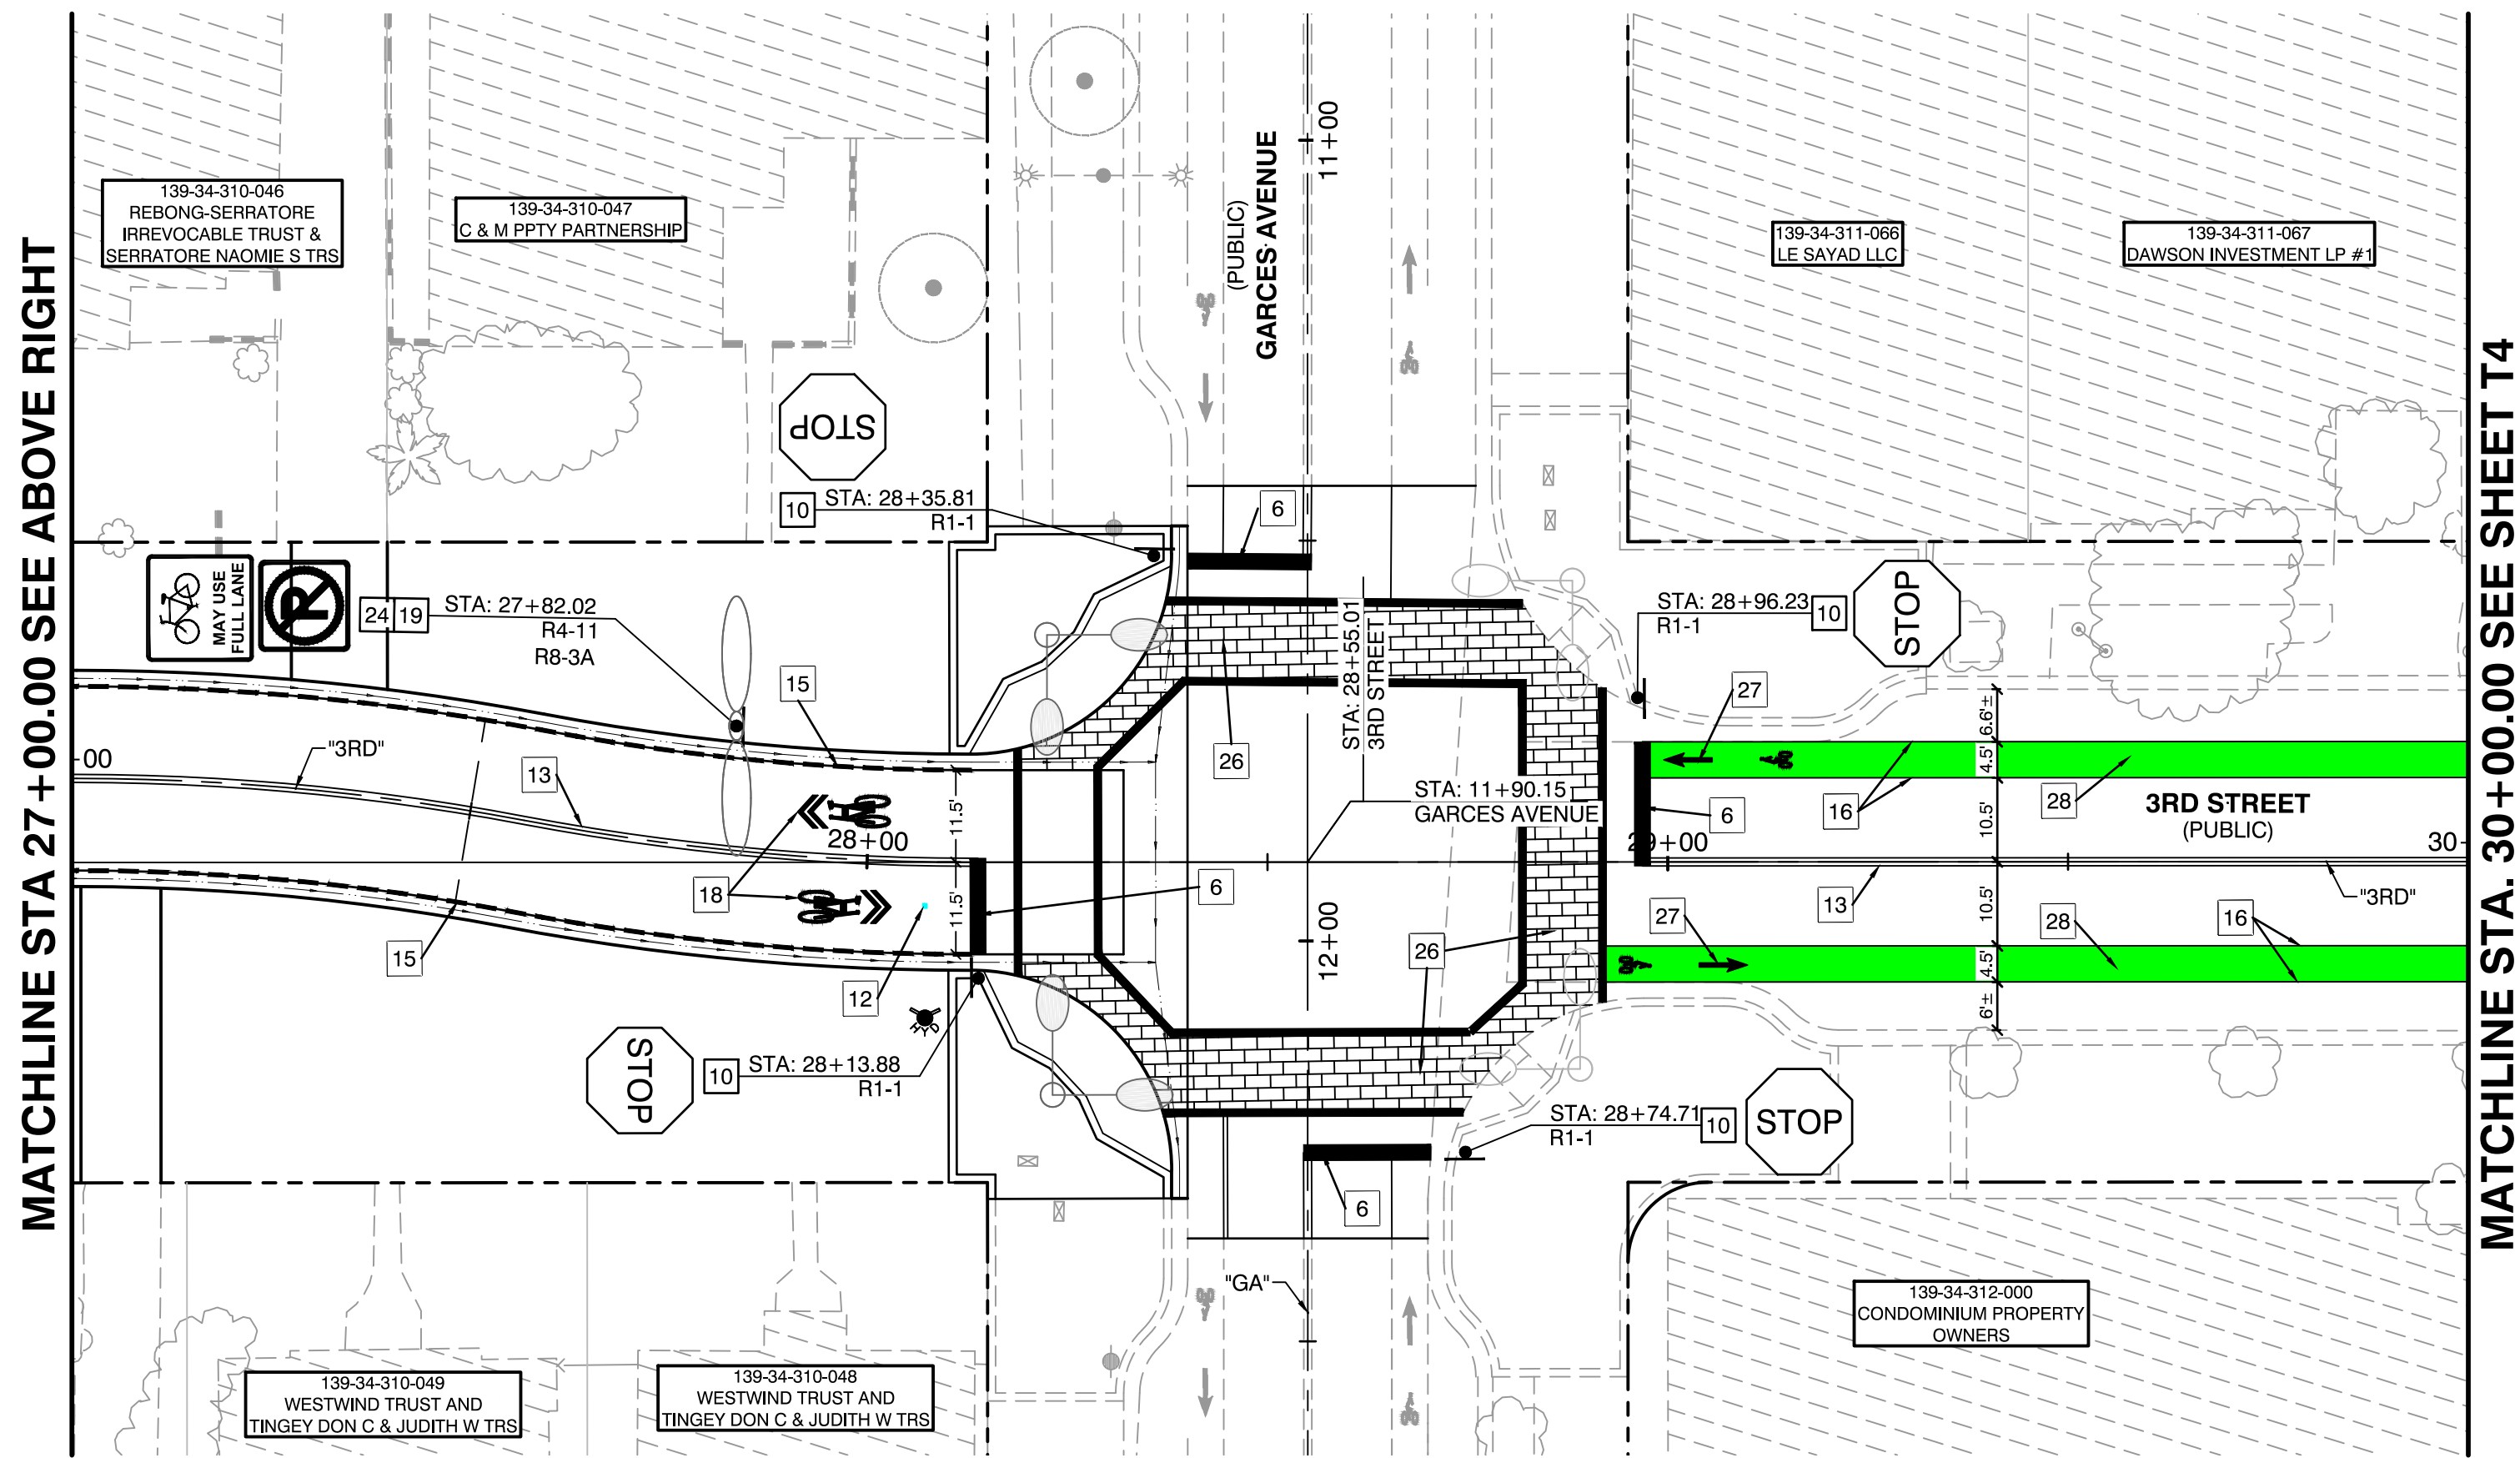

LEGEND	
	'NO PARKING' FIRE LANE. PAINT CURBS WITH INDUSTRIAL STRENGTH ENAMEL (SAFETY RED) WHERE INDICATED
	RIGHT-OF-WAY LINE
	110/160 WATT LED STREET LIGHTS
	160 WATT LED STREET LIGHT
	EXISTING LIGHT POLE
	EXISTING UTILITY POLE
	EXISTING FIRE HYDRANT
	PROPOSED SIGN
	5' X 5' TREE WELL (REFER TO HARDSCAPE PLANS)
	TRASH ENCLOSURE
	BENCH (REFER TO HARDSCAPE PLANS)
	PLANTER (REFER TO HARDSCAPE PLANS)


SIGNAGE LEGEND	
	R1-1 30" X 30"
	R8-3A 18" X 18"
	R4-11 30" X 30"

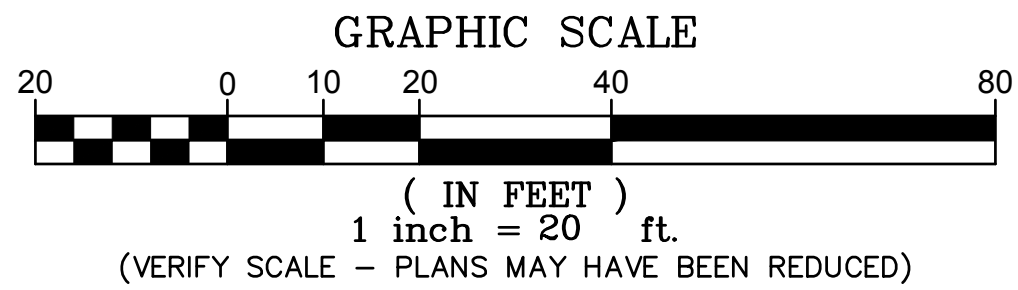

TRAFFIC STRIPING & SIGNAGE LEGEND	
6	INSTALL 24" SOLID WHITE STOP BAR PER CCAUSD NO. 254 (FILM)
10	INSTALL "STREET NAME" SIGN (D3-1) & "STOP SIGN" (R1-1) PER CCAUSD NO. 249.1 OR MOUNT ON STREETLIGHT POLE, SEE PLANS.
12	INSTALL BLUE REFLECTIVE MARKER 8" FROM BACK OF CURB PER CLARK COUNTY FIRE DEPARTMENT STANDARDS
13	INSTALL TYPE I CENTERLINE PER USD NO. 244 (POLYUREA).
15	INSTALL "NO PARKING" FIRE LANE BY PAINTING CURBS WITH INDUSTRIAL STRENGTH ENAMEL (SAFETY RED).
16	INSTALL 6" SOLID WHITE LINE PER USD NO. 244.9 (TYPE II FILM).
18	INSTALL SHARED BIKE LANE LEGEND. SEE MUTCD FIG. 9C-9 (FILM).
19	INSTALL R8-3A "NO PARKING" SIGN PER CCAUSD NO. 249.1 OR MOUNT ON STREETLIGHT POLE. SEE PLANS.
24	INSTALL R4-11 "MAY USE FULL LANE" SIGN PER CCAUSD NO. 249.1 OR MOUNT ON STREETLIGHT POLE. SEE PLANS.
26	INSTALL STAMPED CONCRETE CROSSWALK.
27	INSTALL 20-FT PREFORMED PANELS WITH INTEGRAL ARROW/BIKE SYMBOLS FOLLOWED BY SOLID GREEN PANELS.
28	INSTALL PREFORMED THERMOPLASTIC GREEN BIKE LANE.



30% Submittal
"NOT FOR CONSTRUCTION"
December 2016

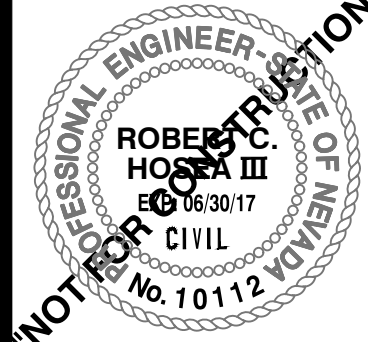

T3
38 OF 61
DRAWING NO.

DOWNTOWN PEDESTRIAN AND BICYCLE IMPROVEMENTS
3RD STREET-PHASE 2
CHARLESTON TO BONNEVILLE
SHEET
SIGNAGE & STRIPING PLANS

PREPARED FOR
CITY OF LAS VEGAS
H# 54616
DATE: --
SUBMITTAL STAGE:
30% Submittal

DESIGNED BY: MD
DRAWN BY: ND
CHECKED BY: LL

REVISIONS	
NO.	DATE


2727 SOUTH RANCHO BOULEVARD
LAS VEGAS, NEVADA 89146-5148
PH: (702) 878-7550
FAX: (702) 878-7550
WWW.VTNV.COM

DEPARTMENT OF PUBLIC WORKS
333 N. RANCHO DRIVE
LAS VEGAS, NV 89101
702-229-8272



- | LEGEND | |
|---|--|
| — — — — — | NO PARKING FIRE LANE. PAINT CURBS WITH INDUSTRIAL STRENGTH ENAMEL (SAFETY RED) WHERE INDICATED |
| - - - - - | RIGHT-OF-WAY LINE |
|  | 110/160 WATT LED STREET LIGHTS |
|  | 160 WATT LED STREET LIGHT |
|  | EXISTING LIGHT POLE |
|  | EXISTING UTILITY POLE |
|  | EXISTING FIRE HYDRANT |
|  | PROPOSED SIGN |
|  | 5' X 5' TREE WELL
(REFER TO HARDSCAPE PLANS) |
|  | TRASH ENCLOSURE |
|  | BENCH (REFER TO HARDSCAPE PLANS) |
|  | PLANTER (REFER TO HARDSCAPE PLANS) |

SIGNAGE LEGEND

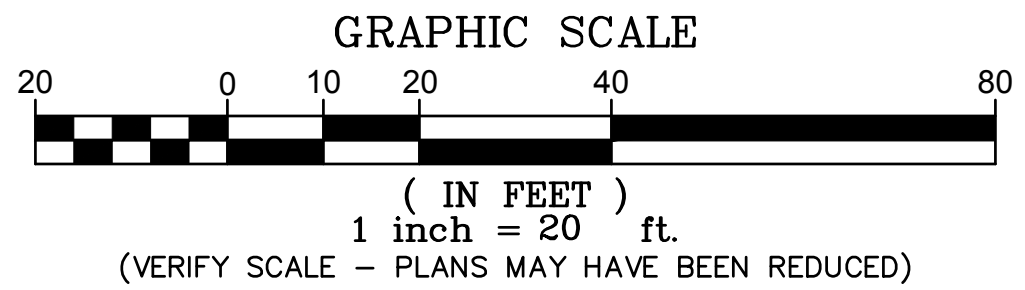

TRAFFIC STRIPING & SIGNAGE LEGEND

- | | |
|----|---|
| 8 | INSTALL 24" SOLID WHITE STOP BAR PER CCAUSD NO. 254 (FILM) |
| 13 | INSTALL TYPE I CENTERLINE PER USD NO. 244 (POLYUREA). |
| 16 | INSTALL 6" SOLID WHITE LINE PER USD NO. 244.9 (TYPE II FILM). |
| 26 | INSTALL STAMPED CONCRETE CROSSWALK. |
| 27 | INSTALL 20-FT PREFORMED PANELS WITH INTEGRAL ARROW/BIKE SYMBOLS FOLLOWED BY SOLID GREEN PANELS. |
| 28 | INSTALL PREFORMED THERMOPLASTIC GREEN BIKE LANE. |
| 29 | INSTALL "PARKING/BIKE LANE" SIGN (R3-17 MOD) PER CCAUSD NO. 249.1, SEE PLANS |

FAST

 Call
before you
UnderGround
1-702-432-5300
FREEWAY AND ARTERIAL
SYSTEM OF TRANSPORTATION


30% Submittal
"NOT FOR CONSTRUCTION"
December 2016





AVOID HITTING OVERHEAD
POWER LINES, IT'S COSTLY.
CALL BEFORE
YOU DO
OVERHEAD
1-702-227-2929

Call
811

 NOT FOR CONSTRUCTION PROFESSIONAL ENGINEER-STATE OF NEVADA ROBERT H. SMITH III E.C. 06/30/17 CIVIL No. 10112	DOWNTOWN PEDESTRIAN AND BICYCLE IMPROVEMENTS 3RD STREET-PHASE 2 CHARLESTON TO BONNEVILLE		CITY OF LAS VEGAS		PREPARED BY  2727 SOUTH RAINBOW BOULEVARD LAS VEGAS, NV 89146 PH. (702) 873-7550 FAX (702) 362-2597 WEB SITE WWW.VTVN.VM.COM				
	SIGNAGE & STRIPING PLANS -----				DESIGNED BY: MD				
	SHEET		H# 54616		DATE: --				
	T4 39 OF 61 DRAWING NO.		30% Submittal		SUBMITTAL STAGE:		DRAWN BY: ND		
				CHECKED BY: LL		DEPARTMENT OF PUBLIC WORKS 333 N. RANCHO DRIVE LAS VEGAS, NV 89106 702-229-8277		NO. DATE	
								REVISIONS	

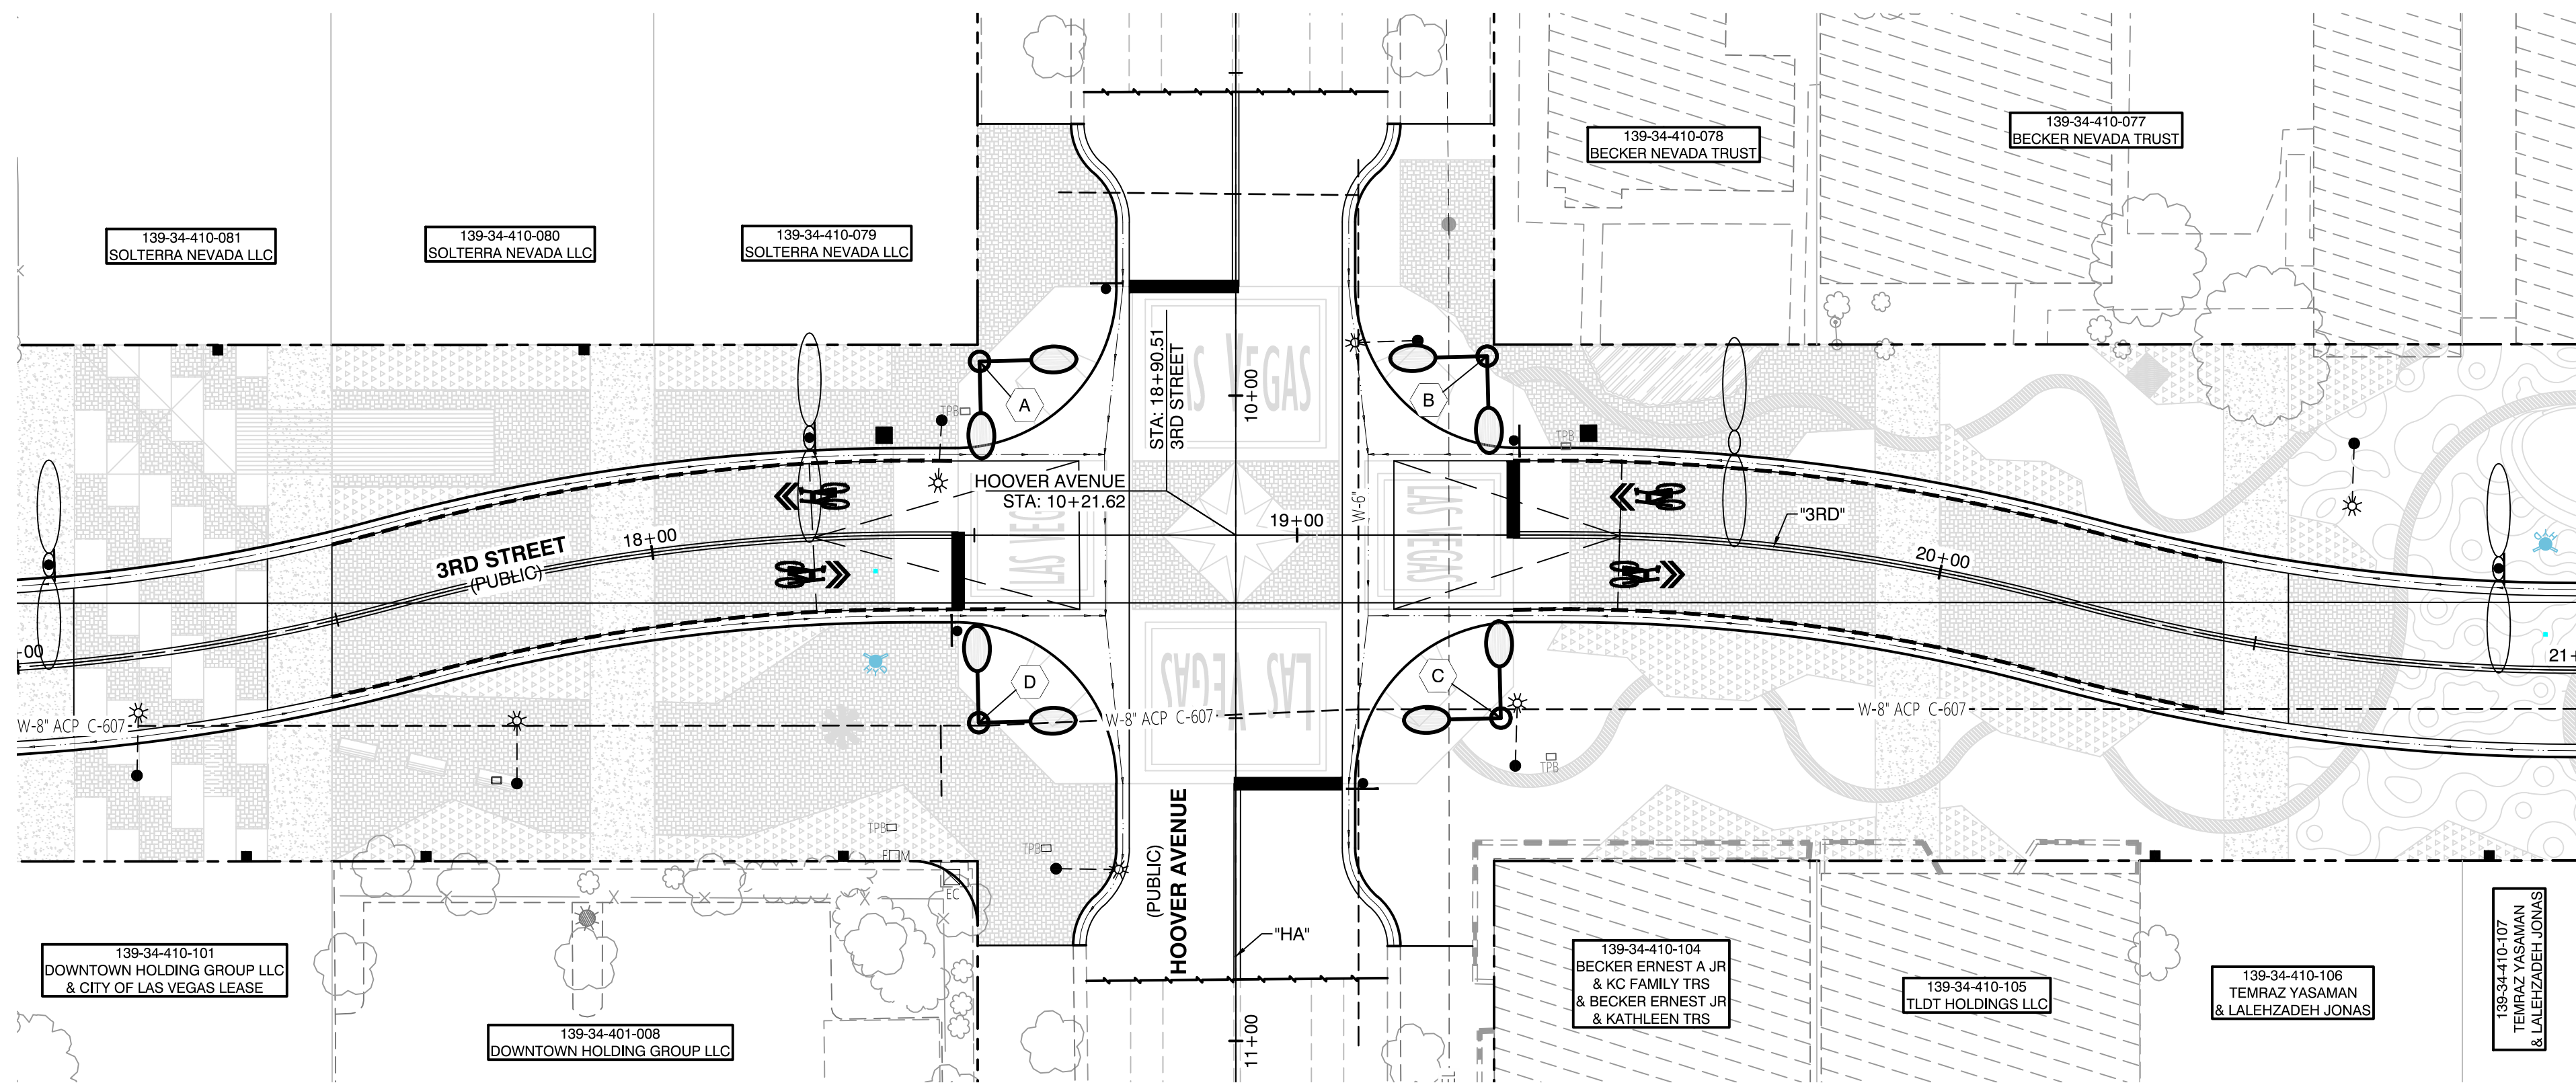

HOOVER AVENUE/3RD STREET

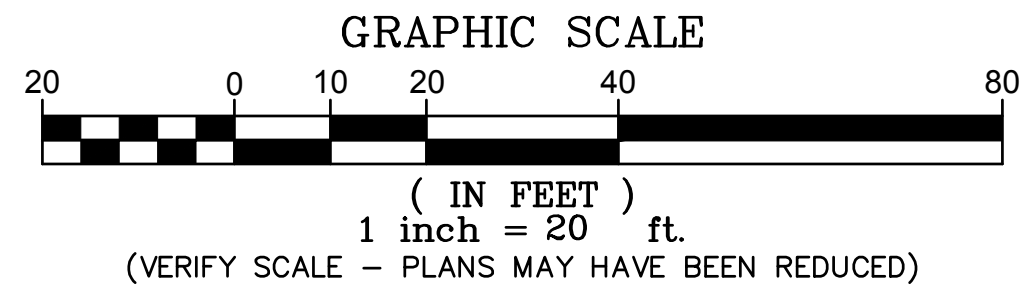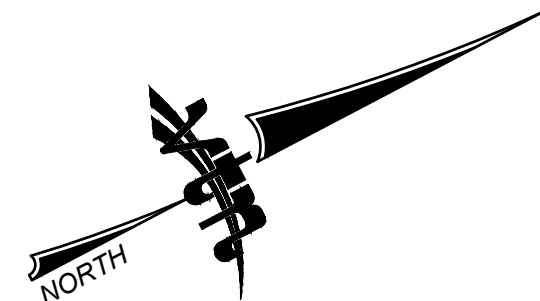


CLV - TRAFFIC NOTES

1. THE CITY OF LAS VEGAS (CLV) SHALL FURNISH THE FOLLOWING EQUIPMENT: ONE (1) POLE MOUNTED TRAFFIC SIGNAL CABINET WITH M53 CONTROLLER, LOAD BAY, LOAD SWITCHES, FLASHER AND FLASH TRANSFER RELAY; AND ONE (1) GTT MODEL 760 OPTICOM PREEMPTION RACK; THE CONTRACTOR SHALL BE RESPONSIBLE FOR SCHEDULING AND PICK UP OF SAID EQUIPMENT AND MATERIALS FROM THE CLV YARD, AND ALL SUBSEQUENT TRANSPORTATION THERETO, THE CONTRACTOR SHALL BE RESPONSIBLE FOR PROVIDING EVERYTHING ELSE BUT NOT LIMITED TO: ALL TRAFFIC SIGNAL POLES INCLUDING ONE (1) CUSTOM XX-A TRAFFIC SIGNAL POLE FOR A POLE-MOUNTED CABINET; THE CABINET MOUNTING BRACKET AND STAND, MALFUNCTION MANAGEMENT UNIT, MODEL 764 PHASE SELECTOR CARD, THE ANCHOR BOLTS, LUMINAIRE, SIGNAL MAST ARM AND LUMINAIRE ARM AND AN AUDIBLE-TACTILE PEDESTRIAN PUSH BUTTON CONTROL UNIT, INTERFACE PANEL AND ANY REQUIRED HARNESSSES TO MATCH THE TYPE OF AUDIBLE-TACTILE PEDESTRIAN PUSH BUTTONS THAT ARE INSTALLED ON THE SIGNAL POLES. THE CONTRACTOR SHALL INSTALL AND WIRE THE AUDIBLE-TACTILE PEDESTRIAN PUSH BUTTON EQUIPMENT IN THE CABINET TO PROVIDE A FULLY FUNCTIONING SYSTEM AS INDICATED IN THE PLANS AND PAINTED AS SPECIFIED IN SECTION 623 OF THE SPECIAL PROVISIONS.
2. THIS PROPOSED CONTROLLER CABINETS MUST HAVE A LAYER 2 FIELD-HARDENED ETHERNET SWITCH PROVIDED, BY THE CONTRACTOR, TO RTC-FAST PER RTC UNIFORM STANDARD SPECIFICATION (USS) 684.
3. EXISTING ITS CONDUIT AND FIBER OPTIC (FO) CABLE MUST BE PROTECTED AND MAINTAINED AT ALL TIMES.
4. CONTRACTOR IS TO MAINTAIN AND KEEP OPERATIONAL ALL EXISTING ITS INFRASTRUCTURE WITHIN THE CONSTRUCTION LIMITS. IF ANY EXISTING ITS INFRASTRUCTURE IS DAMAGED DUE TO CONSTRUCTION WITHIN THE PROJECT LIMITS THE CONTRACTOR IS TO IMMEDIATELY CONTACT MR. JESUS "CHUY" MARMOLEJO (RTC/FAST MANAGER TRAFFIC SYSTEMS MAINTENANCE) AT 702-604-7078 CELL OR AT 702-432-5300 GENERAL.
5. SEE SHEETS SL1-SL4 FOR STREET LIGHT PLANS.
6. SEE SHEET G2 FOR TRAFFIC SIGNAL GENERAL NOTES.



30% Submittal
"NOT FOR CONSTRUCTION"
December 2016

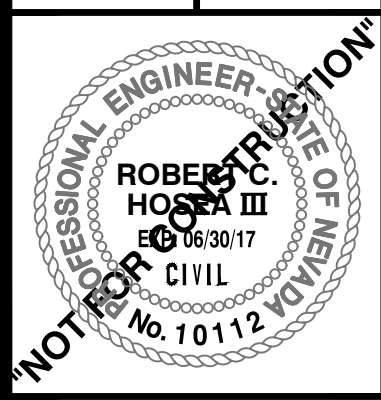

TS1
40 OF 61
DRAWING NO.

PREPARED FOR
CITY OF LAS VEGAS

H# 54616
DATE: --
SUBMITTAL STAGE:
30% Submittal

DOWNTOWN PEDESTRIAN AND BICYCLE IMPROVEMENTS
3RD STREET-PHASE 2
CHARLESTON TO BONNEVILLE


TRAFFIC SIGNAL PLANS

SHEET



BID# ---
DESIGNED BY: MD
DRAWN BY: ND
CHECKED BY: LL

DEPARTMENT OF PUBLIC WORKS
333 N. RANCHO DRIVE
LAS VEGAS, NV 89105
702-229-8272

NO.	DATE	REVISIONS

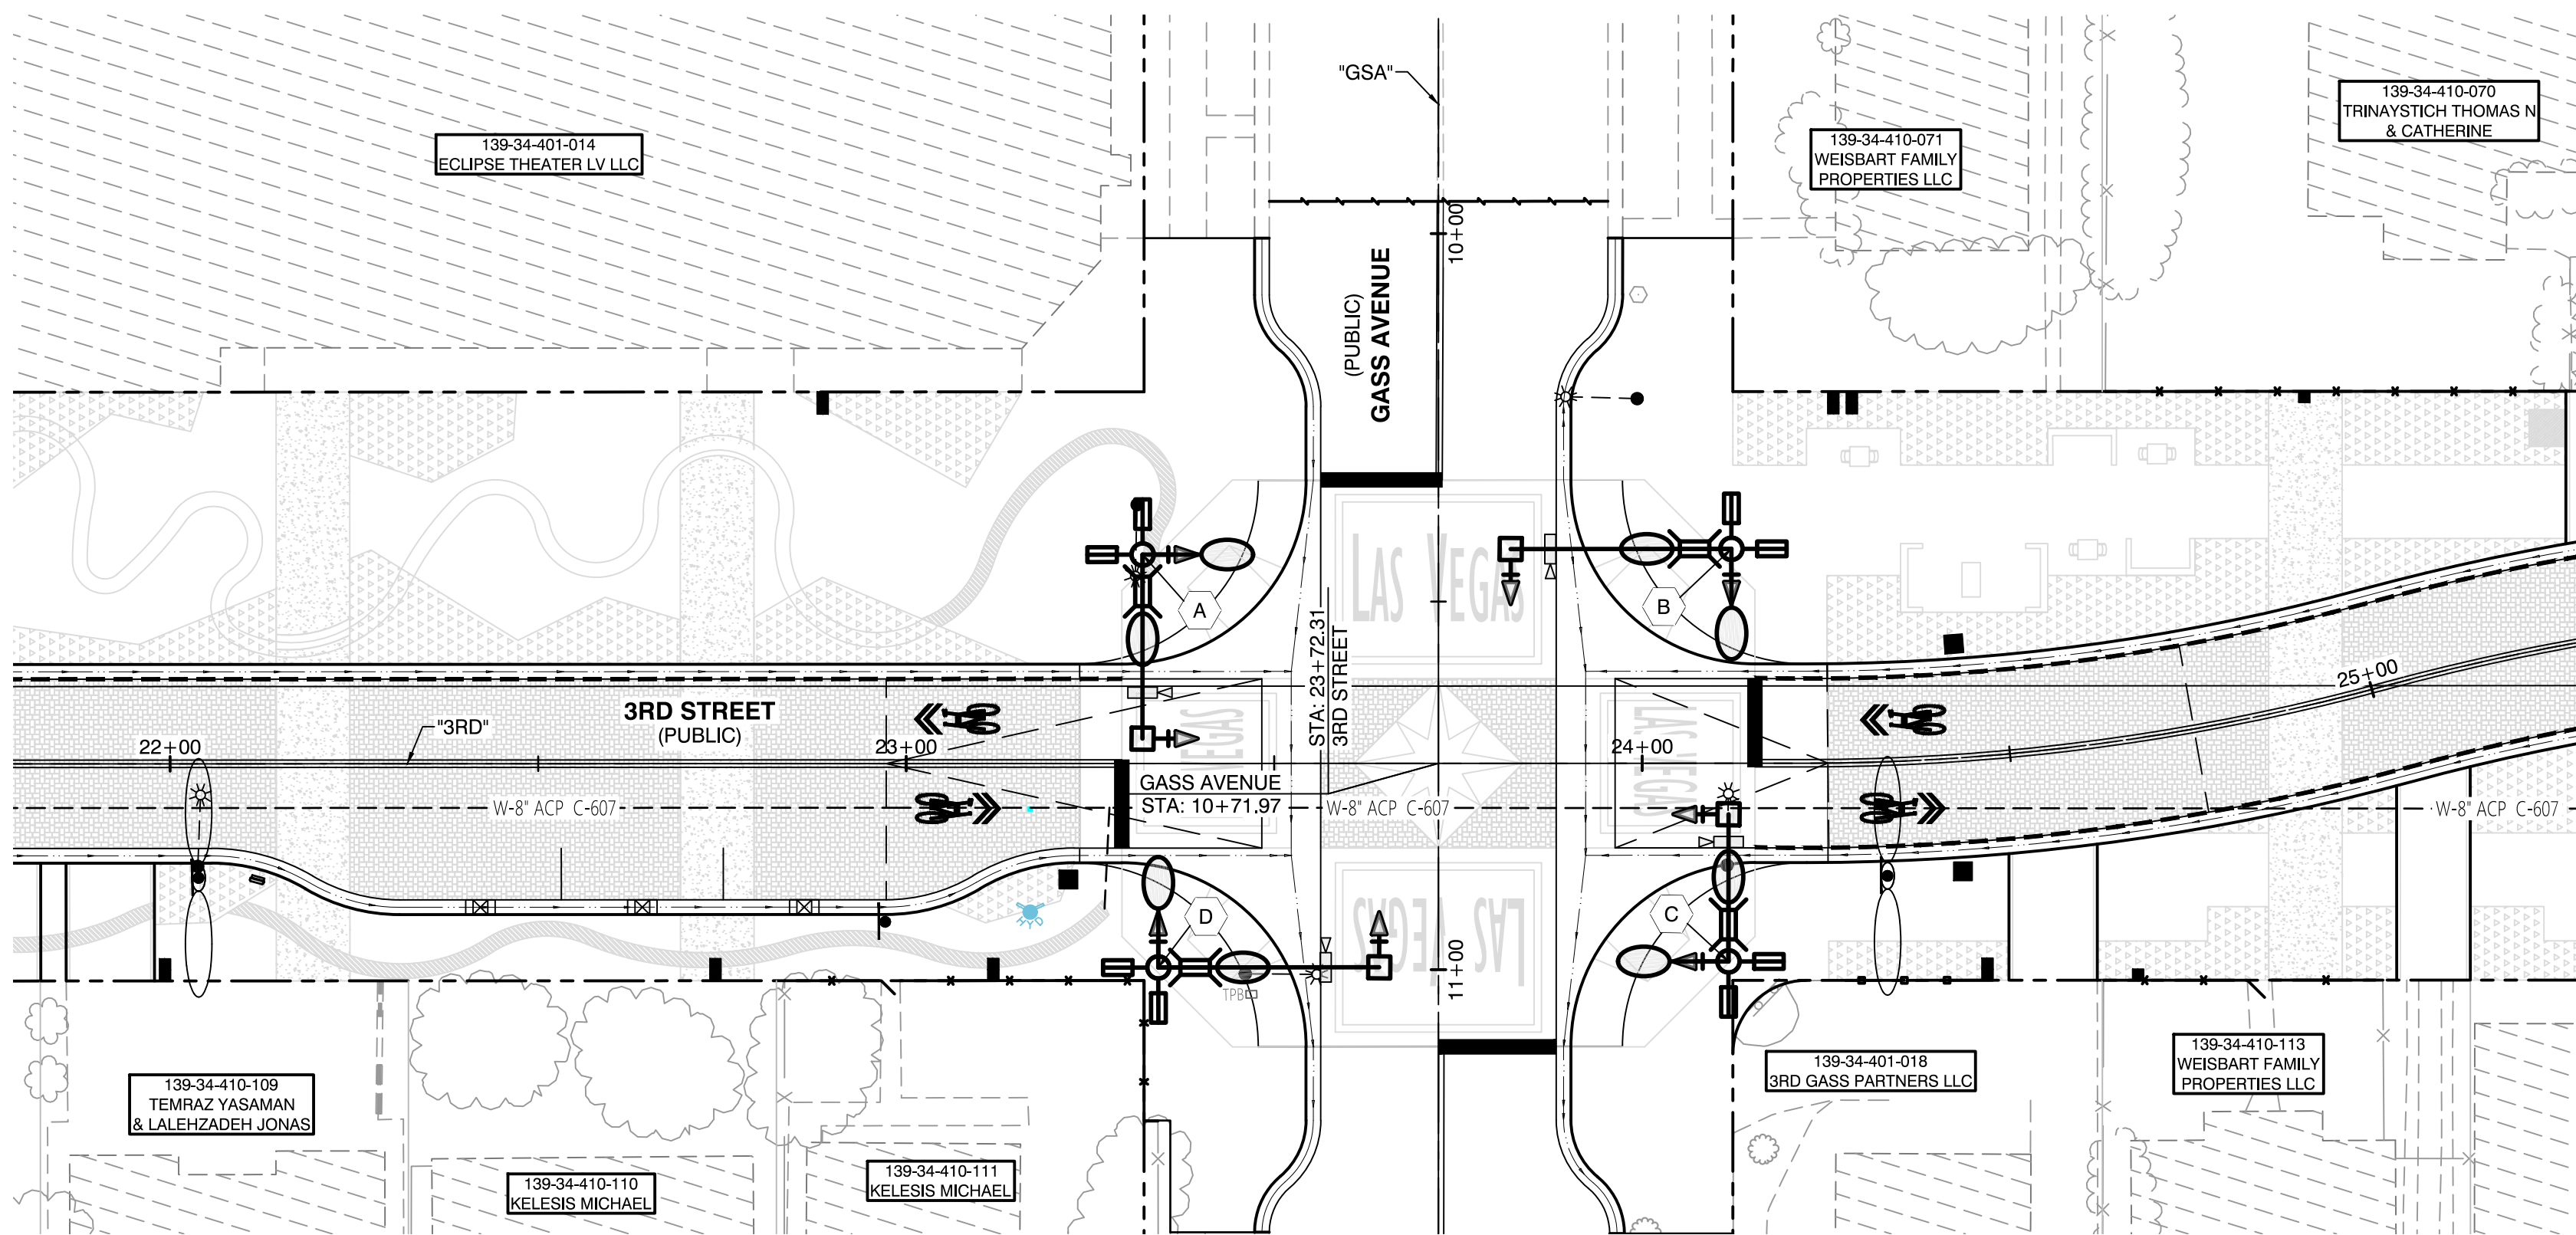


GASS AVENUE/3RD STREET

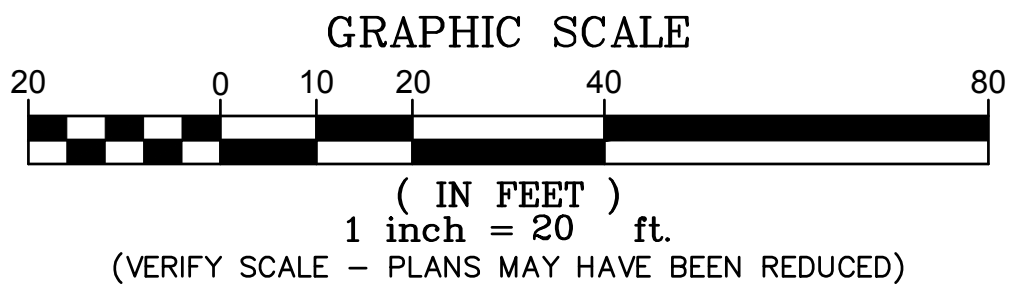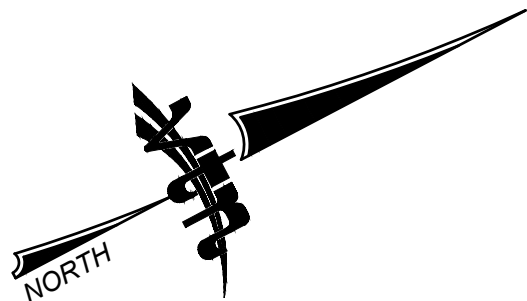

- CLV - TRAFFIC NOTES
1. THE CITY OF LAS VEGAS (CLV) SHALL FURNISH THE FOLLOWING EQUIPMENT: ONE (1) POLE MOUNTED TRAFFIC SIGNAL CABINET WITH M53 CONTROLLER, LOAD BAY, LOAD SWITCHES, FLASHER AND FLASH TRANSFER RELAY; AND ONE (1) GTT MODEL 760 OPTICOM PREEMPTION RACK; THE CONTRACTOR SHALL BE RESPONSIBLE FOR SCHEDULING AND PICK UP OF SAID EQUIPMENT AND MATERIALS FROM THE CLV YARD, AND ALL SUBSEQUENT TRANSPORTATION THERETO, THE CONTRACTOR SHALL BE RESPONSIBLE FOR PROVIDING EVERYTHING ELSE BUT NOT LIMITED TO: ALL TRAFFIC SIGNAL POLES INCLUDING ONE (1) CUSTOM XX-A TRAFFIC SIGNAL POLE FOR A POLE-MOUNTED CABINET; THE CABINET MOUNTING BRACKET AND STAND, MALFUNCTION MANAGEMENT UNIT, MODEL 764 PHASE SELECTOR CARD, THE ANCHOR BOLTS, LUMINAIRE, SIGNAL MAST ARM AND LUMINAIRE ARM AND AN AUDIBLE-TACTILE PEDESTRIAN PUSH BUTTON CONTROL UNIT, INTERFACE PANEL AND ANY REQUIRED HARNESSSES TO MATCH THE TYPE OF AUDIBLE-TACTILE PEDESTRIAN PUSH BUTTONS THAT ARE INSTALLED ON THE SIGNAL POLES. THE CONTRACTOR SHALL INSTALL AND WIRE THE AUDIBLE-TACTILE PEDESTRIAN PUSH BUTTON EQUIPMENT IN THE CABINET TO PROVIDE A FULLY FUNCTIONING SYSTEM AS INDICATED IN THE PLANS AND PAINTED AS SPECIFIED IN SECTION 623 OF THE SPECIAL PROVISIONS.
 2. THIS PROPOSED CONTROLLER CABINETS MUST HAVE A LAYER 2 FIELD-HARDENED ETHERNET SWITCH PROVIDED, BY THE CONTRACTOR, TO RTC-FAST PER RTC UNIFORM STANDARD SPECIFICATION (USS) 684.
 3. EXISTING ITS CONDUIT AND FIBER OPTIC (FO) CABLE MUST BE PROTECTED AND MAINTAINED AT ALL TIMES.
 4. CONTRACTOR IS TO MAINTAIN AND KEEP OPERATIONAL ALL EXISTING ITS INFRASTRUCTURE WITHIN THE CONSTRUCTION LIMITS. IF ANY EXISTING ITS INFRASTRUCTURE IS DAMAGED DUE TO CONSTRUCTION WITHIN THE PROJECT LIMITS THE CONTRACTOR IS TO IMMEDIATELY CONTACT MR. JESUS "CHUY" MARMOLEJO (RTC/FAST MANAGER TRAFFIC SYSTEMS MAINTENANCE) AT 702-604-7078 CELL OR AT 702-432-5300 GENERAL.
 5. SEE SHEETS SL1-SL4 FOR STREET LIGHT PLANS.
 6. SEE SHEET G2 FOR TRAFFIC SIGNAL GENERAL NOTES.



30% Submittal
"NOT FOR CONSTRUCTION"
December 2016

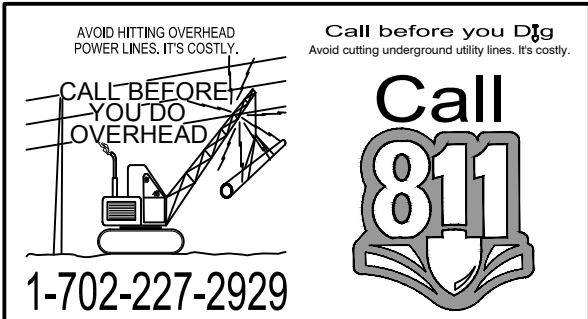


PREPARED BY CITY OF LAS VEGAS		2727 SOUTH RAINBOW BOULEVARD LAS VEGAS, NEVADA 89146-5148 PH: (702) 875-7550 WWW.VTNV.COM	
H# 54616	BID# ---	DESIGNED BY: MD	NO. DATE
DATE: --	DESIGNED BY: MD	DRAWN BY: ND	REVISIONS
SUBMITTAL STAGE:	CHECKED BY: LL	DEPARTMENT OF PUBLIC WORKS 333 N. RANCHO DRIVE LAS VEGAS, NV 89102 702-229-8272	
DOWNTOWN PEDESTRIAN AND BICYCLE IMPROVEMENTS 3RD STREET-PHASE 2 CHARLESTON TO BONNEVILLE		TRAFFIC SIGNAL PLANS	
SHEET		TS3 42 OF 61 DRAWING NO.	
30% Submittal		NOT FOR CONSTRUCTION	

CONDUIT AND WIRE SCHEDULE

[illegible]

POLE SCHEDULE

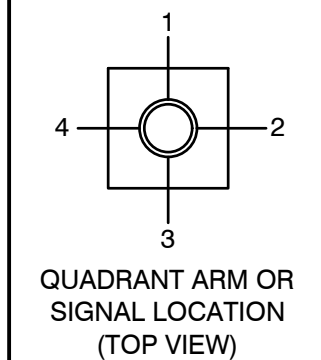[illegible]





POLE NOTES

1. ALL POLE LOCATIONS ARE BASED FROM 3RD STREET CENTERLINE STATIONING.
2. TYPE "H" FOUNDATION PER USDCCA STD. DWG. NO. 721.
3. TYPE "L" FOUNDATION PER USDCCA STD. DWG. NO. 722.
4. R3-4 SIGN SHALL BE 36"x36".
5. TENON ONLY FOR TUBULE LEFT TURN.
6. TRAFFIC POLES TO BE BLACK GREEN (RAL 6012) WITH DUAL STREETLIGHTS (GARDCO CAA22L-2@90-3-160LA-CW-UNIV OR APPROVED EQUAL).
7. TYPE XX POLES PER USDCCA STD. DWG. NO. 808.
8. LUMINAIRES FOR INTERSECTION LIGHTING TO BE FUSED IN THE CABINET.
9. OPTICAL DETECTION TO BE MOUNTED ON SIGNAL, MASTER ARM.
10. INSTALL STREET NAME SIGN (INTERNALLY ILLUMINATED).
11. INSTALL POLE MOUNTED CONTROLLER AND ASSEMBLY.
12. THE CONTRACTOR SHALL PROVIDE AN AUDIBLE-TACTILE PEDESTRIAN PUSH BUTTON CONTROL UNIT, INTERFACE PANEL AND ANY REQUIRED HARNESSSES TO MATCH THE TYPE OF AUDIBLE-TACTILE PEDESTRIAN PUSH BUTTONS THAT ARE INSTALLED ON THE SIGNAL POLES. THE CONTRACTOR SHALL INSTALL AND WIRE THE AUDIBLE-TACTILE PEDESTRIAN PUSH BUTTON EQUIPMENT IN THE CABINET TO PROVIDE A FULLY FUNCTIONING SYSTEM.
- * 13. MOD. POLE PER DETAIL ON SHEET T7, CONTRACTOR TO PROVIDE POLE AND STAFF (RAMSEN & SON, INC., PART # RS0989)
14. PROVIDE 10" OF SPACE IN THE CABINET OF THE STAND BASE FOR ALL TRAFFIC SIGNAL AND ILLUMINATE CONDUCTORS.
15. ALL INDICATIONS SHALL BE CIRCULAR TYPE, NO ARROW INDICATIONS.
16. INSTALL TYPE "C" FOUNDATION PER USDCCA STD. DWG. NO. 717.
17. INSTALL 1-A POLE PER USDCCA STD. DWG. NO. 806.

STREET NAME & BLOCK NUMBER SIGN SCHEDULE

POLE	STREET NAME SIGN	STREET SUFFIX	BLOCK NUMBER	CARDINAL DIRECTION	DOUBLE SIDED
	Gass	AVE	200 SEE NOTE 1	E	YES
	3rd	ST	800 SEE NOTE 1	S	YES
	Gass	AVE	300 SEE NOTE 1	E	YES
	3rd	ST	700 SEE NOTE 1	S	YES

ILLUMINATED STREET SIGN SCHEDULE

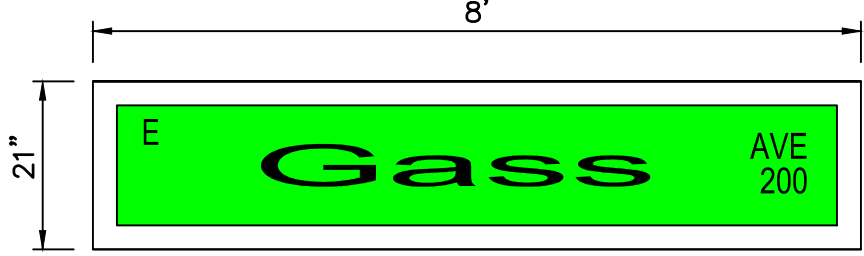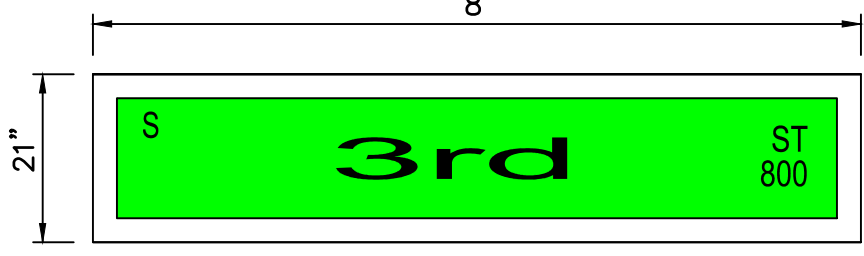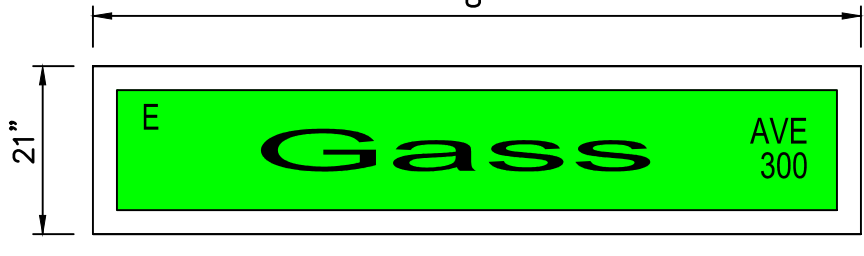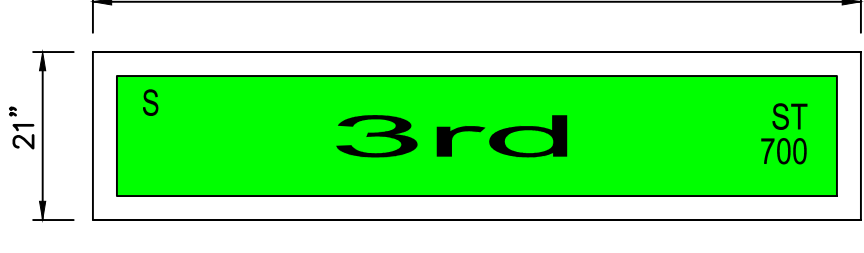POLE	SIGN
A	
B	
C	
D	

ILLUMINATED SIGN NOTES

1. SIGN SCHEDULE PER CLV PLANNING DEPARTMENT & TFO DIRECTIONS, BLOCK #, SUFFIX: 5" HWY "D"
2. STREET NAME: 12" UPPER AND 9" LOWER CASE HWY "D" OR "C" ONLY IF NECESSARY
3. BORDER REQUIRED: 3M GREEN ON WHITE DIAMOND GRADE SHEETING
4. POWER ILLUMINATED SIGN WITH LUMINAIRE DIRECTLY ABOVE TRAFFIC SIGNAL MAST ARM.
5. SIGN TO BE DOUBLE SIDED.



SHEET
TS4
43 OF 61
DRAWING NO.

TRAFFIC SIGNAL PLANS

PREPARED FOR
CITY OF LAS VEGAS

PREPARED BY
vtm
2727 SOUTH RAINBOW BOULEVARD
LAS VEGAS, NEVADA 89146-5148
PH. (702) 873-7550
FAX (702) 362-2597 WEB SITE
WWW.VTNNV.COM




DEPARTMENT OF PUBLIC WORKS
333 N. RANCHO DRIVE
LAS VEGAS, NV 89106
702-229-8272



DESIGNED BY: MD
DRAWN BY: ND
CHECKED BY: LL

REVISIONS

NO.	DATE
-----	------

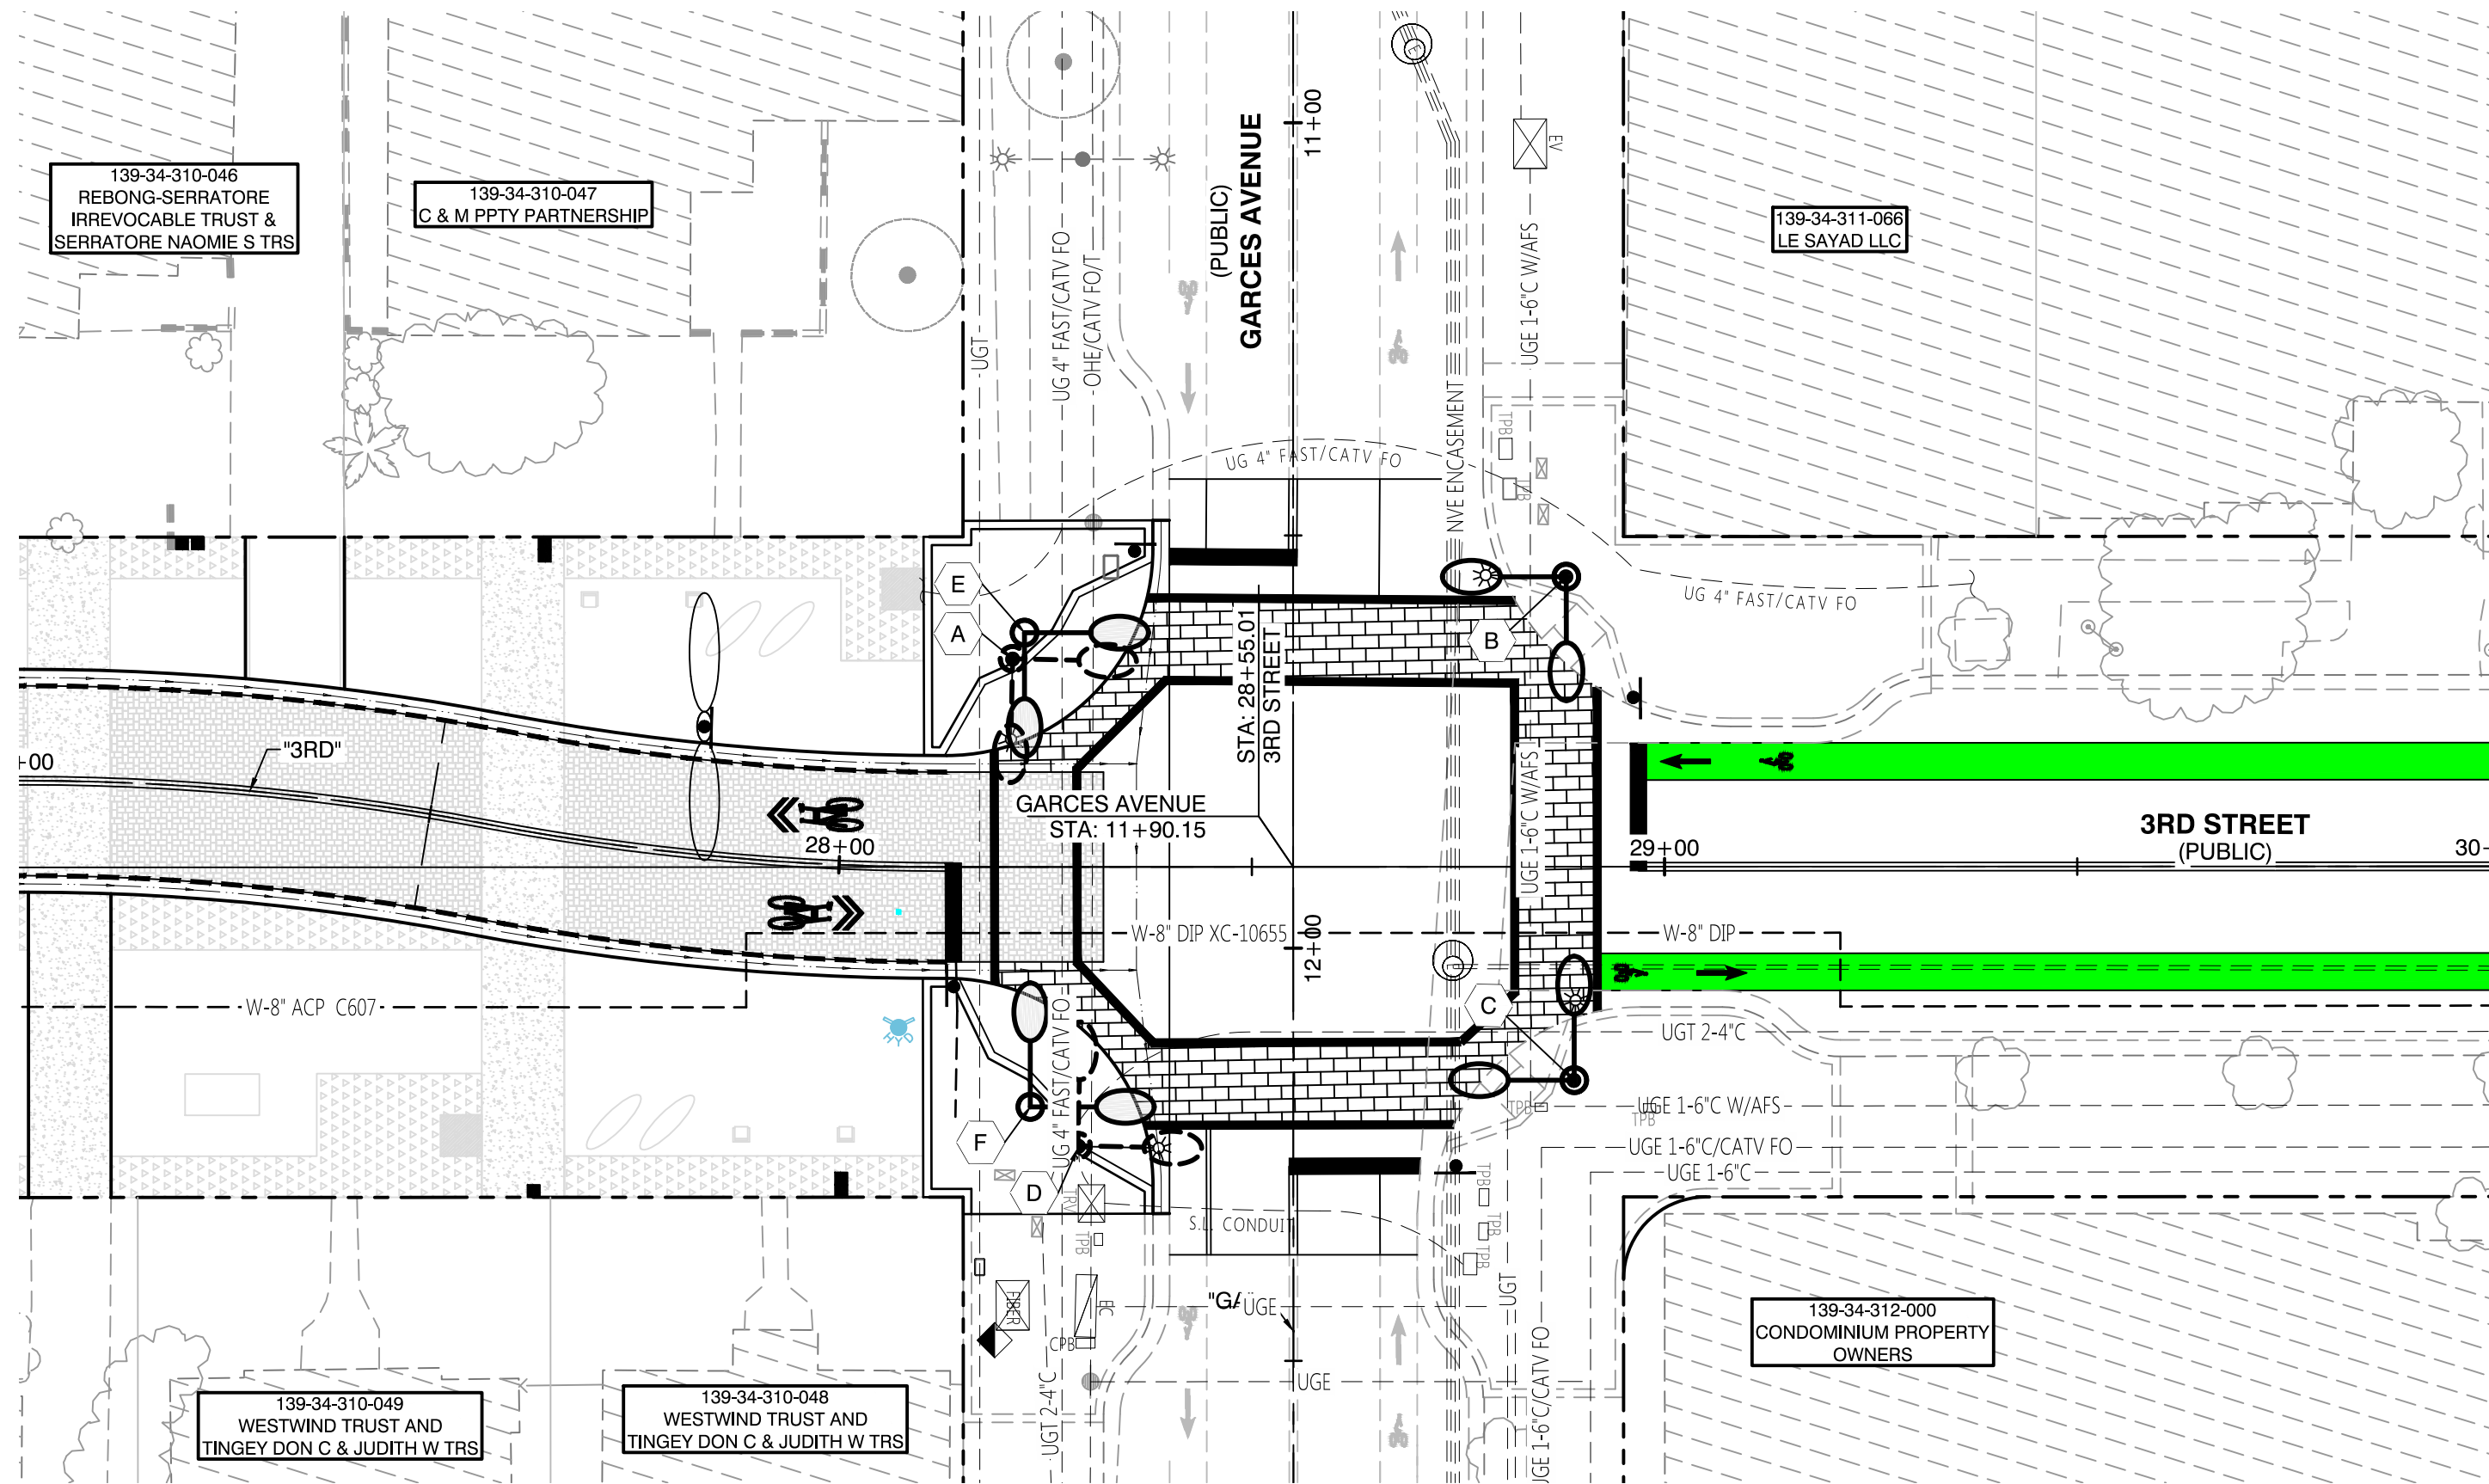


GARCES AVENUE/3RD STREET

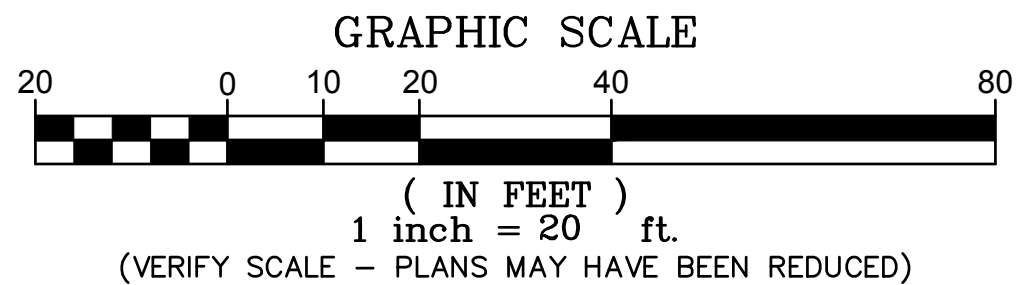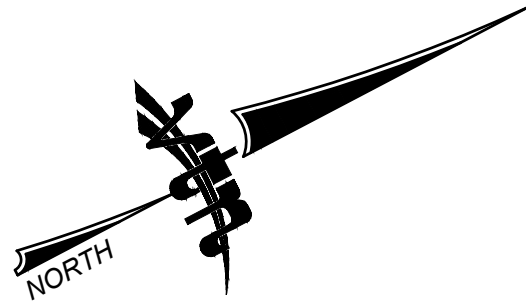

- CLV - TRAFFIC NOTES**
1. THE CITY OF LAS VEGAS (CLV) SHALL FURNISH THE FOLLOWING EQUIPMENT: ONE (1) POLE MOUNTED TRAFFIC SIGNAL CABINET WITH M53 CONTROLLER, LOAD BAY, LOAD SWITCHES, FLASHER AND FLASH TRANSFER RELAY; AND ONE (1) GTT MODEL 760 OPTICOM PREEMPTION RACK; THE CONTRACTOR SHALL BE RESPONSIBLE FOR SCHEDULING AND PICK UP OF SAID EQUIPMENT AND MATERIALS FROM THE CLV YARD, AND ALL SUBSEQUENT TRANSPORTATION THERETO. THE CONTRACTOR SHALL BE RESPONSIBLE FOR PROVIDING EVERYTHING ELSE BUT NOT LIMITED TO: ALL TRAFFIC SIGNAL POLES INCLUDING ONE (1) CUSTOM XX-A TRAFFIC SIGNAL POLE FOR A POLE-MOUNTED CABINET; THE CABINET MOUNTING BRACKET AND STAND, MALFUNCTION MANAGEMENT UNIT, MODEL 764 PHASE SELECTOR CARD, THE ANCHOR BOLTS, LUMINAIRE, SIGNAL MAST ARM AND LUMINAIRE ARM AND AN AUDIBLE-TACTILE PEDESTRIAN PUSH BUTTON CONTROL UNIT, INTERFACE PANEL AND ANY REQUIRED HARNESES TO MATCH THE TYPE OF AUDIBLE-TACTILE PEDESTRIAN PUSH BUTTONS THAT ARE INSTALLED ON THE SIGNAL POLES. THE CONTRACTOR SHALL INSTALL AND WIRE THE AUDIBLE-TACTILE PEDESTRIAN PUSH BUTTON EQUIPMENT IN THE CABINET TO PROVIDE A FULLY FUNCTIONING SYSTEM AS INDICATED IN THE PLANS AND PAINTED AS SPECIFIED IN SECTION 623 OF THE SPECIAL PROVISIONS.
 2. THIS PROPOSED CONTROLLER CABINETS MUST HAVE A LAYER 2 FIELD-HARDENED ETHERNET SWITCH PROVIDED, BY THE CONTRACTOR, TO RTC-FAST PER RTC UNIFORM STANDARD SPECIFICATION (USS) 684.
 3. EXISTING ITS CONDUIT AND FIBER OPTIC (FO) CABLE MUST BE PROTECTED AND MAINTAINED AT ALL TIMES.
 4. CONTRACTOR IS TO MAINTAIN AND KEEP OPERATIONAL ALL EXISTING ITS INFRASTRUCTURE WITHIN THE CONSTRUCTION LIMITS. IF ANY EXISTING ITS INFRASTRUCTURE IS DAMAGED DUE TO CONSTRUCTION WITHIN THE PROJECT LIMITS THE CONTRACTOR IS TO IMMEDIATELY CONTACT MR. JESUS "CHUY" MARMOLEJO (RTC/FAST MANAGER TRAFFIC SYSTEMS MAINTENANCE) AT 702-604-7078 CELL OR AT 702-432-5300 GENERAL.
 5. SEE SHEETS SL1-SL4 FOR STREET LIGHT PLANS.
 6. SEE SHEET G2 FOR TRAFFIC SIGNAL GENERAL NOTES.



30% Submittal
"NOT FOR CONSTRUCTION"
December 2016

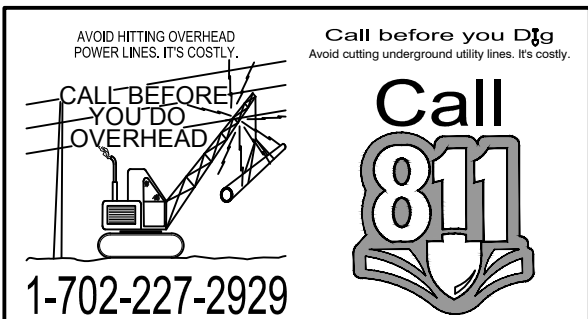

PREPARED BY CITY OF LAS VEGAS		DESIGNED BY: MD		CHECKED BY: LL	
H# 54616		DATE: --		SUBMITTAL STAGE: 30% Submittal	
DOWNTOWN PEDESTRIAN AND BICYCLE IMPROVEMENTS 3RD STREET-PHASE 2 CHARLESTON TO BONNEVILLE		SHEET		TRAFFIC SIGNAL PLANS	
2727 SOUTH RAINBOW BOULEVARD LAS VEGAS, NEVADA 89146-5148 PH: (702) 878-7550 WWW.VTNV.COM		DEPARTMENT OF PUBLIC WORKS 333 N. RANCHO DRIVE LAS VEGAS, NEVADA 89106 702-229-8272		NO. DATE	
REVISIONS					



TS5
44 OF 61
DRAWING NO.