

DEPARTMENT OF OPERATIONS & MAINTENANCE



Las Vegas Senior Center Roof and HVAC Replacement

Index of Drawings

Cvr	Cover Sheet, Index of Drawings
A1	Roof Plan
A2	Roof Details
S1.0	General Structural Notes
S2.0	Roof Framing Plan
S3.0	Typical Details
M0.0	Mechanical Symbols, Abbreviations and Drawing index
M0.1	Mechanical and Plumbing Specifications
M0.2	Mechanical and plumbing schedules and diagrams
M0.3	IECC Compliance Statement
MD2.1	Mechanical Demolition Floor Plan
M2.1	Mechanical Floor Plan
MD2.2	Mechanical Demolition Roof Plan
M2.2	Mechanical Roof Plan
MFS-1	Mechanical Food Service
MFS-2	Mechanical Food Service
P0.1	Natural Gas Diagram
PD2.2	Plumbing Demolition Plan
P2.1	Plumbing Floor Plan
P2.2	Plumbing Roof Plan
EO.0	Electrical Symbols, Abbreviations and Drawing Index
EO.1	Electrical Specifications
EO.2	Electrical Single Line Diagrams and Panel Schedules
ED2.1	Electrical Demolition Floor Plan
ED2.2	Electrical Demolition Roof Plan
E2.1	Electrical Floor Plan
E2.2	Electrical Roof Plan



DISCUSSION

CONSULTANT

Las Vegas Senior Center
451 East Bonanza Rd

Cover

MP	
----	--

OWNER: CITY OF LAS VEGAS
Department of Operations & Maintenance

104 East Bonanza Road
LAS VEGAS, NEVADA 89101
PHONE: (702) 229-6220
FAX: (702) 382-0619
TOLL FREE: (800) 386-9108

4474

E

IE	
----	--

--	--

[illegible]


NO

Cvr

DEPARTMENT OF OPERATIONS AND MAINTENANCE
 STAFF
 OW Dep
 31 LA
 DATE PH
 FILE FA
 DRAW TD
 SCALE
 BID N
 CLV D
 SHT N

Roof Plan

Scale: 1/8" = 1'-0"

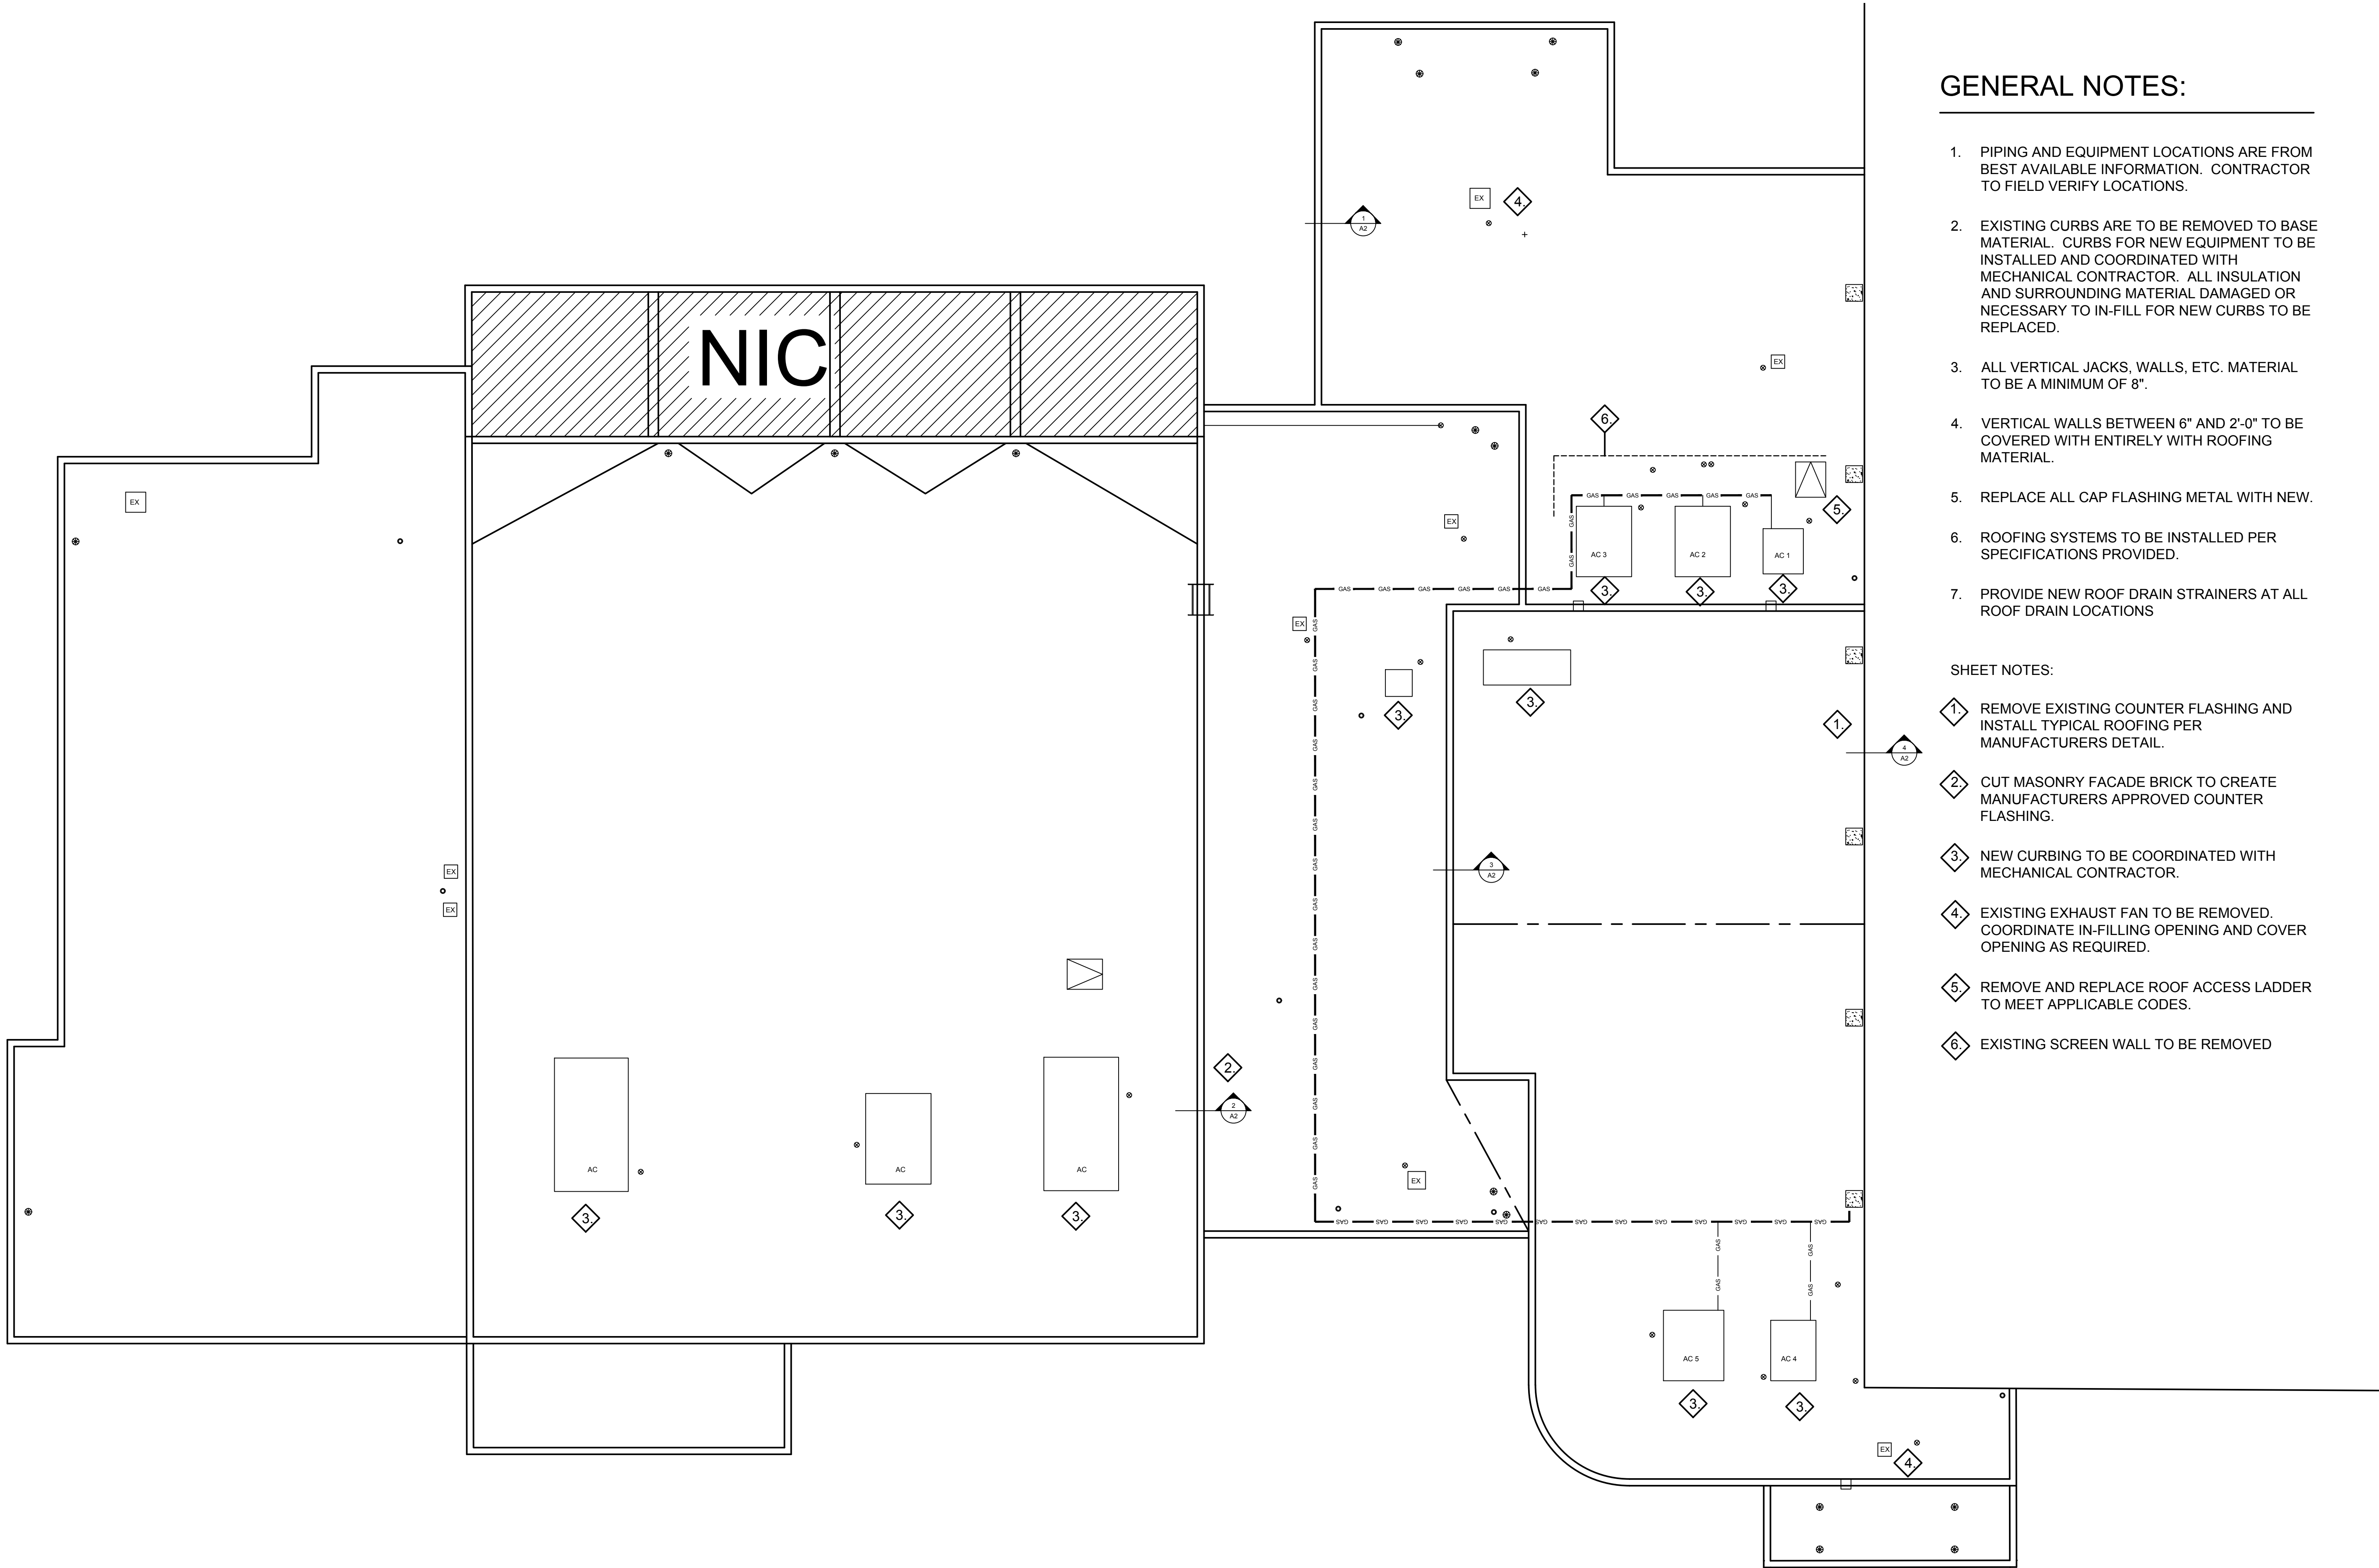

GENERAL NOTES:

1. PIPING AND EQUIPMENT LOCATIONS ARE FROM BEST AVAILABLE INFORMATION. CONTRACTOR TO FIELD VERIFY LOCATIONS.
2. EXISTING CURBS ARE TO BE REMOVED TO BASE MATERIAL. CURBS FOR NEW EQUIPMENT TO BE INSTALLED AND COORDINATED WITH MECHANICAL CONTRACTOR. ALL INSULATION AND SURROUNDING MATERIAL DAMAGED OR NECESSARY TO IN-FILL FOR NEW CURBS TO BE REPLACED.
3. ALL VERTICAL JACKS, WALLS, ETC. MATERIAL TO BE A MINIMUM OF 8".
4. VERTICAL WALLS BETWEEN 6" AND 2'-0" TO BE COVERED WITH ENTIRELY WITH ROOFING MATERIAL.
5. REPLACE ALL CAP FLASHING METAL WITH NEW.
6. ROOFING SYSTEMS TO BE INSTALLED PER SPECIFICATIONS PROVIDED.
7. PROVIDE NEW ROOF DRAIN STRAINERS AT ALL ROOF DRAIN LOCATIONS

SHEET NOTES:

1. REMOVE EXISTING COUNTER FLASHING AND INSTALL TYPICAL ROOFING PER MANUFACTURERS DETAIL.
2. CUT MASONRY FACADE BRICK TO CREATE MANUFACTURERS APPROVED COUNTER FLASHING.
3. NEW CURBING TO BE COORDINATED WITH MECHANICAL CONTRACTOR.
4. EXISTING EXHAUST FAN TO BE REMOVED. COORDINATE IN-FILLING OPENING AND COVER OPENING AS REQUIRED.
5. REMOVE AND REPLACE ROOF ACCESS LADDER TO MEET APPLICABLE CODES.
6. EXISTING SCREEN WALL TO BE REMOVED



REVISIONS

CONSULTANT

Las Vegas Senior Center
451 East Bonanza Rd

Roof Plan

STAMP

OWNER: CITY OF LAS VEGAS
Department of Operations & Maintenance

3104 East Bonanza Road
LAS VEGAS, NEVADA 89101
PHONE: (702) 229-6220
FAX: (702) 382-0619
TDD: (702) 386-9108

DRAWN

FILE

DATE

12/8/17

SCALE

DTD NO

18.69111.02

CLV DWG NO

513-45Q

SHT NO

A1

REVISIONS
CONSULTANT
Las Vegas Senior Center
451 East Bonanza Rd
Roof Plan
STAMP
OWNER: CITY OF LAS VEGAS
Department of Operations & Maintenance
3104 East Bonanza Road
LAS VEGAS, NEVADA 89101
PHONE: (702) 229-6220
FAX: (702) 382-0619
TDD: (702) 386-9108
DRAWN
FILE
DATE
12/8/17
SCALE
DTD NO
18.69111.02
CLV DWG NO
513-45Q
SHT NO
A1



SULTANT					
---------	--	--	--	--	--

Roo Details

WTR					
-----	--	--	--	--	--

12/2/15


LE					
----	--	--	--	--	--

DWG NO.	510-150
---------	---------


A2

--	--	--


THE DRAWINGS AND SPECIFICATIONS ARE THE PROPERTY OF THE DESIGN PROFESSIONAL WHOSE STAMP OF CERTIFICATION APPEARS ON THE DRAWINGS AND SPECIFICATIONS. ANY USE OR REPRODUCTION IN WHOLE OR IN PART WITHOUT WRITTEN CONSENT BY THE CLIENT MAY BE UTILIZED ONLY FOR OCCUPANCY OF THE PROJECT FOR WHICH THEY WERE PREPARED AND NOT FOR THE CONSTRUCTION OF ANY OTHER PROJECT. NO PART OF THE DRAWINGS OR SPECIFICATIONS MAY BE REPRODUCED OR TRANSMITTED IN ANY FORM OR BY ANY MEANS, ELECTRONIC OR MECHANICAL, INCLUDING PHOTOCOPYING, RECORDING, OR BY ANY INFORMATION STORAGE AND RETRIEVAL SYSTEM, WITHOUT PERMISSION IN WRITING FROM THE DESIGN PROFESSIONAL.

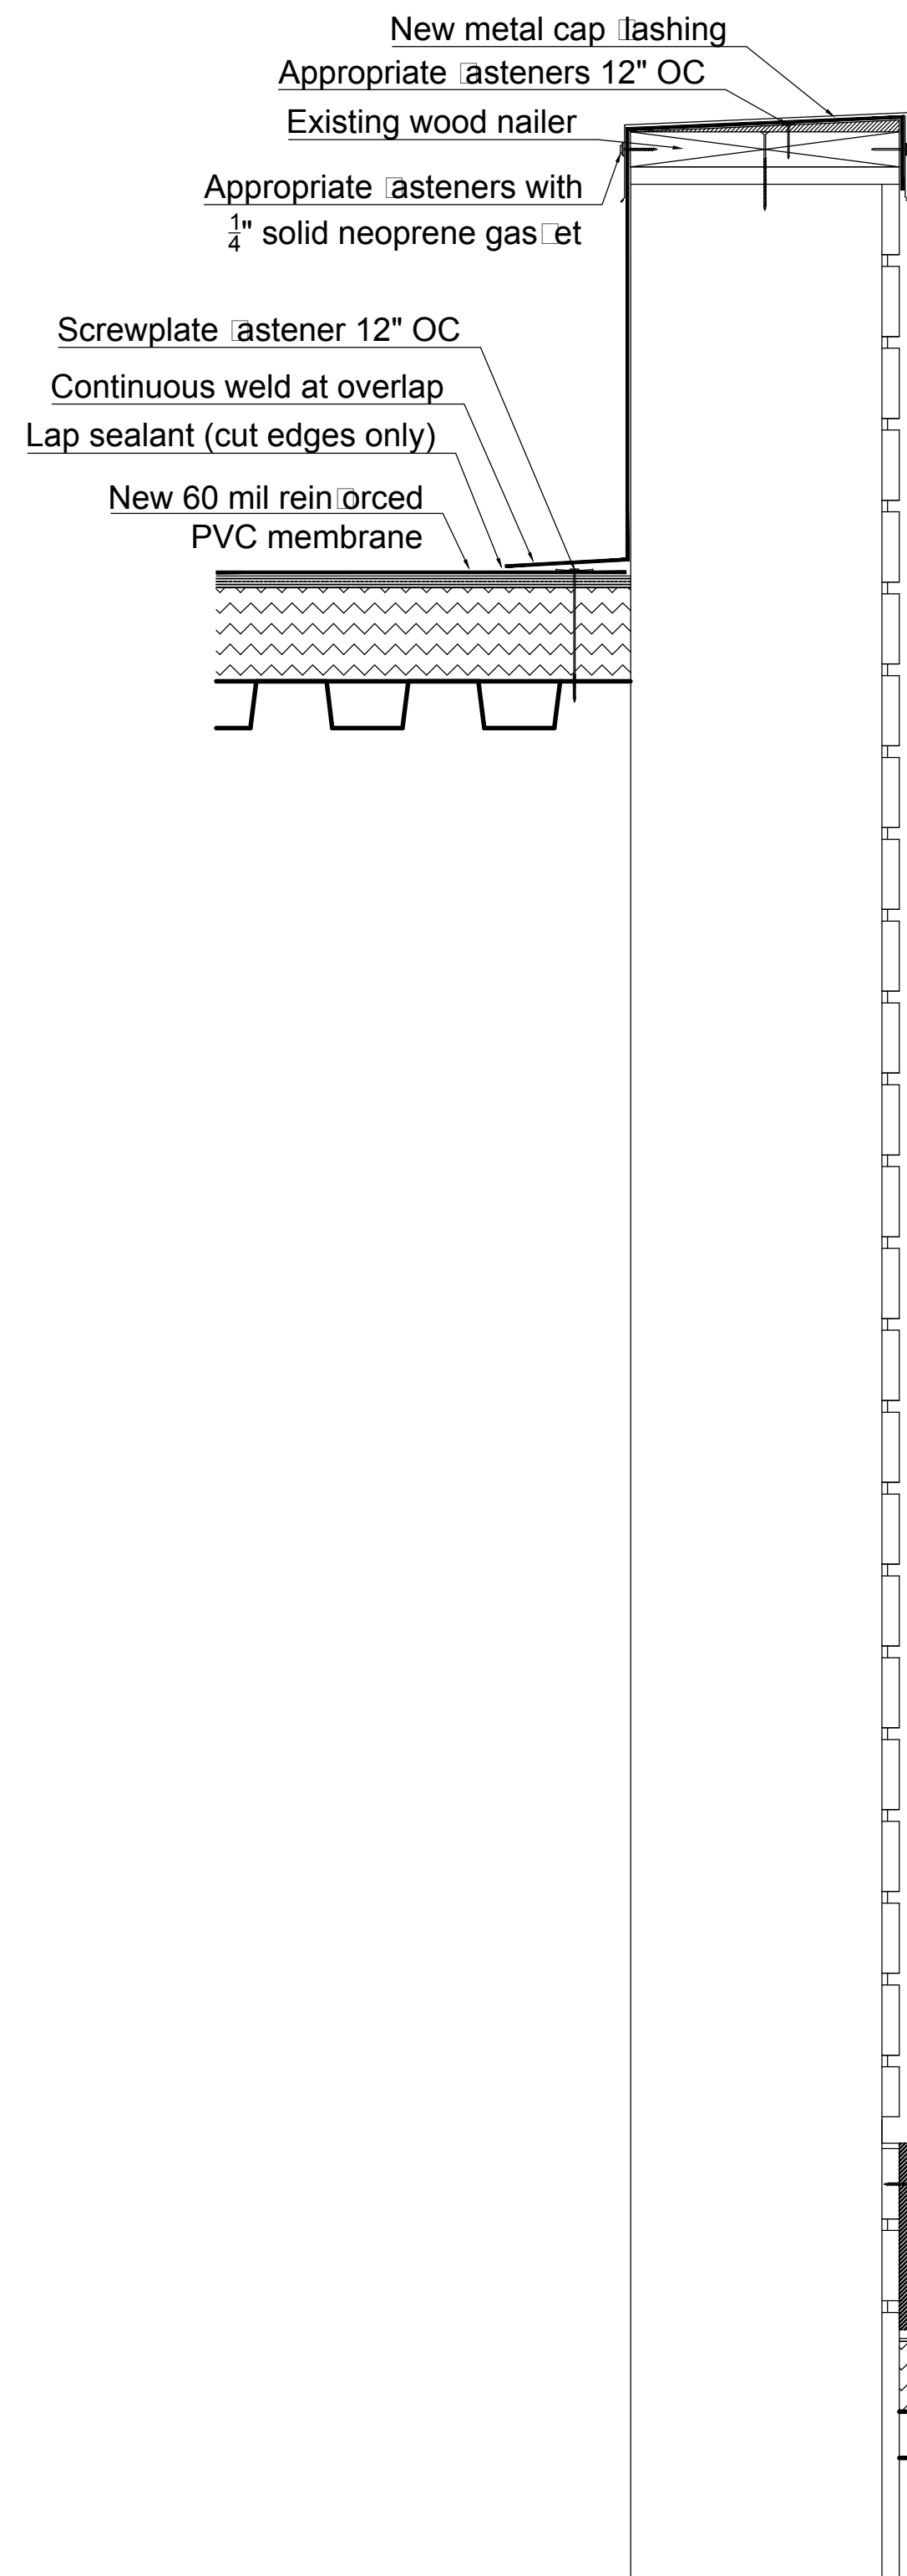


Masonry Wall Detail (Dtl 2/A2)

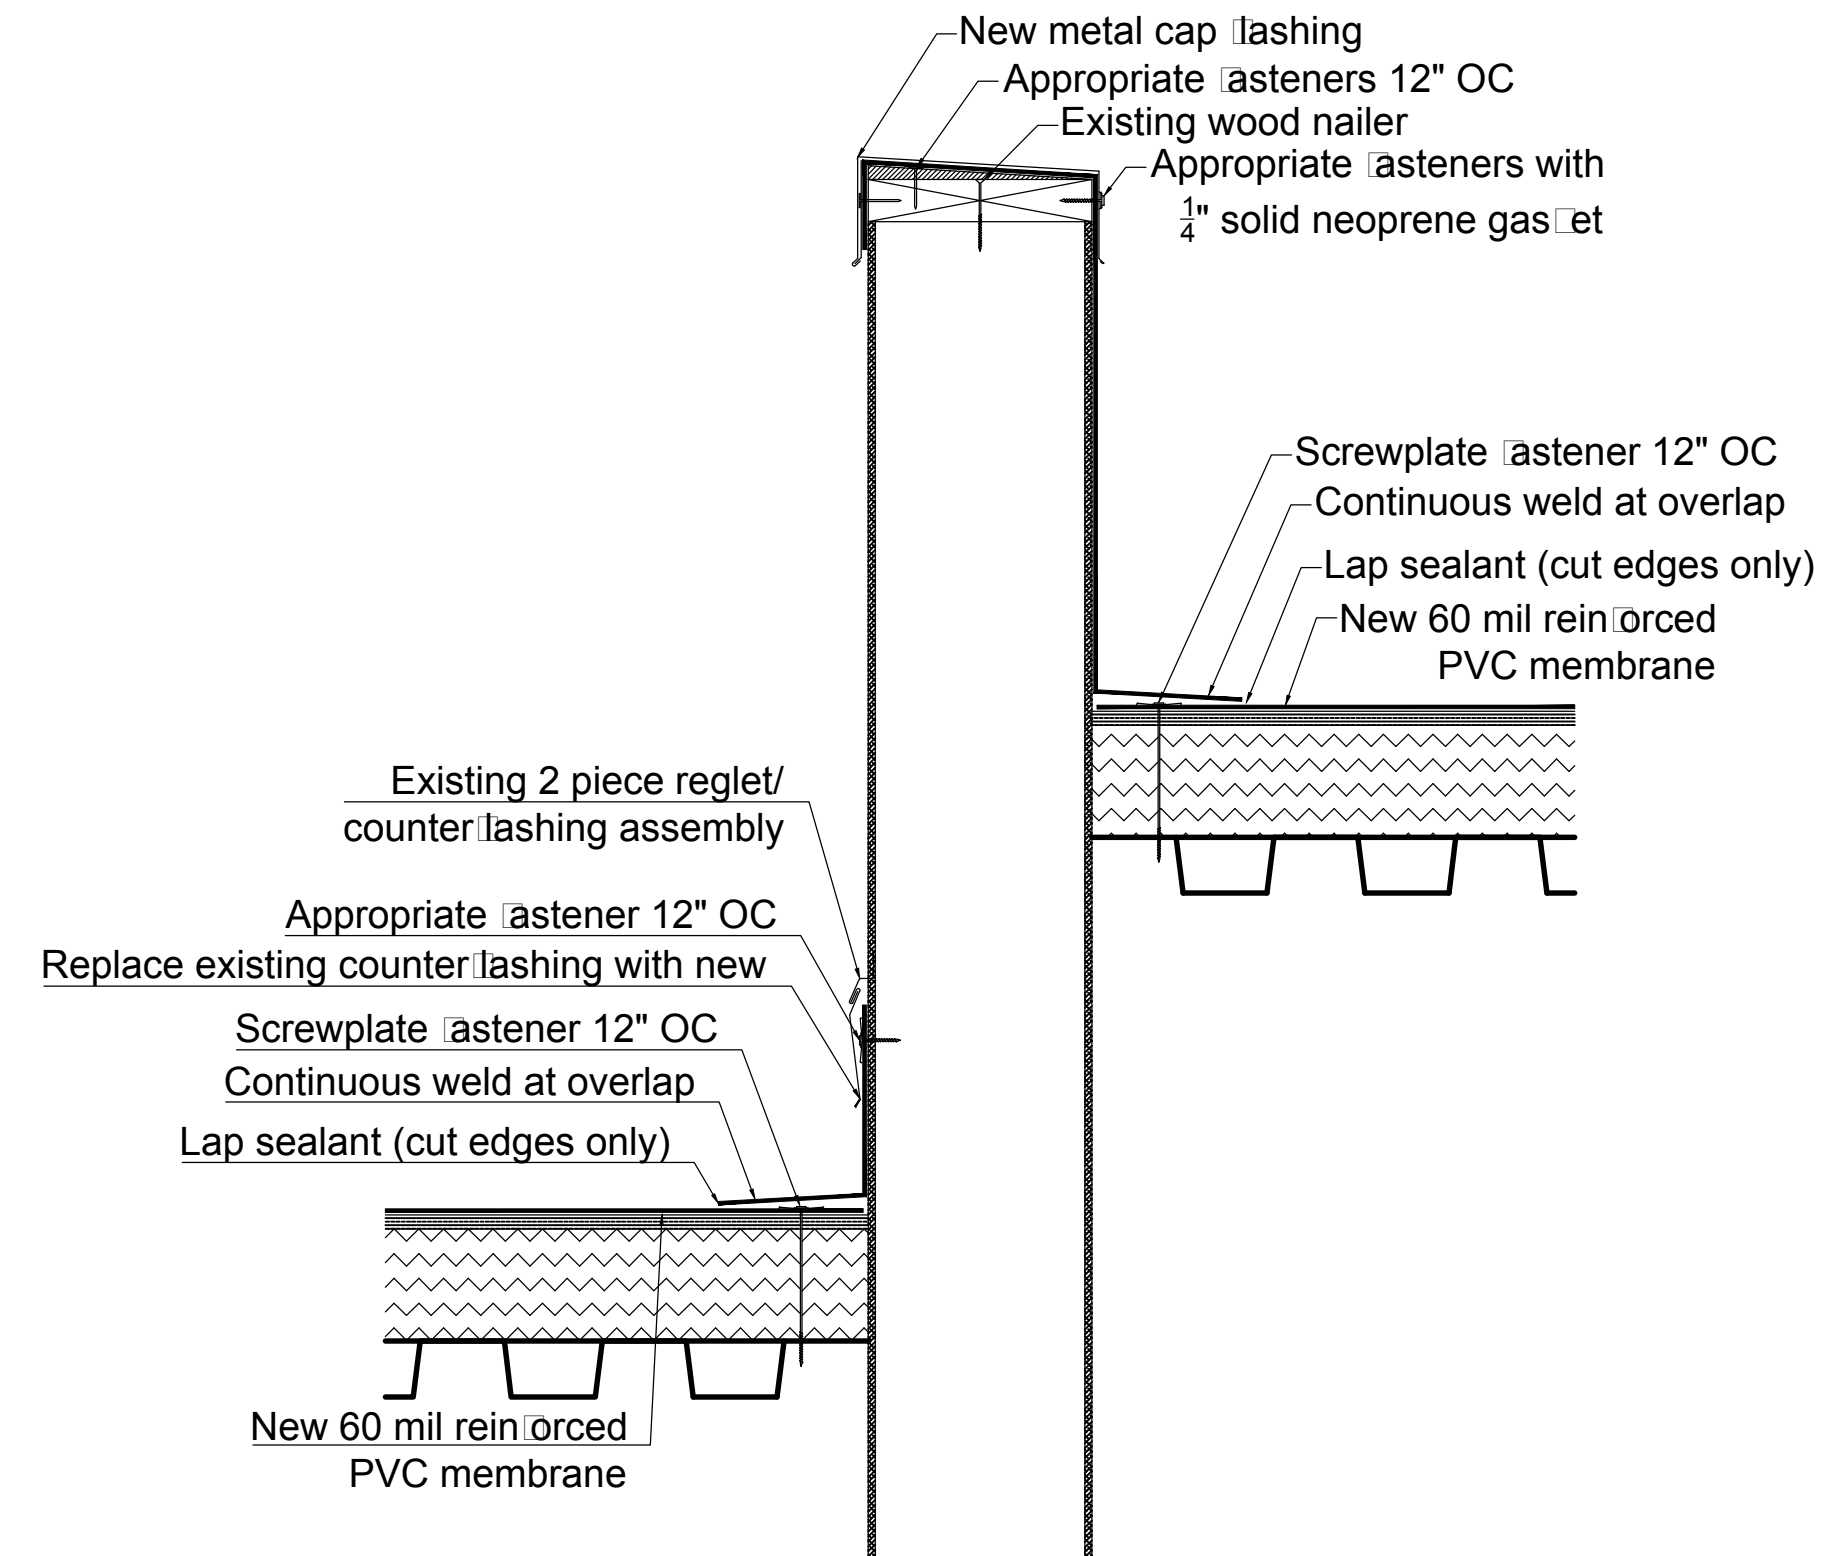

Wall Detail (Dtl 3/A2)

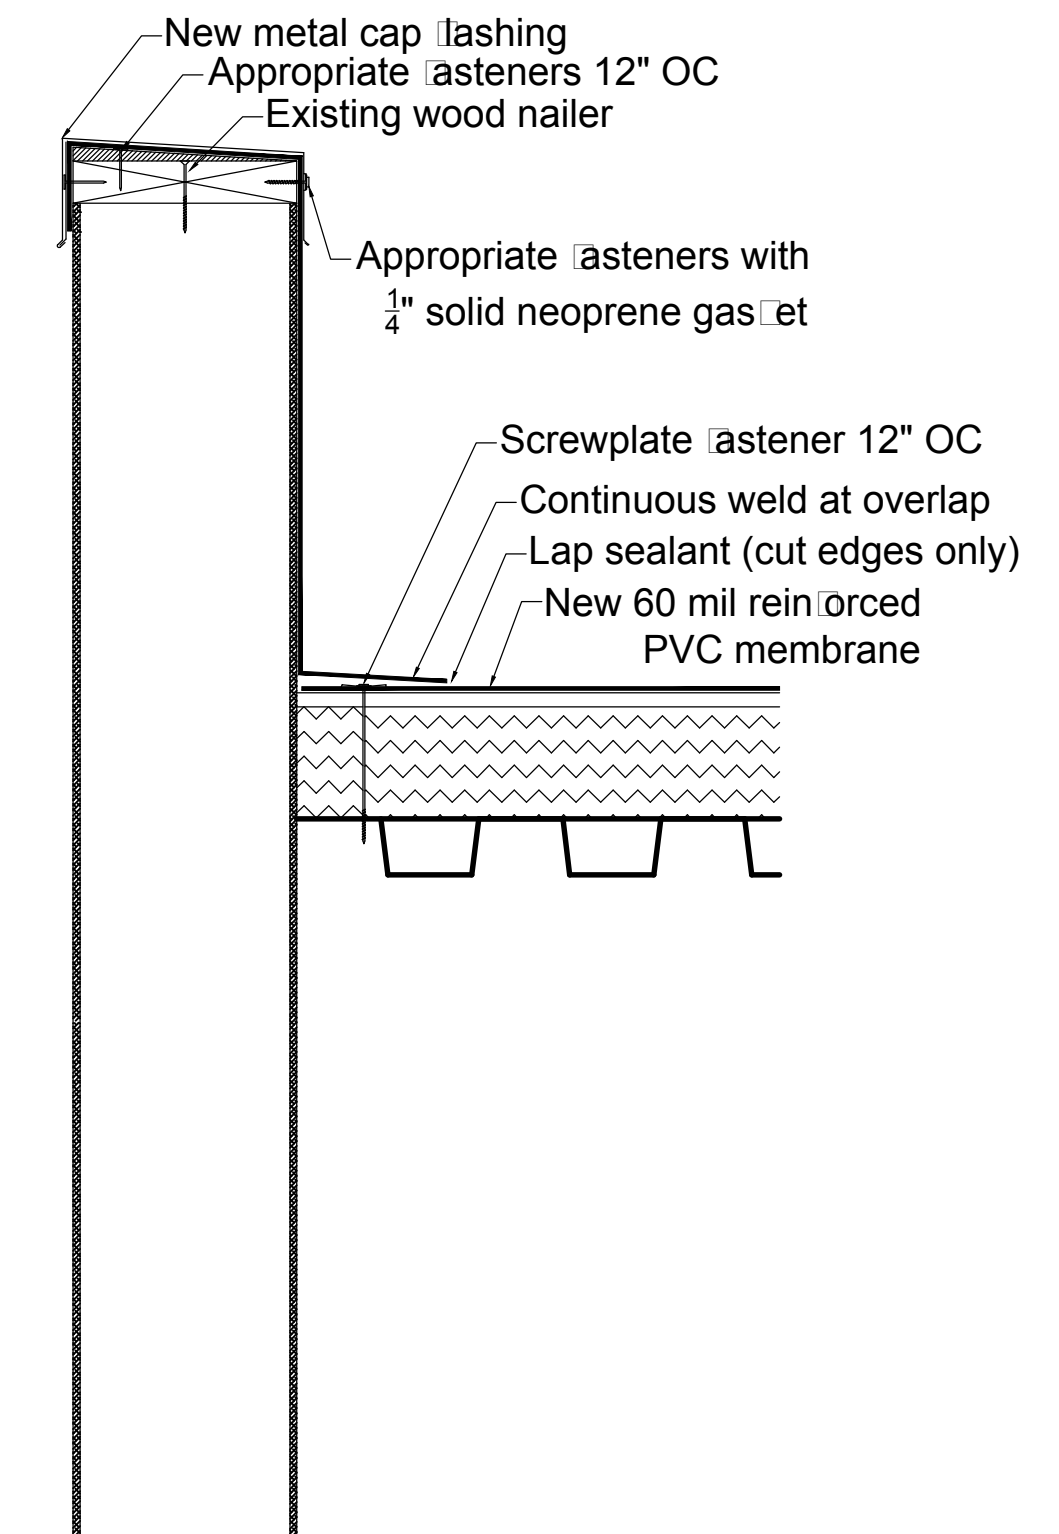

Exterior Wall Detail (Dtl 1/A2)

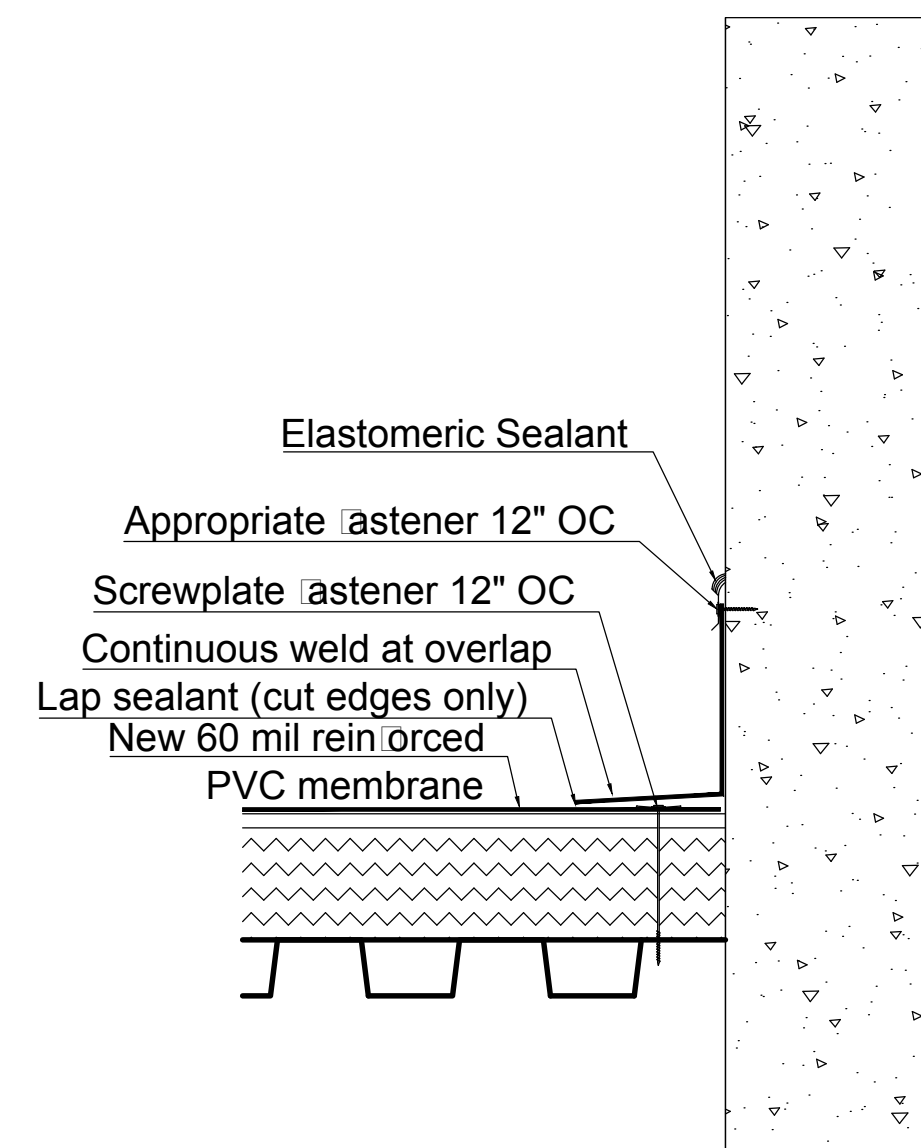

Concrete Wall Detail (Dtl 4/A2)


APPLY UNLESS NOTED ON STRUCTURAL DRAWINGS. IN CASE OF CONFLICT
BETWEEN GSN, DETAILS AND PLANS, THE GREATER REQUIREMENTS
GOVERN.

MECHANICAL LOADS: SEE MECHANICAL DRAWINGS. VERIFY ANY LOADS SHOWN ON STRUCTURAL DRAWINGS WITH MECHANICAL DRAWINGS.

CONTRACTOR SHALL VERIFY IN FIELD ALL EXISTING CONDITIONS SHOWN ON DRAWINGS.



1. VERIFY ANY DIMENSIONS SHOWN WITH ARCHITECTURAL DRAWINGS.
2. MECHANICAL UNITS ARE SHOWN SPECIFICALLY (DUC) PENETRATIONS, UNIT SIZE, ORIENTATION ETC.). SPECIFIC UNITS SHALL BE PURCHASED, BASED ON MECHANICAL SPECIFICATIONS, SUBSEQUENT TO SUBMITTING CONSTRUCTION DOCUMENTS. VERIFICATION THAT THE SPECIFIC MECHANICAL UNIT SIZE, WEIGHT AND LOCATION CONFORMS TO THE SCHEDULE INFORMATION SHOWN IS THE RESPONSIBILITY OF THE CONTRACTOR. COORDINATION OF MECHANICAL UNIT SIZE, WEIGHT AND LOCATION WITH ALL TRADES IS THE RESPONSIBILITY OF THE CONTRACTOR.
3. ALL EXISTING CONDITIONS SHOWN ARE TO BE VERIFIED IN THE FIELD.
4. NEW UNITS ARE TO USE EXISTING SUPPORTS AND ROOF PENETRATIONS WHERE POSSIBLE. PROVIDE NEW SUPPORTS WHERE REQUIRED PER DETAIL 1/53.0. PROVIDE SUPPORTS AT NEW PENETRATIONS AS REQUIRED PER DETAIL 2/53.0.

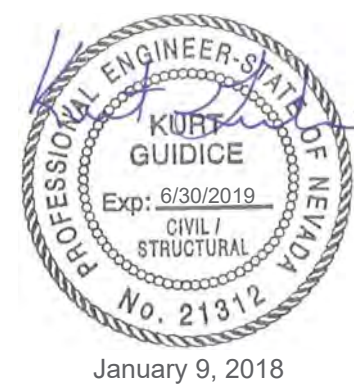

LAS VEGAS SENIOR CENTER HVAC
REPLACEMENT

451 E BONANZA RD
LAS VEGAS, NV 89101



6280 South Valley View Blvd, Suite #411
Las Vegas, Nevada 89118
Phone: (702) 685-0136
Fax: (702) 685-8890
Web: www.hpace-lv.com
Project #: L17138





FIRM #F-12673
303 PEARL PKWY, SUITE 210
SAN ANTONIO, TX 78215
210.646.5500
4425 SOUTH POLARIS AVE.
LAS VEGAS, NV 89103
702.310.8000
WWW.BARKERSTRUCTURAL.COM

ISSUE	DATE	DESCRIPTION
ISSUE DATE:	12.08.2017	
PROJECT NO:	L17138	
CAD DWG FILE:		
DRAWN BY:	TT	
BID NUMBER:	18.691102	
COPYRIGHT:		
© 2017 HPA CONSULTING ENGINEERS		

ROOF FRAMING PLAN

513-45Q

S2.0

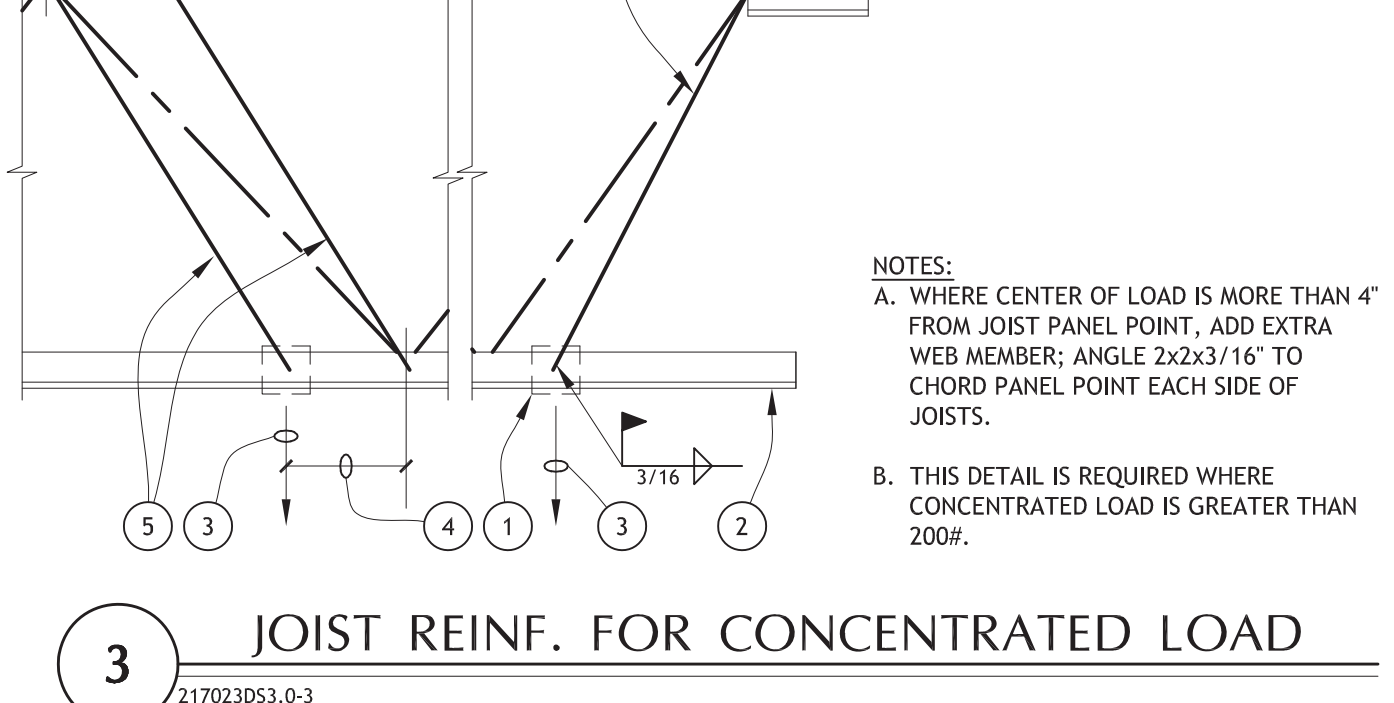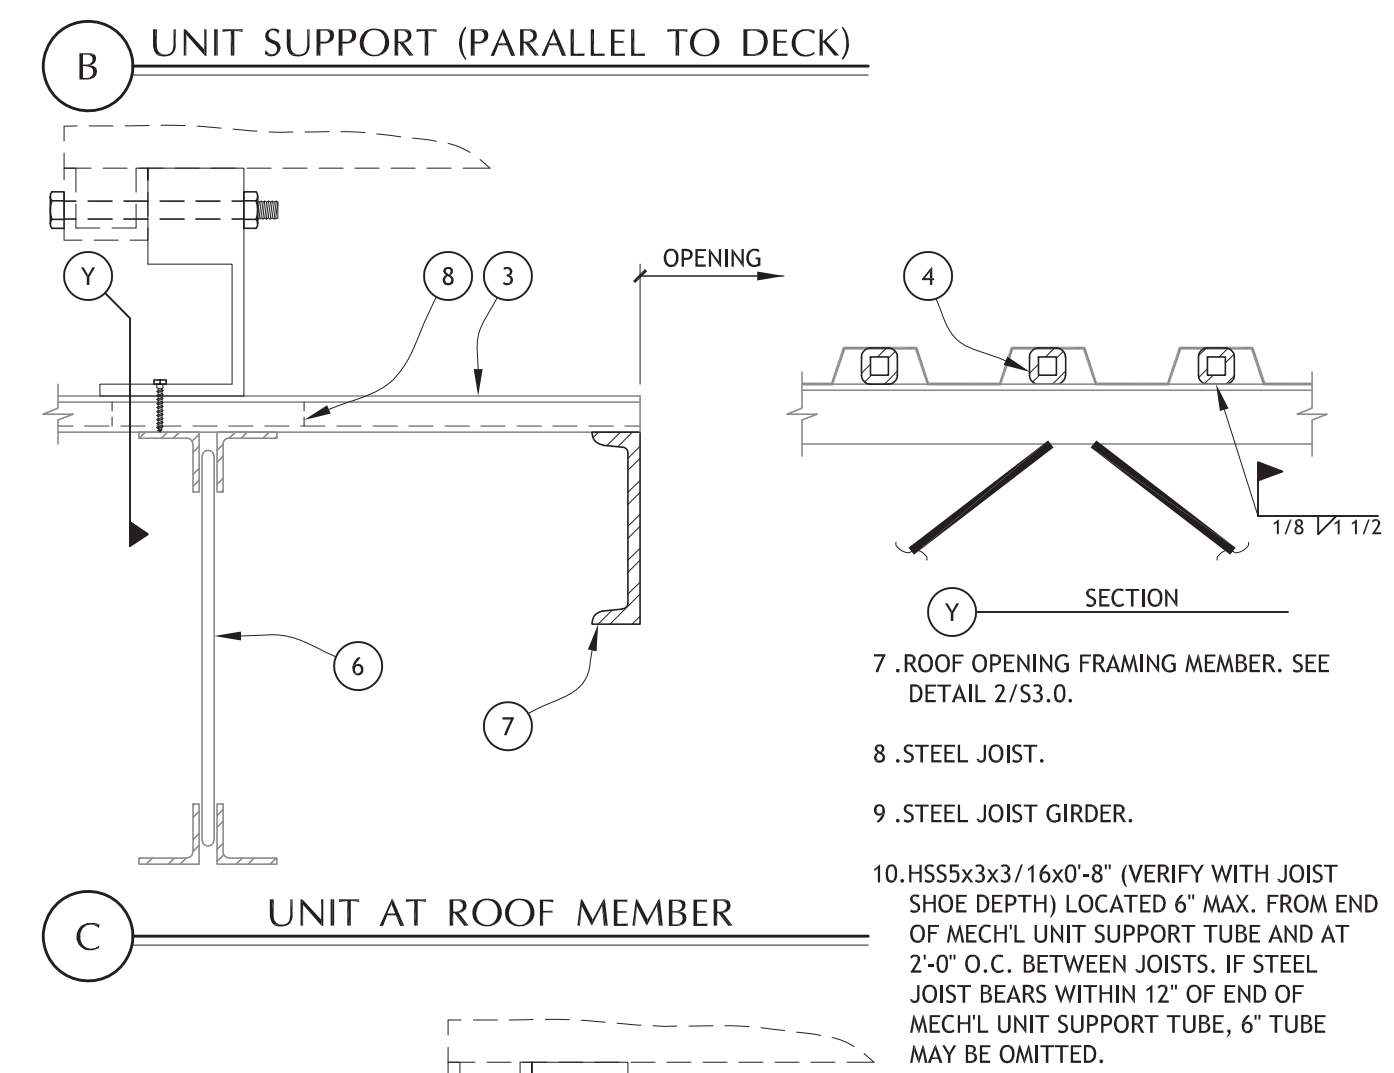

LAS VEGAS SENIOR CENTER HVAC REPLACEMENT

451 E BONANZA RD
LAS VEGAS, NV 89101



6280 South Valley View Blvd, Suite #416
Las Vegas, Nevada 89118
Phone: (702) 685-0136
Fax: (702) 685-8890
Web: www.hpace-lv.com
Project #: *****



ISSUE	DATE	DESCRIPTION
ISSUE DATE:	12.08.2017	
PROJECT NO:	L17138	
CAD DWG FILE:		
DRAWN BY:	TT	
BID NUMBER:	18.6911102	
COPYRIGHT:		
© 2017 HPA CONSULTING ENGINEERS		
SHEET TITLE		

TYPICAL DETAILS

513-45Q

S3.0

MECHANICAL SYMBOLS

(NOT ALL USED IN PROJECT)

	SHEET NOTE		FLOOR DRAIN
	EQUIPMENT ID		ROOF DRAIN
	DIFFUSER TAG		OVERFLOW ROOF DRAIN
	ACCESS DOOR		BALL VALVE
	SUPPLY AIR DUCT DOWN / UP		GAS COCK
	RETURN AIR DUCT DOWN / UP		GATE VALVE
	EXHAUST AIR DUCT DOWN / UP		CHECK VALVE
	SUPPLY DIFFUSER (4 WAY)		THREE-WAY VALVE
	SUPPLY DIFFUSER (3 WAY)		TWO-WAY VALVE
	SUPPLY DIFFUSER (2 WAY)		GLOBE VALVE
	SUPPLY DIFFUSER (2 WAY)		PRESSURE REDUCING VALVE
	SUPPLY DIFFUSER (1 WAY)		HOSE END DRAIN VALVE
	RETURN GRILLE		BUTTERFLY VALVE
	EXHAUST GRILLE		PLUG VALVE
	FLEX DUCT		RELIEF VALVE
	SQUARE TO ROUND TRANSITION (AAXBB SQUARE DUCT DIMENSIONS) (AA" ROUND DUCT DIMENSIONS)		CLEANOUT
	DUCT WITH LINER		FLOOR SINK
	EXISTING DUCT		FLOOR CLEAN OUT
	DUCT TO BE REMOVED		GRADE CLEAN OUT
	MANUAL BALANCE DAMPER		TWO WAY CLEANOUT
	MOTORIZED DAMPER		WATER HAMMER ARRESTOR
	FIRE DAMPER		HOSE BIBB
	SMOKE DAMPER		GAS REGULATOR
	SMOKE/FIRE DAMPER		MANUAL AIR VENT
	SMOKE DETECTOR		THERMOMETER
	THERMOSTAT		Y-STRAINER W/BLOWDOWN
	SENSOR		PIPE DOWN
	HUMIDISTAT		PIPE UP
	CARBON DIOXIDE SENSOR		PRESSURE RELIEF
	GAS METER		TEE UP
	WATER METER		TEE DOWN
	BACKFLOW PREVENTION STATION		CIRCUIT SETTER
	DEMOLITION EXTENT		
	POINT OF CONNECTION		

MECHANICAL LINE TYPES

(NOT ALL USED IN PROJECT)

	4" CHR	CHILLED WATER RETURN PIPING		0" FCW	FILTERED COLD WATER PIPING
	4" CHS	CHILLED WATER SUPPLY PIPING		0" SFW	SOFTENED COLD WATER PIPING
	4" HWR	HEATING WATER RETURN PIPING		0" STM	ROOF DRAIN PIPING
	4" HWS	HEATING WATER SUPPLY PIPING		0" OD	OVERFLOW ROOF DRAIN PIPING
	4" CWR	CONDENSER WATER RETURN PIPING		0" DHW	HOT WATER PIPING
	4" CHS	CONDENSER WATER SUPPLY PIPING		0" 140F	140 F HOT WATER PIPING
	0" SAN	SANITARY SEWER PIPING		0" DHC	HOT WATER RECIRCULATION PIPING
	0" SAN	UNDERGROUND SANITARY SEWER PIPING		0" TW	TEMPERED WATER PIPING
	0" GW	GREASE WASTE PIPING		0" LPG	LOW PRESSURE GAS PIPING
	0" GW	UNDERGROUND GREASE WASTE PIPING		0" MPG	MEDIUM PRESSURE GAS PIPING
	0" V	VENT PIPING		0" AIR	COMPRESSED AIR LINES
	0" CND	CONDENSATE DRAIN PIPING			
	0" D	DRAIN PIPING			
	0" DCW	COLD WATER PIPING			

MECHANICAL ABBREVIATIONS

(NOT ALL USED IN PROJECT)

AABC	AMERICAN BUILDING COUNCIL	LAT	LEAVING AIR TEMPERATURE (F)	WG	WATER GAUGE
AFF	ABOVE FINISHED FLOOR	LBS, #	POUNDS	WMS	WIRE MESH SCREEN
ASHRAE	AMERICAN SOCIETY OF HEATING, REFRIGERATION, AND AIR CONDITIONING ENGINEERS	LWT	LEAVING WATER TEMPERATURE		
ASPE	AMERICAN SOCIETY OF PLUMBING ENGINEERS	MBH	ONE THOUSAND BTUH		
AV	ACID VENT	MCA	MINIMUM CIRCUIT AMPS		
AW	ACID WASTE	MCCP	MAXIMUM OVER CURRENT PROTECTION		
BHP	BRAKE HORSEPOWER	MPG	MEDIUM PRESSURE GAS		
BTUH	BRITISH THERMAL UNIT PER HOUR	N/A	NOT APPLICABLE		
CFH	CUBIC FEET PER HOUR	NC	NORMALLY CLOSED		
CFM	CUBIC FEET PER MINUTE	NEBB	NATIONAL ENVIRONMENTAL BALANCING BUREAU		
CHR	CHILLED WATER RETURN	NEC	NATIONAL ELECTRIC CODE		
CHS	CHILLED WATER SUPPLY	NFPA	NATIONAL FIRE PROTECTION ASSOCIATION		
CND	CONDENSATE DRAIN	NIC	NOT IN CONTRACT		
CO	CLEAN OUT	NO	NORMALLY OPEN		
CR	CONDENSER WATER RETURN	NTS	NOT TO SCALE		
CS	CONDENSER WATER SUPPLY	OA	OUTSIDE AIR		
(D)	EXISTING TO BE DEMOLISHED	OAT	OUTSIDE AIR TEMPERATURE (F)		
D	DRAIN	OBD	OPPOSED BLADE DAMPER		
DB	DRY BULB TEMPERATURE (F)	OD	OVERFLOW ROOF DRAIN		
DOW	DOMESTIC COLD WATER	OFCI	OWNER FURNISHED, CONTRACTOR INSTALLED		
DDC	DIRECT DIGITAL CONTROLS	PD	PRESSURE DROP		
DHC	DOMESTIC HOT WATER RECIRCULATION	PRV	PRESSURE REDUCING VALVE		
DHW	DOMESTIC HOT WATER	PSI	POUNDS PER SQUARE INCH		
DIA	DIAMETER	PSIA	POUNDS PER SQUARE INCH ABSOLUTE		
DX	DIRECT EXPANSION	PSID	POUNDS PER SQUARE INCH DIFFERENTIAL		
(E)	EXISTING TO REMAIN	PSIG	POUNDS PER SQUARE INCH GAUGE		
EA	EXHAUST AIR, EACH	(R)	EXISTING TO BE RELOCATED		
EAT	ENTERING AIR TEMPERATURE (F)	RA	RETURN AIR		
EER	ENERGY EFFICIENCY RATIO	RD	ROOF DRAIN		
EFF	EFFICIENCY	RH	RELATIVE HUMIDITY		
ELEC	ELECTRICAL	RPM	REVOLUTIONS PER MINUTE		
ESP	EXTERNAL STATIC PRESSURE	RPPA	REDUCED PRESSURE PRINCIPAL ASSEMBLY		
EW	ENTERING WATER TEMPERATURE (F)	SA	SUPPLY AIR		
F	DEGREES FAHRENHEIT	SAN	SANITARY SEWER		
FCW	FILTERED COLD WATER	SD	SMOKE DAMPER		
FP	FEET PER MINUTE	SEER	SEASONAL ENERGY EFFICIENCY RATIO		
FW	FILTERED WATER	SF	SMOKE FIRE DAMPER		
G	GAS	SFW	SOFTENED COLD WATER		
GA	GAGE OR GAUGE	SOI	SAND OIL SEPARATOR		
GAL	GALLONS	SP	STATIC PRESSURE		
GCO	GRADE CLEANOUT	SQ.FT.	SQUARE FEET		
GI	GREASE INTERCEPTOR	SS	STAINLESS STEEL		
GPF	GALLONS PER FLUSH	STM	STORM DRAIN		
GPH	GALLONS PER HOUR	T	TEMPERATURE		
GPM	GALLONS PER MINUTE	TAB	TEST AND BALANCE		
GW	GREASE WASTE	TSP	TOTAL STATIC PRESSURE		
HP	HORSEPOWER	TW	TEMPERED WATER		
HPG	HIGH PRESSURE GAS	TYP	TYPICAL		
HSPF	HEATING SEASONAL PERFORMANCE FACTOR	UBC	UNIFORM BUILDING CODE		
HW	HOT WATER	UMC	UNIFORM MECHANICAL CODE		
HWR	HEATING WATER RETURN	UON	UNLESS OTHERWISE NOTED		
HWS	HEATING WATER SUPPLY	UPC	UNIFORM PLUMBING CODE		
IBC	INTERNATIONAL BUILDING CODE	V	VENT		
IE	INVERT ELEVATION	V/PHHZ	VOLTS/PHASE/HERTZ		
IMC	INTERNATIONAL MECHANICAL CODE	V/ HZ	VOLTS/PHASE/HERTZ		
IPC	INTERNATIONAL PLUMBING CODE	VFD	VARIABLE FREQUENCY DRIVE		
KW	KILOWATT	VTR	VENT THROUGH ROOF		
		WB	WET BULB TEMPERATURE		
		WCO	WALL CLEANOUT		

DRAWING INDEX

SHEET NUMBER	SHEET TITLE	PERMIT 12/08/2017	CLARIFICATIONS 08.21.18	OWNER CHANGES 08.23.18
M0.0	MECHANICAL SYMBOLS, ABBREVIATIONS AND DRAWING INDEX	X	X	X
M0.1	MECHANICAL AND PLUMBING SPECIFICATIONS	X		
M0.2	MECHANICAL AND PLUMBING SCHEDULES AND DIAGRAMS	X		
M0.3	IECC COMPLIANCE STATEMENT	X		
MD2.1	MECHANICAL DEMOLITION FLOOR PLAN	X		
M2.1	MECHANICAL FLOOR PLAN	X	X	X
MD2.2	MECHANICAL DEMOLITION ROOF PLAN	X		
M2.2	MECHANICAL ROOF PLAN	X		
MFS-1	MECHANICAL FOOD SERVICE	X		
MFS-2	MECHANICAL FOOD SERVICE	X		
P0.1	NATURAL GAS DIAGRAM	X		
PD2.2	PLUMBING DEMOLITION ROOF PLAN	X		
P2.1	PLUMBING FLOOR PLAN	X		
P2.2	PLUMBING ROOF PLAN	X		
TOTAL		14	2	2

LAS VEGAS SENIOR CENTER HVAC REPLACEMENT

451 E BONANZA RD
LAS VEGAS, NV 89101



6305 South Valley View Blvd, Suite #410
Las Vegas, Nevada 89118
Phone: (702) 855-4138
Fax: (702) 855-4889
Web: www.hpacen.com
Project #: L17138

CONSULTANTS		
2	08.29.18	OWNER CHANGES
1	08.21.18	CLARIFICATIONS
ISSUE	DATE	DESCRIPTION
ISSUE DATE:	12/08/2017	
PROJECT NO:	L17138	
CAD DWG FILE:	MECHANICAL SYMBOLS, ABBREVIATIONS AND DRAWING INDEX.DWG	
DRAWN BY:	HPA	
BID NUMBER:	18.69111.02	
COPYRIGHT:	© 2017 HPA CONSULTING ENGINEERS	
SHEET TITLE		

MECHANICAL SYMBOLS, ABBREVIATIONS AND DRAWING INDEX

513-45Q

M0.0

SHEET - OF -

MECHANICAL AND PLUMBING SPECIFICATIONS		
GENERAL PROVISIONS 1. THE MECHANICAL CONTRACTOR SHALL PROVIDE THE WORK SHOWN ON THE PLANS: A. "PROVIDE" SHALL BE DEFINED AS INSTALL, MAKE ALL FINAL CONNECTIONS, AND TURNOVER TO THE OWNER AN APPROVED FULLY FUNCTIONING AND OPERATIONAL SYSTEM. B. "WORK" SHALL INDICATE ALL MATERIALS, LABOR, TRANSPORTATION, EQUIPMENTS, TOOLS, SUPERVISION, AND ANY OTHER SERVICES AND/OR MATERIALS REQUIRED FOR THE INSTALLATION AND PROPER OPERATION OF THE ENTIRE SYSTEM. 2. ALL WORK SHALL BE PERFORMED IN COMPLIANCE WITH THE LATEST EDITIONS OF THE ADOPTED CODES AS IDENTIFIED BY THE AUTHORITY HAVING JURISDICTION. 3. PRIOR TO INSTALLATION, THE MECHANICAL CONTRACTOR SHALL CAREFULLY EXAMINE ALL CONSTRUCTION DOCUMENTS AND COORDINATE THE WORK WITH ALL OTHER TRADES. THE MECHANICAL CONTRACTOR SHALL BE RESPONSIBLE FOR ENSURING THAT THE WORK FITS INTO THE BUILDING AS SHOWN WITH REASONABLE EXCEPTIONS TO THE LAYOUT AS REQUIRED TO AVOID INTERFERENCE WITH OTHER TRADES. CONTRACTOR IS TO MAINTAIN ACCURATE AS BUILT SET AND DOCUMENT ALL EXCEPTIONS AND MODIFICATIONS TO THE PLANS. 4. CONSTRUCTION DOCUMENTS PROVIDED ARE DIAGRAMMATIC IN NATURE AND INDICATE THE SIZE, TYPE, CONFIGURATION, AND LOCATIONS OF THE WORK. ALL COMPONENTS OF THE SYSTEM MAY NOT BE SHOWN. CONTRACTOR IS RESPONSIBLE FOR ENSURING ALL COMPONENTS ARE PROVIDED AND INSTALLED TO COMPLETE THE WORK ACCORDING TO INDUSTRY STANDARDS. A. DO NOT SCALE DRAWINGS. B. CONTRACTOR TO INSTALL THE WORK REASONABLY PLUMB TO BUILDING CONSTRUCTION AND MAY REQUIRE ALTERNATE ROUTING BASED ON UNFORESEEN FIELD CONDITIONS. 6. IDENTICAL ITEMS SHOWN ON PLANS SHALL BE PROVIDED THOUGH EACH SIMILAR ITEM MAY NOT BE DETAILED. 7. THE CONTRACTOR IS TO CONFIRM AND FIELD VERIFY ALL EXISTING CONDITIONS PRIOR TO PERFORMING WORK. ANY VARIATIONS FROM THE CONTRACT DOCUMENTS SHOULD BE COMMUNICATED TO THE ENGINEER FOR REVIEW. 8. WORK IS INDICATED NEW UNLESS NOTED OTHERWISE. 9. THE CONTRACTOR, PRIOR TO BIDDING, SHALL VISIT THE SITE AND NOTE THE EXISTING CONDITIONS. WORK SHOWN ON CONTRACT DOCUMENTS SHALL BE EVALUATED IN RELATION TO THE EXISTING CONDITIONS. ANY DEVIATION SHALL BE NOTED AND IN WRITING. NOTIFY THE ENGINEER OF SUCH DIFFERENCES. NO CHANGE ORDERS WILL BE ALLOWED DUE TO UNFAMILIARITY OF EXISTING CONDITIONS BY THE CONTRACTOR. A. THE CONTRACTOR PROPOSAL SHOULD BE BASED ON THE MANUFACTURERS OR AS APPROVED EQUALS AS LISTED ON THE PLANS. SUBMITTALS 1. CONTRACTOR TO SUBMIT ELECTRONIC COPY (OR AS REQUIRED BY OWNER/OWNER'S REPRESENTATIVE) OF SHOP DRAWINGS (OR ELECTRONIC VERSION IF APPROVED BY OWNER/ARCHITECT) INCLUDING TECHNICAL PERFORMANCE DATA FOR ALL HVAC EQUIPMENT AND ACCESSORIES AS IDENTIFIED ON THE PLANS TO THE ENGINEER FOR REVIEW. COMPLIANCE OR NON-COMPLIANCE WITH CONTRACT DOCUMENTS WILL BE NOTED AND RETURNED BACK TO OWNER PRIOR TO BEGINNING WORK. THE CONTRACTOR WILL BE RESPONSIBLE FOR ADDITIONAL ENGINEERING FEES ASSOCIATED WITH PERMIT DOCUMENT MODIFICATIONS BASED ON EQUIPMENT SUBSTITUTIONS. 2. ANY AND ALL SUBSTITUTIONS SHALL BE SUBMITTED IN ACCORDANCE WITH 016000 "PRODUCT REQUIREMENTS" TO THE ENGINEER FOR APPROVAL. THE OWNER/OWNER'S REPRESENTATIVE SHALL PRELIMINARILY APPROVE THE SUBSTITUTION PROPOSED IN WRITING. A. IT IS THE RESPONSIBILITY OF THE CONTRACTOR TO PROVIDE THE BURDEN OF PROOF OF EQUAL IN THE SUBMITTAL WITH PERFORMANCE, SPECIFICATIONS, DIMENSIONS, WEIGHTS, ELECTRICAL REQUIREMENTS AS APPLICABLE, WITH ALL ITEMS CLEARLY IDENTIFIED AND IS TO COORDINATE THE CHANGE WITH ALL OTHER TRADES AND FIELD CONDITIONS. B. CONTRACTOR SHALL ALSO IDENTIFY ALL COST DEBITS OR CREDITS IN WRITING TO EVALUATE THE PROPOSED SUBSTITUTION AS IT RELATES TO THE OTHER TRADES. C. FINAL DETERMINATION OF AN OR EQUAL IS ENTIRELY BASED ON ENGINEERS EVALUATION OF THE INFORMATION INCLUDED IN THE SUBMITTAL. 3. AT THE CONCLUSION OF THE PROJECT, THE CONTRACTOR SHALL PROVIDE MINIMUM THREE (OR AS REQUIRED BY OWNER/OWNER'S REPRESENTATIVE) COPIES OF AS-BUILT DOCUMENTS. 4. CONTRACTOR TO SUBMIT SHOP DRAWINGS OF TEMPERATURE CONTROL SYSTEM DRAWINGS SHOWING DEVICES PROPOSED FOR USE, LOCATION OF DEVICES, WIRING, SEQUENCE OF OPERATIONS, SCREENSHOTS OF USER INTERFACE SCREENS, AND NETWORK DIAGRAMS. WARRANTY 1. ALL MATERIALS AND INSTALLATION SHALL BE GUARANTEED FOR A MINIMUM OF ONE YEAR FROM TURNOVER DATE TO OWNER AS ACCEPTED, WITH THE FOLLOWING EXCEPTION. A. REFRIGERATION COMPRESSORS - FIVE YEAR WARRANTY. 2. THE CONTRACTOR SHALL GUARANTEE THAT THE INSTALLATION WILL MEET OR EXCEED ALL PERFORMANCE REQUIREMENTS AS OUTLINED IN THE CONTRACT DOCUMENTS AS OPERATED BY THE OWNER IN ACCORDANCE WITH CONTRACTOR INSTRUCTIONS. A. IN THE EVENT THAT THE SYSTEMS DO NOT MEET THE REQUIREMENTS OF THE CONTRACT DOCUMENTS, THE CONTRACTOR SHALL REMEDY THE SITUATION AT NO COST TO THE OWNER AND WITHOUT DELAY TO RECTIFY THE PROBLEM AND SATISFY THE REQUIREMENTS OF THE CONTRACT DOCUMENTS. PLUMBING PRODUCTS 1. EQUIPMENT A. PROVIDED AS SPECIFIED AND/OR SCHEDULED AND IS TO BE INSTALLED PER APPLICABLE BUILDINGS CODES AND MANUFACTURER'S RECOMMENDATIONS. UNIT IS TO BE INSTALLED PER MANUFACTURER'S OPERATION AND MAINTENANCE MANUAL AND CONFORMING TO THE ONE YEAR WARRANTY. B. PLUMBING FIXTURES TO COMPLY WITH ADOPTED WATER CONSERVATION CODES AND LOCAL JURISDICTION REGULATIONS. 2. DOMESTIC WATER A. BELOW GROUND - TYPE "K" (ASTM B-88), WROUGHT FITTINGS (ASME B16.22), HARD DRAWN, WITH AWS AS 8, 8C/UP SILVER BRAZE JOINTS. B. ABOVE GROUND - TYPE "L" (ASTM B-88), WROUGHT FITTINGS (ASME B16.22), WITH SOLDER, MAX LEAD 0.2%, GRADE 95 TA, ANSI/ASTM B32 JOINTS. 3. PIPE HANGERS A. FOR PIPE SIZES TO 1-1/2", MALLEABLE IRON, CARBON STEEL, SPLIT RING, ADJUSTABLE SWIVEL. B. FOR PIPE SIZES 2" TO 4", ADJUSTABLE, CLEVIS, CARBON STEEL. C. FOR PIPE SIZES 6" AND LARGER, CAST IRON ROLL, DOUBLE HANGER, ADJUSTABLE STEEL YOKE. 6. PIPE INSULATION A. 1" THICK FIBERGLASS WITH ALL SERVICE JACKET, MAXIMUM K VALUE OF 0.27 AT 75 F. B. MINIMUM 3/4" THICK CLOSED CELL NEOPRENE MAY BE USED WHERE CLEARANCE LIMITS INHIBIT THE USE OF 1" FIBERGLASS. C. PROVIDE INSULATION FOR ALL DOMESTIC HOT WATER AND DOMESTIC HOT WATER RETURN PIPING ABOVE GRADE. D. PROVIDE INSULATION FOR ALL DOMESTIC COLD WATER PIPING IN UNCONDITIONED SPACES ONLY. E. PROVIDE INSULATION FOR ALL CONDENSATE PIPING. F. PROVIDE 15" OF INSULATION FOR ALL ROOF DRAINS AND OVERFLOW ROOF DRAINS. 7. GAS PIPING A. BELOW GRADE - POLYETHYLENE WITH BUTT FUSION JOINTS. B. ABOVE GRADE - BLACK IRON SCHEDULE 40 WITH GALVANIZED FITTINGS AND PIPE WITH JOINT COMPOUND (EXPOSED) OR THREADED MALLEABLE FITTINGS (CONCEALED). C. PROVIDE NON-LUBRICATED, TEFLON PACKING, BRONZE TAPERED PLUG, BRONZE BODY VALVES WITH THREADED ENDS. D. PROVIDE PIPE LABELS WITH GAS PRESSURE SERVICE RATINGS - GAS, 2 PSI GAS, 5 PSI GAS, 10 PSI GAS, ETC. E. PROVIDE EQUIPMENT ISOLATION VALVES. F. PROVIDE UNION, DIRT LEG AND GAS COCK FOR ALL EQUIPMENT CONNECTION. 8. CONDENSATE DRAIN A. TYPE M COPPER (ASTM B-88). B. WROUGHT FITTINGS (ASME B16.22). C. SOLDER JOINTS - GRADE 95 TA, 0.2% MAX LEAD CONTENT, ANSI/ASTM B32. MECHANICAL PRODUCTS 1. EQUIPMENT A. PROVIDED AS SPECIFIED AND/OR SCHEDULED AND IS TO BE INSTALLED PER APPLICABLE BUILDINGS CODES AND MANUFACTURER'S RECOMMENDATIONS. UNIT IS TO BE INSTALLED PER MANUFACTURER'S OPERATION AND MAINTENANCE MANUAL AND IN PROPER OPERATING CONDITION PRIOR TO PERFORMING TEST AND BALANCE PROCEDURES. 2. DUCT WORK A. GALVANIZED SHEET METAL IN ACCORDANCE WITH ASTM A90, SMACNA CONSTRUCTION STANDARDS, AND ASHRAE RECOMMENDATIONS. B. MECHANICAL DUCTWORK IS TO BE SEALED AT ALL PENETRATIONS THROUGH BUILDING CONSTRUCTION AND SUPPORTED AND SEALED PER SMACNA STANDARDS FOR RIGID DUCTWORK. C. ALL PLANS SHOW MINIMUM CLEAR INSIDE DIMENSIONS. D. VISIBLE PORTIONS OF INTERIOR DUCTWORK SHALL BE PAINTED BLACK OR AS PER ARCHITECTURAL REQUIREMENTS. E. SUPPLY DUCT CLASSIFICATION 2 PRESSURE CLASS. F. RETURN AND EXHAUST DUCT CLASSIFICATION 1 PRESSURE CLASS. G. FLEXIBLE DUCTS WHERE INDICATED ON THE PLANS, SHALL BE INSULATED AND PROVIDED WITH VAPOR BARRIER ON THE INTERIOR AND EXTERIOR, AND REINFORCED WITH STEEL WIRE. JOINTS TO BE BAND CLAMPED AND SEALED WITH TAPE FOR VAPOR BARRIER INTEGRITY. INSULATION TO HAVE MAXIMUM 0.23 K VALUE AT 75 F. FLEXIBLE DUCT TO BE INSTALLED WITH ADEQUATE SUPPORT TO ELIMINATE SAGS. H. MANUAL BALANCE DAMPERS FOR AIR BALANCING ARE TO BE PROVIDED AT EACH BRANCH DUCT OR AIR DEVICE UNLESS OTHERWISE NOTED. PROVIDE LOCKING QUADRANTS AND DAMPER HANDLE IDENTIFICATION. 3. DUCT INSULATION A. SUPPLY AND RETURN DUCTWORK IS TO BE EXTERNALLY WRAPPED WITH MINIMUM 1-1/2" FLEXIBLE GLASS FIBER WITH MAXIMUM K VALUE OF 0.29 AT 75 F AND SHALL HAVE A FLAME RESISTANT VAPOR BARRIER AT 0.75 LBS/CUBIC FOOT DENSITY. B. EXHAUST DUCTS AND BUILDING NEUTRAL OUTSIDE AIR DUCTS ARE NOT INSULATED. C. SUPPLY AND RETURN DUCTWORK WITHIN 20' OF FAN INLETS AND DISCHARGES ARE TO BE INTERNALLY LINED FOR ACOUSTICAL REDUCTIONS WITH 1" THICK, 1-1/2 LB DENSITY DUCT LINER. LINING SHALL BE APPLIED WITH FIRE RESISTANT ADHESIVES AND CADMIUM OR COPPER FASTENERS. D. DISHWASHER OR GREASE EXHAUST HOOD DUCTWORK SHALL NOT BE LINED. E. MINIMUM R-6 FOR DUCTS IN UNCONDITIONED SPACES AND R-8 FOR DUCTS INSTALLED OUTDOORS, PER IECC 2009. 4. AIR DEVICES A. MAXIMUM NOISE CRITERIA (NC) SHALL NOT EXCEED VALUES LISTED IN AIR DEVICE SCHEDULE. B. APPROVED MANUFACTURERS - TITUS, KRUEGER, NALOR, PRICE, J&J, METAL AIRE, OR APPROVED EQUAL. 5. DUCT MOUNTED SMOKE DETECTORS A. INSTALLED BY THE MECHANICAL CONTRACTOR AND FURNISHED BY THE ELECTRICAL CONTRACTOR WHEN A DESIGN BUILD FIRE ALARM SYSTEM IS REQUIRED. B. FURNISHED AND INSTALLED BY THE MECHANICAL CONTRACTOR WHEN NOT A PART OF THE DESIGN BUILD FIRE ALARM SYSTEM PACKAGE. C. PROVIDE AT 24VAC. D. DUCT DETECTORS SHALL SHUT DOWN THE ASSOCIATED AIR MOVING EQUIPMENT AND ANY OTHER ASSOCIATED UNITS WHEN TOTAL SUPPLY CFM IS 2000 OR GREATER. 6. KITCHEN HOOD EXHAUST DUCT SHALL MEET THE FOLLOWING: A. MINIMUM 16 GAGE CARBON STEEL. B. CONTINUOUS EXTERNALLY WELDED JOINTS SHALL BE PROVIDED. C. FABRICATE TO MEET LOCALLY ADOPTED MECHANICAL CODE, ASTM A569, AND SMACNA STANDARDS. 7. PACKAGED ROOFTOP UNIT - ELECTRIC, GAS/PAK, HEAT PUMP A. PROVIDE COMPLETE ROOFTOP UNIT WITH COILS, AIR COOLED CONDENSER, HERMETICALLY SEALED COMPRESSOR, HEATING SECTION (AS APPLICABLE), EVAPORATOR FAN, CONDENSER FAN, AND 2 SETS OF 1" THROWAWAY PLEATED 30" FILTERS, MANUAL OUTSIDE AIR DAMPER, AND ITEMS AS SCHEDULED AND ALL NECESSARY ACCESSORIES REQUIRED FOR PROPER OPERATION. B. ACCEPTABLE MANUFACTURERS - LENNOX, CARRIER, OR APPROVED EQUAL. C. PROVIDE AUTOMATIC CONTROLS - 7 DAY PROGRAMMABLE THERMOSTAT WITH AUTO HEAT/COOL CHANGEOVER AND FAN AUTO/MANUAL OPERATION. D. PROVIDE ALL CONDUIT, WIRING, TRANSFORMERS, AND RELAYS. E. PROVIDE COMPRESSOR HIGH AND LOW PRESSURE CUT-OFFS. F. PROVIDE CONTROL PANEL WITH STARTERS, DISCONNECT SWITCH, AND RELAYS FOR SINGLE POINT POWER CONNECTION. G. PROVIDE COMPLETELY FACTORY WIRED TERMINAL CONNECTIONS FOR THERMOSTAT CONTROL. 8. FANS A. PROVIDE FORWARD CURVED DIRECT OR BELT DRIVEN STEEL FAN DYNAMICALLY BALANCED WITH VARIABLE OR ADJUSTABLE PITCH MOTOR SHEAVES. B. PROVIDE ACCESSORIES AS OUTLINED IN PLANS AND ANY OTHER REQUIRED COMPONENT TO ENSURE PROPER OPERATION. C. BACK DRAFT DAMPER TO BE STEEL OR CAST IRON. D. ACCEPTABLE MANUFACTURERS - GREENHECK, COOK, TWIN CITIES, OR APPROVED EQUAL. TEST AND BALANCE 1. BALANCE ALL DIFFUSERS AND GRILLES TO OBTAIN THE AIRFLOWS SHOWN ON THE HVAC FLOOR PLANS. 2. THE TEST AND BALANCE (TAB) REPORT SHALL CONTAIN ALL DESIGN AIRFLOW QUANTITIES, ACTUAL AIRFLOW QUANTITIES, SUPPLY AIR TEMPERATURES, EQUIPMENT DESIGN POWER, EQUIPMENT ACTUAL POWER, EQUIPMENT CURRENT DRAW, OUTSIDE AIR QUANTITIES AS APPLICABLE. 3. TEST AND BALANCE WORK SHALL BE DONE BY A CERTIFIED NEBB OR AABC, INDEPENDENT CONTRACTOR. 4. PROVIDE OWNER/OWNER'S REPRESENTATIVE WITH THREE COPIES OF THE FINAL REPORT. AUTOMATIC TEMPERATURE CONTROLS 1. MECHANICAL CONTRACTOR TO PROVIDE A COMPLETE AUTOMATIC TEMPERATURE CONTROL SYSTEM AS OUTLINED BELOW, BUT NOT LIMITED TO: A. 7 DAY PROGRAMMABLE THERMOSTAT WITH AUTO HEAT/COOL CHANGEOVER AND FAN AUTO/MANUAL OPERATION. PROVIDE ALL JUNCTION BOXES, CONDUIT, WIRE, CIRCUIT BREAKERS, SENSOR BACK BOXES, AND ANY OTHER ACCESSORY REQUIRED TO INSTALL A COMPLETE SYSTEM, IN ACCORDANCE WITH PROJECT ELECTRICAL SPECIFICATIONS AND NEC. B. FOR ZONING SYSTEM, SENSOR LOCATED PER PLANS ARE TO BE INTERLOCKED WITH CONTROL PANEL. ZONING MOTORIZED DAMPER TO MODULATE OPEN AND CLOSED BASED ON SPACE LOAD CONDITIONS. CONTROL PANEL TO BE PROGRAMMED TO INPUT FEEDBACK FROM SENSORS AND OUTPUT CONTROL COMMANDS TO DEVICES AT THE ZONES. UNIT HEATING AND COOLING FUNCTIONS TO BE CONTROLLED BY THERMOSTAT OR SEPARATE SENSOR LOCATED IN AN AVERAGE SPACE. CONTROL PANEL TO HAVE CAPABILITY OF AVERAGING ALL ZONES TO DETERMINE THE MODE OF THE UNIT-HEAT OR COOL. BYPASS DAMPER TO OPERATE BASED ON LOGIC FROM THE CONTROLLER AND DEPENDENT ON PRESSURE SWITCH. 2. SUBMIT SHOP DRAWINGS SHOWING THE LOCATION OF DEVICES, TEMPERATURE CONTROL WIRING, DEVICE AND COMPONENT DATA SHEETS, AND INSTALLATION DATA FOR REVIEW PRIOR TO PERFORMING WORK. DUCT MOUNTED SMOKE DETECTORS A. SHALL HAVE A DUCT SMOKE TEST, AND WHEN ACTIVATED, IT SHALL INITIATE A VISIBLE AND AUDIBLE SIGNAL (ANNUNCIATOR) IN ADDITION TO THE REQUIREMENT BELOW. 1. PROVIDE WHEN INDIVIDUAL AIR MOVING EQUIPMENT EXCEEDS 2000 CFM. A. IF MULTIPLE UNITS ARE SERVING THE SAME SPACE, THEN EACH UNIT SERVING THE SPACE WILL REQUIRE DUCT MOUNTED SMOKE DETECTORS IF THE AGGREGATE AIRFLOW EXCEEDS 2000 CFM. B. DUCT DETECTORS TO SHUT DOWN THE RESPECTIVE AIR MOVING EQUIPMENT. 2. DUCT MOUNTED SMOKE DETECTORS SHALL BE INSTALLED AND PROVIDED AT 24 VAC BY THE MECHANICAL CONTRACTOR WHEN NOT PART OF THE FIRE ALARM SYSTEM. A. WHEN PART OF A DESIGN BUILD FIRE ALARM SYSTEM, THE MECHANICAL CONTRACTOR SHALL INSTALL THE DUCT MOUNTED SMOKE DETECTORS PROVIDED BY THE ELECTRICAL CONTRACTOR. INSTALLATION 1. CONTRACTOR TO PROVIDE ALL OPENINGS, SLEEVES, CUTTING, PATCHING, AS REQUIRED. ALL WORK TO BE DONE BY SKILLED WORKMAN IN THE APPROPRIATE TRADES REQUIRED AND PAID BY THE CONTRACTOR REQUIRING THE WORK. SLEEVES PENETRATING FIRE RATED CONSTRUCTION SHALL BE APPROPRIATELY FIRE PROOFED WITH APPROVED MATERIAL FOR THE RATING AND UL LISTED. SLEEVES PASSING THROUGH WATER PROOF OR DAMP PROOF ASSEMBLIES ARE TO BE WATER TIGHT. 2. ESCUTCHEON PLATES WITH COLORS AND FINISHES SHALL BE PROVIDED AND COORDINATED WITH ARCHITECT WHERE CONDUIT OR PIPING PASSES THROUGH FLOORS, CEILING, WALLS IN FINISHED AREAS. 3. PROVIDE BASE AND COUNTER FLASHING AND WATER PROOFING FOR EXTERIOR WALL OR ROOF PENETRATIONS. COORDINATE WITH GENERAL CONTRACTOR AND/OR ROOFING CONTRACTOR ANY PROCEDURES, PROVISIONS, MEASURES RELATED TO ROOF WARRANTY, IF APPLICABLE. 4. CONTRACTOR TO PROVIDE HANDLING OF MATERIALS, RIGGING, HANDLING OF EQUIPMENT. A. CONTRACTOR TO PROVIDE PROTECTION OF ALL MATERIALS AND EQUIPMENT AGAINST DAMAGE, DIRT, THEFT, ETC, UNTIL ACCEPTED BY THE OWNER. B. ALL WORK SHALL BE TURNED OVER FULLY FUNCTIONAL, IN NEW CONDITION, AND CLEAN. 5. CONTRACTOR TO PROVIDE ALL EQUIPMENT SUPPORTS REQUIRED WITHIN THEIR SCOPE OF WORK. A. HANGERS, FOUNDATION, AND SUPPORTS. B. EQUIPMENT WITH MOVING PARTS SHALL BE PROVIDED WITH, AS APPLICABLE: FLEXIBLE DUCT CONNECTIONS. FLEXIBLE PIPING CONNECTIONS. VIBRATION ISOLATION. 6. SEISMIC RESTRAINTS A. THE MECHANICAL CONTRACTOR IS TO INCLUDE IN THEIR SCOPE OF WORK, THE DESIGN SERVICES OF A REGISTERED STRUCTURAL ENGINEER TO PRODUCE STAMPED AND SIGNED CONSTRUCTION DOCUMENTS OF MECHANICAL/PLUMBING SYSTEMS SEISMIC RESTRAINT SUPPORTS PER THE APPLICABLE BUILDING CODE. B. SHOP DRAWINGS TO BE SUBMITTED PRIOR TO PERFORMING WORK AND SHALL INCLUDE COORDINATION BETWEEN ALL AFFECTED TRADES. INCLUDED, BUT NOT LIMITED TO, THE FOLLOWING: TYPES OF SEISMIC SUPPORT REQUIRED. SYSTEM SUPPORT REQUIRED. AREAS REQUIRING SUPPORT. DRAWINGS DEPICTING DESIGN AND DETAILS. C. DRAWINGS TO BE SENT TO LOCAL BUILDING DEPARTMENT APPROVAL ANY INSTALLATION WITHOUT THE APPROVAL OF THE LOCAL BUILDING DEPARTMENT IS ENTIRELY AT THE RISK OF THE CONTRACTOR.		

<

7. PIPE HANGERS

A. PIPE SIZES TO 1-1/2": 6'-0" MAXIMUM SPACING WITH 3/8" ROD DIAMETER.

B. PIPE SIZES 2" TO 3": 10'-0" MAXIMUM SPACING WITH 1/2" ROD DIAMETER.

C. PIPE SIZES 4" TO 6": 10'-0" MAXIMUM SPACING WITH 5/8" ROD DIAMETER.

8. PLUMBING

A. CLEAN OUTS TO BE PROVIDED IN DRAIN, SANITARY, WASTE AS SHOWN AND AS REQUIRED BY LOCAL PLUMBING CODE AND AMENDMENTS.

B. ON ALL INDIRECT WASTE PIPING BETWEEN 5 TO 15 FEET IN TOTAL DEVELOPED LENGTH, PROVIDE A NON-VENTED TRAP.

C. CLEANOUTS TO BE PROVIDED IN CHANGES OF PIPING DIRECTION.

D. DIELECTRIC FITTINGS ARE TO BE PROVIDED WHEREVER DISSIMILAR METALS ARE JOINED.

E. PROVIDE BALANCE VALVE FOR HOT WATER RETURN SYSTEM AS REQUIRED.

F. PROVIDE PRESSURE REDUCING VALVE IN SYSTEM AS REQUIRED.

G. PROVIDE EXTERNAL OR INTEGRAL HEAT TRAPS FOR ALL WATER HEATING EQUIPMENT.

H. PROVIDE CHROME PLATED ANGLE STOPS WITH ESCUTCHEON PLATES AT ALL PLUMBING FIXTURES.

I. ALL POTABLE WATER SYSTEMS TO BE DISINFECTED PER AWWA STANDARD AND/OR PLUMBING CODE. PROVIDE OWNER OR OWNER'S REPRESENTATIVE WITH OFFICIAL DOCUMENT SIGNING COMPLIANCE.

9. AT THE CONCLUSION OF THE JOB, PROVIDE THE FOLLOWING, INCLUDING BUT NOT LIMITED TO:

A. ALL AIR SIDE AND WATER SIDE SYSTEMS TO BE BALANCED, TESTED AND ADJUSTED.

B. ALL EQUIPMENT TO BE OPERATING SAFELY, QUIETLY, AND STABLE AS PER MANUFACTURER RECOMMENDATIONS.

C. PROVIDE SYSTEM OPERATION DEMONSTRATION TO OWNER/OWNER'S REPRESENTATIVE.

D. PROVIDE IDENTIFICATION FOR THE FOLLOWING, WHETHER VISIBLE OR CONCEALED IN ACCORDANCE WITH OSHA AND ANSI REQUIREMENTS: SWITCHES. STARTERS. VALVES - PROVIDE 2 LAQUERED BRASS TAGS WITH STAMPED LETTERS ON CHAINS OR S HOOKS. EQUIPMENT - PROVIDE PERMANENTLY ATTACHED (ADHESIVE NOT ACCEPTED) LAMINATED ENGRAVED NAMEPLATES WITH BEVELED EDGES, WITH WHITE LETTERS ON BLACK BACKGROUND. PIPING - NEAR EACH VALVE WITH PIPE TAPE INDICATING SYSTEM TYPE, DIRECTION OF FLOW, AREA SERVED AND SIZE. DUCT DAMPERS - PROVIDE 2 LAQUERED BRASS TAGS WITH STAMPED LETTERS ON CHAINS OR S HOOKS. CONTROLS - PROVIDE 2 LAQUERED BRASS TAGS WITH STAMPED LETTERS ON CHAINS OR S HOOKS.

10. GENERAL

A. MAINTAIN RATED WALL ASSEMBLY INTEGRITY AS REQUIRED. PROVIDE FIRE DAMPERS, SMOKE/FIRE DAMPERS, SMOKE DAMPERS AND ALL ASSOCIATED ACCESSORIES AND CONSTRUCTION REQUIREMENTS AS REQUIRED.

B. STARTERS AND MOTOR CONTROLS TO BE FURNISHED BY MECHANICAL CONTRACTOR, INSTALLED BY ELECTRICAL CONTRACTOR. ELECTRICAL CONTRACTOR TO PROVIDE ALL NECESSARY COMPONENTS REQUIRED FOR INSTALLATION. MECHANICAL CONTRACTOR TO FURNISH ALL CONTROLS AND RELATED ACCESSORIES REQUIRED.

C. PROVIDE APPROPRIATE ACCESS PANELS FOR INACCESSIBLE COMPONENTS WHERE REQUIRED

MECHANICAL ANALYSIS OF SCHELES AND RAMS

PACKAGED GAS HEATING ELECTRIC COOLING ROOFTOP UNIT SCHEDULE																								
EQUIP ID	MANUFACTURER MODEL	LOCATION	SERVICE	SUPPLY AIR CFM	MIN. OUTSIDE AIR, CFM	ESP IN	BHP	COOLING				HEATING				ELECTRICAL				OPERATING WEIGHT, LBS	NOTES			
								TOTAL MBH	SENSIBLE MBH	EB (°F)	WB (°F)	OUTSIDE AMBIENT (°F)	SEER/EER	GAS INPUT MBH	GAS OUTPUT MBH	EB (°F)	WB (°F)	GAS TYPE (NATURAL, LP, PROP)	EFFICIENCY (%)			VPH/HZ	MCA	MOC/P
AC-1	LENNOX KG4090S4B	ROOF	RECEPTION	3000	600	0.75	2	72.4	68.8	115	68	115	- / 13	150	120	54.9	56.6	NATURAL	80	208/3/60	42	60	1300	1 THROUGH 11
AC-2	LENNOX KG4090S4B	ROOF	RECEPTION	800	200	0.75	1/4	800	18.8	115	68	115	14 / 12.7	65	52	56.8	59.15	NATURAL	80	208/3/60	16	25	1000	1 THROUGH 11
AC-3	LENNOX KG4120S4B	ROOF	TOILET, TOILET, MAINTENANCE	4000	800	0.75	3	78.4	74.2	115	68	115	- / 11	180	144	59.4	61.1	NATURAL	80	208/3/60	46	50	1400	1 THROUGH 11
AC-4	LENNOX KG4120S4B	ROOF	RECEPTION	4000	800	0.75	3	78.4	74.2	115	68	115	- / 11	180	144	59.4	61.1	NATURAL	80	208/3/60	46	50	1400	1 THROUGH 11
AC-5	LENNOX KG4090S4B	ROOF	RECEPTION	2000	400	0.75	2	47.4	45.6	115	68	115	13 / 11.2	150	120	55.2	56.7	NATURAL	80	208/3/60	27	40	1100	1 THROUGH 11
AC-6	LENNOX LGH242H4V	ROOF	KITCHEN, DINING ROOM, BANQUET HALL, LARGE OFFICE SPACE, OFFICES (11)	8000	1600	0.75	5	203	185.4	115	68	115	- / 12.3	260	208	55.1	56.3	NATURAL	80	208/3/60	131	150	4200	1 THROUGH 15
AC-7	LENNOX KG4120S4B	ROOF	ROOM, ROOM, OFFICE, OFFICE, OFFICE, BANQUET HALL, LARGE OFFICE SPACE	4000	800	0.75	3	78.4	74.2	115	68	115	- / 11	180	144	59.4	61.1	NATURAL	80	208/3/60	46	50	1400	1 THROUGH 11
AC-8	LENNOX LGH20S4V	ROOF	OFFICES (17)	14000	300	0.75	10	287.7	244	115	68	115	- / 10	500	400	60.2	62.1	NATURAL	80	208/3/60	203	225	7400	1 THROUGH 11, 13

NOTES
1. PROVIDE DUCT MOUNTED SMOKE DETECTOR.
2. PROVIDE DISCONNECT.
3. PROVIDE VIBRATION ISOLATION.
4. PROVIDE 2" MIN 4 THRU W/AVY FILTER.

5. PROVIDE 14" ROOF CURB.
6. PROVIDE FLEX DUCT CONNECTION AT DUCT DROPS.
7. PROVIDE DUCT ACOUSTICAL LINING FOR MINIMUM 20 FEET FROM DUCT CONNECTION INCLUDING DUCT FITTINGS.

8. PROVIDE ECONOMIZER WITH BAROMETRIC RELIEF.
9. PROVIDE LOW AMBIENT KIT.
10. PROVIDE BELT DRIVE INDOOR MOTOR.
11. PROVIDE POWERED CONVEIENCE OUTLET, POWERED FROM LINE VOLTAGE SIDE OF UNIT.

12. PROVIDE ENVIRON COIL SYSTEM.
13. PROVIDE 100% HIGH STATIC PEF WITH VFD AND HOOD.
14. PROVIDE STANDARD CAP.
15. PROVIDE STATIC LIMIT TRANSDUCER.

EXHAUST FAN SCHEDULE												
EQUIP ID	MANUFACTURER & MODEL	LOCATION	AREA SERVED	EXHAUST AIR CFM	FAN TYPE	ESP IN	RPM	ELECTRICAL			OPERATING WEIGHT, LBS	NOTES
								V/PH/Hz	HP	FLA		
EF-1	COOK 120R15D	ROOF	TOILET	1000	CENTRIFUGAL	0.6	1550	120/1/60	1/4	5.8	60	1,2,3,4,5
EF-2	COOK 101R1TD	ROOF	TOILET	500	CENTRIFUGAL	0.6	1725	120/1/60	1/8	5.2	32	1,2,3,4,5,6,7,8
EF-3	COOK 101R1TD	ROOF	STORAGE	600	CENTRIFUGAL	0.6	1725	120/1/60	1/8	5.2	32	1,2,3,4,5
EF-4	COOK 150R13D	ROOF	DISH	1600	CENTRIFUGAL	0.7	1300	120/1/60	3/4	13.8	62	1,2,3,4,5,6,7,8
EF-5	COOK 101R1TD	ROOF	KILN	500	CENTRIFUGAL	0.6	1725	120/1/60	1/8	5.2	32	1,2,3,4,5,6,9
NOTES												
1. PROVIDE ROOF CURB.						5. PROVIDE BACKDRAFT DAMPER.			9. INTERLOCK WITH KILN ROOM SWITCH.			
2. PROVIDE DISCONNECT.						6. PROVIDE CLEAN OUT PORT.						
3. INTERLOCK WITH EXISTING CONTROLS.						7. PROVIDE ALL ALUMINUM CONNECTION.						
4. PROVIDE MOTOR WITH THERMAL OVERLOADS.						8. INTERLOCK WITH DISH HOOD. FIELD VERIFY CONNECTION.						

KITCHEN EXHAUST FAN SCHEDULE												
EQUIP ID	MANUFACTURER & MODEL	LOCATION	AREA SERVED	EXHAUST AIR CFM	FAN TYPE	ESP IN	RPM	ELECTRICAL			OPERATING WEIGHT, LBS	NOTES
								V/PH/Hz	HP	FLA		
KEF-1	COOK225VX1TD	ROOF	HOOD	3600	CENTRIFUGAL	2.5	1895	208/3/60	3	10.6	219	1, 2, 3, 4, 5

NOTES

1. INTERLOCK WITH HOOD.

2. PROVIDE DISCONNECT.

3. PROVIDE MOTOR WITH THERMAL OVERLOADS.

4. PROVIDE AUTOMATIC BELT TENSIONER.

5. UL 762.

[illegible]

MAKE UP AIR UNIT SCHEDULE												
EQUIP ID	MANUFACTURER & MODEL	LOCATION	AREA SERVED	MAKE-UP AIR CFM	ESP IN	RPM	ELECTRICAL			OPERATING WEIGHT, LBS	NOTES	
							V/PH/Hz	FLA	HP			
MAU-1	CAPITVEARE A2-BIT-300-G15	ROOF	HOOD	2400	0.8	756	208/3/60	4.6	1.5	1383	1, 2	
EQUIP ID	HEATING SECTION DATA				EVAP COOLER ENTERING AIR		EVAP COOLER LEAVING AIR					
	INPUT MBH / OUTPUT MBH	ENTERING AIR / LEAVING AIR (°F)	FUEL TYPE	EFFICIENCY (%)	DB (°F)	WB (°F)	DB (°F)	WB (°F)				
	MAU-1	139 / 111	27 / 70	NAT GAS	80	107	67.0	84	67.0			
NOTES 1. ACCESSORIES AS DETAILED ON CAPITVEARE SHOP DRAWNGS MFS-1 AND MFS-2. 2. OR APPROVED EQUAL												



PROFESSIONAL ENGINEER-STATE OF NEVADA
BRYAN
OSAMU
NEKOBA
Exp. 12-31-19
MECHANICAL
No. 18520
01/09/2018

LAS VEGAS SENIOR CENTER HVAC
REPLACEMENT

451 E BONANZA RD
LAS VEGAS, NV 89101



6390 South Valley View Blvd, Suite #416
Las Vegas, Nevada 89118
Phone: (702) 685-0136
Fax: (702) 685-8890
Web: www.jpac-llc.com
Project #: L17138

CONSULTANTS		
ISSUE	DATE	DESCRIPTION
ISSUE DATE:	12.08.2017	
PROJECT NO:	L17138	
CAD DWG FILE:	M02 MECHANICAL AND PLUMBING SCHEDULES AND DIAGRAMS DWG	
DRAWN BY:	HPA	
BID NUMBER:	18.691111.02	
COPYRIGHT:		
© 2017 HPA CONSULTING ENGINEERS		
SHEET TITLE		

MECHANICAL AND PLUMBING SCHEDULES AND DIAGRAMS

513-45Q

M0.2

SHEET - OF -

IECC COMLIANCE STATEMENT



Section 1: Project Information

Energy Code: 2009 IECC
Project Title: Las Vegas Senior Center HVAC
Project Type: Alteration
Construction Site: 451 East Bonanza Road Las Vegas, NV 89101
Owner/Agent: Las Vegas, Nevada 3b
Designer/Contractor: HPA Consulting Engineers 6280 S. Valley View Blvd Suite 416 Las Vegas, NV 89118

Section 2: General Information

Building Location (for weather data): Las Vegas, Nevada
Climate Zone: 3b

Section 3: Mechanical Systems List

Quantity	System Type & Description
1	AC-1 (Single Zone) : Heating: 1 each - Other, Gas, Capacity = 52 kBtu/h No minimum efficiency requirement applies Cooling: 1 each - Single Package DX Unit, Capacity = 19 kBtu/h, Air-Cooled Condenser, Air Economizer Proposed Efficiency = 14.00 SEER, Required Efficiency: 13.00 SEER Fan System: FAN SYSTEM 1 - Compliance (Motor nameplate HP method) : Passes Fans: MUA1 Supply, Constant Volume, 2400 CFM, 1.5 motor nameplate hp
3	AC-2, 4, 7 (Single Zone) : Heating: 1 each - Other, Gas, Capacity = 144 kBtu/h No minimum efficiency requirement applies Cooling: 1 each - Single Package DX Unit, Capacity = 78 kBtu/h, Air-Cooled Condenser, Air Economizer Proposed Efficiency = 11.00 EER, Required Efficiency: 11.00 EER Fan System: FAN SYSTEM 1 - Compliance (Motor nameplate HP method) : Passes Fans: MUA1 Supply, Constant Volume, 2400 CFM, 1.5 motor nameplate hp
1	AC-3 (Single Zone) : Heating: 1 each - Other, Gas, Capacity = 120 kBtu/h No minimum efficiency requirement applies Cooling: 1 each - Single Package DX Unit, Capacity = 72 kBtu/h, Air-Cooled Condenser, Air Economizer Proposed Efficiency = 13.00 SEER, Required Efficiency: 13.00 SEER Fan System: FAN SYSTEM 1 - Compliance (Motor nameplate HP method) : Passes Fans: MUA1 Supply, Constant Volume, 2400 CFM, 1.5 motor nameplate hp
1	AC-5 (Single Zone) : Heating: 1 each - Other, Gas, Capacity = 120 kBtu/h No minimum efficiency requirement applies Cooling: 1 each - Single Package DX Unit, Capacity = 47 kBtu/h, Air-Cooled Condenser, Air Economizer Proposed Efficiency = 13.00 SEER, Required Efficiency: 13.00 SEER Fan System: FAN SYSTEM 1 - Compliance (Motor nameplate HP method) : Passes Fans: MUA1 Supply, Constant Volume, 2400 CFM, 1.5 motor nameplate hp
1	AC-6 (Single Zone) :

Project Title: Las Vegas Senior Center HVAC
Data filename: J:\2017\L17138_Las Vegas Senior Center HVAC Replacement\Design\Calcs\IECCOL17138-Mech.cck
Report date: 11/15/17
Page 1 of 4

Heating: 1 each - Other, Gas, Capacity = 208 kBtu/h
No minimum efficiency requirement applies
Cooling: 1 each - Single Package DX Unit, Capacity = 203 kBtu/h, Air-Cooled Condenser, Air Economizer
Proposed Efficiency = 12.30 EER, Required Efficiency: 10.80 EER
Fan System: FAN SYSTEM 1 - Compliance (Motor nameplate HP method) : Passes
Fans:
MUA1 Supply, Constant Volume, 2400 CFM, 1.5 motor nameplate hp

1 AC-8 (Single Zone) :
Heating: 1 each - Other, Gas, Capacity = 400 kBtu/h
No minimum efficiency requirement applies
Cooling: 1 each - Single Package DX Unit, Capacity = 288 kBtu/h, Air-Cooled Condenser, Air Economizer
Proposed Efficiency = 10.00 EER, Required Efficiency: 9.80 EER (9.5 IPLV)
Fan System: FAN SYSTEM 1 - Compliance (Motor nameplate HP method) : Passes
Fans:
MUA1 Supply, Constant Volume, 2400 CFM, 1.5 motor nameplate hp

Section 4: Requirements Checklist

- Requirements Specific To: AC-1 :**
- ☐ 1. Equipment minimum efficiency: Single Package Unit: 13.00 SEER
- Requirements Specific To: AC-2, 4, 7 :**
- ☐ 1. Equipment minimum efficiency: Single Package Unit: 11.00 EER
 - ☐ 2. Integrated economizer is required for this location and system.
 - ☐ 3. Cooling system provides a means to relieve excess outdoor air during economizer operation.
- Requirements Specific To: AC-3 :**
- ☐ 1. Equipment minimum efficiency: Single Package Unit: 11.00 EER
 - ☐ 2. Integrated economizer is required for this location and system.
 - ☐ 3. Cooling system provides a means to relieve excess outdoor air during economizer operation.
- Requirements Specific To: AC-5 :**
- ☐ 1. Equipment minimum efficiency: Single Package Unit: 13.00 SEER
- Requirements Specific To: AC-6 :**
- ☐ 1. Equipment minimum efficiency: Single Package Unit: 10.80 EER
 - ☐ 2. Integrated economizer is required for this location and system.
 - ☐ 3. Cooling system provides a means to relieve excess outdoor air during economizer operation.
 - ☐ 4. Hot gas bypass prohibited unless system has multiple steps of unloading or continuous capacity modulation
 - ☐ 5. Hot gas bypass limited to 50% of total cooling capacity
- Requirements Specific To: AC-8 :**
- ☐ 1. Equipment minimum efficiency: Single Package Unit: 9.80 EER (9.5 IPLV)
 - ☐ 2. Integrated economizer is required for this location and system.
 - ☐ 3. Cooling system provides a means to relieve excess outdoor air during economizer operation.
 - ☐ 4. Hot gas bypass prohibited unless system has multiple steps of unloading or continuous capacity modulation
 - ☐ 5. Hot gas bypass limited to 25% of total cooling capacity
- Generic Requirements: Must be met by all systems to which the requirement is applicable:**
- ☐ 1. Plant equipment and system capacity no greater than needed to meet loads
Exception(s):
 - ☐ Standby equipment automatically off when primary system is operating
 - ☐ Multiple units controlled to sequence operation as a function of load
 - ☐ 2. Minimum one temperature control device per system
 - ☐ 3. Minimum one humidity control device per installed humidification/dehumidification system
 - ☐ 4. Load calculations per ASHRAE/ACCA Standard 183.
 - ☐ 5. Automatic Controls: Setback to 55°F (heat) and 85°F (cool); 7-day clock; 2-hour occupant override; 10-hour backup
Exception(s):
 - ☐ Continuously operating zones
 - ☐ 6. Outside-air source for ventilation; system capable of reducing OSA to required minimum

Project Title: Las Vegas Senior Center HVAC
Data filename: J:\2017\L17138_Las Vegas Senior Center HVAC Replacement\Design\Calcs\IECCOL17138-Mech.cck
Report date: 11/15/17
Page 2 of 4

- ☐ 7. R-5 supply and return air duct insulation in unconditioned spaces
- ☐ R-8 supply and return air duct insulation outside the building
- ☐ R-8 insulation between ducts and the building exterior when ducts are part of a building assembly
Exception(s):
 - ☐ Ducts located within equipment
 - ☐ Ducts with interior and exterior temperature difference not exceeding 15°F.
- ☐ 8. Mechanical fasteners and sealants used to connect ducts and air distribution equipment.
- ☐ 9. Ducts sealed - longitudinal seams on rigid ducts; transverse seams on all ducts; UL 181A or 181B tapes and mastics
- ☐ 10. Hot water pipe insulation: 1.5 in. for pipes <=1.5 in. and 2 in. for pipes >1.5 in.
Chilled water/refrigerant/brine pipe insulation: 1.5 in. for pipes <=1.5 in. and 1.5 in. for pipes >1.5 in.
Steam pipe insulation: 1.5 in. for pipes <=1.5 in. and 3 in. for pipes >1.5 in.
Exception(s):
 - ☐ Piping within HVAC equipment.
 - ☐ Fluid temperatures between 55 and 105°F.
 - ☐ Fluid not heated or cooled with renewable energy.
 - ☐ Piping within room fan-coil (with AHR440 rating) and unit ventilators (with AHR840 rating).
 - ☐ Runouts <=4 ft in length.
- ☐ 11. Operation and maintenance manual provided to building owner
- ☐ 12. Thermostatic controls have 5°F deadband
Exception(s):
 - ☐ Thermostats requiring manual changeover between heating and cooling
 - ☐ Special occupancy or special applications where wide temperature ranges are not acceptable and are approved by the authority having jurisdiction.
- ☐ 13. Balancing devices provided in accordance with IMC 603.17
- ☐ 14. Demand control ventilation (DCV) present for high design occupancy areas (>40 persons/1000 ft2 in spaces >500 ft2) and served by systems with any one of 1) an air-side economizer, 2) automatic modulating control of the outdoor air damper, or 3) a design outdoor airflow greater than 3000 cfm.
Exception(s):
 - ☐ Systems with heat recovery.
 - ☐ Multiple-zone systems without DDC of individual zones communicating with a central control panel.
 - ☐ Systems with a design outdoor airflow less than 1200 cfm.
 - ☐ Spaces where the supply airflow rate minus any makeup or outgoing transfer air requirement is less than 1200 cfm.
- ☐ 15. Motorized, automatic shutoff dampers required on exhaust and outdoor air supply openings
Exception(s):
 - ☐ Gravitally dampers acceptable in buildings <3 stories
- ☐ 16. Automatic controls for freeze protection systems present
- ☐ 17. Exhaust air heat recovery included for systems 5,000 cfm or greater with more than 70% outside air fraction or specifically exempted
Exception(s):
 - ☐ Hazardous exhaust systems, commercial kitchen and clothes dryer exhaust systems that the International Mechanical Code prohibits the use of energy recovery systems.
 - ☐ Systems serving spaces that are heated and not cooled to less than 60°F.
 - ☐ Where more than 60 percent of the outdoor heating energy is provided from site-recovered or site solar energy.
 - ☐ Heating systems in climates with less than 3600 HDD.
 - ☐ Cooling systems in climates with a 1 percent cooling design wet-bulb temperature less than 64°F.
 - ☐ Systems requiring dehumidification that employ energy recovery in series with the cooling coil.
 - ☐ Laboratory fume hood exhaust systems that have either a variable air volume system capable of reducing exhaust and makeup air volume to 50 percent or less of design values or, a separate make up air supply meeting the following makeup air requirements: a) at least 75 percent of exhaust flow rate, b) heated to no more than 2°F below room setpoint temperature, c) cooled to no lower than 3°F above room setpoint temperature, d) no humidification added, e) no simultaneous heating and cooling.

Section 5: Compliance Statement

Compliance Statement: The proposed mechanical alteration project represented in this document is consistent with the building plans, specifications and other calculations submitted with this permit application. The proposed mechanical alteration project has been designed to meet the 2009 IECC, Chapter 8, requirements in COMcheck Version 4.0.5.0 and to comply with the mandatory requirements in the Requirements Checklist.

Project Title: Las Vegas Senior Center HVAC
Data filename: J:\2017\L17138_Las Vegas Senior Center HVAC Replacement\Design\Calcs\IECCOL17138-Mech.cck
Report date: 11/15/17
Page 3 of 4

Name - Title Signature Date

Section 6: Post Construction Compliance Statement

- ☐ HVAC record drawings of the actual installation, system capacities, calibration information, and performance data for each equipment provided to the owner.
 - ☐ HVAC O&M documents for all mechanical equipment and system provided to the owner by the mechanical contractor.
 - ☐ Written HVAC balancing and operations report provided to the owner.
- The above post construction requirements have been completed.

Principal Mechanical Designer-Name Signature Date



01/09/2018

LAS VEGAS SENIOR CENTER HVAC REPLACEMENT

451 E BONANZA RD
LAS VEGAS, NV 89101



6280 South Valley View Blvd, Suite #416
Las Vegas, Nevada 89118
Phone: (702) 855-4138
Fax: (702) 855-4880
Web: www.hpacen.com
Project #: L17138

CONSULTANTS

ISSUE DATE DESCRIPTION

ISSUE DATE: 12.08.2017

PROJECT NO: L17138

CAD DWG FILE: M03 IECC COMPLIANCE STATEMENT.DWG

DRAWN BY: HPA

BID NUMBER: 18.69111.02

COPYRIGHT:
© 2017 HPA CONSULTING ENGINEERS

SHEET TITLE

IECC COMPLIANCE STATEMENT

513-45Q

M0.3

SHEET - OF -

GENERAL NOTES:

- WHERE DUCT OR PIPING IS TO BE REMOVED AT A SPECIFIC POINT, DUCT OR PIPE IS TO BE BLANKED OFF OR CAPPED AND REPAIRED TO LIKE NEW CONDITION.
- PIPING AND EQUIPMENT LOCATIONS SHOWN ARE FROM BEST AVAILABLE INFORMATION. CONTRACTOR TO FIELD VERIFY SPECIFIC LOCATION.
- PIPING DISCONNECTED FROM EQUIPMENT REMOVED. SHALL BE BLANKED OFF OR CAPPED IN CEILING, FLOORS OR WALLS.
- ANY EQUIPMENT OR COMPONENT REMOVED SHALL BE DISPOSED OF PROPERLY BY THE CONTRACTOR AND REMOVED FROM THE PROJECT SITE.
- RECYCLE DEMOLISHED COMPONENTS TO THE FURTHEST EXTENT POSSIBLE. CONTRACTOR ALLOWED TO PERFORM RECYCLING PROVIDED PAPERWORK IS PRODUCED TO PROVE RECYCLING.

SHEET NOTES:

- ◇ EXISTING VAV BOX TO BE REMOVED. FIELD VERIFY SPECIFIC LOCATION. REMOVE EXISTING ASSOCIATED CONTROLS AND SENSOR. RETURN TO OWNER.



LAS VEGAS SENIOR CENTER HVAC
REPLACEMENT

451 E BONANZA RD
LAS VEGAS, NV 89101



6305 South Valley View Blvd, Suite #410
Las Vegas, Nevada 89118
Phone: (702) 855-4138
Fax: (702) 855-4880
Web: www.hpacen.com
Project #: L17138

CONSULTANTS

ISSUE DATE DESCRIPTION

ISSUE DATE: 12.08.2017

PROJECT NO: L17138

CAD DWG FILE: MD2.1 MECHANICAL DEMOLITION FLOOR PLAN.DWG

DRAWN BY: HPA

BID NUMBER: 18.69111.02

COPYRIGHT:

© 2017 HPA CONSULTING ENGINEERS

SHEET TITLE

MECHANICAL
DEMOLITION
FLOOR PLAN

513-45Q

MD2.1

SHEET - OF -


A MECHANICAL DEMOLITION FLOOR PLAN
MD2.1 1/8" = 1'-0"

GENERAL NOTES:

- WHERE DUCT OR PIPING IS TO BE REMOVED AT A SPECIFIC POINT, DUCT OR PIPE IS TO BE BLANKED OFF OR CAPPED AND REPAIRED TO LIKE NEW CONDITION.
- PIPING AND EQUIPMENT LOCATIONS SHOWN ARE FROM BEST AVAILABLE INFORMATION. CONTRACTOR TO FIELD VERIFY SPECIFIC LOCATION.
- PIPING DISCONNECTED FROM EQUIPMENT REMOVED SHALL BE BLANKED OFF OR CAPPED IN CEILING, FLOORS OR WALLS.
- ANY EQUIPMENT OR COMPONENT REMOVED SHALL BE DISPOSED OF PROPERLY BY THE CONTRACTOR AND REMOVED FROM THE PROJECT SITE.
- RECYCLE DEMOLISHED COMPONENTS TO THE FURTHEST EXTENT POSSIBLE. CONTRACTOR ALLOWED TO PERFORM RECYCLING PROVIDED PAPERWORK IS PRODUCED TO PROVE RECYCLING.
- ALL WORK TO BE COORDINATED WITH ROOFING CONTRACTOR.

SHEET NOTES:

- EXISTING ROOFTOP UNIT TO BE REPLACED. FIELD VERIFY SPECIFIC LOCATION. REMOVE EXISTING CURB AND PREPARE FOR NEW UNIT AND CURB.
- EXISTING EXHAUST FAN TO BE REMOVED. FIELD VERIFY SPECIFIC LOCATION. REMOVE EXISTING CURB. CAP AND SEAL ROOFING PER OWNER REQUIREMENTS. REMOVE ALL AIR DISTRIBUTION DOWNSTREAM.
- EXISTING KITCHEN EXHAUST FAN TO BE REPLACED. FIELD VERIFY SPECIFIC LOCATION. REMOVE EXISTING CURB AND PREPARE FOR NEW FAN AND CURB. MAINTAIN AND INSPECT EXISTING GREASE DUCT. PROVIDE ITEMIZED LIST OF DEFICIENCIES TO OWNER.
- EXISTING MAKE UP AIR UNIT TO BE REPLACED. FIELD VERIFY SPECIFIC LOCATION. REMOVE EXISTING CURB AND PREPARE FOR NEW UNIT AND CURB. MAINTAIN AND INSPECT EXISTING MAKE UP AIR CONNECTION.
- EXISTING FAN TO BE REPLACED. FIELD VERIFY SPECIFIC LOCATION.

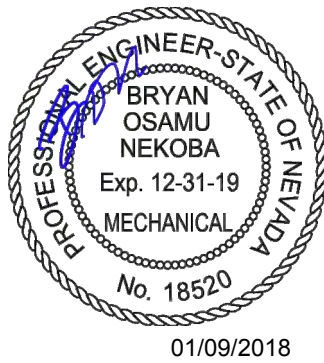

LAS VEGAS SENIOR CENTER HVAC
REPLACEMENT

451 E BONANZA RD
LAS VEGAS, NV 89101



6305 South Valley View Blvd, Suite #410
Las Vegas, Nevada 89118
Phone: (702) 855-4138
Fax: (702) 855-4880
Web: www.hpacs.com
Project #: L17138

CONSULTANTS

ISSUE DATE DESCRIPTION

PROJECT NO: L17138

CAD DWG FILE: MD2.2 MECHANICAL DEMOLITION ROOF PLAN.DWG

DRAWN BY: HPA

BID NUMBER: 18.69111.02

COPYRIGHT:
© 2017 HPA CONSULTING ENGINEERS

SHEET TITLE

MECHANICAL
DEMOLITION
ROOF PLAN

513-45Q

MD2.2

SHEET - OF -


A MECHANICAL DEMOLITION ROOF PLAN
MD2.2 1/8" = 1'-0"

GENERAL NOTES:


- MECHANICAL CONTRACTOR TO COORDINATE ROUTING AND LOCATION OF MECHANICAL COMPONENTS AND EQUIPMENT WITH ALL OTHER TRADES AND EXISTING FIELD CONDITIONS PRIOR TO PERFORMING WORK.
- CONTRACTOR TO CUT AND PATCH AS REQUIRED TO PERFORM THE WORK.
- ACCESS DOORS ARE REQUIRED FOR ANY COMPONENT REQUIRING ACCESS ABOVE HARD LID CEILINGS COORDINATE SIZE, LOCATION AND FINISH WITH ARCHITECT PRIOR TO PERFORMING WORK.
- REFER TO THE DIAGRAMS THAT APPLY TO THIS SHEET WHICH PROVIDE GENERAL GUIDANCE FOR INSTALLATION THOUGH NOT ALL COMPONENTS AND ACCESSORIES MAY BE SHOWN.
- PRIOR TO INSTALLATION, CONFIRM SPECIFIC LOCATION FOR ALL THERMOSTATS / SENSORS WITH ARCHITECT. MOUNT AT 48" A.F.F. OR IN ACCORDANCE WITH ADA REQUIREMENTS. PROVIDE LOCKING COVERS.
- COORDINATE AND CONFIRM BORDER, FRAME, FINISH, AND LOCATION WITH ARCHITECT PRIOR TO ORDERING.
- ANY PENETRATIONS THROUGH WALL STUDS, FLOOR JOISTS, OR ROOF TO BE IN ACCORDANCE WITH THE LATEST ADOPTED BUILDING CODE.
- DUCT DIMENSIONS SHOWN ARE CLEAR INSIDE DIMENSIONS.
- CONTRACTOR TO CONFIRM ADEQUATE RETURN AIR PATH BACK TO MAIN AIR HANDLING UNIT.

SHEET NOTES:


- CONNECT NEW TO EXISTING.
- ZONE CONTROL DAMPER, HONEYWELL MARD OR EQUAL INTEGRATED WITH CONTROL PANEL.
- BYPASS DAMPER, HONEYWELL MARD MODULATING DAMPER WITH STATIC PRESSURE SWITCH.
- ZONE CONTROL PANEL, HONEYWELL TRUEZONE HZ432 OR EQUAL. PROVIDE EXPANSION TO ACCOMMODATE REQUIRED NUMBER OF ZONES SHOWN ON FLAN.
- RETURN CONTROL DAMPER, DAMPER TO MODULATE IN CONJUNCTION WITH BYPASS DAMPER.
- ALL SENSORS/THERMOSTATS TO BE FIELD LOCATED.

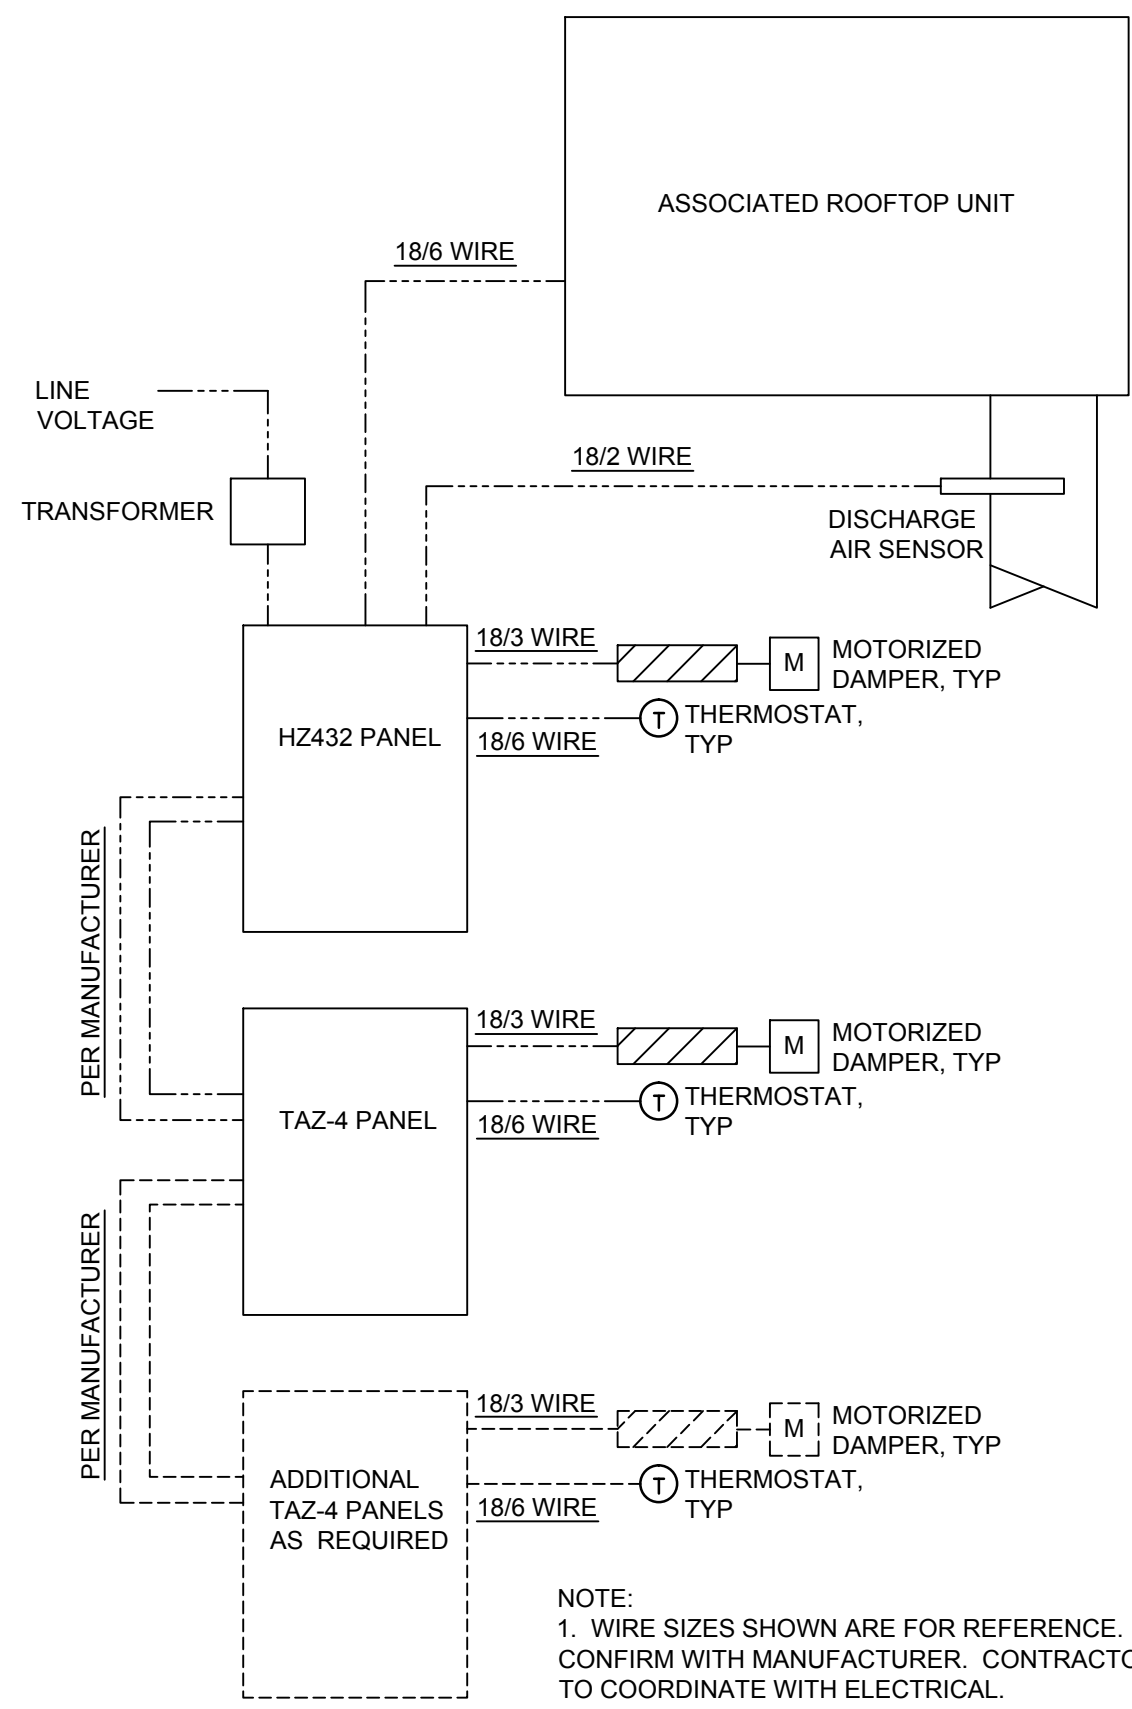


B GENERAL WIRING DIAGRAM
M2.1 NO SCALE

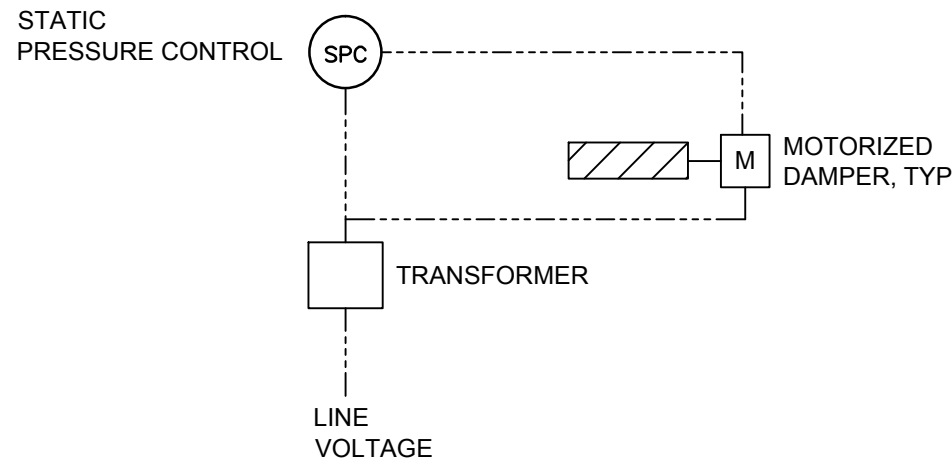

C GENERAL BYPASS DAMPER WIRING DIAGRAM
M2.1 NO SCALE

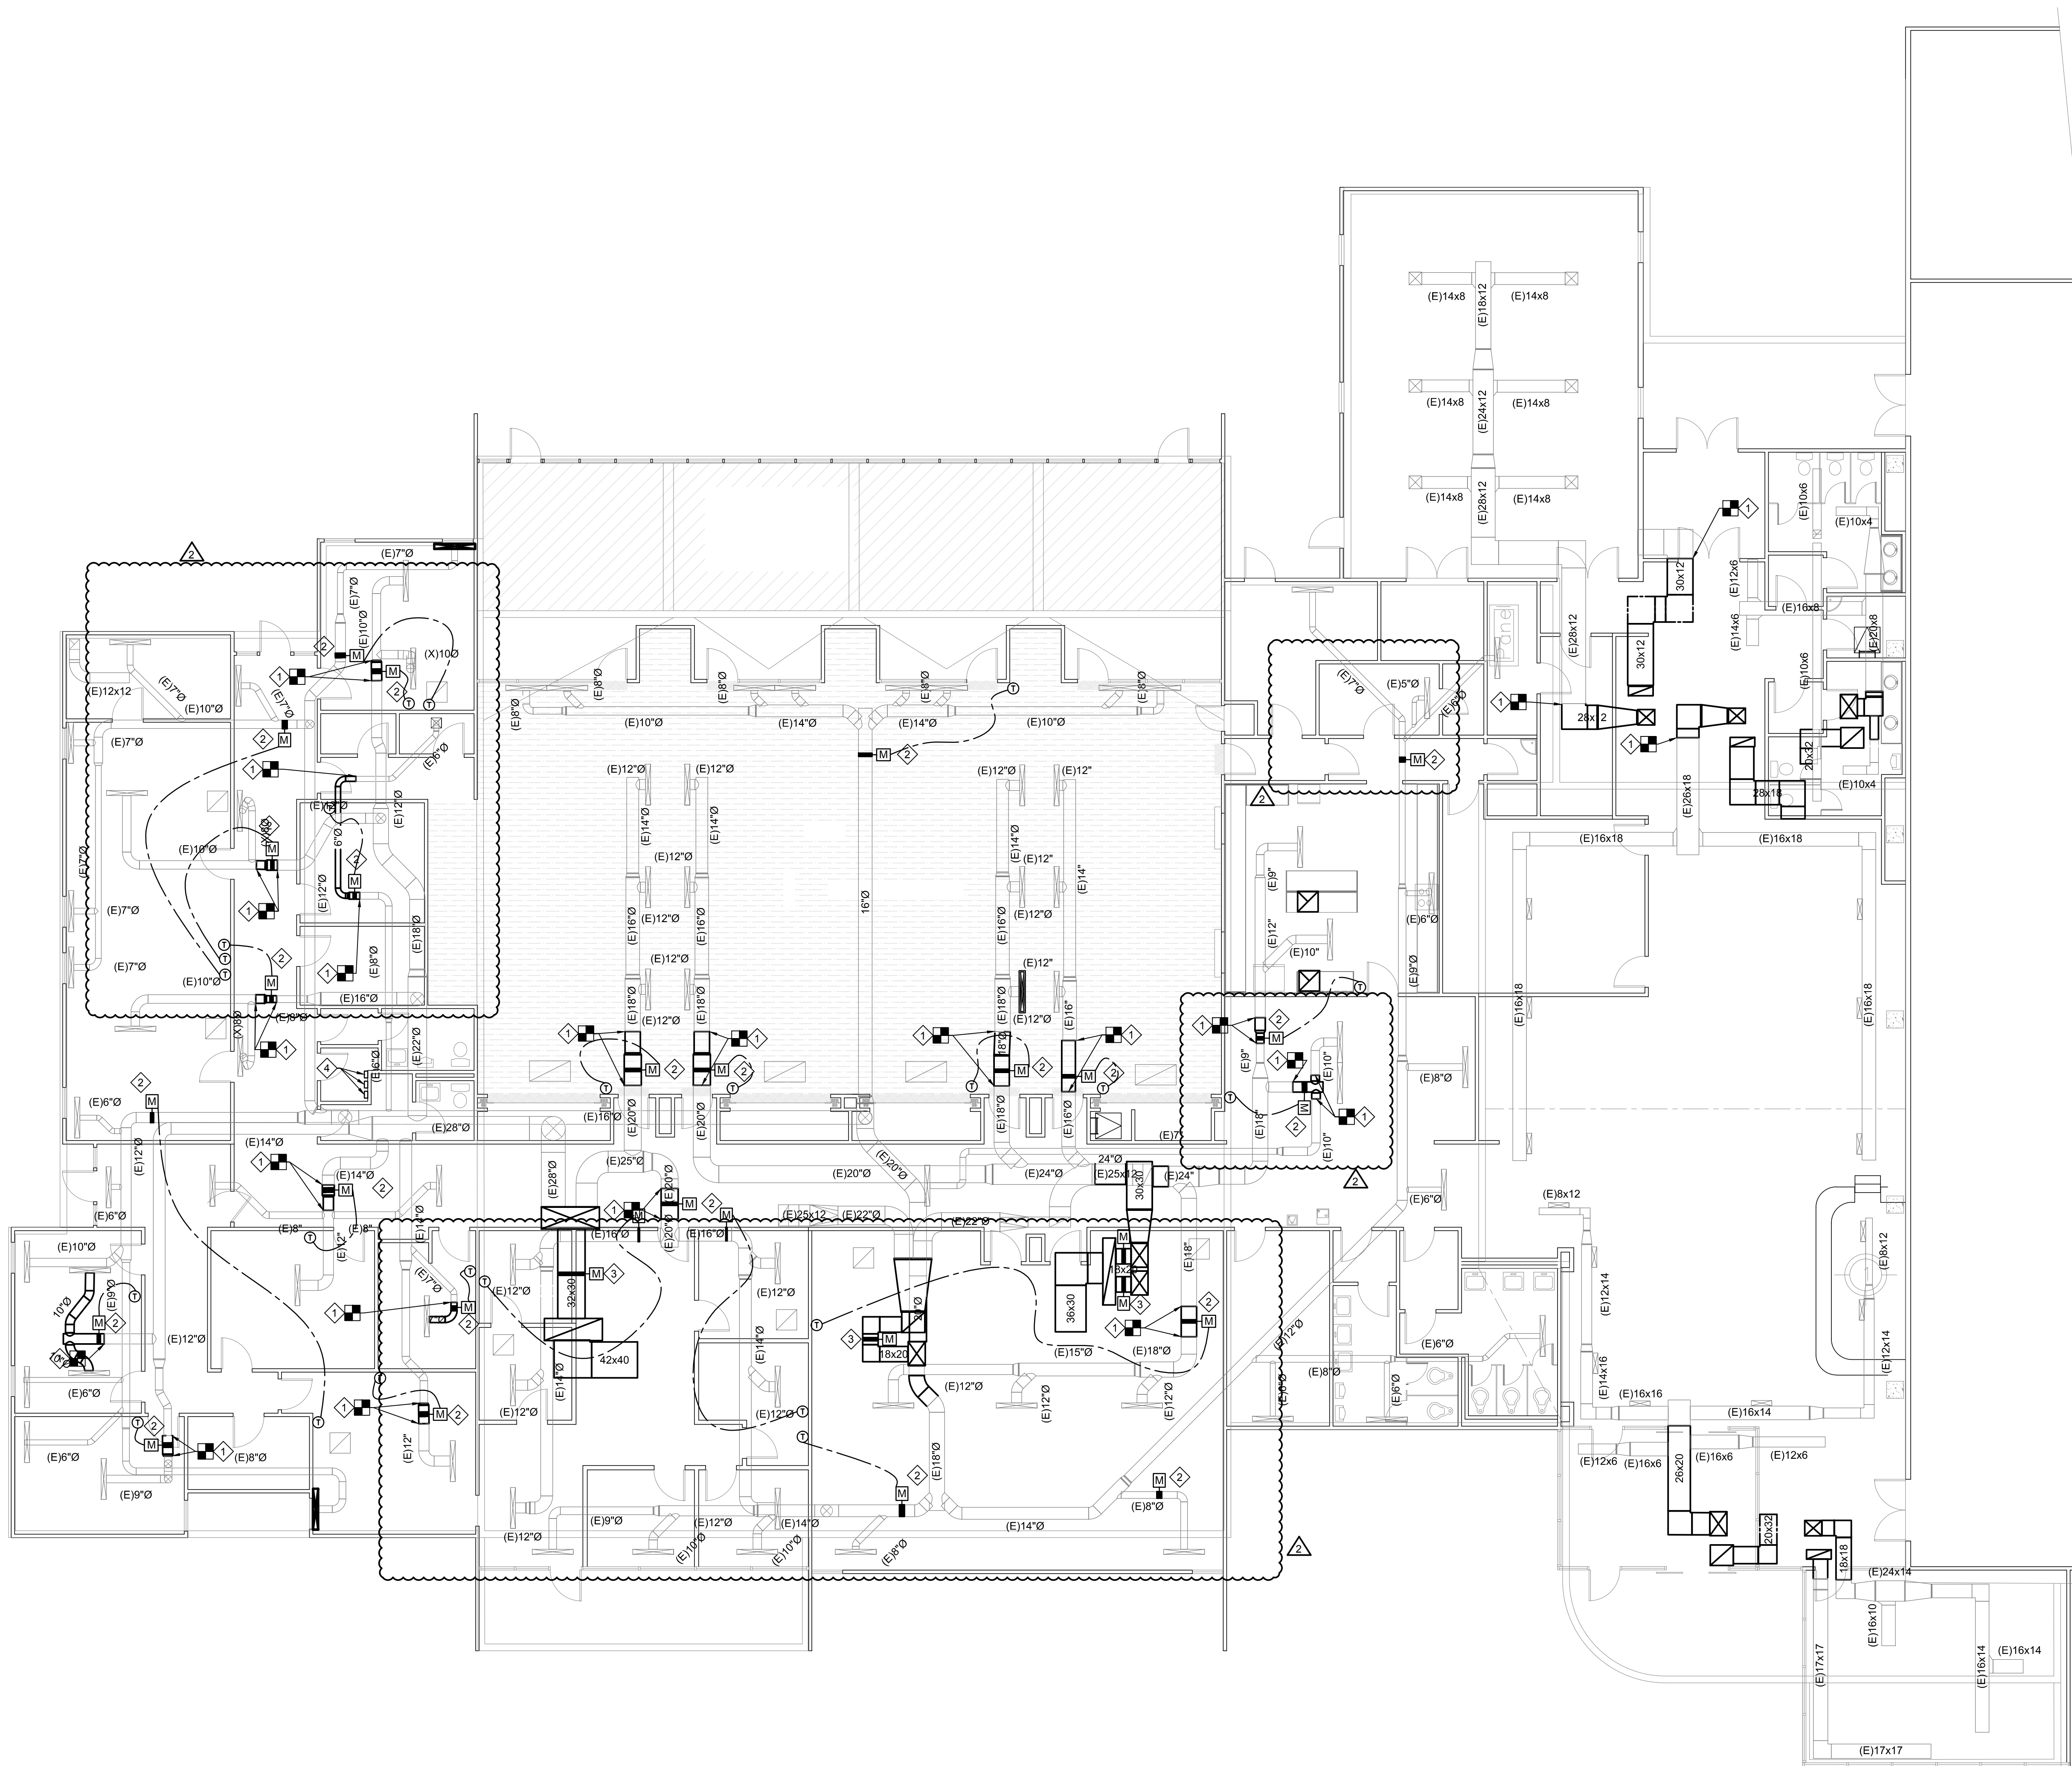

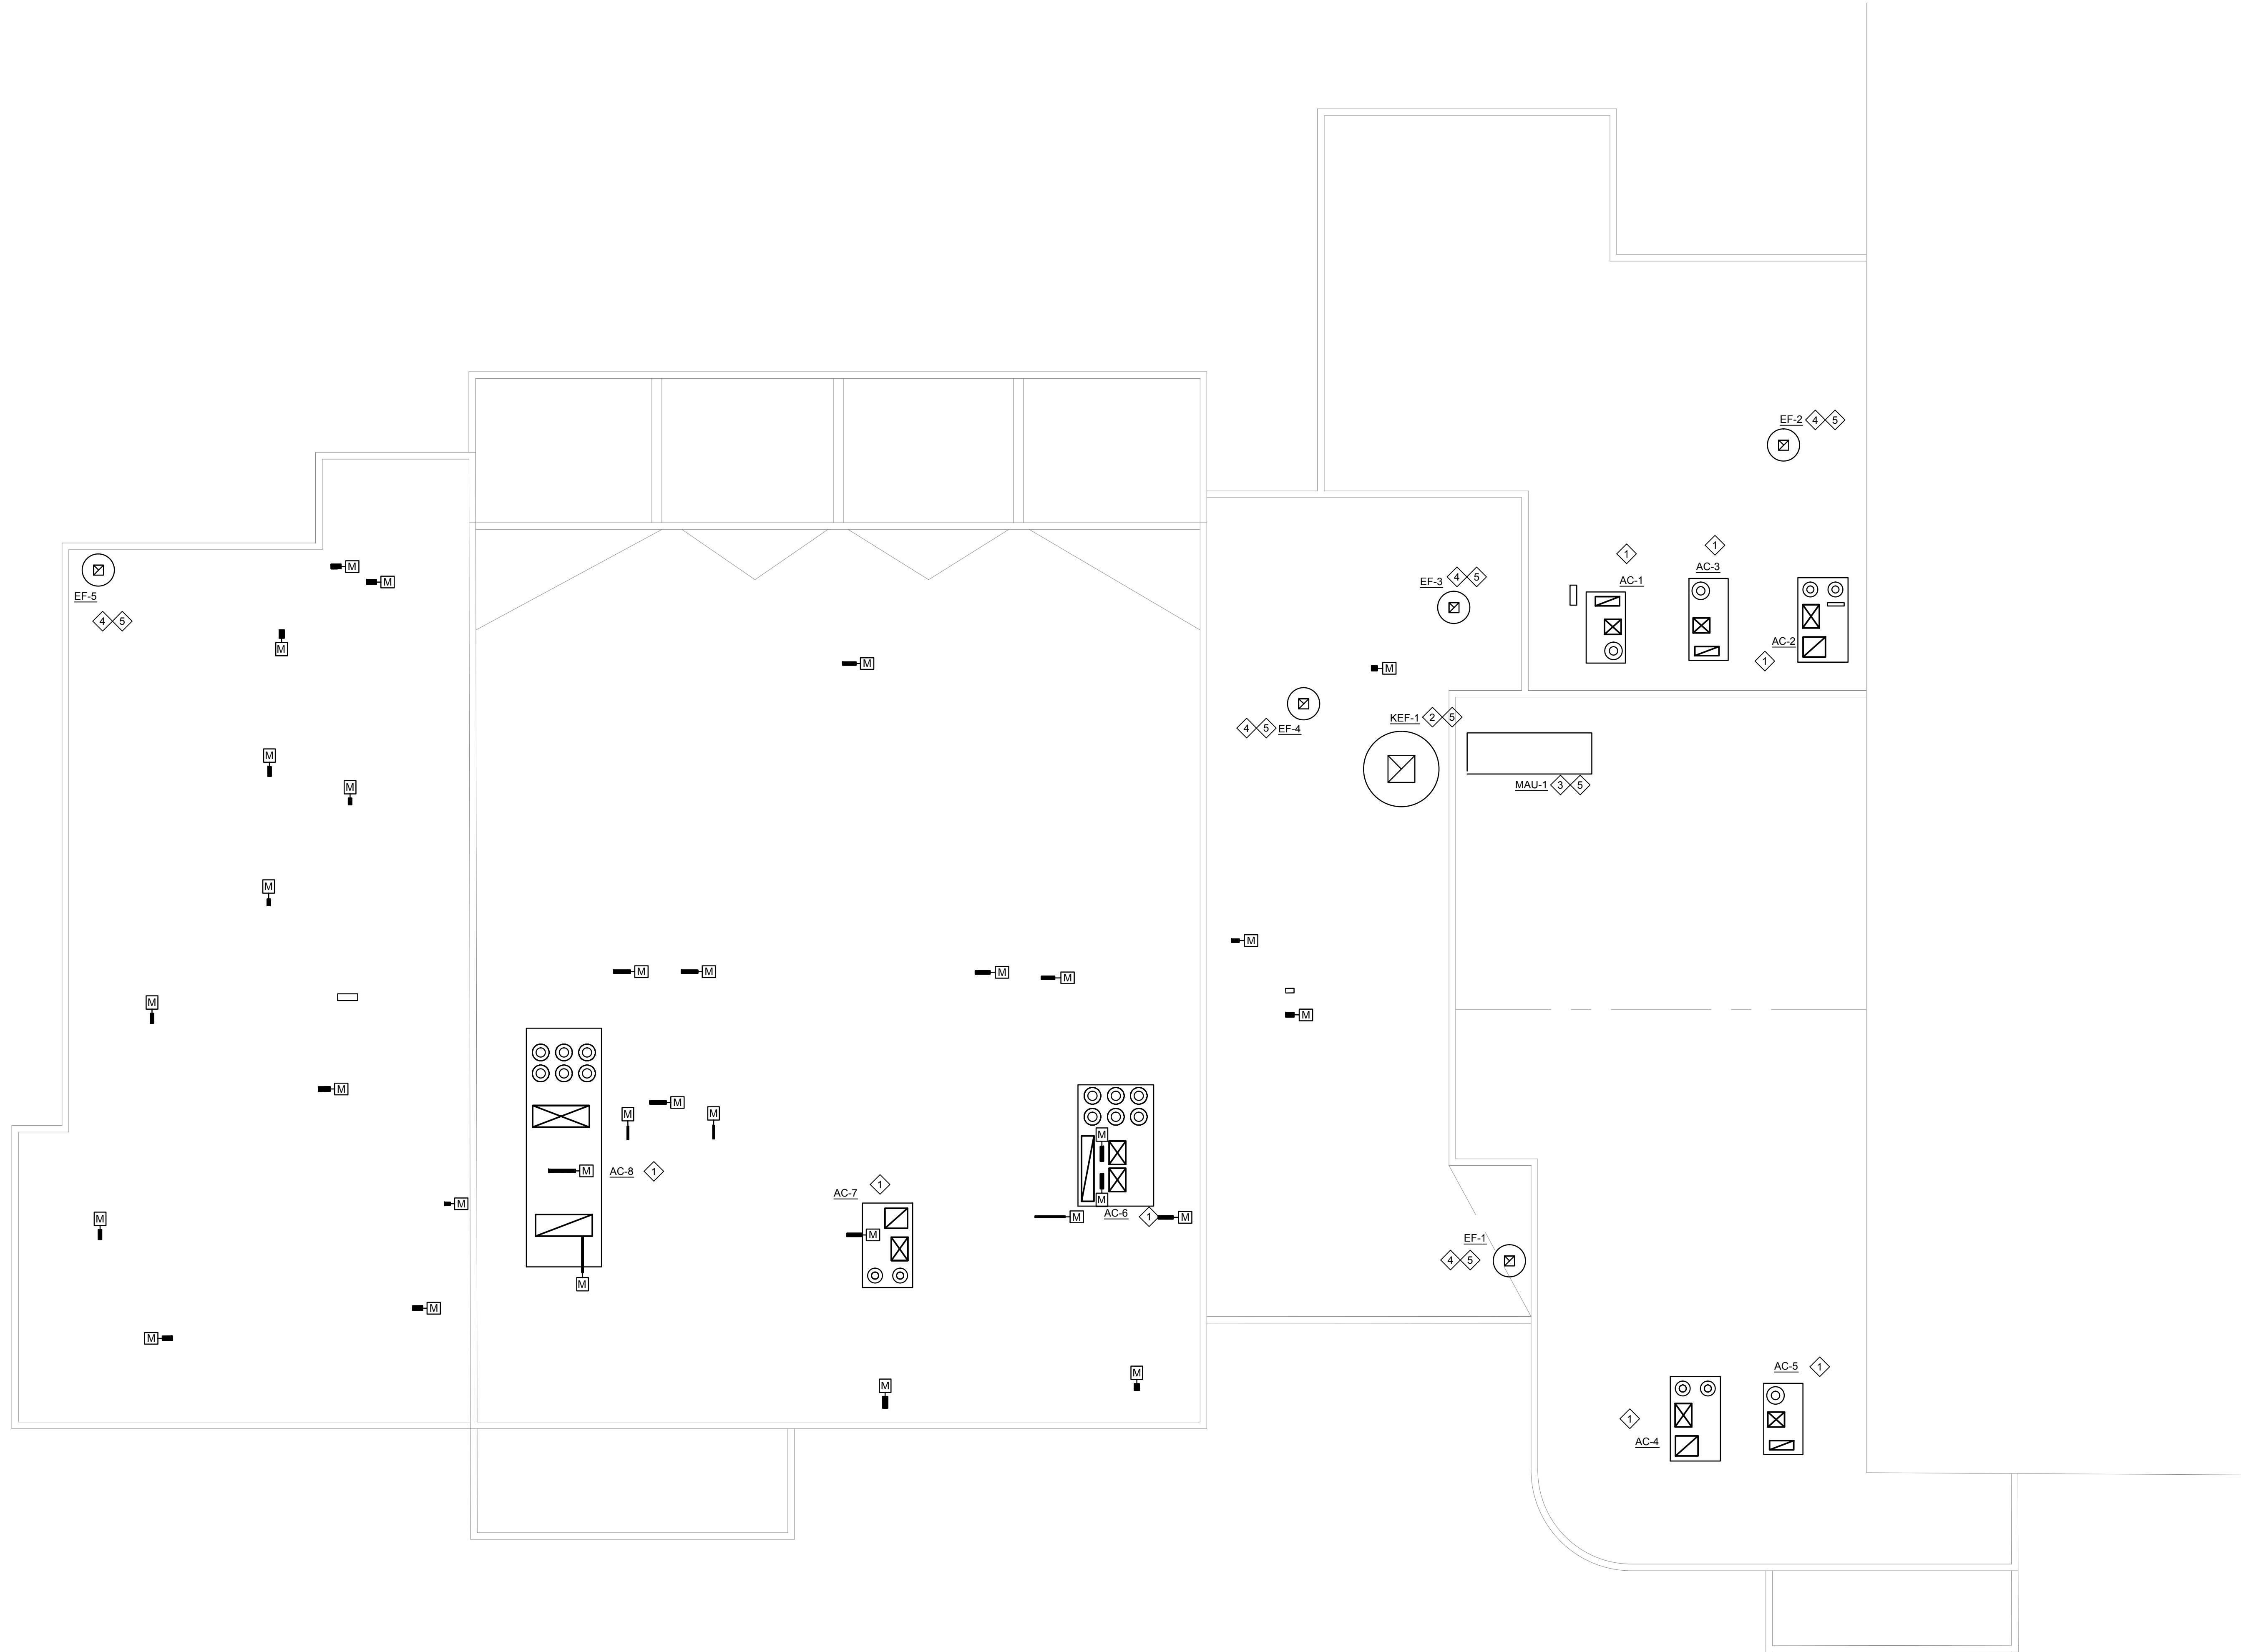


A MECHANICAL ROOF PLAN
M2.2 1/8" = 1'-0"

GENERAL NOTES:

- MECHANICAL CONTRACTOR TO COORDINATE ROUTING AND LOCATION OF MECHANICAL COMPONENTS AND EQUIPMENT WITH ALL OTHER TRADES AND EXISTING FIELD CONDITIONS PRIOR TO PERFORMING WORK.
- CONTRACTOR TO CUT AND PATCH AS REQUIRED TO PERFORM THE WORK.
- ACCESS DOORS ARE REQUIRED FOR ANY COMPONENT REQUIRING ACCESS ABOVE HARD LID CEILINGS. COORDINATE SIZE, LOCATION AND FINISH WITH ARCHITECT PRIOR TO PERFORMING WORK.
- REFER TO THE DIAGRAMS THAT APPLY TO THIS SHEET WHICH PROVIDE GENERAL GUIDANCE FOR INSTALLATION. THOUGH NOT ALL COMPONENTS AND ACCESSORIES MAY BE SHOWN.
- COORDINATE AND CONFIRM BORDER, FRAME, FINISH, AND LOCATION WITH ARCHITECT PRIOR TO ORDERING.
- ANY PENETRATIONS THROUGH WALL STUDS, FLOOR JOISTS, OR ROOF TO BE IN ACCORDANCE WITH THE LATEST ADOPTED BUILDING CODE.
- DUCT DIMENSIONS SHOWN ARE CLEAR INSIDE DIMENSIONS.
- ALL WORK TO BE COORDINATED WITH ROOFING CONTRACTOR.

SHEET NOTES:

- NEW ROOFTOP UNIT. INSTALL PER MANUFACTURER RECOMMENDATIONS AND APPLICABLE BUILDING CODES.
- NEW ROOF MOUNTED KITCHEN EXHAUST FAN. INSTALL PER MANUFACTURER RECOMMENDATIONS AND APPLICABLE BUILDING CODES. MAINTAIN 10' MINIMUM FROM OUTSIDE AIR INTAKES. RECONNECT EXISTING GREASE DUCT TO NEW FAN. PROVIDE DUCT EXTENSION AND TRANSITIONS AS REQUIRED.
- NEW MAKEUP AIR UNIT. INSTALL PER MANUFACTURER RECOMMENDATIONS AND APPLICABLE BUILDING CODES. RECONNECT EXISTING MAKEUP AIR DUCT TO NEW UNIT.
- NEW EXHAUST FAN. INSTALL PER MANUFACTURER'S RECOMMENDATIONS AND APPLICABLE BUILDING CODES.
- RECONNECT EXISTING DUCT TO NEW EQUIPMENT. PROVIDE TRANSITIONS AS REQUIRED. FIELD VERIFY SPECIFIC LOCATION.

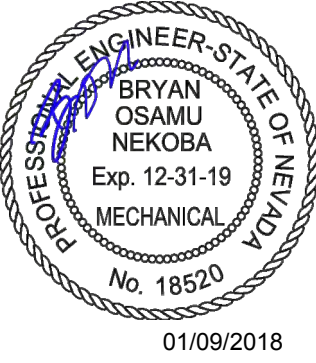

LAS VEGAS SENIOR CENTER HVAC
REPLACEMENT

451 E BONANZA RD
LAS VEGAS, NV 89101



6305 South Valley View Blvd, Suite #416
Las Vegas, Nevada 89118
Phone: (702) 885-4138
Fax: (702) 885-4880
Web: www.hpacen.com
Project #: L17138

CONSULTANTS

ISSUE DATE DESCRIPTION

PROJECT NO: L17138

CAD DWG FILE: M2.2 MECHANICAL ROOF PLAN.DWG

DRAWN BY: HPA

BID NUMBER: 18.69111.02

COPYRIGHT:
© 2017 HPA CONSULTING ENGINEERS

SHEET TITLE

MECHANICAL
ROOF PLAN

513-45Q

M2.2

SHEET - OF -

GAS FIRED MAKE-UP AIR UNIT(S)

FAN UNIT NO.	TAG	FAN UNIT MODEL #	BLDWR	HOUSING	DESIGN CFM	ESP.	RPM	H.P.	B.H.P.	Ø	VOLT	FLA ENTERING D/B	EVAP COOLER ENTERING W/B	EVAP COOLER ENTERING W/B	EVAP COOLER LEAVING TEMP.	EVAP COOLER LEAVING W/B	EVAP COOLER LEAVING TEMP.	WEIGHT (LBS.)	SDNES	BURNER EFFICIENCY(%)
1		A2-1BT-300-G15	G15-PB	A2-1BT-300	2400	0.800	756	1.500	0.9260	3	208	4.6	107.0°F	67.0°F	67.0°F	84.0°F	67.0°F	1383	11	80

GAS FIRED MAKE-UP AIR UNIT(S)

FAN UNIT NO.	TAG	INPUT BTUs	OUTPUT BTUs	TEMP. RISE	REQUIRED INPUT GAS PRESSURE	GAS TYPE
1		139320	111456	43 deg F	7 in. w.c. - 14 in. w.c.	Natural

FAN OPTIONS

FAN UNIT NO.	TAG	OPTION (Qty. = Descr.)
1		1 - Standard Electrical Connection (main and control panel) for Standing Power - Single Module. If a Non-DCV Premix is used on the IBT Heater, the #28, #47, "NS", "MA", or "Ed" Option Premix must be selected. Do not provide supply starter in premise
		1 - Motorized Backdraft Damper for A2-I Housing
		1 - Inlet Pressure Gauge, 0-35"
		1 - Manifold Pressure Gauge, 0 to 10" wc, 1 Furnace
		1 - IBT Evap Interlock
		1 - Freeze Protection Drain Kit for IBTs with Evaporative Coolers

FAN ACCESSORIES

FAN UNIT NO.	TAG	EXHAUST			SUPPLY			
		GREASE CUP	GRAVITY DAMPER	WALL MOUNT	SIDE DISCHARGE	GRAVITY DAMPER	MOTORIZED DAMPER	WALL MOUNT
1							YES	

CURB ASSEMBLIES

NO.	ON FAN	WEIGHT	ITEM	SIZE	
1	# 1	76 LBS	Curb	31.000"W x 79.000"L x 20.000"H	Insulated
	# 1		Rail	6.000"W x 31.000"L x 20.000"H	
	# 1		Rail	4.000"W x 4.000"L x 36.000"H	

FAN #1 INDOOR BOLT TUBE GAS FIRED HEATER WITH 15" BLOWER, 1 FURNACE, ELECTRONIC FLUE MODULATION, CONTROL 80% EFFICIENCY, AND 61 MAX TURNDOWN FLOW INC, 551 MAX TURNDOWN FLOW LPA, STAINLESS STEEL BURNER AND HEAT EXCHANGER.

2. EVAP COILDER (LPF CELDEKO) W/INTAKE HOOD W/EE FILTERS

3. SEPARATE 120V ELECTRICAL CONNECTION FOR EACH 18T HEATER WITH 1 MIDDLE FOR STANDING POWER. 120V MUST BE RUN BY ELECTRICAL FROM BUILDING TO EACH UNIT.

4. 22" BACK DRAIN, 22" 2" DIA. 2" MESH

5. STANDARD 2 MODULAR HEATER UNITS X/EXTENDED SHIELD, STANDARD GALVANNEED CONSTRUCTION, 3/4" REAR FLANGE, 1"20S ATTACHED INCLUDED

6. 1/2" PRESS. TREAD, 1/2" PRESS. TREAD

7. GAS PRESSURE GAUGE, 0 TO 10 INCHES WC, 2 1/2" DIAMETER, 1/8" THREAD, REAR, TREAD

8. LAYER CONTROL

9. FREEZE PROTECTION RANGE CONTROL KIT FOR EVAPORATIVE COILERS, INCLUDES 3-WAY WATER SOLENOID VALVE 83160604

10. 1/2" PRESS. TREAD, 1/2" PRESS. TREAD

11. 1/2" PRESS. TREAD, 1/2" PRESS. TREAD

12. 1/2" PRESS. TREAD, 1/2" PRESS. TREAD

142. 1/2" PRESS. TREAD, 1/2" PRESS. TREAD



143. 1/2" PRESS. TREAD, 1/2" PRESS. TREAD

144. 1/2" PRESS. TREAD, 1/2" PRESS. TREAD

145. 1/2" PRESS. TREAD, 1/2" PRESS. TREAD</

SUPPLY SIDE HEATER INFORMATION:

WINTER TEMPERATURE = 32°F. TEMP. RISE = 43°F.
BTUs CALCULATED OFF STANDARD AIR DENSITY
OUTPUT BTUs AT ALTITUDE OF 0.0 ft. = 111456
INPUT BTUs AT ALTITUDE OF 0.0 ft. = 139320

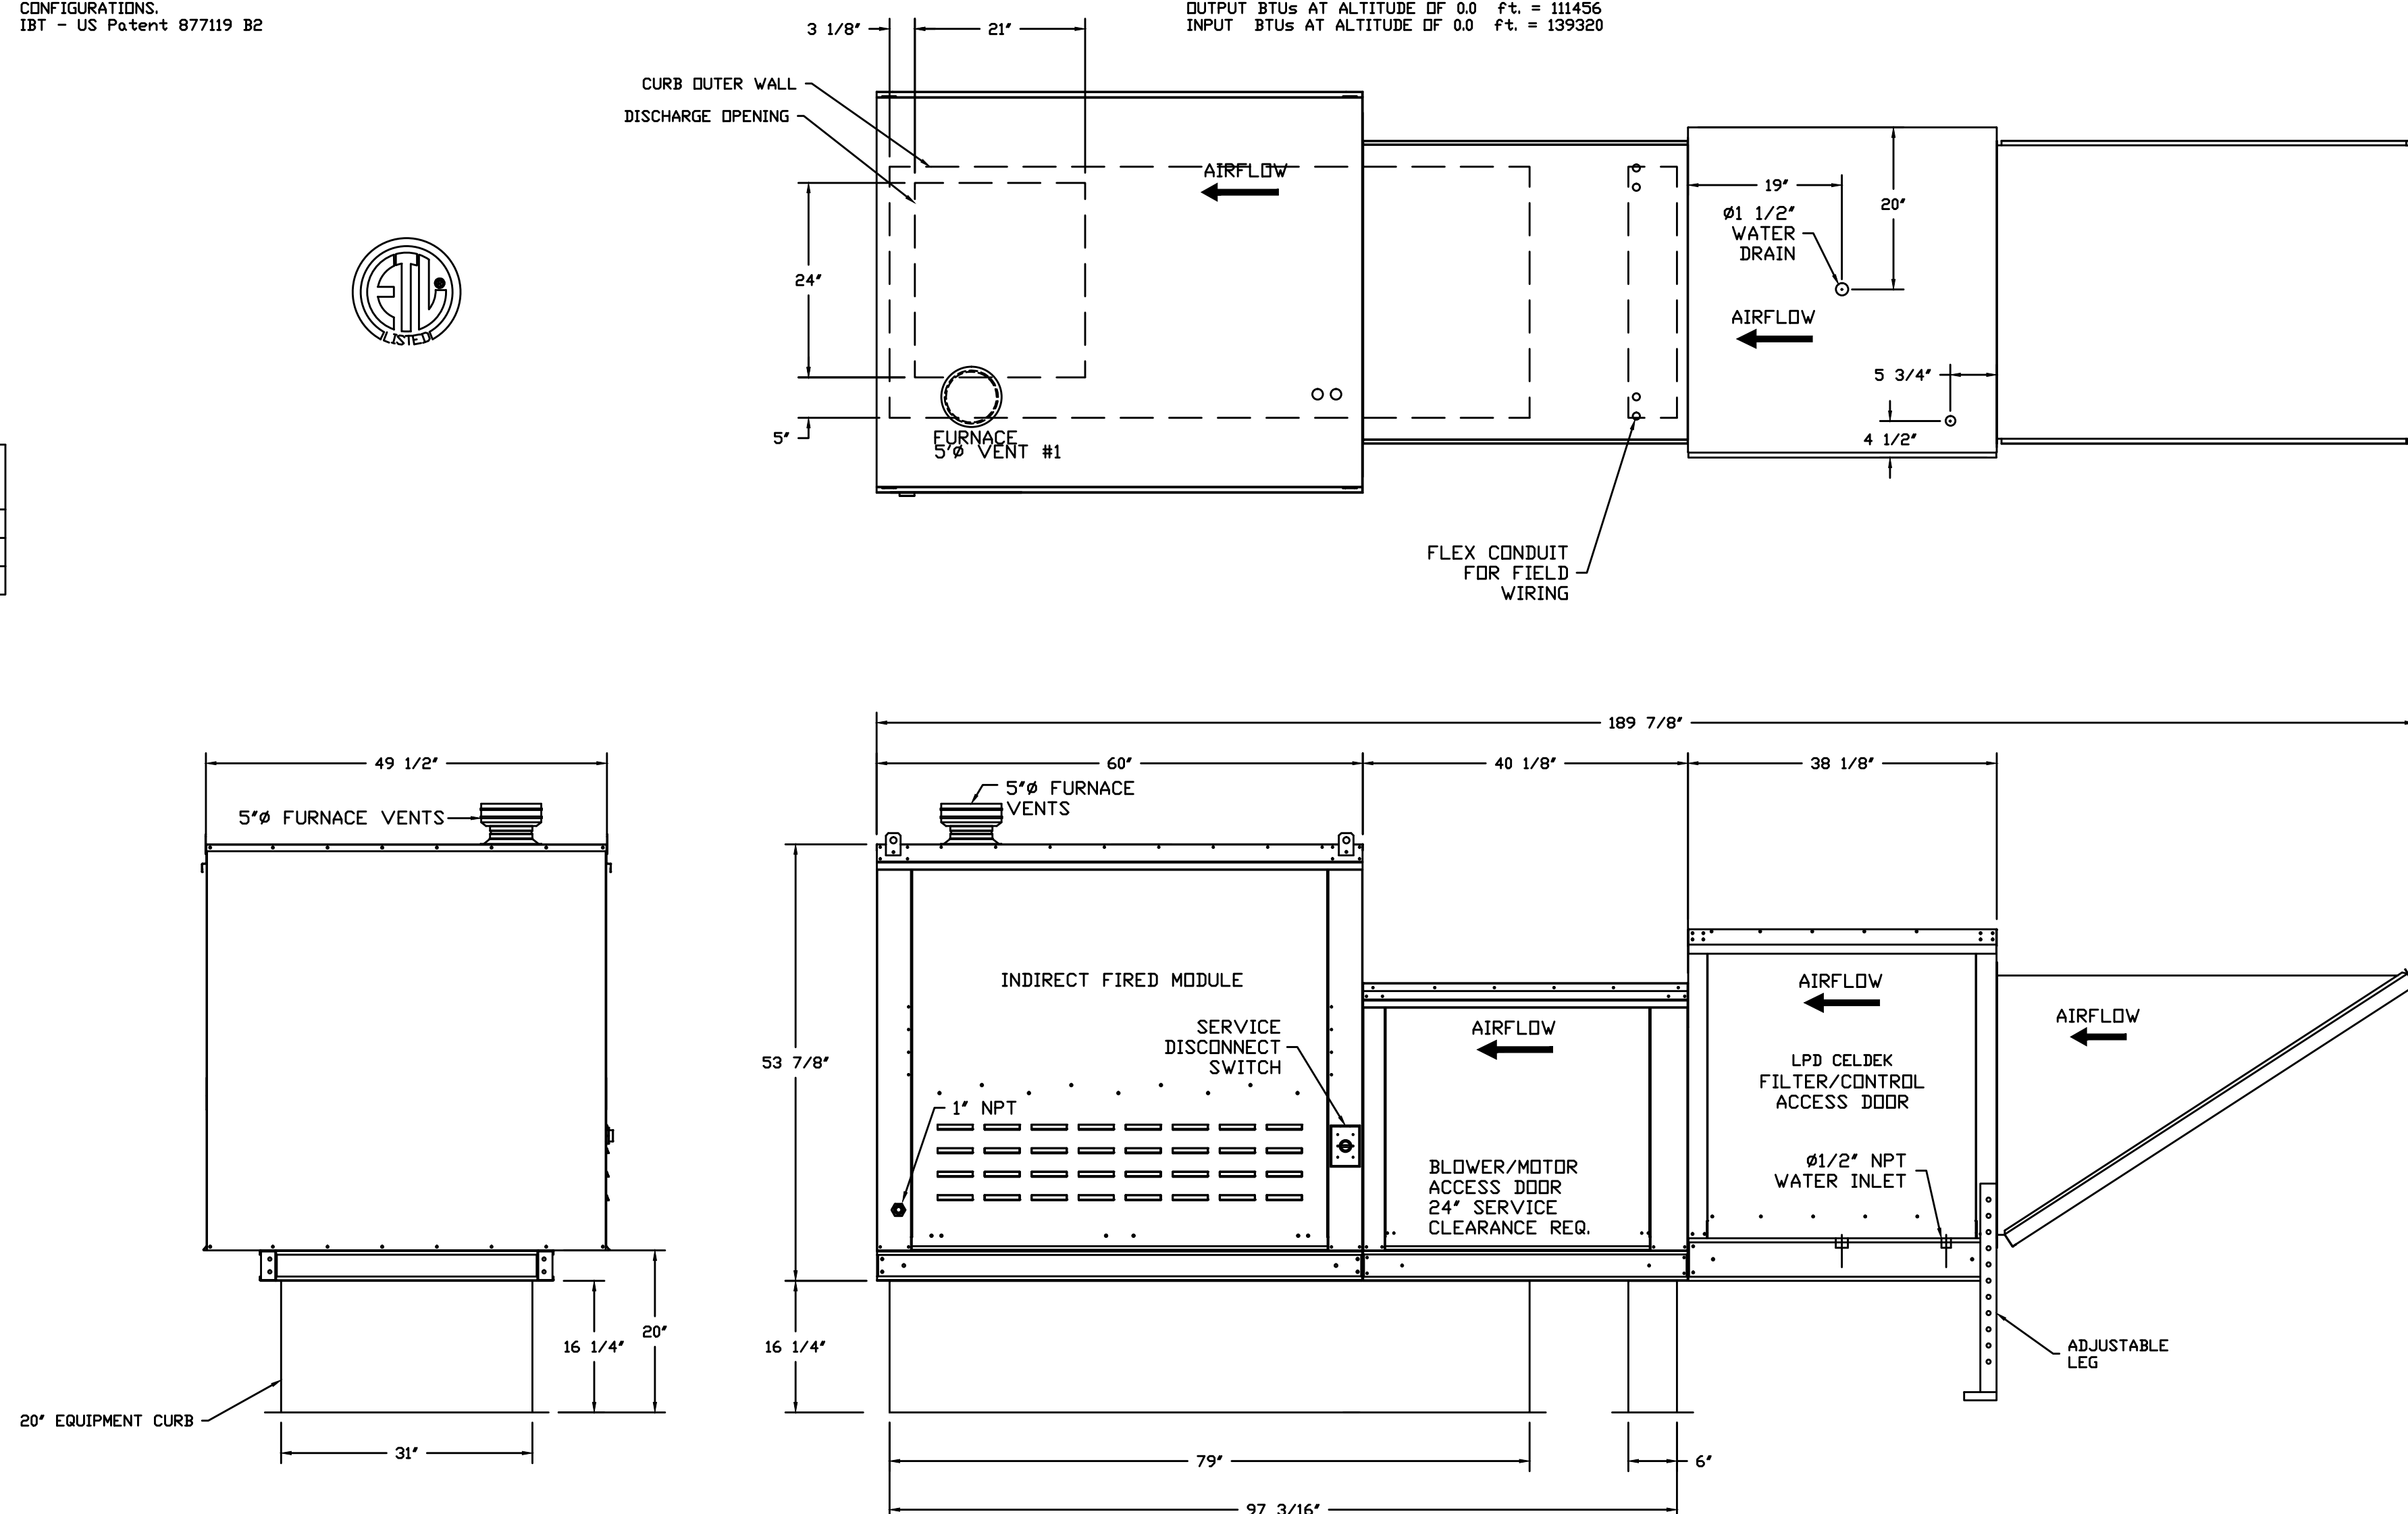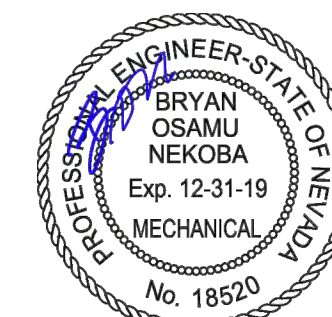[illegible]

**LAS VEGAS SENIOR CENTER HVAC
REPLACEMENT**

451 E BONANZA RD
LAS VEGAS, NV 89101




CONSULTANTS		
ISSUE	DATE	DESCRIPTION
ISSUE DATE:	12.08.2017	
PROJECT NO:	L17138	
CAD DWG FILE:	MFS-TMECHANICAL FOOD SERVICE.DWG	
DRAWN BY:	HPA	
BID NUMBER:	18.691111.02	
COPYRIGHT:		
© 2017 HPA CONSULTING ENGINEERS		
SHEET TITLE		

MECHANICAL
FOOD SERVICE




MFS-2

SHEET OF -

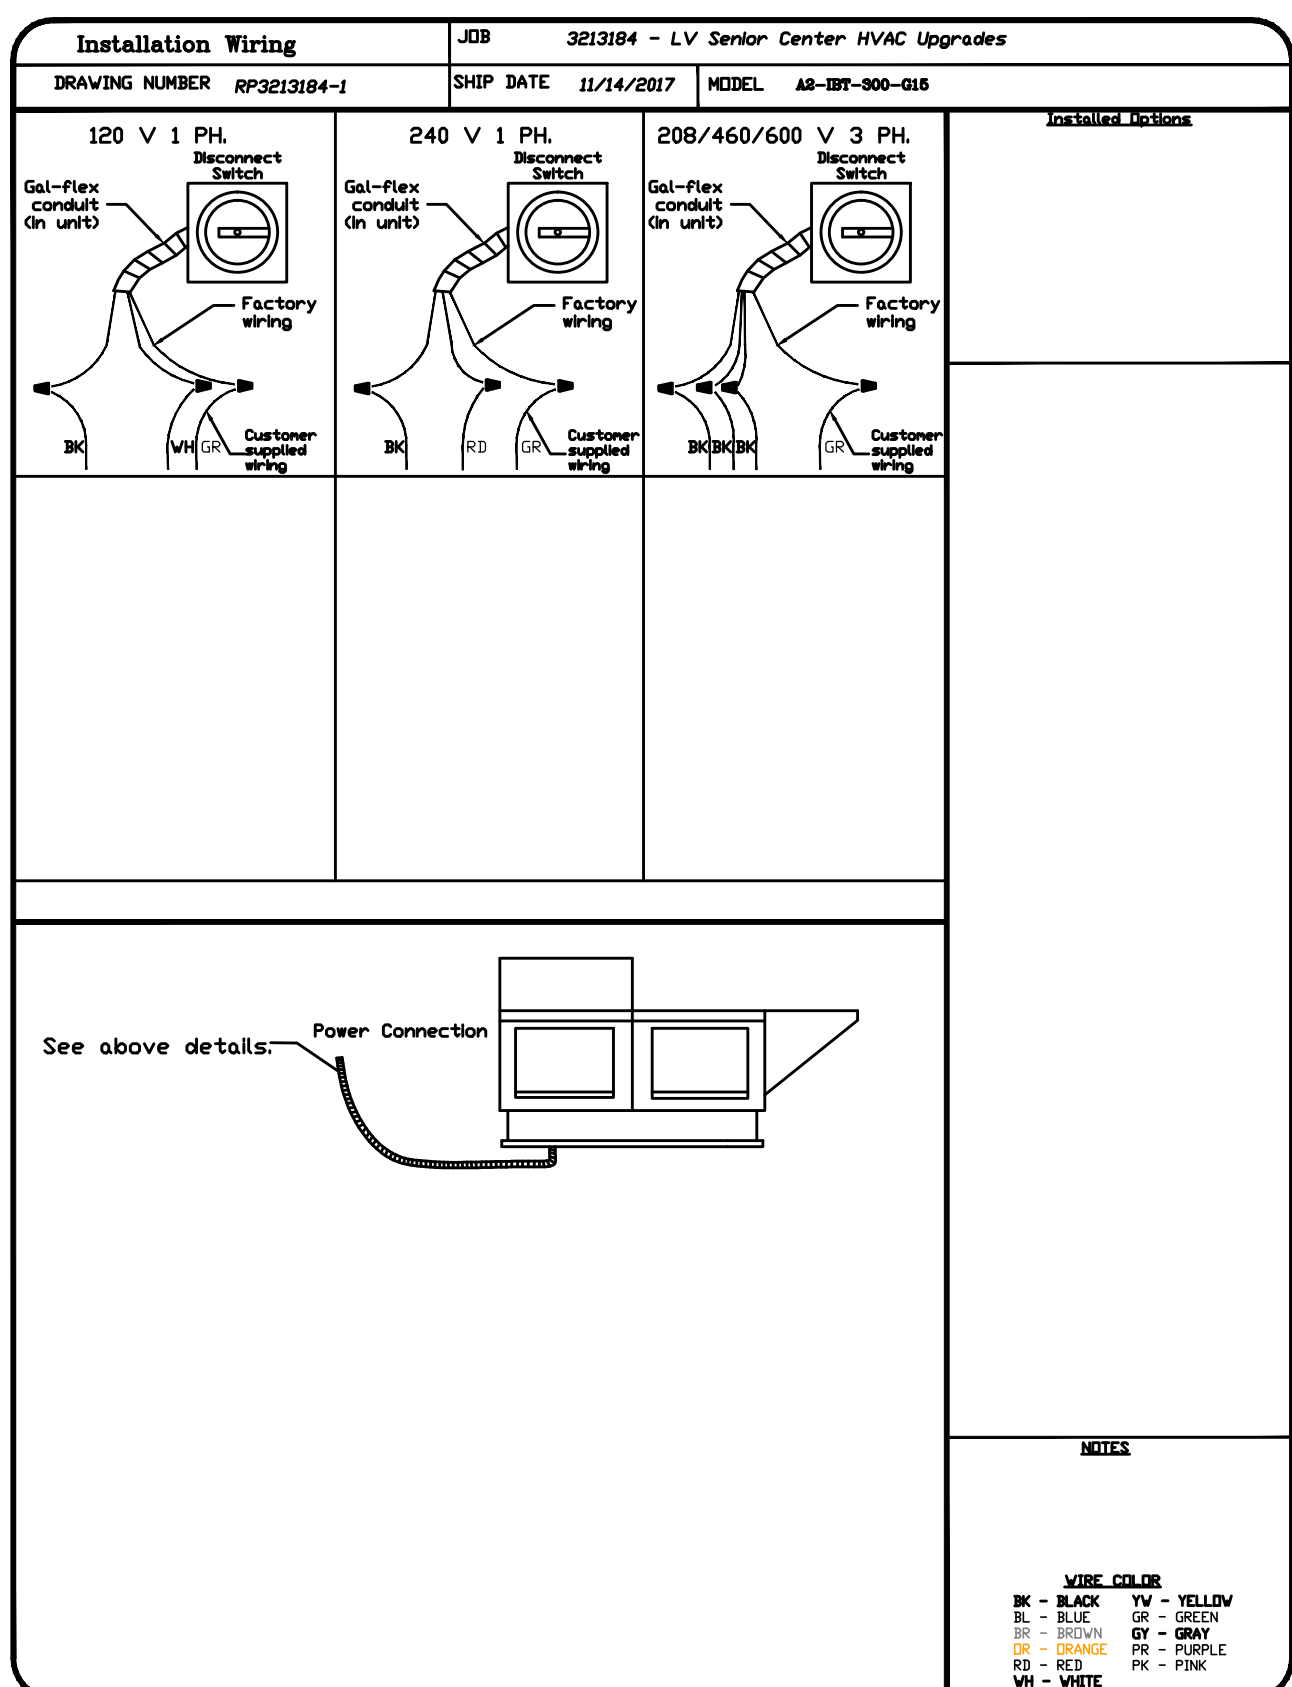

REVISIONS		DATE
DESCRIPTION		
Δ		
Δ		
Δ		
LV Senior Center HVAC Upgrades LAS VEGAS, NV, 89101  CAPTIVE AIR www.captiveair.com Las Vegas 7351 West Charleston Blvd., Suite 130, Las Vegas, NV 89117 PHONE: (702) 508-0455 FAX: (919) 327-5902 EMAIL: ng@captivewa.com		
DATE: 11/14/2017		
DWG.#: 3213184		
DRAWN BY: DRS-84		
SCALE: 3/4" = 1'-0"		
MASTER DRAWING		
SHEET NO.		
2		

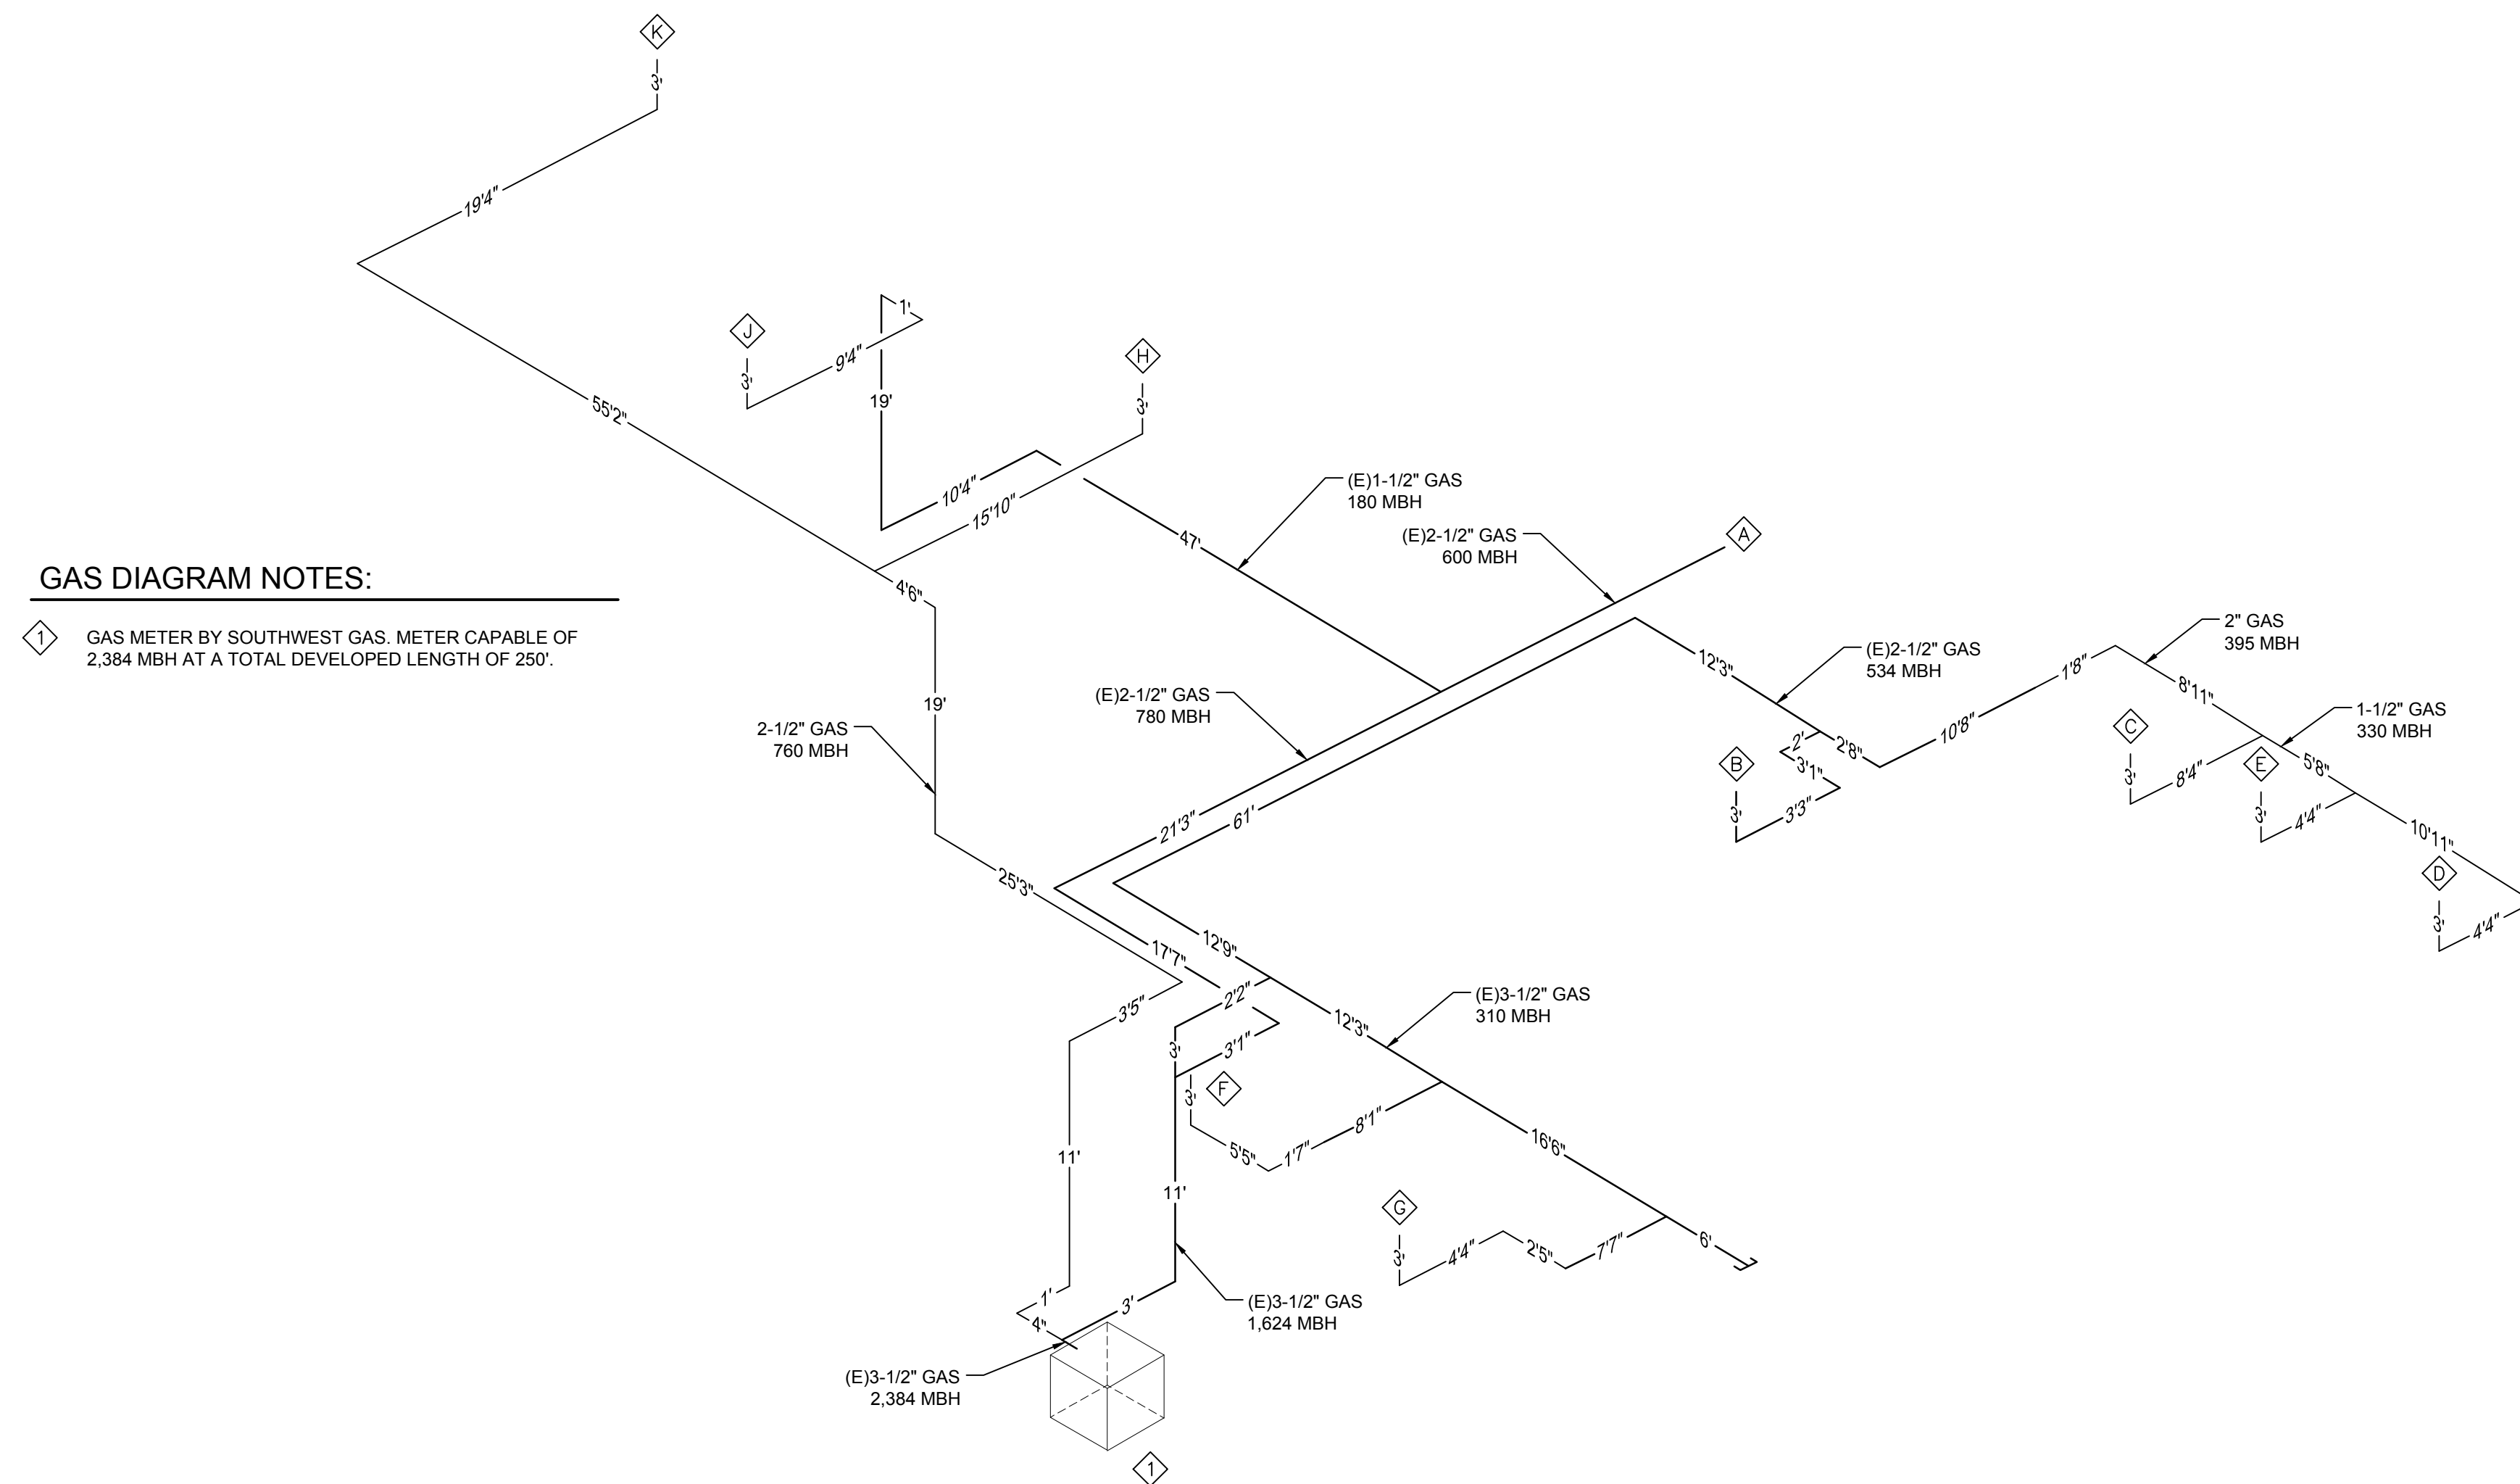

GAS EQUIPMENT SCHEDULE								
LINE ID	TOTAL DEVELOPED LENGTH'	EQUIPMENT	MBH	CONNECTION PIPE SIZE	WATER COLUMN	DIRT LEG	GAS COCK & UNION	NOTES
A	1711"	KITCHEN EQUIP	630	(E)-1/2"	7" WC	PROVIDE	PROVIDE	
B	116"	MU-1	38	(E)-1/2"	7" WC	PROVIDE	PROVIDE	
C	140"	AC-1	85	1"	7" WC	PROVIDE	PROVIDE	
D	1337"	AC-2	89	1 1/4"	7" WC	PROVIDE	PROVIDE	
E	1421"	AC-3	50	1 1/4"	7" WC	PROVIDE	PROVIDE	
F	491"	AC-4	60	1 1/4"	7" WC	PROVIDE	PROVIDE	
G	83.5"	AC-5	50	1 1/4"	7" WC	PROVIDE	PROVIDE	
H	83.4"	AC-6	260	1 1/2"	7" WC	PROVIDE	PROVIDE	
I	1401"	AC-7	80	1 1/2"	7" WC	PROVIDE	PROVIDE	
J	1421"	AC-8	530	2"	7" WC	PROVIDE	PROVIDE	
		TOTAL	2384					

NOTES	
1.	PROVIDE GAS REGULATOR FOR 5 PSI INLET TO 7" W.C. OUTLET.
2.	PROVIDE GAS REGULATOR FOR 2 PSI INLET TO 7" W.C. OUTLET.
3.	VENT REGULATOR PORT FULL SIZE PROVIDE WITH GOOSENECK VENT. VENT SHALL BE A MINIMUM OF 10' FROM ANY FRESH AIR INTAKE.
4.	PROVIDE UNION, VALVE AND SOLENOID VALVE FOR ANSUL SYSTEM. REFER TO HOOD MANUFACTURER FOR INSTALLATION REQUIREMENTS.
5.	REFER TO FIREPLACE INSTALLATION REQUIREMENTS FOR SHUT-OFF VALVE.

GAS METER INFORMATION

PIPE SIZING FROM METER TO OUTLETS H.K. BASED ON A TOTAL DEVELOPED LENGTH OF 225'
PIPE SIZING FROM METER TO OUTLETS A-G. J BASED ON A TOTAL DEVELOPED LENGTH OF 250'
SIZED PER TABLE 1216.2(1) OF THE 2012 UPC. GAS METER 7" W.C. BY SOUTHWEST GAS CORPORATION.

GAS DIAGRAM NOTES:

1 GAS METER BY SOUTHWEST GAS. METER CAPABLE OF 2,384 MBH AT A TOTAL DEVELOPED LENGTH OF 250'.

A GAS ISOMETRIC DIAGRAM
P0.1 NOT TO SCALE

LAS VEGAS SENIOR CENTER HVAC REPLACEMENT

451 E BONANZA RD
LAS VEGAS, NV 89101



South Valley View Blvd, Suite #416
Las Vegas, Nevada 89118
Phone: (702) 685-0136
Fax: (702) 685-8890
Web: www.tspace-llc.com
Project #: L17138

CONSULTANTS		


ISSUE	DATE	DESCRIPTION
ISSUE DATE:	12.08.2017	
PROJECT NO:	L17138	
CAD DWG FILE:	FIG. 1 NATURAL GAS DIAGRAM DWG	
DRAWN BY:	HPA	
BID NUMBER:	18.69111.02	
COPYRIGHT:		
© 2017 HPA CONSULTING ENGINEERS		
SHEET TITLE		

NATURAL GAS DIAGRAM

513-45Q

P0.1

SHEET - OF -

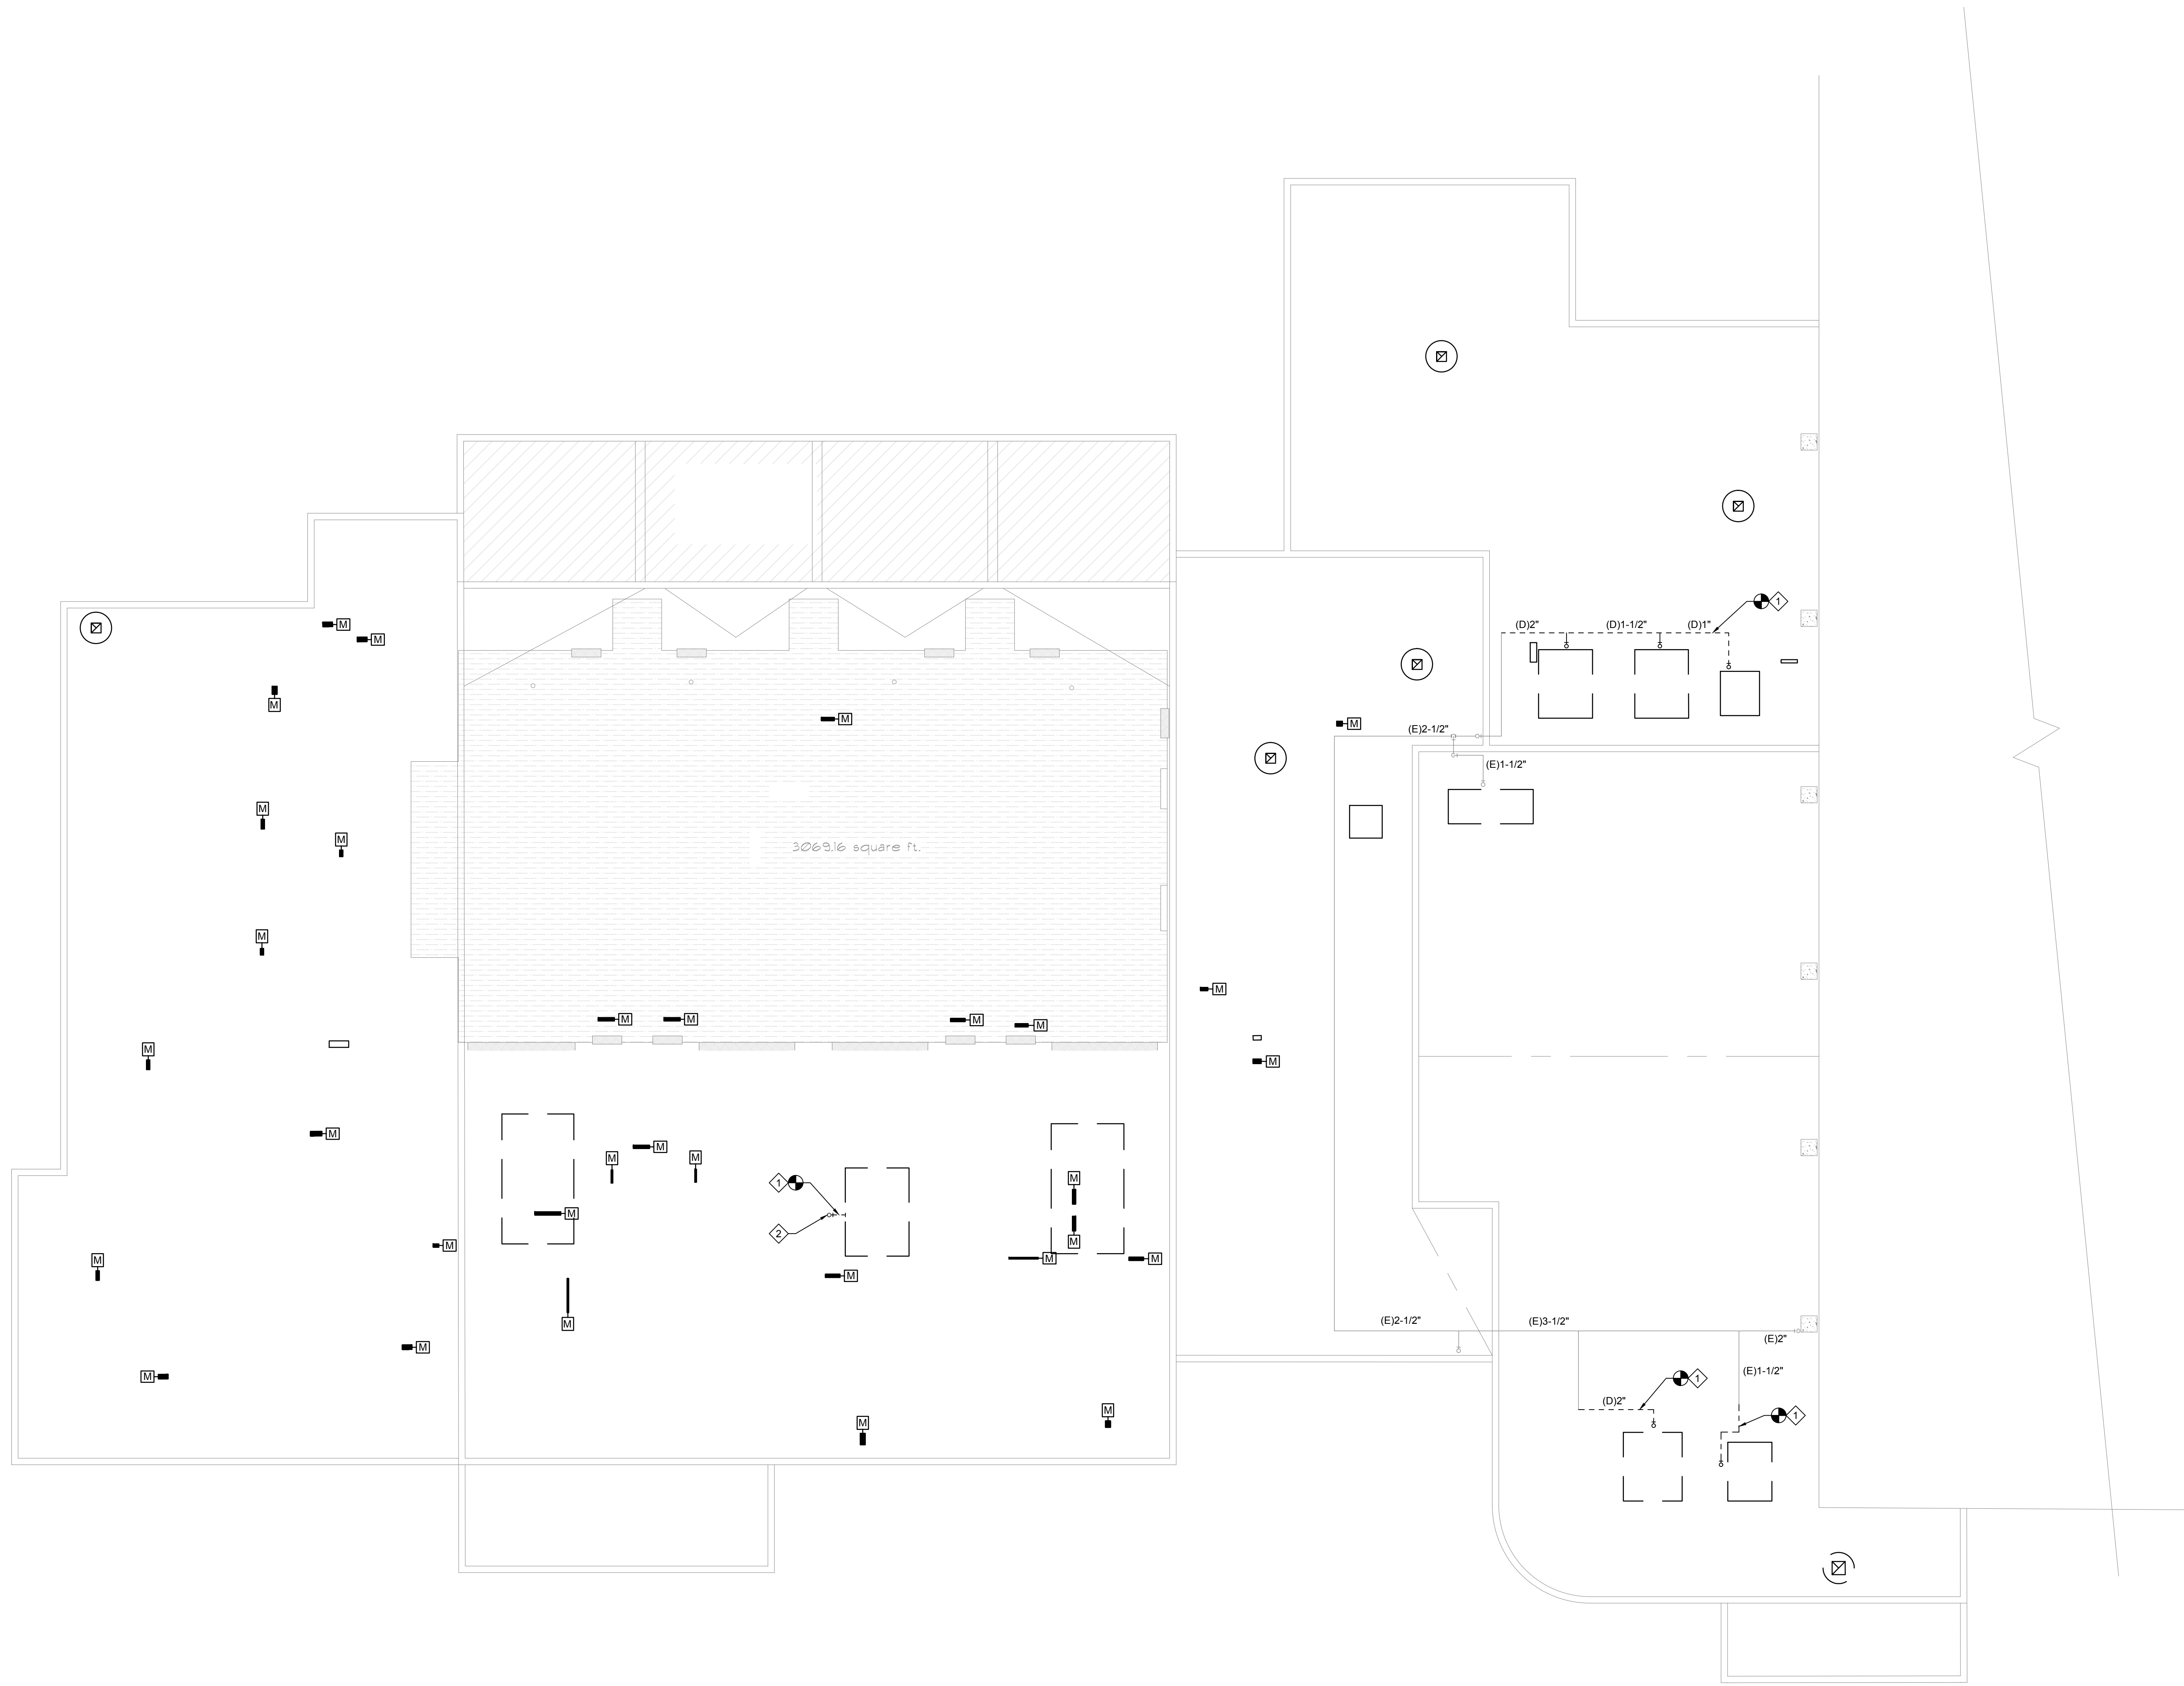


GENERAL NOTES:

- WHERE DUCT OR PIPING IS TO BE REMOVED AT A SPECIFIC POINT, DUCT OR PIPE IS TO BE BLANKED OFF OR CAPPED AND REPAIRED TO LIKE NEW CONDITION.
- PIPING AND EQUIPMENT LOCATIONS SHOWN ARE FROM BEST AVAILABLE INFORMATION. CONTRACTOR TO FIELD VERIFY SPECIFIC LOCATION.
- PIPING DISCONNECTED FROM EQUIPMENT REMOVED. SHALL BE BLANKED OFF OR CAPPED IN CEILING, FLOORS OR WALLS.
- ANY EQUIPMENT OR COMPONENT REMOVED SHALL BE DISPOSED OF PROPERLY BY THE CONTRACTOR AND REMOVED FROM THE PROJECT SITE.

SHEET NOTES:

- 1 REMOVE GAS PIPING UP TO POINT SHOWN. FIELD VERIFY EXACT LOCATION.
- 2 EXISTING GAS LINE TO ROOF TO REMAIN.

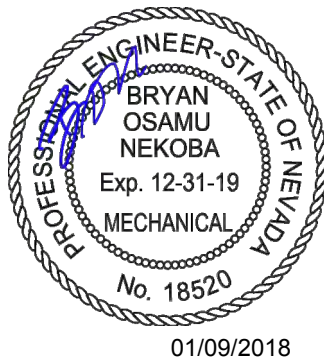

LAS VEGAS SENIOR CENTER HVAC
REPLACEMENT

451 E BONANZA RD
LAS VEGAS, NV 89101



6305 South Valley View Blvd, Suite #410
Las Vegas, Nevada 89118
Phone: (702) 885-4138
Fax: (702) 885-4880
Web: www.hpac-engineers.com
Project #: L17138

CONSULTANTS

ISSUE DATE DESCRIPTION

ISSUE DATE: 12.08.2017

PROJECT NO: L17138

CAD DWG FILE: P02.2 PLUMBING DEMOLITION ROOF PLAN.DWG

DRAWN BY: HPA

BID NUMBER: 18.69111.02

COPYRIGHT:
© 2017 HPA CONSULTING ENGINEERS

SHEET TITLE

PLUMBING
DEMOLITION
ROOF PLAN

513-45Q

PD2.2


SHEET - OF -



1. CONNECT NEW GAS LINE TO EXISTING GAS METER. FIELD VERIFY EXACT LOCATION.
2. EXISTING GAS RISE TO ROOF TO REMAIN.
3. REFER TO SHEET P2.2 FOR CONTINUATION.
4. CONNECT NEW 3/4" DCW TO EXISTING. FIELD VERIFY EXACT LOCATION.
5. 3/4" DCW RISE TO ABOVE.



PLUMBING FLOOR PLAN

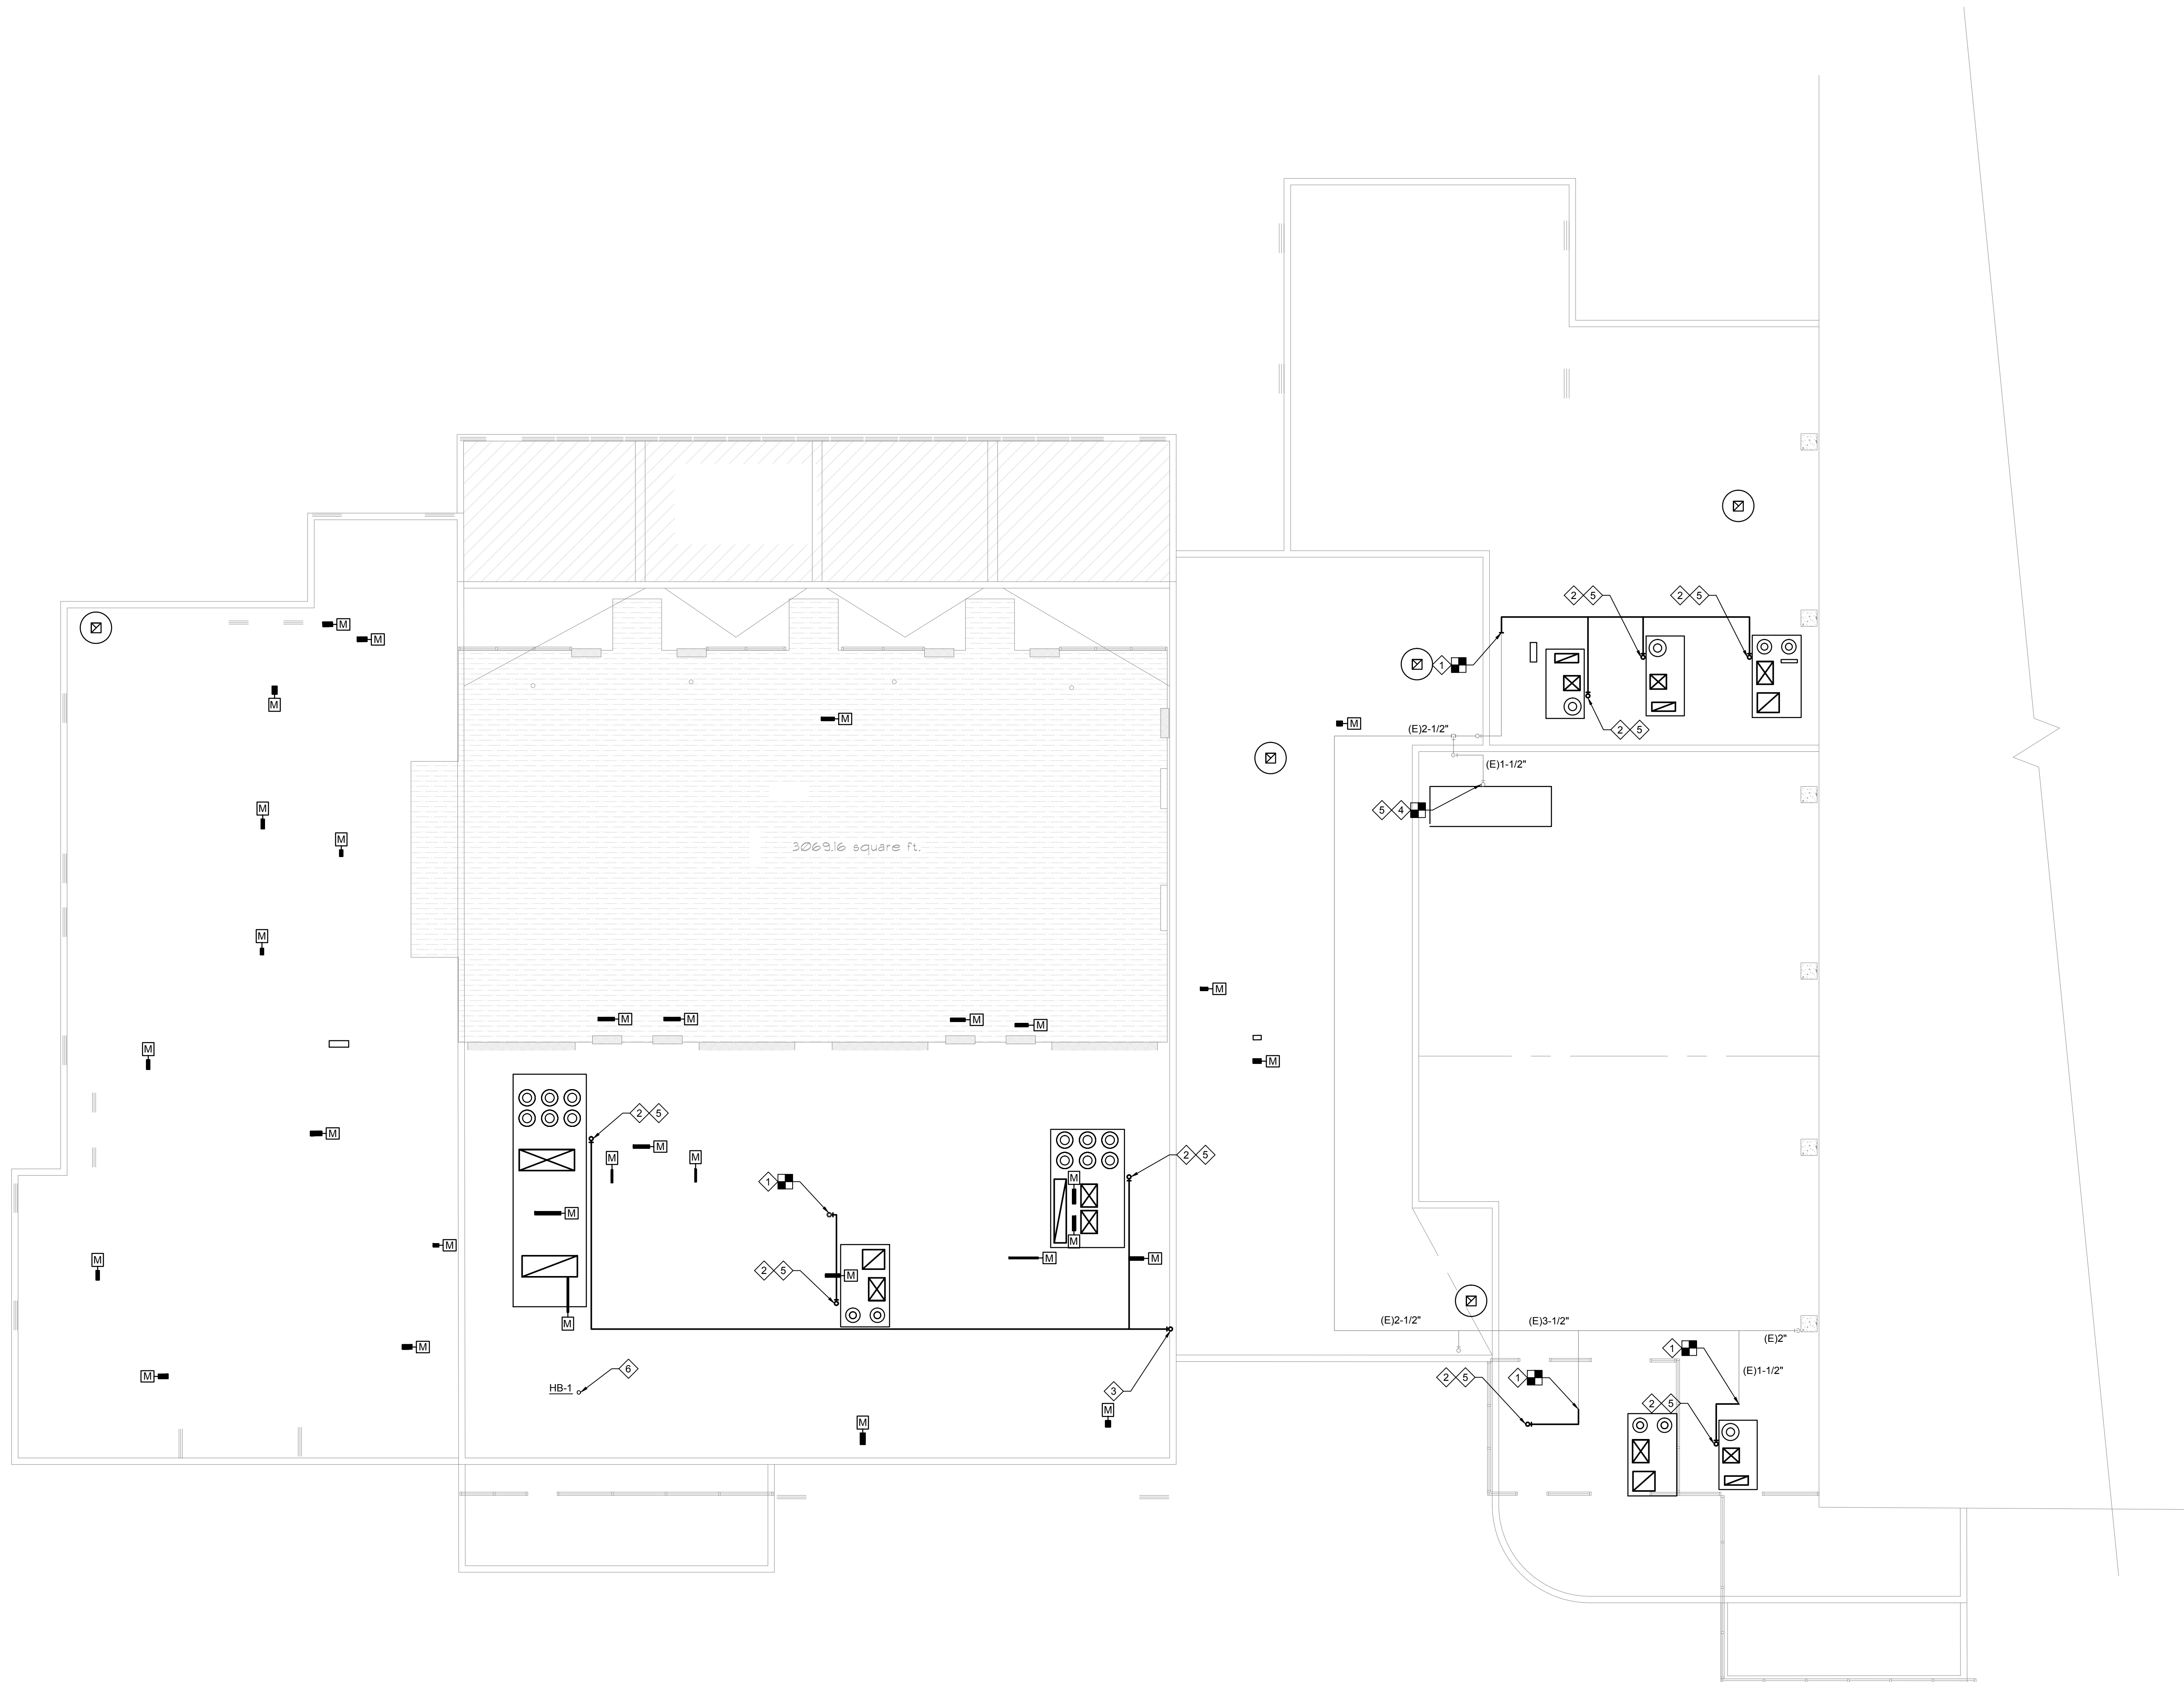


A PLUMBING ROOF PLAN
P2.2 1/8" = 1'-0"

GENERAL NOTES:

1. PRIOR TO PERFORMING WORK, CONTRACTOR TO COORDINATE EXACT PIPE SIZES, INVERT ELEVATIONS, PRESSURES FOR LOCATIONS OF ANY SEWER, WATER PIPING AND WATER METER WITH CIVIL UTILITIES DRAWINGS, AND ANY OTHER ENGINEER AS APPLICABLE.
2. PRIOR TO PERFORMING WORK, CONTRACTOR COORDINATE PIPE ROUTING WITH ALL OTHER TRADES AND EXISTING FIELD CONDITIONS.
3. REFER TO MECHANICAL PLANS FOR PLUMBING SPECIFICATION OF MATERIAL, INSULATION AND INSTALLATION REQUIREMENTS.
4. CONTRACTOR IS RESPONSIBLE FOR ROUGH-IN COORDINATION AND LOCATIONS. REFER TO ARCHITECTURAL PLANS FOR LOCATIONS AND FIXTURES.
5. CONTRACTOR IS RESPONSIBLE FOR ANY REQUIRED CUTTING AND PATCHING.
6. ALL NOTCHING, BORING, AND CUTTING OF HOLES IN WALL STUDS AND FLOOR JOISTS SHALL BE PERFORMED BASED ON THE LATEST ADOPTED AND APPROVED EDITION OF THE BUILDING CODE.
7. ALL PLUMBING FIXTURES SHALL BE OF WATER CONSERVATION TYPE AS REQUIRED BY LOCAL AUTHORITY HAVING JURISDICTION.
8. ALL WATER CLOSETS IDENTIFIED AS ACCESSIBLE SHALL HAVE THE FLUSH VALVE ACTUATOR INSTALLED ON THE WIDE SIDE.
9. ALL WATER PIPING SHALL BE INSTALLED ON INTERIOR SIDE OF THE BUILDING WALL INSULATION.
10. CONTRACTOR SHALL PROVIDE VALVES LOCATED ABOVE LAY-IN CEILING OR 24"X24" CEILING ACCESS PANEL. COORDINATE FINAL LOCATION AND SIZE WITH ARCHITECT. PROVIDE BALANCING VALVES FOR HOT WATER RETURN SYSTEM AS REQUIRED.
11. ALL SANITARY DRAINAGE PIPING 3" AND SMALLER SHALL BE SLOPED AT 1/4" PER FOOT. PIPING 4" AND LARGER SHALL BE SLOPED AT 1/8" PER FOOT.
12. ALL CONDENSATE DRAIN PIPING SHALL BE SLOPED AT 1/8" PER FOOT AND PROVIDE ACCESSIBLE CLEANOUTS AT ALL CHANGES OF DIRECTION.
13. VENTS THAT TERMINATE AT THE ROOF SHALL BE A MINIMUM OF 10' FROM ANY FRESH AIR INTAKE.
14. REFER TO THE PLUMBING DIAGRAMS FOR GUIDANCE OF INSTALLATION INTENT. CONTRACTOR IS TO PROVIDE ALL COMPONENTS NECESSARY TO MEET THE DESIGN INTENT, WHETHER SHOWN IN DIAGRAM OR NOT.
15. SECONDARY CONDENSATE DRAIN FROM MECHANICAL UNIT DRAIN PAN ROUTE AND DISCHARGE AT A POINT THAT IS READILY OBSERVED. COORDINATE FINAL LOCATION WITH ARCHITECT.

SHEET NOTES:

1. CONNECT NEW GAS TO EXISTING GAS. FIELD VERIFY EXACT LOCATION.
2. GAS CONNECT TO MECHANICAL UNIT.
3. REFER TO SHEET P2.1 FOR CONTINUATION.
4. RECONNECT EXISTING GAS TO NEW MECHANICAL UNIT.
5. RECONNECT EXISTING CONDENSATE TO NEW MECHANICAL UNIT.
6. 3/4" DCW RISE FROM BELOW.

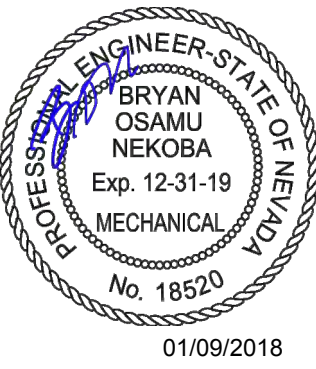

LAS VEGAS SENIOR CENTER HVAC
REPLACEMENT

451 E BONANZA RD
LAS VEGAS, NV 89101



6305 South Valley View Blvd, Suite #416
Las Vegas, Nevada 89118
Phone: (702) 855-4138
Fax: (702) 855-4880
Web: www.hpacen.com
Project #: L17138

CONSULTANTS

ISSUE DATE DESCRIPTION

ISSUE DATE: 12.08.2017

PROJECT NO: L17138

CAD DWG FILE: P2.2 PLUMBING ROOF PLAN.DWG

DRAWN BY: HPA

BID NUMBER: 18.69111.02

COPYRIGHT: © 2017 HPA CONSULTING ENGINEERS

SHEET TITLE

PLUMBING
ROOF PLAN

513-45Q


P2.2

SHEET - OF -

ELECTRICAL SINGLE LINE DIAGRAMS

GENERAL NOTES:

1. EXISTING TO REMAIN SHOWN LIGHT AND/OR DESIGNATED WITH AN 'E'; EXISTING TO BE REMOVED SHOWN LIGHT AND/OR DESIGNATED WITH A 'R'. NEW SHOWN BOLD.
2. EXISTING SINGLE LINE DIAGRAMS ARE BASED UPON EXISTING DRAWINGS AND INFORMATION AVAILABLE AT THE TIME OF DESIGN. CONTRACTOR TO VERIFY EXISTING TO BE REUSED SWITCH BOARDS, DISTRIBUTION BOARDS, MOTOR CONTROL CENTERS, PANELS AND NOTIFY DESIGN ENGINEER OF ANY DISCREPANCIES PRIOR TO COMMENCEMENT OF WORK.
3. THE ENGINEER OF RECORD HAS PERFORMED VOLTAGE DROP CALCULATIONS AND ALL BRANCH CIRCUITS AND FEEDERS COMPLY WITH NEC 210-15(A) FPN NO.4.

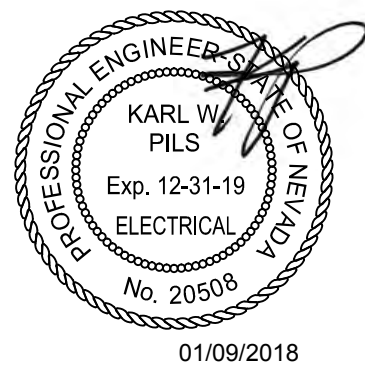

SHEET NOTES:

1. EXISTING DISCONNECT SWITCHED TO BE REMOVED AND REPLACED WITH NEW. REFER TO ELECTRICAL ROOF PLAN FOR LOCATION.
2. EXISTING CONDUCTORS TO BE REMOVED AND REPLACED WITH NEW. CONDUIT MAY BE REUSED IF IT MEETS CURRENT CODE AND CITY OF LAS VEGAS STANDARDS.
3. EXISTING CONDUIT AND CONDUCTORS TO BE REMOVED AND REPLACE.
4. ROUTE 1 1/2" CONDUIT WITH 4#6 THWN, AND 1#10 THWN COPPER GROUND.
5. ROUTE 3/4" CONDUIT WITH 4#10 THWN, AND 1#10 THWN COPPER GROUND.
6. CONDUIT MAY BE REUSED IF IT MEETS CURRENT CODE AND CITY OF LAS VEGAS STANDARDS.
7. EXISTING CONDUIT AND CONDUCTORS FEEDING TAP JUNCTION BOX TO REMAIN.
8. EXISTING EXTERIOR, NEMA 3R, TAPISPLICE JUNCTION BOX TO REMAIN.
9. FURNISH AND INSTALL NEW WEATHER PROOF FUSED DISCONNECT. FUSE PER MANUFACTURERS NAMEPLATE. COORDINATE WITH MECHANICAL CONTRACTOR FOR SPECIFIC LOCATION AND POINT OF CONNECTION.
10. PROVIDE NEW CIRCUIT BREAKER IN EXISTING MAIN SERVICE BOARD. ITE IMPERIAL CORPORATION FC-20 SERIES. PROVIDE ALL MOUNTING HARDWARE AND BRACKETS AS REQUIRED FOR A COMPLETE INSTALLATION.
11. TEMPORARILY DISCONNECT EXISTING FEEDER SERVING MECHANICAL UNIT AND CONNECT TO NEW UNIT INSTALLED IN SAME LOCATION. PROVIDE ADDITIONAL CONDUIT, CONDUCTOR, JUNCTIONS BOXES, ETC. AS REQUIRED TO CONNECT UNIT AND DISCONNECT.
12. EXISTING FEEDER SERVING MECHANICAL UNIT TO BE REMOVED AND REPLACED WITH NEW.
13. ROUTE 2 1/2" CONDUIT WITH 4#4/0 THWN AND 1#4 THWN COPPER GROUND

LAS VEGAS SENIOR CENTER HVAC REPLACEMENT

451 E BONANZARD LAS VEGAS, NV 89101



6305 South Valley View Blvd, Suite #415
Las Vegas, Nevada 89118
Phone: (702) 855-4138
Fax: (702) 855-4880
Web: www.hpac.com
Project #: L17138

Panel: A (EXISTING)

LOCATION: ELECTRICAL ROOM

FLOOR PLAN: X

PANEL VOLTAGE: 120/208 3Ø, 4W

BUS: 225 AMPS

MAIN: L.O. 225 AMPS

A/C RATING: 10,000 AMPS

CIRCUIT CODE: N: NON-CONTINUOUS
C: CONTINUOUS
R: DEMANDABLE RECEPTS
K: KITCHEN: (0)

M: MOTOR
P: PANEL
E: ELEV: (0)

LOAD DESIGNATION				CONNECTED VA										LOAD DESIGNATION											
CKT NO	CODE	TRIP	POLE	DESCRIPTION	NOTE	REC'D	LEG	0A	0B	0C	A	B	C	0B	0C	LEG	REC'D	INSIC	NOTE	DESCRIPTION	TRIP	POLE	CODE	CKT NO	
1	C	20	1	(E) SERVICE AREA LTG	1		1	1,100						800		14	9		1	(E) SNAKE BAR LTG	20	1	C	4	
3	C	20	1	(E) KITCHEN LTG	1		1												1	(E) STORAGE, CORR LTG	20	1	C	2	
5	N	20	1	(E) EXTERIOR RECEPTS N.W.	1		1		500										1	(E) POWER N.W.	20	1	N	6	
7	N	20	1	(E) EXTERIOR RECEPTS S.E.	1		1	500						500					1	(E) POWER S.E.	20	1	N	8	
9	N	20	1	(E) SPARE	1										540		3		3	ROOF RECEPTS	20	1	N	10	
11	N	20	1	(E) SPARE	1														1	(E) SPARE	20	1	N	12	
13	N	20	1	(E) SPARE	1														1	(E) SPARE	20	1	N	14	
15	N	20	1	(E) SPARE	1														1	(E) SPARE	20	1	N	16	
17	R	20	1	(E) BATTERY PACK	1				1,500							360	2		1	(E) EXTERIOR RECEPTS	20	1	N	18	
19	R	20	1	(E) MULTI USER RM.	1		3	540						360					3	(E) TOILET RM AREA	20	1	R	20	
21	R	20	1	(E) MULTI USER RM.	1		2	360							540		3		1	(E) TOILET RM AREA	20	1	R	22	
23	R	20	1	(E) MULTI USER RM.	1		2	360							540	3		1	(E) TOILET RM AREA	20	1	R	24		
25	R	20	1	(E) MULTI USER RM.	1		3	540						360		2		1	(E) TOILET RM AREA	20	1	R	26		
27	R	20	1	(E) TELE BOARD	1		1	180							360		2		1	(E) CORRIDOR RECEPTS	20	1	R	28	
29	N	20	1	(E) EF	1		1		200							180	1		1	(E) SOUND SYSTEM	20	1	R	30	
31	N	20	1	(E) SPARE	1														1	(E) SPARE	20	1	N	32	
33	N	20	1	(E) SPARE	1											222			1	(E) WH - CIRC PUMP	20	1	N	34	
35	N	20	1	(E) WATER COOLER	1		2		400							100	#	2	2	WAV'S	20	1	N	36	
37	P	70	1	(E) PANEL 'A'	1			3,419						100			#	2	2	WAV'S	20	1	N	38	
39	P	70	1		1										2,225				1	(E) WATER HEATER	30	4	N	40	
41	P	3		1					2,000							2,225			1	1		20	2	N	42

PANEL NOTES:

PHASE TOTALS 0A: 8,219 0B: 10,665 0C: 8,865

1 EXISTING CIRCUIT BREAKER / LOAD

2 REPLACED LOAD WITH NEW ON EXISTING CIRCUIT

3 NEW LOAD ON EXISTING SPARE BREAKER.

PANEL(S) TOTAL CONNECTED VA	25,877
PANEL(S) DEMAND KVA	28.8
PANEL(S) DEMAND AMPS	79.9
LARGEST Ø DEMAND AMPS	93.7

Panel: C (Also labeled 'A1')				PANEL VOLTAGE: 120/208 3Ø, 4W		CIRCUIT CODE:		N: NON-CONTINUOUS		M: MOTOR										
SLD: X FLOOR PLAN: X				BUS: 225 AMPS				C: CONTINUOUS		P: PANEL										
LOCATION: ELECTRICAL ROOM				MAIN: L.O. 225 AMPS				R: DEMANDABLE RECEPTS		E: ELEV: (0)										
A/C RATING: 10,000 AMPS				MOUNTING: SURFACE				K: KITCHEN: (0)												
LOAD DESIGNATION				CONNECTED VA				LOAD DESIGNATION												
CKT NO	CODE	TRIP	POLE	DESCRIPTION	NOTE	ØA	ØB	ØC	ØA	ØB	ØC	RECP	INISC	NOTE	DESCRIPTION	TRIP	POLE	CODE	CKT NO	
1	N	20	1	(E) CARD READER	1	1,400			A	B	C	1,080			1	(E) CARD ROOM RECEP	20	1	R	2
3	N	20	1	(E) LIGHT REC ROOM	1	1,400						1,000			1	(E) CARD ROOM RECEP	20	1	R	4
5	N	20	1	(E) LIGHT REC ROOM	1		1,600					600			1	(E) CARD ROOM RECEP	20	1	N	6
7	N	20	1	(E) LIGHT REC ROOM	1	1,500						1,500			1	(E) LIGHTING POOL RM	20	1	N	8
9	N	20	1	(E) VESTIBULE	1		1,600					1,500			1	(E) LIGHTING POOL RM	20	1	N	10
11	N	20	1	(E) CLASSROOM	1		1,700					1,200			1	(E) LIGHTING POOL RM	20	1	N	12
13	N	20	1	(E) UTIL SPACES	1	700						720			1	(E) RECEP	20	1	R	14
15	R	20	1	(E) DUCT SMOKE RECEP	1		900					900			1	(E) RECEP	20	1	R	16
17	R	20	1	(E) RECEP	1		720					900			2	(E) DUCT SMOKE RECEP	20	1	R	18
19	R	20	1	(E) RECEP	1	720						500			1	(E) EWIC	20	1	N	20
21	N	20	1	(E) DOOR OPREATOR	1		1,200					1,500			1	(E) VEND. MACH	20	1	N	22
23	N	15	---	MAU-1	2		552					1,500			1	(E) VEND. MACH	20	1	N	24
25	N	---	---	---	2		552					3,000			1	(E) VEH	40	2	N	26
27	N	---	---	---	2		552					3,000			1	---	40	2	N	28
29	N	15	---	KEF-1	2			1,272				200			1	(E) H.W.C.P	20	1	N	30
31	N	---	---	---	2		1,272								2	(E) SPARE	20	1	N	32
33	N	---	---	---	2		1,272					360			2	(E) DATA BOX RECEP	20	1	R	34
35	N	20	1	(E) F-3	1		510								1	(E) DATA BOX RECEP	20	1	R	36
37	R	20	1	(E) COMPUTER LAB RECEPT	1	4	720					720			4	(E) DATA BOX RECEP	20	1	R	38
39	R	20	1	(E) COMPUTER LAB RECEPT	1	4	720					720			4	(E) DATA BOX RECEP	20	1	R	40
41	R	20	1	(E) COMPUTER LAB RECEPT	1	4	720									SPACE			N	42
PANEL NOTES:				PHASE TOTALS		ØA: 14,384		ØB: 16,624		ØC: 12,194		PANEL(S) TOTAL CONNECTED VA: 43,202								
												PANEL(S) DEMAND KVA: 42.9								
												PANEL(S) DEMAND AMPS: 119.1								
												LARGEST Ø DEMAND AMPS: 137.7								
1 EXISTING CIRCUIT BREAKER / LOAD.																				
2 EXISTING EQUIPMENT REPLACED WITH NEW ON SAME CIRCUIT.																				

Panel: K (EXISTING)				PANEL VOLTAGE: 120/208 3Ø, 4W		CIRCUIT CODE:		N: NON-CONTINUOUS C: CONTINUOUS R: DEMANDABLE RECEPTS K: KITCHEN (28)		M: MOTOR P: PANEL E: ELEV: (0)											
SLD: X FLOOR PLAN: X				BUS: 225 AMPS		MAIN: L.O. 225 AMPS															
LOCATION: ELECTRICAL ROOM				A/C RATING: 10,000 AMPS		MOUNTING: FLUSH															
LOAD DESIGNATION				CONNECTED VA						LOAD DESIGNATION											
CKT NO	CODE	TRIP	POLE	DESCRIPTION	NOTE	RECP	LGTS	ØA	ØB	ØC	RECP	LGTS	ØA	ØB	ØC	DESCRIPTION	TRIP	POLE	CODE	CKT NO	
1	K	20	1	(E) VENDING MACHINE	1	1	500	ØA	ØC			1	1	180			(E) KITCHEN RECEPTACLE	20	1	K	2
3	K	20	1	(E) VENDING MACHINE	1	1	500					1	1	180			(E) KITCHEN RECEPTACLE	20	1	K	4
5	K	20	1	(E) VENDING MACHINE	1	1	500			500		1	1	500			(E) KITCHEN RECEPTACLE	20	1	K	6
7	K	20	1	(E) VENDING MACHINE	1	1	500					1	1				(E) KITCHEN RECEPTACLE	20	1	K	8
9	K	20	1	(E) LOBBY	1	1	400					1	1	180			(E) KITCHEN RECEPTACLE	20	1	K	10
11	K	20	1	(E) REFRIG	1	1	200			200		1	1	180			(E) KITCHEN RECEPTACLE	20	1	K	12
13	K	20	1	(E) REF-FREEZER	1	1	200					1	1	180			(E) COUNTER RECEPTS	20	1	K	14
15	K	20	1	(E) DISHWASHER	1	1	500					1	1	180			(E) COUNTER RECEPTS	20	1	K	16
17	K	20	1	(E) DISHWASHER	1	1	500					1	1	360			(E) GARBAGE DISPOSAL	20	1	K	18
19	K	20	1	(E) BUN WARMER	1	1	750					1	1	2,160			(E) ICE MAKER	30	1	K	20
21	K	20	1		1	1	750					1	1	2,160				2	2	K	22
23	K	20	1	EF-4	1	1	1,656					1	1	800			(E) EF-5	20	1	K	24
25	K	20	1	(E) GARBAGE DISPOSAL	1	1	1,920					1	1	1,920			(E) GARBAGE DISPOSAL	20	1	K	26
27	K	20	1		1	1	1,920					1	1	1,920				30	1	K	28
29	K	30	1		1	1	1,920					1	1	1,920				3	3	K	30
31	K	70	1	(E) COOK TOP	1	1	2,000					1	1	2,000			(E) COOK TOP	70	1	K	32
33	K	70	1		1	1	2,000					1	1	2,000				3	3	K	34
35	K	30	1		1	1	2,000					1	1	2,000				3	3	K	36
37	K	70	1	(E) DOUBLE OVEN	1	1	2,000					1	1	2,000			(E) DOUBLE OVEN	70	1	K	38
39	K	70	1		1	1	2,000					1	1	2,000				3	3	K	40
41	K	30	1		1	1	2,000					1	1	2,000				3	3	K	42
PANEL NOTES:				PHASE TOTALS		ØA: 16,490		ØB: 16,690		ØC: 16,536		PANEL(S) TOTAL CONNECTED VA:		49,716							
1- EXISTING CIRCUIT BREAKER / LOAD												PANEL(S) DEMAND KVA:		32.3							
												PANEL(S) DEMAND AMPS:		89.7							
												LARGEST Ø DEMAND AMPS:		90.4							

Panel: B1

SLD: X

FLOOR PLAN: X

LOCATION: X

PANEL VOLTAGE: 120/208 3Ø, 4W

BUS: 100 AMPS

MAIN: L.O. 100 AMPS

A/C RATING: 10,000 AMPS

CIRCUIT CODE: N: NON-CONTINUOUS
C: CONTINUOUS
R: DEMANDABLE RECEPTS
K: KITCHEN: (0)

M: MOTOR
P: PANEL
E: ELEV: (0)

LOAD DESIGNATION

CONNECTED VA

CKT NO

CODE

TRIP

POLE

DESCRIPTION

NOTE

1

REC'D

LTG

ØA

ØB

ØC

A

B

C

ØA

ØB

ØC

LTG

REC'D

NOTE

DESCRIPTION

TRIP

POLE

CODE

CKT NO

1

N

20

1

(E) MEN-VEST CORR

360

(E) FAN

20

1

N

2

3

N

20

1

(E) FIRE ALARM PANEL

360

(E) REC ROOM 9

20

1

N

4

5

N

20

1

(E) FIRE ALARM PANEL

360

SPARE

20

1

N

6

7

N

20

1

SPARE

SPARE

20

1

N

8

9

N

20

1

FANS #3

1

624

SPARE

20

1

N

10

11

N

20

1

FANS #2

1

624

SPARE

20

1

N

12

13

N

20

1

FANS #1

1

696

SPARE

20

1

N

14

15

N

20

1

FANS #5

1

624

SPARE

20

1

N

16

17

N

20

1

ROOF RECEPTS EAST

3

540

SPARE

20

1

N

18

PANEL NOTES:

PHASE TOTALS

ØA: 1,136

ØB: 2,148

ØC: 1,524

PANEL(S) TOTAL CONNECTED VA: 4,808

PANEL(S) DEMAND KVA: 4.8

PANEL(S) DEMAND AMPS: 13.3

LARGEST Ø DEMAND AMPS: 17.9

1 EXISTING EQUIPMENT REPLACED WITH NEW ON SAME CIRCUIT.

CONSULTANTS		
ISSUE	DATE	DESCRIPTION
ISSUE	DATE	12.08.2017
PROJECT NO:	L17138	
CAD DWG FILE:	EQ2 ELECTRICAL SINGLE LINE DIAGRAMS AND PANEL SCHEDULES.DWG	
DRAWN BY:	HPA	
BID NUMBER:	18.69111.02	
COPYRIGHT:		
© 2017 HPA CONSULTING ENGINEERS		
SHEET TITLE		

ELECTRICAL SINGLE LINE DIAGRAMS AND PANEL SCHEDULES

513-45Q

E0.2


SHEET - OF -

GENERAL NOTES:

- EXISTING TO REMAIN SHOWN SOLID AND/OR DESIGNATED WITH AN (E), EXISTING TO BE REMOVED SHOWN DASHED AND/OR DESIGNATED WITH A (X), EXISTING TO BE RELOCATED DESIGNATED WITH AN (R).
- EXISTING ITEMS AND CONDUIT ARE BASED UPON EXISTING DRAWINGS AND INFORMATION AVAILABLE AT THE TIME OF DESIGN. CONTRACTOR TO VERIFY EXISTING LOCATIONS.
- EXISTING TO BE REMOVED ITEMS SHALL HAVE ASSOCIATED CONDUIT, JUNCTION BOXES, WIRE, CABLE, ETC REMOVED TO SOURCE OR FIRST EXISTING TO REMAIN ITEM.
- EXISTING TO REMAIN ITEMS AND ITS ASSOCIATED CONDUIT, JUNCTION BOXES, WIRE, CABLE, ETC. SHALL BE INSPECTED FOR PROPER OPERATION AND CONDITION AS PER THEIR RESPECTIVE MANUFACTURER RECOMMENDATIONS AND LOCAL/NATIONAL CODES. IF ANY SUCH ITEM IS FOUND TO NOT MEET THESE REQUIREMENTS, IT SHALL BE REPLACED WITH EQUIVALENT ITEM.
- EXISTING TO BE RELOCATED LIGHT FIXTURES SHALL BE CLEANED AND RELAMPED PRIOR TO ROUGH-IN. IF ANY LIGHT FIXTURE IS DAMAGED OR DEFECTIVE, IT SHALL BE REPLACED WITH EQUIVALENT FIXTURE OF SAME TYPE, LAMP QUANTITY, AND ACCESSORIES.

SHEET NOTES:

- DISCONNECT EXISTING VAV AND CIRCUITING BACK TO AN ACCESSIBLE POINT. MAINTAIN CONTINUITY OF DOWNSTREAM DEVICES.

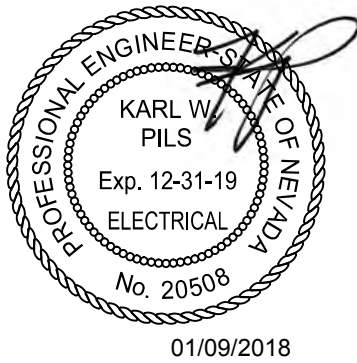

LAS VEGAS SENIOR CENTER HVAC
REPLACEMENT

451 E BONANZA RD
LAS VEGAS, NV 89101



6305 South Valley View Blvd, Suite #410
Las Vegas, Nevada 89118
Phone: (702) 885-4138
Fax: (702) 885-4880
Web: www.hpacnv.com
Project #: L17138

CONSULTANTS

ISSUE DATE DESCRIPTION

ISSUE DATE: 12.08.2017

PROJECT NO: L17138

CAD DWG FILE: E02.1 ELECTRICAL DEMOLITION FLOOR PLAN.DWG

DRAWN BY: HPA

BID NUMBER: 18.69111.02

COPYRIGHT:

© 2017 HPA CONSULTING ENGINEERS


SHEET TITLE

ELECTRICAL
DEMOLITION
FLOOR PLAN

513-45Q

ED2.1

SHEET - OF -

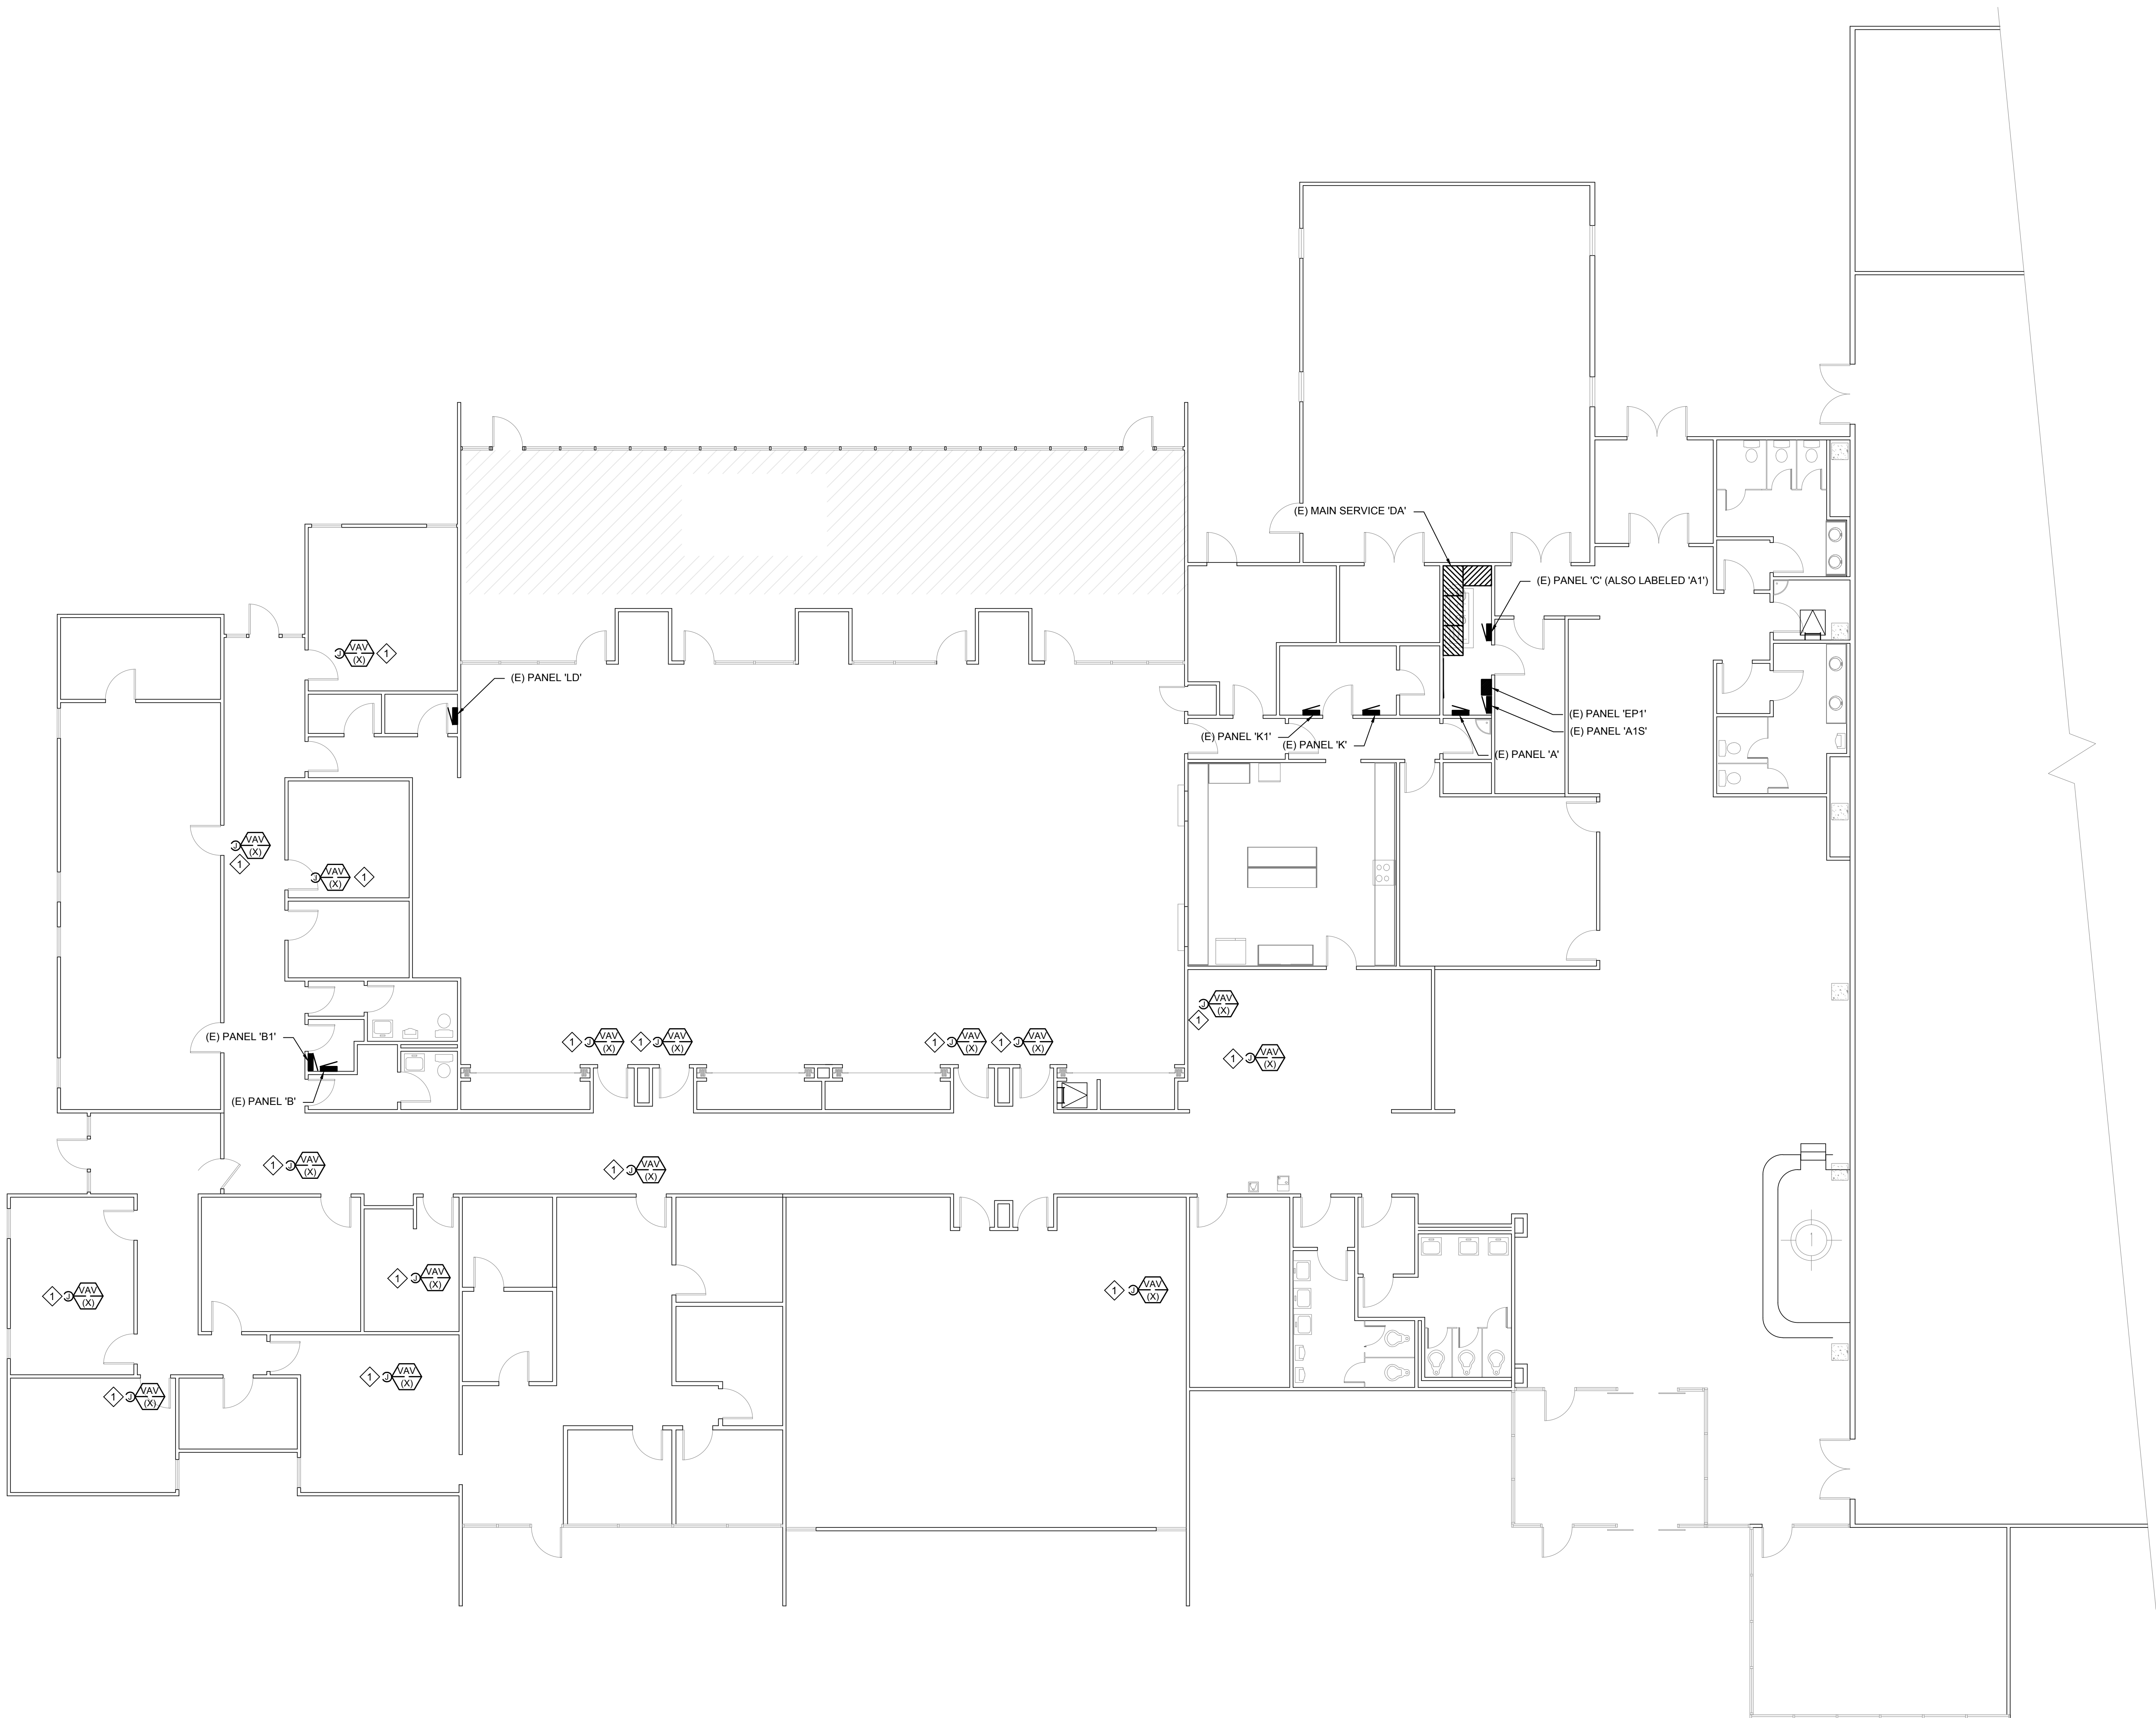


A
E02.1
ELECTRICAL DEMOLITION FLOOR PLAN
E02.1 1/8" = 1'-0"

GENERAL NOTES:

- EXISTING TO REMAIN SHOWN SOLID AND/OR DESIGNATED WITH AN (E), EXISTING TO BE REMOVED SHOWN DASHED AND/OR DESIGNATED WITH A (X), EXISTING TO BE RELOCATED DESIGNATED WITH AN (R).
- EXISTING ITEMS AND CONDUIT ARE BASED UPON EXISTING DRAWINGS AND INFORMATION AVAILABLE AT THE TIME OF DESIGN. CONTRACTOR TO VERIFY EXISTING LOCATIONS.
- EXISTING TO BE REMOVED ITEMS SHALL HAVE ASSOCIATED CONDUIT, JUNCTION BOXES, WIRE, CABLE, ETC REMOVED TO SOURCE OR FIRST EXISTING TO REMAIN ITEM.
- EXISTING TO REMAIN ITEMS AND ITS ASSOCIATED CONDUIT, JUNCTION BOXES, WIRE, CABLE, ETC. SHALL BE INSPECTED FOR PROPER OPERATION AND CONDITION AS PER THEIR RESPECTIVE MANUFACTURER RECOMMENDATIONS AND LOCAL/NATIONAL CODES. IF ANY SUCH ITEM IS FOUND TO NOT MEET THESE REQUIREMENTS, IT SHALL BE REPLACED WITH EQUIVALENT ITEM.
- EXISTING TO BE RELOCATED LIGHT FIXTURES SHALL BE CLEANED AND RELAMPED PRIOR TO ROUGH-IN. IF ANY LIGHT FIXTURE IS DAMAGED OR DEFECTIVE, IT SHALL BE REPLACED WITH EQUIVALENT FIXTURE OF SAME TYPE, LAMP QUANTITY, AND ACCESSORIES.

SHEET NOTES:

- EXISTING ROOF TOP UNIT TO BE REMOVED AND REPLACED WITH NEW IN SAME LOCATION. EXISTING CIRCUITING TO REMAIN FOR NEW UNIT.
- EXISTING NEMA 3R JUNCTION BOX ON ROOFWITH MECHANICAL UNIT FEEDERS TO REMAIN.
- EXISTING EXHAUST FAN TO BE REMOVED. REMOVE DISCONNECT, CONDUIT AND CIRCUITING BACK TO SOURCE.
- EXISTING KITCHEN EXHAUST FAN TO BE REMOVED AND REPLACED WITH NEW IN SAME LOCATION. EXISTING CIRCUITING TO REMAIN FOR NEW UNIT.
- EXISTING MAKE UP AIR UNIT TO BE REMOVED AND REPLACED WITH NEW IN SAME LOCATION. EXISTING CIRCUITING TO REMAIN FOR NEW UNIT.
- EXISTING EXHAUST FAN TO BE REMOVED AND REPLACED WITH NEW IN SAME LOCATION. EXISTING CIRCUITING TO REMAIN FOR NEW UNIT.
- EXISTING ROOF TOP UNIT TO BE REMOVED AND REPLACED WITH NEW LARGER UNIT IN SAME LOCATION. REMOVE EXISTING CIRCUITING BACK TO SOURCE.
- EXISTING ROOF TOP UNIT TO BE REMOVED AND REPLACED WITH NEW IN SAME LOCATION. REMOVE DISCONNECT SWITCH, CONDUIT, AND CONDUCTORS, BACK TO EXISTING TAP JUNCTION BOX.

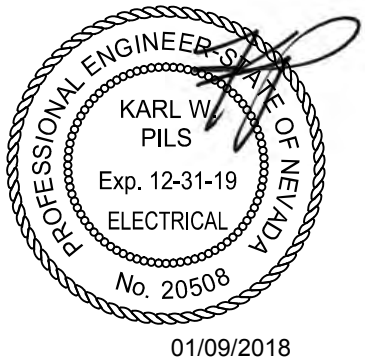

LAS VEGAS SENIOR CENTER HVAC
REPLACEMENT

451 E BONANZA RD
LAS VEGAS, NV 89101



6305 South Valley View Blvd, Suite #416
Las Vegas, Nevada 89118
Phone: (702) 855-4138
Fax: (702) 855-4880
Web: www.hpacen.com
Project #: L17138

CONSULTANTS

ISSUE DATE DESCRIPTION

PROJECT NO: L17138

CAD DWG FILE: 6002 ELECTRICAL DEMOLITION ROOF PLAN.DWG

DRAWN BY: HPA

BID NUMBER: 18.69111.02

COPYRIGHT:
© 2017 HPA CONSULTING ENGINEERS


SHEET TITLE

ELECTRICAL
DEMOLITION
ROOF PLAN

513-45Q

ED2.2

SHEET - OF -

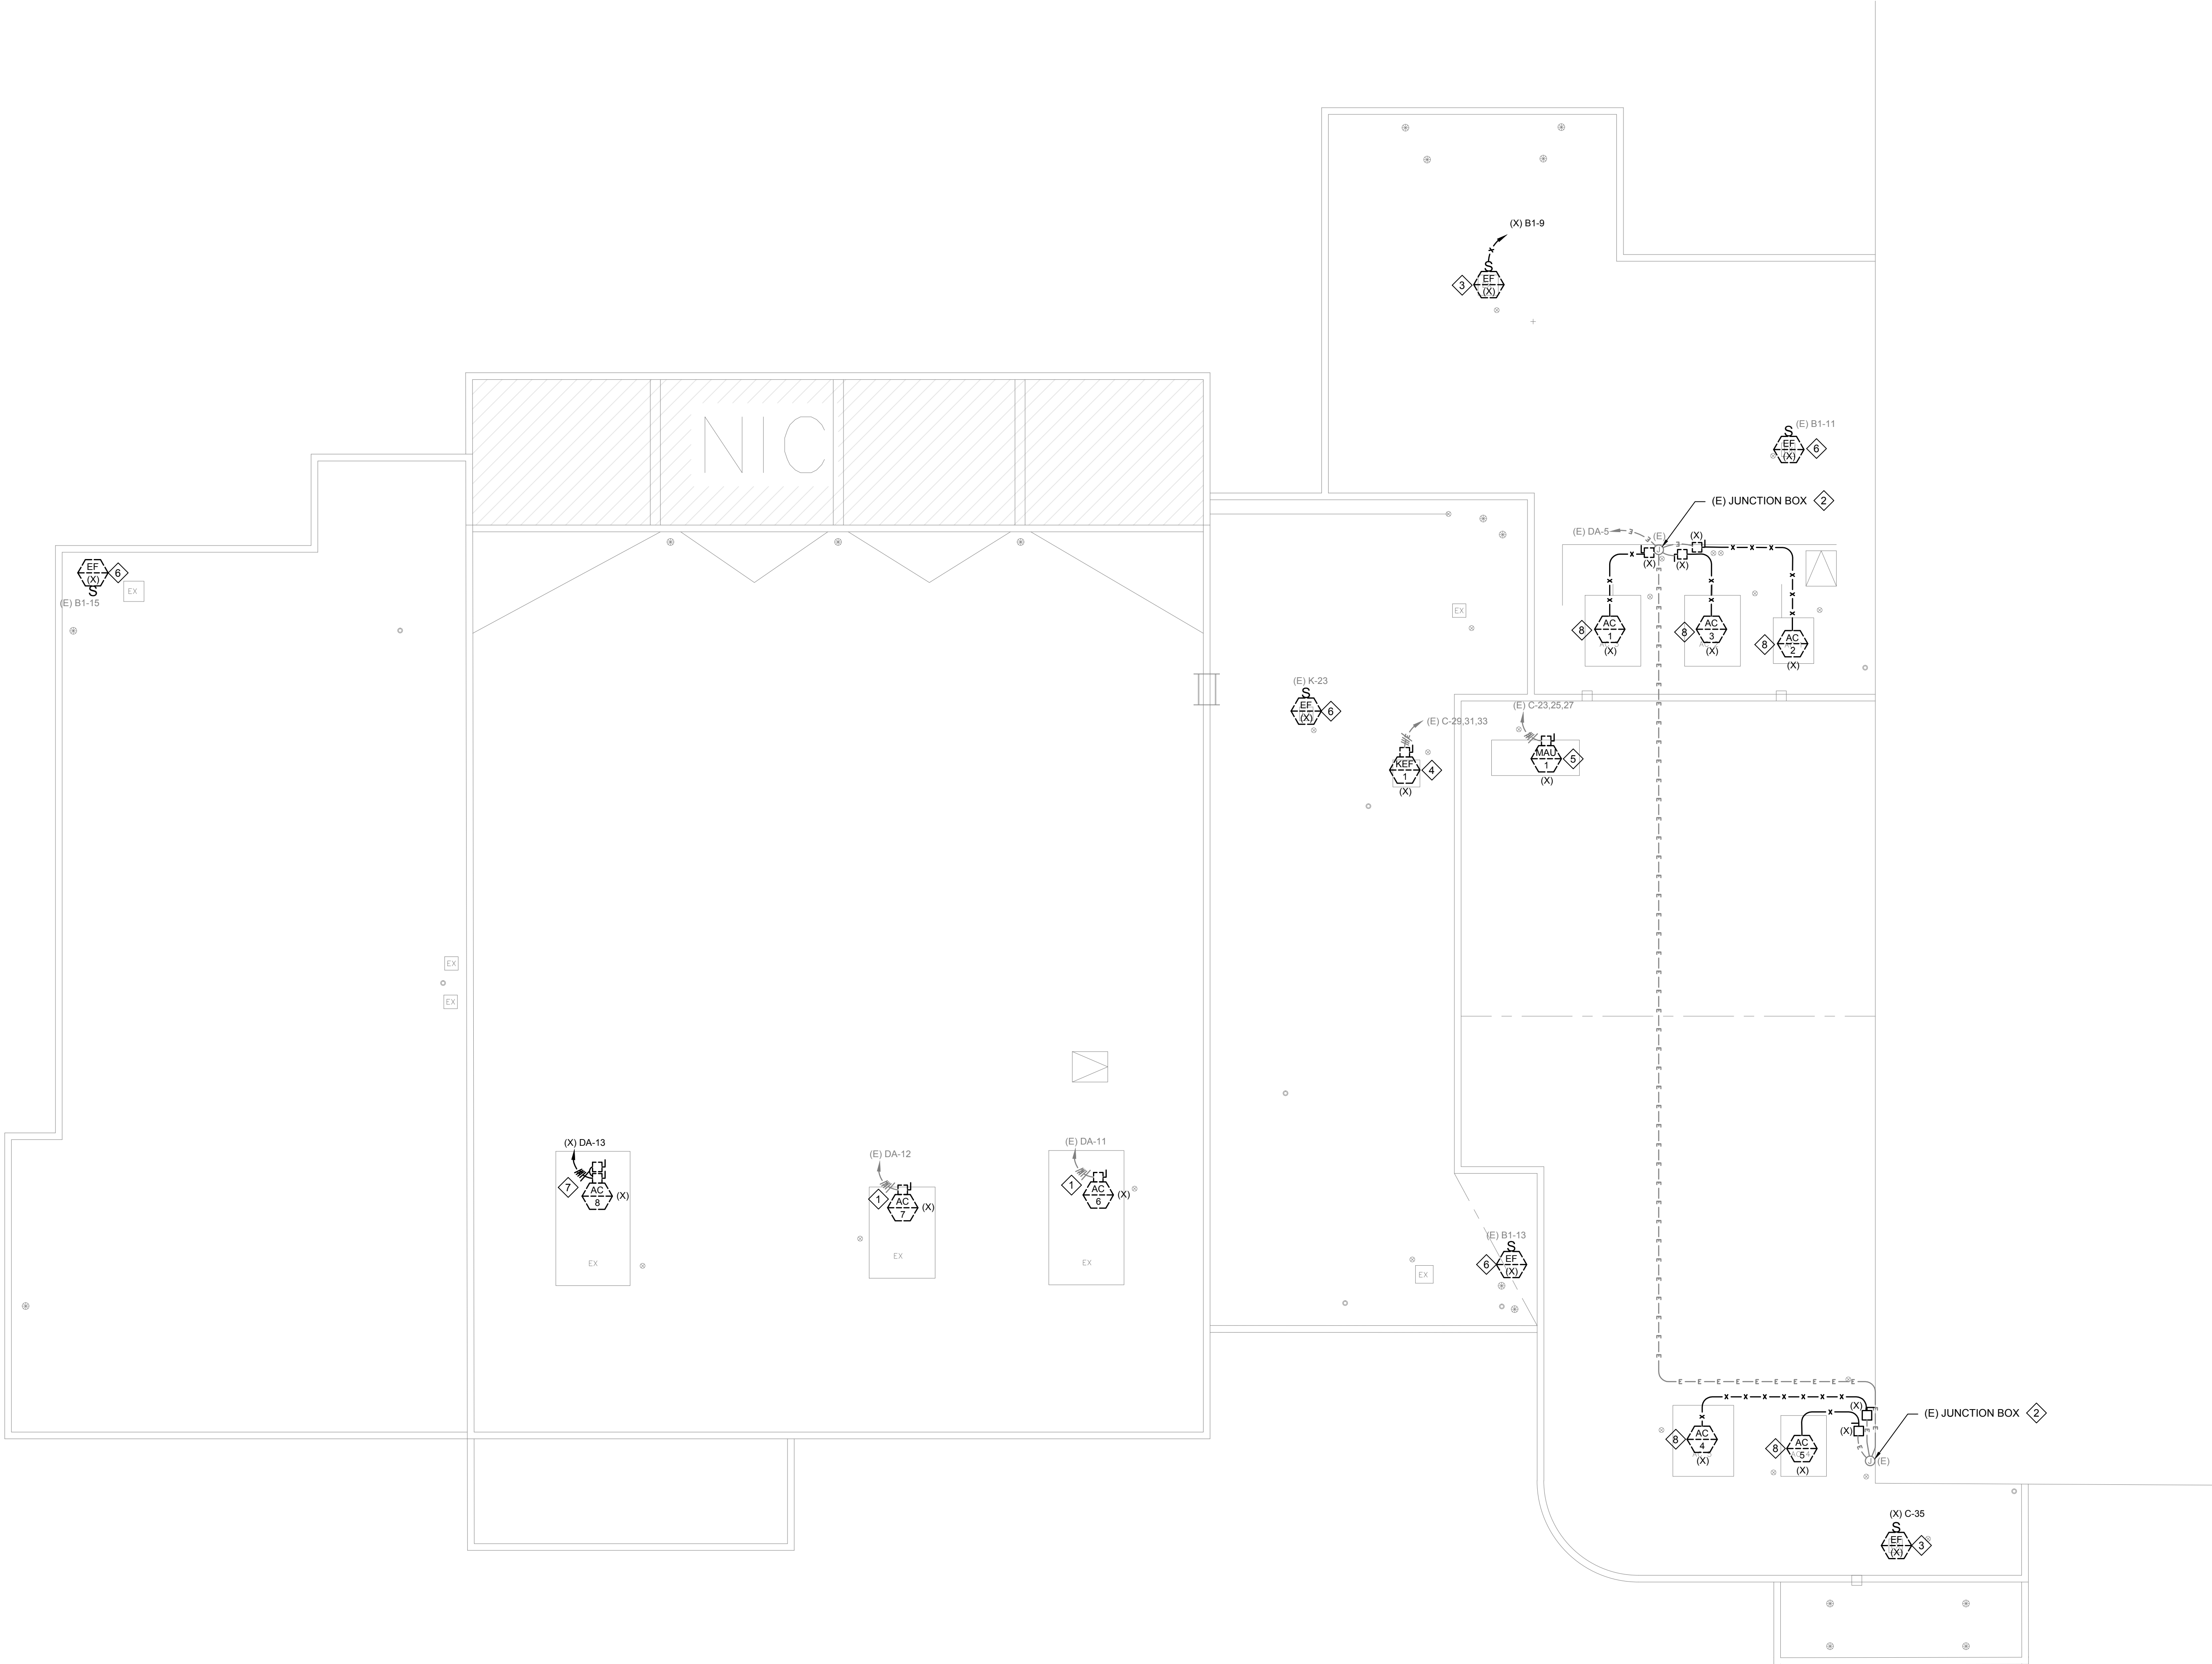


A ELECTRICAL DEMOLITION ROOF PLAN
ED2.2 1/8" = 1'-0"

GENERAL NOTES:

1. EXISTING ITEMS SHOWN LIGHT AND/OR DESIGNATED WITH AN (E).
RELOCATED ITEMS SHOWN DARK AND DESIGNATED WITH A (R). NEW
SHOWN DARK.

SHEET NOTES:

1. EXISTING EXHAUST FAN TO BE REMOVED AND REPLACED WITH NEW IN
SAME LOCATION. INTERCEPT EXISTING CIRCUITING AND ROUTE TO NEW
FAN. PROVIDE ALL JUNCTION BOXES, CONDUITS, CONDUCTORS, ETC AS
REQUIRED FOR A COMPLETE INSTALLATION.
2. EXISTING KITCHEN EXHAUST FAN TO BE REMOVED AND REPLACED WITH
NEW IN SAME LOCATION. INTERCEPT EXISTING CIRCUITING AND ROUTE
TO NEW FAN. PROVIDE ALL JUNCTION BOXES, CONDUITS, CONDUCTORS,
ETC AS REQUIRED FOR A COMPLETE INSTALLATION.
3. MAKE UP AIR UNIT TO BE REMOVED AND REPLACED WITH NEW IN SAME
LOCATION. INTERCEPT EXISTING CIRCUITING AND ROUTE TO NEW FAN.
PROVIDE ALL JUNCTION BOXES, CONDUITS, CONDUCTORS, ETC AS
REQUIRED FOR A COMPLETE INSTALLATION.
4. REFER TO SINGLE LINE DIAGRAM FOR FEEDER SIZING.
5. INTERCEPT EXISTING CIRCUIT SERVING REMOVED UNIT AND ROUTE TO
NEW UNIT. PROVIDE ALL JUNCTION BOXES, CONDUIT CONDUCTORS AS
REQUIRED FOR COMPLETE INSTALLATION.
6. FURNISH AND INSTALL NEW DISCONNECT SWITCH, CONDUIT AND
CONDUCTORS. REFER TO SINGLE LINE DIAGRAM, SHEET E0.2 FOR
ADDITIONAL REQUIREMENTS.
7. NEW EXHAUST FAN AND CIRCUITING. COORDINATE SPECIFIC LOCATION
AND POINT OF CONNECTION WITH MECHANICAL CONTRACTOR.
8. CONNECT TO DUCT SMOKE DETECTOR PER MANUFACTURERS WIRING
DIAGRAM. COORDINATE POINT OF CONNECTION WITH MECHANICAL
CONTRACTOR. UTILIZE EXISTING CIRCUIT SERVING REMOVED DUCT
DETECTORS.

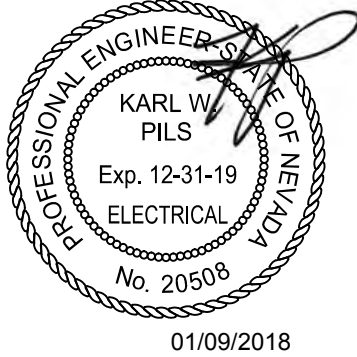

LAS VEGAS SENIOR CENTER HVAC
REPLACEMENT

451 E BONANZA RD
LAS VEGAS, NV 89101



6285 South Valley View Blvd, Suite #416
Las Vegas, Nevada 89118
Phone: (702) 855-4138
Fax: (702) 855-4880
Web: www.hpacen.com
Project #: L17138

CONSULTANTS

ISSUE DATE DESCRIPTION

ISSUE DATE: 12.08.2017

PROJECT NO: L17138

CAD DWG FILE: E2.2 ELECTRICAL ROOF PLANDWG

DRAWN BY: HPA

BID NUMBER: 18.69111.02

COPYRIGHT:
© 2017 HPA CONSULTING ENGINEERS

SHEET TITLE

ELECTRICAL
ROOF PLAN








 
 










513-45Q

E2.2

SHEET - OF -

A ELECTRICAL ROOF PLAN
E2.2 1/8" = 1'-0"

(NOT ALL USED IN PROJECT)

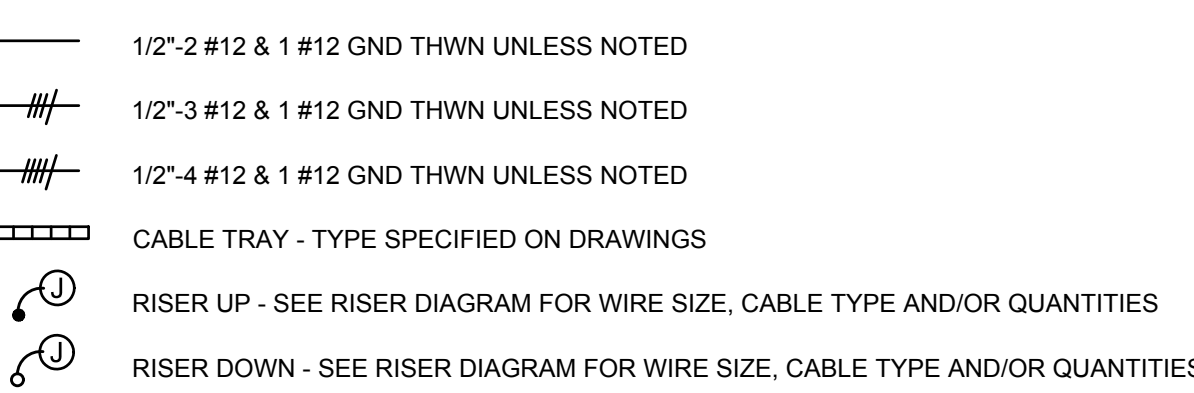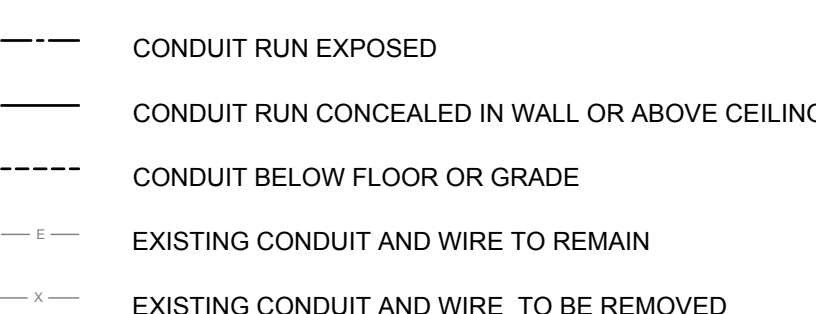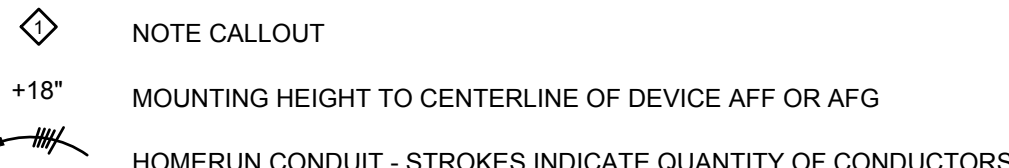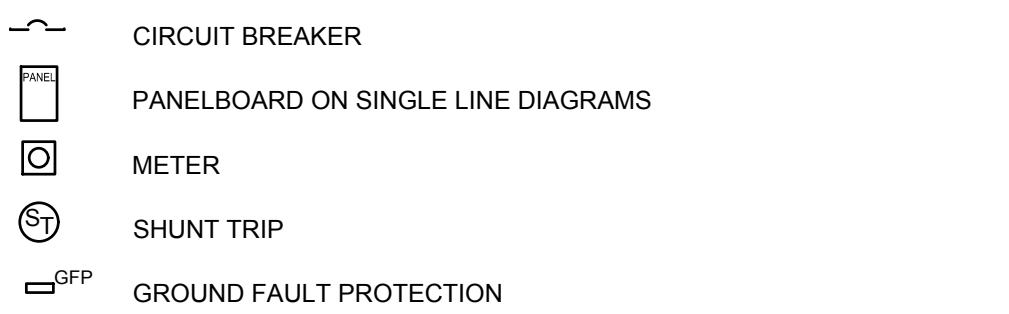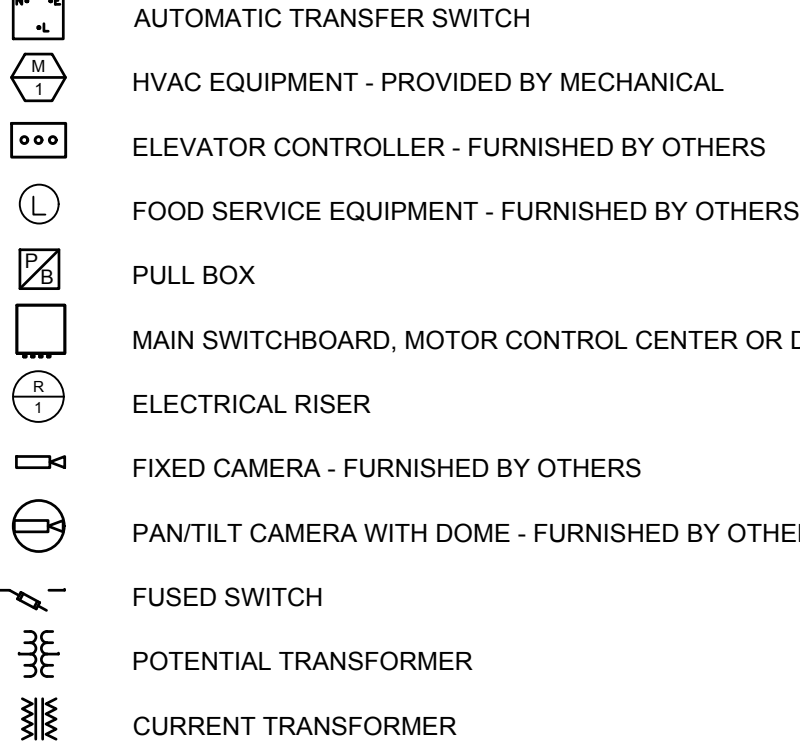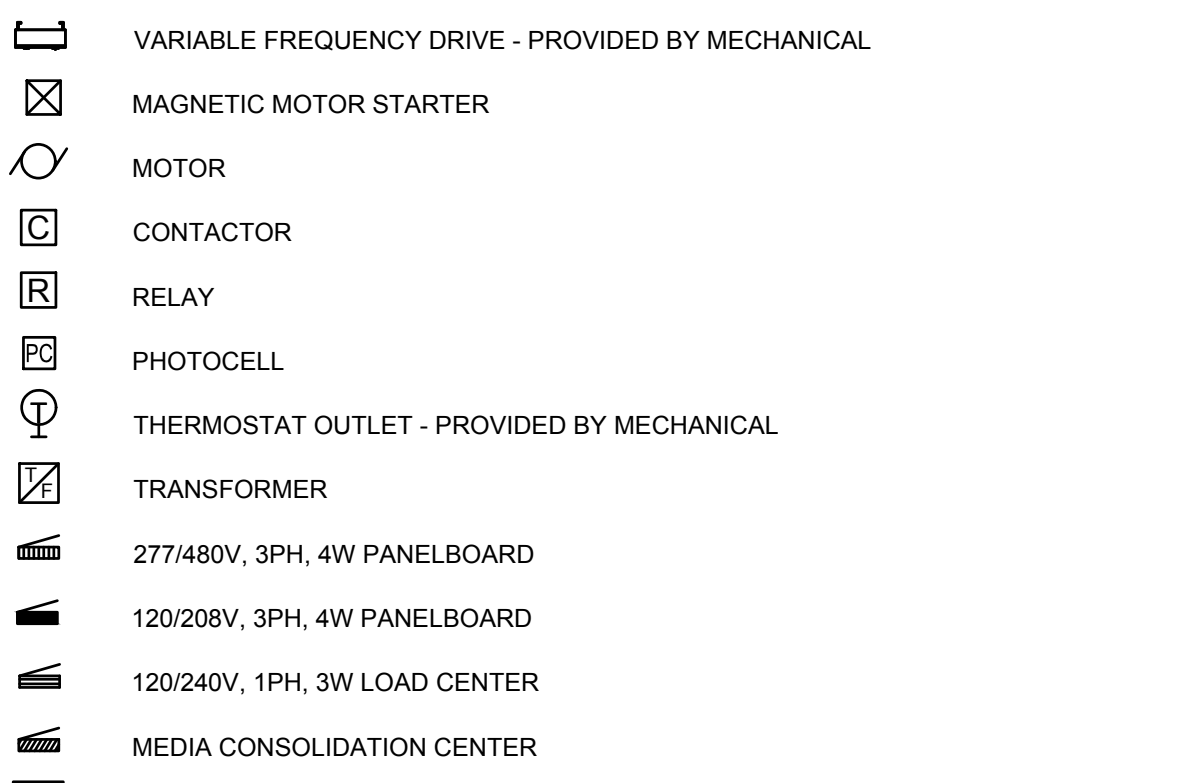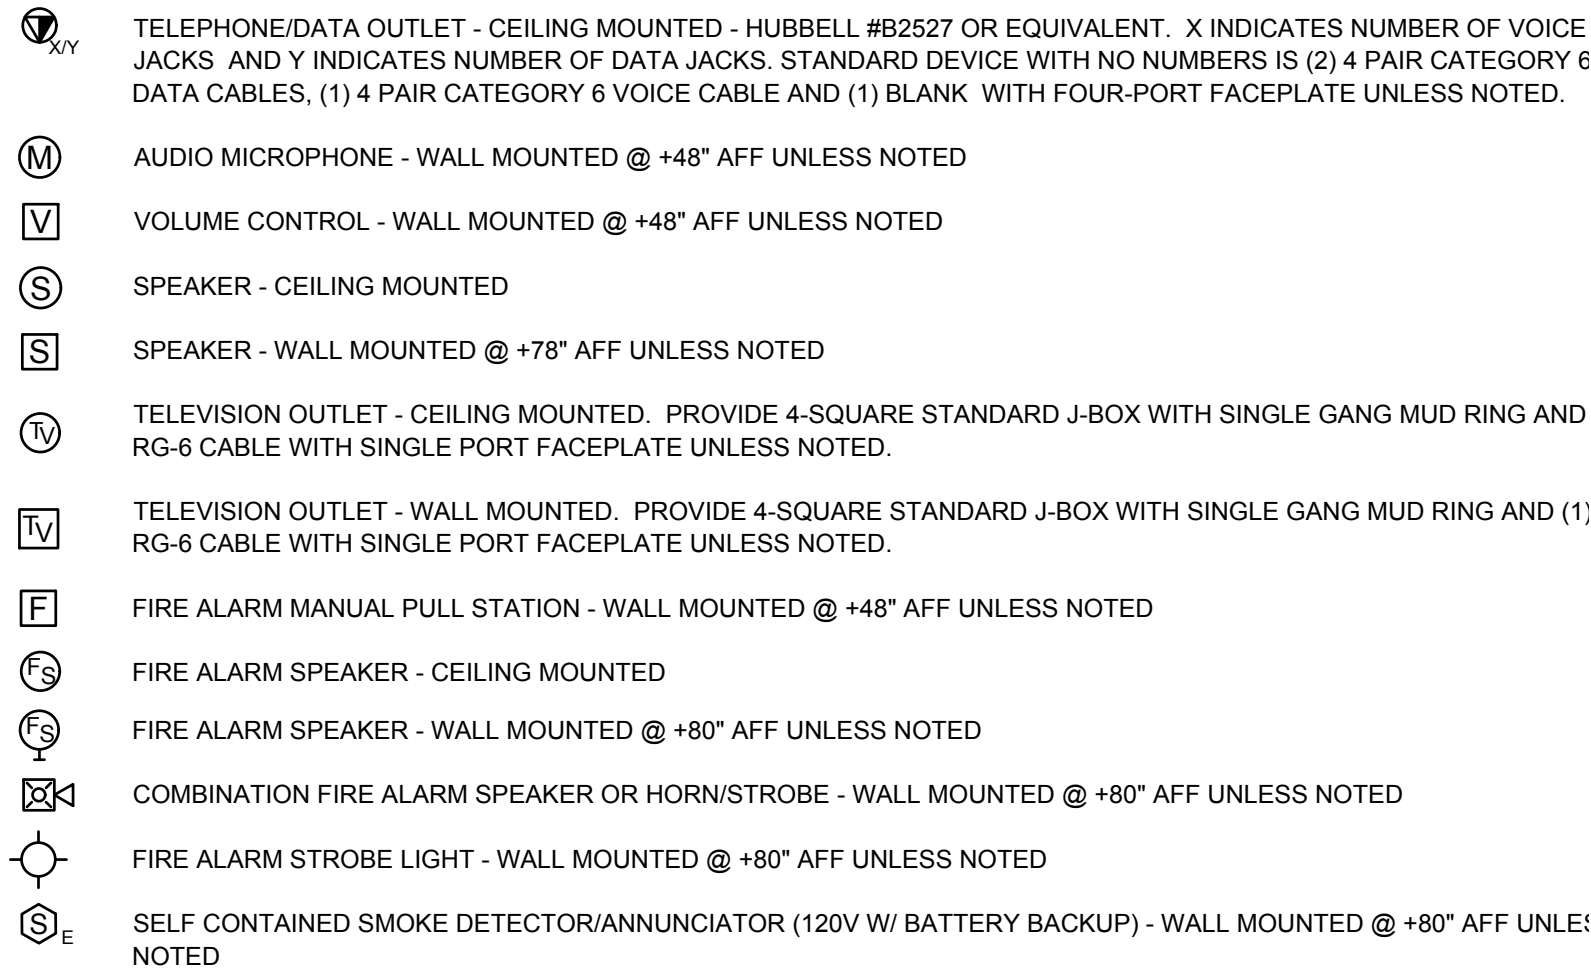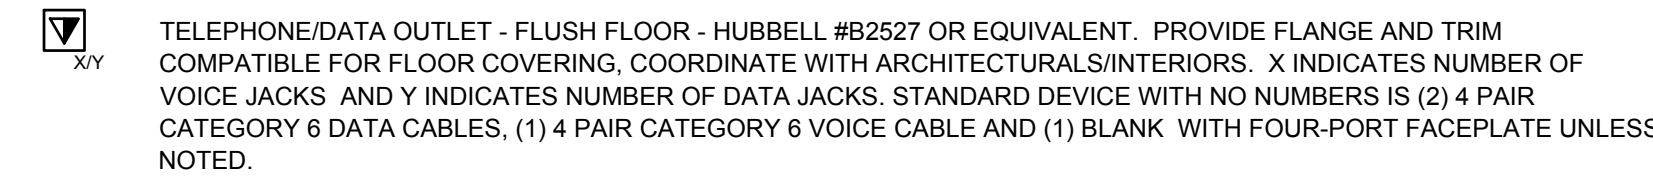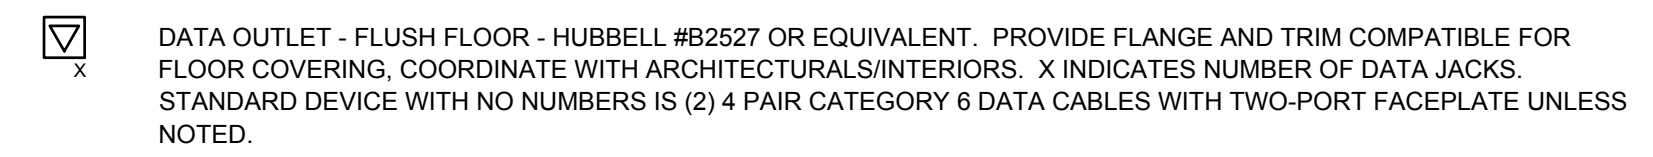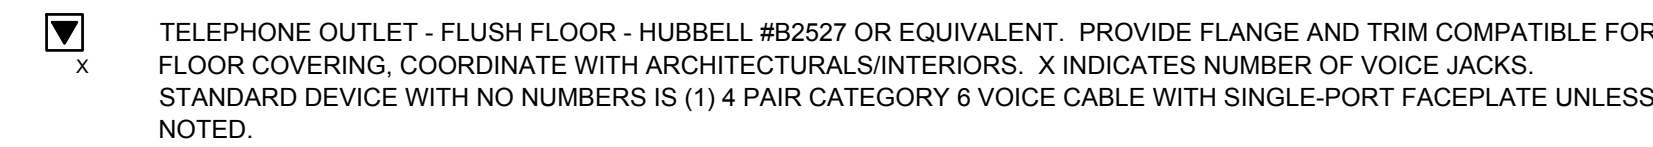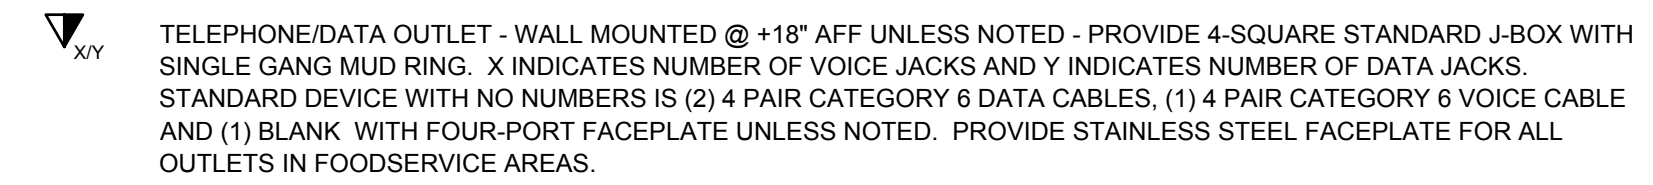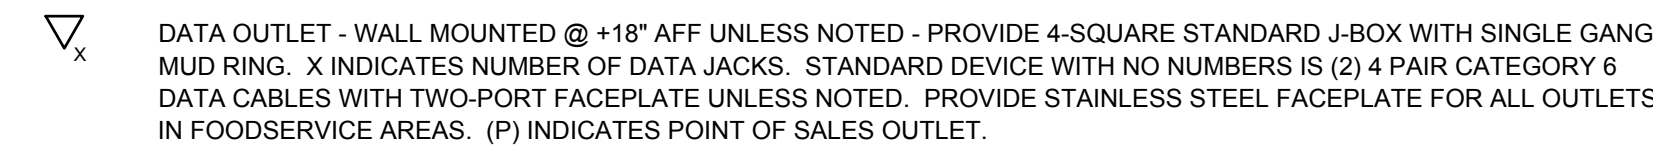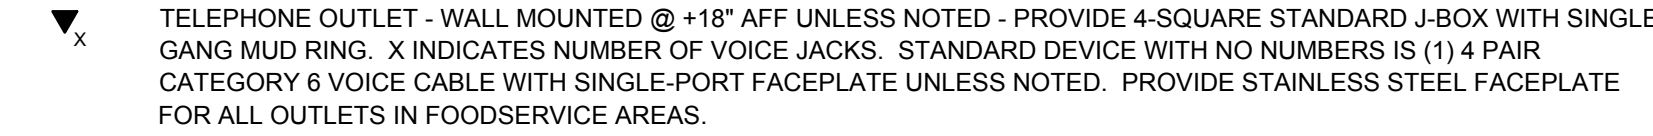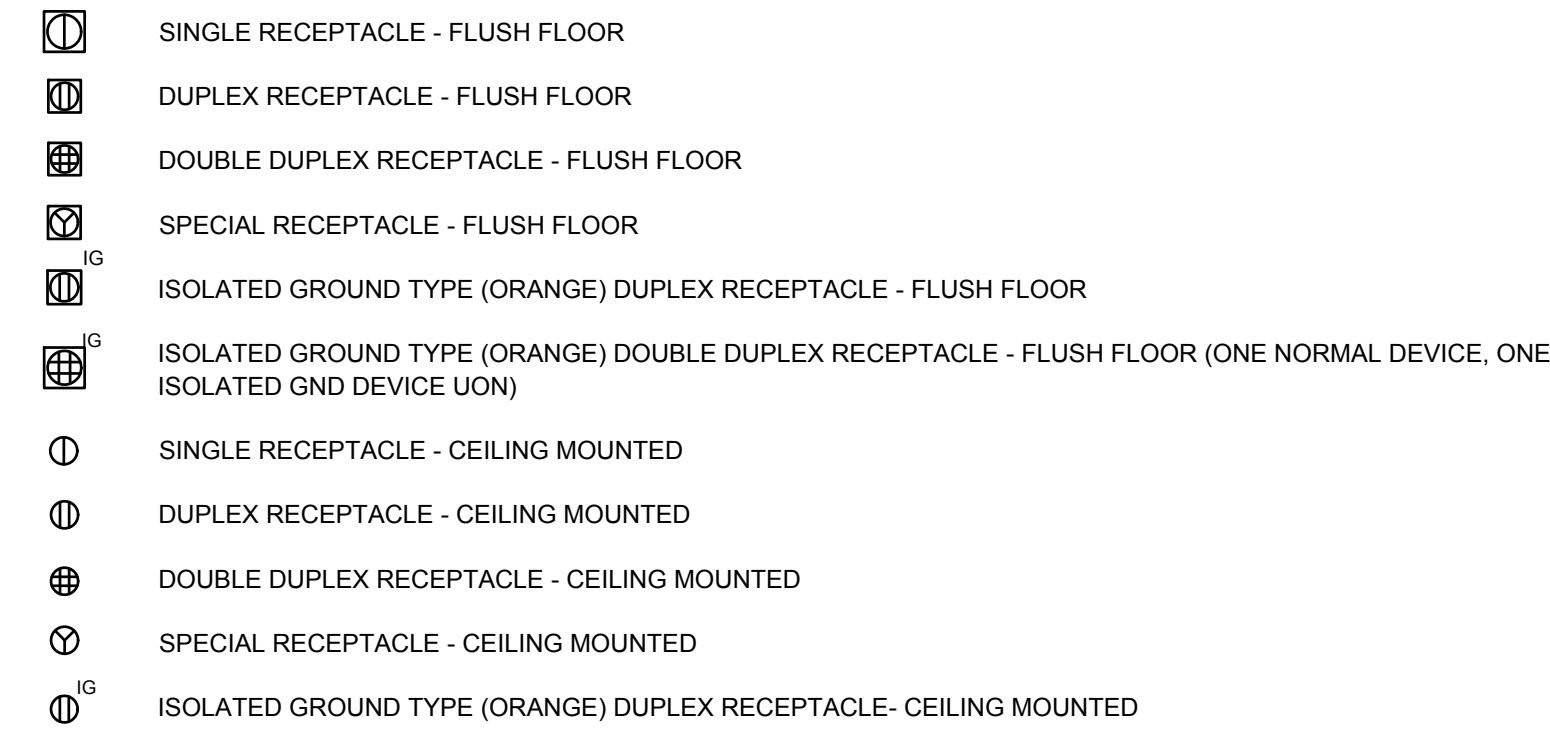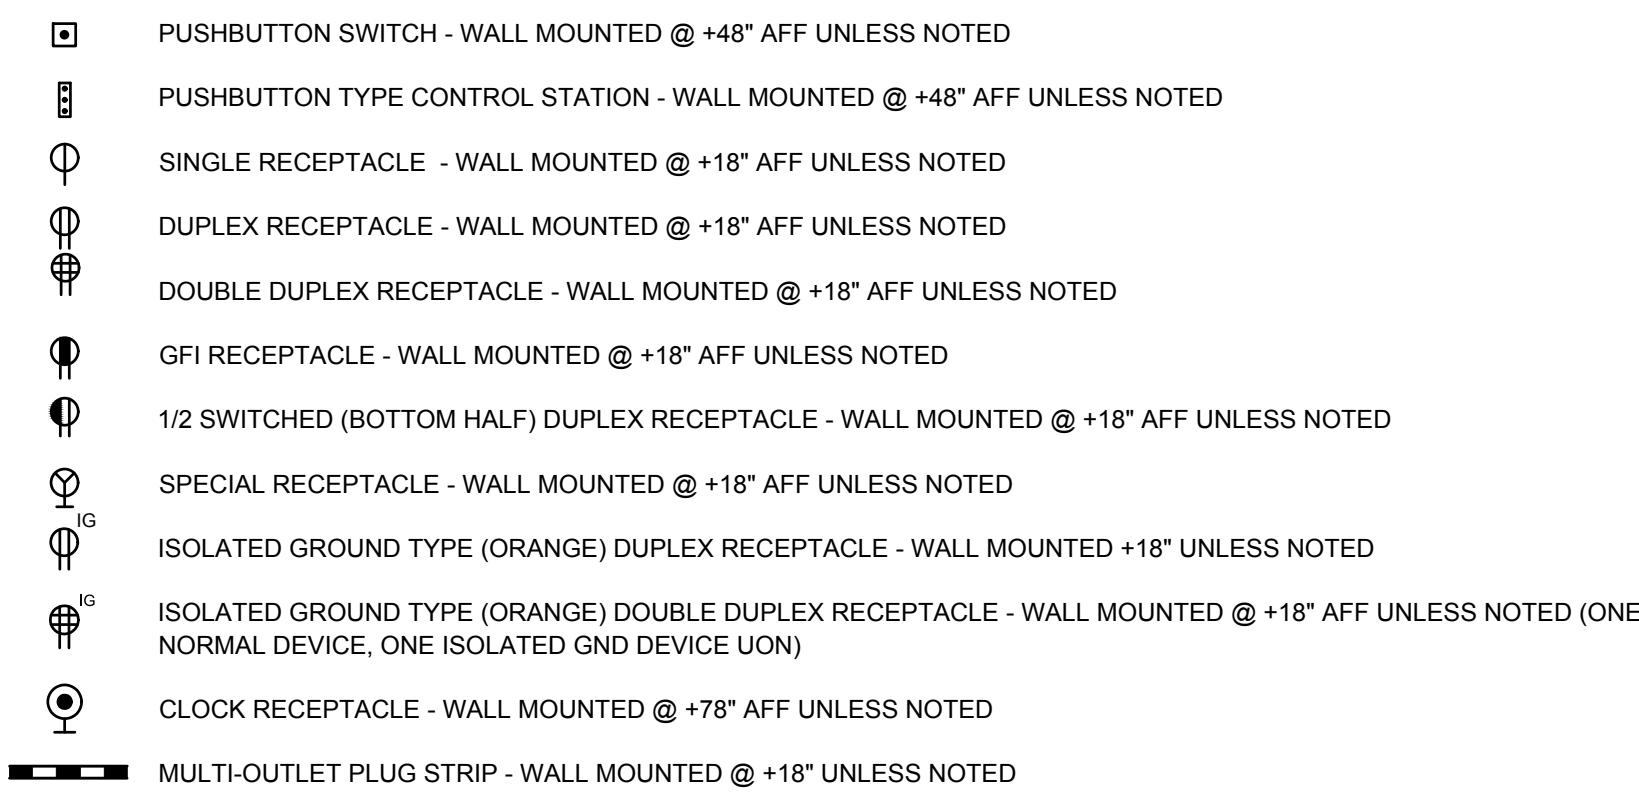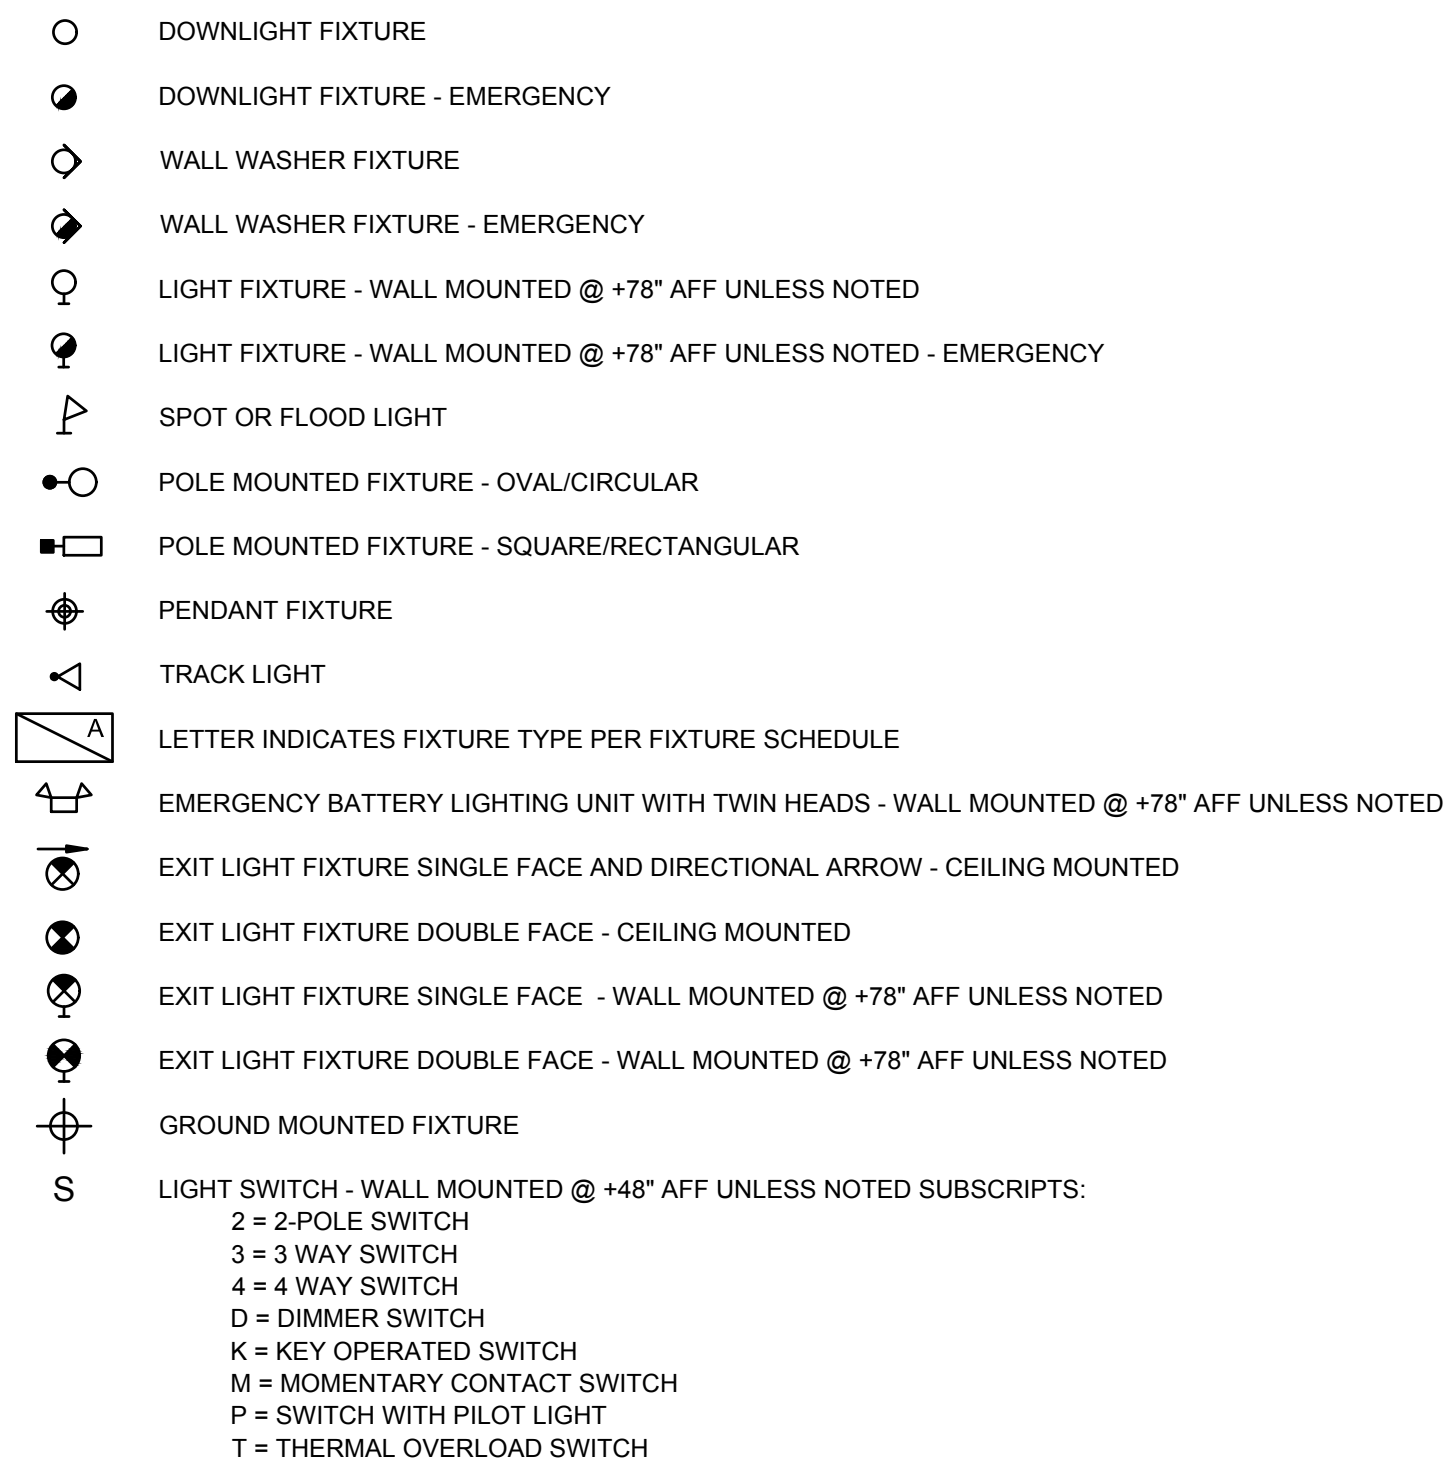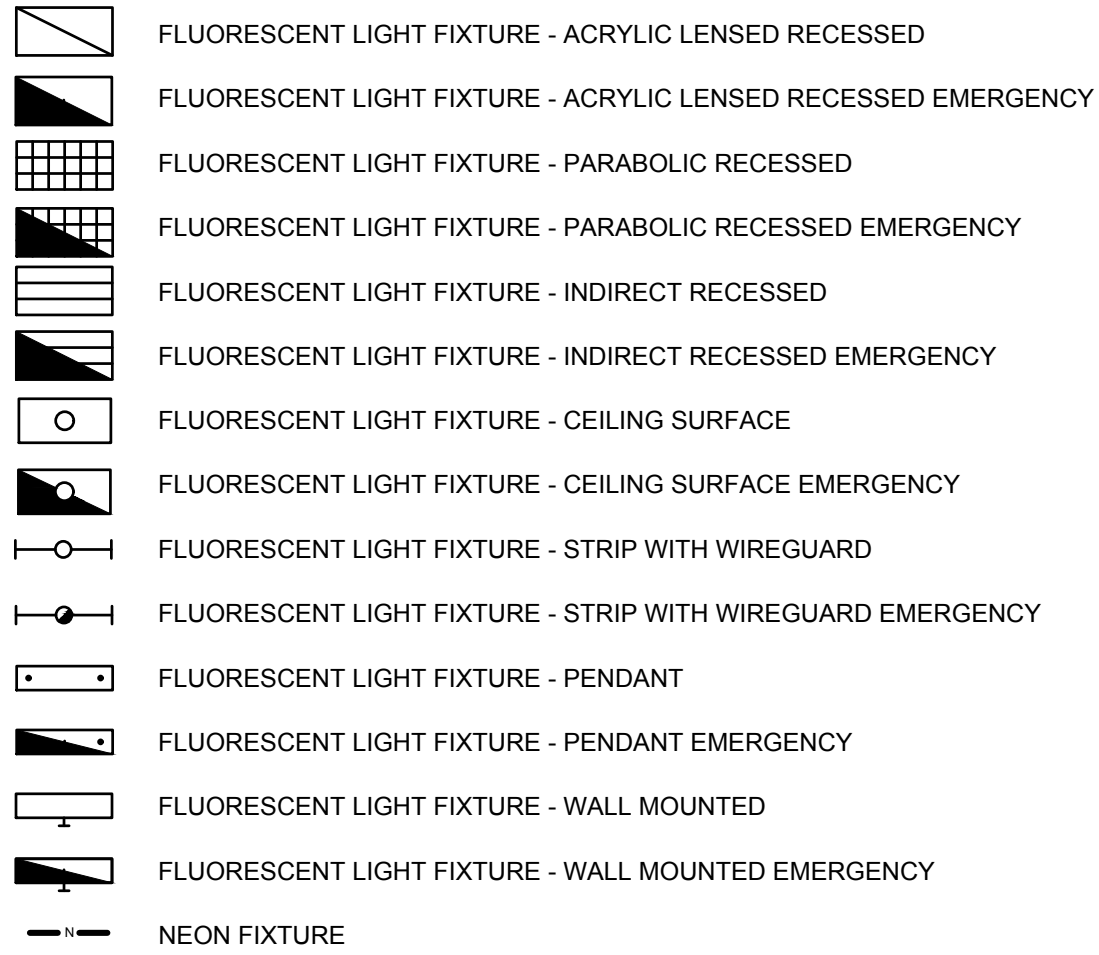

(NOT ALL USED IN PROJECT)

AFF	ABOVE FINISHED FLOOR	HOA	HAND-OFF-AUTOMATIC	SWBD	SWITCH BOARD
AFG	ABOVE FINISHED GRADE	HP	HORSEPOWER	SQFT	SQUARE FEET
AIC	AMP INTERRUPTING CURRENT				
AL	ALUMINUM	IG	ISOLATED GROUND	TL	TWISTLOCK
ATS	AUTOMATIC TRANSFER SWITCH			TVSS	TRANSIENT VOLTAGE SURGE SUPPRESSION
		JBOX	JUNCTION BOX	TYP	TYPICAL
BFG	BELOW FINISHED GRADE				
BKBD	BACKBOARD	KVA	KILOVOLT-AMPS	UG	UNDERGROUND
		KW	KILOWATT	UMC	UNIFORM MECHANICAL CODE
C	CONDUIT			UON	UNLESS OTHERWISE NOTED
CU	COPPER	MCC	MOTOR CONTROL CENTER	UPS	UNINTERRUPTIBLE POWER SUPPLY
		MPC	MINI POWER CENTER		
DB	DISTRIBUTION BOARD			V	VOLTS
		NC	NORMALLY CLOSED	VA	VOLT-AMPS
(E)	EXISTING TO REMAIN	NEC	NATIONAL ELECTRIC CODE	VPH/A	VOLTS/PHASE/AMPS
EA	EACH	NF	NON-FUSED	VPH/HZ	VOLTS/PHASE/HERTZ
EM	EMERGENCY	NFPA	NATIONAL FIRE PROTECTION ASSOCIATION	VFD	VARIABLE FREQUENCY DRIVE - PROVIDED BY MECHANICAL
EMCS	ENERGY MANAGEMENT CONTROL SYSTEM	NIC	NOT IN CONTRACT	WP	WEATHER PROOF (NEMA 3R)
EWG	ELECTRIC WATER COOLER	NL	NIGHT LIGHT		
		NO	NORMALLY OPEN	(X)	EXISTING TO BE REMOVED
F	FUSE (DUAL ELEMENT, TIME DELAY)	NTS	NOT TO SCALE	XFMR	TRANSFORMER
FBO	FURNISHED BY OTHERS			XP	EXPLOSION PROOF
FPN	FUSE PER NAMEPLATE	PB	PULLBOX		
		PNL	PANEL BOARD		
GFI	GROUND FAULT CIRCUIT INTERRUPTER				
GND	GROUND	(R)	EXISTING TO BE RELOCATED		
		RGS	RIGID GALVANIZED STEEL		

DRAWING INDEX			
SHEET NUMBER	SHEET TITLE	PERMIT 12/08/2017	CLARIFICATIONS 08/21/2016
			
E0.0	ELECTRICAL SYMBOLS, ABBREVIATIONS AND DRAWING INDEX	X	X
E0.1	ELECTRICAL SPECIFICATIONS	X	
E0.2	ELECTRICAL SINGLE LINE DIAGRAMS AND PANEL SCHEDULES	X	
ED2.1	ELECTRICAL DEMOLITION FLOOR PLAN	X	
ED2.2	ELECTRICAL DEMOLITION ROOF PLAN	X	
E2.1	ELECTRICAL FLOOR PLAN	X	X
E2.2	ELECTRICAL ROOF PLAN	X	
TOTAL		7	2

LAS VEGAS SENIOR CENTER HVAC REPLACEMENT

451 E BONANZA RD
LAS VEGAS, NV 89101




CONSULTANTS	
1	08.21.18 CLARIFICATIONS
ISSUE	DATE
ISSUE DATE:	12/08/2017
PROJECT NO:	L17138
CAD DWG FILE:	EDJ ELECTRICAL SYMBOLS, ABBREVIATIONS AND DRAWING INDEX.DWG
DRAWN BY:	HPA
BID NUMBER:	18.69111.02
COPYRIGHT:	
© 2017 HPA CONSULTING ENGINEERS	
SHEET TITLE	

ELECTRICAL SYMBOLS, ABBREVIATIONS AND DRAWING INDEX

513-45Q

E0.0

SHEET - OF -

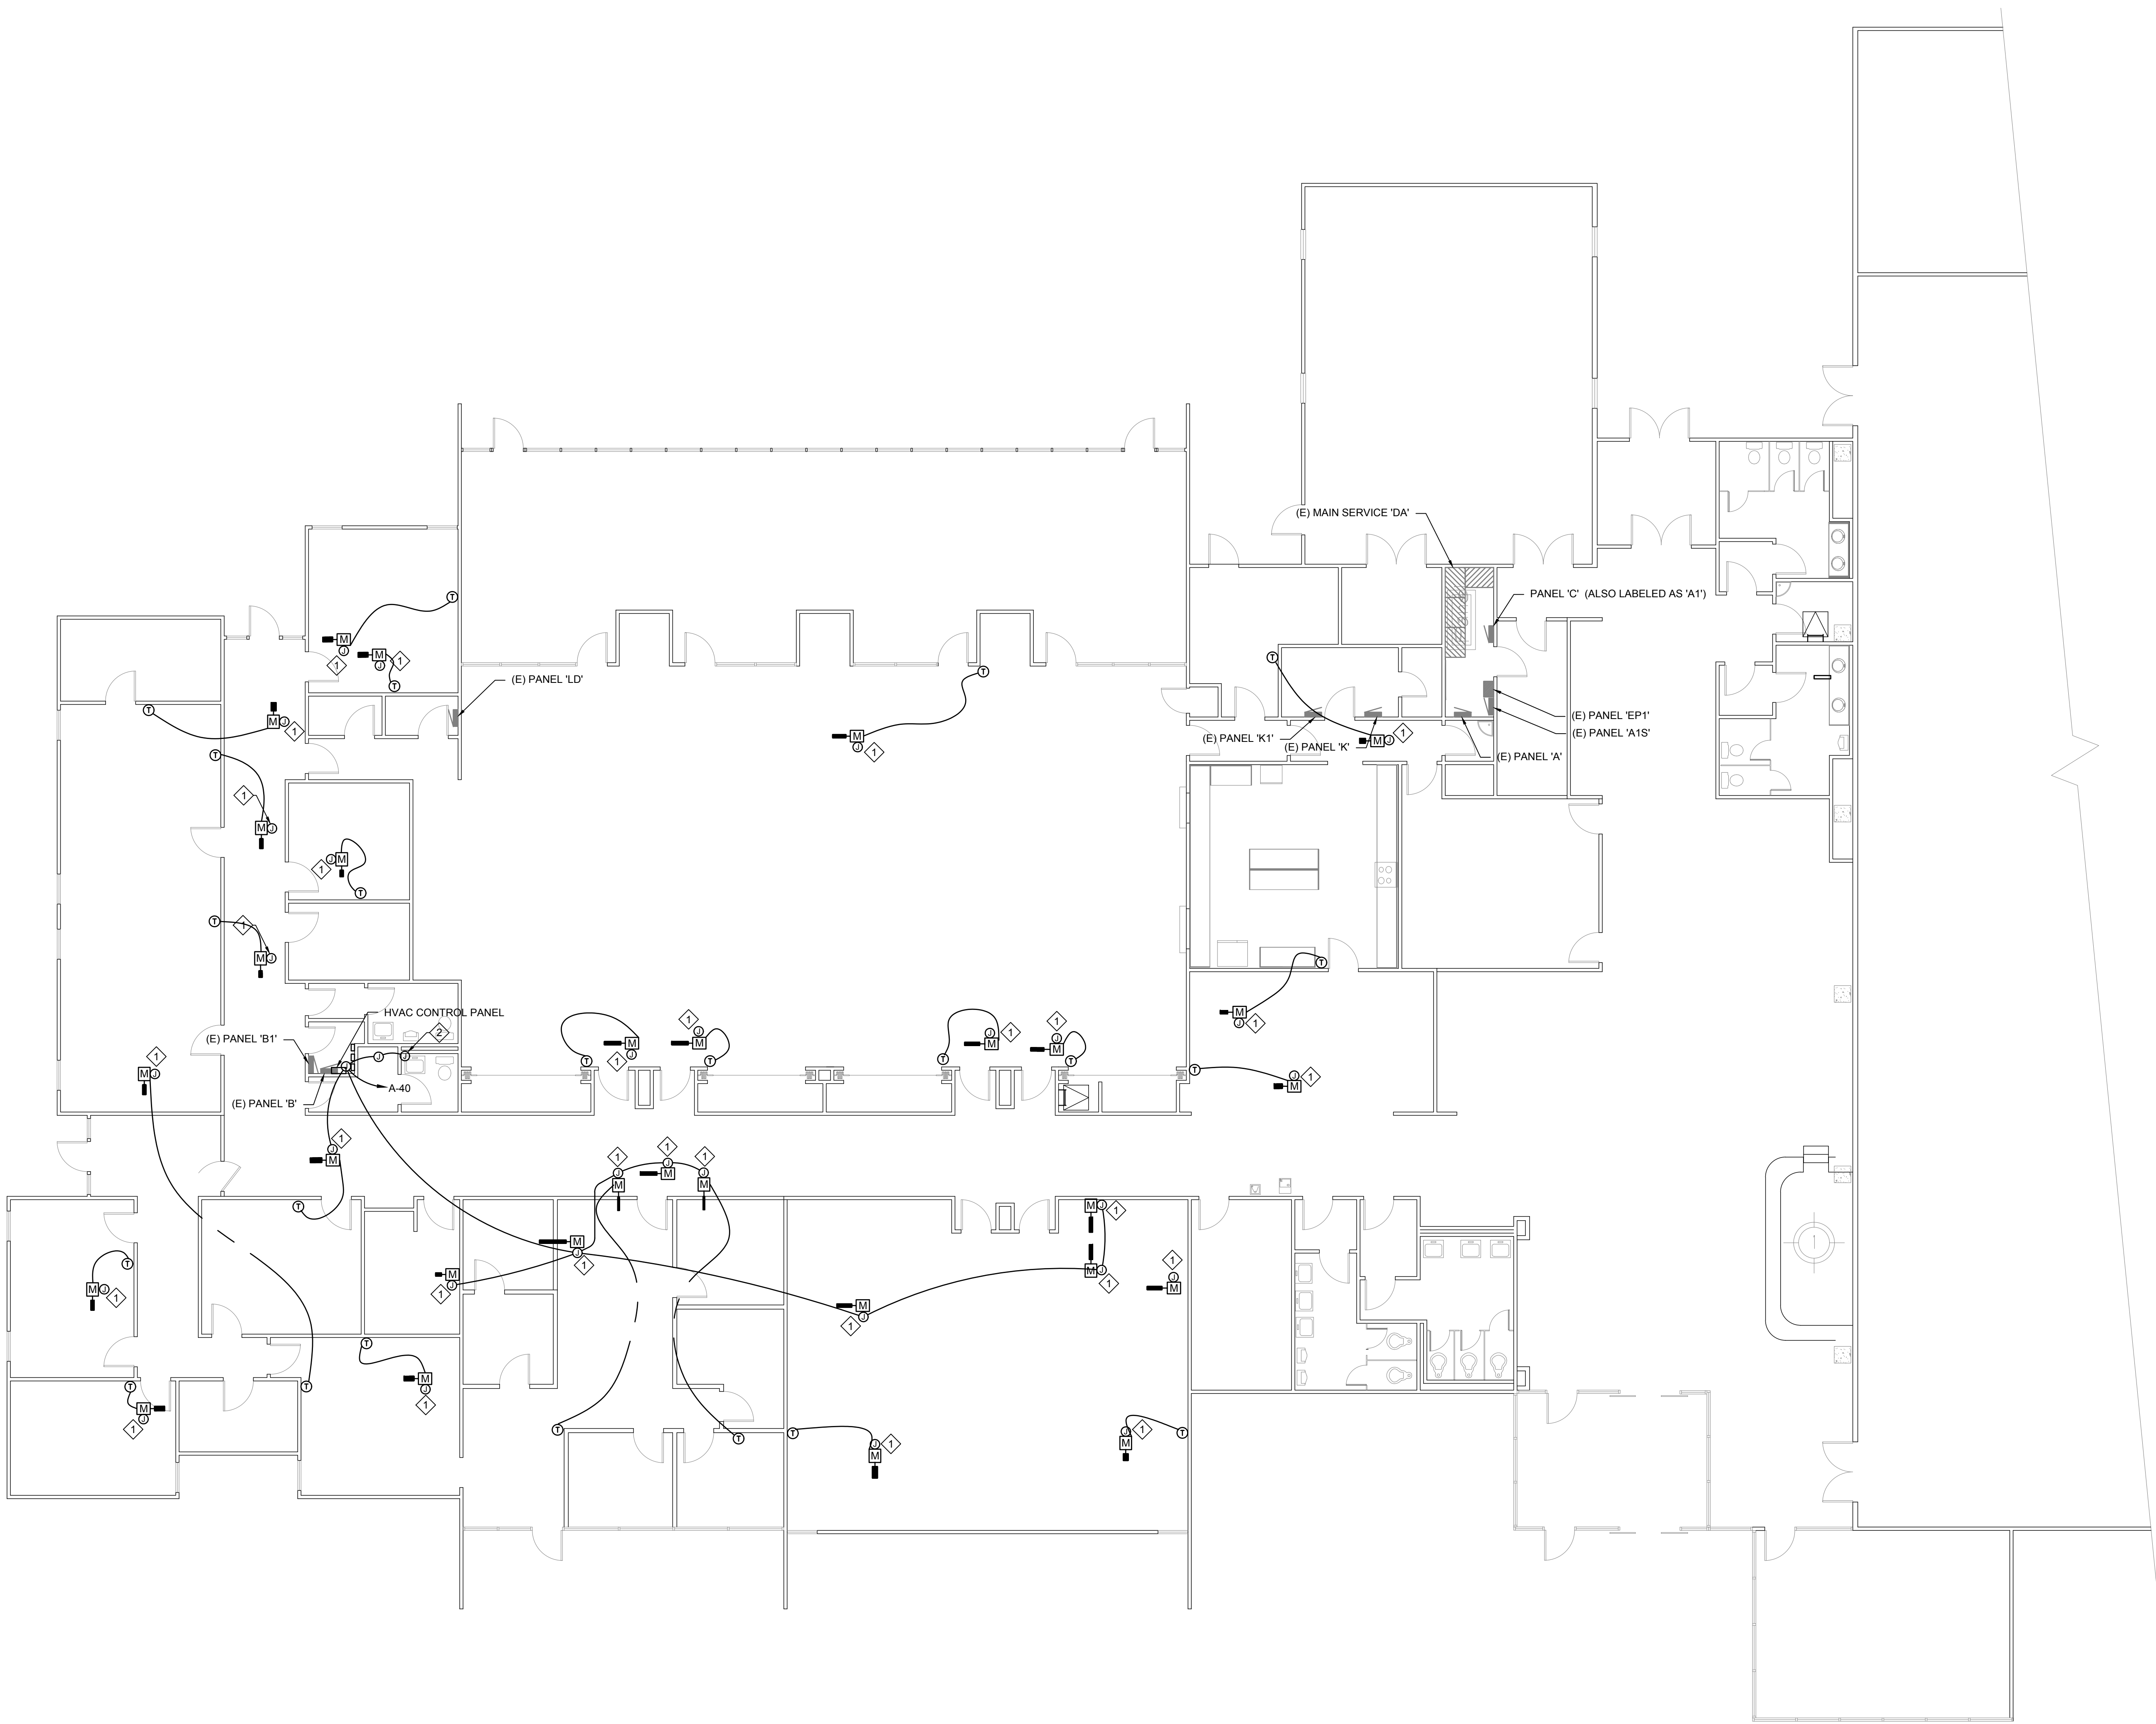

GENERAL NOTES:

- EXISTING ITEMS SHOWN LIGHT AND/OR DESIGNATED WITH AN (E), RELOCATED ITEMS SHOWN DARK AND DESIGNATED WITH A (R), NEW SHOWN DARK.

SHEET NOTES:

- ROUTE CONTROL CABLING TO HVAC CONTROL PANEL CONNECT TO MOTORIZED DAMPER PER MANUFACTURERS WIRING DIAGRAM. COORDINATE SPECIFIC LOCATION AND POINT OF CONNECTION WITH MECHANICAL CONTRACTOR.
- PROVIDE POWER TO (3) CONTROL PANELS AND 24V TRANSFORMER. REFER TO DIAGRAM B AND C ON MECHANICAL SHEET M2.1 FOR ADDITIONAL REQUIREMENTS.

LAS VEGAS SENIOR CENTER HVAC REPLACEMENT

451 E BONANZA RD
LAS VEGAS, NV 89101



6205 South Valley View Blvd, Suite #416
Las Vegas, Nevada 89118
Phone: (702) 885-5138
Fax: (702) 885-4980
Web: www.hpacs.com
Project #: L17138

CONSULTANTS

1 10/21/18 CLARIFICATIONS

ISSUE DATE: 12/08/2017

PROJECT NO: L17138

CAD DWG FILE: E2.1 ELECTRICAL FLOOR PLAN.DWG

DRAWN BY: HPA

BID NUMBER: 18.69111.02

COPYRIGHT:
© 2017 HPA CONSULTING ENGINEERS

SHEET TITLE

ELECTRICAL FLOOR PLAN

REVISED MOTORIZED DAMPER WIRING

A ELECTRICAL FLOOR PLAN
E2.1 1/8" = 1'-0"

513-45Q

E2.1

SHEET - OF -