


IMPROVEMENT PLANS

FOR

SKYE CANYON PHASE 2

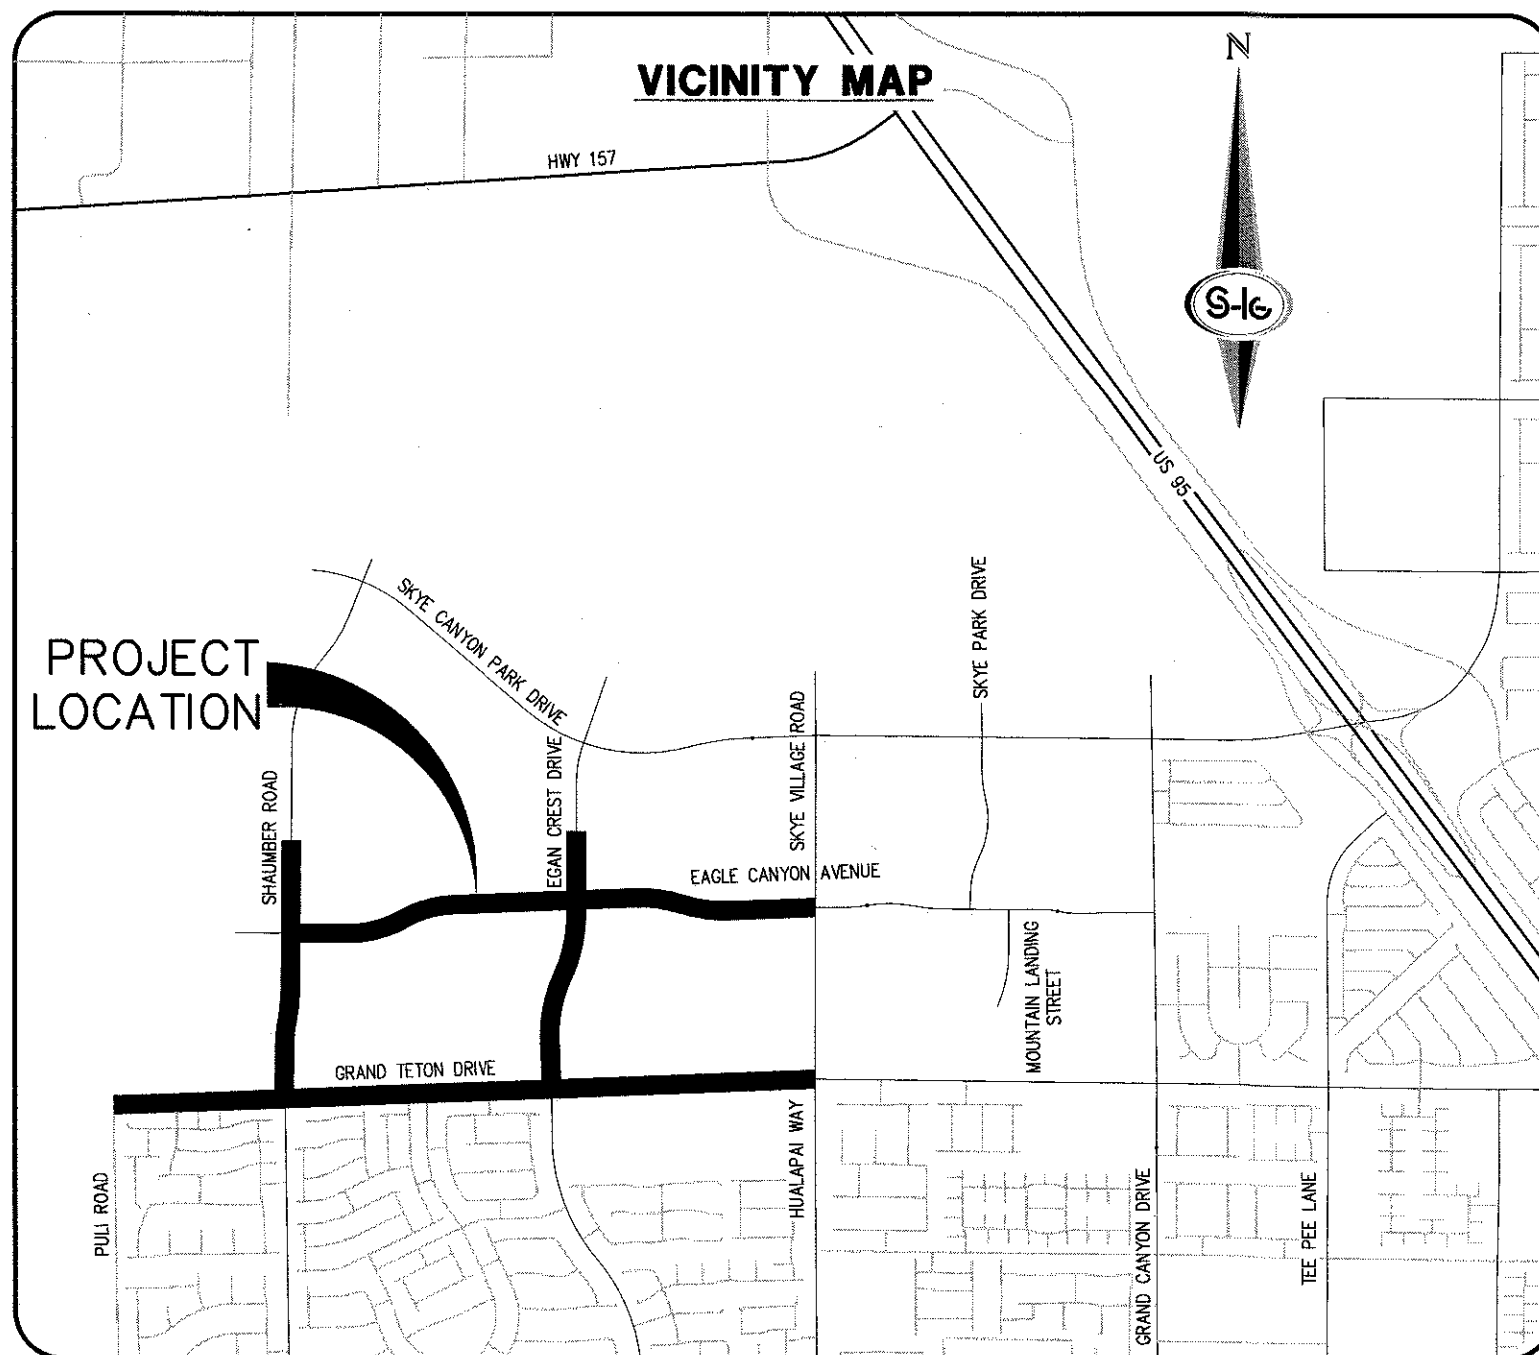

BENCHMARK

MONUMENT ID: USDA (1934) 19

U.S. DEPARTMENT OF AGRICULTURE BRASS DISC AT SOUTHWEST CORNER OF U.S. 95 AND KYLE CANYON ROAD

ELEVATION = 2817.61 FEET, 858.810 METERS
NAVD 88 DATUM

PER THE CITY OF LAS VEGAS BENCHMARK BOOK -
2008 ADJUSTMENT (UPDATED 05/24/2010)

BASIS OF BEARING

SOUTH 00°22'12" WEST, BEING THE BEARING OF THE WEST LINE OF THE NORTHWEST QUARTER (NW1/4) OF SECTION 6, TOWNSHIP 19 SOUTH, RANGE 60 EAST, M.D.M., CITY OF LAS VEGAS, CLARK COUNTY, NEVADA, AS SHOWN BY MAP THEREOF IN FILE 151, PAGE 14 OF SURVEYS IN THE CLARK COUNTY RECORDER'S OFFICE, NEVADA.

OWNER

SECTION 12 LLC
% OLYMPIA COMPANIES LLC
11411 SOUTHERN HIGHLANDS
PARKWAY, SUITE 300
LAS VEGAS, NV 89141

DEVELOPER

NINETY-FIVE MANAGEMENT LLC
% OLYMPIA COMPANIES LLC
11411 SOUTHERN HIGHLANDS
PARKWAY, SUITE 300
LAS VEGAS, NV 89141
PH (702) 220-6565
FX (702) 220-6566

ENGINEER

SLATER HANIFAN GROUP
5740 S. ARVILLE STREET #216
LAS VEGAS, NV 89118
(702) 284-5300



APPROVALS

CITY ENGINEER-DAVID BOWER PE, PTOE #16736 DATE
APPROVAL OF THESE PLANS BY THE CITY ENGINEER IS LIMITED TO THOSE IMPROVEMENTS CONSTRUCTED IN THE DEDICATED RIGHT-OF-WAY, AND/OR DEDICATED EASEMENTS. THIS APPROVAL DOES NOT AUTHORIZE CONSTRUCTION OF ANY IMPROVEMENTS THAT DEVIATE FROM ADOPTED STANDARDS AND/OR SPECIFICATIONS EXCEPT THOSE SPECIALLY LISTED UNDER DEVIATIONS FORM STANDARDS. THE ENGINEER SHALL RESOLVE ANY DEVIATION OTHER THAN THOSE LISTED IN DEVIATIONS FROM STANDARDS IN FAVOR OF THE UNIFORM STANDARD DRAWINGS AND SPECIFICATIONS, CLARK COUNTY AREA, NEVADA.

CHRIS KNIGHT DATE
DIRECTOR, BUILDING AND SAFETY
THIS PLAN MEETS THE APPLICABLE STANDARDS OF THE PLANNING DEPARTMENT.

APPROVED FOR CONSTRUCTION

LAS VEGAS VALLEY WATER DISTRICT ENGINEERING SERVICES MANAGER
PROJECT NO. XXXXXX DATE:
SHEETS: X

APPROVAL BY THE FIRE DEPARTMENT HAVING JURISDICTION IS REQUIRED PRIOR TO OBTAINING FINAL APPROVAL FROM THE LAS VEGAS VALLEY WATER DISTRICT.

LAS VEGAS FIRE AND RESCUE DATE

NV ENERGY DATE

NV ENERGY ACKNOWLEDGES THAT WE HAVE RECEIVED YOUR PLANS AND WILL PROVIDE SERVICE TO ALL ELECTRICAL NEEDS ASSOCIATED WITH THIS PROJECT. NV ENERGY RESERVES THE RIGHT TO ADDRESS ANY EXISTING OR FUTURE CONFLICTS ONCE THE FINAL DESIGN IS COMPLETED. THE NEW SERVICE AND THE RESOLUTION OF ANY CONFLICTS WILL BE ACCOMPLISHED PURSUANT TO THE NEVADA PUBLIC UTILITY COMMISSION'S RULES AND REGULATIONS.

CENTRAL TELEPHONE CO, DBA CENTURYLINK DATE

THE AFFIXED CENTRAL TELEPHONE CO, DBA CENTURYLINK APPROVAL DOES NOT ASSUME OR GUARANTEE LIABILITY FOR KNOWN OR UNKNOWN CONFLICTS WITH EXISTING OR PROPOSED IMPROVEMENTS. RESOLUTION OF ANY CONFLICT WILL BE ACCOMPLISHED PURSUANT TO LOCAL ORDINANCES, NEVADA REVISED STATUTES AND/OR PUBLIC UTILITY COMMISSION RULES AND REGULATIONS.

SOUTHWEST GAS DATE

COX COMMUNICATIONS LAS VEGAS, INC. DATE


INDEX OF DRAWINGS

SHT. NO.	DWG. NO.	DESCRIPTION
1	G-01	COVER SHEET
2	G-02	GENERAL NOTES
3	G-03	ABBREVIATIONS, KEY MAP, LEGEND AND QUANTITIES
4	SD-01	GRAND TETON DRIVE STORM DRAIN PLAN AND PROFILE "GTD" 14+00.00 TO "GTD" 23+50.00
5	SD-02	GRAND TETON DRIVE STORM DRAIN PLAN AND PROFILE "GTD" 23+50.00 TO "GTD" 33+00.00
6	SD-03	GRAND TETON DRIVE STORM DRAIN PLAN AND PROFILE "GTD" 33+00.00 TO "GTD" 42+50.00
7	SD-04	GRAND TETON DRIVE STORM DRAIN PLAN AND PROFILE "GTD" 42+50.00 TO "GTD" 52+00.00
8	SD-05	GRAND TETON DRIVE STORM DRAIN PLAN AND PROFILE "GTD" 52+00.00 TO "GTD" 61+50.00
9	SD-06	GRAND TETON DRIVE STORM DRAIN PLAN AND PROFILE "GTD" 61+50.00 TO "GTD" 71+00.00
10	SD-07	SHAUMBER ROAD STORM DRAIN PLAN AND PROFILE "SR" 8+00.00 TO "SR" 16+50.00
11	SD-08	SHAUMBER ROAD STORM DRAIN PLAN AND PROFILE "SR" 16+50.00 TO "SR" 25+50.00
12	SD-09	SHAUMBER ROAD STORM DRAIN PLAN AND PROFILE "SR" 25+50.00 TO "SR" 30+00.00
13	SD-10	EGAN CREST DRIVE STORM DRAIN PLAN AND PROFILE "ECD" 8+00.00 TO "ECD" 15+50.00
14	SD-11	EGAN CREST DRIVE STORM DRAIN PLAN AND PROFILE "ECD" 15+50.00 TO "ECD" 21+00.00
15	SD-12	EGAN CREST DRIVE STORM DRAIN PLAN AND PROFILE "ECD" 21+00.00 TO "ECD" 28+50.00
16	SD-13	EGAN CREST DRIVE STORM DRAIN PLAN AND PROFILE "ECD" 28+50.00 TO "ECD" 34+00.00
17	SD-14	EAGLE CANYON AVENUE STORM DRAIN PLAN AND PROFILE "ECA" 25+00.00 TO "ECA" 33+00.00
18	SD-15	EAGLE CANYON AVENUE STORM DRAIN PLAN AND PROFILE "ECA" 33+00.00 TO "ECA" 39+00.00
19	SD-16	EAGLE CANYON AVENUE STORM DRAIN PLAN AND PROFILE "ECA" 39+00.00 TO "ECA" 47+00.00
20	SD-17	EAGLE CANYON AVENUE STORM DRAIN PLAN AND PROFILE "ECA" 47+00.00 TO "ECA" 56+00.00
21	SD-18	EAGLE CANYON AVENUE STORM DRAIN PLAN AND PROFILE "ECA" 56+00.00 TO "ECA" 63+00.00
22	SD-19	EAGLE CANYON AVENUE STORM DRAIN PLAN AND PROFILE "ECA" 63+00.00 TO "ECA" 71+50.00
23	SD-20	STORM DRAIN LATERAL PROFILES
24	SD-21	STORM DRAIN LATERAL PROFILES
25	SD-22	STORM DRAIN LATERAL PROFILES
26	SD-23	STORM DRAIN LATERAL PROFILES
27	SD-24	STORM DRAIN LATERAL PROFILES
28	SD-25	ROADWAY SECTIONS
29	SD-26	STORM DRAIN DETAILS
30	SD-27	STORM DRAIN DETAILS
31	GR-01	GRADING PLAN 1
32	GR-02	GRADING PLAN 2
33	GR-03	GRADING PLAN 3
	S0.1	GENERAL STRUCTURAL NOTES
	S0.2	TYPICAL DETAILS
	S1.1	PLAN AND SECTION

SLATER HANIFAN GROUP
CONSULTING ENGINEERS & PLANNERS
5740 S. ARVILLE STREET #216, LAS VEGAS, NV 89118
PHONE (702) 284-5300 FAX (702) 284-5309

NINETY-FIVE MANAGEMENT LLC
SKYE CANYON PHASE 2
COVER SHEET

DATE: 11/19/15
DRAFTER: JAS
DESIGNER: DAM
CHECKED: JSR
PROJECT NO.
OLY1501-001

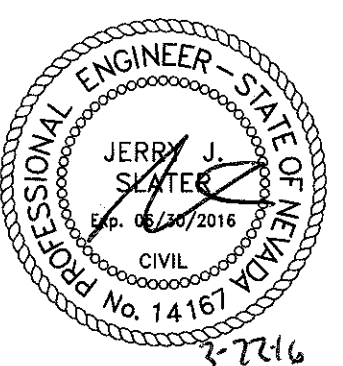

G-01
SHEET 1 OF 33

CITY OF LAS VEGAS SEWER NOTES

4. ALL CONSTRUCTION AND MATERIALS SHALL BE IN ACCORDANCE WITH THE LATEST EDITION OF THE DESIGN AND CONSTRUCTION STANDARDS FOR WASTEWATER COLLECTION SYSTEMS AND THE UNIFORM STANDARD SPECIFICATIONS FOR PUBLIC WORKS' CONSTRUCTION OFF-SITE IMPROVEMENTS, CLARK COUNTY AREA, NEVADA, AND AMENDMENTS. IT WILL BE THE RESPONSIBILITY OF THE CONTRACTOR TO BE AWARE OF THE CONTENTS OF THE ABOVE SPECIFICATIONS.
5. IT SHALL BE THE CONTRACTOR'S RESPONSIBILITY TO PERFORM CONSTRUCTION AS PER PLANS. ANY ADDITIONS, DELETIONS, OR CHANGES SHALL FIRST MEET WITH THE APPROVAL OF THE CITY ENGINEER.
6. CHISEL "S" OR "G" IN CURBS WHERE SEWER OR GAS LATERALS PASS UNDER THE CURB.
7. POLYVINYL (PVC) SEWER PIPE SHALL MEET ASTM D-3034 SD-35 SPECIFICATIONS, INSTALLED WITH SAND BEDDING AND BACKFILL OF TYPE II AGGREGATE BASE.
8. ALL MANHOLES PAVED IN STREETS EIGHTY (80') FOOT R/W AND LARGER SHALL HAVE CONCRETE COLLARS. STREETS LESS THAN EIGHTY (80') FOOT R/W WILL REQUIRE RETROFIT IF PAVING DOES NOT CONFORM TO CITY STANDARDS AT THE MANHOLE.
9. TEE SADDLES SHALL BE USED TO CONNECT SEWER LATERALS TO EXISTING MAIN LINES UP TO TWELVE INCH (12" DIAMETER). CONNECTIONS TO FIFTEEN INCH (15") OR LARGER MAINS SHALL REQUIRE SPECIAL PROCEDURES. IN LINE "Y" S SHALL BE USED ON LINES TWELVE INCHES (12") OR ABOVE.
10. WATER MAINS SHALL BE PROTECTED IN ACCORDANCE WITH LVWDG STANDARDS WHENEVER A SEWER MAIN CROSSES UNDER A WATER MAIN OR THE SEWER IS LESS THAN EIGHTEEN INCH (18") UNDER A WATER MAIN.
11. ALL MANHOLES INSTALLING SPECIAL COLLARS SHALL BE UNDER THE JURISDICTION OF THE CITY OF LAS VEGAS. MANHOLES BE STATE "NEED" CLASS "A" CONTRACTORS.
12. THE CITY OF LAS VEGAS WILL NOT ACCEPT ANY SEWER MAINS WHICH HAVE A VERTICAL DEFLECTION OF MORE THAN ONE TENTH (1/10") OF A FOOT FROM THE APPROVED CONSTRUCTION PLANS AT ANY LOCATION. SEWER MAINS FOUND TO EXCEED THIS TOLERANCE WILL HAVE TO BE REPAIRED OR REMOVED OR REPLACED TO THE SATISFACTION OF THE CITY OF LAS VEGAS.
13. INSTALLATION OF CURVED SEWER REQUIRES THE USE OF C-900 PIPE WHICH ALLOWS FOR PIPE DEFLECTION AT THE JOINTS.

REVISÉD 04/15/10

STORMWATER MANAGEMENT NOTES

1. THE OWNER, SITE DEVELOPER, CONTRACTOR, AND/OR THEIR AUTHORIZED AGENTS SHALL EACH DAY REMOVE ALL SEDIMENT, MUD, CONSTRUCTION DEBRIS, OR OTHER POTENTIAL POLLUTANTS THAT MAY HAVE BEEN DISCHARGED TO, OR ACCUMULATED IN, THE PUBLIC LANDS OF CLARK COUNTY AS A RESULT OF CONSTRUCTION ACTIVITIES. THE CONTRACTOR SHALL SITE DEVELOPMENT OR CONSTRUCTION PROJECT. SUCH MATERIALS SHALL BE PREVENTED FROM ENTERING THE STORM SEWER SYSTEM.
2. ADDITIONAL CONSTRUCTION SITE DISCHARGE BEST MANAGEMENT PRACTICES MAY BE REQUIRED OF THE OWNER AND HIS OR HER AGENTS DUE TO UNFORESEEN EROSION PROBLEMS IF THE SUBMITTED PLAN DOES NOT MEET THE PERFORMANCE STANDARD IN THE USDOCA AND THE LAS VEGAS VALLEY CONSTRUCTION SITE BMP JUDICE MANUAL.
3. TEMPORARY OR PERMANENT STABILIZATION PRACTICES WILL BE INSTALLED ON DISTURBED AREAS AS SOON AS FEASIBLE, AND NO LATER THAN 14 DAYS AFTER THE CONSTRUCTION ACTIVITY IN THAT PORTION OF THE SITE HAS TEMPORARILY OR PERMANENTLY CEASED. SOME EXCEPTIONS MAY APPLY; REFER TO THE NEVADA STORMWATER GENERAL PERMIT FOR CONSTRUCTION ACTIVITY NVR100000, SECTION III.A.5.
4. AT A MINIMUM, THE CONTRACTOR OR HIS AGENT SHALL INSPECT ALL DISTURBED AREAS, AREAS USED FOR STORAGE OF MATERIALS AND EQUIPMENT THAT ARE EXPOSED TO PRECIPITATION, VEHICLE ENTRANCE AND EXIT, AND OTHER ACTIVITIES THAT MAY CAUSE EROSION OR POLLUTION. THE CONTRACTOR MAY DO MORE. THE CONTRACTOR OR HIS AGENT SHALL UPDATE OR MODIFY THE STORMWATER POLLUTION PREVENTION PLAN AS NECESSARY. SOME EXCEPTIONS TO WEEKLY INSPECTIONS MAY APPLY, SUCH AS THE FOLLOWING: REFERENCE TO THE NEVADA STORMWATER GENERAL PERMIT FOR CONSTRUCTION ACTIVITY NVR 100000, SECTION III.A.12.
5. THE DEVELOPER SHALL BE RESPONSIBLE TO PROVIDE AND INSTALL ALL PERMANENT SIGNS SHOWN ON THE PLANS. STREET NAME SIGNS SHALL CONFORM IN THEIR ENTIRETY TO CLARK COUNTY AREA STANDARDS. ALL OTHER SIGNS SHALL BE STANDARD SIZE UNLESS OTHERWISE SPECIFIED ON THE PLANS. ALL SIGN POSTS SHALL BE INSTALLED IN ACCORDANCE WITH CLARK COUNTY AREA STANDARDS. ALL SIGNS SHALL USE TYPE III SHEETING.

LAS VEGAS VALLEY WATER DISTRICT
(LVVWD) STANDARD NOTES

LVVWD PROJECT #XXXXXX

1. NO WORK SHALL BEGIN UNTIL THE WATER PLANS HAVE BEEN APPROVED FOR CONSTRUCTION BY THE LVVMD. FOLLOWING WATER PLAN APPROVAL, NOTICE SHALL BE GIVEN TO THE LVVMD COMMUNICATION SUPPORT CENTER (258-7171) TWO (2) WORKING DAYS PRIOR TO THE START OF CONSTRUCTION. FOR FUTURE INSPECTIONS, NOTICE MUST BE GIVEN BY 2:00 P.M. THE BUSINESS DAY PRIOR TO THE REQUESTED LVVMD INSPECTION. WHEN REQUESTING INSPECTIONS, PLEASE REFER TO THE PROJECT # IDENTIFIED ABOVE.
2. ALL WORK SHALL CONFORM TO LVVMD STANDARD PLATES, DRAWINGS, AND SPECIFICATIONS, AND TO THE 2010 EDITION OF THE UNIFORM DESIGN AND CONSTRUCTION STANDARDS FOR POTABLE WATER SYSTEMS (UDACS). THE LATEST EDITION OF UDACS SHALL SUPERSEDE ANY CONFLICTS CONTAINED IN THE APPROVED DRAWINGS AND/OR SPECIFICATIONS.
3. ALL WORK, EXCEPT AS MODIFIED BY THESE PLANS OR BY NOTE 2 ABOVE, SHALL BE DONE IN ACCORDANCE WITH THE MOST RECENT DRAFT OR EDITION OF THE UNIFORM SPECIFICATIONS FOR PUBLIC WORKS CONSTRUCTION OFFSITE IMPROVEMENT, CLARK COUNTY AREA.
4. A SINGLE PIPE MATERIAL SHALL BE USED THROUGHOUT THE PROJECT UNLESS OTHERWISE APPROVED BY THE LVVMD.
5. ALL SERVICE LATERALS TWO (2) INCHES IN DIAMETER AND SMALLER SHALL BE TYPE K COPPER TUBING WITH LVVMD APPROVED SERVICE SADDLES.
6. ALL WATER METER BOXES SHALL BE LOCATED OUTSIDE OF DRIVEWAY AREAS.
7. ALL VALVES SHALL BE LOCATED OUTSIDE OF DRIVEWAYS, VALLEY AND CURB GUTTERS.
8. ALL WATER AND STORM DRAIN OR SANITARY SEWER CROSSINGS SHALL CONFORM TO SECTION 2.22 OF THE 2010 EDITION OF THE UDACS
9. ALL WATER FACILITIES SHALL BE FILLED, DISINFECTED, PRESSURE TESTED, FLUSHED, FILLED, AND AN ACCEPTABLE WATER SAMPLE OBTAINED, PRIOR TO CONNECTION TO THE LVVMD DISTRIBUTION SYSTEM.
10. THE CONTRACTOR MUST OBTAIN ALL METERS TWO (2) INCHES AND SMALLER FROM LVVMD CENTRAL STORES. TELEPHONE 258-3152 OR 258-3802, TWO (2) WORKING DAYS PRIOR TO METER PICKUP.
11. ANY INTERRUPTION OF SERVICE MUST BE PERFORMED IN ACCORDANCE WITH UDACS SECTION 3.14.01, AND APPROVED BY THE LVVMD INSPECTION DEPARTMENT PRIOR TO SHUTDOWN. PROPER WRITTEN NOTIFICATION MUST BE GIVEN TO ALL AFFECTED CUSTOMERS.
12. ALL WATER FACILITY CONSTRUCTION MATERIALS USED MUST BE LISTED ON THE LVVMD PRE-APPROVED MATERIALS AND MANUFACTURER'S LISTING FOR NEW FACILITIES, LATEST REVISION, OR SPECIALLY APPROVED ON THESE PLANS.
13. TELEPHONE "CALL BEFORE YOU DIG" AT "811" OR 1-800-227-2600.
14. THE INSTALLATION OF LAS VEGAS VALLEY WATER DISTRICT (LVVMD) MUNICIPAL WATER FACILITIES WITHIN ALL STREETS IS ASSUMED TO BE IN COMPLIANCE WITH THE UNIFORM STANDARDS, INCLUDING THE PLACEMENT OF ASPHALT PAVING SURFACES. ANY REPAIR WORK DONE BY THE LVVMD TO THE MUNICIPAL WATER FACILITIES WILL INCLUDE THE PLACEMENT OF AN APPROPRIATELY SIZED ASPHALT REPAIR PATCH ON THE STREET SURFACE. ANY DECORATIVE PAVING SURFACE WITHIN THE STREET IS THE RESPONSIBILITY OF THE OWNER'S ASSOCIATION, OR THE INDIVIDUAL PROPERTY OWNERS IF NO OWNER'S ASSOCIATION IS IN EXISTENCE, OR THE AGENCY HAVING JURISDICTION DECORATIVE SURFACE MATERIALS PLACED WITHIN THE TEN FOOT EASEMENT ABUTTING A PUBLIC OR PRIVATE STREET, IF DISTURBED BY THE LVVMD DURING THE REPAIR OR OPERATION OF ITS FACILITIES, WILL BE REPLACED BY LVVMD WITH AN APPROPRIATELY SIZED PLAN FINISH CONCRETE PATCH. THE LVVMD WILL NOT RESTORE, AND WILL NOT BE RESPONSIBLE FOR THE RESTORATION OF ANY DECORATIVE PAVING SURFACES WITH THE STREET. THE LVVMD WILL NOT ATTEMPT TO MATCH COLOR OR FINISH OF ANY ADJACENT MATERIALS.

APPROVED FOR CONSTRUCTION

LAS VEGAS VALLEY WATER DISTRICT ENGINEERING SERVICES MANAGER
DATE _____ LVVWD PROJECT # XXXXXX

CITY OF LAS VEGAS GENERAL NOTES

1. ALL CONSTRUCTION AND MATERIALS SHALL BE IN ACCORDANCE WITH THE "UNIFORM STANDARD SPECIFICATIONS FOR PUBLIC WORKS CONSTRUCTION OFF-SITE IMPROVEMENTS, CLARK COUNTY AREA NEVADA", LATEST EDITION, THE "UNIFORM STANDARD DRAWINGS FOR PUBLIC WORKS CONSTRUCTION, CLARK COUNTY AREA NEVADA", LATEST REVISION AND THE "SUMMIT COUNTY STANDARD SPECIFICATIONS FOR WORK IN THE SUMMERLIN AREA, AND OTHER APPLICABLE APPROVED STANDARDS (ISSUED BY THE CONTROLLING AGENCY, THE UNIFORM BUILDING CODE, AND ALL LOCAL CITY CODES AND ORDINANCES APPLICABLE, EXCEPT AS NOTED ON THIS SHEET AS "DEVIATIONS FROM STANDARDS".
2. THE EXISTENCE AND LOCATION OF ANY OVERHEAD OR UNDERGROUND UTILITY LINES, PIPES, OR STRUCTURES SHOWN ON THESE PLANS ARE OBTAINED BY A RESEARCH OF THE AVAILABLE RECORDS. EXISTING UTILITIES AS SHOWN FROM CLV PLANS LIBRARY ARE APPROXIMATE AND FOR RECORD PURPOSES. EXISTING UTILITIES ARE LOCATED ON PLANS PROVIDED BY THE CITY ENGINEER. THE CONTRACTOR'S EXISTING UTILITY SERVICE LATERALS MAY NOT BE SHOWN ON THE PLANS. THE CONTRACTOR SHALL, AT HIS OWN EXPENSE, LOCATE ALL UNDERGROUND AND OVERHEAD INTERFERENCE WHICH MAY AFFECT HIS OPERATION DURING CONSTRUCTION AND SHALL TAKE ALL NECESSARY PRECAUTIONS TO AVOID DAMAGE TO SAME. THE CONTRACTOR SHALL EXERCISE EXTREME CAUTION WHEN WORKING NEAR OVERHEAD UTILITIES SO AS TO SAFELY PROTECT ALL PERSONNEL AND EQUIPMENT, AND SHALL BE RESPONSIBLE FOR ALL COST AND LIABILITY IN CONNECTION THEREWITH.
3. THE CONTRACTOR SHALL TAKE ALL PRECAUTIONARY MEASURES NECESSARY TO PROTECT EXISTING UTILITY LINES, STRUCTURES AND STREET IMPROVEMENTS WHICH ARE TO REMAIN IN PLACE, FROM DAMAGE, AND ALL SUCH IMPROVEMENTS OR STRUCTURES DAMAGED BY THE CONTRACTOR'S OPERATIONS SHALL BE REPAIRED OR REPLACED SATISFACTORY TO THE CITY ENGINEER OR OWNING UTILITY COMPANY AT THE EXPENSE OF THE CONTRACTOR.
4. ALL CONSTRUCTION SHALL BE AS SHOWN ON THESE PLANS; ANY REVISIONS SHALL HAVE THE PRIOR WRITTEN APPROVAL OF THE CITY ENGINEER.
5. TYPE V CEMENT SHALL BE USED IN ALL OFF-SITE CONCRETE WORK. CONCRETE TO BE 3000 P.S.I. MINIMUM @ 28 DAYS. MIX DESIGN TO BE APPROVED BY THE QUALITY CONTROL DIVISION, PRIOR TO THE USE ON THE PROJECT.
6. PERMITS ARE REQUIRED FOR ANY WORK IN THE PUBLIC RIGHT-OF-WAY. THE CONTRACTOR SHALL SECURE ALL PERMITS AND INSPECTIONS EVERY 300' IN EXTRUDED-TYPE CURB.
7. JOINTS REQUIRED, MAXIMUM EVERY 300' IN EXTRUDED-TYPE CURB.
8. AC PAVEMENT TO BE 1/2" ABOVE LIP OF ALL GUTTERS AFTER COMPACTION, EXCEPT AT SIDEWALK RAMPS.
9. CURB AND GUTTER WITH A GRADE OF LESS THAN FOUR-TENTHS OF ONE PERCENT SHALL BE WATER-TESTED AS SOON AS POSSIBLE AFTER CONSTRUCTION, ANY CURB AND GUTTER FOUND TO BE UNACCEPTABLE TO THE CITY SHALL BE REMOVED AND REPLACED PER USD 216.
10. SIDEWALK RAMPS SHALL BE CONSTRUCTED IN EACH QUADRANT OF AN INTERSECTION PER USD 235, CASE I. EXACT LOCATION OF RAMPS MAY BE ADJUSTED IN THE FIELD BY A CITY PROJECT REPRESENTATIVE.
11. CONTRACTOR SHALL PROVIDE ALL NECESSARY HORIZONTAL AND VERTICAL TRANSITIONS BETWEEN NEW CONSTRUCTION AND EXISTING SURVEY TO PROVIDE FOR PROPER DRAINAGE AND FOR INGRESS AND EGRESS TO NEW CONSTRUCTION. THE EXTENT OF TRANSITIONS TO BE AS SHOWN ON PLANS, OR AS DESIGNATED IN THE FIELD BY CITY PROJECT REPRESENTATIVE.
12. EXACT LOCATION OF ALL SAWCUT LINES MAY BE DETERMINED IN THE FIELD BY A CITY PROJECT REPRESENTATIVE IF LOCATION ON PLANS IS NOT CLEARLY SHOWN, OR EXISTING PAVEMENT CONDITION REQUIRES RELOCATIONS.
13. THE CONTRACTOR SHALL TAKE ALL PRECAUTIONS NECESSARY TO PROTECT EXISTING PERMANENT SURVEY MONUMENTS. ANY MONUMENTS DISTURBED SHALL BE REPLACED, AND SHALL BE DONE ONLY BY A NEVADA PROFESSIONAL LAND SURVEYOR OR ACCORDING TO NEVADA UNIFORM STANDARD DRAWINGS - CLARK COUNTY AREA. A RECORD-OF-SURVEY FOR REPLACEMENT OF PERMANENT SURVEY MONUMENTS SHALL BE SUBMITTED TO THE CITY ENGINEER FOR APPROVAL PRIOR TO RECORDING. THE RECORD-OF-SURVEY SHALL BE PREPARED IN ACCORDANCE WITH NEVADA REVISED STATUTES 625.350.
14. UTILITY COMPANY METER BOXES, MANHOLE LIDS, VALVE COVERS, ETC., SHALL BE LOCATED IN THE FIELD BY THE CITY ENGINEER AND CROSS GUTTER UNLESS WRITTEN APPROVAL IS GRANTED BY THE AFFECTED UTILITY COMPANY AND THE CITY ENGINEER.
15. ALL WALLS, NEW OR EXISTING, ARE ONLY SHOWN ON CIVIL PLANS FOR THE PURPOSE OF REVIEWING GRADING RELATIONSHIPS, FLOOD CONTROL, AND SIGHT DISTANCE AT INTERSECTIONS. NEW WALLS REQUIRE A SEPARATE PERMIT AND INSPECTION BY THE CLV BUILDING DEPARTMENT.
16. ASPHALT MIX DESIGN MUST BE SUBMITTED AND APPROVED BY THE CITY ENGINEER PRIOR TO THE PLACEMENT OF ASPHALT WITHIN CITY RIGHTS OF WAY.
17. CONTRACTOR SHALL ADJUST ALL NEW AND EXISTING INLETS, VALVE BOXES, MANHOLE RIMS, SEWER CLEANOUPS, ETC. TO FINISH GRADE AS APPLICABLE WHETHER OR NOT THEY ARE SHOWN ON THE PLANS.
18. MATERIALS, HANDLING AND PLACEMENT OF PORTLAND CEMENT CONCRETE SHALL BE IN ACCORDANCE WITH APPLICABLE SECTIONS OF NDOT AND CLARK COUNTY AREA SPECIFICATIONS (AS APPLICABLE) AND THE PLANS AND DETAILS SHOWN HEREON.
19. WHEN INSTALLING UNDERGROUND FACILITIES THAT REQUIRE UNDERGROUND LOCATING DEVICES SUCH AS MARKER BAILS, LOCATING RIBBON, ETC., THE CONTRACTOR SHALL PROVIDE WRITTEN DOCUMENTATION TO THE ENGINEER CERTIFYING THAT ALL DEVICES HAVE BEEN PLACED AND VERIFIED TO BE IN GOOD WORKING CONDITION PRIOR TO THE CONSTRUCTION OF ANY ROAD BASE.
20. SANITARY SEWER AND STORM DRAIN FINAL LOCATION INFORMATION SHALL BE PROVIDED TO THE ENGINEER PRIOR TO PROJECT ACCEPTANCE. THE INFORMATION SHALL INCLUDE THE HORIZONTAL AND VERTICAL (INVERT) LOCATION OF PUBLIC SEWER MANHOLES, STORM DRAIN MANHOLES, STORM DRAIN LATERALS AT THE CONNECTION TO THE STORM DRAIN MAIN AND THE LOCATION OF THE CONNECTION TO A DROP INLET, AND THE CONNECTION OF SEWER SERVICE LATERALS TO THE SEWER MAIN AND WHERE THE SEWER SERVICE LATERALS EXITS THE PUBLIC RIGHT-OF-WAY. THE LOCATION SHALL BE DESCRIBED BY COORDINATES WHICH SHALL BE BASED ON THE OFFICIAL HORIZONTAL AND VERTICAL CONTROL NETWORKS. THE CONTRACTOR SHALL HAVE THE LOCATION OF THE SEWER SERVICE LATERALS AND CERTIFIED BY A NEVADA PROFESSIONAL LAND SURVEYOR TO HAVE POSITIONAL CERTAINITIES OF ± 0.09 METERS (± 0.3 FEET) HORIZONTALLY AND VERTICALLY. A SEPARATE ELECTRONIC COMMA DELIMITED FILE FOR THE SANITARY SEWER AND STORM DRAIN COORDINATES SHALL ALSO ACCOMPANY THE SANITARY SEWER AND STORM DRAIN FINAL LOCATION INFORMATION.
21. CCTV VIDEO INSPECTION IS REQUIRED FOR ALL SEWER AND STORM DRAINS. THE CCTV VIDEO INSPECTIONS NEED TO BE PERFORMED PER THE DESIGN AND CONSTRUCTION STANDARDS FOR WASTEWATER COLLECTION SYSTEMS LATEST ADDITION.
22. A SEPARATE BORING PERMIT IS REQUIRED FOR ALL BORING ACTIVITIES.

REVISÉ JANUARY 23, 2014

CITY OF LAS VEGAS STREETLIGHT NOTES

1. ALL STREET LIGHTING INSTALLATIONS SHALL BE IN ACCORDANCE WITH THE STREET LIGHTING PLANS, THE "UNIFORM STANDARD SPECIFICATIONS FOR PUBLIC WORKS CONSTRUCTION OFF-SITE IMPROVEMENTS, CLARK COUNTY AREA, NEVADA," LATEST REVISION, AND THE "UNIFORM STANDARD DRAWINGS FOR PUBLIC WORKS CONSTRUCTION OFF-SITE IMPROVEMENTS, CLARK COUNTY AREA, NEVADA," LATEST REVISION, AND ANY ADOPTED SPECIAL AREA STANDARDS.
2. NO DEVIATION OF STREET LIGHT, PULL BOX, CONDUITS (ETC.) LOCATIONS SHALL BE PERMITTED WITHOUT WRITTEN APPROVAL OF TRAFFIC ENGINEERING AND THE CITY ENGINEER.
3. ALL EXISTING STREET LIGHTING SHALL REMAIN OPERATIONAL DURING CONSTRUCTION.
4. ALL STREET LIGHTING CONDUITS SUB SHALL HAVE AT LEAST ONE GREEN #8 THW WIRE INSTALLED, AS TRACER WIRE. WHEN "EMERGENCY" CONDUIT COMPLETELY INSTALLED, IT SHALL BE LEFT TO IT SHALL HAVE MINIMUM OF 2 #4 ALUMINUM WIRE WITH GREEN END CAPS TO BE LEFT OFF, RETURN TO FINAL LOCATION.
5. ANY STRUCTURE SUCH AS BLOCK WALLS, CHAIN LINK FENCES, RETAINING WALLS, ETC., SHALL HAVE A MINIMUM CLEARANCE IN ACCORDANCE WITH THE USD NO. 320A.
6. AS-BUILT DRAWINGS SHALL BE SUPPLIED TO THE TEF0 PRIOR TO ANY PRE-FINAL INSPECTION. THE AS-BUILT DRAWING NEEDS TO BE STAMPED AS-BUILT AND SIGNED BY THE PREPARER.
7. SERVICE POINT SHALL BE COORDINATED WITH NV ENERGY COMPANY AND WHEREVER POSSIBLE, BE LOCATED NEAR THE CENTER OF THE STREET. SERVICE POINTS SHALL BE LOCATED NEAR THE CIVIL PLANS.
8. IT SHALL BE ASSUMED THAT IN THE ABSENCE OF AN EXISTING, WORKABLE CIRCUIT TO ATTACH TO, ALL INSTALLATIONS SHALL REQUIRE A NEW SERVICE FOR OPERATION OF THE CIRCUIT.
9. WHEREVER THERE IS AN OVERHEAD UTILITY THAT MAY CONFLICT WITH THE INSTALLATION OF STREET LIGHTING CIRCUITS AND/OR POLES, THESE CONFLICTS MUST BE RESOLVED BETWEEN THE DEVELOPER AND THE UTILITIES AGENCIES, AT NO CHARGE TO THE CITY OF LAS VEGAS, PRIOR TO STREET LIGHTING BASES ARE INSTALLED.
10. THE CONTRACTOR SHALL FURNISH COMPLETE SERVICE TO TRANSFORMERS AND CONTROL SYSTEMS IF REQUIRED ON PLANS.
11. THE DEVELOPER/OWNER WILL BE REQUIRED TO SUPPLY POWER TO ALL NEW PUBLIC STREET LIGHTS INSTALLED UNDER THIS DESIGN PRIOR TO BOND RELEASE OR PROJECT COMPLETION. THE DEVELOPER/OWNER WILL BE RESPONSIBLE FOR ALL ITEMS ASSOCIATED WITH THE DESIGN, CONSTRUCTION, ENERGIZING, MAINTENANCE AND OPERATIONAL OF THE STREET LIGHTING PRIOR TO PROJECT COMPLETION. REFER TO THE PLAN FOR ANY NEW SERVICE REQUIREMENTS. THE TRANSFER OF OWNERSHIP FROM THE DEVELOPER/OWNER TO THE CITY OF LAS VEGAS FOR ALL NEW PUBLIC STREET LIGHTS AND/OR SERVICE/S INSTALLED UNDER THIS DESIGN SHALL BE CONSIDERED TO BE THE DATE OF THE PROJECT COMPLETION. ALL MAINTENANCE AND OPERATIONAL TRANSFERS WITH THE CITY OF LAS VEGAS TRAFFIC ENGINEERING DEPARTMENT (TEF0) AT (702) 229-6331.

REVISÉD 04/15/10

LAS VEGAS FIRE AND RESCUE GENERAL NOTES

- ALL WORK SHALL BE DONE IN STRICT ACCORDANCE WITH THE LAS VEGAS FIRE AND RESCUE ADOPTED FIRE CODE ORDINANCE # 6325 FOR HYDRANT SPECIFICATIONS AND HYDRANT INSTALLATION SPECIFICATIONS.
2. AUTHORIZED FIRE HYDRANTS ARE AS FOLLOWS:
- KENNEDY -GARDIAN MODELS KB1A AND KB1D
 - MUELLER -SUPER CENTURION 250, MODEL A-423
 - CLOW -MEDALLION MODEL F-25461LV0
 - U.S.PIPE -METROFLOW/M-03
3. A PERMIT IS REQUIRED FROM LAS VEGAS FIRE AND RESCUE FOR THE INSTALLATION OF ON-SITE WATER LINES AND FIRE HYDRANTS. THE PERMIT AND CONTRACTORS MATERIAL TEST CERTIFICATE FOR UNDERGROUND PIPING WORK SHALL BE OBTAINED FROM THE FIRE PROTECTION ENGINEER BEFORE COMMENCEMENT OF WORK. [IFC § 505.7.12]
4. ON ANY RESIDENTIAL OR COMMERCIAL INSTALLATIONS, FIRE HYDRANTS SHALL BE INSTALLED AND FIRE APPARATUS ACCESS ROADS SHALL BE MAINTAINED BEFORE COMMENCEMENT OF ANY COMBUSTIBLE CONSTRUCTION. ALL FIRE HYDRANTS SHALL BE IN GOOD WORKING ORDER AND SHALL BE CAPABLE OF DELIVERING THE REQUIRED FIRE FLOW. [IFC § 531.0, § 531.2]
5. TO IDENTIFY THE FIRE HYDRANT LOCATIONS, THE CONTRACTOR SHALL PLACE A BLUE REFLECTIVE MARKER AT THE CENTER LINE OF THE STREET ADJACENT TO THE FIRE HYDRANTS. [IFC § 507.5.7.3]
6. ALL UNDERGROUND INSPECTIONS, PRESSURE AND FLUSH VERIFICATIONS OF ALL FIRE HYDRANTS AND FIRE LINES, SHALL BE CONDUCTED BEFORE COVERING THE LINES, CENTER LOADING IS ACCEPTABLE FOR THE HYDRO TESTS WITH PRIOR FIRE PREVENTION APPROVAL. [IFC § 106.3]
7. ALL ON-SITE UNDERGROUND WATER MAINS AND MATERIALS SHALL BE U.L. LISTED, A.W.W.A. APPROVED AND SHALL BE RATED FOR THE APPROPRIATE WORKING PRESSURE. [IFC § 507.2.1, NFPA 24]
8. PAINTING OF CURBS, FIRE HYDRANTS, BARS, PROTECTION OF FIRE HYDRANTS FROM PHYSICAL DAMAGE, AND ALL OTHER WORK NECESSARY PLANS SHALL BE COMPLETED BEFORE APPROVAL BY LAS VEGAS FIRE AND RESCUE, FIRE PREVENTION DIVISION. [IFC § 507]
9. PRIVATE HYDRANTS SHALL BE PAINTED RED. [IFC § 507.5.3.1]
10. PRIOR TO THE FINAL OCCUPANCY, A FIRE FLOW TEST SHALL BE WITNESSED BY LAS VEGAS FIRE AND RESCUE, FIRE PREVENTION DIVISION TO VERIFY AVAILABILITY OF THE REQUIRED FIRE FLOW. [IFC § 507]
11. FIRE HYDRANT SPACING SHALL BE AS FOLLOWS: [IFC § C102]
- RESIDENTIAL -500 FT UNSPRINKLERED; 600 FT SPRINKLERED.
 - COMMERCIAL -300 FT UNSPRINKLERED; 400 FT SPRINKLERED.
12. WHERE THE WATER MAINS ARE EXTENDED ALONG STREETS OR NEW STREETS ARE INSTALLED WHERE FIRE HYDRANTS ARE NOT NEEDED FOR PROTECTION OF THE STRUCTURES, FIRE HYDRANTS SHALL BE INSTALLED AT A MAXIMUM OF 1000 FT SPACING, TO PROVIDE FOR TRANSPORTATION HAZARDS. WHERE STREETS ARE PROVIDED WITH MEDIAN DIVIDERS OR HAVE FOUR (4) OR MORE TRAFFIC LANES AND HAVE A TRAFFIC COUNT OF MORE THAN 30,000 PER DAY, HYDRANTS ARE REQUIRED ON EACH SIDE OF THE STREET SPACED AT 500 FT ON AN ALTERNATING BASIS. [IFC § C102.6]
13. NO FIRE HYDRANTS SHALL BE LOCATED WITHIN THE RADIUS OF A CUL-DE-SAC OR WITHIN 20 FT OF THE PERIMETER OF THE RADIUS OF THE CUL-DE-SAC.
14. NO FIRE HYDRANTS SHALL BE LOCATED WITHIN 6 FT OF ANY CURB RETURN, DRIVEWAY, POWER POLE, STREETLIGHT OR ANY OTHER OBSTRUCTION. [IFC § C102.12]
15. A MAXIMUM DISTANCE FROM A FIRE HYDRANT TO A ONE-TWO FAMILY DWELLING SHALL NOT EXCEED 300 FT, AS MEASURED BY AN APPROVED ROUTE. [IFC § C102.4]
16. THE MAXIMUM DISTANCE FROM A FIRE HYDRANT TO A FIRE DEPARTMENT CONNECTION (FDC) SHALL NOT EXCEED 100 FT, AS MEASURED BY AN APPROVED ROUTE. [IFC § C102.7]
17. THE MAXIMUM DISTANCE FROM A HYDRANT TO THE END OF A DEAD-END STREET SHALL NOT EXCEED 200 FT. [IFC § C102.6]
18. TWO (2) SOURCES OF SUPPLY ARE REQUIRED WHENEVER THERE IS 4 OR MORE FIRE HYDRANTS/SPRINKLER LEAD-INS ARE INSTALLED ON A SINGLE SYSTEM. SECTIONAL CONTROL VALVE SHALL BE INSTALLED AT A MAXIMUM OF 800 FT. TWO (2) FIRE HYDRANTS CAN BE OUT OF SERVICE DUE TO A BREAK IN A WATER MAIN. [IFC § C104]
19. ALL FIRE APPARATUS ACCESS ROADS SHALL BE PAVED TO PROVIDE ALL-WEATHER DRIVING CAPABILITY AND BE DESIGNED AND MAINTAINED TO SUPPORT THE IMPOSED LOADS OF THE FIRE APPARATUS. [IFC § 503.2.3]
20. THE GRADIENT FOR THE FIRE APPARATUS ACCESS ROADS SHALL NOT EXCEED 12% ANGLES OF APPROACH AND ANGLES OF DEPARTURE SHALL NOT EXCEED 6% FOR 25 FT PRIOR TO AND AFTER THE GRADE CHANGE. ADJACENT TO THE STRUCTURES GRADIENT SHALL NOT EXCEED 6%. [IFC § 503.2.7, § 503.2.8]
21. THE TURNING RADIUS OF THE FIRE APPARATUS ACCESS ROADS SHALL BE NO LESS THAN 52 FT OUTSIDE AND 28 FT INSIDE TURNING RADIUS. [IFC § 503.2.4]
22. VERTICAL CLEARANCE OF ALL FIRE APPARATUS ACCESS ROADS SHALL NOT BE LESS THAN 13FT 6 INS. [IFC § 503.2.1]
23. FIRE DEPARTMENT ACCESS ROADS SHALL HAVE A MINIMUM UNOBSTRUCTED WIDTH OF NOT LESS THAN 12 FT. FLOW-LINE AND FLOW-LINE WITH PARALLEL PARKING PERMITTED ON BOTH SIDES, NOT LESS THAN 32 FT WIDE, FLOW-LINE TO FLOW-LINE, WHERE PARKING IS PERMITTED ONLY ON ONE SIDE OF THE FIRE APPARATUS ACCESS ROAD, NOT LESS THAN 24 FT WIDE, FLOW-LINE TO FLOW-LINE, WHERE ROADWAY IS PERMITTED TO PREVENT PARKING ON EITHER SIDE. SIGNS TO BE INSTALLED NOT LESS THAN 24 FT. [IFC § 503.2.1.1]
24. A FIRE APPARATUS ACCESS ROAD SHALL BE REQUIRED WHEN ANY PORTION OF AN EXTERIOR WALL OF A FIRE STORY IS LESS THAN 150 FT FROM A FIRE DEPARTMENT VEHICLE ACCESS. THIS DISTANCE COULD BE INCREASED TO 250 FT IF THE BUILDING IS SPRINKLERED. [IFC § 503.1.1]
25. APPROVED SECONDARY FIRE APPARATUS ACCESS SHALL BE PROVIDED FOR 100 OR MORE DWELLING UNITS, ROAD(S) WITH DEAD-ENDS OR WITH A SINGLE POINT OF ACCESS IN EXCESS OF 600 FT. COMMERCIAL AND INDUSTRIAL DEVELOPMENTS WHERE BUILDINGS EXCEED 2 STORIES OR 30 FEET IN HEIGHT, OR EXCEEDING 62,000 SQUARE FEET IN AREA. [IFC § 503.1.2]
26. ALL DEAD-END FIRE APPARATUS ROADS AND/OR FIRE LINES, PUBLIC OR PRIVATE, IN EXCESS OF 150 FT IN LENGTH SHALL BE PROVIDED WITH AN APPROVED TURN AROUND HAVING A MINIMUM DIAMETER OF 81 FT. [IFC § 503.2.5]
27. ALL FIRE APPARATUS ACCESS ROADS SHALL BE MARKED BY PLACING APPROVED SIGNS AT THE START OF THE DESIGNATED FIRE LANE, ONE SIGN AT THE END OF THE FIRE LANE AND WITH SIGNS AT INTERVALS OF 100 FT ALONG THE DESIGNATED FIRE LINES. SIGNS TO BE PLACED ON BOTH SIDES OF AN ACCESS ROADWAY IS PERMITTED TO PREVENT PARKING ON EITHER SIDE. SIGNS TO BE INSTALLED NO HIGHER THAN 10 FT OR LESS THAN 6 FT FROM THE ROADWAY LEVEL. THE CURB ALONG OR ON THE PAVEMENT OR CEMENT (IF NO CURB IS PROVIDED) SHALL BE PAINTED WITH A RED WEATHER RESISTANT PAINT IN ADDITION TO THE SIGNS. [IFC § 503.3]
28. ELECTRICALLY CONTROLLED ACCESS GATES SHALL BE PROVIDED WITH AN APPROVED EMERGENCY VEHICLE DETECTOR/RECEIVER SYSTEM. SAID SYSTEM SHALL BE INSTALLED IN ACCORDANCE WITH THE IFC § 503.6 AND IFC APPENDIX M.
- REVISED 7/1/14

UTILITY NOTES

NV ENERGY, CENTRAL TELEPHONE CO, DBA CENTURY LINK TELEPHONE, AND SOUTHWEST GAS SHOWN FOR INFORMATIONAL PURPOSES ONLY. REFERENCE NV ENERGY, CENTRAL TELEPHONE CO, DBA CENTURY LINK TELEPHONE, AND SOUTHWEST GAS DRAWINGS FOR CONSTRUCTION DETAILS. CONTRACTOR TO COORDINATE WITH UTILITIES FOR REMOVAL AND INSTALLATION OF FACILITIES.

ALL EXISTING UTILITY LOCATIONS SHOWN HEREON ARE APPROXIMATE ONLY. IT SHALL BE THE CONTRACTOR'S RESPONSIBILITY TO DETERMINE THE EXACT VERTICAL AND HORIZONTAL LOCATION OF ALL EXISTING UNDERGROUND UTILITIES PRIOR TO COMMENCING CONSTRUCTION. NO REPRESENTATION IS MADE THAT ALL UTILITIES ARE SHOWN HEREON. THE ENGINEER ASSUMES NO RESPONSIBILITY FOR UTILITIES NOT SHOWN IN THEIR EXISTING LOCATION. THE DEPTH BELOW GRADE OF ALL EXISTING UTILITIES DETECTED ON THE PLANS VARIES THROUGHOUT THE PROJECT AREA. THE CONTRACTOR SHALL EXERCISE EXTREME CARE WHEN EXCAVATING AND GRADING THE SUBBASE IN THE VICINITY OF UTILITIES TO THE LATTER.

ALL EXISTING UTILITIES SHALL BE PROTECTED IN PLACE UNLESS OTHERWISE NOTED.

CITY OF LAS VEGAS GRADING NOTES

1. IN THE EVENT THAT ANY UNFORESEEN CONDITIONS NOT COVERED BY THESE NOTES ARE ENCOUNTERED DURING GRADING OPERATIONS, THE OWNER/ENGINEER SHALL BE IMMEDIATELY NOTIFIED FOR DIRECTION.
2. IT SHALL BE THE RESPONSIBILITY OF THE CONTRACTOR TO PERFORM ALL NECESSARY CUTS AND FILLS WITHIN THE LIMITS OF THIS PROJECT AND THE RELATED OFF-SITE WORK, SO AS TO GENERATE THE DESIRED SUBGRADE, FINISH GRADES AND SLOPES SHOWN.
3. CONTRACTOR SHALL TAKE FULL RESPONSIBILITY FOR ALL EXCAVATION. ADEQUATE SHORING SHALL BE DESIGNED AND PROVIDED BY THE CONTRACTOR TO PREVENT UNDERMINING OF ANY ADJACENT FEATURES OR FACILITIES AND/OR CAVING OF THE EXCAVATION.
4. THE GRADING CONTRACTOR IS RESPONSIBLE TO COORDINATE WITH THE OWNER TO PROVIDE FOR THE REQUIREMENTS OF THE PROJECT STORM WATER POLLUTION PREVENTION PLAN (SWPPP) AND ASSOCIATED PERMIT.
5. CONTRACTOR SHALL GRADE TO THE LINES AND ELEVATIONS SHOWN ON THE PLANS WITHIN THE FOLLOWING HORIZONTAL AND VERTICAL TOLERANCES AND DEGREES OF COMPACTION, IN THE AREAS INDICATED:

	<u>HORIZONTAL</u>	<u>VERTICAL</u>
A. PAVEMENT AREA SUBGRADE	0.1'±	+0.0' TO -0.1'
B. ENGINEERED FILL	0.5'±	+0.1' TO -0.1'
6. COMPACTION TESTING WILL BE PERFORMED BY THE OWNER OR HIS REPRESENTATIVE. COMPACTION SHALL COMPLY WITH THE REQUIREMENTS OF THE ENGINEER.
7. ALL CUT AND FILL SLOPES SHALL BE PROTECTED UNTIL EFFECTIVE EROSION CONTROL HAS BEEN ESTABLISHED.
8. THE USE OF POTABLE WATER WITHOUT A SPECIAL PERMIT FOR BUILDING OR CONSTRUCTION PURPOSES INCLUDING CONSOLIDATION OF BACKFILL OR DUST CONTROL IS PROHIBITED. THE CONTRACTOR SHALL OBTAIN ALL NECESSARY PERMITS FOR CONSTRUCTION WATER.
9. THE CONTRACTOR SHALL MAINTAIN THE STREETS, SIDEWALKS AND ALL OTHER PUBLIC RIGHT-OF-WAY IN A CLEAN, SAFE AND USABLE CONDITION. ALL SPILLS OF SOIL, ROCK OR CONSTRUCTION DEBRIS SHALL BE PROMPTLY REMOVED FROM THE PUBLICLY OWNED PROPERTY DURING CONSTRUCTION AND UPON COMPLETION OF THE PROJECT. ALL ADJACENT PROPERTY, PRIVATE OR PUBLIC SHALL BE MAINTAINED IN A CLEAN, SAFE AND USABLE CONDITION.
10. IN THE EVENT THAT ANY TEMPORARY CONSTRUCTION ITEM IS REQUIRED THAT IS NOT SHOWN ON THESE DRAWINGS, SUCH ITEM SHALL BE PROVIDED, AS DIRECTED BY THE CITY ENGINEER, AT NO EXPENSE TO THE CITY OF LAS VEGAS. TEMPORARY CONSTRUCTION INCLUDES DITCHES, BERMS, ROAD SIGNS AND BARRICADES, ETC.

REVISÉ JULY 2008

DEVIATION FROM STANDARDS

NONE

CITY OF LAS VEGAS TRAFFIC NOTES

1. ALL CONSTRUCTION SIGNING, BARRICADING, AND TRAFFIC DELINEATION SHALL CONFORM TO THE "MANUAL ON UNIFORM TRAFFIC CONTROL DEVICES", LATEST EDITION.
2. THE STREET SIGN CONTRACTOR SHALL OBTAIN STREET NAMES AND BLOCK NUMBERING FROM THE PLANNING DEPARTMENT PRIOR TO CONSTRUCTION.
3. BEFORE ANY WORK IS STARTED IN THE RIGHT-OF-WAY, THE CONTRACTOR SHALL INSTALL ALL ADVANCE WARNING SIGNS FOR THE CONSTRUCTION ZONE. THE CONTRACTOR SHALL INSTALL TEMPORARY STOP SIGNS AT ALL NEW STREET ENCROACHMENTS INTO EXISTING CITY STREETS WHERE WARRANTED IMMEDIATELY AFTER FIRST GRADING WORK IS ACCOMPLISHED, AND SHALL MAINTAIN SAID SIGNS UNTIL PERMANENT SIGNS ARE INSTALLED.
4. WHEN A DESIGNATED "SUGGESTED ROUTE TO SCHOOL" IS ENCROACHED UPON BY A CONSTRUCTION WORK ZONE AND PUBLIC WORKS STAFF IDENTIFIES A NEED FOR STUDENTS TO BE ASSISTED IN THE SAFE CROSSING THROUGH THE CONSTRUCTION ZONE, THE CONTRACTOR SHALL BE REQUIRED TO PROVIDE A QUALIFIED "CROSSING GUARD". THE GUARD SHALL BE PRESENT FOR THE FULL DURATION OF TIME THAT CHILDREN ARE LIKELY TO BE PRESENT.
5. IF THE IMPROVEMENTS NECESSITATE THE OBLITERATION, TEMPORARY OBSTRUCTION, TEMPORARY REMOVAL OR RELOCATION OF ANY EXISTING TRAFFIC PAVEMENT MARKING, SUCH PAVEMENT MARKING SHALL BE RESTORED OR REPLACED WITH LIKE MATERIALS TO THE SATISFACTION OF THE CITY TRAFFIC ENGINEER.
6. THE CONTRACTOR SHALL BE RESPONSIBLE FOR PROVIDING AND INSTALLING ALL PERMANENT SIGNS SHOWN ON THE PLANS. ALL NEW TRAFFIC SIGNS SHALL BE FABRICATED WITH DIAMOND GRADE VPI CLASS 6 REFLECTIVE SHEETING OR APPROVED EQUAL. ALL NEW TRAFFIC SIGNS, EXCEPT STREET NAME AND SCHOOL ZONE SIGNS, SHALL HAVE 3M SERIES 1160 OR APPROVED EQUIVALENT ANTI-GRAFFITI PROTECTIVE OVERLAY FILM. SCHOOL ZONE SIGNS SHALL HAVE 3M SERIES 1150 ANTI-GRAFFITI PROTECTIVE OVERLAY FILM. STREET NAME SIGNS SHALL CONFORM IN THEIR ENTIRETY TO CURRENT CITY STANDARDS. ALL OTHER SIGNS SHALL BE STANDARD SIZE UNLESS OTHERWISE SPECIFIED ON THE PLANS. ALL SIGN POSTS SHALL BE INSTALLED IN ACCORDANCE WITH THE CURRENT CITY STANDARDS.
7. WHEN A PROPOSED STREET LIGHT STANDARD IS LOCATED WITHIN FIVE (5') FEET OF ANY PROPOSED SIGN SHOWN ON THE PLANS TO BE MOUNTED ON A SIGNPOST, THE SIGN SHALL BE MOUNTED ON THE STREET LIGHT STANDARD AND THE SIGNPOST SHALL BE ELIMINATED.
8. ALL PERMANENT TRAFFIC CONTROL DEVICES CALLED FOR HEREON SHALL BE IN PLACE AND IN FINAL POSITION PRIOR TO ALLOWING ANY PUBLIC TRAFFIC ONTO THE PORTIONS OF THE ROAD(S) BEING IMPROVED. HERE UNDER, REGARDLESS OF THE STATUS OF COMPLETION OF PAVING OR OTHER OFF-SITE IMPROVEMENTS CALLED FOR BY THESE PLANS.
9. STREET SIGNS AND STOP SIGNS SHALL BE INSTALLED PER CITY STANDARD SPECIFICATIONS FOR PLACEMENT OF STREET NAME SIGNS.
10. THE CONTRACTOR SHALL PROVIDE ALL NECESSARY TRAFFIC CONTROL DEVICES AND FLAGGERS TO INSURE THE SAFETY OF THE PUBLIC IN OR AROUND THE WORK AREA. THE CONTRACTOR SHALL HAVE A CERTIFIED ATSSA TRAFFIC CONTROL TECHNICIAN OR IMSA WORK ZONE SAFETY SPECIALIST SET UP, MAINTAIN AND/OR REMOVE ALL TRAFFIC CONTROL DEVICES IN THE CITY OF LAS VEGAS RIGHT OF WAY.
11. WORK IN PUBLIC STREETS, ONCE BEGUN, SHALL BE EXPEDITED TO COMPLETION SO AS TO PROVIDE MINIMUM INCONVENIENCE TO ADJACENT PROPERTY OWNERS AND TO THE TRAVELING PUBLIC.
12. THE CONTRACTOR SHALL BE RESPONSIBLE FOR NOTIFYING CITIZENS AREA TRANSIT (C.A.T.) IF THE CONSTRUCTION INTERRUPTS OR RELOCATES A BUS STOP OR HAS AN ADVERSE EFFECT ON BUS SERVICE ON THAT STREET TO ARRANGE FOR TEMPORARY RELOCATION OF STOP.
13. GUARDS SHALL BE OBTAINED BY CONTACTING THE METROPOLITAN POLICE DEPARTMENT SPECIAL EVENTS UNIT (PHONE # 828-3442) WHO WILL PROVIDE OFFICERS PROPERLY TRAINED IN TRAFFIC CONTROL. FEES FOR THE USE OF THESE OFFICERS SHALL BE SET BY METRO AND WILL BE PAID BY THE CONTRACTOR. THE CONTRACTOR IS RESPONSIBLE FOR ALL ARRANGEMENTS WITH METRO.
14. ANY WORK WITHIN 300' OF A SIGNALIZED INTERSECTION WILL BE NIGHT WORK, UNLESS DIRECTED BY THE CITY OF LAS VEGAS TRAFFIC ENGINEER.
15. THE CONTRACTOR SHALL CONTACT THE TRAFFIC ENGINEERING DIVISION (TRANSPORTATION SECTION) THROUGH THE PROJECTS OFFSITE INSPECTOR PRIOR TO INITIATING PAVING TO RECEIVE DIRECTION FOR ANY PERMANENT OR TEMPORARY MODIFICATIONS TO THE APPROVED DRAWINGS REGARDING FINAL PAVEMENT TREATMENT, MARKING AND SIGNING. THEY ARE REQUIRED TO MATCH ADJACENT ROADWAY SEGMENTS. THE CONTRACTOR SHALL PROVIDE A DRAWING FOR APPROVAL BY THE TRAFFIC ENGINEERING DIVISION DEPICTING ANY ADJUSTMENTS TO THE FINAL PAVEMENT MARKINGS AND SIGNAGE, WHICH MAY INCLUDE OMITTING, ADDING OR MODIFYING TRAFFIC MARKINGS AND TRAFFIC CONTROL SIGNS SUCH THAT ADEQUATE TRANSITIONS AND LANE TERMINATIONS BETWEEN ADJACENT ROADWAY SEGMENTS ARE CONSTRUCTED.

REVISÉ 05/05/08

[illegible]

NINETY-FIVE MANAGEMENT LLC

SKYE CANYON PHASE 2

GENERAL NOTES

DATE: 11/19/15


DRAFTER: JAS

DESIGNER: DAM

CHECKED: JSR


PROJECT NO.

OLY1501-001

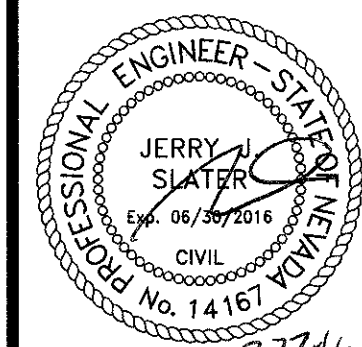

G-02

SHEET 2 OF 33

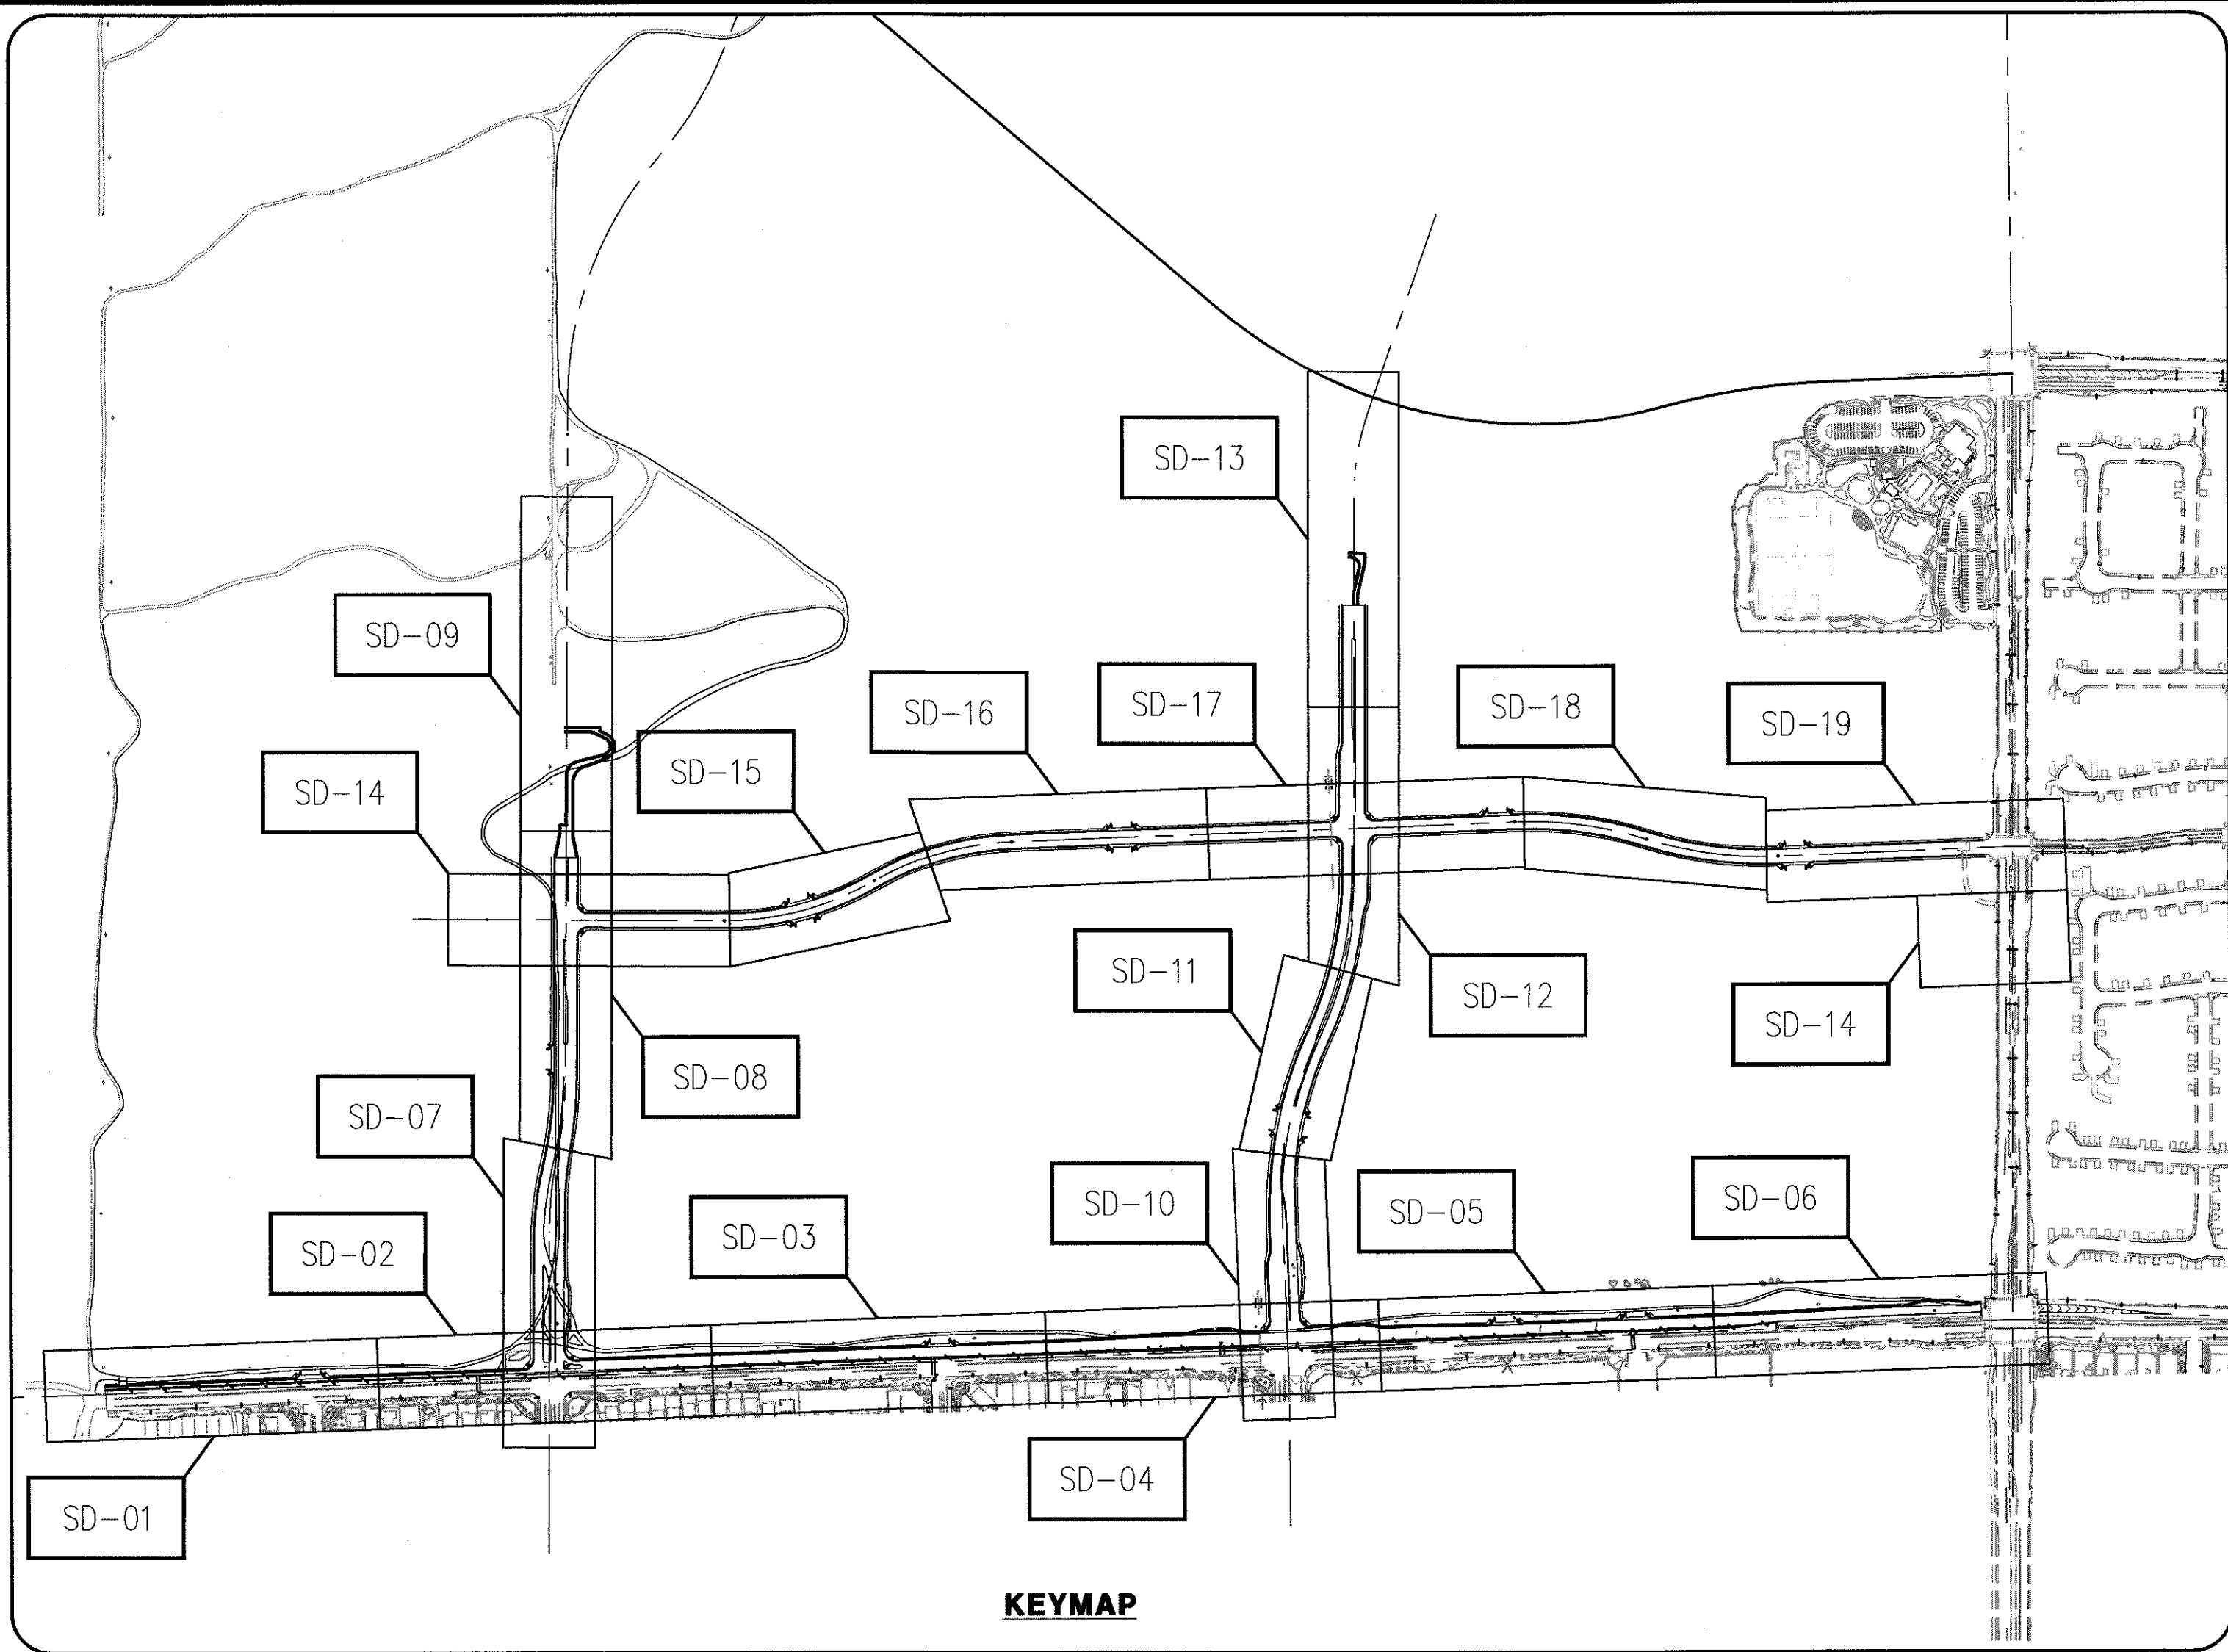

LEGEND

	EXISTING CURB & GUTTER
	EXISTING RIGHT-OF-WAY LINE
	EXISTING PROPERTY LINE
	EXISTING CHAIN-LINK FENCE
	EXISTING MANHOLE OR VAULT
	EXISTING CONTOUR LINE
	EXISTING ELEVATION
	STREET CENTERLINE
	EASEMENT LINE
	FLOWLINE
	SAWCUT LINE
	CONTOUR LINE
	ELEVATION

QUANTITIES

DESCRIPTION	UNIT	TOTAL QUANTITY
DROP INLET 5' TYPE CM	EA	3
DROP INLET 5' TYPE CM2	EA	16
DROP INLET 7.5' TYPE CM2	EA	4
DROP INLET 12.5' TYPE CM2	EA	1
DROP INLET 15' TYPE CM2	EA	6
DROP INLET 17.5' TYPE CM2	EA	2
DROP INLET 20' TYPE CM2	EA	4
STORM DRAIN MANHOLE - 60" TYPE III	EA	22
STORM DRAIN MANHOLE - 60" TYPE III WITH TYPE 1A RISER	EA	10
STORM DRAIN MANHOLE - NDOT TYPE 4	EA	1
18" RCP	LF	800
24" RCP	LF	100
30" RCP	LF	125
36" RCP	LF	1,680
42" RCP	LF	600
48" RCP	LF	1,670
54" RCP	LF	300
66" RCP	LF	100
18" RCP END SECTION	EA	1
24" RCP END SECTION	EA	1
30" RCP END SECTION	EA	2
36" RCP END SECTION	EA	6
42" RCP END SECTION	EA	2
48" RCP END SECTION	EA	2
RIPRAP	SY	1040

ABBREVIATIONS

ABUT	ABUTMENT	GND	GROUND	R/W	RIGHT-OF-WAY
AC	ALUMINUM CAP/ASPHALTIC CONCRETE	H	HEIGHT	RT	RIGHT
AEP	AUTHORIZATION TO ENTER PROPERTY	HGL	HYDRAULIC GRADE LINE	S	SOUTH
AP	ANGLE POINT	HORIZ	HORIZONTAL	SCH	SCHEDULE
APN	ASSESSORS PARCEL NUMBER	HWY	HIGHWAY	SD	STORM DRAIN
AVE	AVENUE	INV	INVERT	SOMH	STORM DRAIN MANHOLE
BC	BEGIN CURVE/BRASS CAP/BACK OF CURB	ITS	INTELLIGENT TRANSPORTATION SYSTEM	SECT	SECTION
BCR	BEGIN CURB RETURN	JT	JOINT	SF	SQUARE FOOT/FEET
BLVD	BOULEVARD	LF	LINEAR (LINEAL) FEET	SHLDR	SHOULDER
BM	BENCHMARK	LIP	LIP OF GUTTER	SHT	SHEET
BOT	BOTTOM	LT	LEFT	SIM	SIMILAR
BRG	BEARING	LUM	LUMINAIRE	SP	SERVICE POINT
BSW	BACK OF SIDEWALK	LVWD	LAS VEGAS VALLEY WATER DISTRICT	SPA	SPACING
BVCE	BEGIN VERTICAL CURVE ELEVATION	MAX	MAXIMUM	SQ	SQUARE
BVCS	BEGIN VERTICAL CURVE STATION	MH	MANHOLE	SS	SANITARY SEWER
CATV	UNDERGROUND CABLE TV	MIN	MINIMUM	SSMH	SANITARY SEWER MANHOLE
CG	CURB AND GUTTER	MLCP	MULTI-LAYERED COMPOSITE PIPE	STA	STATION
CCSD	DESIGN AND CONSTRUCTION STANDARDS FOR WASTEWATER COLLECTION SYSTEMS	MOD	MODIFY/MODIFIED	STD	STANDARD
CKT	CIRCUIT	MON	MONUMENT	ST	STREET
CLR	CLEAR/CLEARANCE	MPH	MILES PER HOUR	STL	STEEL
CLB	CITY OF LAS VEGAS BENCHMARK	N	NORTH	SL	STREET LIGHT
CLV	CITY OF LAS VEGAS	NDOT	NEVADA DEPARTMENT OF TRANSPORTATION	STRUCT	STRUCTURE
CMU	CONCRETE MASONRY UNIT	NO	NUMBER	SW	SIDEWALK
CONC	CONCRETE	NVE	NV ENERGY	SNBORS	SOUTHERN NEVADA BUILDING OFFICIALS
C/C/L	CENTERLINE	NTS	NOT TO SCALE		REGIONAL STANDARDS
COB	CENTER OF BOLLARD	OC	ON CENTER	SWG	SOUTHWEST GAS
COL	COLUMN	OHP	OVERHEAD POWER LINE	T	TELEPHONE/TOP
CONSTR	CONSTRUCT/CONSTRUCTION	PAT	PATENT	TAN	TANGENT
COORD	COORDINATE	PB	PULL BOX	TC	TOP OF CURB
COR	CORNER	PBS	PLANTMIX BITUMINOUS SURFACE	TEMP	TEMPORARY
CY	CUBIC YARD(S)	PC	POINT OF CURVE, PHOTO CELL	TF	TOP OF FOOTING
Δ	DELTA	PCC	POINT OF COMPOUND CURVE	TG	TOP OF GRATE
DB	DIRECT BURY	PD	PONDING DEPTH	TMH	TOP OF MANHOLE
DBL	DOUBLE	PE	PROJECT ENGINEER/POLYETHYLENE	TRANS	TRANSITION STRUCTURE
DI	DROP INLET	PED	PEDESTRIAN	TRW	TOP OF RETAINING WALL
DIA	DIAMETER	PG	PROFILE GRADE (FG ON CONTROL LINE)	TW	TOP OF WALL
DIST	DISTANCE	PGL	PROFILE GRADE LINE	TS	TRAFFIC SIGNAL
DR	DRIVE	PH	POTHOLE	TYP	TYPICAL
DW	DRIVEWAY	PI	POINT OF INTERSECTION	UDACS	UNIFORM DESIGN AND CONSTRUCTION STANDARDS FOR WATER DISTRIBUTION SYSTEMS
DWG	DRAWING	PKWY	PARKWAY	USDCCA	UNIFORM STD. DRAWINGS FOR PUBLIC WORKS' CONSTRUCTION OFF-SITE IMPROVEMENTS CLARK COUNTY AREA, NEVADA
ECR	END CURB RETURN	PL	PROPERTY LINE		UNDERGROUND TELEPHONE
E	EACH	PMF	PAVEMENT MARKING FILM	UT	VARIABLE/VARIES
EA	EASEMENT	POB	POINT OF BEGINNING	VAR	VERTICAL
ESMT	END CURB RETURN	POC	POINT ON CURVE	VC	VERTICAL
ELEC	ELECTRICAL	POE	POINT OF ENDING	VERT	VALLEY GUTTER
ELEV/EL	ELEVATION	POT	POINT ON TANGENT	W	WEST
EP/EOP	EDGE OF PAVEMENT	PP	POWER POLE	WY	WAY
EQ	EQUAL	PPCB	PORTABLE PRECAST CONCRETE BARRIER RAIL	WT	WEIGHT
EST	ESTIMATED	PPM	POLYUREA PAVEMENT MARKINGS	XING	CROSSING
EVC	END VERTICAL CURVE	PR	PROPOSED		
EX/EXIST	EXISTING	PRC	POINT OF REVERSE CURVE		
EXP	EXPANSION JOINT	PRVC	POINT REVERSE VERTICAL CURVE		
EW	EACH WAY	PSI	POUNDS PER SQUARE INCH		
FC	FACE OF CURB	PT	POINT OF TANGENCY		
FG	FINISH GRADE	PVI	POINT OF VERTICAL INTERSECTION		
FH	FIRE HYDRANT	PVMT	PAVEMENT		
FL	FLOW LINE	R	RADIUS		
FO	FIBER OPTIC	RCB	REINFORCED CONCRETE BOX		
FS	FINISH SURFACE	RCP	REINFORCED CONCRETE PIPE		
FT	FOOT/FEET	RD	ROAD		
FTG	FOOTING	RDWY	ROADWAY		
FW	FACE OF WALL	REC	RECTANGULAR		
FYA	FLASHING YELLOW ARROW	REINF	REINFORCED		
G	GAS	REQD	REQUIRED		
GA	GAUGE	RND	ROUND		
GB	GRADE BREAK	RP	RADIUS POINT		
		RPM	RAISED PAVEMENT MARKERS		

ALIGNMENT ABBREVIATIONS

"ECA"	EAGLE CANYON AVENUE (SHAUMBER ROAD TO SKYE VILLAGE ROAD)
"SR"	SHAUMBER ROAD (GRAND TETON DRIVE TO EAGLE CANYON AVENUE)
"GTD"	GRAND TETON DRIVE (PULI ROAD TO SKYE VILLAGE ROAD)
"ECD"	EGAN CREST DRIVE (GRAND TETON DRIVE TO EAGLE CANYON AVENUE)
"SVR"	SKYE VILLAGE ROAD (GRAND TETON DRIVE TO EAGLE CANYON AVENUE)


SLATER HANIFAN GROUP
CONSULTING ENGINEERS & PLANNERS
5740 S. ARVILLE STREET #216, LAS VEGAS, NV 89116
PHONE (702) 284-5300 FAX (702) 284-5389

NINETY-FIVE MANAGEMENT LLC
SKYE CANYON PHASE 2
ABBREVIATIONS, KEYMAP, LEGEND AND QUANTITIES

DATE: 11/19/15
DRAFTER: JAS
DESIGNER: DAM
CHECKED: JSR
PROJECT NO. OLY1501-001

G-03
SHEET 3 OF 33

JERRY SLATER
REGISTERED PROFESSIONAL ENGINEER - STATE OF NEVADA
NO. 14161
CIVIL
3.7.26

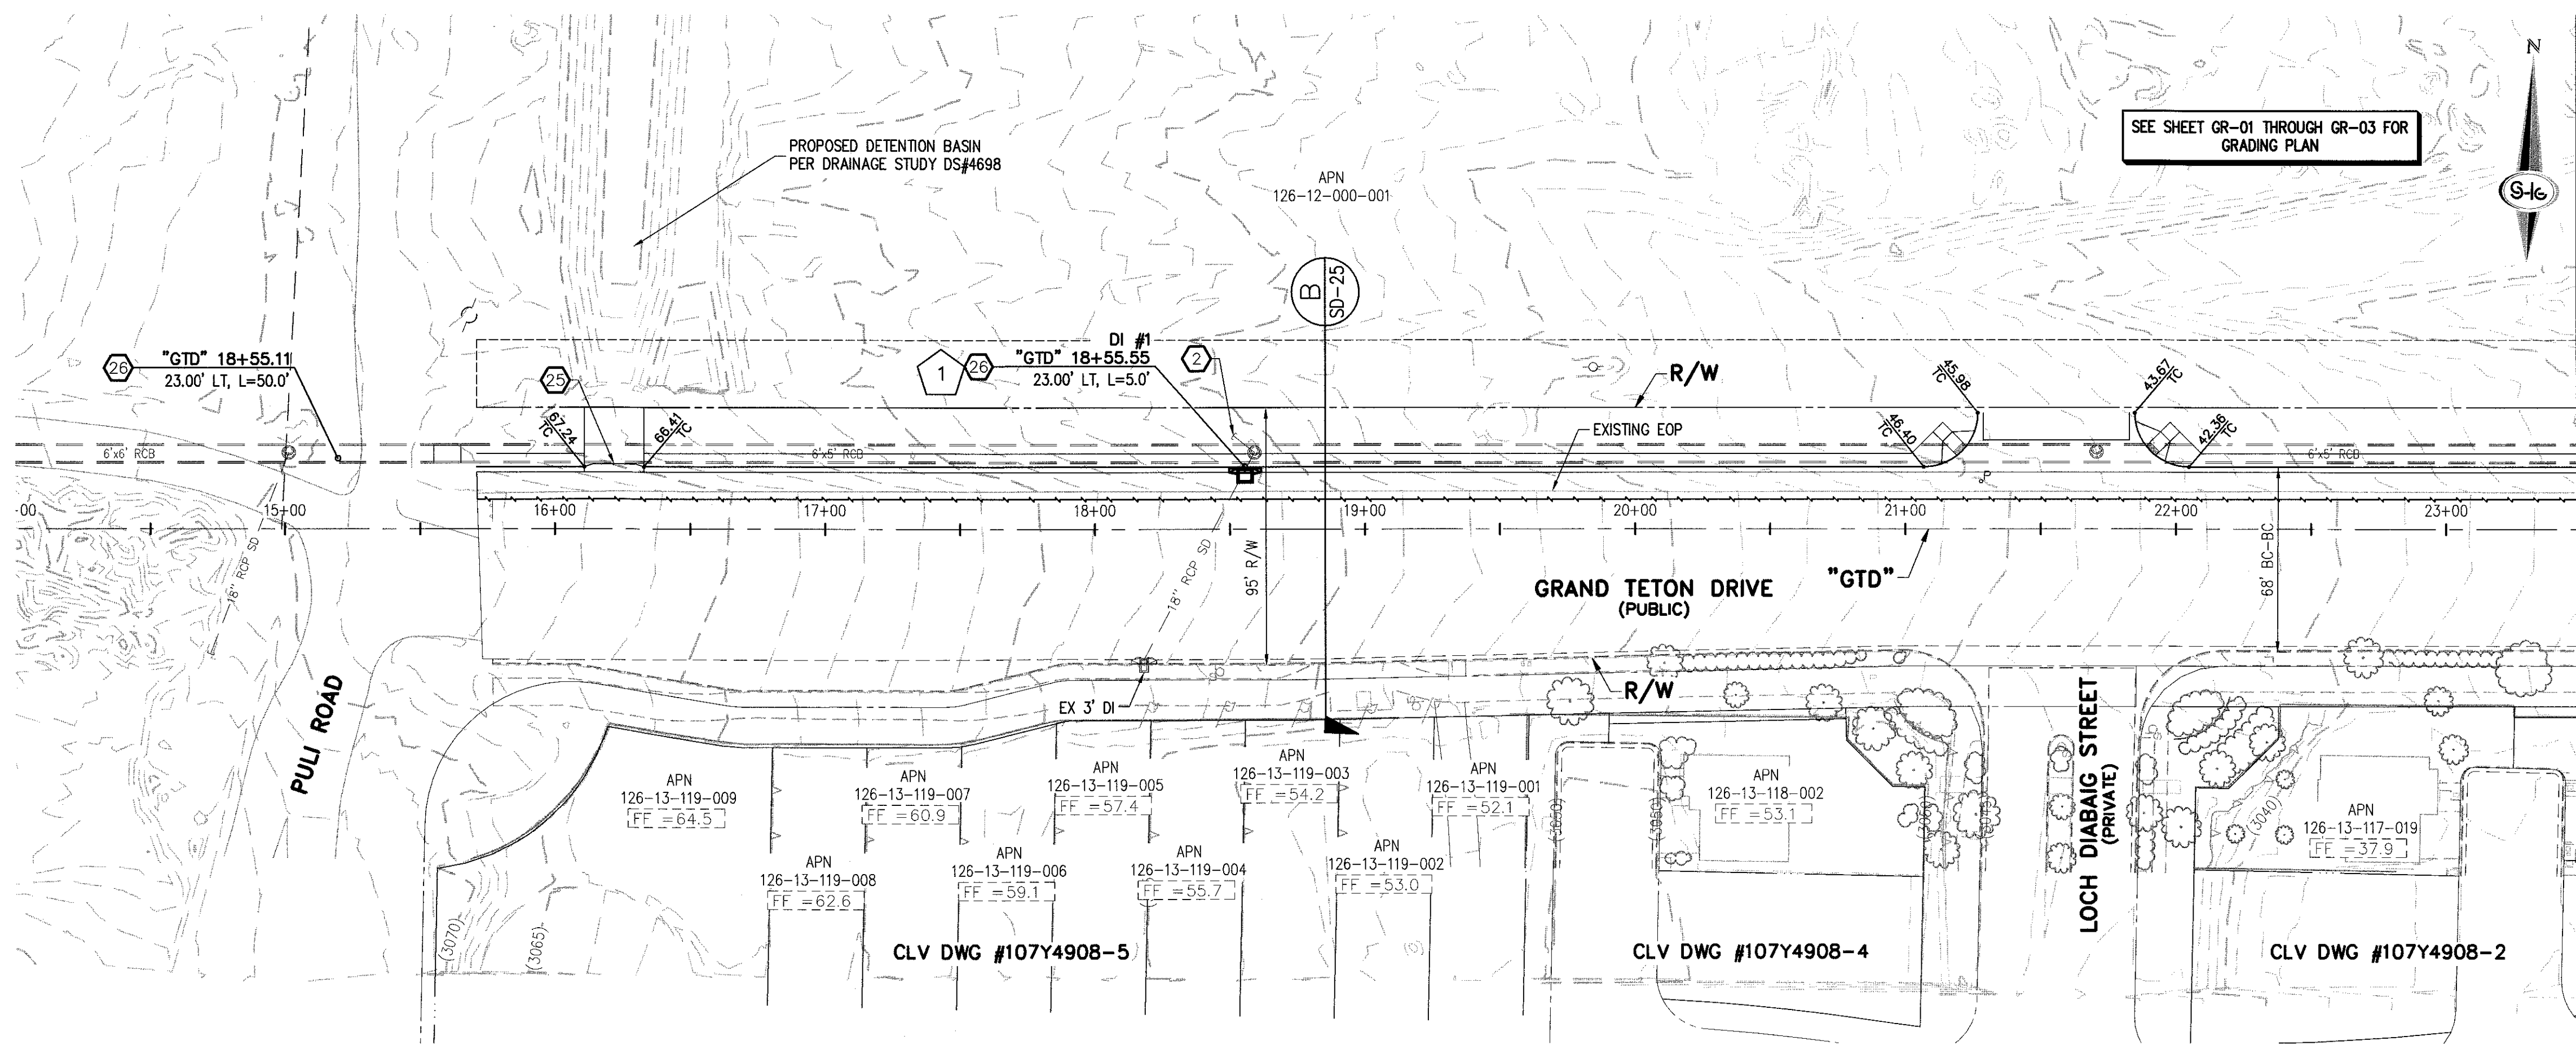

SEE SHEET SD-02
MATCHLINE
"GTD" 23+50.00

- ### STORM DRAIN NOTES
1. CONSTRUCT TYPE "CM2" DROP INLET (USDCCA STD. DWG. NO. 412.1)
 2. REMOVE EXISTING LATERAL STUB AND CONSTRUCT RCB PLUG (SEE DETAIL 5, DRAWING SD-26)
 3. CONSTRUCT 60" TYPE I MANHOLE (USDCCA STD. DWG. NO. 403.1)
 4. CONSTRUCT 60" TYPE III MANHOLE (USDCCA STD. DWG. NO. 406.1)
 5. CONSTRUCT 60" TYPE III MANHOLE WITH TYPE IA RISER (USDCCA STD. DWG. NO. 404.1 AND 406.1)
 6. CONSTRUCT NDOT TYPE 4 MANHOLE (NDOT STD. PLAN R-4.3.2)
 7. INSTALL 18" RCP (USDCCA STD. DWG. NO. 503.2)
 8. INSTALL 24" RCP (USDCCA STD. DWG. NO. 503.2)
 9. INSTALL 30" RCP (USDCCA STD. DWG. NO. 503.2)
 10. INSTALL 36" RCP (USDCCA STD. DWG. NO. 503.2)
 11. INSTALL 42" RCP (USDCCA STD. DWG. NO. 503.2)
 12. INSTALL 54" RCP (USDCCA STD. DWG. NO. 503.2)
 13. INSTALL 60" RCP (USDCCA STD. DWG. NO. 503.2)
 14. INSTALL 66" RCP (USDCCA STD. DWG. NO. 503.2)
 15. INSTALL 18" RCP END SECTION (NDOT STD. PLAN R-2.3.1)
 16. INSTALL 24" RCP END SECTION (NDOT STD. PLAN R-2.3.1)
 17. INSTALL 30" RCP END SECTION (NDOT STD. PLAN R-2.3.1)
 18. INSTALL 36" RCP END SECTION (NDOT STD. PLAN R-2.3.1)
 19. INSTALL 42" RCP END SECTION (NDOT STD. PLAN R-2.3.1)
 20. PIPE PENETRATION (SEE DETAIL 4, DRAWING SD-26)
 21. CONSTRUCT CONCRETE COLLAR (SEE DETAIL 2, DRAWING SD-26)
 22. CONSTRUCT BRICK AND MORTAR PLUG (SEE DETAIL 1, DRAWING SD-26)
 23. INSTALL 48" RCP (USDCCA STD. DWG. NO. 503.2)
 24. INSTALL 48" RCP END SECTION (NDOT STD. PLAN R-2.3.1)
 25. INSTALL DRIVEWAY (USDCCA STD. DWG. NO. 224)
 26. CONSTRUCT TYPE "CM" DROP INLET (USDCCA STD. DWG. NO. 422)

- ### NOTES
1. ALL RCP SHALL BE CLASS III UNLESS OTHERWISE SHOWN.
 2. ALL PIPE LENGTHS ARE MEASURED ALONG PIPE CENTERLINE TO CENTER OF MANHOLE OR INSIDE EDGE OF DI OR RCB/HCA.
 3. ALL DROP INLETS SHALL INCLUDE STORM WATER MANAGEMENT STAMP AND DETAIL PER USDCCA STD. DWG. NO. 421.
 4. SEE STRUCTURAL PLANS FOR ADDITIONAL STRUCTURAL DETAILS AND CONNECTIONS.
 5. ALL PIPES ARE PUBLICLY MAINTAINED.
 6. ADD SPECIAL INSPECTION REQUIRED FOR PIPE SEGMENTS WITH SACRIFICIAL CONCRETE.

DROP INLET NOTE

WHERE 10 FEET PARALLEL SEPARATION IS NOT PRACTICABLE:
CAST-IN-PLACE MONOLITHIC POUR WITH WATERSTOP BETWEEN SLAB AND WALLS. BASE, WALLS AND TOP TO BE CONSTRUCTED WITH WATERSTOPS, CENTER BUILT, OR FLAT STRIP (VINYLEX, GREENSTREAK PLASTIC PRODUCTS OR APPROVED EQUAL).

LEGEND



1 STORM DRAIN LATERAL # (SEE SHEETS SD-20 THRU SD-24)

FLOOD ZONE

THE PROJECT SITE IS LOCATED WITHIN A FEMA DESIGNATED ZONE "X" (OUTSIDE THE 500-YEAR FLOOD PLAIN) ON THE FLOOD INSURANCE RATE MAP (FIRM) PANEL: 32003C1750E, DATED SEPTEMBER 27, 2002

NOTE:

PROPERTY OWNER IS RESPONSIBLE TO MAINTAIN THE BEST MANAGEMENT PRACTICES, SUCH AS BUT NOT LIMITED TO, THE REMOVAL OF ACCUMULATED SEDIMENT AND DEBRIS AND CARE OF VEGETATION.

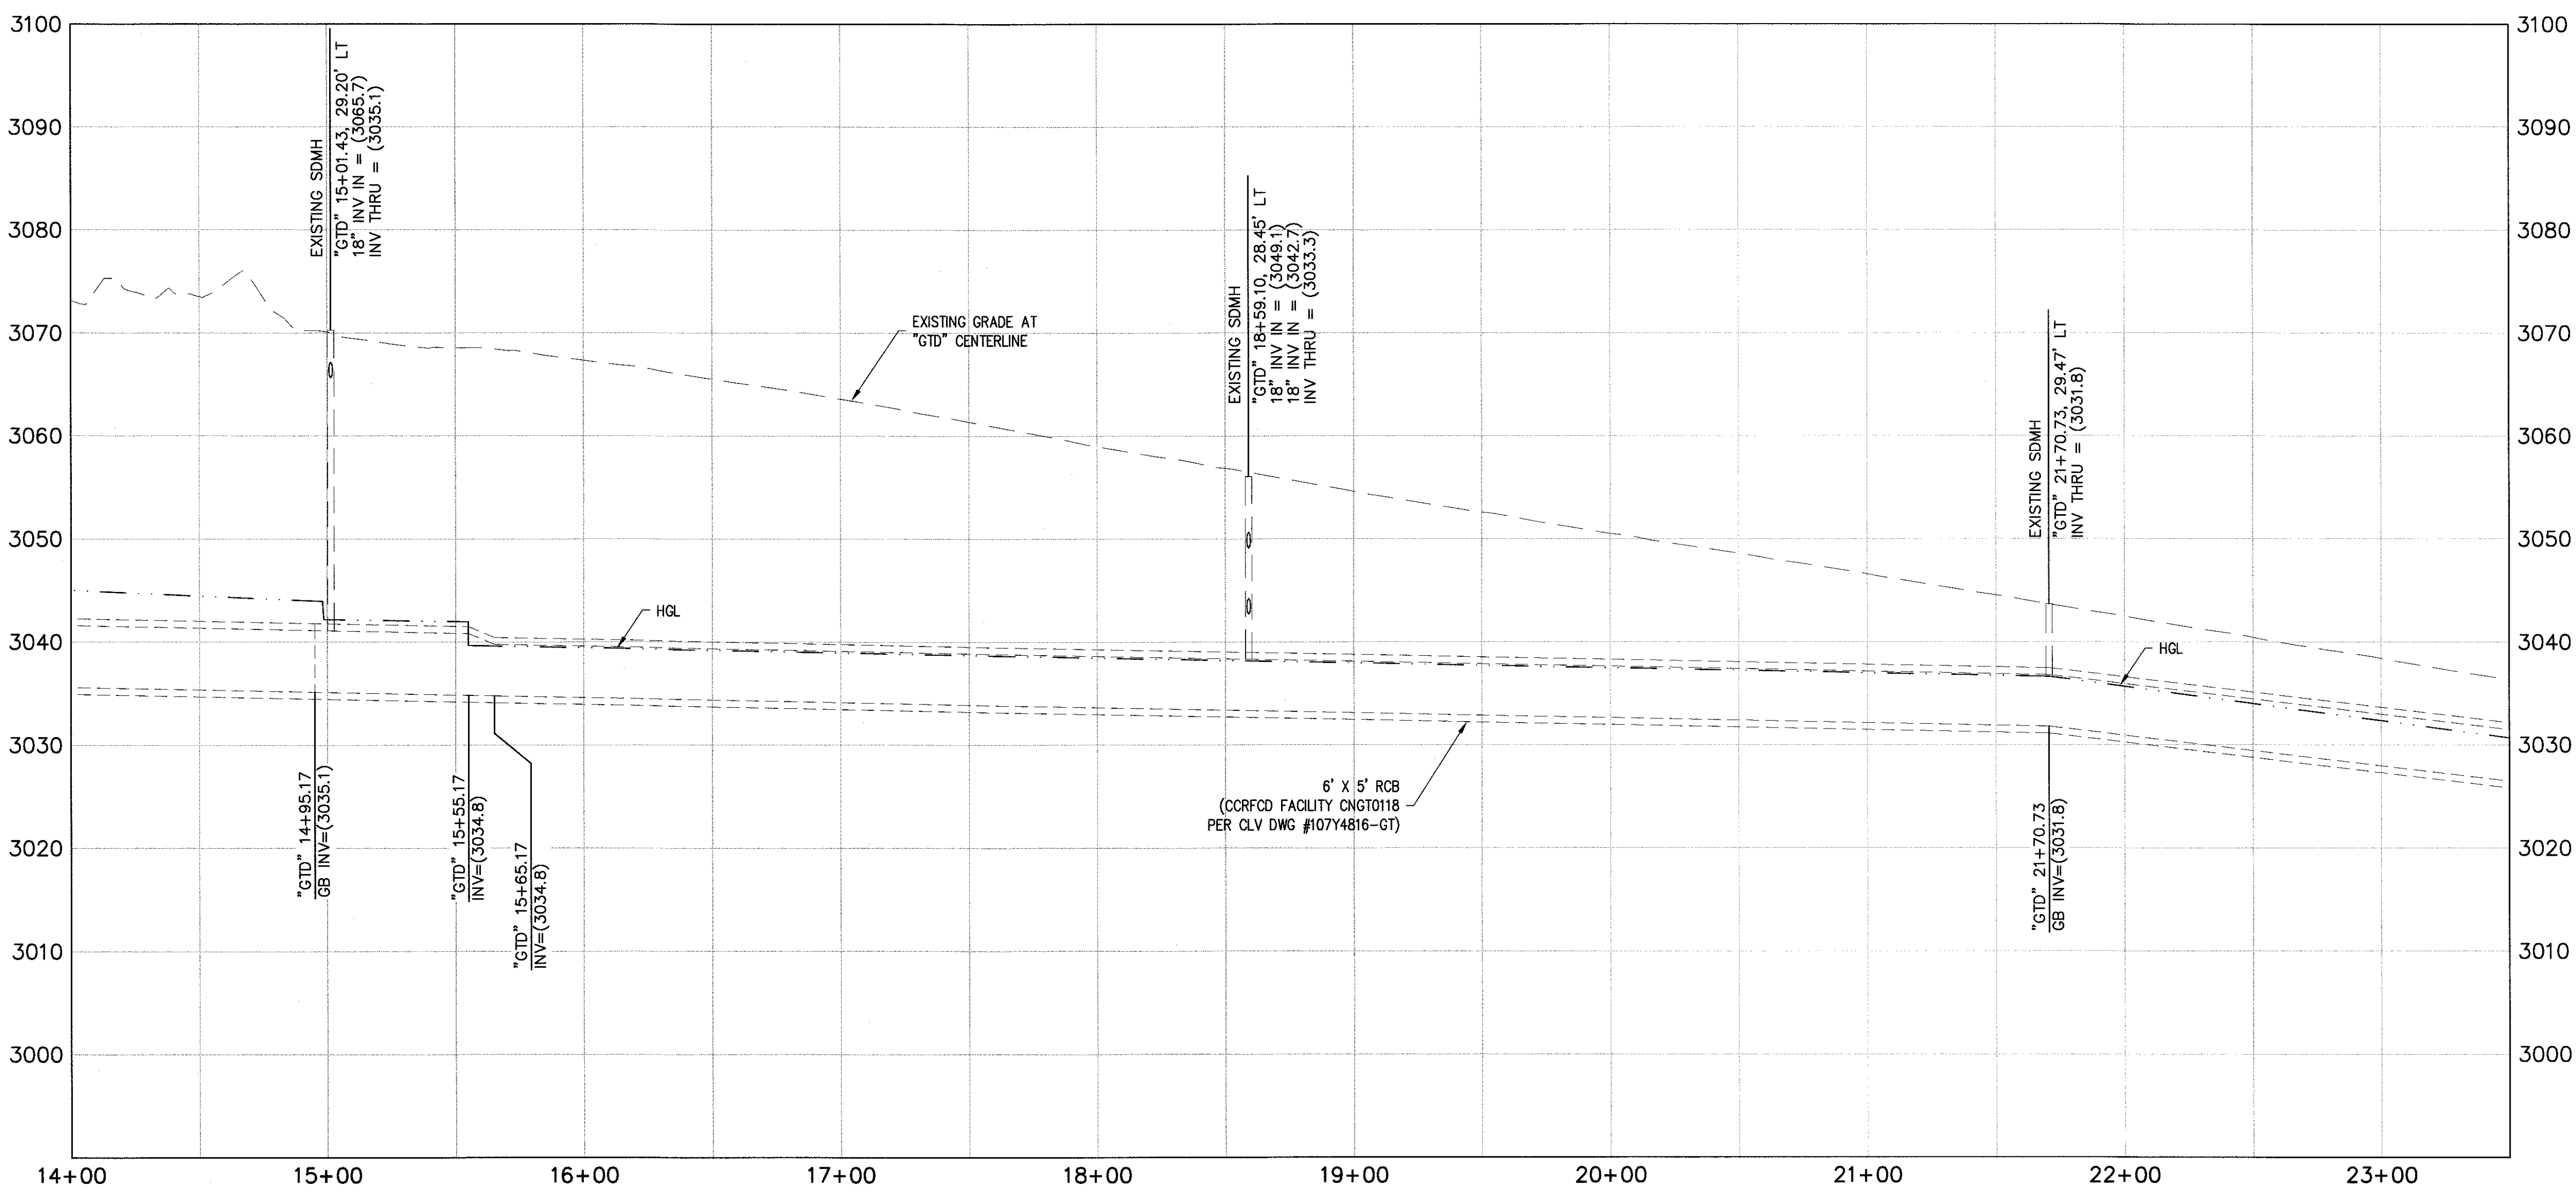
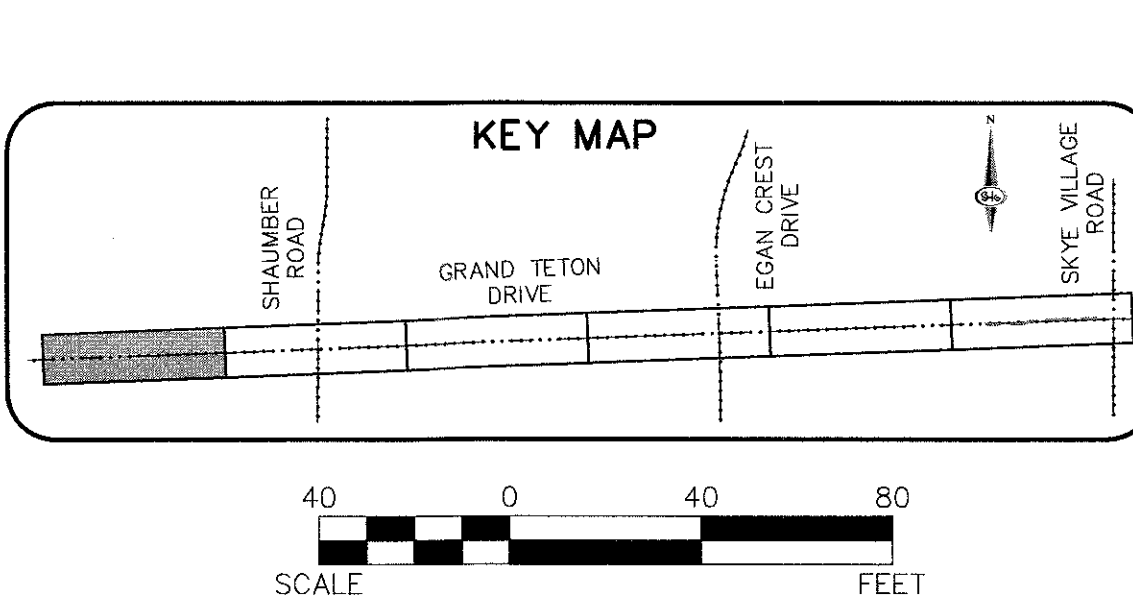


SLATER HANIFAN GROUP
CONSULTING ENGINEERS & PLANNERS
5740 S. ARVILLE STREET #216, LAS VEGAS, NV 89118
PHONE (702) 284-5300 FAX (702) 284-5399

NINETY-FIVE MANAGEMENT LLC
SKYE CANYON PHASE 2
GRAND TETON DRIVE STORM DRAIN PLAN AND PROFILE
"GTD" 14+00.00 TO "GTD" 23+50.00

DATE: 11/19/15
DRAFTER: JAS
DESIGNER: DAM
CHECKED: JSR
PROJECT NO.
OLY1501-001

SD-01
SHEET 4 OF 33

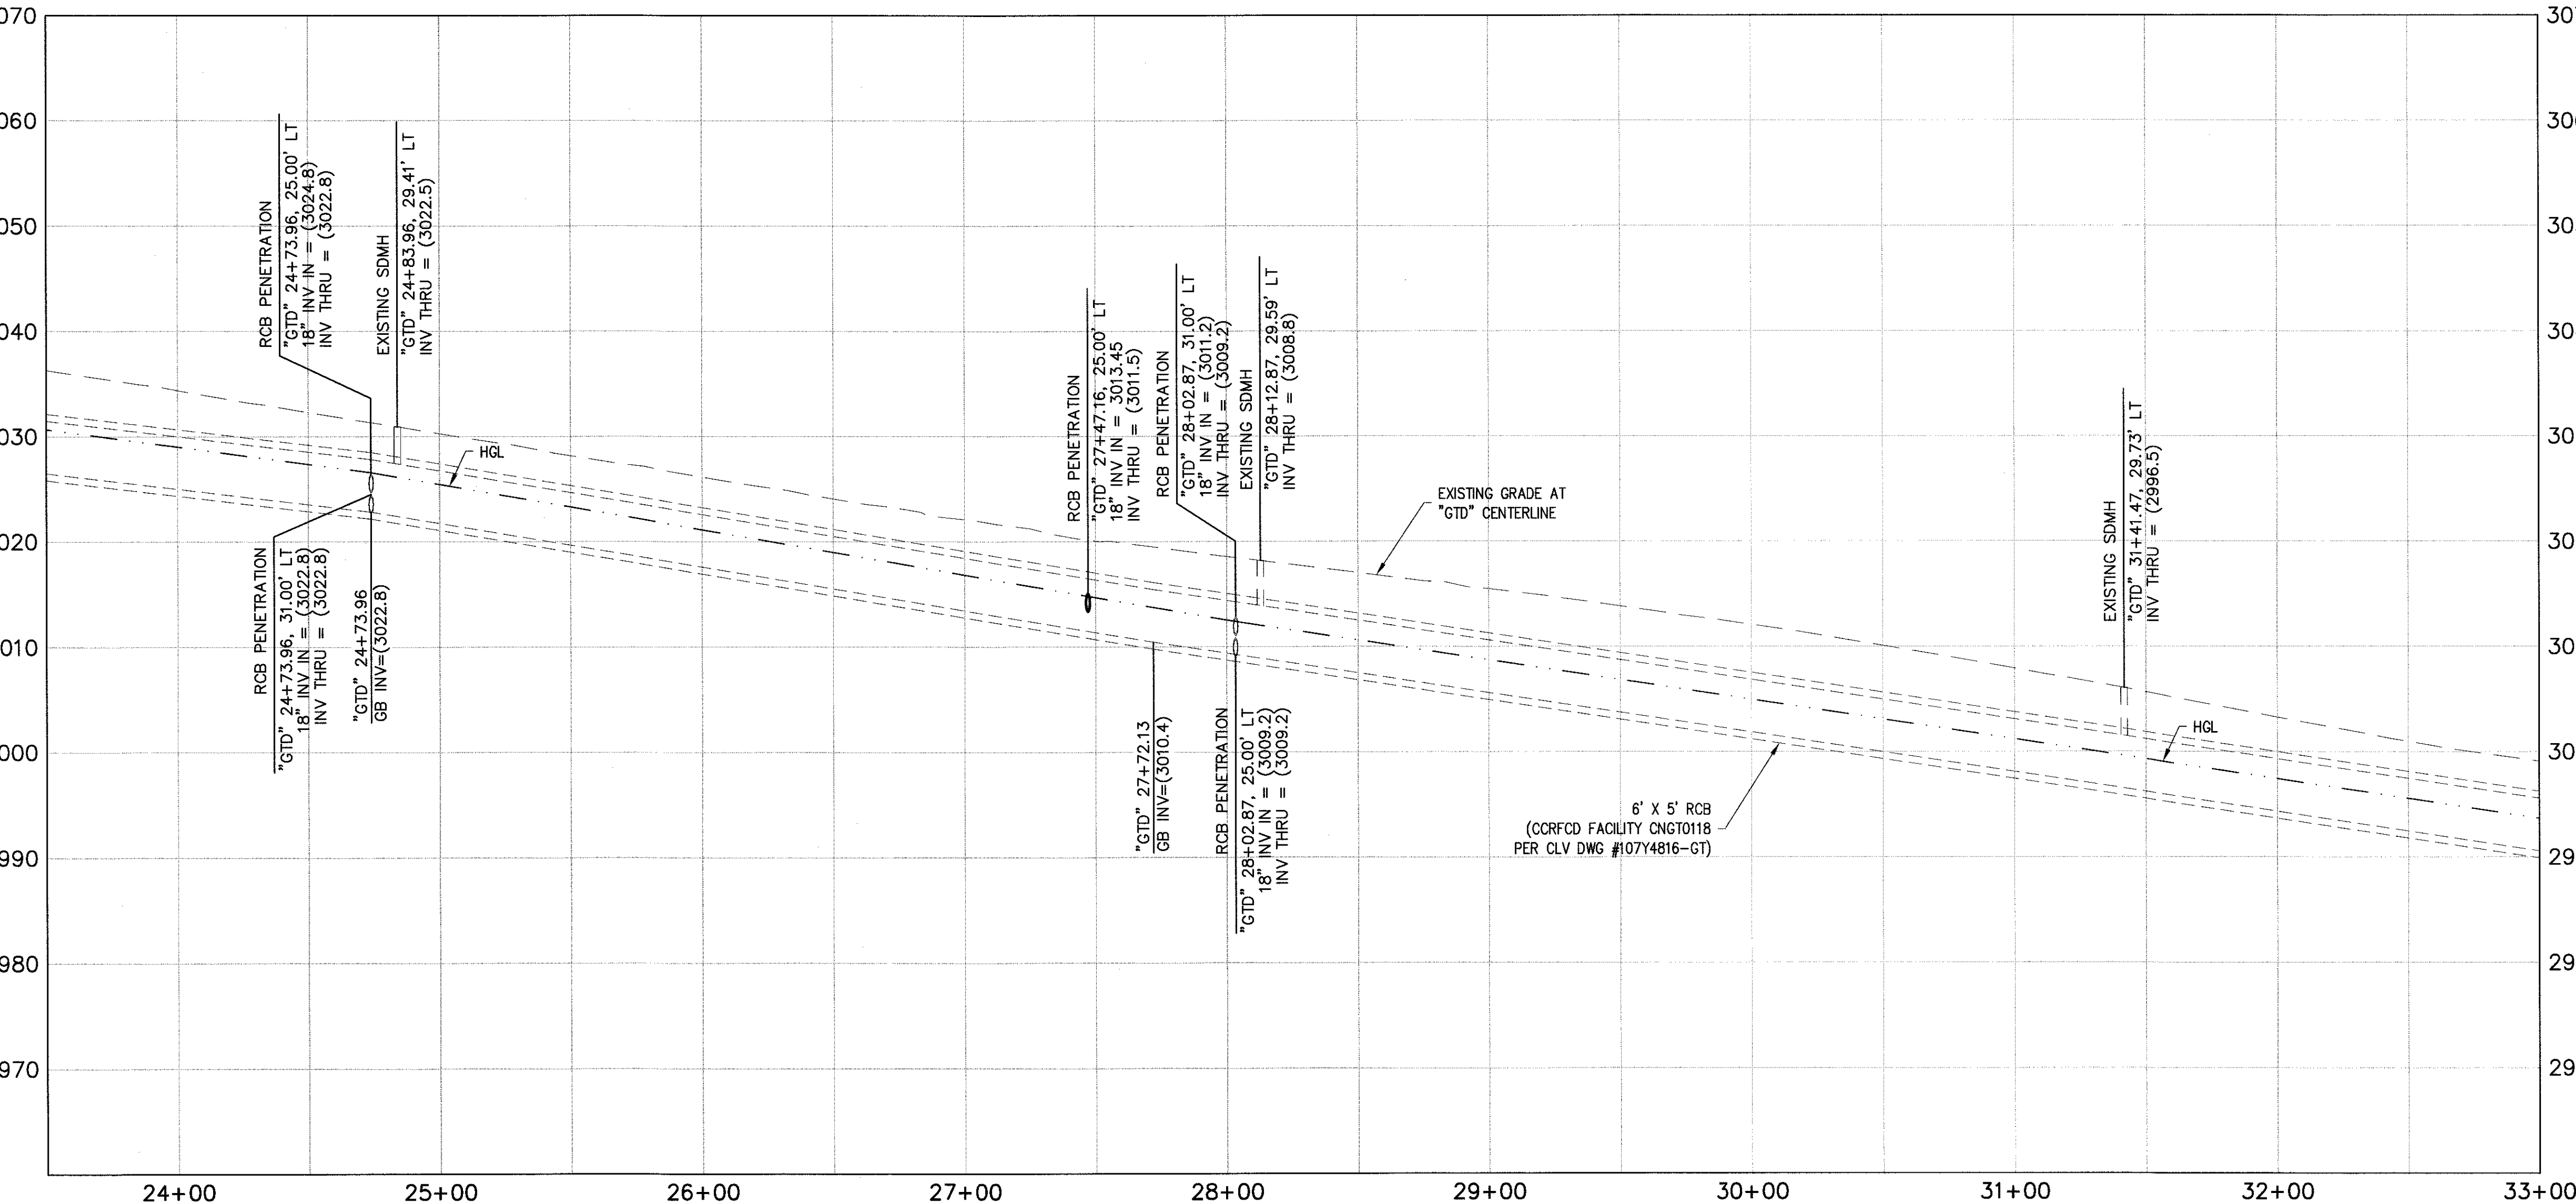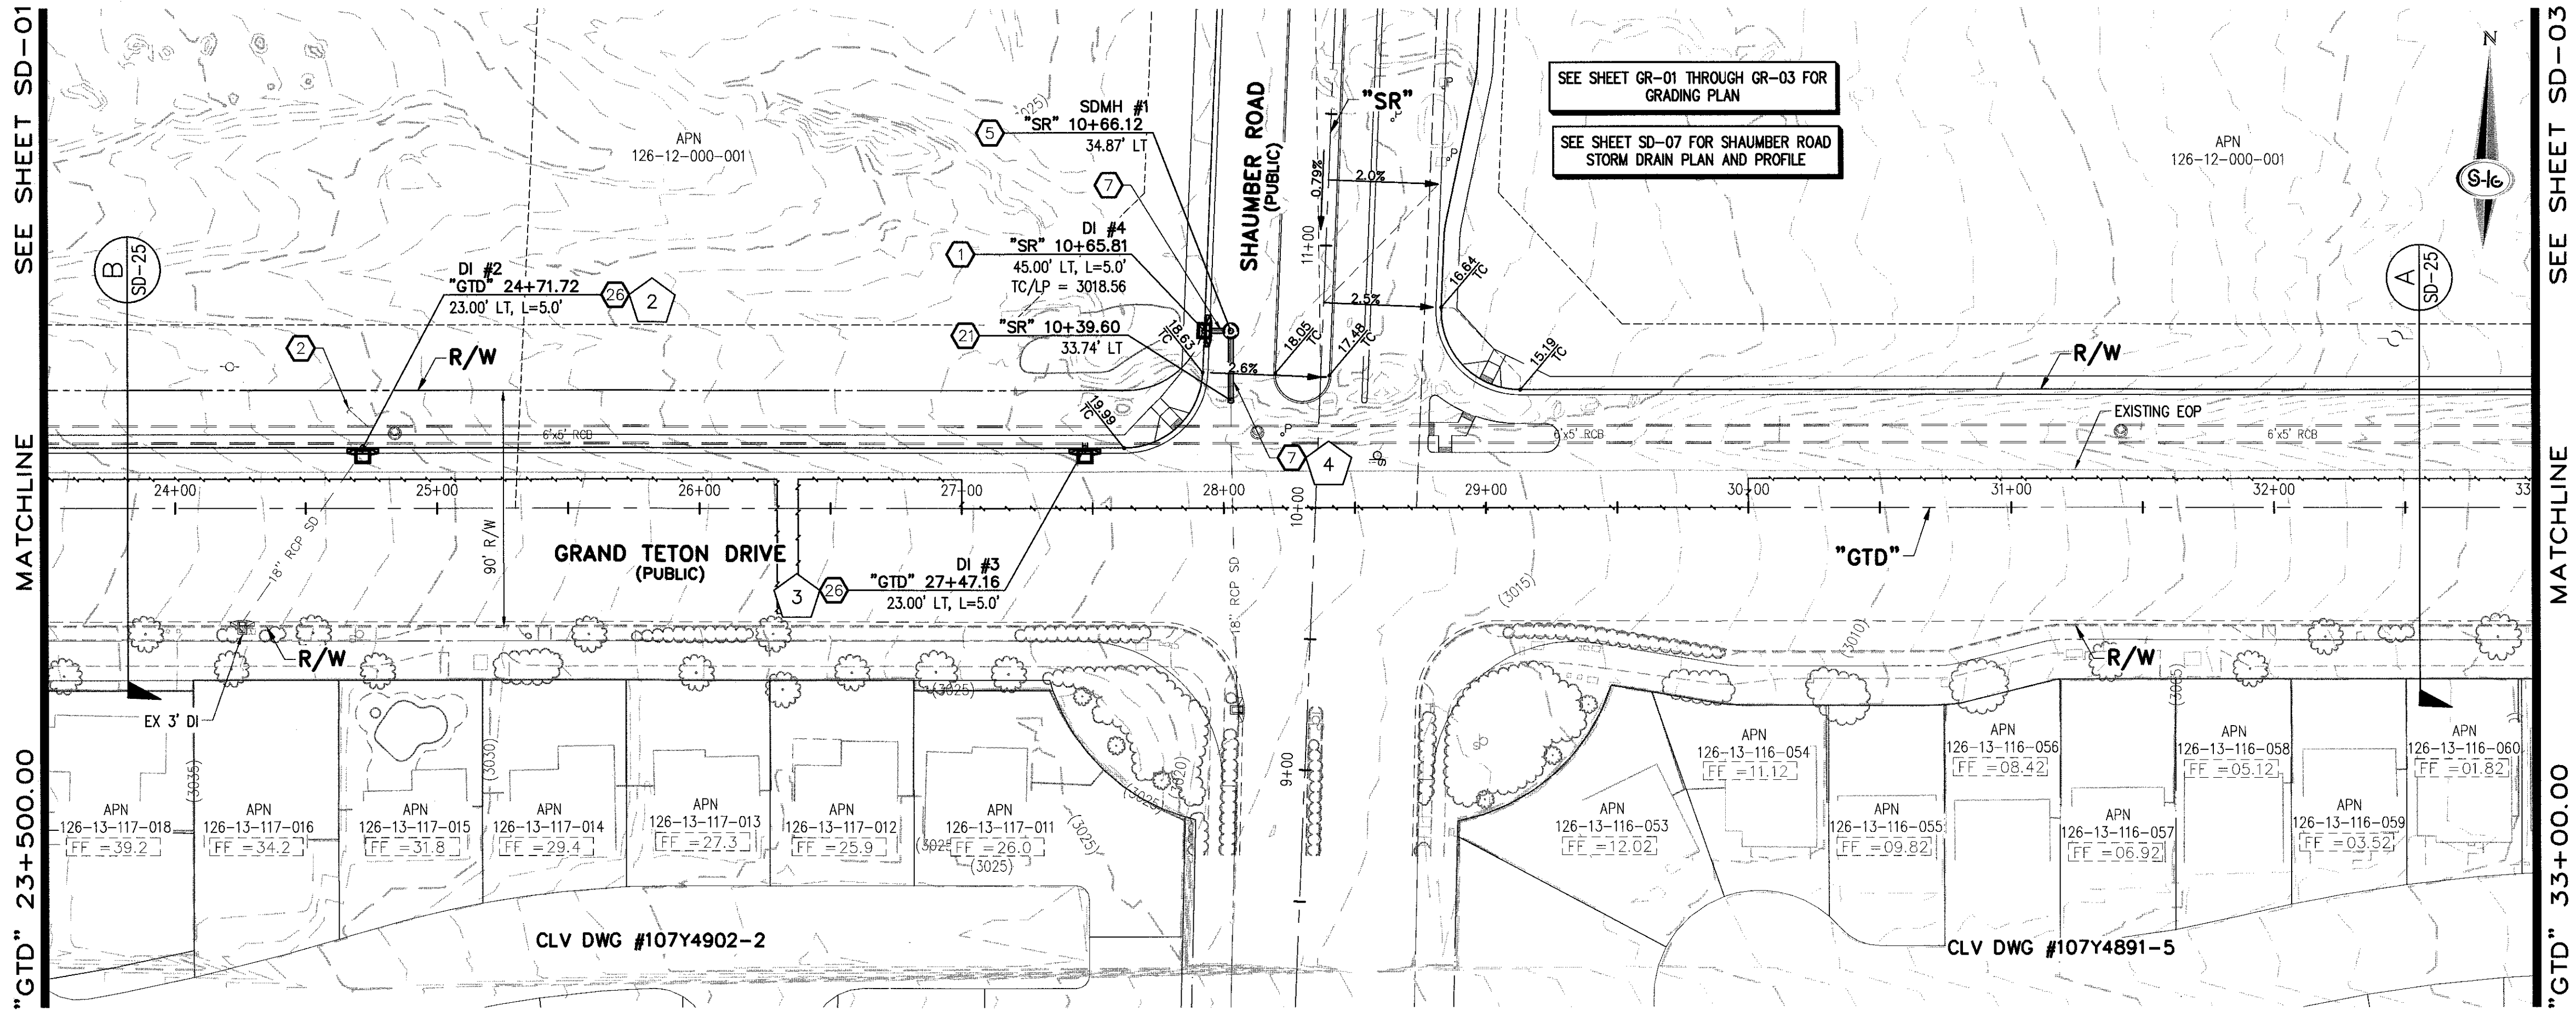

- ### STORM DRAIN NOTES
- CONSTRUCT TYPE "CM2" DROP INLET (USDCCA STD. DWG. NO. 412.1)
 - REMOVE EXISTING LATERAL STUB AND CONSTRUCT RCB PLUG (SEE DETAIL 5, DRAWING SD-26)
 - CONSTRUCT 60" TYPE I MANHOLE (USDCCA STD. DWG. NO. 403.1)
 - CONSTRUCT 60" TYPE III MANHOLE (USDCCA STD. DWG. NO. 406.1)
 - CONSTRUCT 60" TYPE III MANHOLE WITH TYPE IA RISER (USDCCA STD. DWG. NO. 404.1 AND 406.1)
 - CONSTRUCT NDOT TYPE 4 MANHOLE (NDOT STD. PLAN R-4.3.2)
 - INSTALL 18" RCP (USDCCA STD. DWG. NO. 503.2)
 - INSTALL 24" RCP (USDCCA STD. DWG. NO. 503.2)
 - INSTALL 30" RCP (USDCCA STD. DWG. NO. 503.2)
 - INSTALL 36" RCP (USDCCA STD. DWG. NO. 503.2)
 - INSTALL 42" RCP (USDCCA STD. DWG. NO. 503.2)
 - INSTALL 54" RCP (USDCCA STD. DWG. NO. 503.2)
 - INSTALL 60" RCP (USDCCA STD. DWG. NO. 503.2)
 - INSTALL 66" RCP (USDCCA STD. DWG. NO. 503.2)
 - INSTALL 18" RCP END SECTION (NDOT STD. PLAN R-2.3.1)
 - INSTALL 24" RCP END SECTION (NDOT STD. PLAN R-2.3.1)
 - INSTALL 30" RCP END SECTION (NDOT STD. PLAN R-2.3.1)
 - INSTALL 36" RCP END SECTION (NDOT STD. PLAN R-2.3.1)
 - INSTALL 42" RCP END SECTION (NDOT STD. PLAN R-2.3.1)
 - PIPE PENETRATION (SEE DETAIL 4, DRAWING SD-26)
 - CONSTRUCT CONCRETE COLLAR (SEE DETAIL 2, DRAWING SD-26)
 - CONSTRUCT BRICK AND MORTAR PLUG (SEE DETAIL 1, DRAWING SD-26)
 - INSTALL 48" RCP (USDCCA STD. DWG. NO. 503.2)
 - INSTALL 48" RCP END SECTION (NDOT STD. PLAN R-2.3.1)
 - INSTALL DRIVEWAY (USDCCA STD. DWG. NO. 224)
 - CONSTRUCT TYPE "CM" DROP INLET (USDCCA STD. DWG. NO. 422)

- ### NOTES
- ALL RCP SHALL BE CLASS III UNLESS OTHERWISE SHOWN.
 - ALL PIPE LENGTHS ARE MEASURED ALONG PIPE CENTERLINE TO CENTER OF MANHOLE OR INSIDE EDGE OF DI OR RCB/RCA.
 - ALL DROP INLETS SHALL INCLUDE STORM WATER MANAGEMENT STAMP AND DETAIL PER USDCCA STD. DWG. NO. 421.
 - SEE STRUCTURAL PLANS FOR ADDITIONAL STRUCTURAL DETAILS AND CONNECTIONS.
 - ALL PIPES ARE PUBLICLY MAINTAINED.
 - ADD SPECIAL INSPECTION REQUIRED FOR PIPE SEGMENTS WITH SACRIFICIAL CONCRETE.

DROP INLET NOTE

WHERE 10 FEET PARALLEL SEPARATION IS NOT PRACTICABLE, CAST-IN-PLACE MONOLITHIC POUR WITH WATERSTOP BETWEEN SLAB AND WALLS. BASE, WALLS AND TOP TO BE CONSTRUCTED WITH WATERSTOPS, CENTER BULB, OR FLAT STRIP (VINYLEX, GREENSTREAK PLASTIC PRODUCTS OR APPROVED EQUAL).

LEGEND

1 STORM DRAIN LATERAL # (SEE SHEETS SD-20 THRU SD-24)

FLOOD ZONE


I CERTIFY THAT THIS GRADING PLAN IS IN CONFORMANCE WITH THE APPROVED TECHNICAL DRAINAGE STUDY 05-4738A ON FILE AT THE CITY OF LAS VEGAS FOR THE SUBJECT PROJECT



JERRY SLATER, P.E. 14167 DATE 2-22-16

THE PROJECT SITE IS LOCATED WITHIN A FEMA DESIGNATED ZONE "X" (OUTSIDE THE 500-YEAR FLOOD PLAIN) ON THE FLOOD INSURANCE RATE MAP (FIRM) PANEL: 32003G1750E, DATED SEPTEMBER 27, 2002

NOTE:

PROPERTY OWNER IS RESPONSIBLE TO MAINTAIN THE BEST MANAGEMENT PRACTICES, SUCH AS BUT NOT LIMITED TO, THE REMOVAL OF ACCUMULATED SEDIMENT AND DEBRIS AND CARE OF VEGETATION.

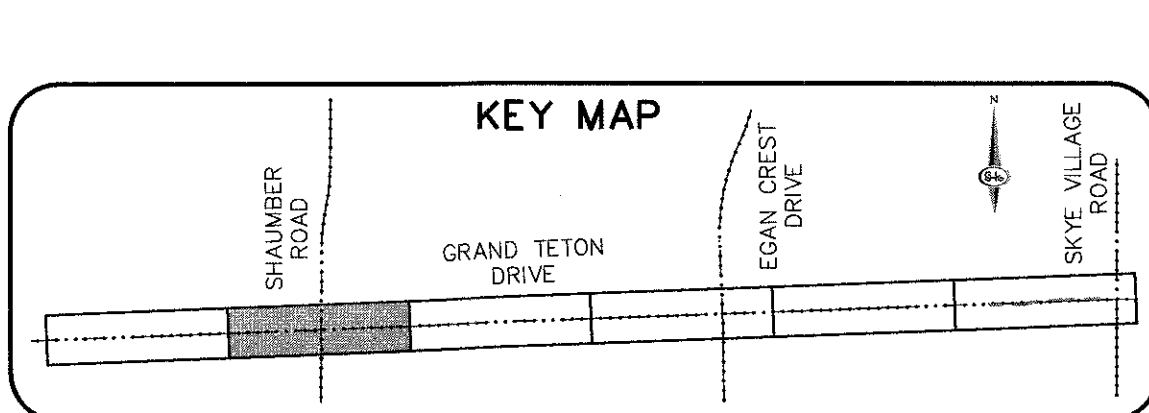

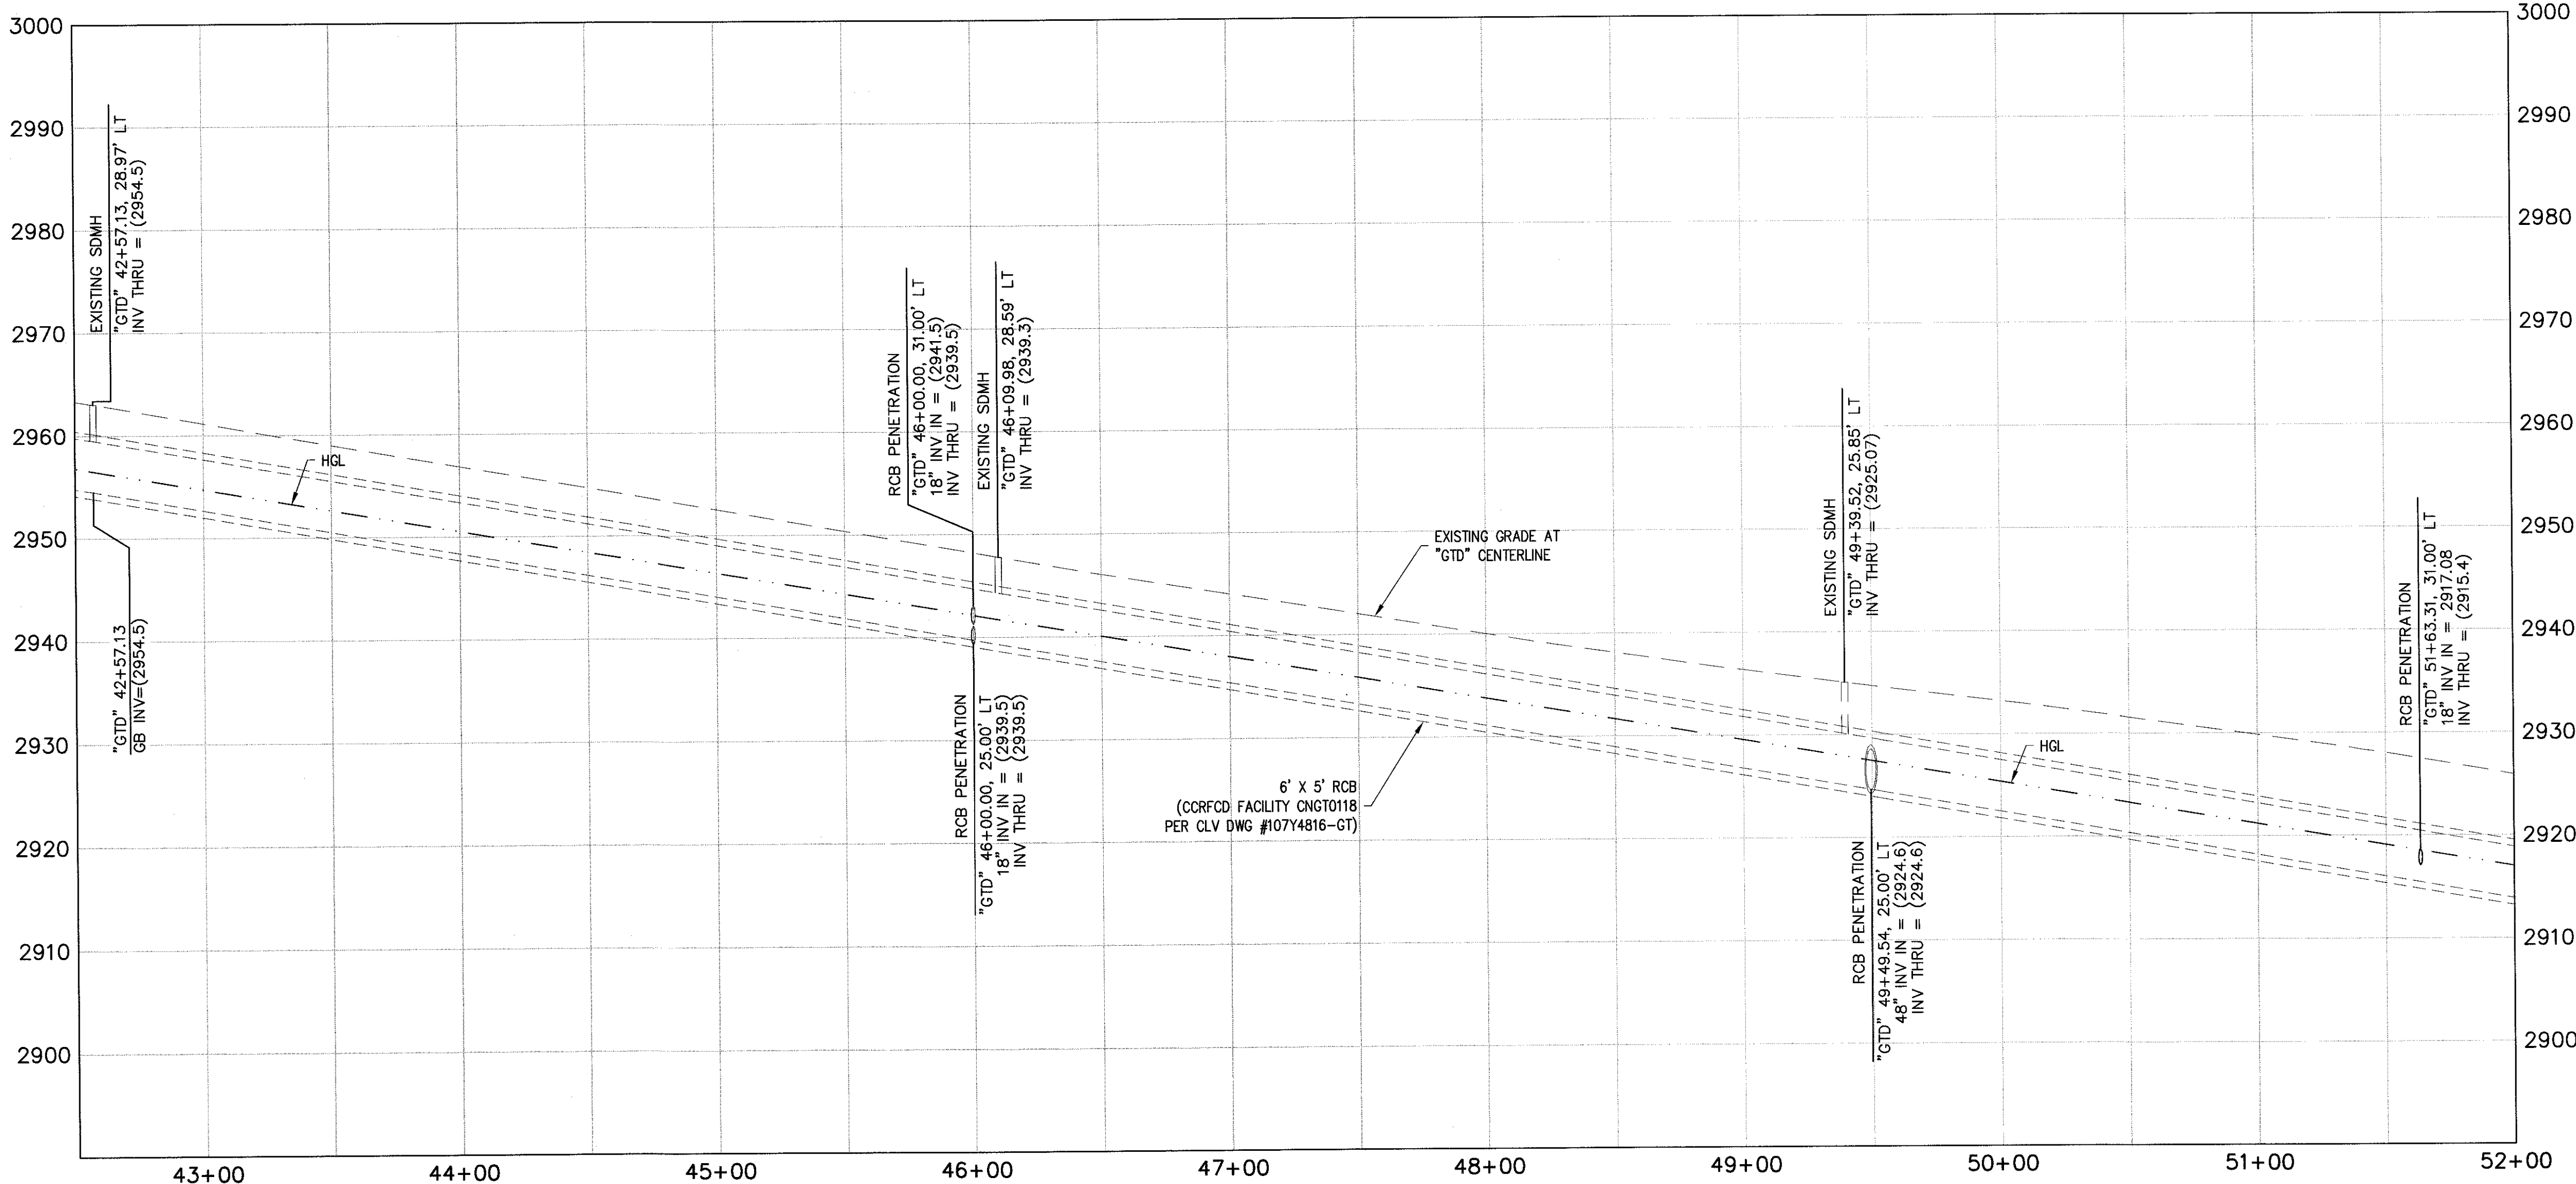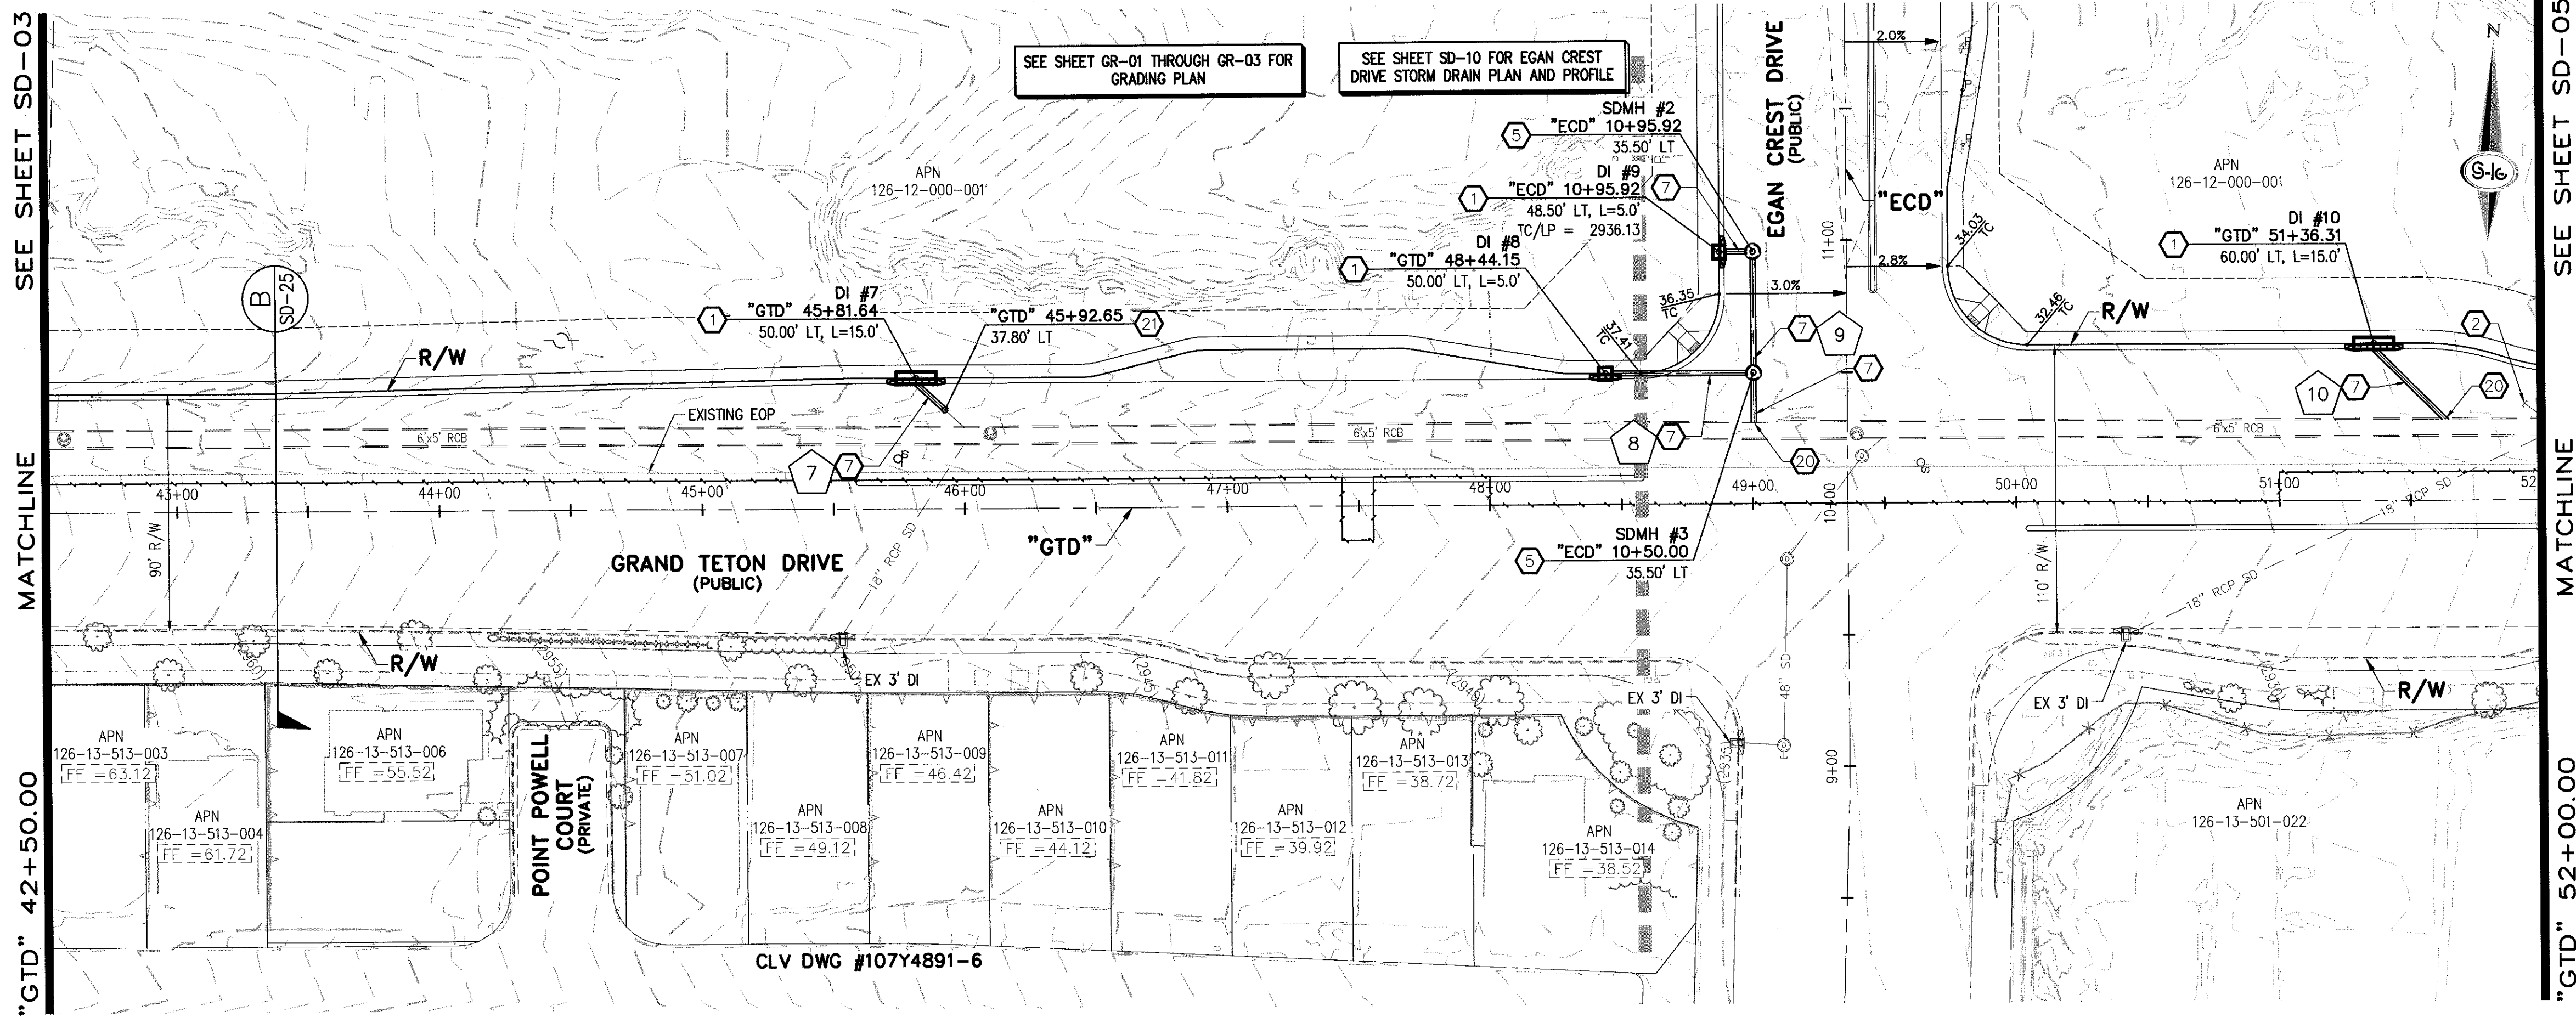

STORM DRAIN NOTES

- CONSTRUCT TYPE "CM2" DROP INLET (USDCCA STD. DWG. NO. 412.1)
- REMOVE EXISTING LATERAL STUB AND CONSTRUCT RCB PLUG (SEE DETAIL 5, DRAWING SD-26)
- CONSTRUCT 60" TYPE I MANHOLE (USDCCA STD. DWG. NO. 403.1)
- CONSTRUCT 60" TYPE III MANHOLE (USDCCA STD. DWG. NO. 406.1)
- CONSTRUCT 60" TYPE III MANHOLE WITH TYPE IA RISER (USDCCA STD. DWG. NO. 404.1 AND 406.1)
- CONSTRUCT NDOT TYPE 4 MANHOLE (NDOT STD. PLAN R-4.3.2)
- INSTALL 18" RCP (USDCCA STD. DWG. NO. 503.2)
- INSTALL 24" RCP (USDCCA STD. DWG. NO. 503.2)
- INSTALL 30" RCP (USDCCA STD. DWG. NO. 503.2)
- INSTALL 36" RCP (USDCCA STD. DWG. NO. 503.2)
- INSTALL 42" RCP (USDCCA STD. DWG. NO. 503.2)
- INSTALL 54" RCP (USDCCA STD. DWG. NO. 503.2)
- INSTALL 60" RCP (USDCCA STD. DWG. NO. 503.2)
- INSTALL 66" RCP (USDCCA STD. DWG. NO. 503.2)
- INSTALL 18" RCP END SECTION (NDOT STD. PLAN R-2.3.1)
- INSTALL 24" RCP END SECTION (NDOT STD. PLAN R-2.3.1)
- INSTALL 30" RCP END SECTION (NDOT STD. PLAN R-2.3.1)
- INSTALL 36" RCP END SECTION (NDOT STD. PLAN R-2.3.1)
- INSTALL 42" RCP END SECTION (NDOT STD. PLAN R-2.3.1)
- PIPE PENETRATION (SEE DETAIL 4, DRAWING SD-26)
- CONSTRUCT CONCRETE COLLAR (SEE DETAIL 2, DRAWING SD-26)
- CONSTRUCT BRICK AND MORTAR PLUG (SEE DETAIL 1, DRAWING SD-26)
- INSTALL 48" RCP (USDCCA STD. DWG. NO. 503.2)
- INSTALL 48" RCP END SECTION (NDOT STD. PLAN R-2.3.1)
- INSTALL DRIVEWAY (USDCCA STD. DWG. NO. 224)
- CONSTRUCT TYPE "CM" DROP INLET (USDCCA STD. DWG. NO. 422)

NOTES

- ALL RCP SHALL BE CLASS III UNLESS OTHERWISE SHOWN.
- ALL PIPE LENGTHS ARE MEASURED ALONG PIPE CENTERLINE TO CENTER OF MANHOLE OR INSIDE EDGE OF DI OR RCB/RCA.
- ALL DROP INLETS SHALL INCLUDE STORM WATER MANAGEMENT STAMP AND DETAIL PER USDCCA STD. DWG. NO. 421.
- SEE STRUCTURAL PLANS FOR ADDITIONAL STRUCTURAL DETAILS AND CONNECTIONS.
- ALL PIPES ARE PUBLICLY MAINTAINED.
- ADD SPECIAL INSPECTION REQUIRED FOR PIPE SEGMENTS WITH SACRIFICIAL CONCRETE.

DROP INLET NOTE

WHERE 10 FEET PARALLEL SEPARATION IS NOT PRACTICABLE, CAST-IN-PLACE MONOLITHIC POUR WITH WATERSTOP BETWEEN SLAB AND WALLS. BASE, WALLS AND TOP TO BE CONSTRUCTED WITH WATERSTOPS, CENTER BULB, OR FLAT STRIP (VINYLEX, GREENSTREAK PLASTIC PRODUCTS OR APPROVED EQUAL).

LEGEND



STORM DRAIN LATERAL # (SEE SHEETS SD-20 THRU SD-24)

I CERTIFY THAT THIS GRADING PLAN IS IN CONFORMANCE WITH THE APPROVED TECHNICAL DRAINAGE STUDY DS-4739A ON FILE AT THE CITY OF LAS VEGAS FOR THE SUBJECT PROJECT.

JERRY SLATER, P.E. 14167



DATE 3.22.20



FLOOD ZONE

THE PROJECT SITE IS LOCATED WITHIN A FEMA DESIGNATED ZONE "X" (OUTSIDE THE 500-YEAR FLOOD PLAIN) ON THE FLOOD INSURANCE RATE MAP (FIRM) PANEL: 32003C1750E, DATED SEPTEMBER 27, 2002.

NOTE:

PROPERTY OWNER IS RESPONSIBLE TO MAINTAIN THE BEST MANAGEMENT PRACTICES, SUCH AS BUT NOT LIMITED TO, THE REMOVAL OF ACCUMULATED SEDIMENT AND DEBRIS AND CARE OF VEGETATION.

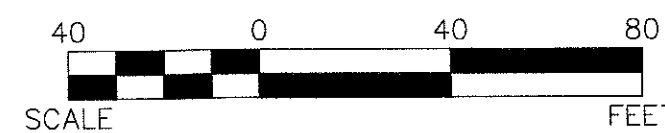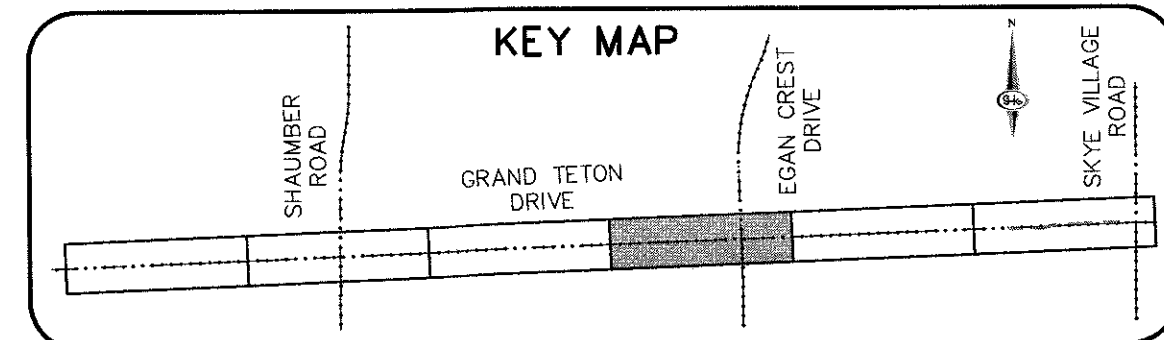

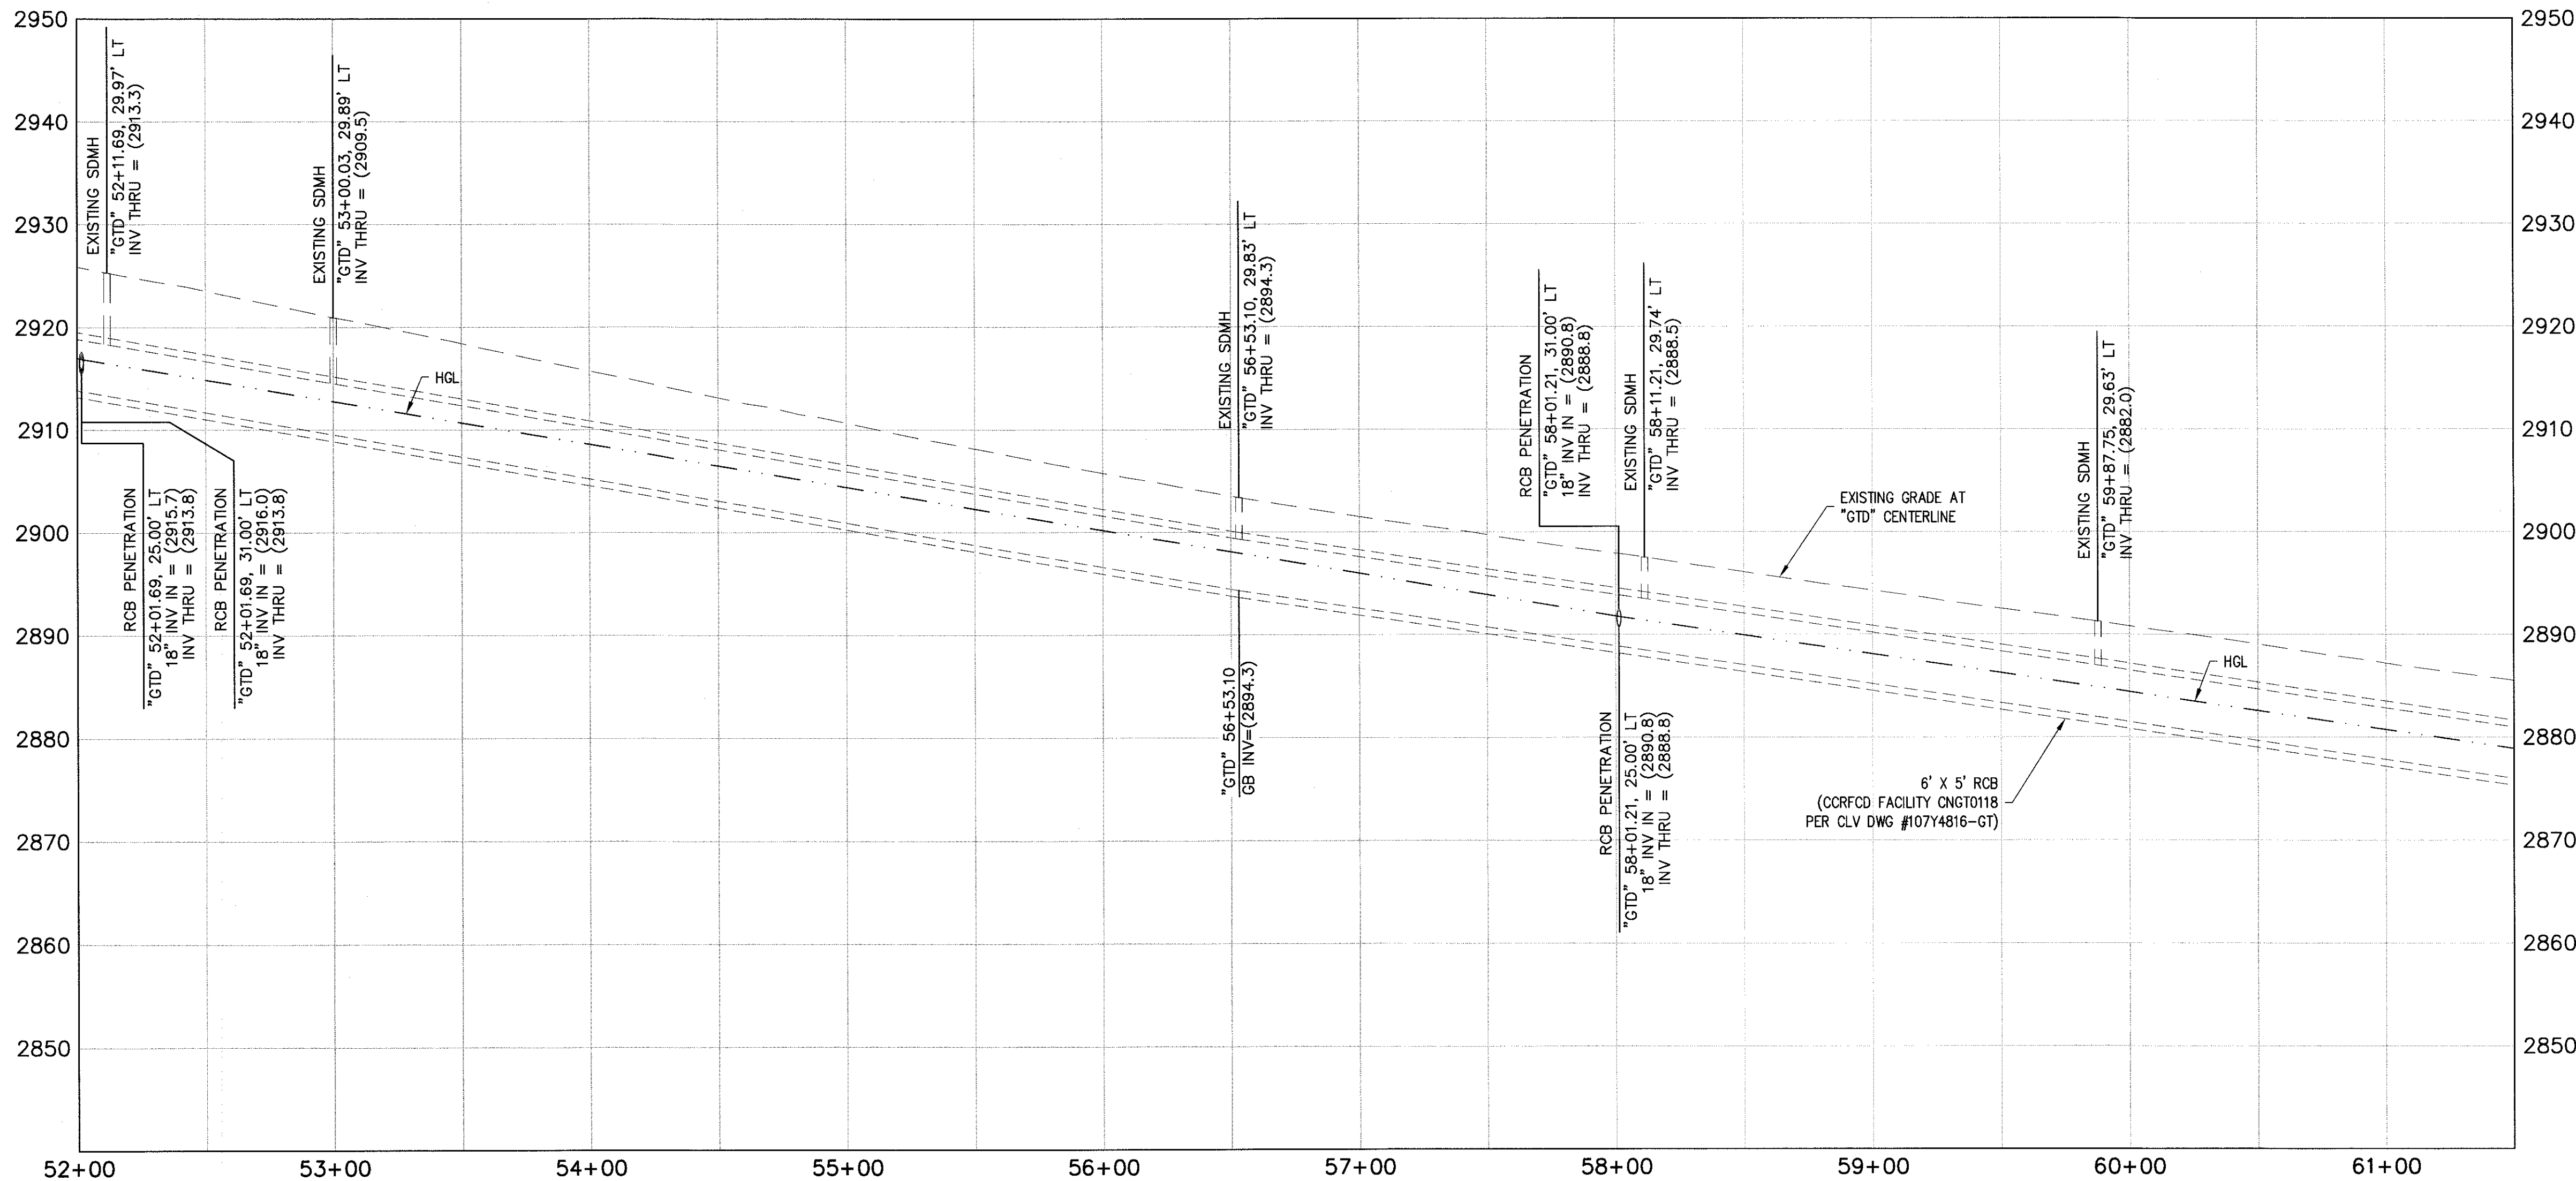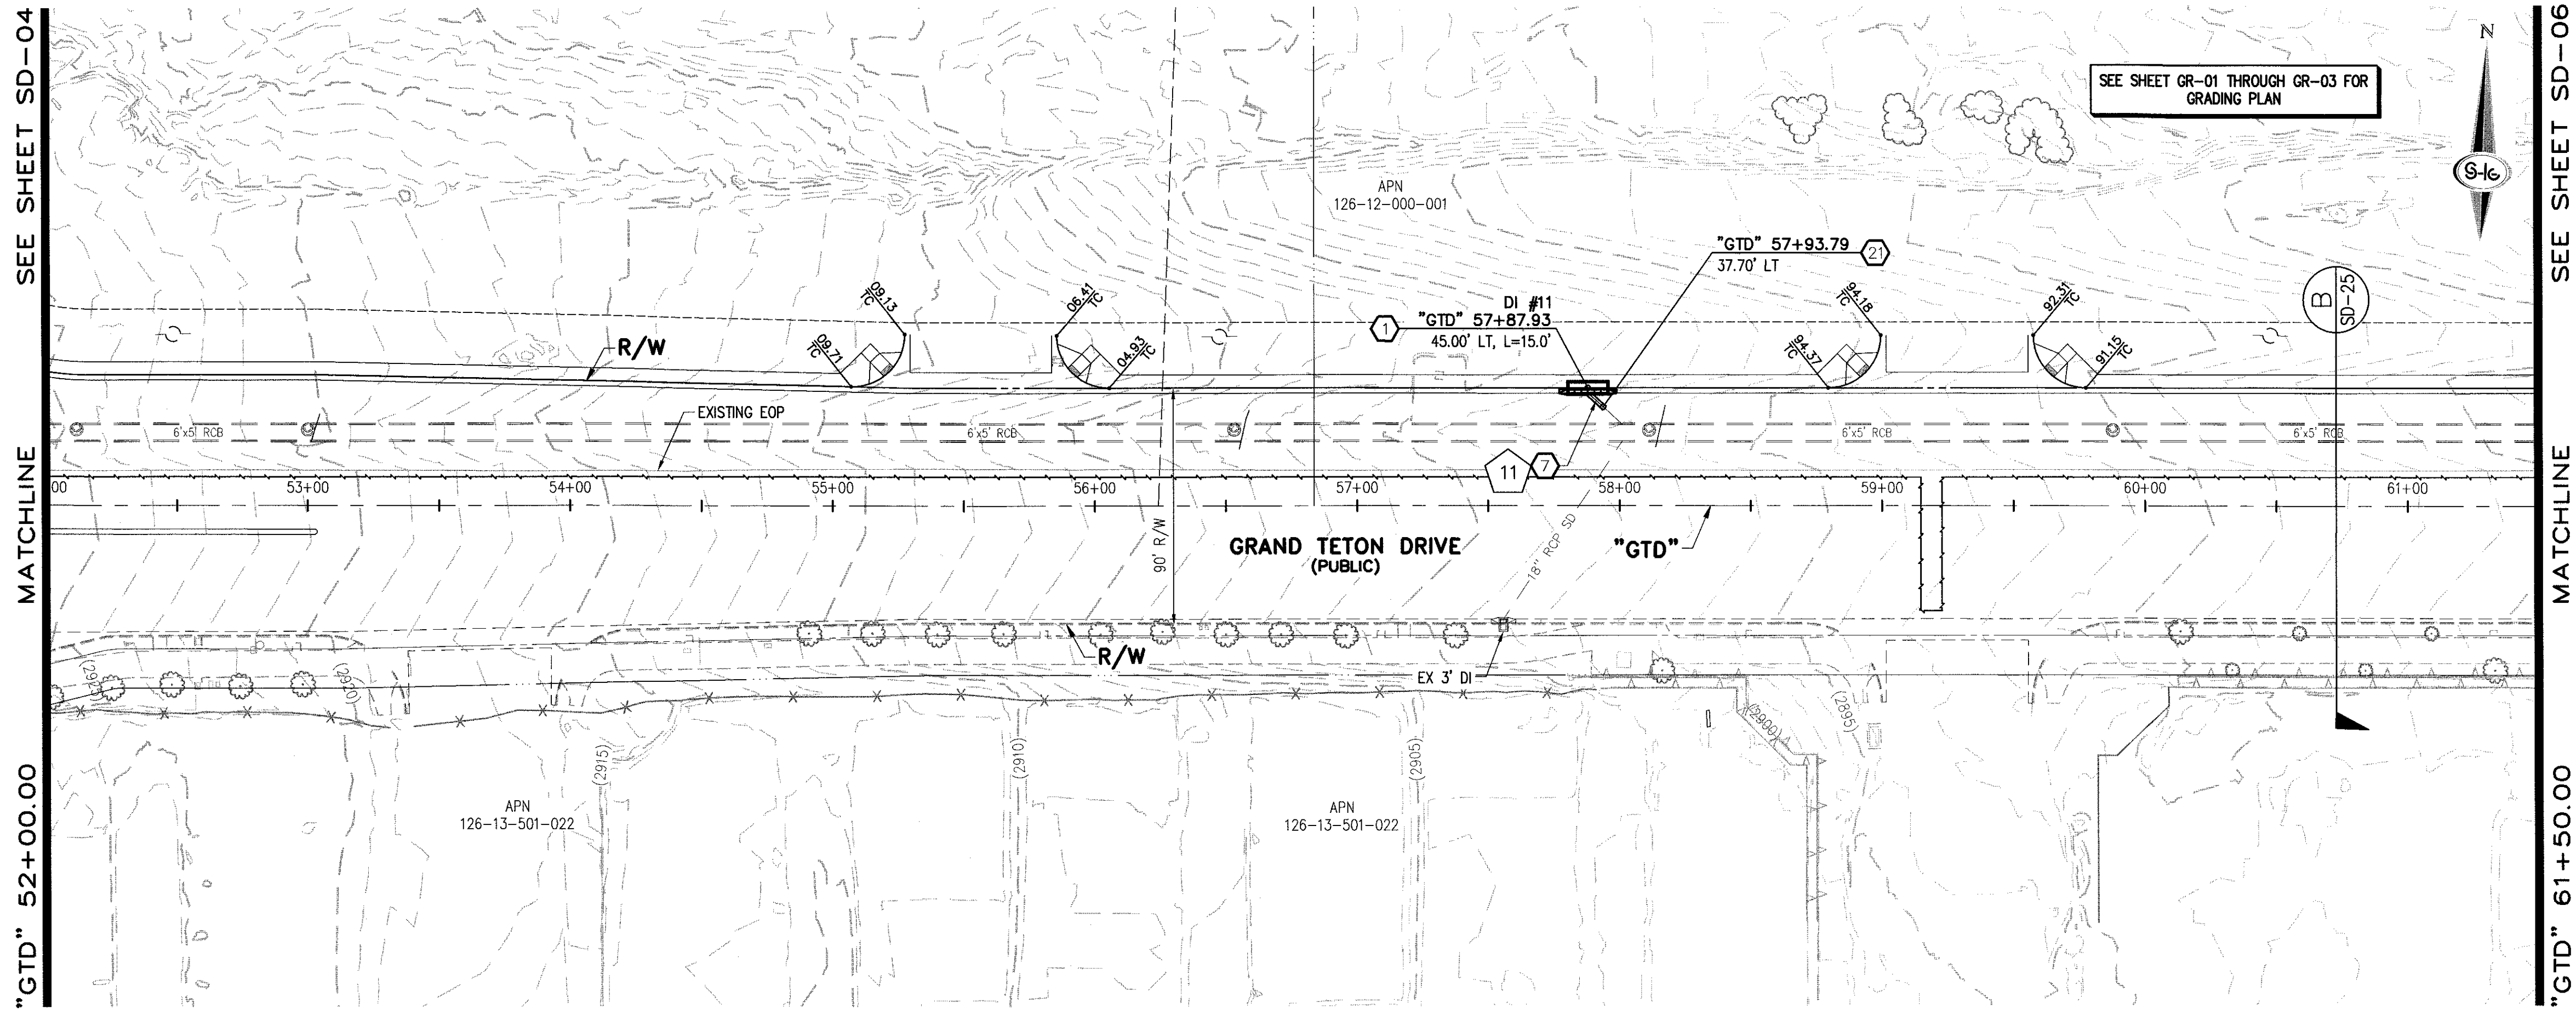

- ### STORM DRAIN NOTES
1. CONSTRUCT TYPE "CM2" DROP INLET (USDCCA STD. DWG. NO. 412.1)
 2. REMOVE EXISTING LATERAL STUB AND CONSTRUCT RCB PLUG (SEE DETAIL 5, DRAWING SD-26)
 3. CONSTRUCT 60" TYPE I MANHOLE (USDCCA STD. DWG. NO. 403.1)
 4. CONSTRUCT 60" TYPE III MANHOLE (USDCCA STD. DWG. NO. 406.1)
 5. CONSTRUCT 60" TYPE III MANHOLE WITH TYPE IA RISER (USDCCA STD. DWG. NO. 404.1 AND 406.1)
 6. CONSTRUCT NDOT TYPE 4 MANHOLE (NDOT STD. PLAN R-4.3.2)
 7. INSTALL 18" RCP (USDCCA STD. DWG. NO. 503.2)
 8. INSTALL 24" RCP (USDCCA STD. DWG. NO. 503.2)
 9. INSTALL 30" RCP (USDCCA STD. DWG. NO. 503.2)
 10. INSTALL 36" RCP (USDCCA STD. DWG. NO. 503.2)
 11. INSTALL 42" RCP (USDCCA STD. DWG. NO. 503.2)
 12. INSTALL 54" RCP (USDCCA STD. DWG. NO. 503.2)
 13. INSTALL 60" RCP (USDCCA STD. DWG. NO. 503.2)
 14. INSTALL 66" RCP (USDCCA STD. DWG. NO. 503.2)
 15. INSTALL 18" RCP END SECTION (NDOT STD. PLAN R-2.3.1)
 16. INSTALL 24" RCP END SECTION (NDOT STD. PLAN R-2.3.1)
 17. INSTALL 30" RCP END SECTION (NDOT STD. PLAN R-2.3.1)
 18. INSTALL 36" RCP END SECTION (NDOT STD. PLAN R-2.3.1)
 19. INSTALL 42" RCP END SECTION (NDOT STD. PLAN R-2.3.1)
 20. PIPE PENETRATION (SEE DETAIL 4, DRAWING SD-26)
 21. CONSTRUCT CONCRETE COLLAR (SEE DETAIL 2, DRAWING SD-26)
 22. CONSTRUCT BRICK AND MORTAR PLUG (SEE DETAIL 1, DRAWING SD-26)
 23. INSTALL 48" RCP (USDCCA STD. DWG. NO. 503.2)
 24. INSTALL 48" RCP END SECTION (NDOT STD. PLAN R-2.3.1)
 25. INSTALL DRIVEWAY (USDCCA STD. DWG. NO. 224)
 26. CONSTRUCT TYPE "CM" DROP INLET (USDCCA STD. DWG. NO. 422)

- ### NOTES
1. ALL RCP SHALL BE CLASS III UNLESS OTHERWISE SHOWN.
 2. ALL PIPE LENGTHS ARE MEASURED ALONG PIPE CENTERLINE TO CENTER OF MANHOLE OR INSIDE EDGE OF DI OR RCB/RCA.
 3. ALL DROP INLETS SHALL INCLUDE STORM WATER MANAGEMENT STAMP AND DETAIL PER USDCCA STD. DWG. NO. 421.
 4. SEE STRUCTURAL PLANS FOR ADDITIONAL STRUCTURAL DETAILS AND CONNECTIONS.
 5. ALL PIPES ARE PUBLICLY MAINTAINED.
 6. ADD SPECIAL INSPECTION REQUIRED FOR PIPE SEGMENTS WITH SACRIFICIAL CONCRETE.

DROP INLET NOTE

WHERE 10 FEET PARALLEL SEPARATION IS NOT PRACTICABLE:
CAST-IN-PLACE MONOLITHIC POUR WITH WATERSTOP BETWEEN SLAB AND WALLS. BASE, WALLS AND TOP TO BE CONSTRUCTED WITH WATERSTOPS, CENTER BULB, OR FLAT STRIP (VINYLEX, GREENSTREAK PLASTIC PRODUCTS OR APPROVED EQUAL).

LEGEND

1 STORM DRAIN LATERAL # (SEE SHEETS SD-20 THRU SD-24)

I CERTIFY THAT THIS GRADING PLAN IS IN CONFORMANCE WITH THE APPROVED TECHNICAL DRAINAGE STUDY DS-4758A ON FILE AT THE CITY OF LAS VEGAS FOR THE PROJECT.


JERRY SLATER, P.E. 14167 DATE 3/22/16

FLOOD ZONE

THE PROJECT SITE IS LOCATED WITHIN A FEMA DESIGNATED ZONE "X" (OUTSIDE THE 500-YEAR FLOOD PLAIN) ON THE FLOOD INSURANCE RATE MAP (FIRM) PANEL:32003C1750E, DATED SEPTEMBER 27, 2002

NOTE:

PROPERTY OWNER IS RESPONSIBLE TO MAINTAIN THE BEST MANAGEMENT PRACTICES, SUCH AS BUT NOT LIMITED TO, THE REMOVAL OF ACCUMULATED SEDIMENT AND DEBRIS AND CARE OF VEGETATION.

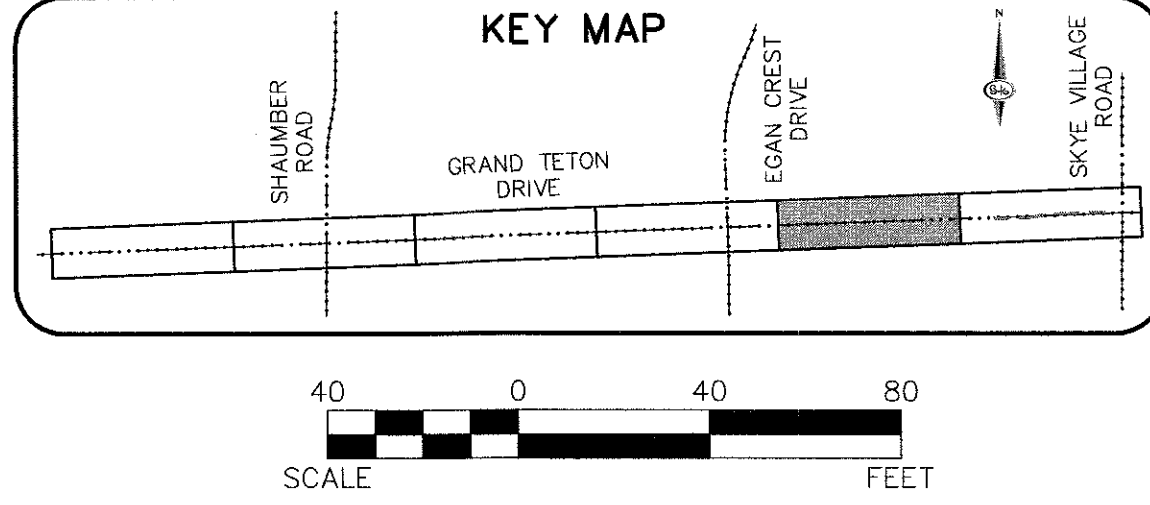

AVOID HITTING OVERHEAD POWER LINES. IT'S DANGEROUS. CALL BEFORE YOU DIG. 1-702-227-2929

FAST
Call before you dig.
1-702-432-5300
TRENCHING AND UTILITY SYSTEMS OF ILLINOIS

Call before you Dig
811
1-800-227-2600

SLATER HANIFAN GROUP
CONSULTING ENGINEERS & PLANNERS
5740 S. ARVILLE STREET #216, LAS VEGAS, NV 89118
PHONE (702) 284-5300 FAX (702) 284-5398

NINETY-FIVE MANAGEMENT LLC

SKYE CANYON PHASE 2
GRAND TETON DRIVE STORM DRAIN PLAN AND PROFILE
"GTD" 52+00.00 TO "GTD" 61+50.00


DATE: 11/19/15
DRAFTER: JAS
DESIGNER: DAM
CHECKED: JSR
PROJECT NO. OLY1501-001

SD-05
SHEET 8 OF 33

SEE SHEET SD-05

MATCHLINE

"GTD" 61+50.00

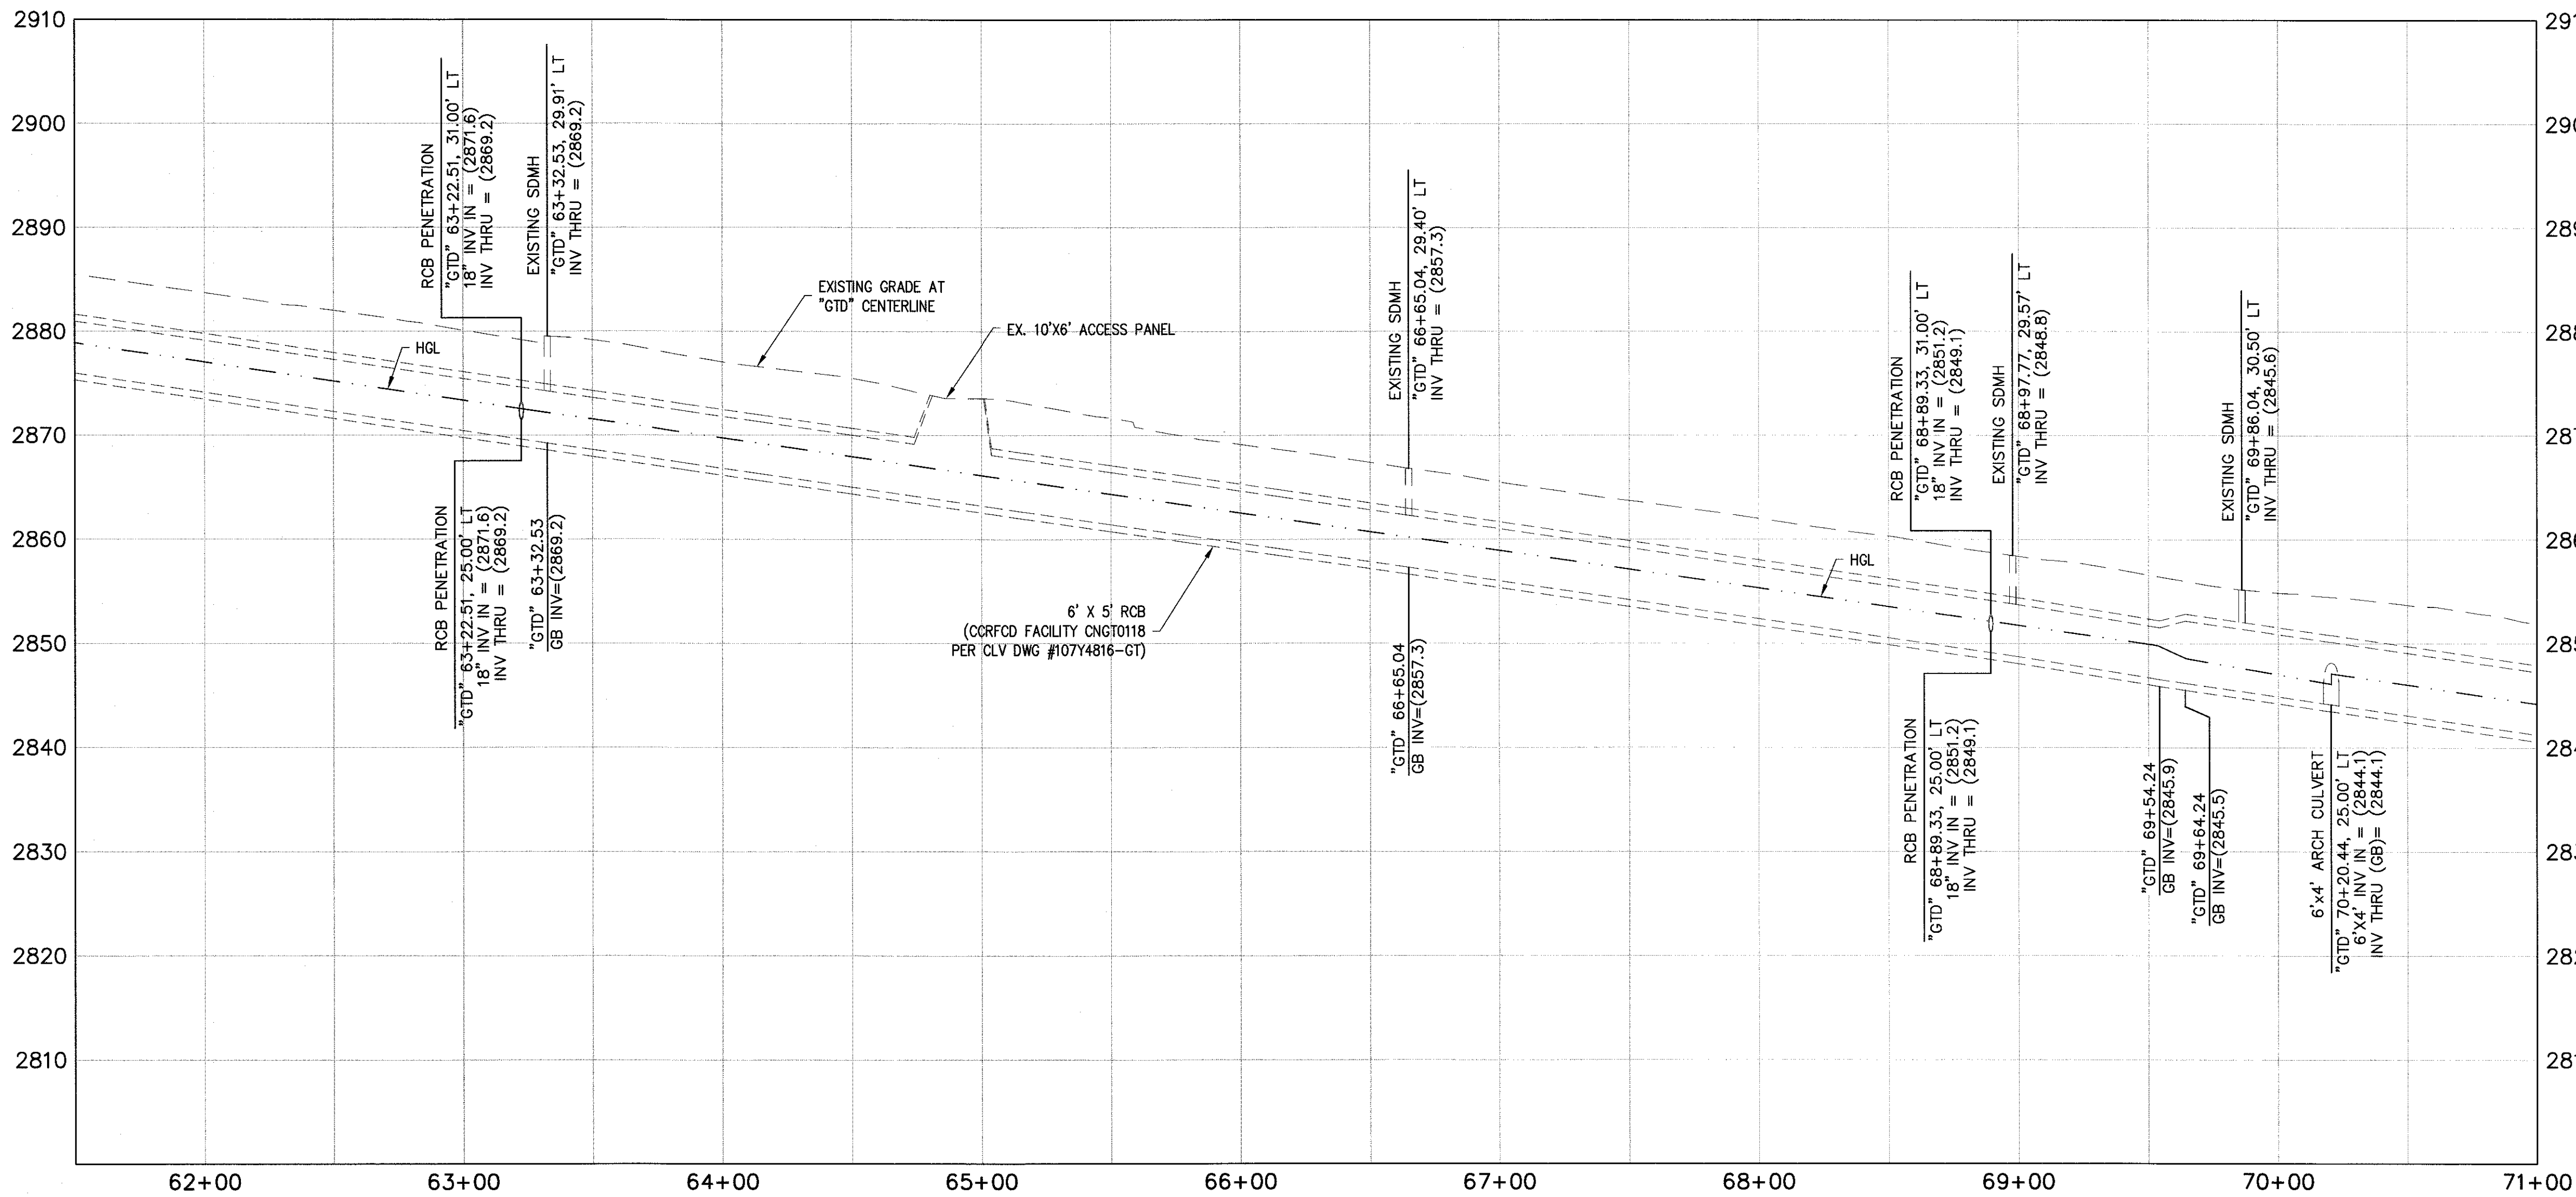

STORM DRAIN NOTES

1. CONSTRUCT TYPE "CM2" DROP INLET (USDCCA STD. DWG. NO. 412.1)
2. REMOVE EXISTING LATERAL STUB AND CONSTRUCT RCB PLUG (SEE DETAIL 5, DRAWING SD-26)
3. CONSTRUCT 60" TYPE I MANHOLE (USDCCA STD. DWG. NO. 403.1)
4. CONSTRUCT 60" TYPE III MANHOLE (USDCCA STD. DWG. NO. 406.1)
5. CONSTRUCT 60" TYPE III MANHOLE WITH TYPE IA RISER (USDCCA STD. DWG. NO. 404.1 AND 406.1)
6. CONSTRUCT NDOT TYPE 4 MANHOLE (NDOT STD. PLAN R-4.3.2)
7. INSTALL 18" RCP (USDCCA STD. DWG. NO. 503.2)
8. INSTALL 24" RCP (USDCCA STD. DWG. NO. 503.2)
9. INSTALL 30" RCP (USDCCA STD. DWG. NO. 503.2)
10. INSTALL 36" RCP (USDCCA STD. DWG. NO. 503.2)
11. INSTALL 42" RCP (USDCCA STD. DWG. NO. 503.2)
12. INSTALL 54" RCP (USDCCA STD. DWG. NO. 503.2)
13. INSTALL 60" RCP (USDCCA STD. DWG. NO. 503.2)
14. INSTALL 66" RCP (USDCCA STD. DWG. NO. 503.2)
15. INSTALL 18" RCP END SECTION (NDOT STD. PLAN R-2.3.1)
16. INSTALL 24" RCP END SECTION (NDOT STD. PLAN R-2.3.1)
17. INSTALL 30" RCP END SECTION (NDOT STD. PLAN R-2.3.1)
18. INSTALL 36" RCP END SECTION (NDOT STD. PLAN R-2.3.1)
19. INSTALL 42" RCP END SECTION (NDOT STD. PLAN R-2.3.1)
20. PIPE PENETRATION (SEE DETAIL 4, DRAWING SD-26)
21. CONSTRUCT CONCRETE COLLAR (SEE DETAIL 2, DRAWING SD-26)
22. CONSTRUCT BRICK AND MORTAR PLUG (SEE DETAIL 1, DRAWING SD-26)
23. INSTALL 48" RCP (USDCCA STD. DWG. NO. 503.2)
24. INSTALL 48" RCP END SECTION (NDOT STD. PLAN R-2.3.1)
25. INSTALL DRIVEWAY (USDCCA STD. DWG. NO. 224)
26. CONSTRUCT TYPE "CM" DROP INLET (USDCCA STD. DWG. NO. 422)

NOTES

1. ALL RCP SHALL BE CLASS III UNLESS OTHERWISE SHOWN.
2. ALL PIPE LENGTHS ARE MEASURED ALONG PIPE CENTERLINE TO CENTER OF MANHOLE OR INSIDE EDGE OF DI OR RCB/RCA.
3. ALL DROP INLETS SHALL INCLUDE STORM WATER MANAGEMENT STAMP AND DETAIL PER USDCCA STD. DWG. NO. 421.
4. SEE STRUCTURAL PLANS FOR ADDITIONAL STRUCTURAL DETAILS AND CONNECTIONS.
5. ALL PIPES ARE PUBLICLY MAINTAINED.
6. ADD SPECIAL INSPECTION REQUIRED FOR PIPE SEGMENTS WITH SACRIFICIAL CONCRETE.

DROP INLET NOTE

WHERE 10 FEET PARALLEL SEPARATION IS NOT PRACTICABLE:
CAST-IN-PLACE MONOLITHIC POUR WITH WATERSTOP BETWEEN SLAB AND WALLS.
BASE, WALLS AND TOP TO BE CONSTRUCTED WITH WATERSTOPS, CENTER BUILT,
OR FLAT STRIP (VINYLEX, GREENSTREAK PLASTIC PRODUCTS OR APPROVED EQUAL).

LEGEND



STORM DRAIN LATERAL # (SEE SHEETS SD-20 THRU SD-24)

I CERTIFY THAT THIS GRADING PLAN IS IN
CONFORMANCE WITH THE APPROVED TECHNICAL
DRAINAGE STUDY (DS-47304 ON FILE AT THE CITY
OF LAS VEGAS FOR THE SUBJECT PROJECT
JERRY SLATER, P.E. 14167 DATE 3-22-16


FLOOD ZONE

THE PROJECT SITE IS LOCATED WITHIN A FEMA
DESIGNATED ZONE "X" (OUTSIDE THE 500-YEAR
FLOOD PLAIN) ON THE FLOOD INSURANCE RATE
MAP (FIRM) PANEL:32003C1750E, DATED
SEPTEMBER 27, 2002


NOTE:

PROPERTY OWNER IS RESPONSIBLE TO MAINTAIN THE BEST MANAGEMENT PRACTICES,
SUCH AS BUT NOT LIMITED TO, THE REMOVAL OF ACCUMULATED SEDIMENT AND DEBRIS
AND CARE OF VEGETATION.

KEY MAP

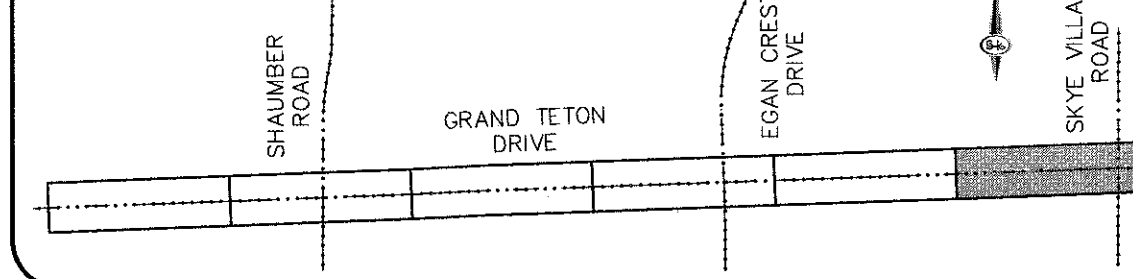

40 0 40 80
SCALE FEET

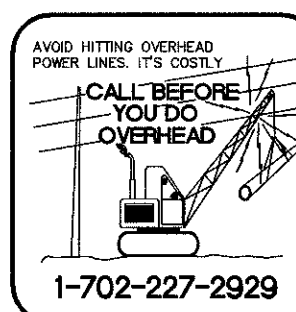

DATE: 11/19/15


DRAFTER: JAS

DESIGNER: DAM

CHECKED: JSR



PROJECT NO.

OLY1501-001

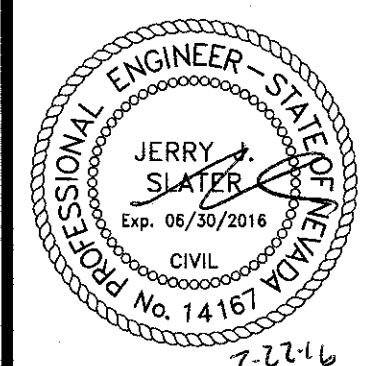

SD-06

SHEET 9 OF 33

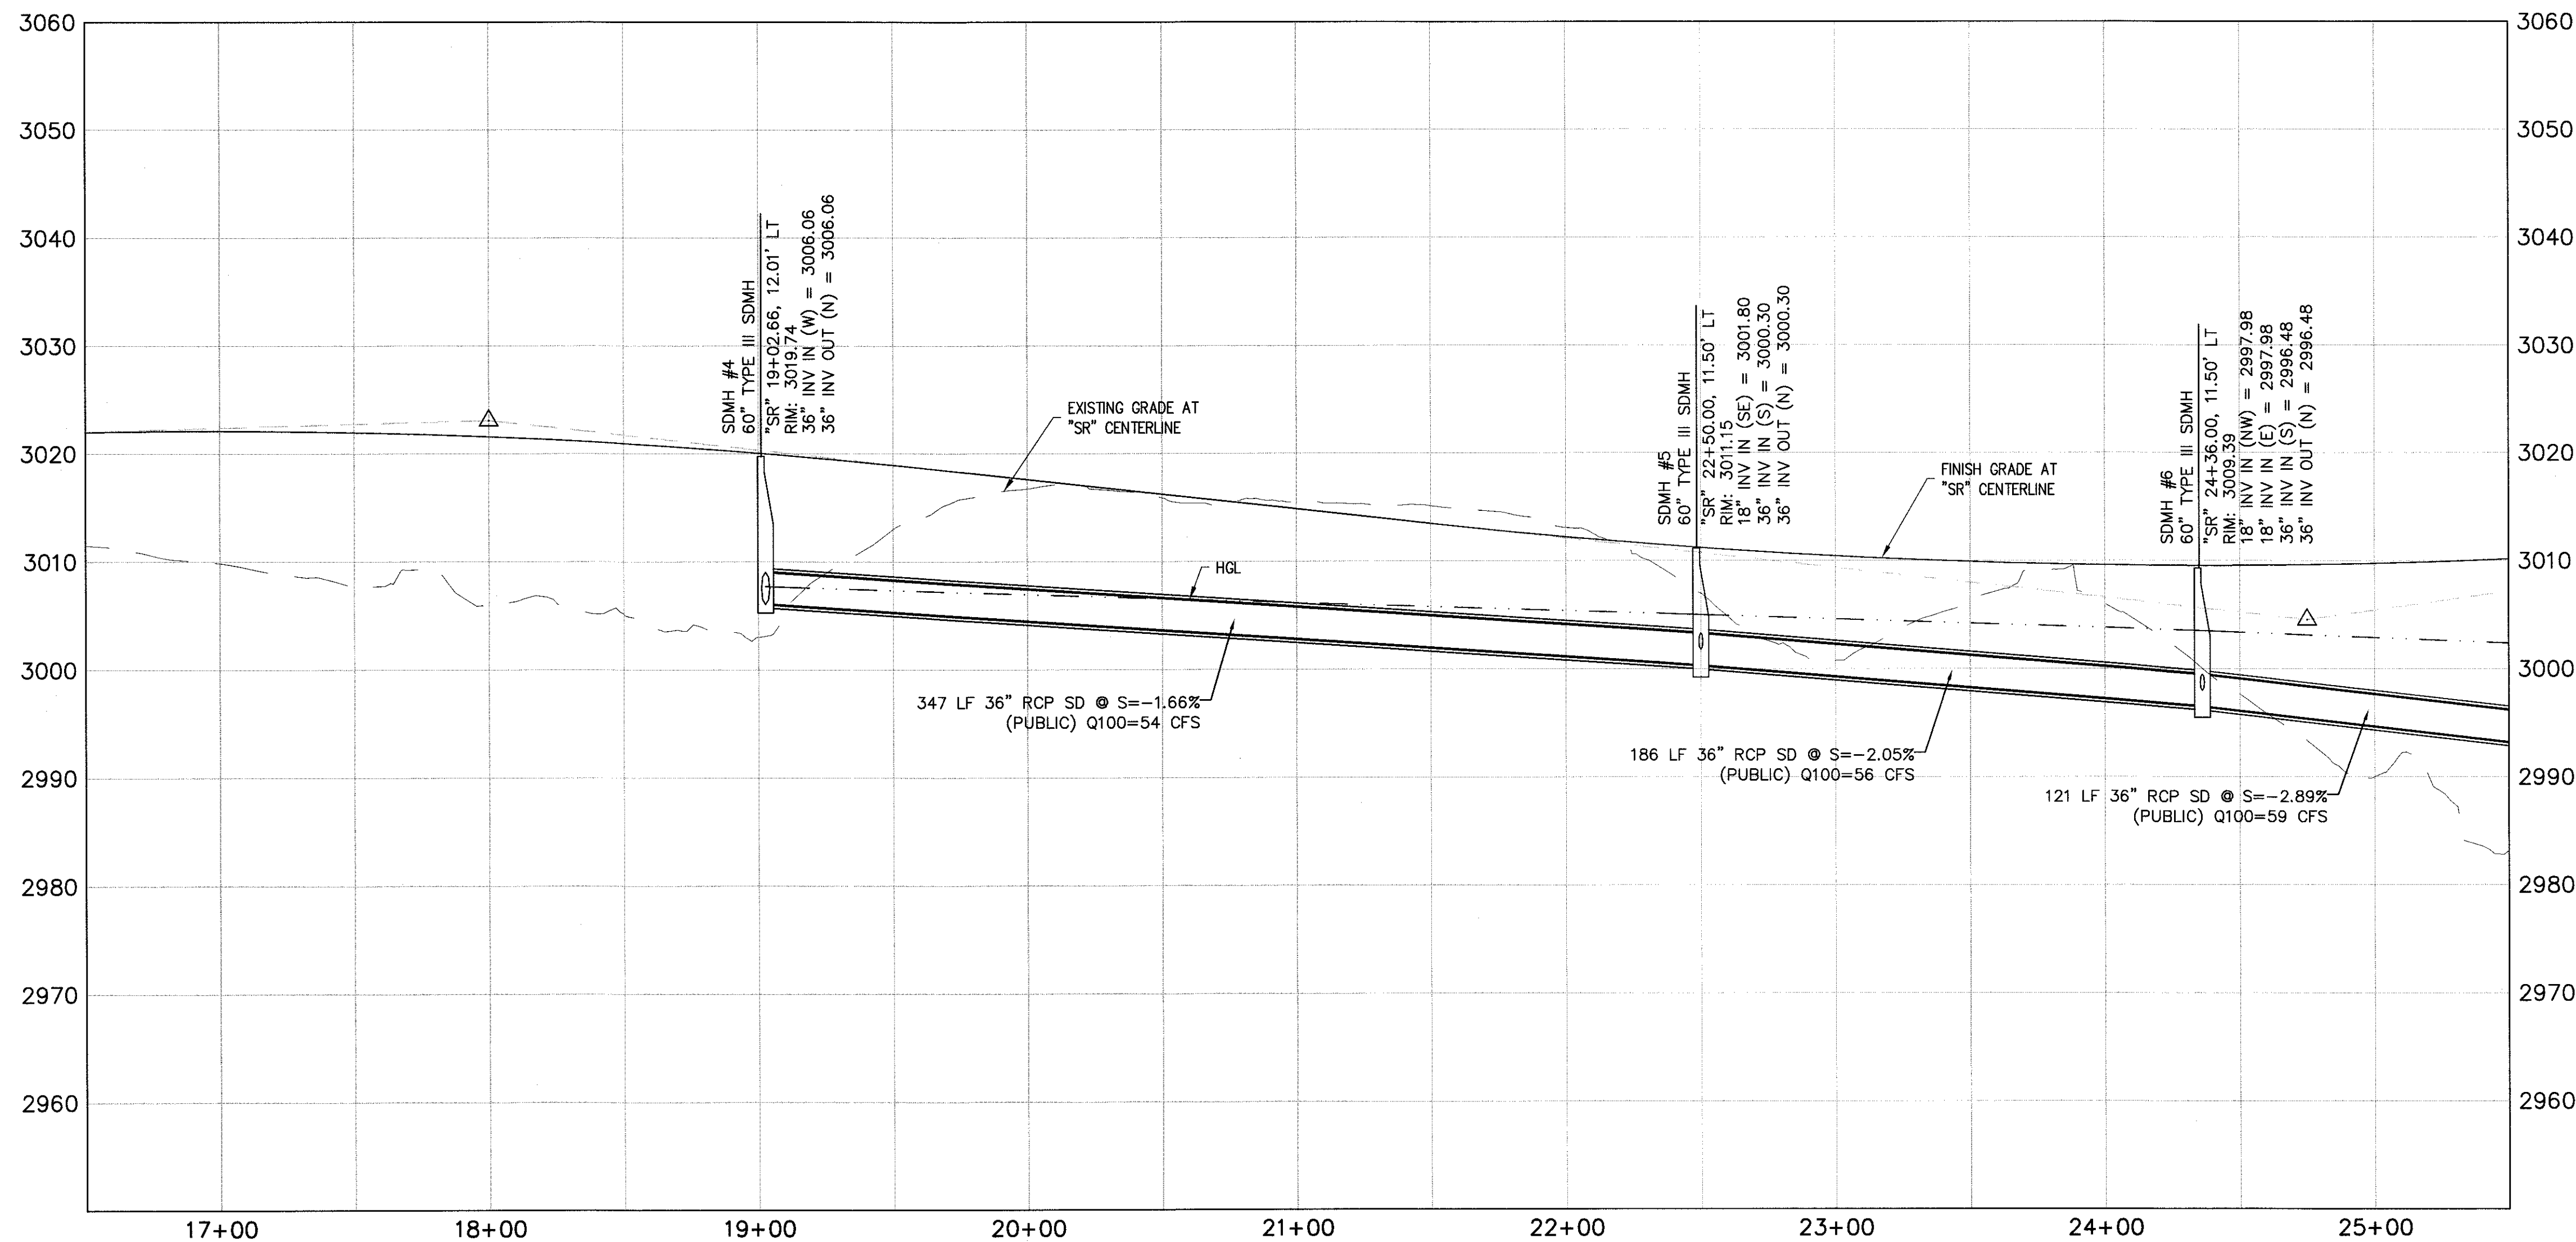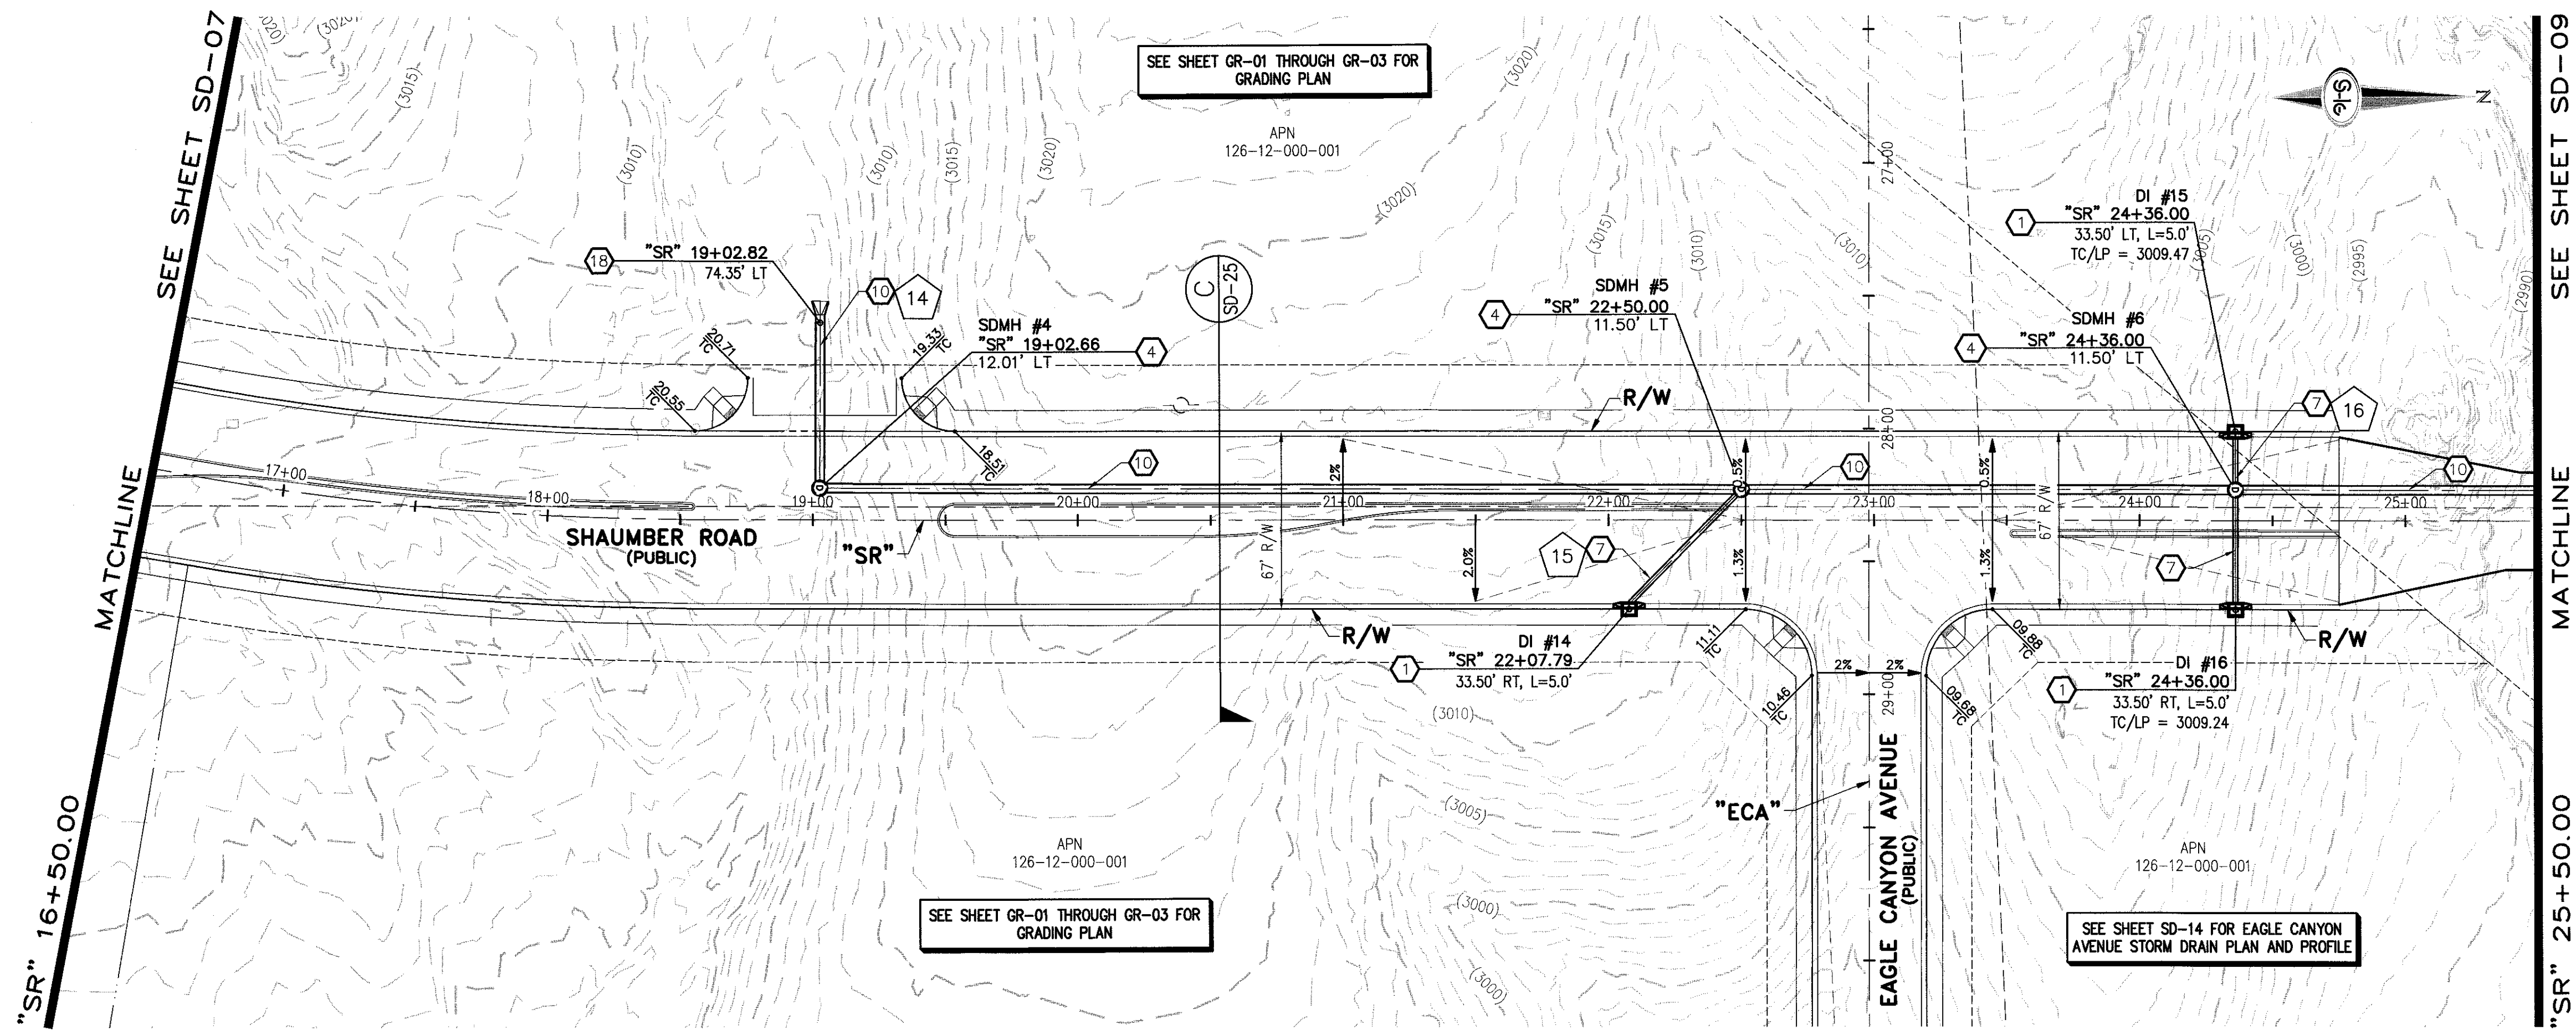

STORM DRAIN NOTES

1. CONSTRUCT TYPE "CM2" DROP INLET (USDCCA STD. DWG. NO. 412.1)
2. REMOVE EXISTING LATERAL STUB AND CONSTRUCT RCB PLUG (SEE DETAIL 5, DRAWING SD-26)
3. CONSTRUCT 60" TYPE I MANHOLE (USDCCA STD. DWG. NO. 403.1)
4. CONSTRUCT 60" TYPE III MANHOLE (USDCCA STD. DWG. NO. 406.1)
5. CONSTRUCT 60" TYPE III MANHOLE WITH TYPE IA RISER (USDCCA STD. DWG. NO. 404.1 AND 406.1)
6. CONSTRUCT NDOT TYPE 4 MANHOLE (NDOT STD. PLAN R-4.3.2)
7. INSTALL 18" RCP (USDCCA STD. DWG. NO. 503.2)
8. INSTALL 24" RCP (USDCCA STD. DWG. NO. 503.2)
9. INSTALL 30" RCP (USDCCA STD. DWG. NO. 503.2)
10. INSTALL 36" RCP (USDCCA STD. DWG. NO. 503.2)
11. INSTALL 42" RCP (USDCCA STD. DWG. NO. 503.2)
12. INSTALL 54" RCP (USDCCA STD. DWG. NO. 503.2)
13. INSTALL 60" RCP (USDCCA STD. DWG. NO. 503.2)
14. INSTALL 66" RCP (USDCCA STD. DWG. NO. 503.2)
15. INSTALL 18" RCP END SECTION (NDOT STD. PLAN R-2.3.1)
16. INSTALL 24" RCP END SECTION (NDOT STD. PLAN R-2.3.1)
17. INSTALL 30" RCP END SECTION (NDOT STD. PLAN R-2.3.1)
18. INSTALL 36" RCP END SECTION (NDOT STD. PLAN R-2.3.1)
19. INSTALL 42" RCP END SECTION (NDOT STD. PLAN R-2.3.1)
20. PIPE PENETRATION (SEE DETAIL 4, DRAWING SD-26)
21. CONSTRUCT CONCRETE COLLAR (SEE DETAIL 2, DRAWING SD-26)
22. CONSTRUCT BRICK AND MORTAR PLUG (SEE DETAIL 1, DRAWING SD-26)
23. INSTALL 48" RCP (USDCCA STD. DWG. NO. 503.2)
24. INSTALL 48" RCP END SECTION (NDOT STD. PLAN R-2.3.1)
25. INSTALL DRIVEWAY (USDCCA STD. DWG. NO. 224)
26. CONSTRUCT TYPE "CM" DROP INLET (USDCCA STD. DWG. NO. 422)

 
NOTES

1. ALL RCP SHALL BE CLASS III UNLESS OTHERWISE SHOWN.
2. ALL PIPE LENGTHS ARE MEASURED ALONG PIPE CENTERLINE TO CENTER OF MANHOLE OR INSIDE EDGE OF DI OR RCB/RCA.
3. ALL DROP INLETS SHALL INCLUDE STORM WATER MANAGEMENT STAMP AND DETAIL PER USDCCA STD. DWG. NO. 421.
4. SEE STRUCTURAL PLANS FOR ADDITIONAL STRUCTURAL DETAILS AND CONNECTIONS.
5. ALL PIPES ARE PUBLICLY MAINTAINED.
6. ADD SPECIAL INSPECTION REQUIRED FOR PIPE SEGMENTS WITH SACRIFICIAL CONCRETE.

DROP INLET NOTE

WHERE 10 FEET PARALLEL SEPARATION IS NOT PRACTICABLE:
CAST-IN-PLACE MONOLITHIC POUR WITH WATERSTOP BETWEEN SLAB AND WALLS.
BASE, WALLS AND TOP TO BE CONSTRUCTED WITH WATERSTOPS, CENTER BULB, OR FLAT STRIP (VINYLEX, GREENSTREAK PLASTIC PRODUCTS OR APPROVED EQUAL).

LEGEND



STORM DRAIN LATERAL # (SEE SHEETS SD-20 THRU SD-24)

FLOOD ZONE

I CERTIFY THAT THIS GRADING PLAN IS IN CONFORMANCE WITH THE APPROVED TECHNICAL DRAINAGE STUDY DS-4739A ON FILE AT THE CITY OF LAS VEGAS FOR THE SUBJECT PROJECT.


JERRY SLATER, P.E. 14167 DATE 3/22/16

THE PROJECT SITE IS LOCATED WITHIN A FEMA DESIGNATED ZONE "X" (OUTSIDE THE 500-YEAR FLOOD PLAIN) ON THE FLOOD INSURANCE RATE MAP (FIRM) PANEL: 32003C1750E, DATED SEPTEMBER 27, 2002.


NOTE:



PROPERTY OWNER IS RESPONSIBLE TO MAINTAIN THE BEST MANAGEMENT PRACTICES, SUCH AS BUT NOT LIMITED TO, THE REMOVAL OF ACCUMULATED SEDIMENT AND DEBRIS AND CARE OF VEGETATION.

KEY MAP

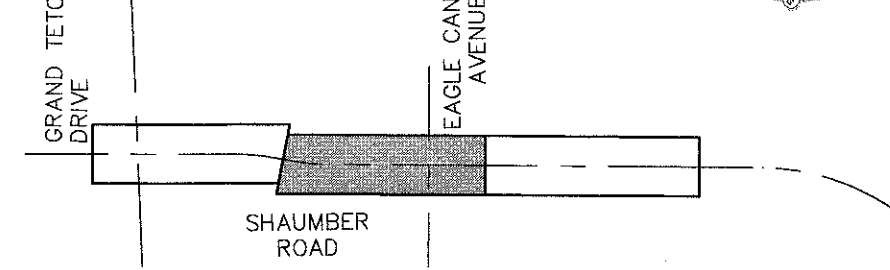

40 0 40 80
SCALE FEET

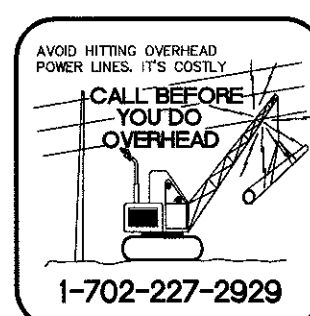

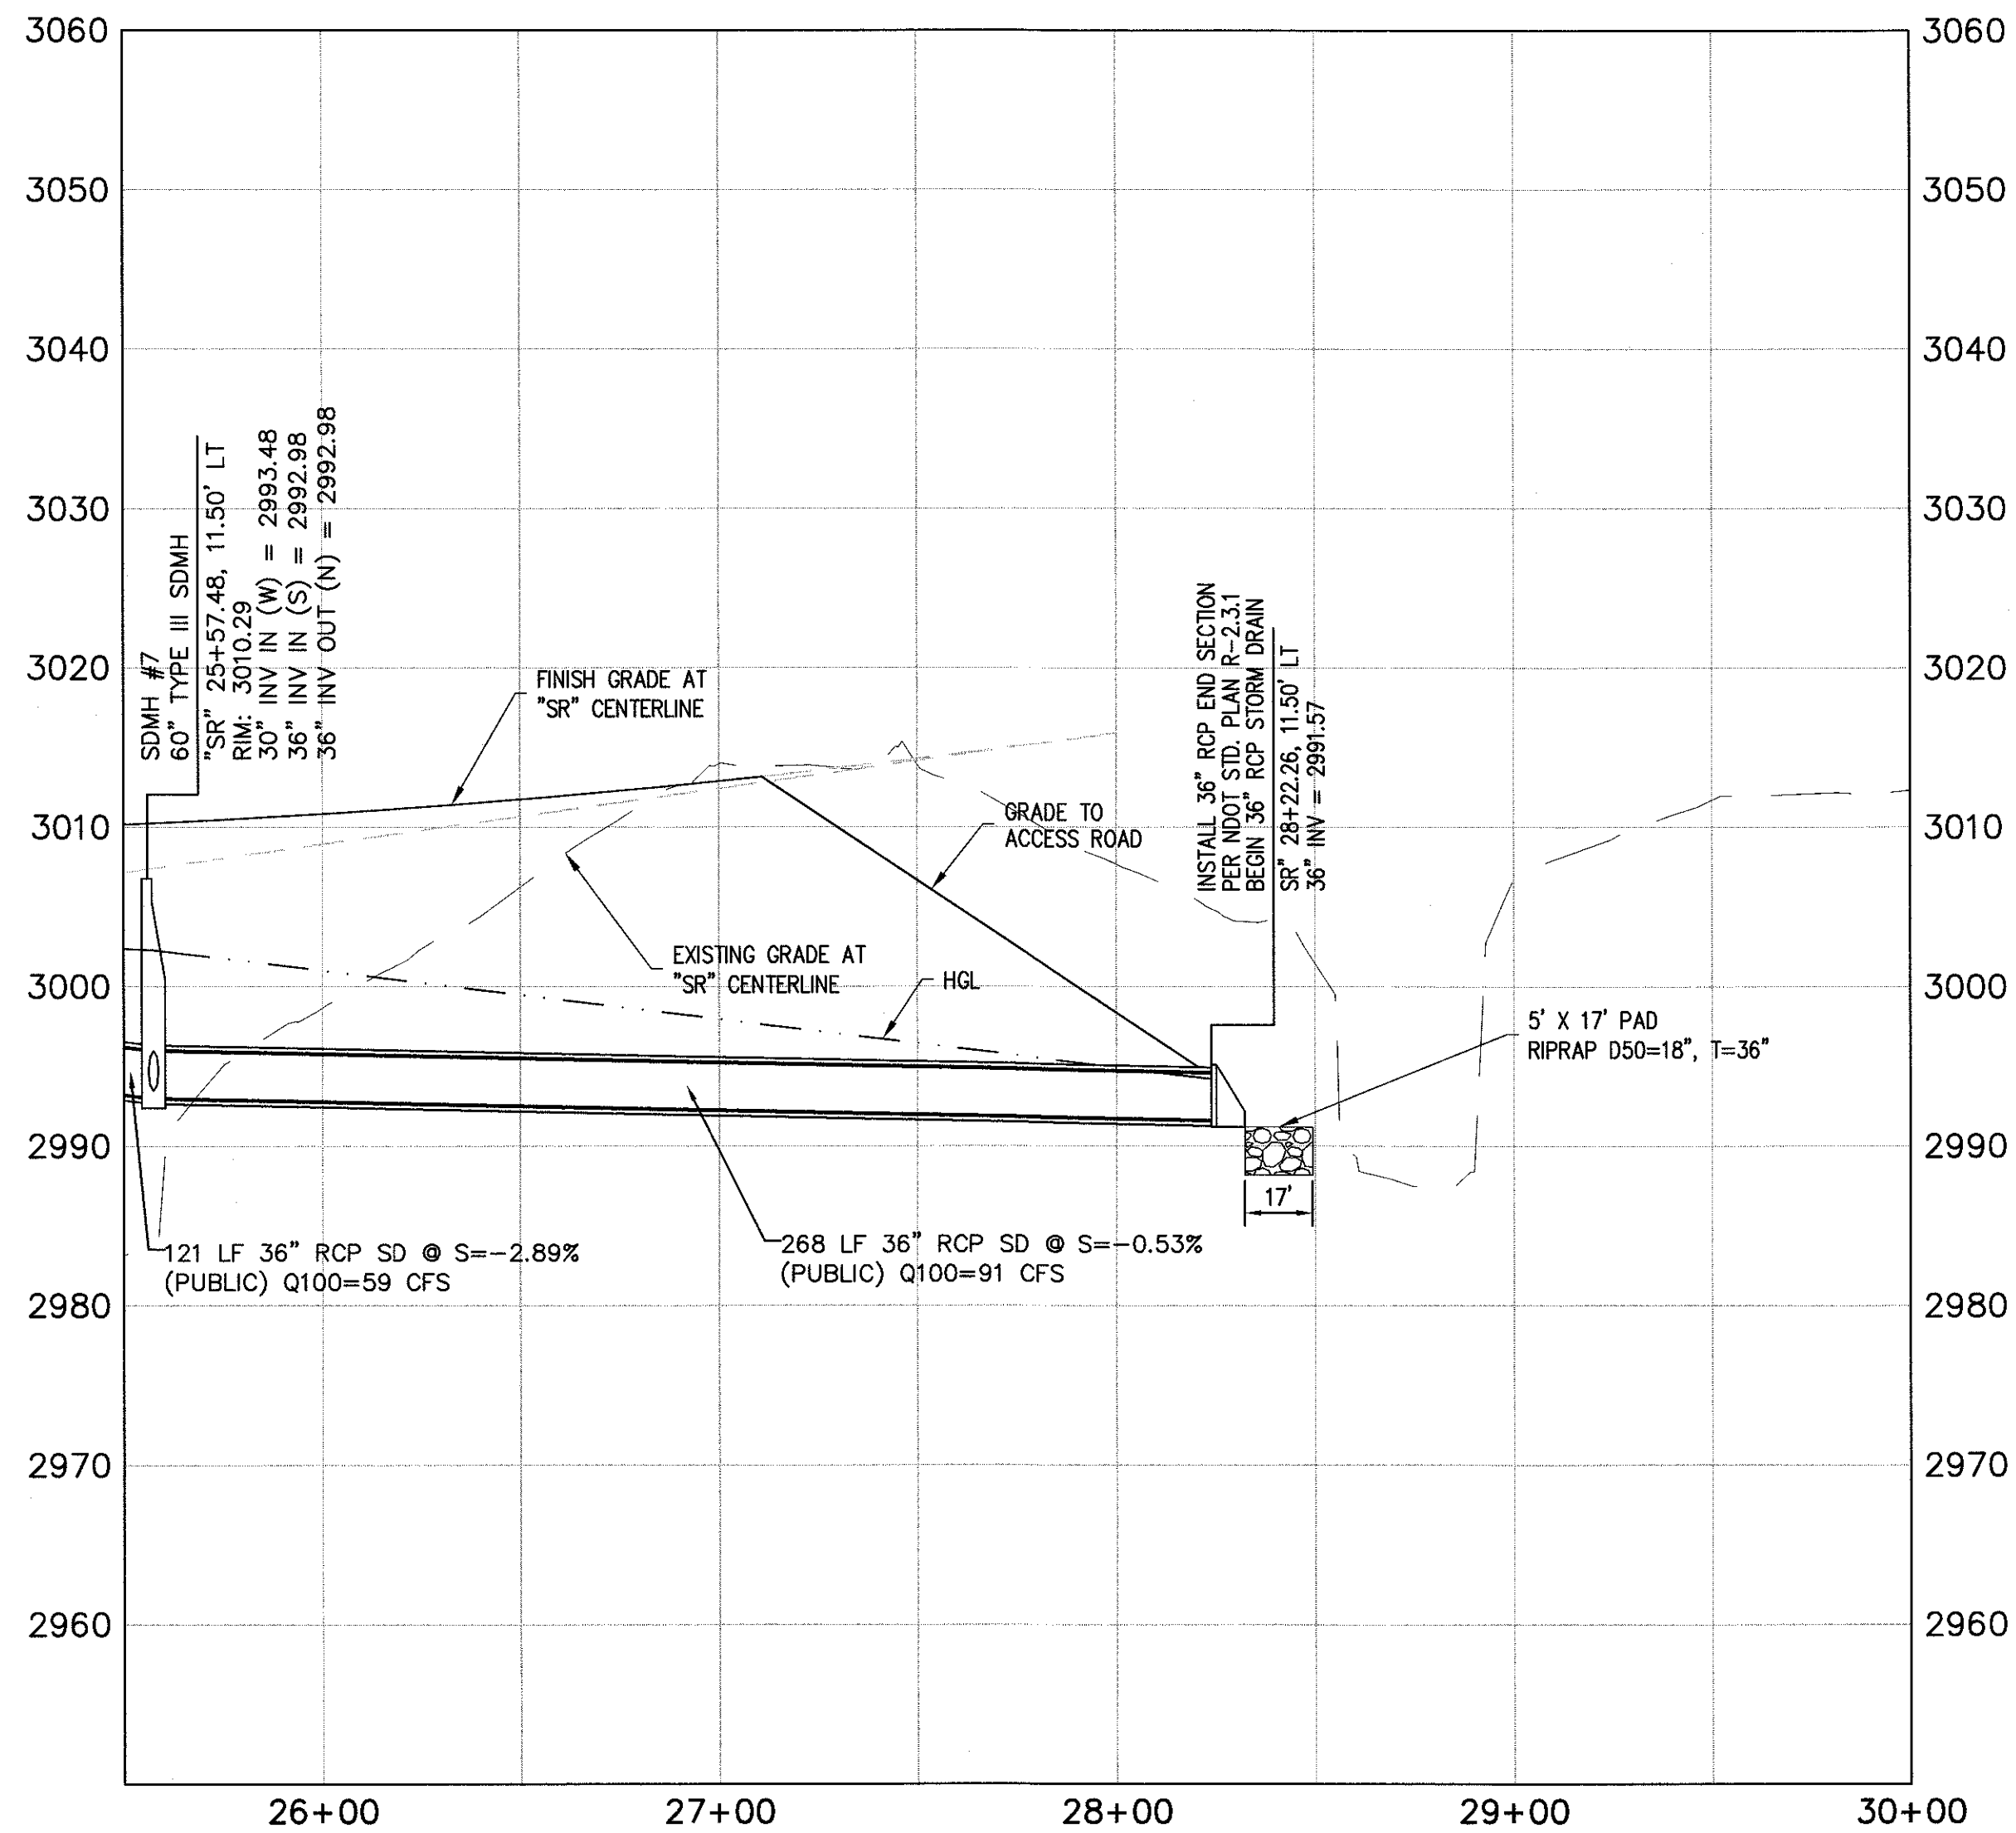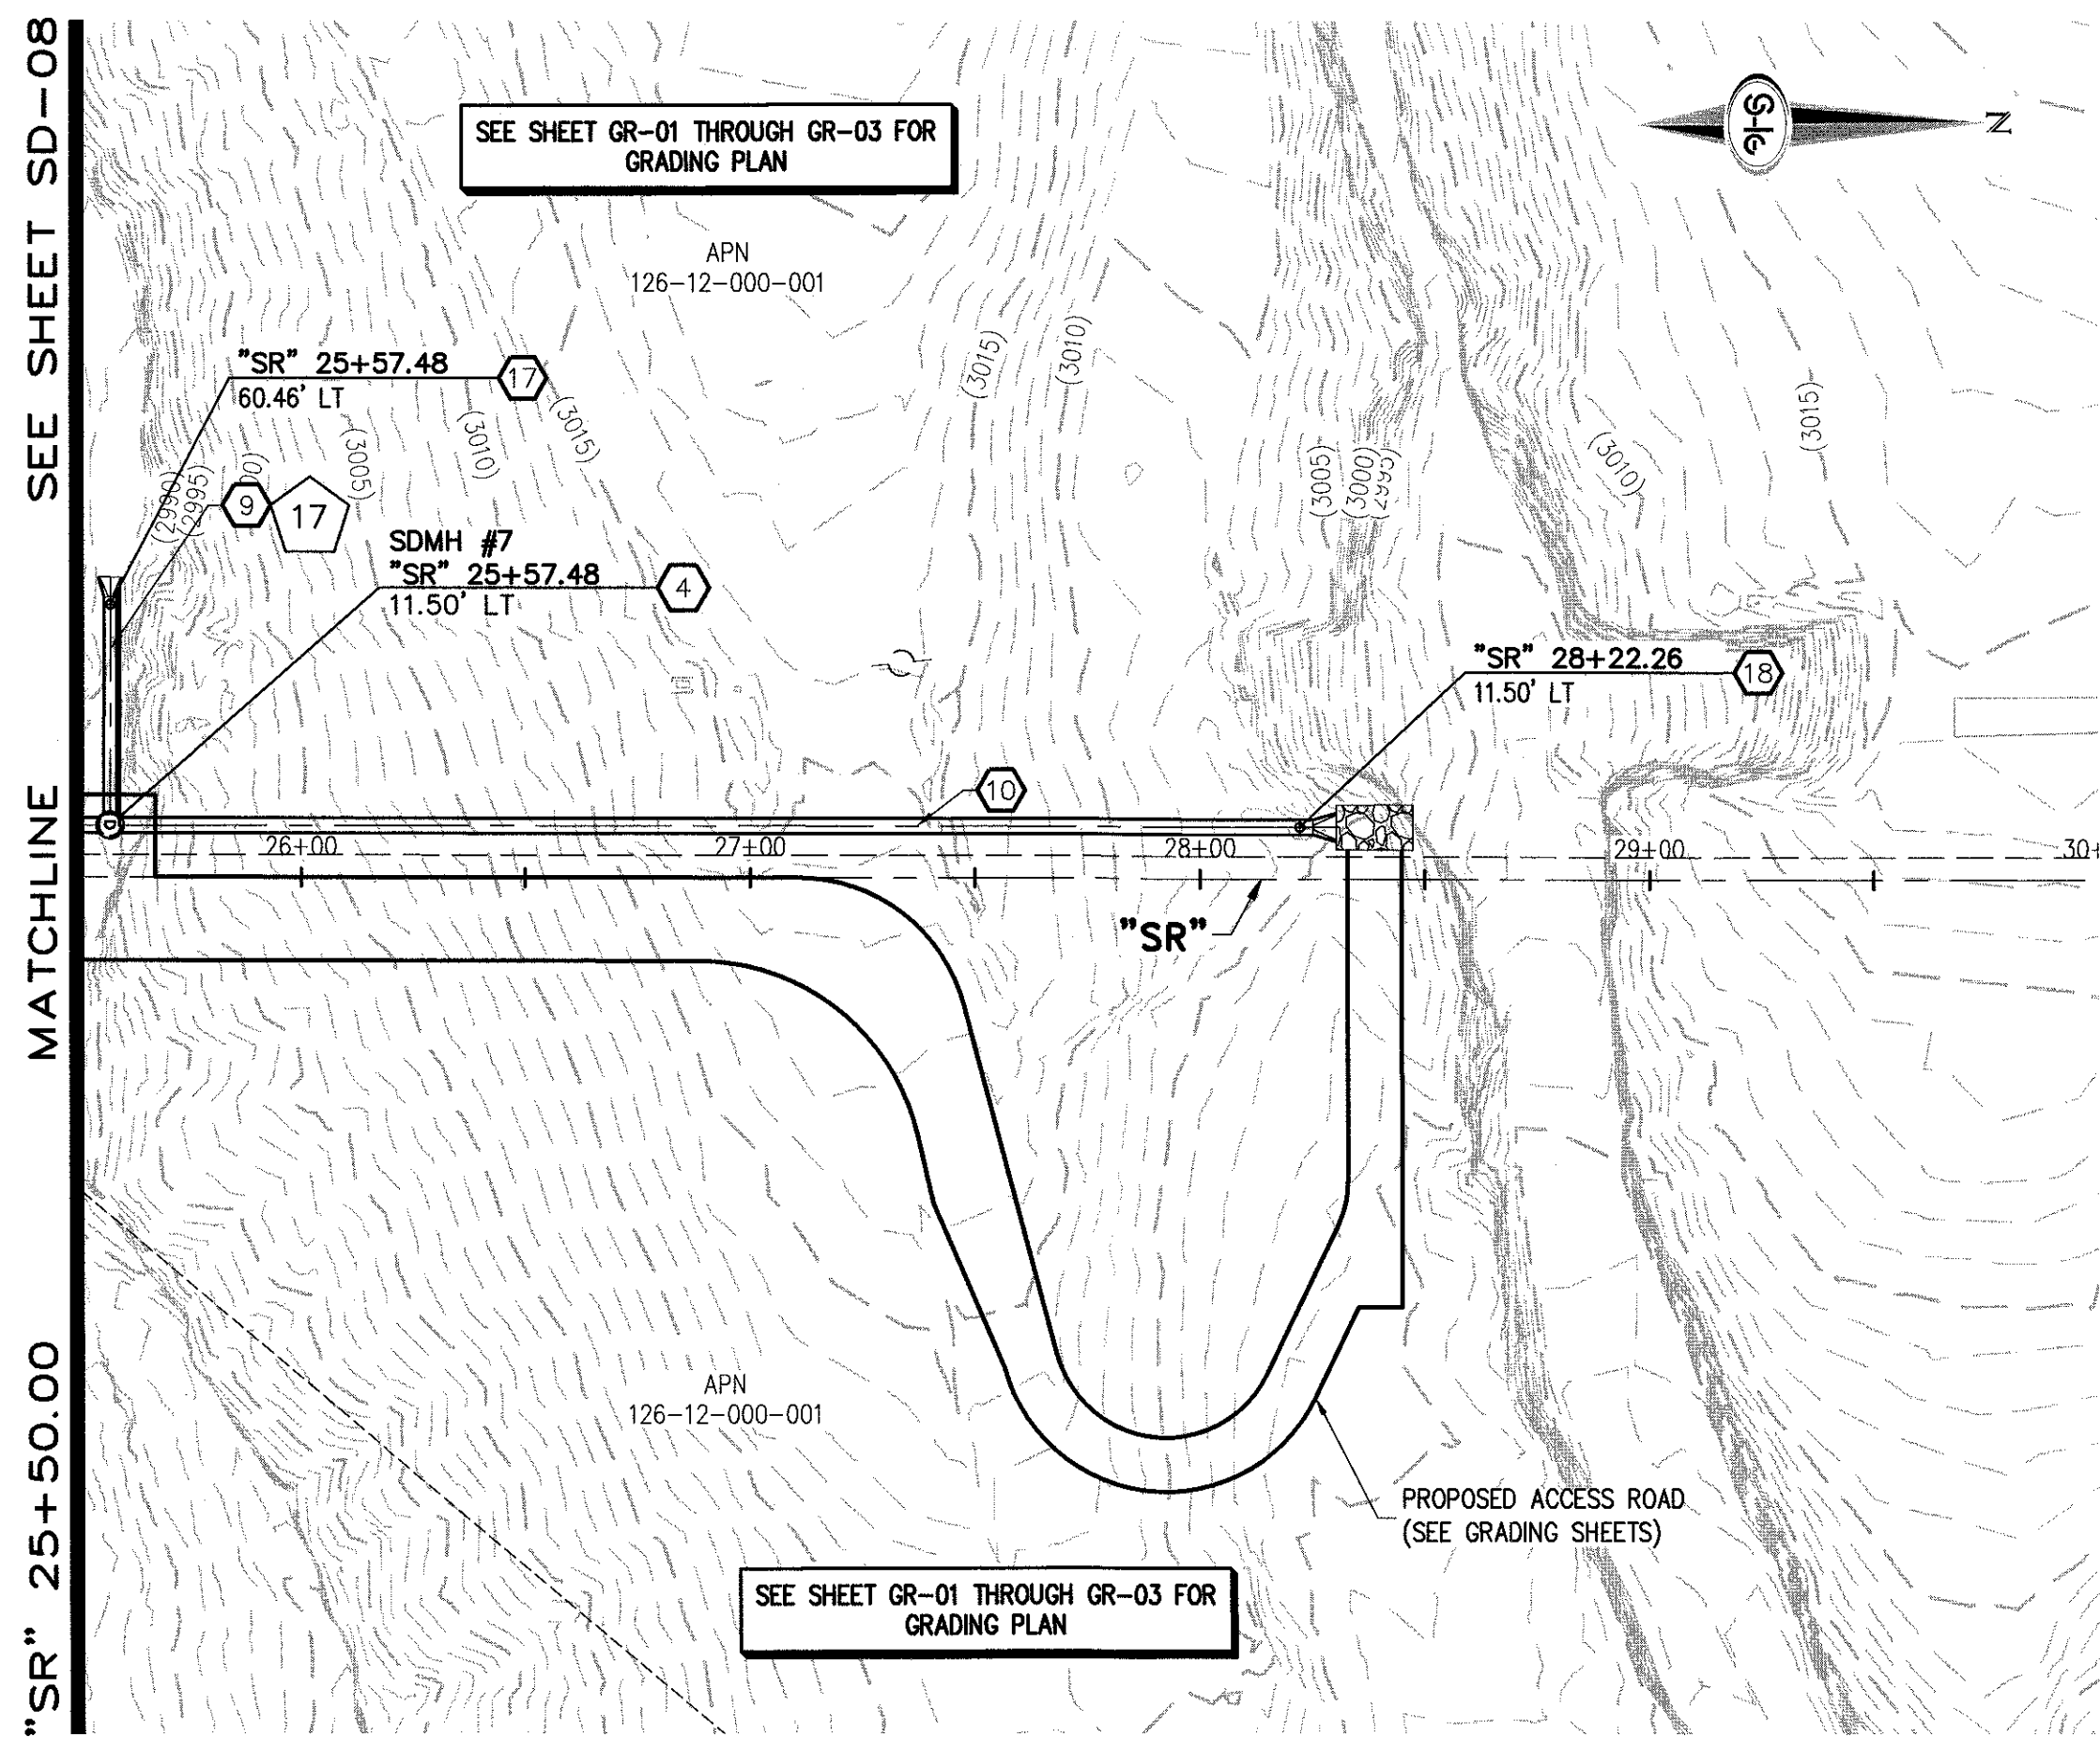

STORM DRAIN NOTES

1. CONSTRUCT TYPE "CM2" DROP INLET (USDCCA STD. DWG. NO. 412.1)
2. REMOVE EXISTING LATERAL STUB AND CONSTRUCT RCB PLUG (SEE DETAIL 5, DRAWING SD-26)
3. CONSTRUCT 60" TYPE I MANHOLE (USDCCA STD. DWG. NO. 403.1)
4. CONSTRUCT 60" TYPE III MANHOLE (USDCCA STD. DWG. NO. 406.1)
5. CONSTRUCT 60" TYPE III MANHOLE WITH TYPE IA RISER (USDCCA STD. DWG. NO. 404.1 AND 406.1)
6. CONSTRUCT NDOT TYPE 4 MANHOLE (NDOT STD. PLAN R-4.3.2)
7. INSTALL 18" RCP (USDCCA STD. DWG. NO. 503.2)
8. INSTALL 24" RCP (USDCCA STD. DWG. NO. 503.2)
9. INSTALL 30" RCP (USDCCA STD. DWG. NO. 503.2)
10. INSTALL 36" RCP (USDCCA STD. DWG. NO. 503.2)
11. INSTALL 42" RCP (USDCCA STD. DWG. NO. 503.2)
12. INSTALL 54" RCP (USDCCA STD. DWG. NO. 503.2)
13. INSTALL 60" RCP (USDCCA STD. DWG. NO. 503.2)
14. INSTALL 66" RCP (USDCCA STD. DWG. NO. 503.2)
15. INSTALL 18" RCP END SECTION (NDOT STD. PLAN R-2.3.1)
16. INSTALL 24" RCP END SECTION (NDOT STD. PLAN R-2.3.1)
17. INSTALL 30" RCP END SECTION (NDOT STD. PLAN R-2.3.1)
18. INSTALL 36" RCP END SECTION (NDOT STD. PLAN R-2.3.1)
19. INSTALL 42" RCP END SECTION (NDOT STD. PLAN R-2.3.1)
20. PIPE PENETRATION (SEE DETAIL 4, DRAWING SD-26)
21. CONSTRUCT CONCRETE COLLAR (SEE DETAIL 2, DRAWING SD-26)
22. CONSTRUCT BRICK AND MORTAR PLUG (SEE DETAIL 1, DRAWING SD-26)
23. INSTALL 48" RCP (USDCCA STD. DWG. NO. 503.2)
24. INSTALL 48" RCP END SECTION (NDOT STD. PLAN R-2.3.1)
25. INSTALL DRIVEWAY (USDCCA STD. DWG. NO. 224)
26. CONSTRUCT TYPE "CM" DROP INLET (USDCCA STD. DWG. NO. 422)

NOTES

1. ALL RCP SHALL BE CLASS III UNLESS OTHERWISE SHOWN.
2. ALL PIPE LENGTHS ARE MEASURED ALONG PIPE CENTERLINE TO CENTER OF MANHOLE OR INSIDE EDGE OF DI OR RCB/RCA.
3. ALL DROP INLETS SHALL INCLUDE STORM WATER MANAGEMENT STAMP AND DETAIL PER USDCCA STD. DWG. NO. 421.
4. SEE STRUCTURAL PLANS FOR ADDITIONAL STRUCTURAL DETAILS AND CONNECTIONS.
5. ALL PIPES ARE PUBLICLY MAINTAINED.
6. ADD SPECIAL INSPECTION REQUIRED FOR PIPE SEGMENTS WITH SACRIFICIAL CONCRETE.

DROP INLET NOTE

WHERE 10 FEET PARALLEL SEPARATION IS NOT PRACTICABLE:
CAST-IN-PLACE MONOLITHIC POUR WITH WATERSTOP BETWEEN SLAB AND WALLS. BASE, WALLS AND TOP TO BE CONSTRUCTED WITH WATERSTOPS, CENTER BUILT, OR FLAT STRIP (VINYLEX, GREENSTREAK PLASTIC PRODUCTS OR APPROVED EQUAL).

LEGEND



STORM DRAIN LATERAL # (SEE SHEETS SD-20 THRU SD-24)

I CERTIFY THAT THIS GRADING PLAN IS IN CONFORMANCE WITH THE APPROVED TECHNICAL DRAINAGE STUDY 05-47354 ON FILE AT THE CITY OF LAS VEGAS FOR THE SUBJECT PROJECT.

JERRY SLATER, P.E. 14167 DATE 3.22.16



FLOOD ZONE



THE PROJECT SITE IS LOCATED WITHIN A FEMA DESIGNATED ZONE "X" (OUTSIDE THE 500-YEAR FLOOD PLAIN) ON THE FLOOD INSURANCE RATE MAP (FIRM) PANEL:32003C1750E, DATED SEPTEMBER 27, 2002.

NOTE:

PROPERTY OWNER IS RESPONSIBLE TO MAINTAIN THE BEST MANAGEMENT PRACTICES, SUCH AS BUT NOT LIMITED TO, THE REMOVAL OF ACCUMULATED SEDIMENT AND DEBRIS AND CARE OF VEGETATION.

KEY MAP

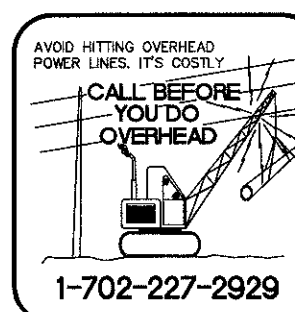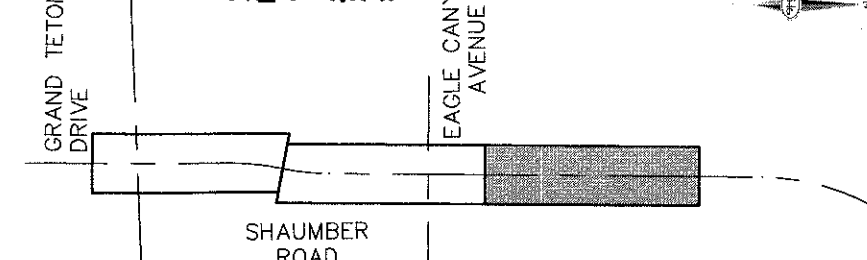

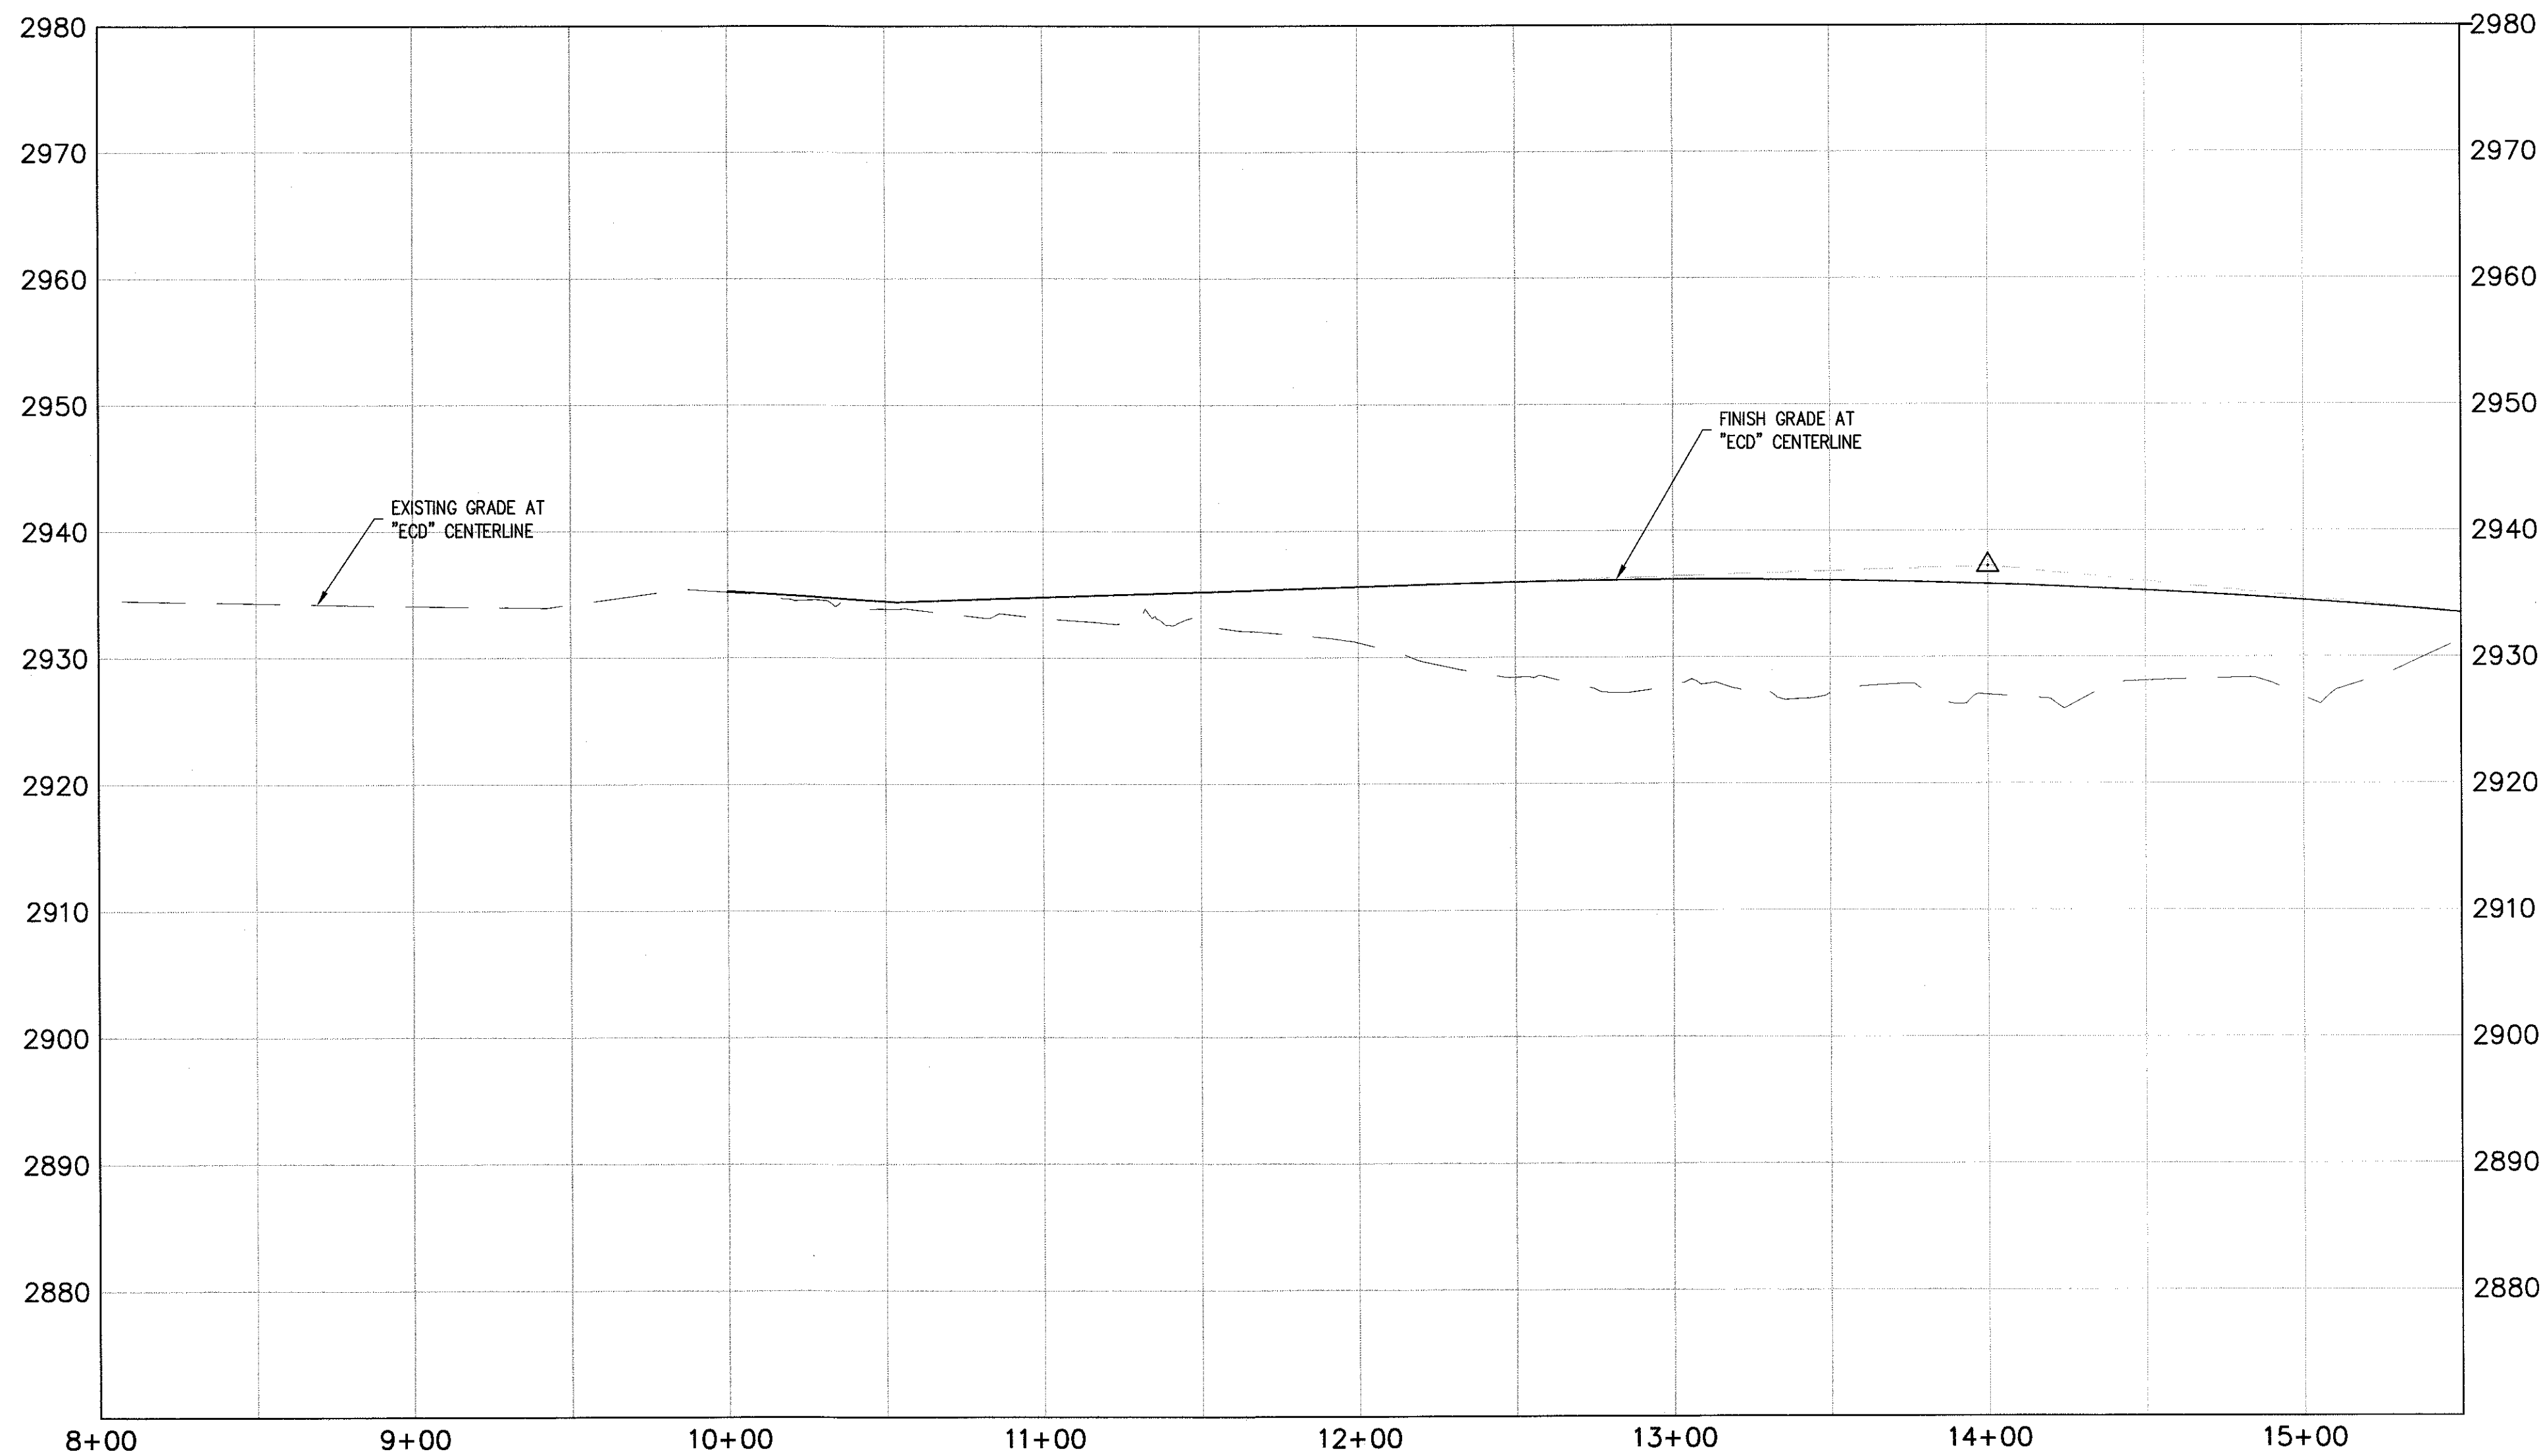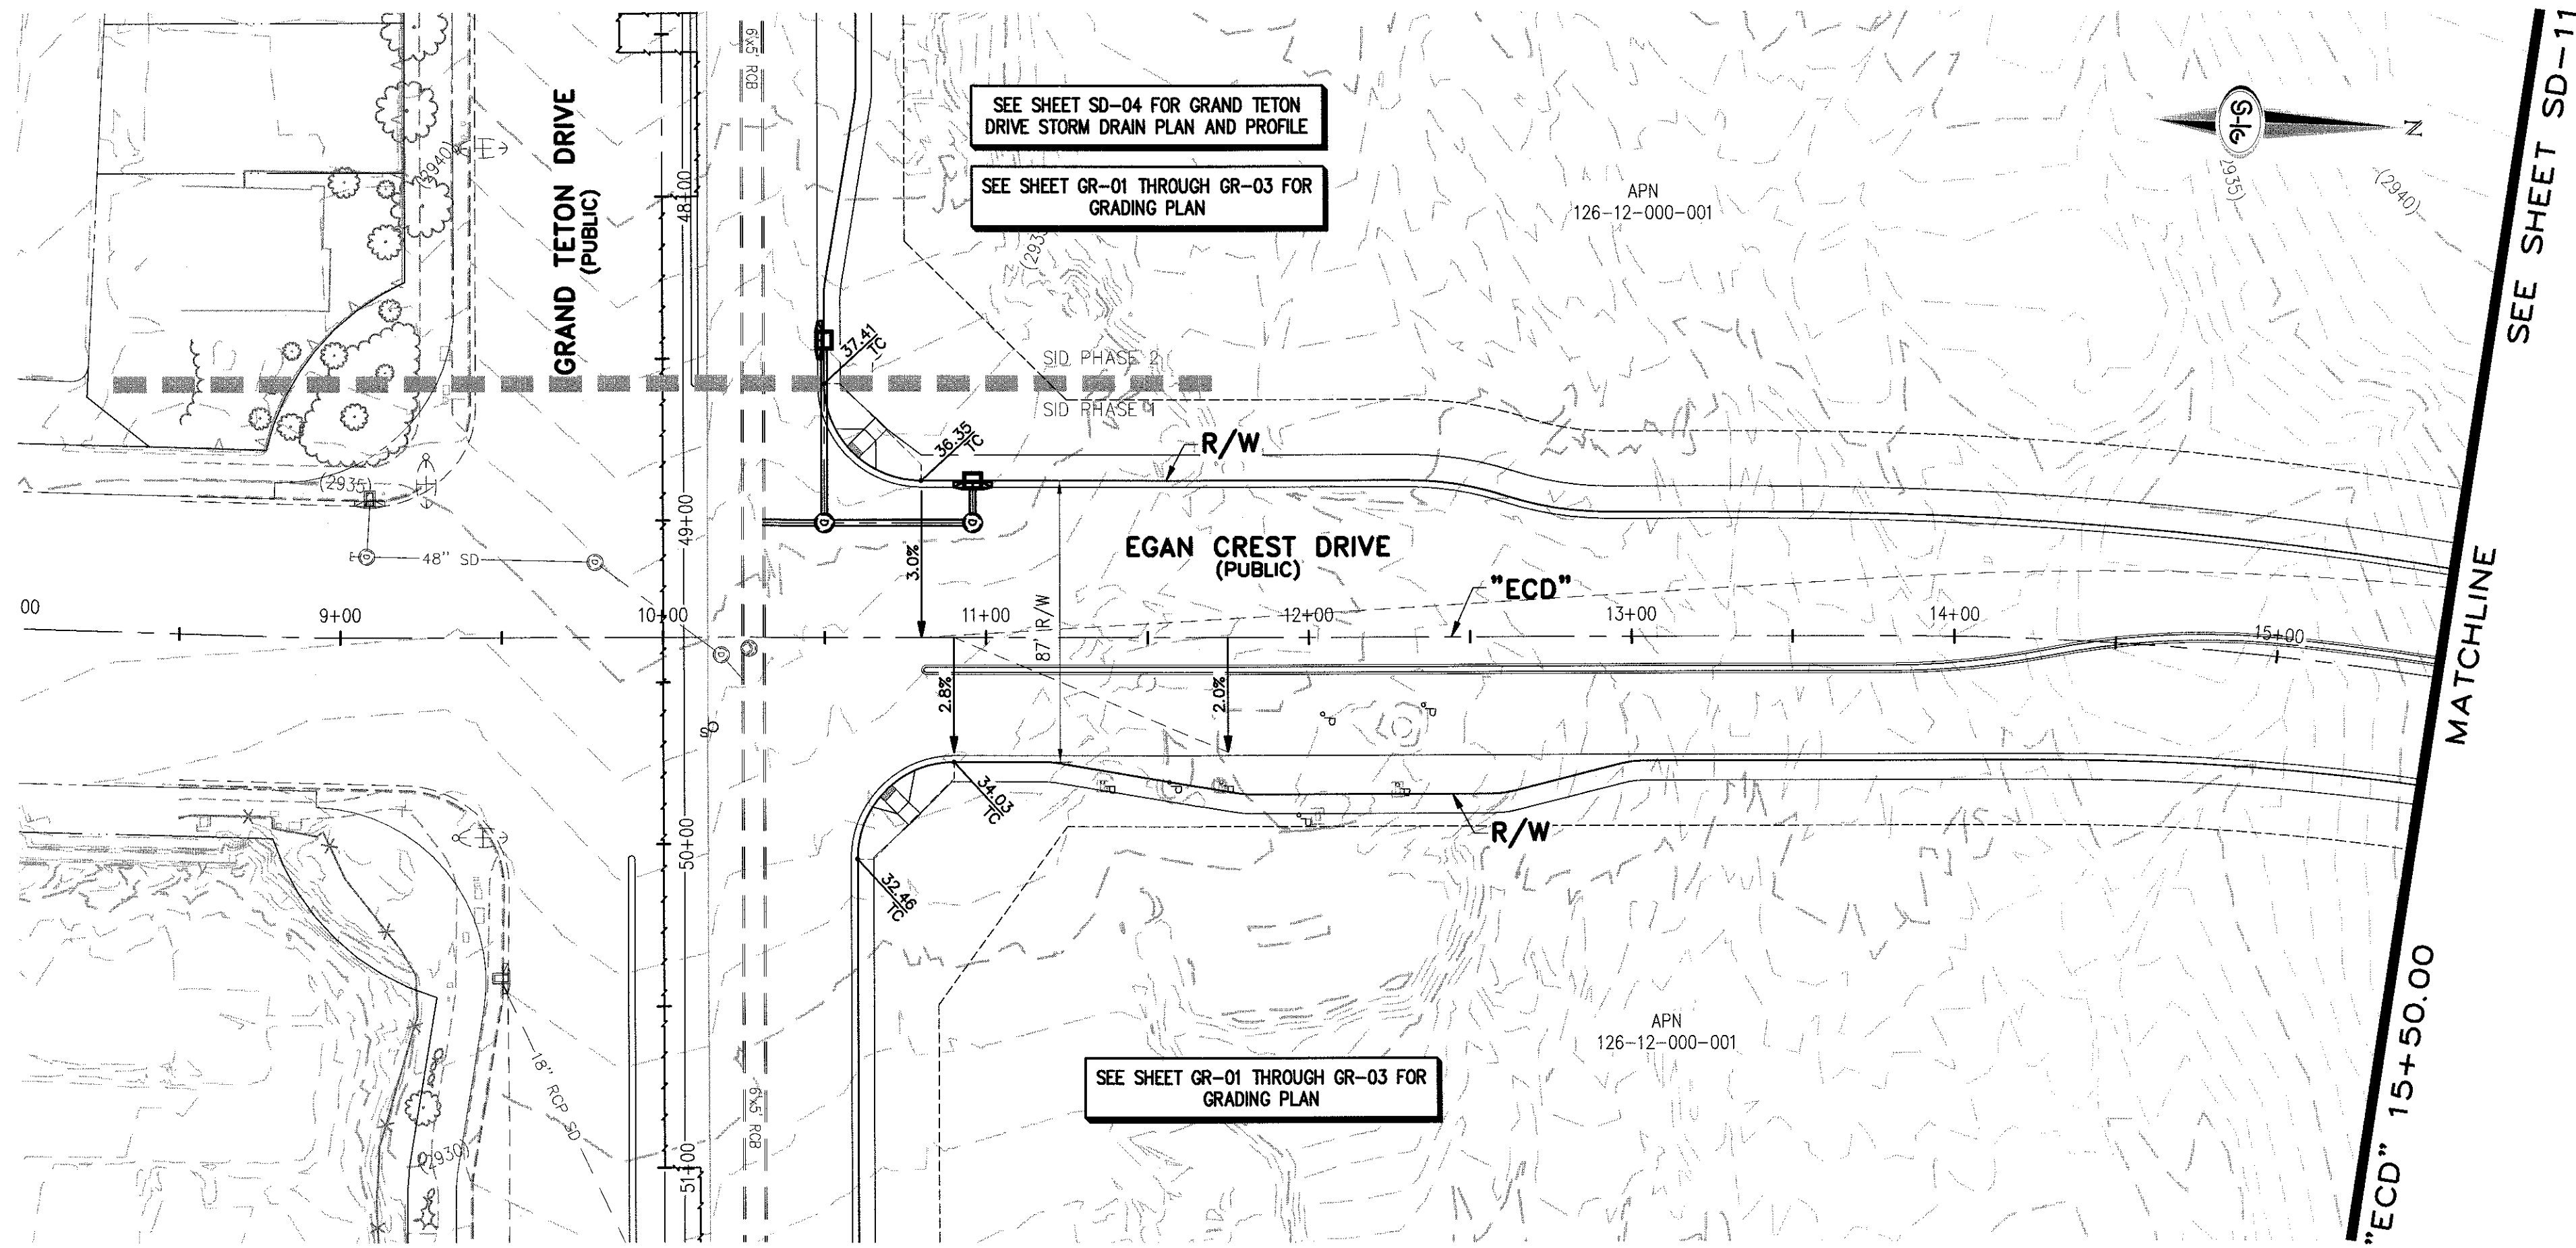

STORM DRAIN NOTES

1. CONSTRUCT TYPE "CM2" DROP INLET (USDCCA STD. DWG. NO. 412.1)
2. REMOVE EXISTING LATERAL STUB AND CONSTRUCT RCB PLUG (SEE DETAIL 5, DRAWING SD-26)
3. CONSTRUCT 60" TYPE I MANHOLE (USDCCA STD. DWG. NO. 403.1)
4. CONSTRUCT 60" TYPE III MANHOLE (USDCCA STD. DWG. NO. 406.1)
5. CONSTRUCT 60" TYPE III MANHOLE WITH TYPE IA RISER (USDCCA STD. DWG. NO. 404.1 AND 406.1)
6. CONSTRUCT NDOT TYPE 4 MANHOLE (NDOT STD. PLAN R-4.3.2)
7. INSTALL 18" RCP (USDCCA STD. DWG. NO. 503.2)
8. INSTALL 24" RCP (USDCCA STD. DWG. NO. 503.2)
9. INSTALL 30" RCP (USDCCA STD. DWG. NO. 503.2)
10. INSTALL 36" RCP (USDCCA STD. DWG. NO. 503.2)
11. INSTALL 42" RCP (USDCCA STD. DWG. NO. 503.2)
12. INSTALL 54" RCP (USDCCA STD. DWG. NO. 503.2)
13. INSTALL 60" RCP (USDCCA STD. DWG. NO. 503.2)
14. INSTALL 66" RCP (USDCCA STD. DWG. NO. 503.2)
15. INSTALL 18" RCP END SECTION (NDOT STD. PLAN R-2.3.1)
16. INSTALL 24" RCP END SECTION (NDOT STD. PLAN R-2.3.1)
17. INSTALL 30" RCP END SECTION (NDOT STD. PLAN R-2.3.1)
18. INSTALL 36" RCP END SECTION (NDOT STD. PLAN R-2.3.1)
19. INSTALL 42" RCP END SECTION (NDOT STD. PLAN R-2.3.1)
20. PIPE PENETRATION (SEE DETAIL 4, DRAWING SD-26)
21. CONSTRUCT CONCRETE COLLAR (SEE DETAIL 2, DRAWING SD-26)
22. CONSTRUCT BRICK AND MORTAR PLUG (SEE DETAIL 1, DRAWING SD-26)
23. INSTALL 48" RCP (USDCCA STD. DWG. NO. 503.2)
24. INSTALL 48" RCP END SECTION (NDOT STD. PLAN R-2.3.1)
25. INSTALL DRIVEWAY (USDCCA STD. DWG. NO. 224)
26. CONSTRUCT TYPE "CM" DROP INLET (USDCCA STD. DWG. NO. 422)

NOTES

1. ALL RCP SHALL BE CLASS III UNLESS OTHERWISE SHOWN.
2. ALL PIPE LENGTHS ARE MEASURED ALONG PIPE CENTERLINE TO CENTER OF MANHOLE OR INSIDE EDGE OF DI OR RCB/RCA.
3. ALL DROP INLETS SHALL INCLUDE STORM WATER MANAGEMENT STAMP AND DETAIL PER USDCCA STD. DWG. NO. 421.
4. SEE STRUCTURAL PLANS FOR ADDITIONAL STRUCTURAL DETAILS AND CONNECTIONS.
5. ALL PIPES ARE PUBLICLY MAINTAINED.
6. ADD SPECIAL INSPECTION REQUIRED FOR PIPE SEGMENTS WITH SACRIFICIAL CONCRETE.

DROP INLET NOTE

WHERE 10 FEET PARALLEL SEPARATION IS NOT PRACTICABLE:
CAST-IN-PLACE MONOLITHIC POUR WITH WATERSTOP BETWEEN SLAB AND WALLS.
BASE, WALLS AND TOP TO BE CONSTRUCTED WITH WATERSTOPS, CENTER BULB,
OR FLAT STRIP (VINYLEX, GREENSTREAK PLASTIC PRODUCTS OR APPROVED EQUAL).

LEGEND



STORM DRAIN LATERAL # (SEE SHEETS SD-20 THRU SD-24)




I CERTIFY THAT THIS GRADING PLAN IS IN
CONFORMANCE WITH THE APPROVED TECHNICAL
DRAINAGE STUDY DS-4739A ON FILE AT THE CITY
OF LAS VEGAS FOR THE SUBJECT PROJECT
JERRY SLATER, P.E. 14167
DATE 3-22-24



FLOOD ZONE

THE PROJECT SITE IS LOCATED WITHIN A FEMA
DESIGNATED ZONE "X" (OUTSIDE THE 500-YEAR
FLOOD PLAIN) ON THE FLOOD INSURANCE RATE
MAP (FIRM) PANEL: 32003C1750E, DATED
SEPTEMBER 27, 2002

NOTE:

PROPERTY OWNER IS RESPONSIBLE TO MAINTAIN THE BEST MANAGEMENT PRACTICES,
SUCH AS BUT NOT LIMITED TO, THE REMOVAL OF ACCUMULATED SEDIMENT AND DEBRIS
AND CARE OF VEGETATION.

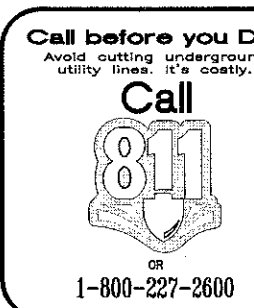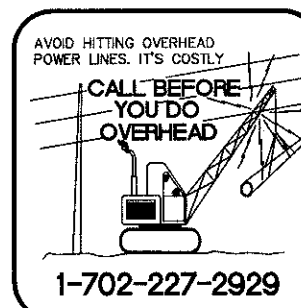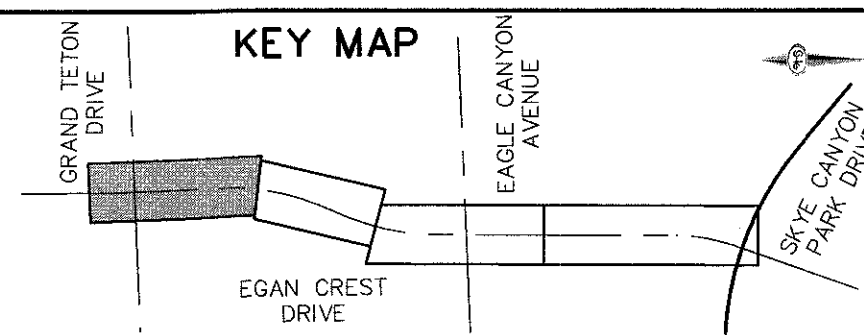

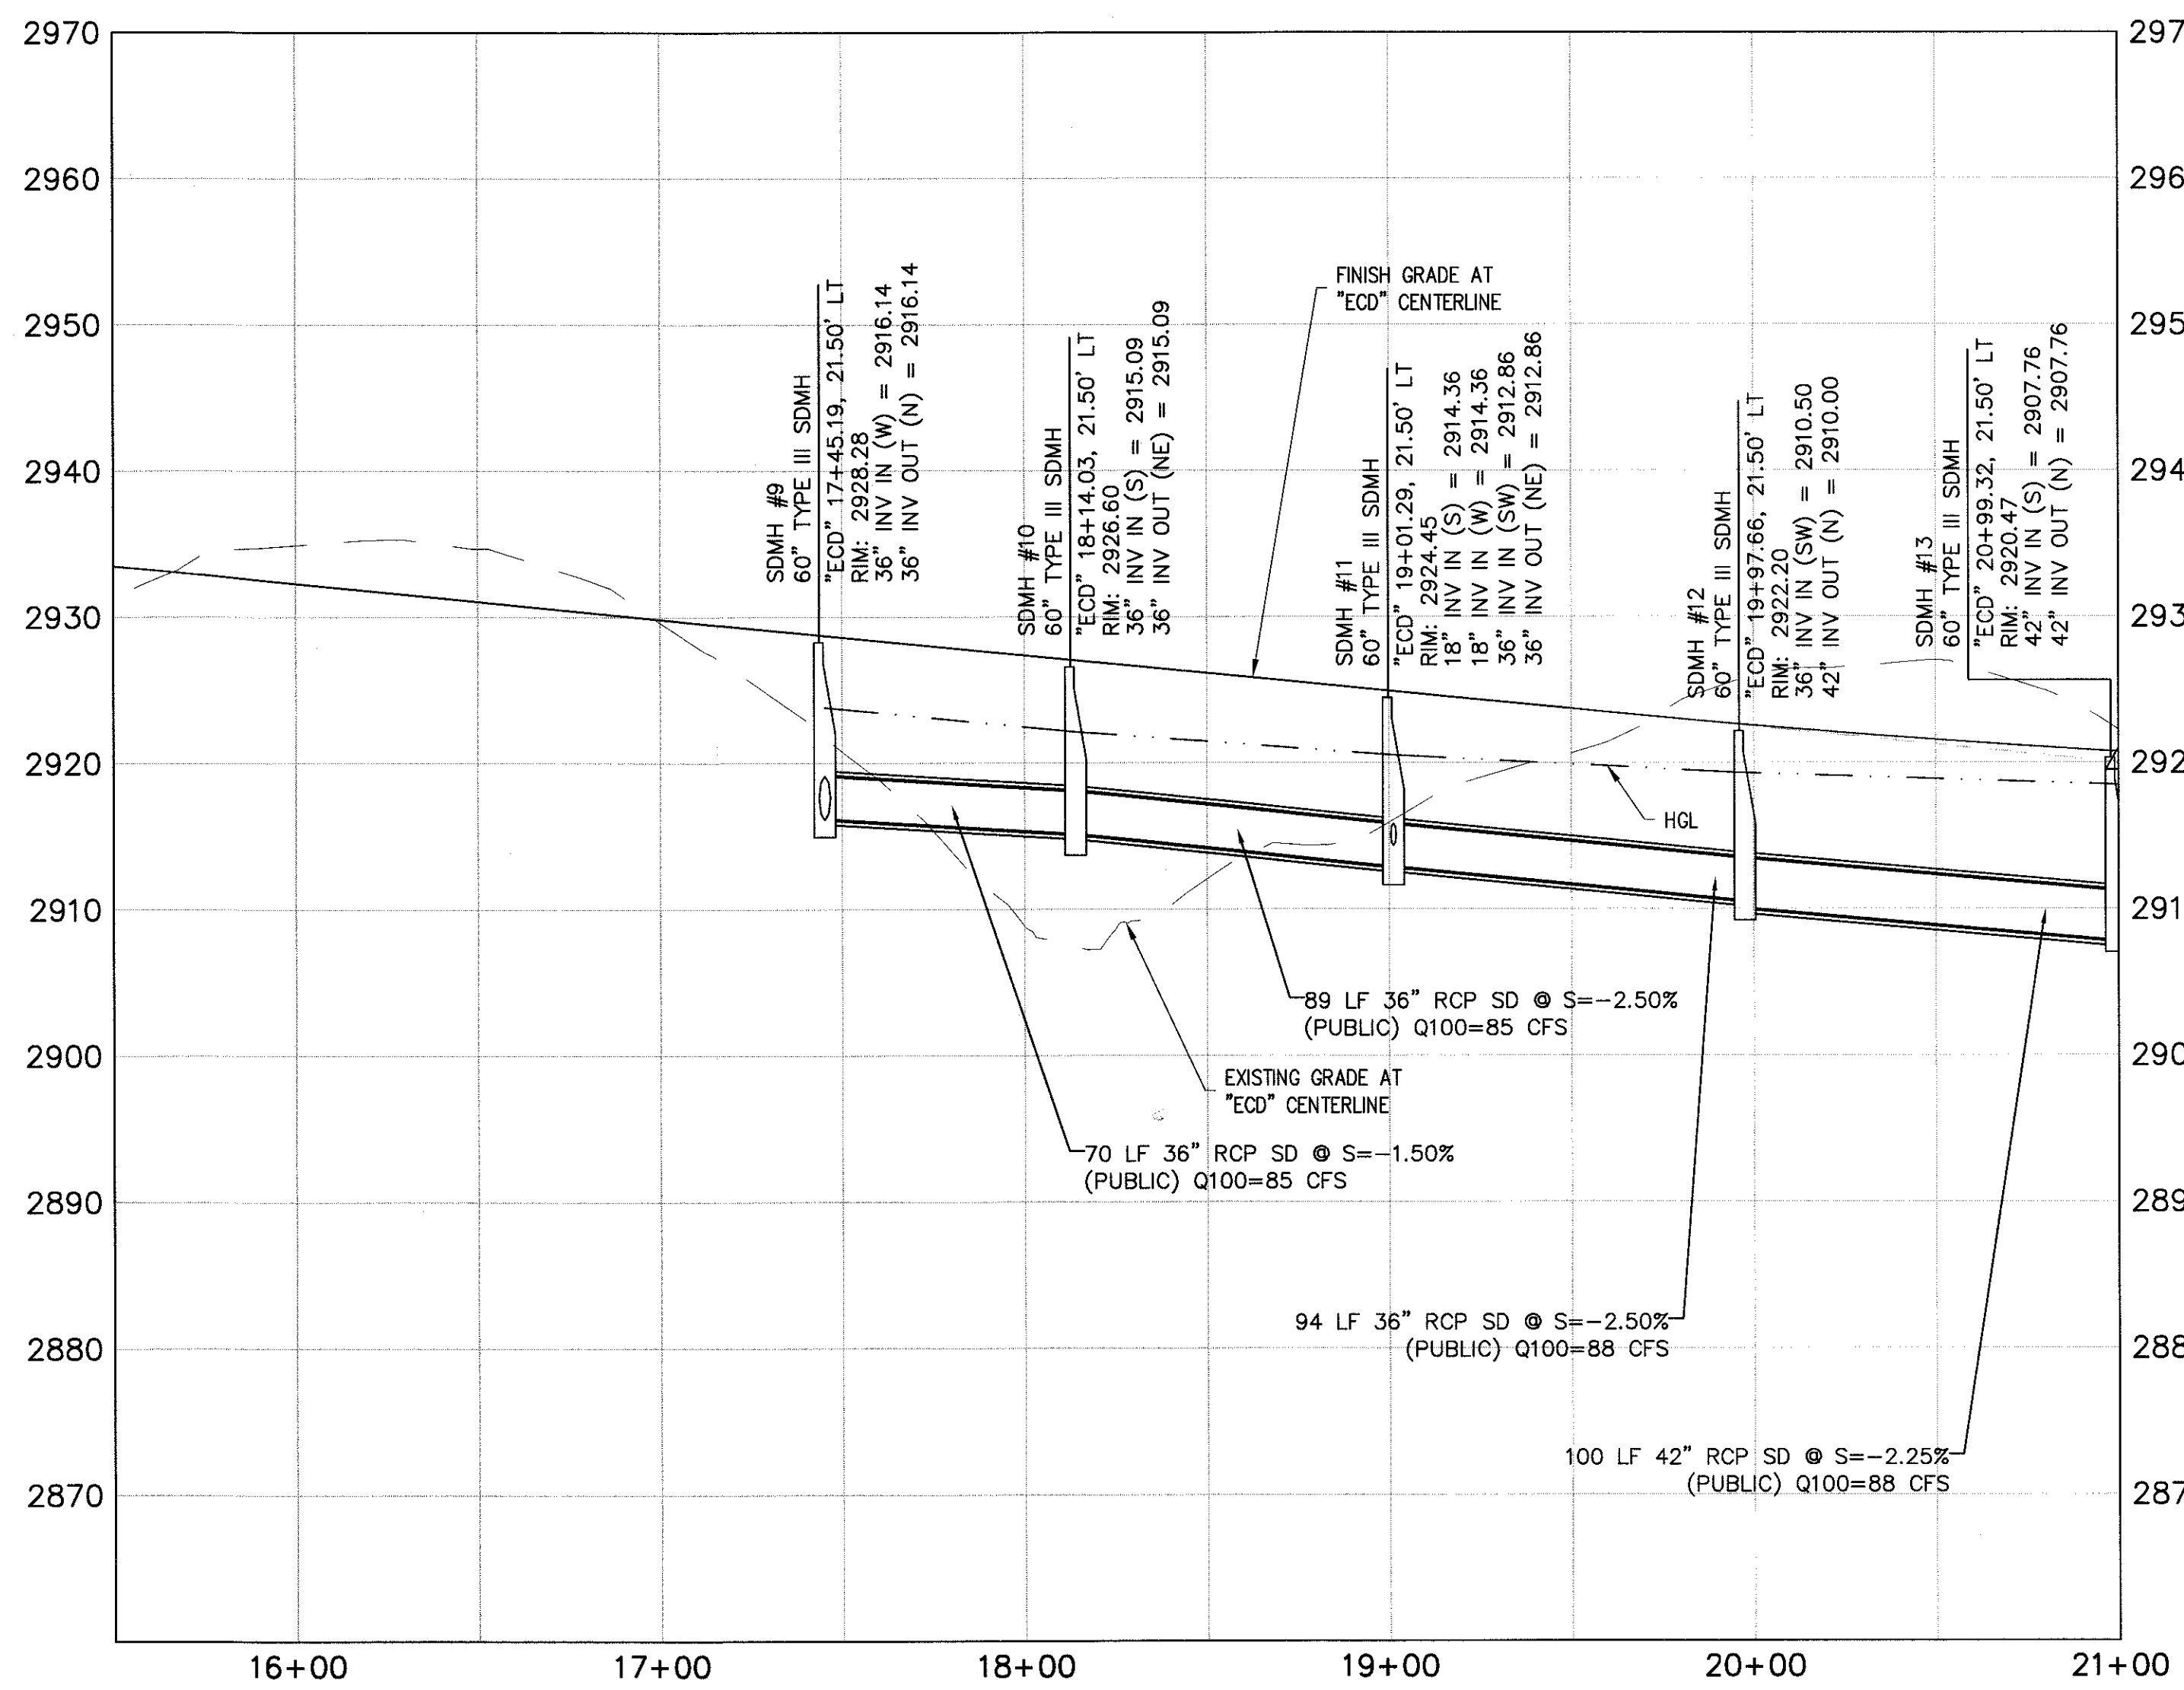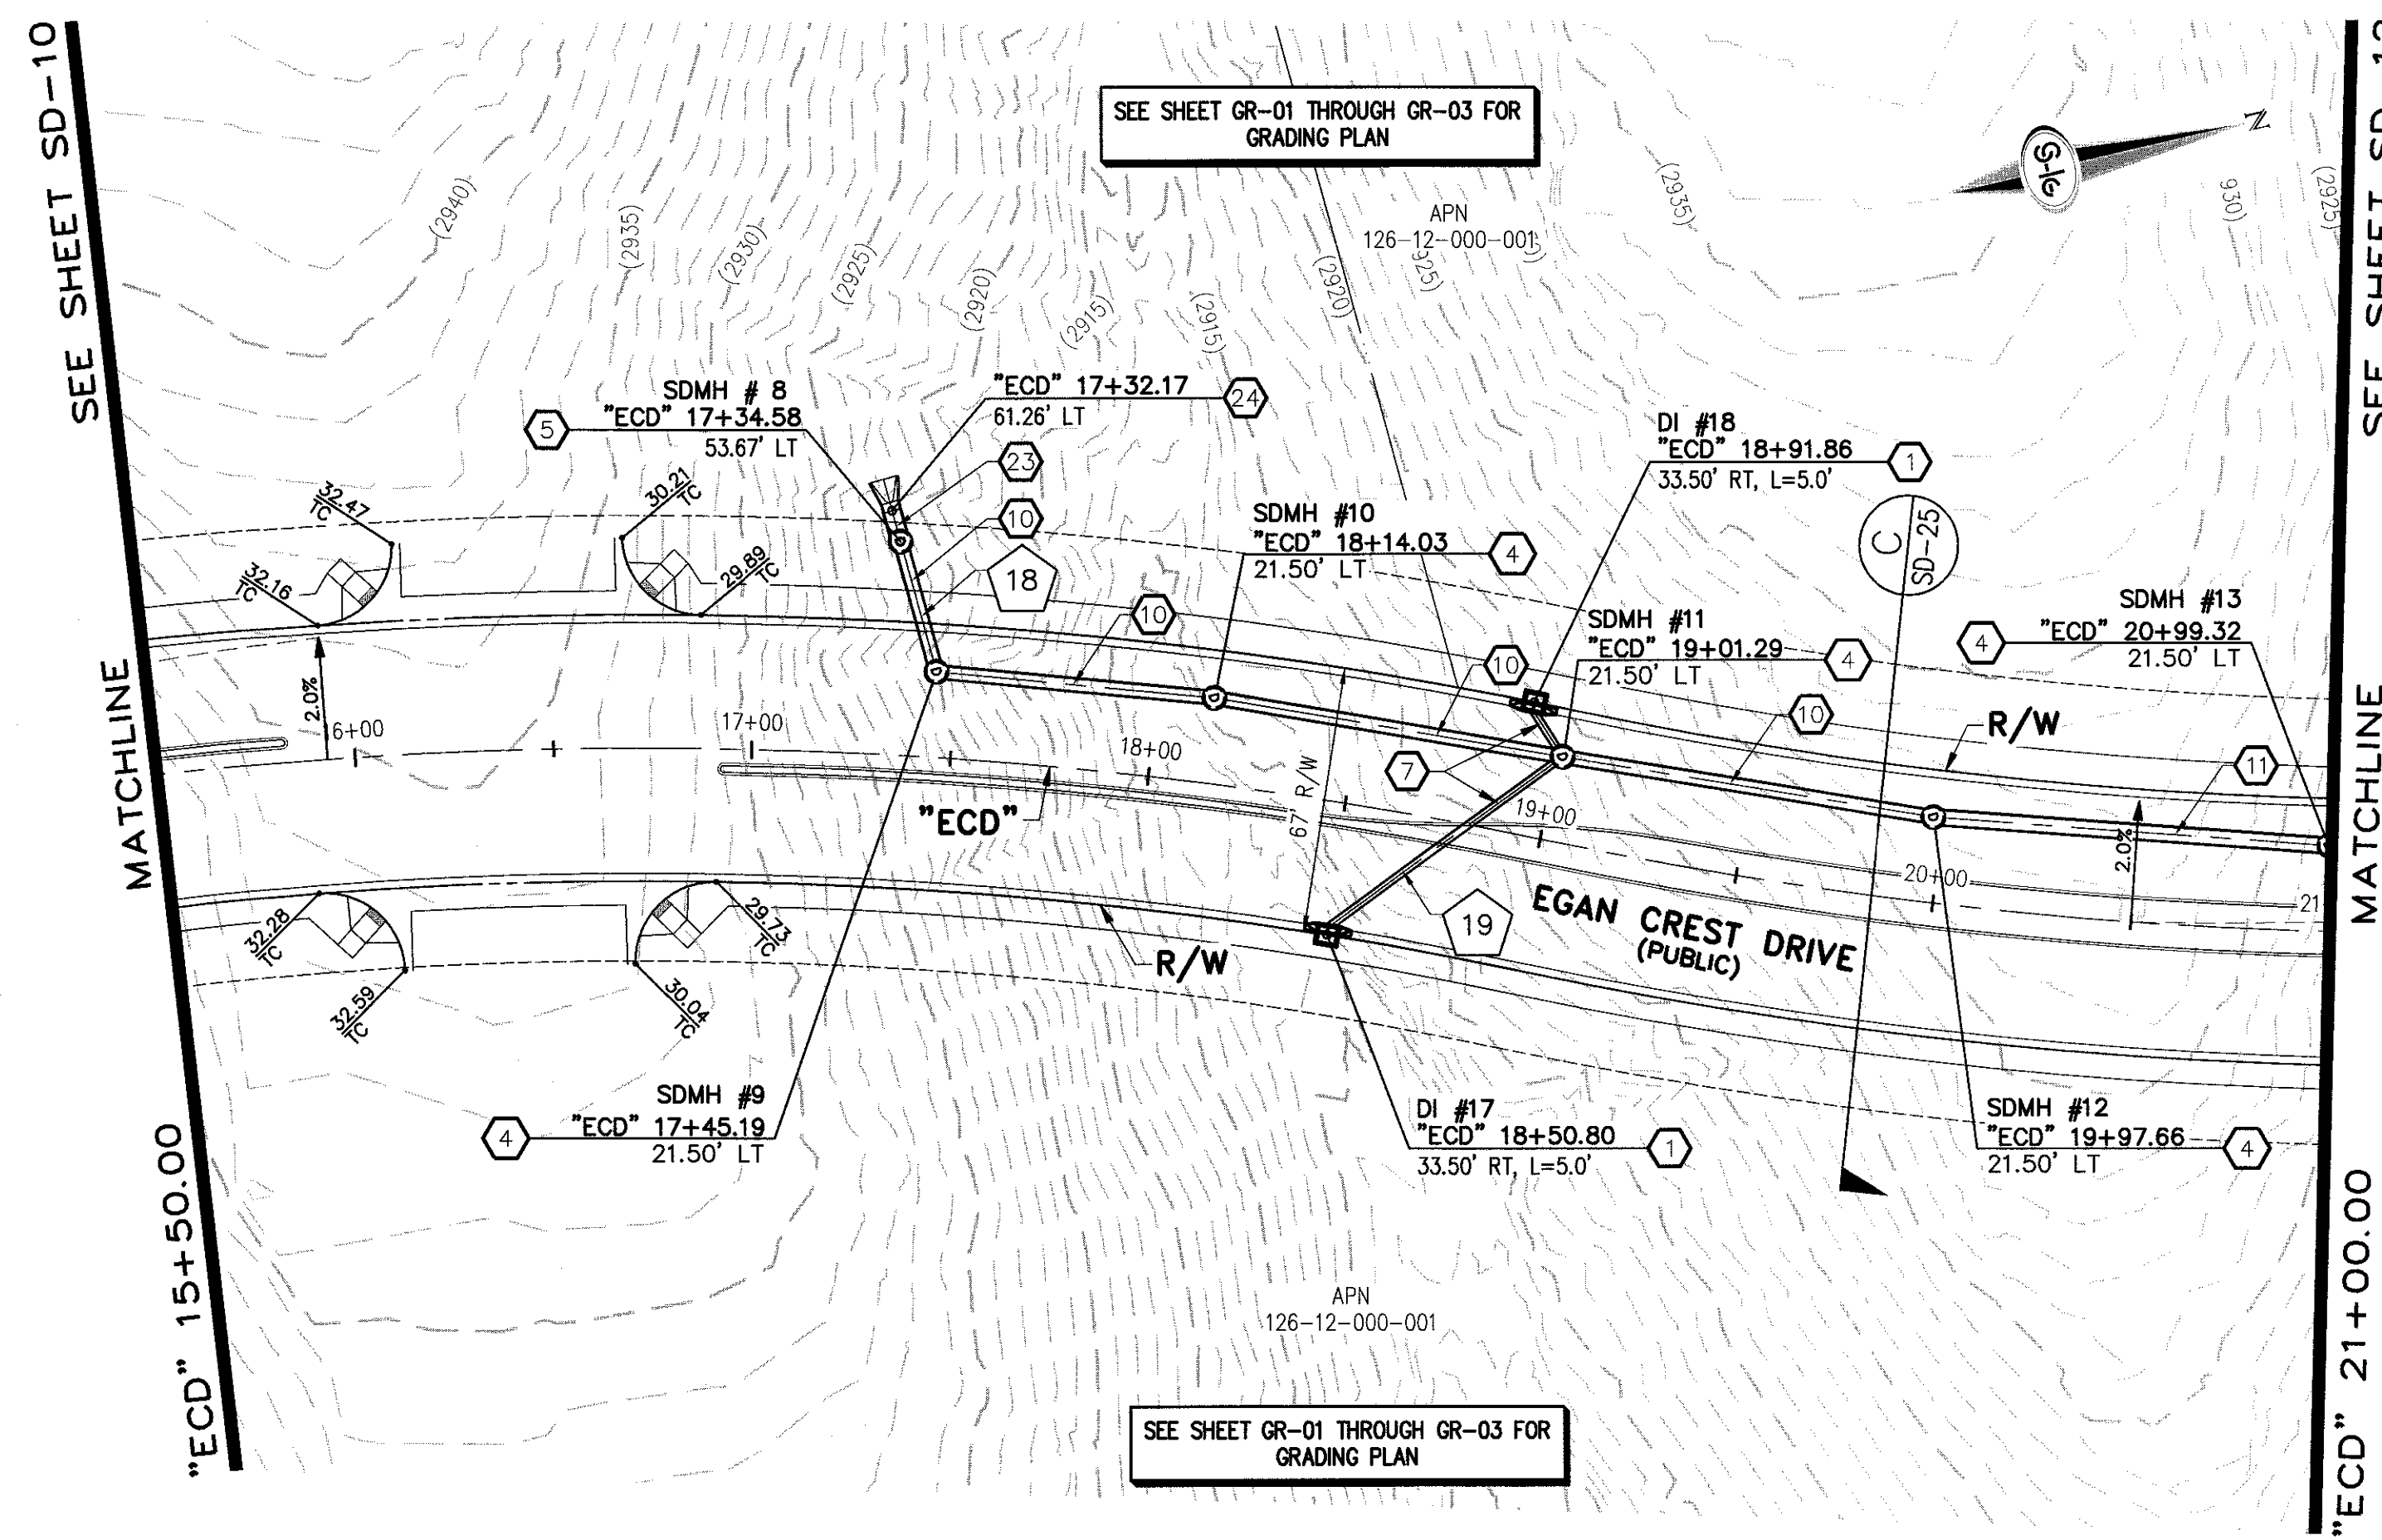

STORM DRAIN NOTES

- CONSTRUCT TYPE "CM2" DROP INLET (USDCCA STD. DWG. NO. 412.1)
- REMOVE EXISTING LATERAL STUB AND CONSTRUCT RCB PLUG (SEE DETAIL 5, DRAWING SD-26)
- CONSTRUCT 60" TYPE I MANHOLE (USDCCA STD. DWG. NO. 403.1)
- CONSTRUCT 60" TYPE III MANHOLE (USDCCA STD. DWG. NO. 406.1)
- CONSTRUCT 60" TYPE III MANHOLE WITH TYPE IA RISER (USDCCA STD. DWG. NO. 404.1 AND 406.1)
- CONSTRUCT NDOT TYPE 4 MANHOLE (NDOT STD. PLAN R-4.3.2)
- INSTALL 18" RCP (USDCCA STD. DWG. NO. 503.2)
- INSTALL 24" RCP (USDCCA STD. DWG. NO. 503.2)
- INSTALL 30" RCP (USDCCA STD. DWG. NO. 503.2)
- INSTALL 36" RCP (USDCCA STD. DWG. NO. 503.2)
- INSTALL 42" RCP (USDCCA STD. DWG. NO. 503.2)
- INSTALL 54" RCP (USDCCA STD. DWG. NO. 503.2)
- INSTALL 60" RCP (USDCCA STD. DWG. NO. 503.2)
- INSTALL 66" RCP (USDCCA STD. DWG. NO. 503.2)
- INSTALL 18" RCP END SECTION (NDOT STD. PLAN R-2.3.1)
- INSTALL 24" RCP END SECTION (NDOT STD. PLAN R-2.3.1)
- INSTALL 30" RCP END SECTION (NDOT STD. PLAN R-2.3.1)
- INSTALL 36" RCP END SECTION (NDOT STD. PLAN R-2.3.1)
- INSTALL 42" RCP END SECTION (NDOT STD. PLAN R-2.3.1)
- PIPE PENETRATION (SEE DETAIL 4, DRAWING SD-26)
- CONSTRUCT CONCRETE COLLAR (SEE DETAIL 2, DRAWING SD-26)
- CONSTRUCT BRICK AND MORTAR PLUG (SEE DETAIL 1, DRAWING SD-26)
- INSTALL 48" RCP (USDCCA STD. DWG. NO. 503.2)
- INSTALL 48" RCP END SECTION (NDOT STD. PLAN R-2.3.1)
- INSTALL DRIVEWAY (USDCCA STD. DWG. NO. 224)
- CONSTRUCT TYPE "CM" DROP INLET (USDCCA STD. DWG. NO. 422)

NOTES

- ALL RCP SHALL BE CLASS III UNLESS OTHERWISE SHOWN.
- ALL PIPE LENGTHS ARE MEASURED ALONG PIPE CENTERLINE TO CENTER OF MANHOLE OR INSIDE EDGE OF DI OR RCB/RCA.
- ALL DROP INLETS SHALL INCLUDE STORM WATER MANAGEMENT STAMP AND DETAIL PER USDCCA STD. DWG. NO. 421.
- SEE STRUCTURAL PLANS FOR ADDITIONAL STRUCTURAL DETAILS AND CONNECTIONS.
- ALL PIPES ARE PUBLICLY MAINTAINED.
- ADD SPECIAL INSPECTION REQUIRED FOR PIPE SEGMENTS WITH SACRIFICIAL CONCRETE.

DROP INLET NOTE

WHERE 10 FEET PARALLEL SEPARATION IS NOT PRACTICABLE:
CAST-IN-PLACE MONOLITHIC POUR WITH WATERSTOP BETWEEN SLAB AND WALLS. BASE, WALLS AND TOP TO BE CONSTRUCTED WITH WATERSTOPS, CENTER BULB, OR FLAT STRIP (VINYLEX, GREENSTREAK PLASTIC PRODUCTS OR APPROVED EQUAL).

LEGEND

- 1 STORM DRAIN LATERAL # (SEE SHEETS SD-20 THRU SD-24)


FLOOD ZONE

I CERTIFY THAT THIS GRADING PLAN IS IN CONFORMANCE WITH THE APPROVED TECHNICAL DRAINAGE STUDY DS-4739A ON FILE AT THE CITY OF LAS VEGAS FOR THE SUBJECT PROJECT.

JERRY SLATER, P.E. 14167 DATE 3/11/15

THE PROJECT SITE IS LOCATED WITHIN A FEMA DESIGNATED ZONE "X" (OUTSIDE THE 500-YEAR FLOOD PLAIN) ON THE FLOOD INSURANCE RATE MAP (FIRM) PANEL: 32003C1750E, DATED SEPTEMBER 27, 2002.

NOTE:
PROPERTY OWNER IS RESPONSIBLE TO MAINTAIN THE BEST MANAGEMENT PRACTICES, SUCH AS BUT NOT LIMITED TO, THE REMOVAL OF ACCUMULATED SEDIMENT AND DEBRIS AND CARE OF VEGETATION.

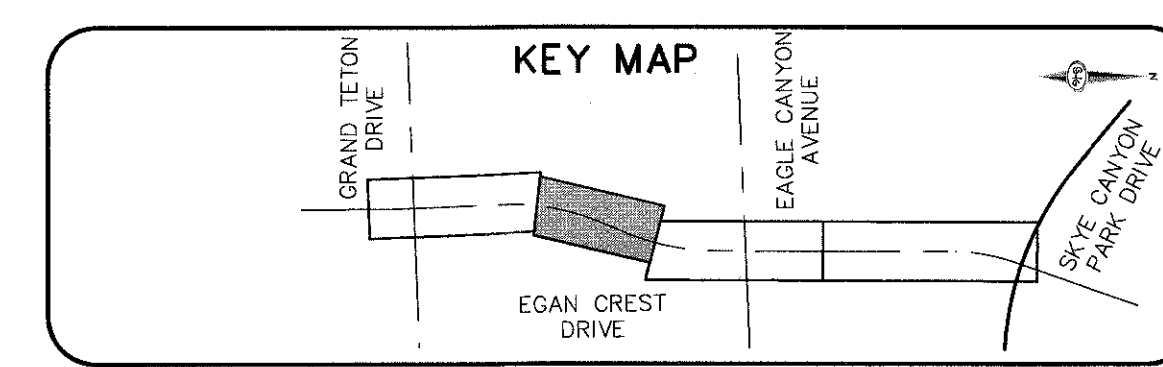

40 0 40 80
SCALE FEET

AVOID HITTING OVERHEAD POWER LINES. IT'S COSTLY.
CALL BEFORE YOU DIG
1-702-227-2929

FAST
Call before you dig
1-702-432-6300
UTILITY AND INTERIOR SYSTEMS OF TRANSPORTATION

Call before you dig
1-800-227-2600



SLATER HANIFAN GROUP
CONSULTING ENGINEERS & PLANNERS
5740 S. ARVILLE STREET #216, LAS VEGAS, NV 89118
PHONE (702) 284-5390 FAX (702) 284-5399

NINETY-FIVE MANAGEMENT LLC

SKYE CANYON PHASE 2
EGAN CREST STORM DRAIN PLAN AND PROFILE
"ECD" 15+50.00 TO "ECD" 21+00.00

DATE: 11/19/15
DRAFTER: JAS
DESIGNER: DAM
CHECKED: JSR
PROJECT NO. **OLY1501-001**

SD-11
SHEET 14 OF 33

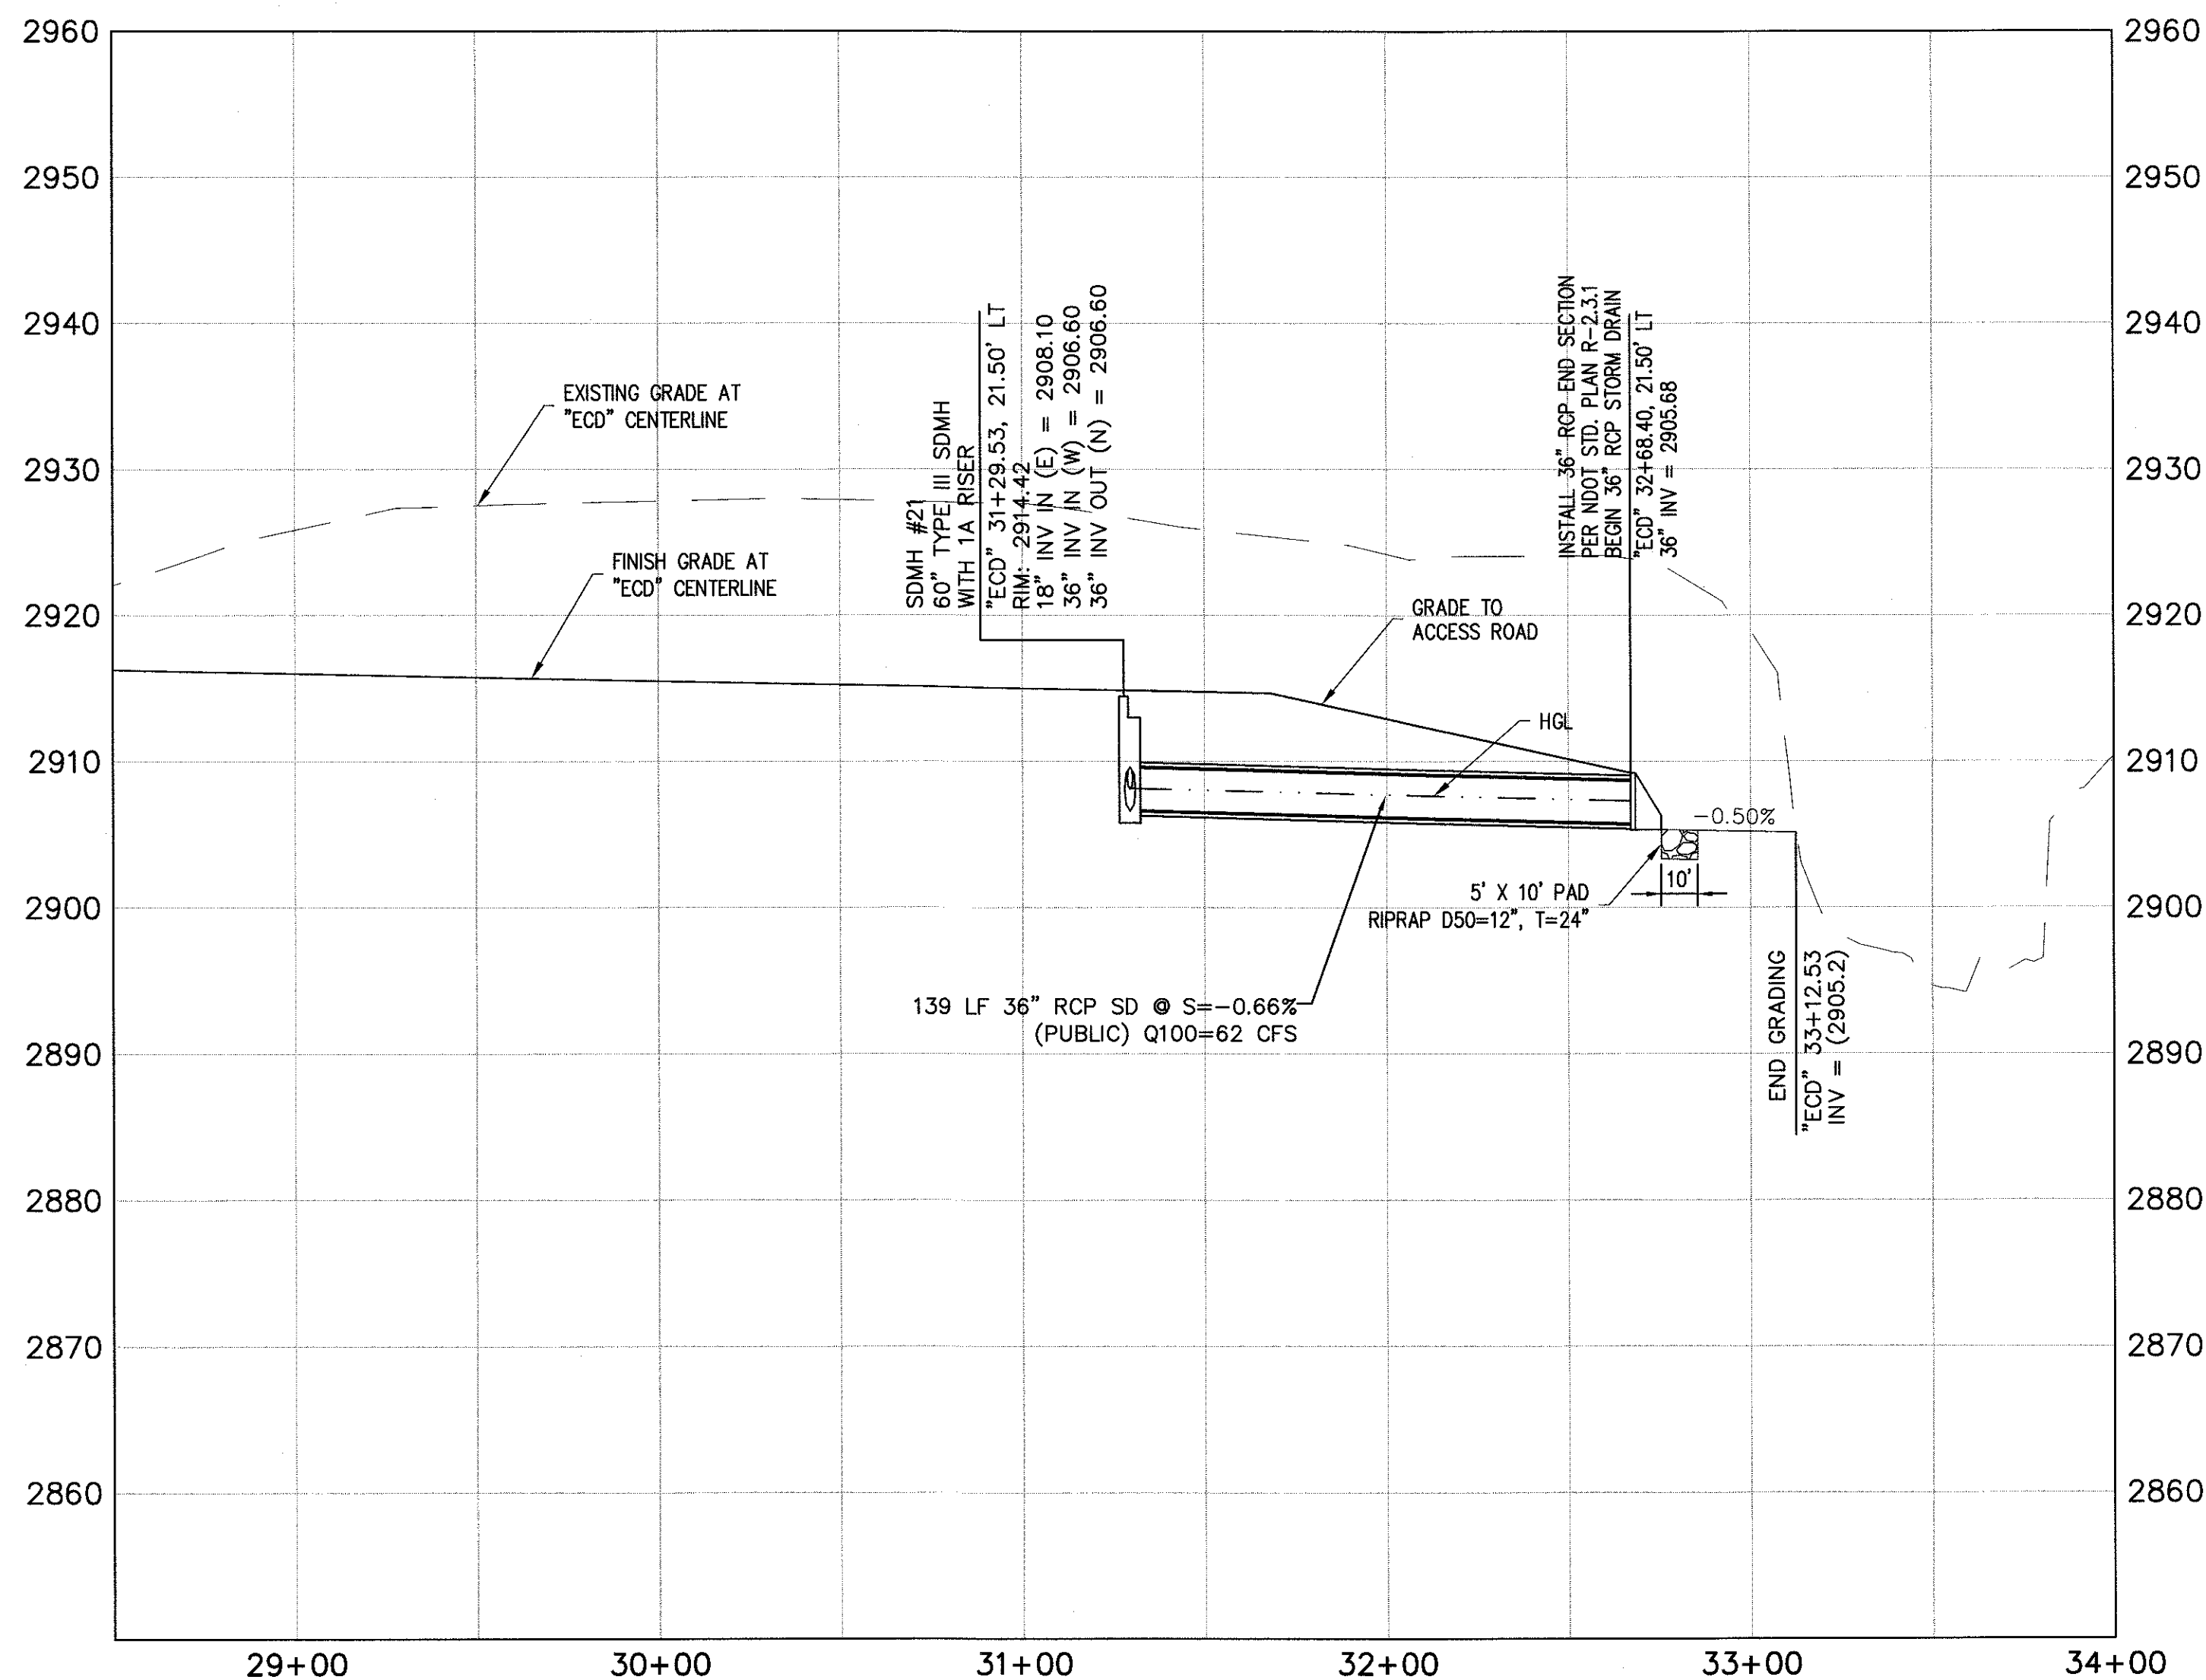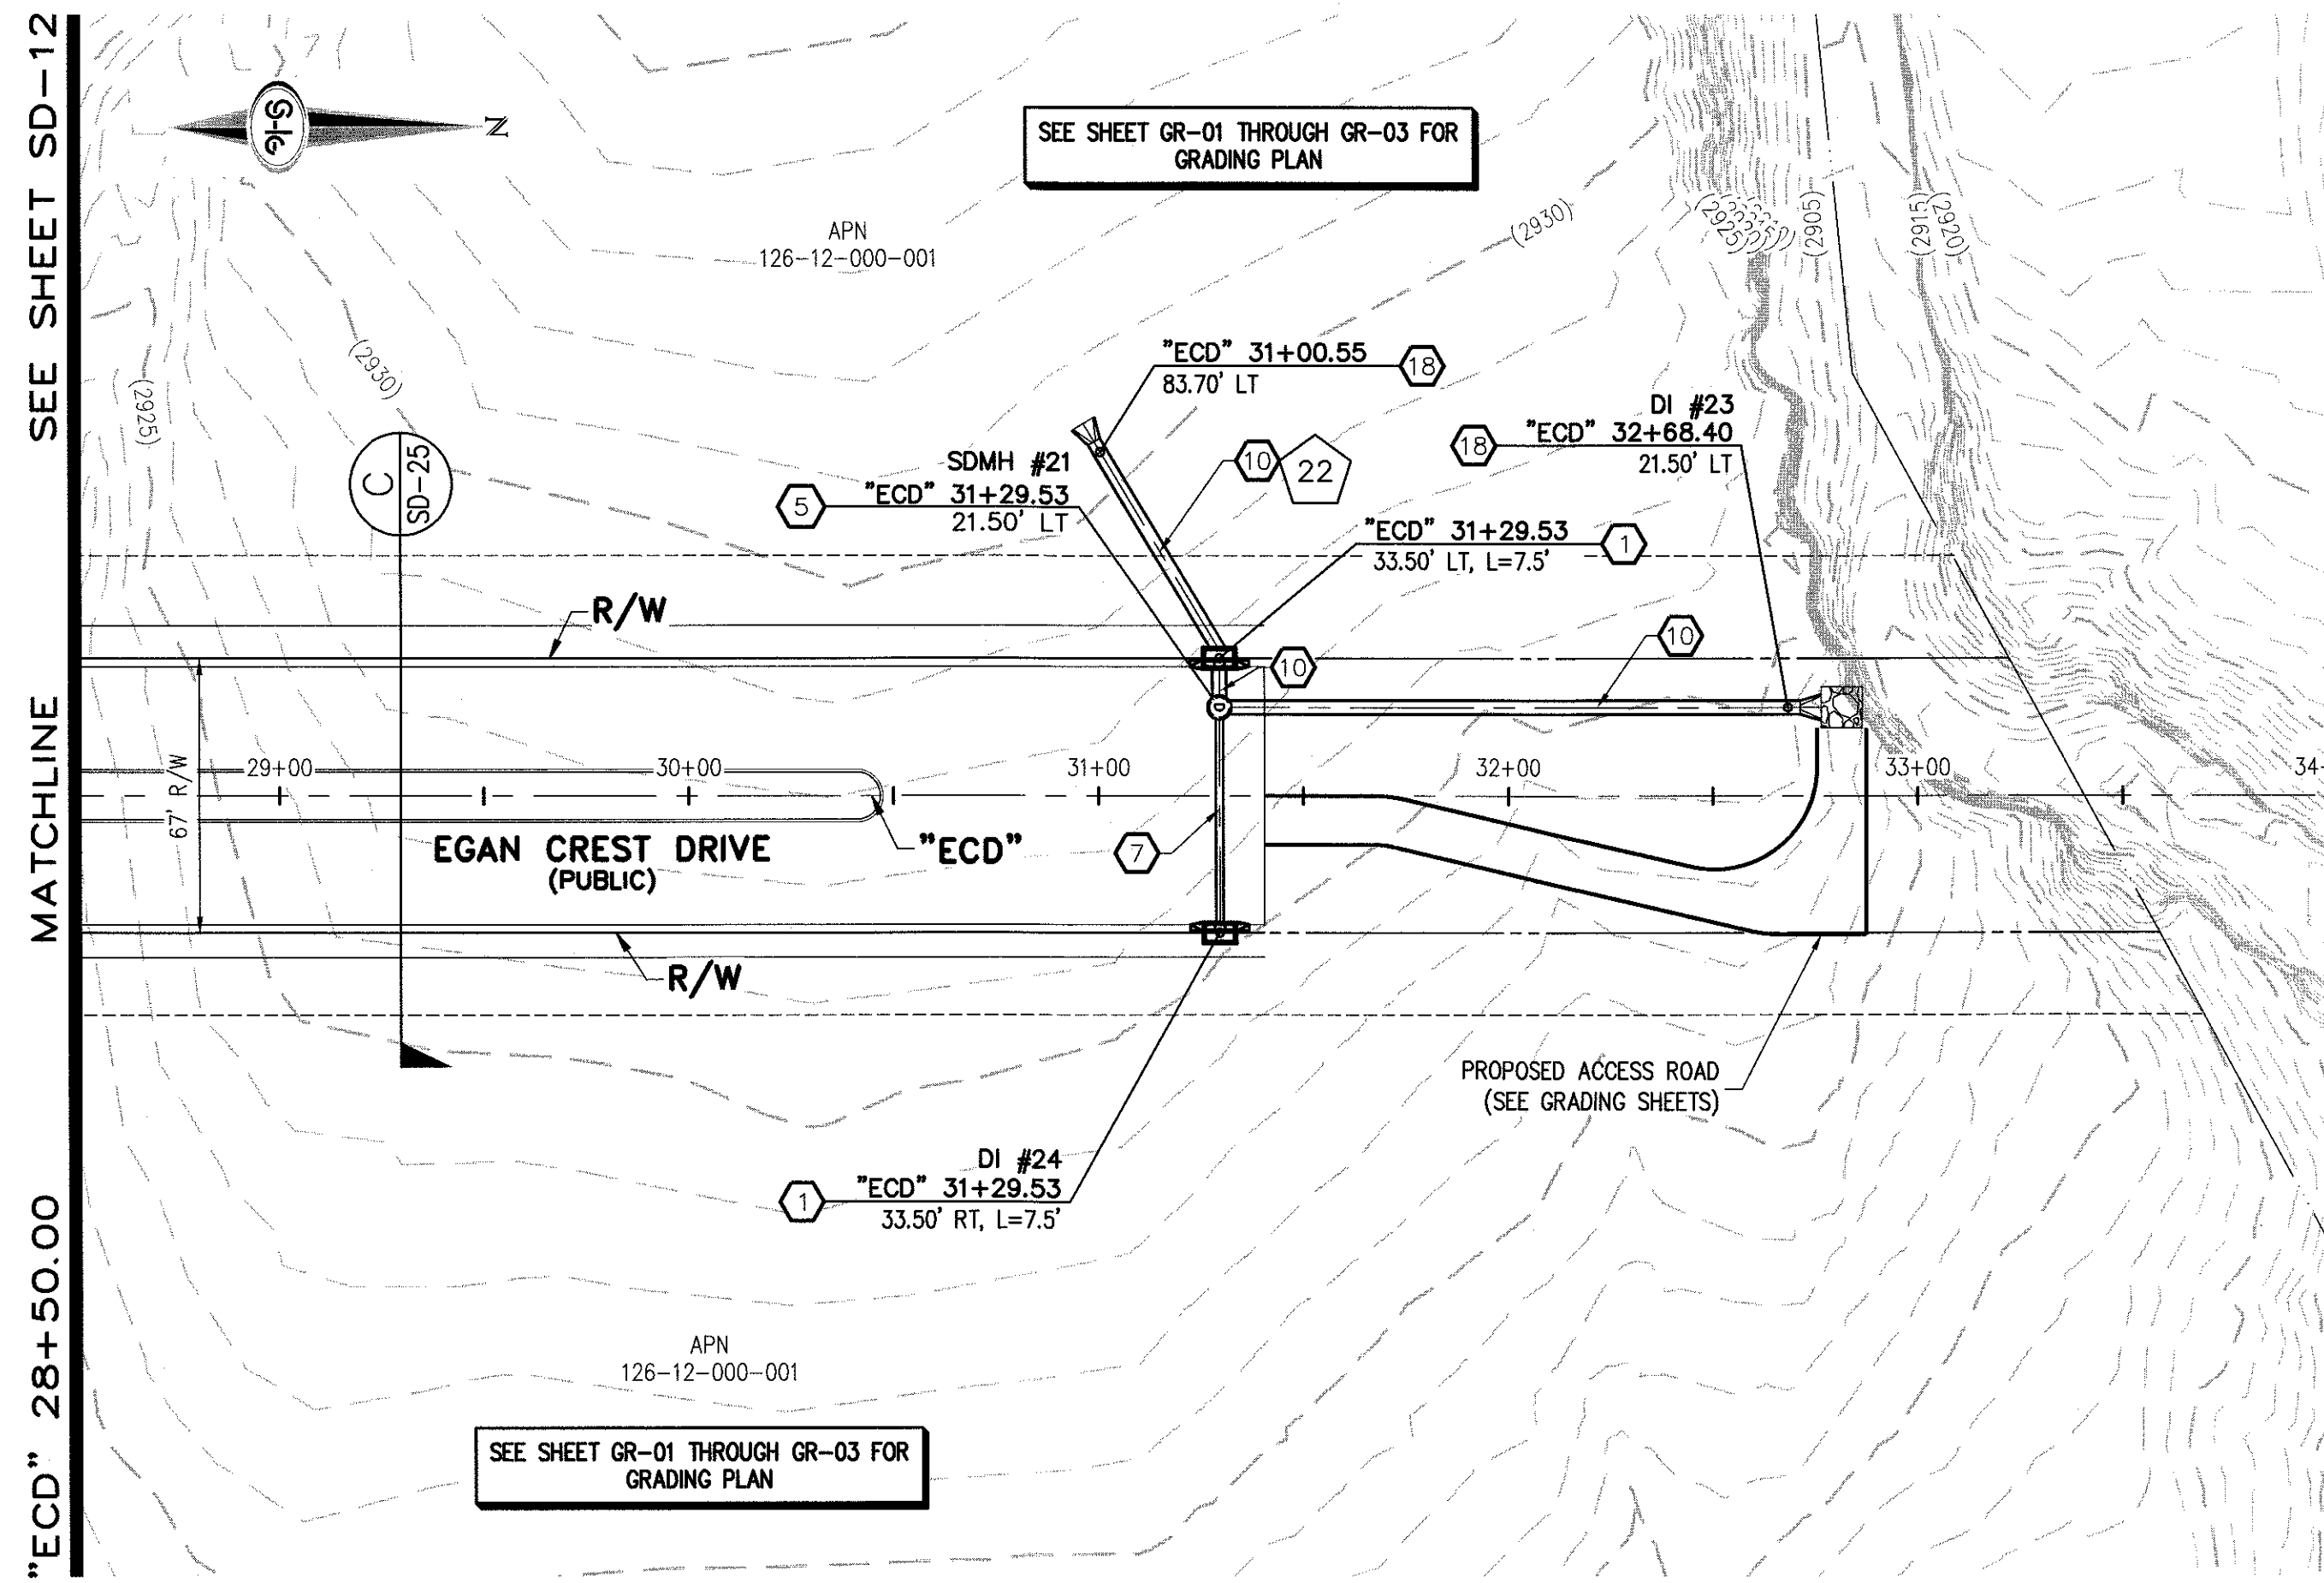

STORM DRAIN NOTES

1. CONSTRUCT TYPE "CM2" DROP INLET (USDCCA STD. DWG. NO. 412.1)
2. REMOVE EXISTING LATERAL STUB AND CONSTRUCT RCB PLUG (SEE DETAIL 5, DRAWING SD-26)
3. CONSTRUCT 60" TYPE I MANHOLE (USDCCA STD. DWG. NO. 403.1)
4. CONSTRUCT 60" TYPE III MANHOLE (USDCCA STD. DWG. NO. 406.1)
5. CONSTRUCT 60" TYPE III MANHOLE WITH TYPE IA RISER (USDCCA STD. DWG. NO. 404.1 AND 406.1)
6. CONSTRUCT NDOT TYPE 4 MANHOLE (NDOT STD. PLAN R-4.3.2)
7. INSTALL 18" RCP (USDCCA STD. DWG. NO. 503.2)
8. INSTALL 24" RCP (USDCCA STD. DWG. NO. 503.2)
9. INSTALL 30" RCP (USDCCA STD. DWG. NO. 503.2)
10. INSTALL 36" RCP (USDCCA STD. DWG. NO. 503.2)
11. INSTALL 42" RCP (USDCCA STD. DWG. NO. 503.2)
12. INSTALL 54" RCP (USDCCA STD. DWG. NO. 503.2)
13. INSTALL 60" RCP (USDCCA STD. DWG. NO. 503.2)
14. INSTALL 66" RCP (USDCCA STD. DWG. NO. 503.2)
15. INSTALL 18" RCP END SECTION (NDOT STD. PLAN R-2.3.1)
16. INSTALL 24" RCP END SECTION (NDOT STD. PLAN R-2.3.1)
17. INSTALL 30" RCP END SECTION (NDOT STD. PLAN R-2.3.1)
18. INSTALL 36" RCP END SECTION (NDOT STD. PLAN R-2.3.1)
19. INSTALL 42" RCP END SECTION (NDOT STD. PLAN R-2.3.1)
20. PIPE PENETRATION (SEE DETAIL 4, DRAWING SD-26)
21. CONSTRUCT CONCRETE COLLAR (SEE DETAIL 2, DRAWING SD-26)
22. CONSTRUCT BRICK AND MORTAR PLUG (SEE DETAIL 1, DRAWING SD-26)
23. INSTALL 48" RCP (USDCCA STD. DWG. NO. 503.2)
24. INSTALL 48" RCP END SECTION (NDOT STD. PLAN R-2.3.1)
25. INSTALL DRIVEWAY (USDCCA STD. DWG. NO. 224)
26. CONSTRUCT TYPE "CM" DROP INLET (USDCCA STD. DWG. NO. 422)

NOTES

1. ALL RCP SHALL BE CLASS III UNLESS OTHERWISE SHOWN.
2. ALL PIPE LENGTHS ARE MEASURED ALONG PIPE CENTERLINE TO CENTER OF MANHOLE OR INSIDE EDGE OF DI OR RCB/RCA.
3. ALL DROP INLETS SHALL INCLUDE STORM WATER MANAGEMENT STAMP AND DETAIL PER USDCCA STD. DWG. NO. 421.
4. SEE STRUCTURAL PLANS FOR ADDITIONAL STRUCTURAL DETAILS AND CONNECTIONS.
5. ALL PIPES ARE PUBLICLY MAINTAINED.
6. ADD SPECIAL INSPECTION REQUIRED FOR PIPE SEGMENTS WITH SACRIFICIAL CONCRETE.

DROP INLET NOTE

WHERE 10 FEET PARALLEL SEPARATION IS NOT PRACTICABLE, CAST-IN-PLACE MONOLITHIC POUR WITH WATERSTOP BETWEEN SLAB AND WALLS. BASE, WALLS AND TOP TO BE CONSTRUCTED WITH WATERSTOPS, CENTER BULB, OR FLAT STRIP (VINYLEX, GREENSTREAK PLASTIC PRODUCTS OR APPROVED EQUAL).

LEGEND



STORM DRAIN LATERAL # (SEE SHEETS SD-20 THRU SD-24)

I CERTIFY THAT THIS GRADING PLAN IS IN CONFORMANCE WITH THE APPROVED TECHNICAL DRAINAGE STUDY D5-1725A ON FILE AT THE CITY OF LAS VEGAS FOR THE SUBJECT PROJECT

JERRY SLATER, P.E. 14167 DATE 3/22/16




FLOOD ZONE



THE PROJECT SITE IS LOCATED WITHIN A FEMA DESIGNATED ZONE "X" (OUTSIDE THE 500-YEAR FLOOD PLAIN) ON THE FLOOD INSURANCE RATE MAP (FIRM) PANEL:32003C1750E, DATED SEPTEMBER 27, 2002

NOTE:

PROPERTY OWNER IS RESPONSIBLE TO MAINTAIN THE BEST MANAGEMENT PRACTICES, SUCH AS BUT NOT LIMITED TO, THE REMOVAL OF ACCUMULATED SEDIMENT AND DEBRIS AND CARE OF VEGETATION.

KEY MAP

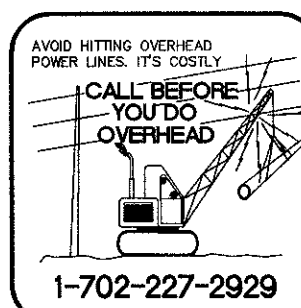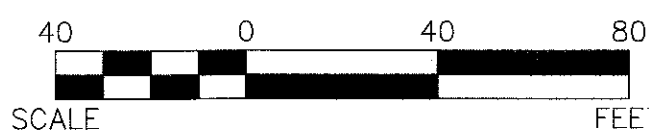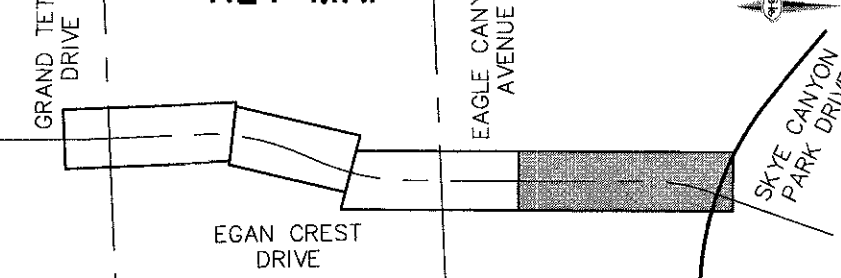

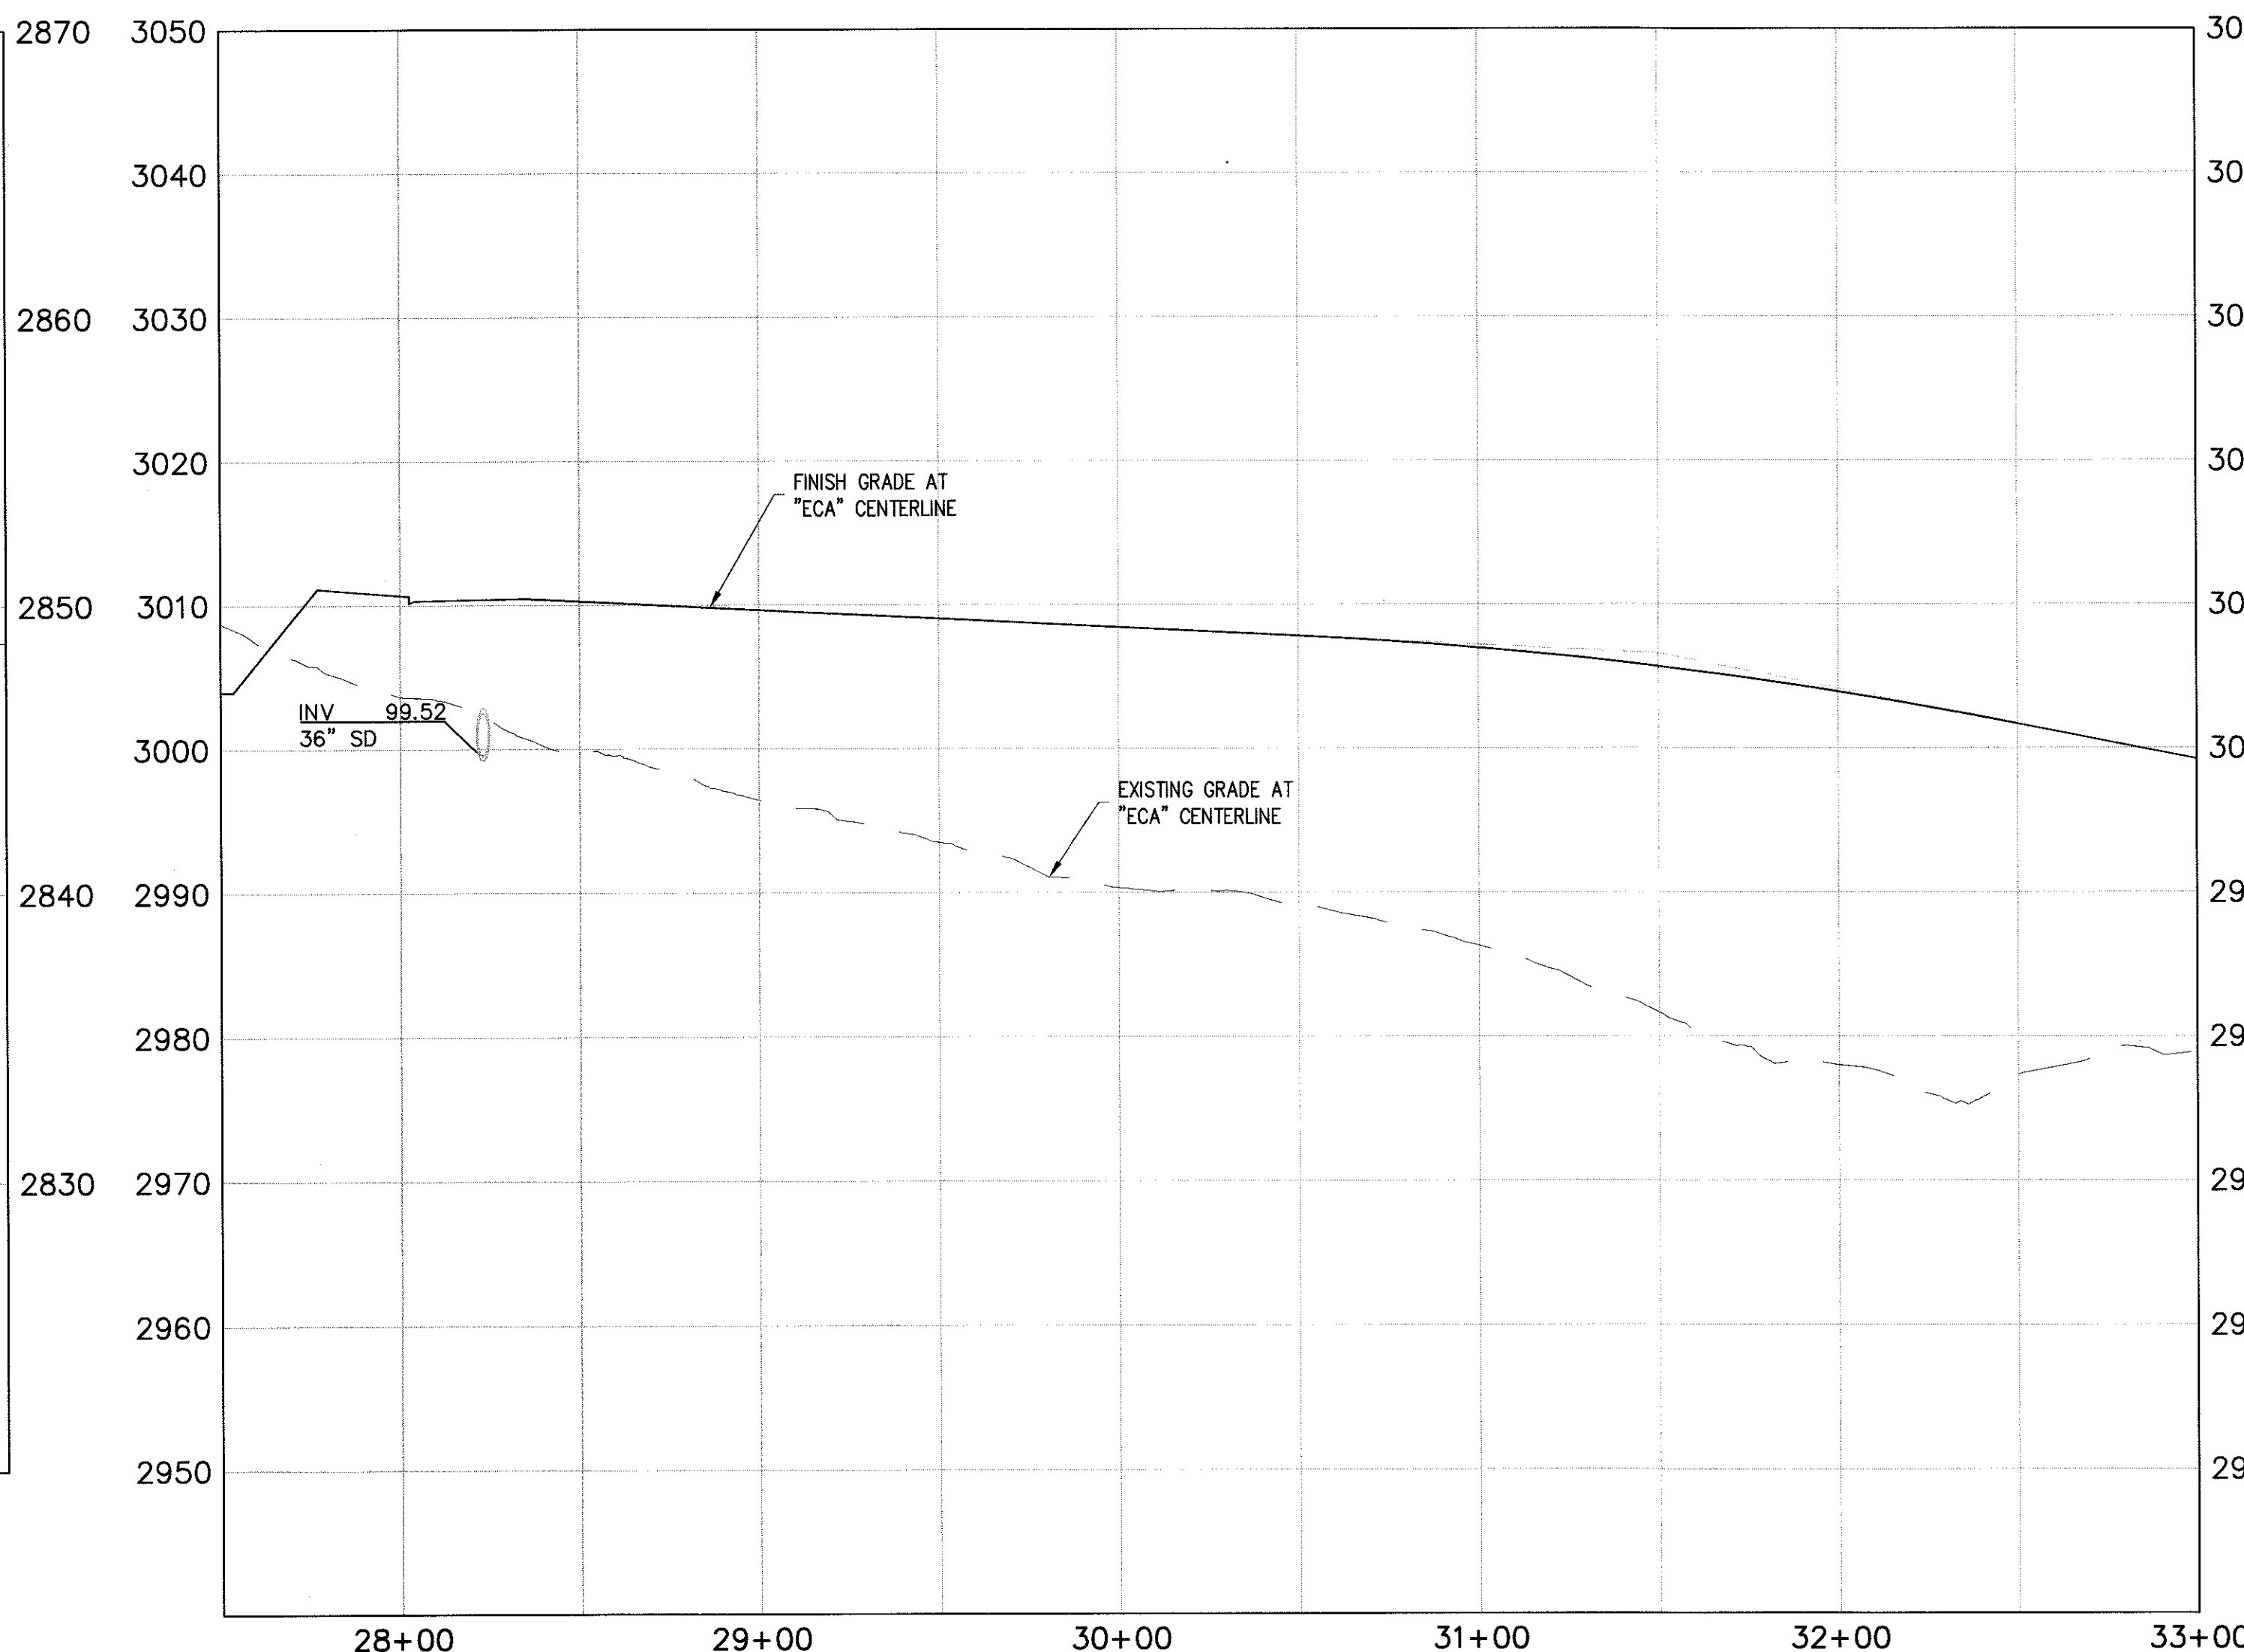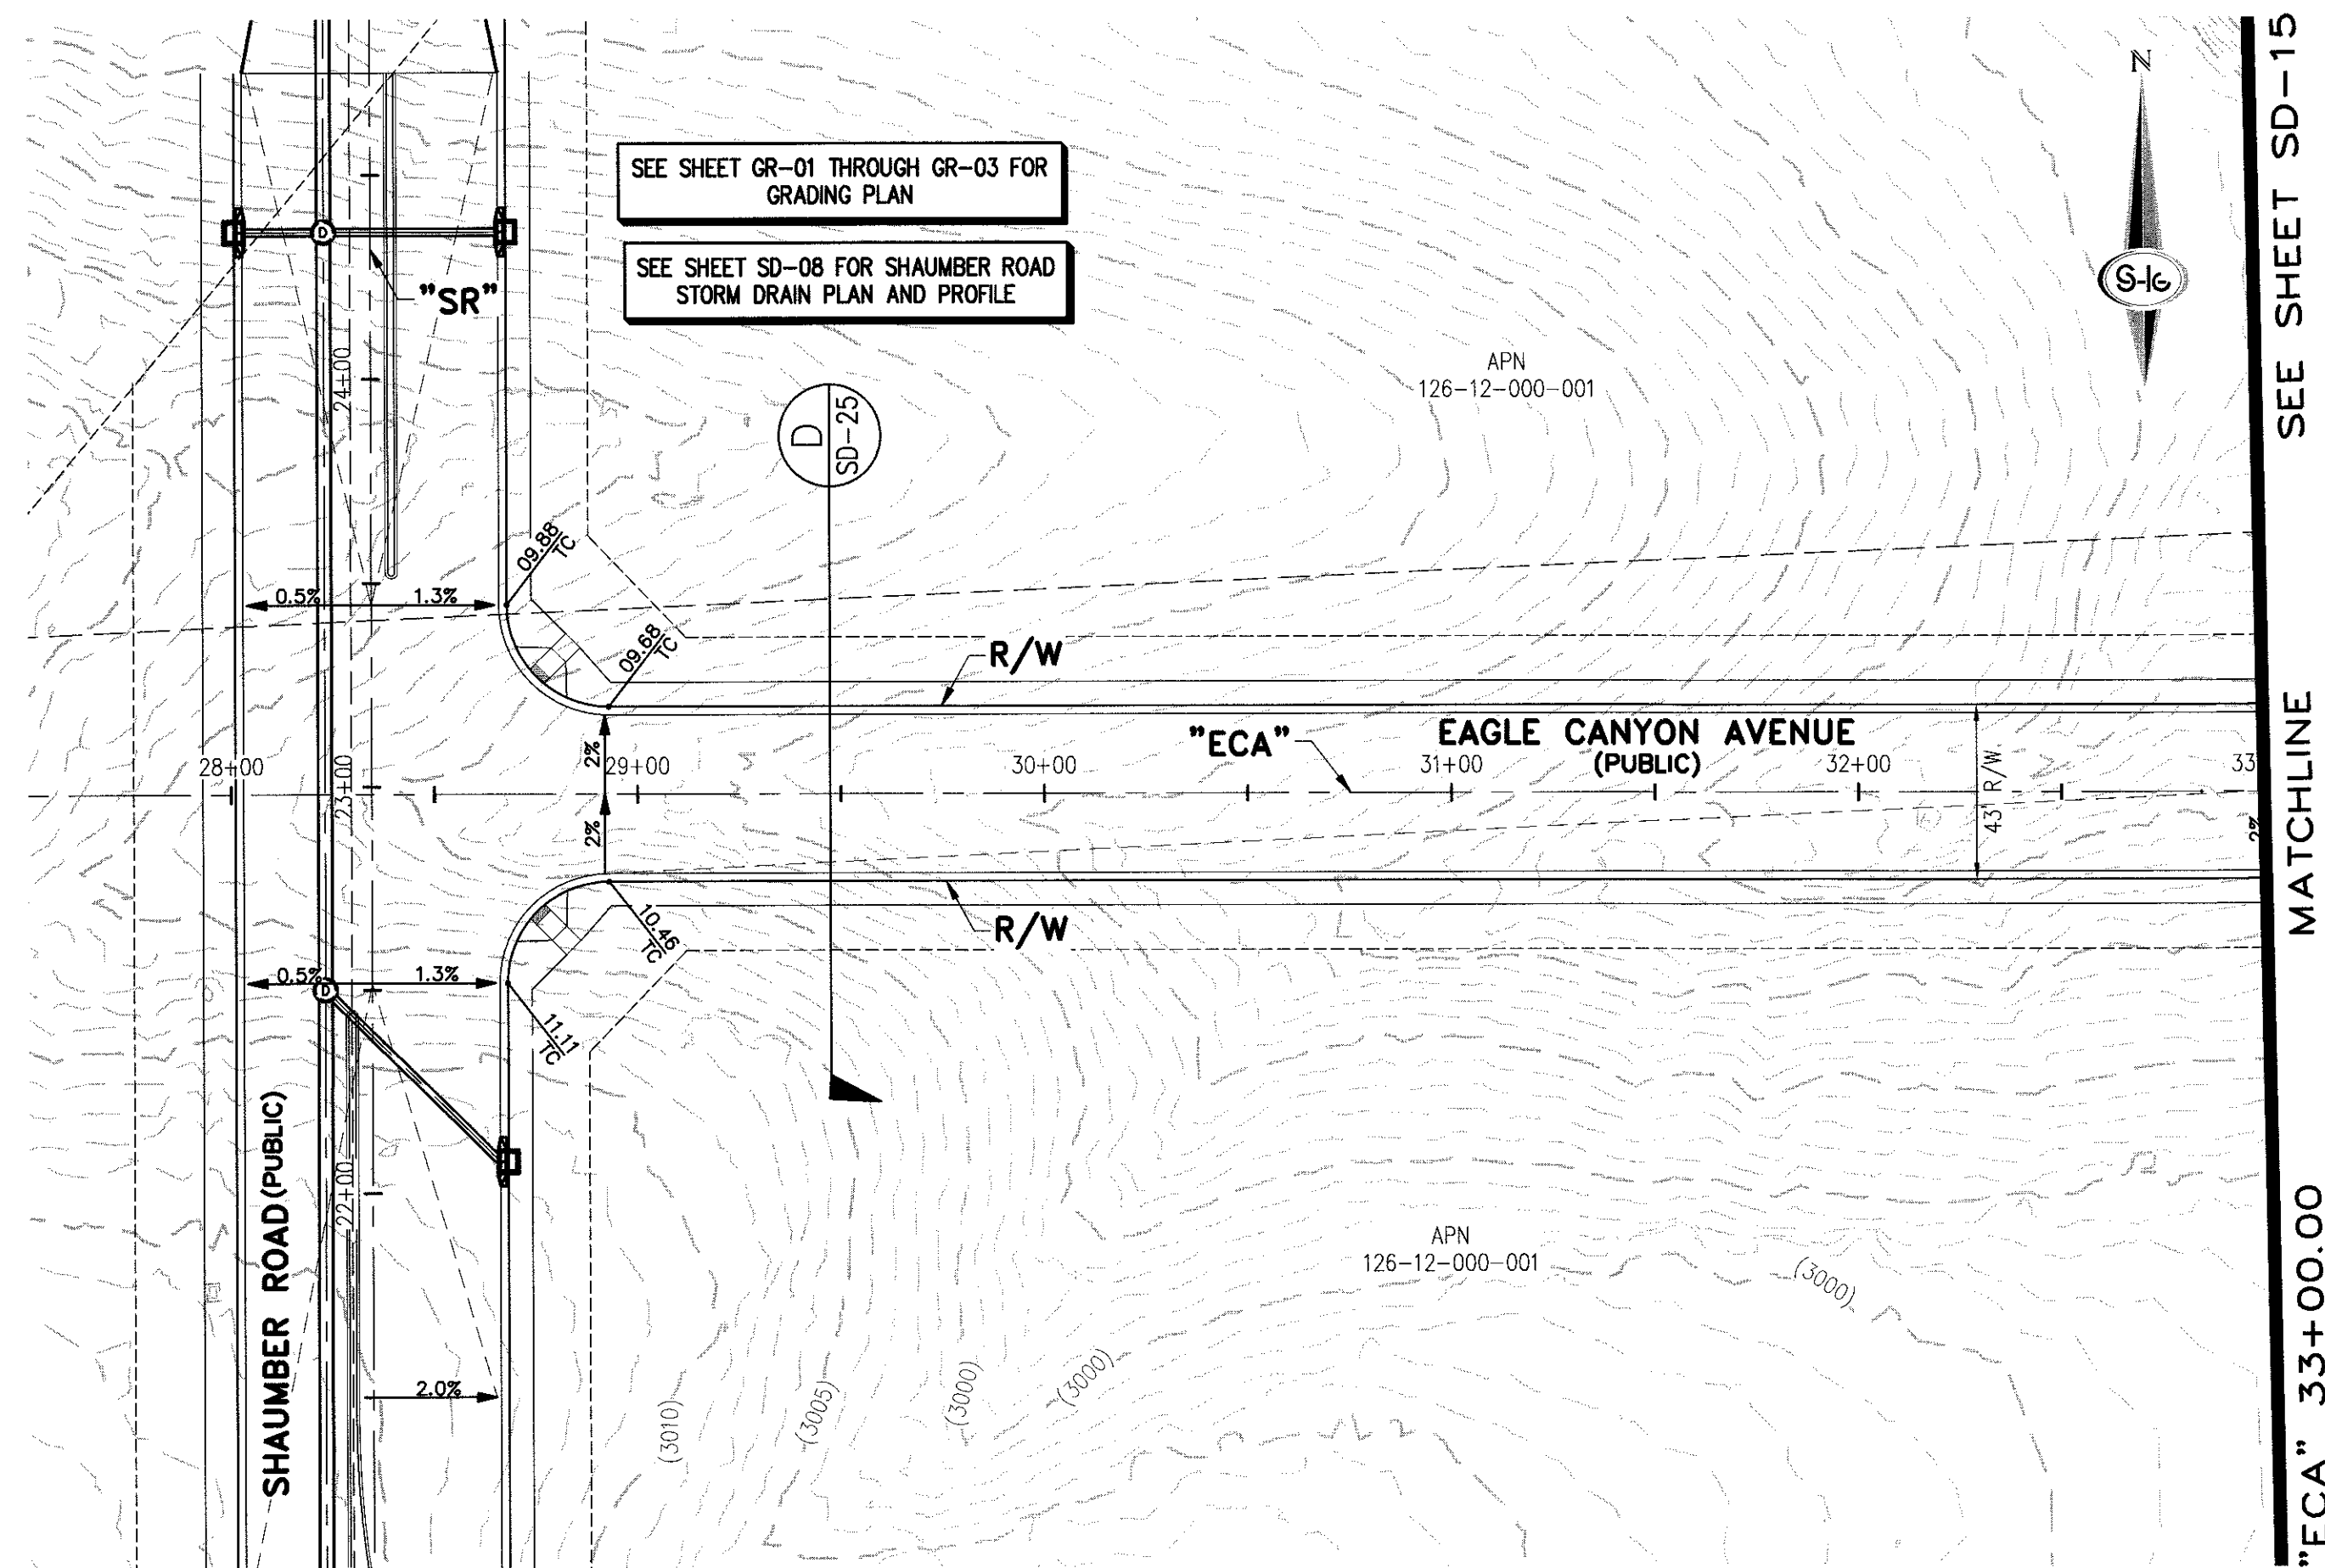

- 1 CONSTRUCT TYPE "CM2" DROP INLET (USDOCCA STD. DWG. NO. 412.1)
- 2 REMOVE EXISTING LATERAL STUB AND CONSTRUCT RCB PLUG
(SEE DETAIL 5, DRAWING SD-26)
- 3 CONSTRUCT 60" TYPE I MANHOLE (USDOCCA STD. DWG. NO. 403.1)
- 4 CONSTRUCT 60" TYPE III MANHOLE (USDOCCA STD. DWG. NO. 406.1)
- 5 CONSTRUCT 60" TYPE III MANHOLE WITH TYPE IA RISER (USDOCCA STD.
DWG. NO. 404.1 AND 406.1)
- 6 CONSTRUCT NDOT TYPE 4 MANHOLE (NDOT STD. PLAN R-4.3.2)
- 7 INSTALL 18" RCP (USDOCCA STD. DWG. NO. 503.2)
- 8 INSTALL 24" RCP (USDOCCA STD. DWG. NO. 503.2)
- 9 INSTALL 30" RCP (USDOCCA STD. DWG. NO. 503.2)
- 10 INSTALL 36" RCP (USDOCCA STD. DWG. NO. 503.2)
- 11 INSTALL 42" RCP (USDOCCA STD. DWG. NO. 503.2)
- 12 INSTALL 54" RCP (USDOCCA STD. DWG. NO. 503.2)
- 13 INSTALL 60" RCP (USDOCCA STD. DWG. NO. 503.2)
- 14 INSTALL 66" RCP (USDOCCA STD. DWG. NO. 503.2)
- 15 INSTALL 18" RCP END SECTION (NDOT STD. PLAN R-2.3.1)
- 16 INSTALL 24" RCP END SECTION (NDOT STD. PLAN R-2.3.1)
- 17 INSTALL 30" RCP END SECTION (NDOT STD. PLAN R-2.3.1)
- 18 INSTALL 36" RCP END SECTION (NDOT STD. PLAN R-2.3.1)
- 19 INSTALL 42" RCP END SECTION (NDOT STD. PLAN R-2.3.1)
- 20 PIPE PENETRATION (SEE DETAIL 4, DRAWING SD-26)
- 21 CONSTRUCT CONCRETE COLLAR (SEE DETAIL 2, DRAWING SD-26)
- 22 CONSTRUCT BRICK AND MORTAR PLUG (SEE DETAIL 1, DRAWING SD-26)
- 23 INSTALL 48" RCP (USDOCCA STD. DWG. NO. 503.2)
- 24 INSTALL 48" RCP END SECTION (NDOT STD. PLAN R-2.3.1)
- 25 INSTALL DRIVEWAY (USDOCCA STD. DWG. NO. 224)
- 26 CONSTRUCT TYPE "CM" DROP INLET (USDOCCA STD. DWG. NO. 422)

1. ALL RCP SHALL BE CLASS III UNLESS OTHERWISE SHOWN.
2. ALL PIPE LENGTHS ARE MEASURED ALONG PIPE CENTERLINE TO CENTER OF MANHOLE OR INSIDE EDGE OF DI OR RCB/RCA.
3. ALL DROP INLETS SHALL INCLUDE STORM WATER MANAGEMENT STAMP AND DETAIL PER USDECCA STD. DWG. NO. 421.
4. SEE STRUCTURAL PLANS FOR ADDITIONAL STRUCTURAL DETAILS AND CONNECTIONS.
5. ALL PIPES ARE PUBLICLY MAINTAINED.
6. ADD SPECIAL INSPECTION REQUIRED FOR PIPE SEGMENTS WITH SACRIFICIAL CONCRETE.

WHERE 10 FEET PARALLEL SEPARATION IS NOT PRACTICABLE:
CAST-IN-PLACE MONOLITHIC POUR WITH WATERSTOP BETWEEN SLAB AND WALLS.
BASE, WALLS AND TOP TO BE CONSTRUCTED WITH WATERSTOPS, CENTER BULB,
OR FLAT STRIP (VINYLEX, GREENSTREAK PLASTIC PRODUCTS OR APPROVED EQUAL).

1 STORM DRAIN LATERAL # (SEE SHEETS SD-20 THRU SD-24)



I CERTIFY THAT THIS GRADING PLAN IS IN
CONFORMANCE WITH THE APPROVED TECHNICAL
DRAINAGE STUDY DS-4739A ON FILE AT THE CITY
OF LAS VEGAS FOR THE SUBJECT PROJECT

 3.22.04

JERRY SLATER, P.E. 14167

THE PROJECT SITE IS LOCATED WITHIN A FEMA DESIGNATED ZONE 'X' (OUTSIDE THE 500-YEAR FLOOD PLAIN) ON THE FLOOD INSURANCE RATE MAP (FIRM) PANEL:32003C1750E, DATED SEPTEMBER 27, 2002

PROPERTY OWNER IS RESPONSIBLE TO MAINTAIN THE BEST MANAGEMENT PRACTICES, SUCH AS BUT NOT LIMITED TO, THE REMOVAL OF ACCUMULATED SEDIMENT AND DEBRIS AND CARE OF VEGETATION.

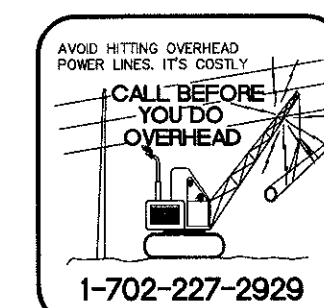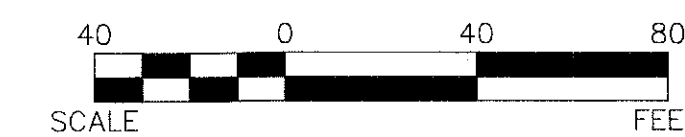


SLATER
HANFAN
GROUP
CONSULTING ENGINEERS & PLANNERS
5740 S. ARVILLE STREET #216, LAS VEGAS, NV 89118
PHONE (702) 284-5300
FAX (702) 284-5399

[illegible]



NINETY-FIVE MANAGEMENT LLC

SKYE CANYON PHASE 2
EAGLE CANYON AVENUE STORM DRAIN PLAN AND PROFILE
"ECA" 25+00.00 TO "ECA" 33+00.00

DATE: 11/19/15
DRAFTER: JAS
DESIGNER: DAM
CHECKED: JSR
PROJECT NO.
OLY1501-001

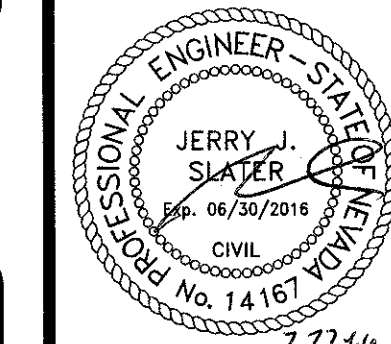

SD-14
SHEET 17 OF 33

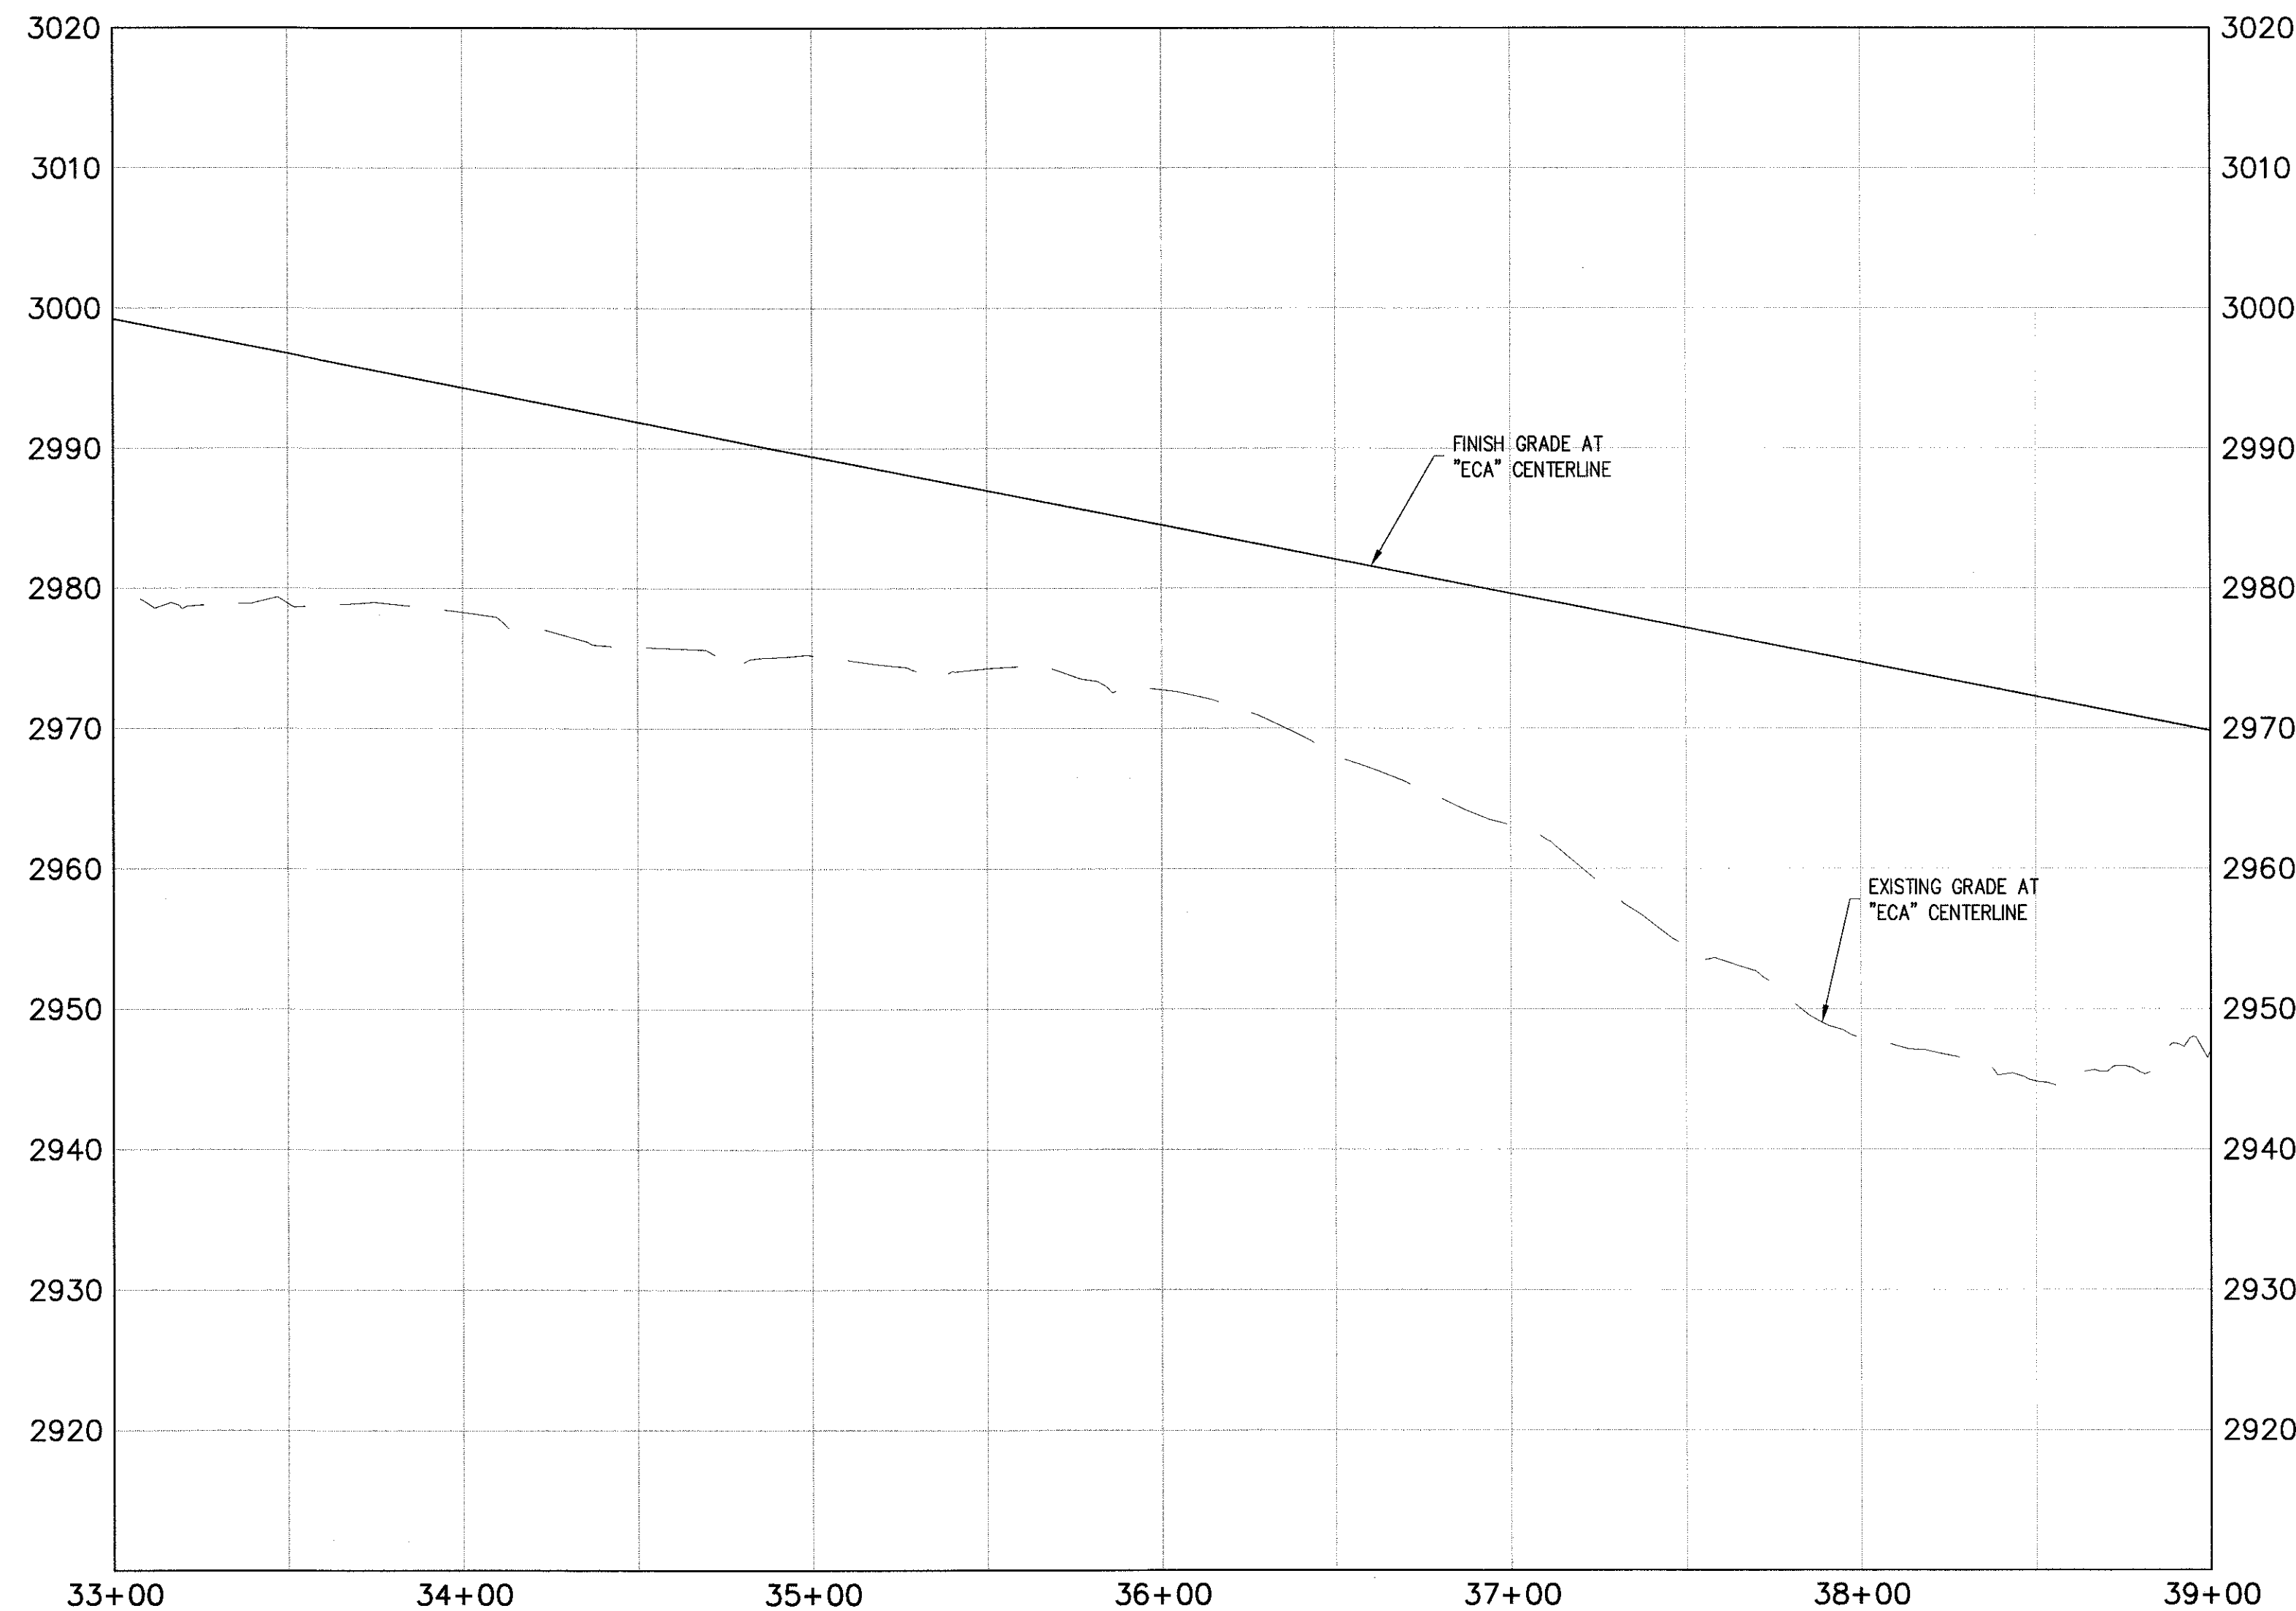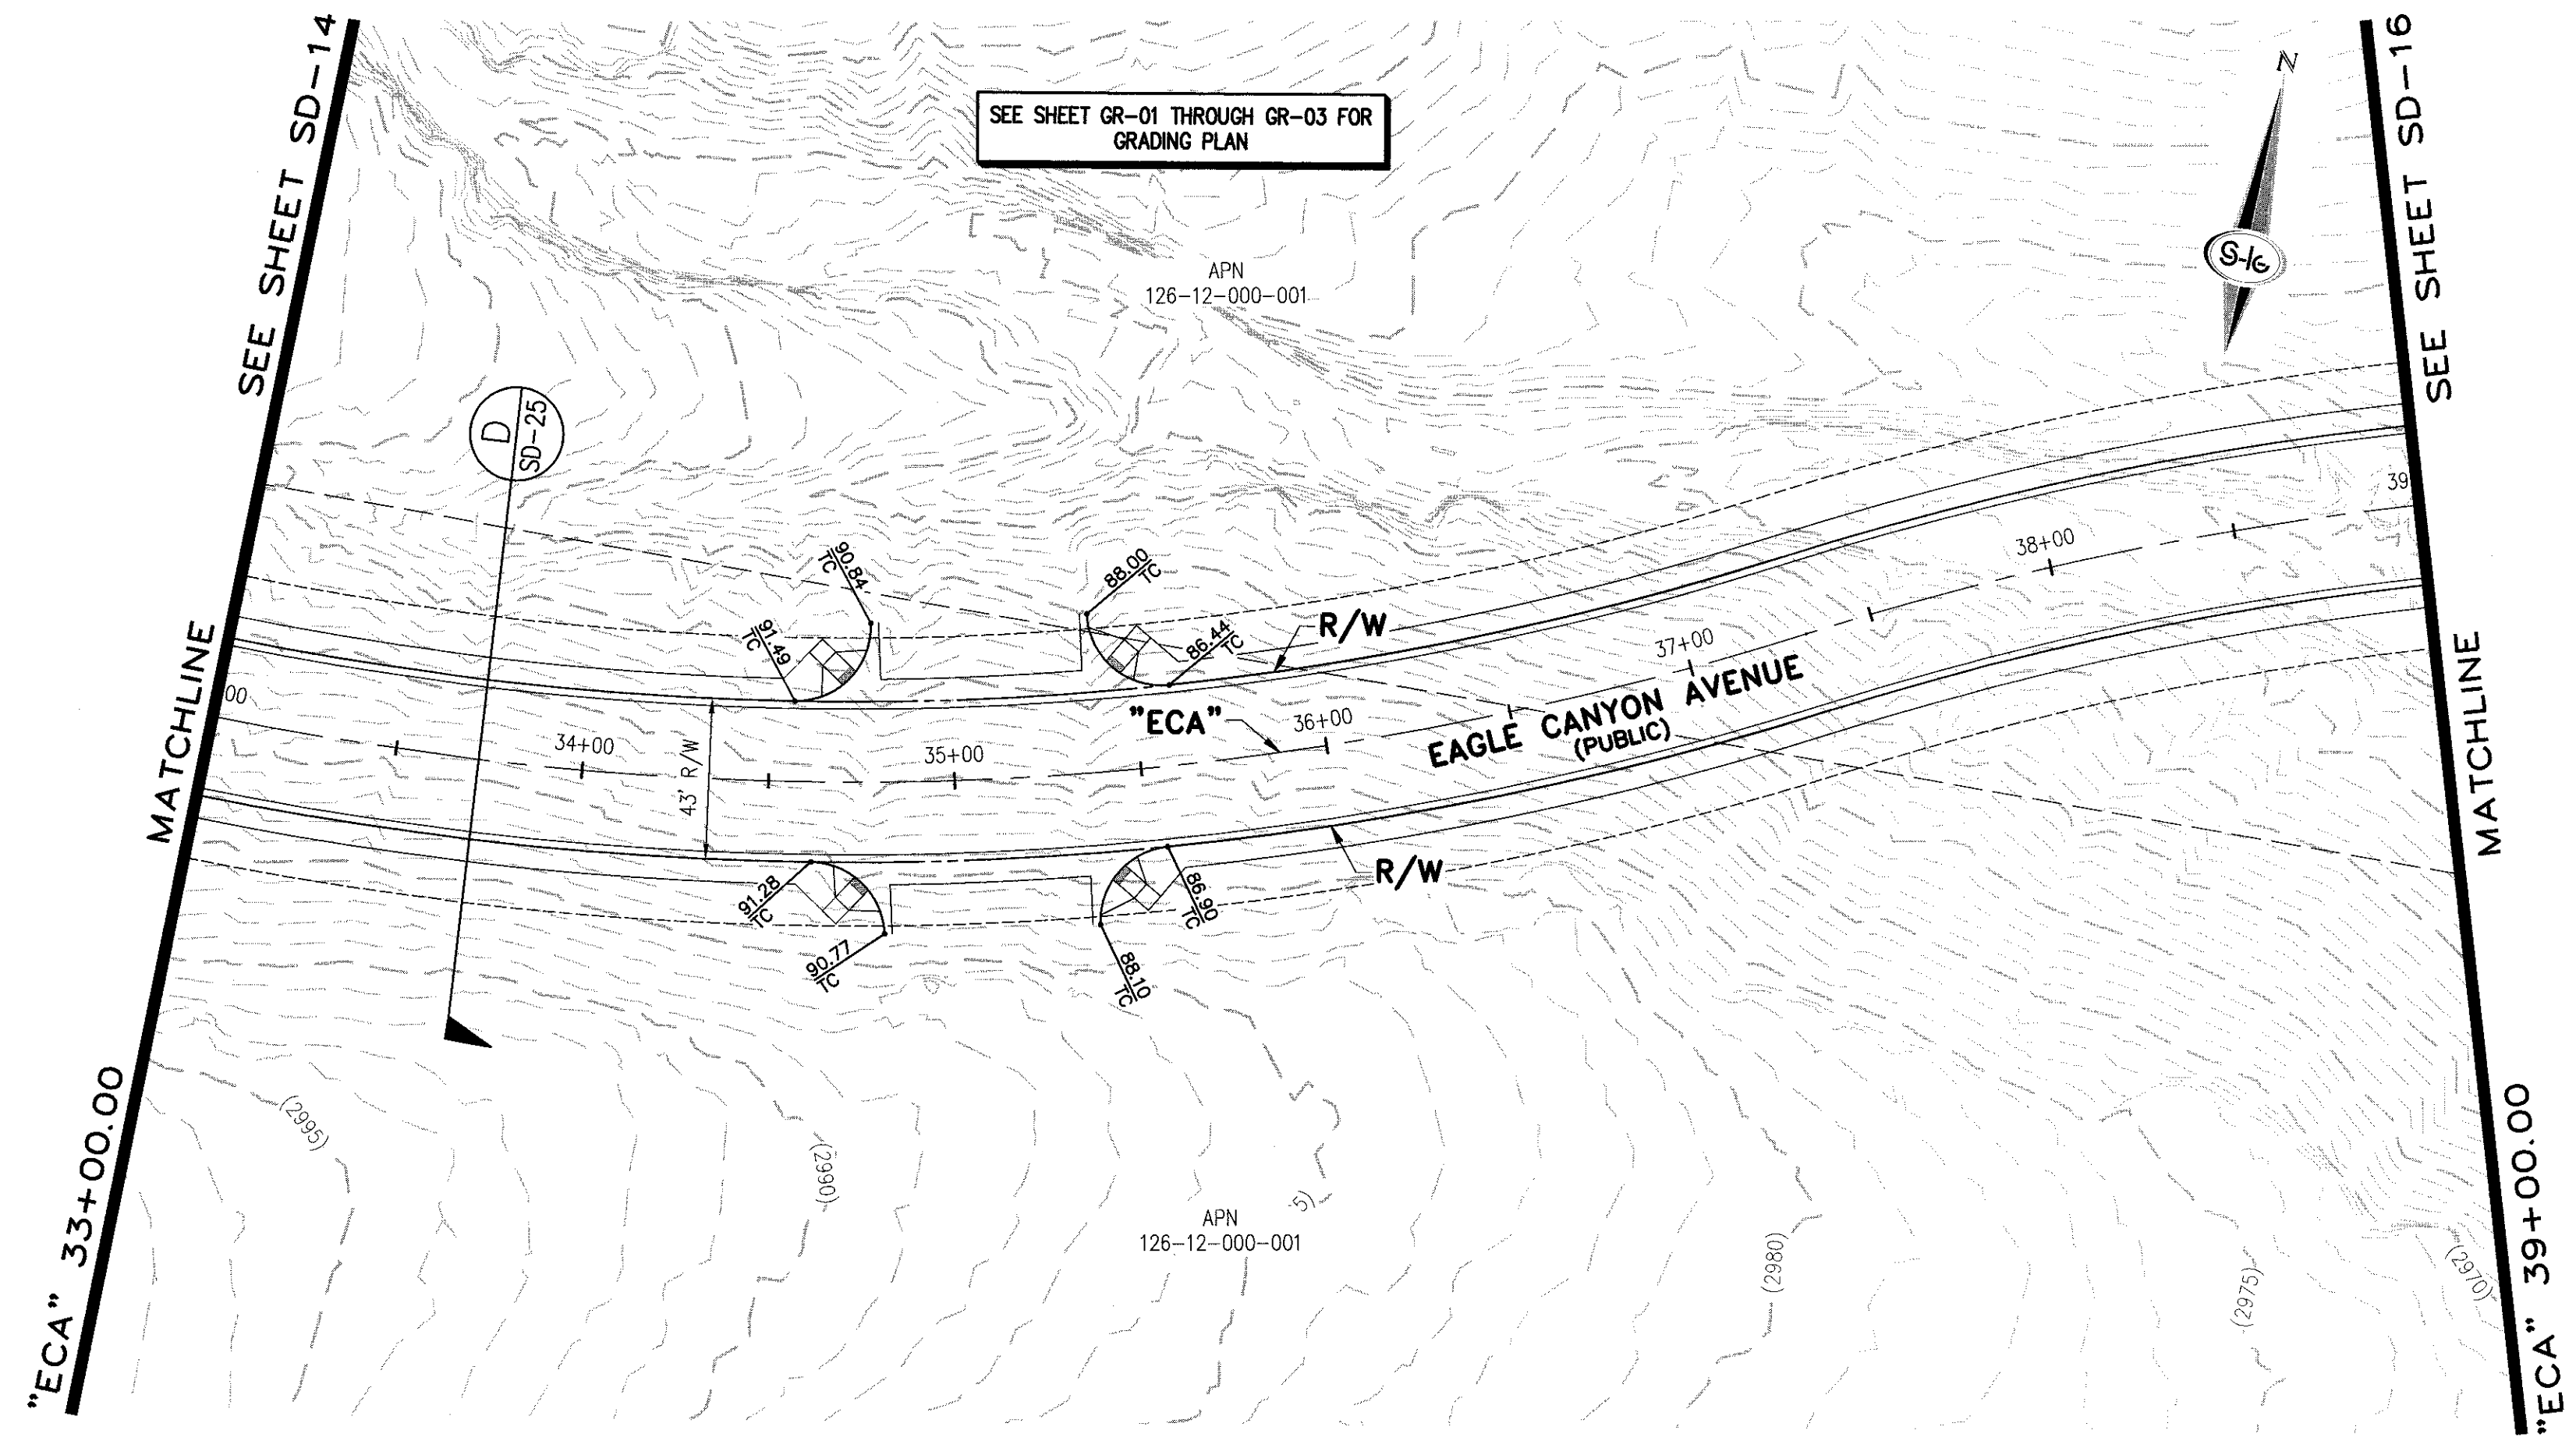

STORM DRAIN NOTES

1. CONSTRUCT TYPE "CM2" DROP INLET (USDCCA STD. DWG. NO. 412.1)
2. REMOVE EXISTING LATERAL STUB AND CONSTRUCT RCB PLUG (SEE DETAIL 5, DRAWING SD-26)
3. CONSTRUCT 60" TYPE I MANHOLE (USDCCA STD. DWG. NO. 403.1)
4. CONSTRUCT 60" TYPE III MANHOLE (USDCCA STD. DWG. NO. 406.1)
5. CONSTRUCT 60" TYPE III MANHOLE WITH TYPE IA RISER (USDCCA STD. DWG. NO. 404.1 AND 406.1)
6. CONSTRUCT NDOT TYPE 4 MANHOLE (NDOT STD. PLAN R-4.3.2)
7. INSTALL 18" RCP (USDCCA STD. DWG. NO. 503.2)
8. INSTALL 24" RCP (USDCCA STD. DWG. NO. 503.2)
9. INSTALL 30" RCP (USDCCA STD. DWG. NO. 503.2)
10. INSTALL 36" RCP (USDCCA STD. DWG. NO. 503.2)
11. INSTALL 42" RCP (USDCCA STD. DWG. NO. 503.2)
12. INSTALL 54" RCP (USDCCA STD. DWG. NO. 503.2)
13. INSTALL 60" RCP (USDCCA STD. DWG. NO. 503.2)
14. INSTALL 66" RCP (USDCCA STD. DWG. NO. 503.2)
15. INSTALL 18" RCP END SECTION (NDOT STD. PLAN R-2.3.1)
16. INSTALL 24" RCP END SECTION (NDOT STD. PLAN R-2.3.1)
17. INSTALL 30" RCP END SECTION (NDOT STD. PLAN R-2.3.1)
18. INSTALL 36" RCP END SECTION (NDOT STD. PLAN R-2.3.1)
19. INSTALL 42" RCP END SECTION (NDOT STD. PLAN R-2.3.1)
20. PIPE PENETRATION (SEE DETAIL 4, DRAWING SD-26)
21. CONSTRUCT CONCRETE COLLAR (SEE DETAIL 2, DRAWING SD-26)
22. CONSTRUCT BRICK AND MORTAR PLUG (SEE DETAIL 1, DRAWING SD-26)
23. INSTALL 48" RCP (USDCCA STD. DWG. NO. 503.2)
24. INSTALL 48" RCP END SECTION (NDOT STD. PLAN R-2.3.1)
25. INSTALL DRIVEWAY (USDCCA STD. DWG. NO. 224)
26. CONSTRUCT TYPE "CM" DROP INLET (USDCCA STD. DWG. NO. 422)

NOTES

1. ALL RCP SHALL BE CLASS III UNLESS OTHERWISE SHOWN.
2. ALL PIPE LENGTHS ARE MEASURED ALONG PIPE CENTERLINE TO CENTER OF MANHOLE OR INSIDE EDGE OF DI OR RCB/RCA.
3. ALL DROP INLETS SHALL INCLUDE STORM WATER MANAGEMENT STAMP AND DETAIL PER USDCCA STD. DWG. NO. 421.
4. SEE STRUCTURAL PLANS FOR ADDITIONAL STRUCTURAL DETAILS AND CONNECTIONS.
5. ALL PIPES ARE PUBLICLY MAINTAINED.
6. ADD SPECIAL INSPECTION REQUIRED FOR PIPE SEGMENTS WITH SACRIFICIAL CONCRETE.

DROP INLET NOTE

WHERE 10 FEET PARALLEL SEPARATION IS NOT PRACTICABLE:
CAST-IN-PLACE MONOLITHIC POUR WITH WATERSTOP BETWEEN SLAB AND WALLS.
BASE, WALLS AND TOP TO BE CONSTRUCTED WITH WATERSTOPS, CENTER BUILT,
OR FLAT STRIP (VINYLEX, GREENSTREAK PLASTIC PRODUCTS OR APPROVED EQUAL).

LEGEND



STORM DRAIN LATERAL # (SEE SHEETS SD-20 THRU SD-24)

I CERTIFY THAT THIS GRADING PLAN IS IN CONFORMANCE WITH THE APPROVED TECHNICAL DRAINAGE STUDY DS-4729A ON FILE AT THE CITY OF LAS VEGAS FOR THE SUBJECT PROJECT.

JERRY SLATER, P.E. 14167



DATE 3/22/16

FLOOD ZONE

THE PROJECT SITE IS LOCATED WITHIN A FEMA DESIGNATED ZONE 'X' (OUTSIDE THE 500-YEAR FLOOD PLAIN) ON THE FLOOD INSURANCE RATE MAP (FIRM) PANEL:32003C1750E, DATED SEPTEMBER 27, 2002.

NOTE:

PROPERTY OWNER IS RESPONSIBLE TO MAINTAIN THE BEST MANAGEMENT PRACTICES, SUCH AS BUT NOT LIMITED TO, THE REMOVAL OF ACCUMULATED SEDIMENT AND DEBRIS AND CARE OF VEGETATION.

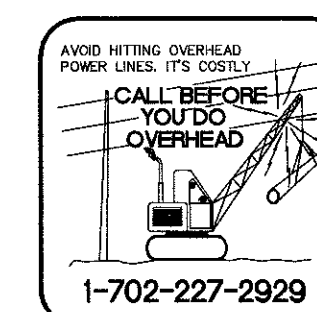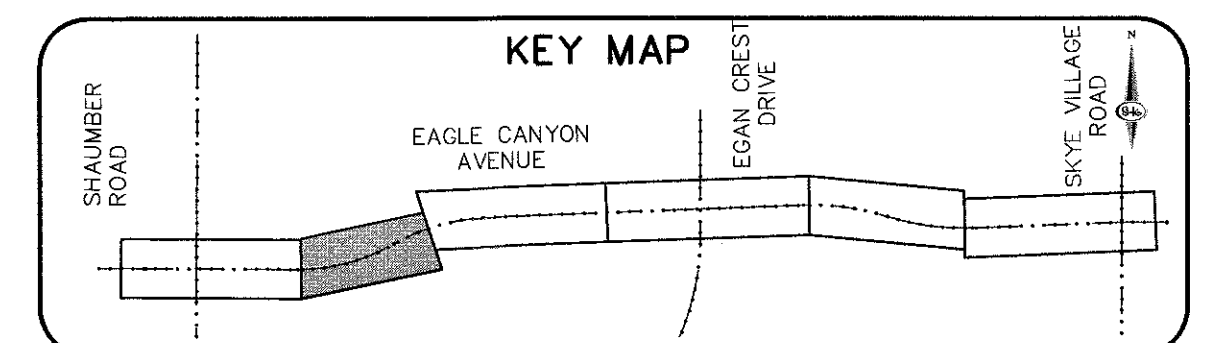

DATE: 11/19/15


DRAFTER: JAS

DESIGNER: DAM

CHECKED: JSR



PROJECT NO.

OLY1501-001

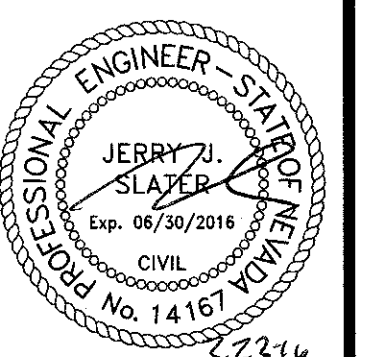

SD-15

SHEET 18 OF 33

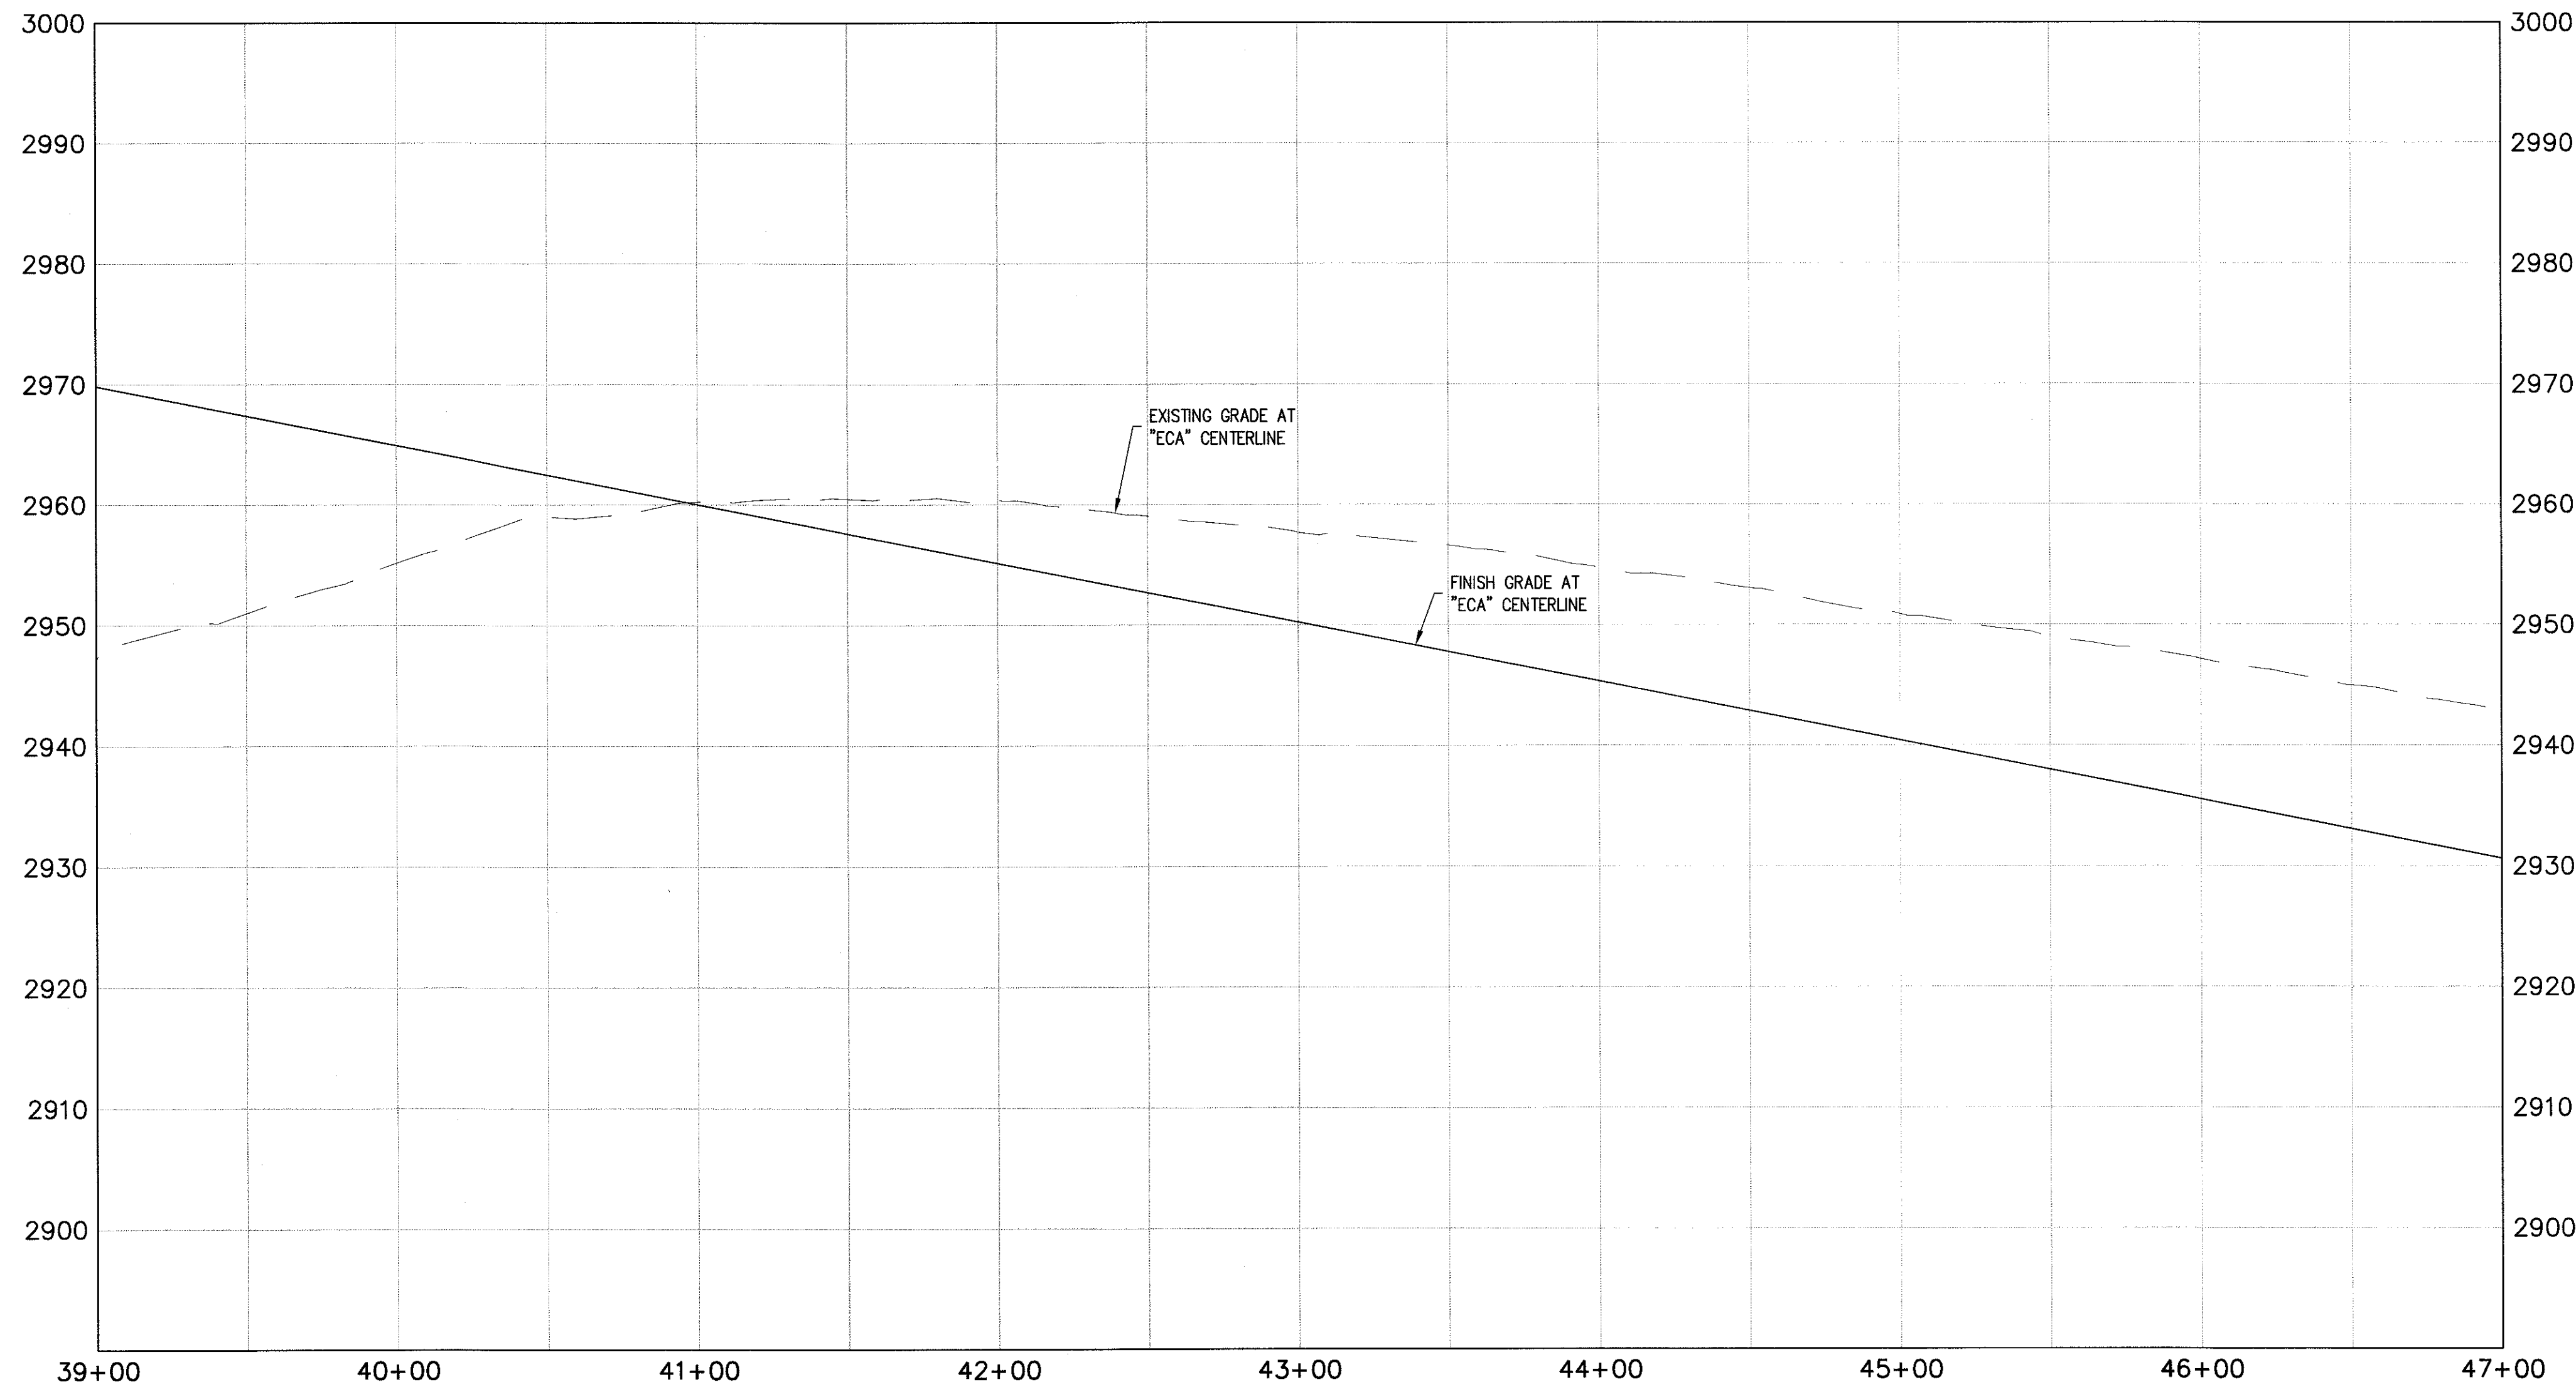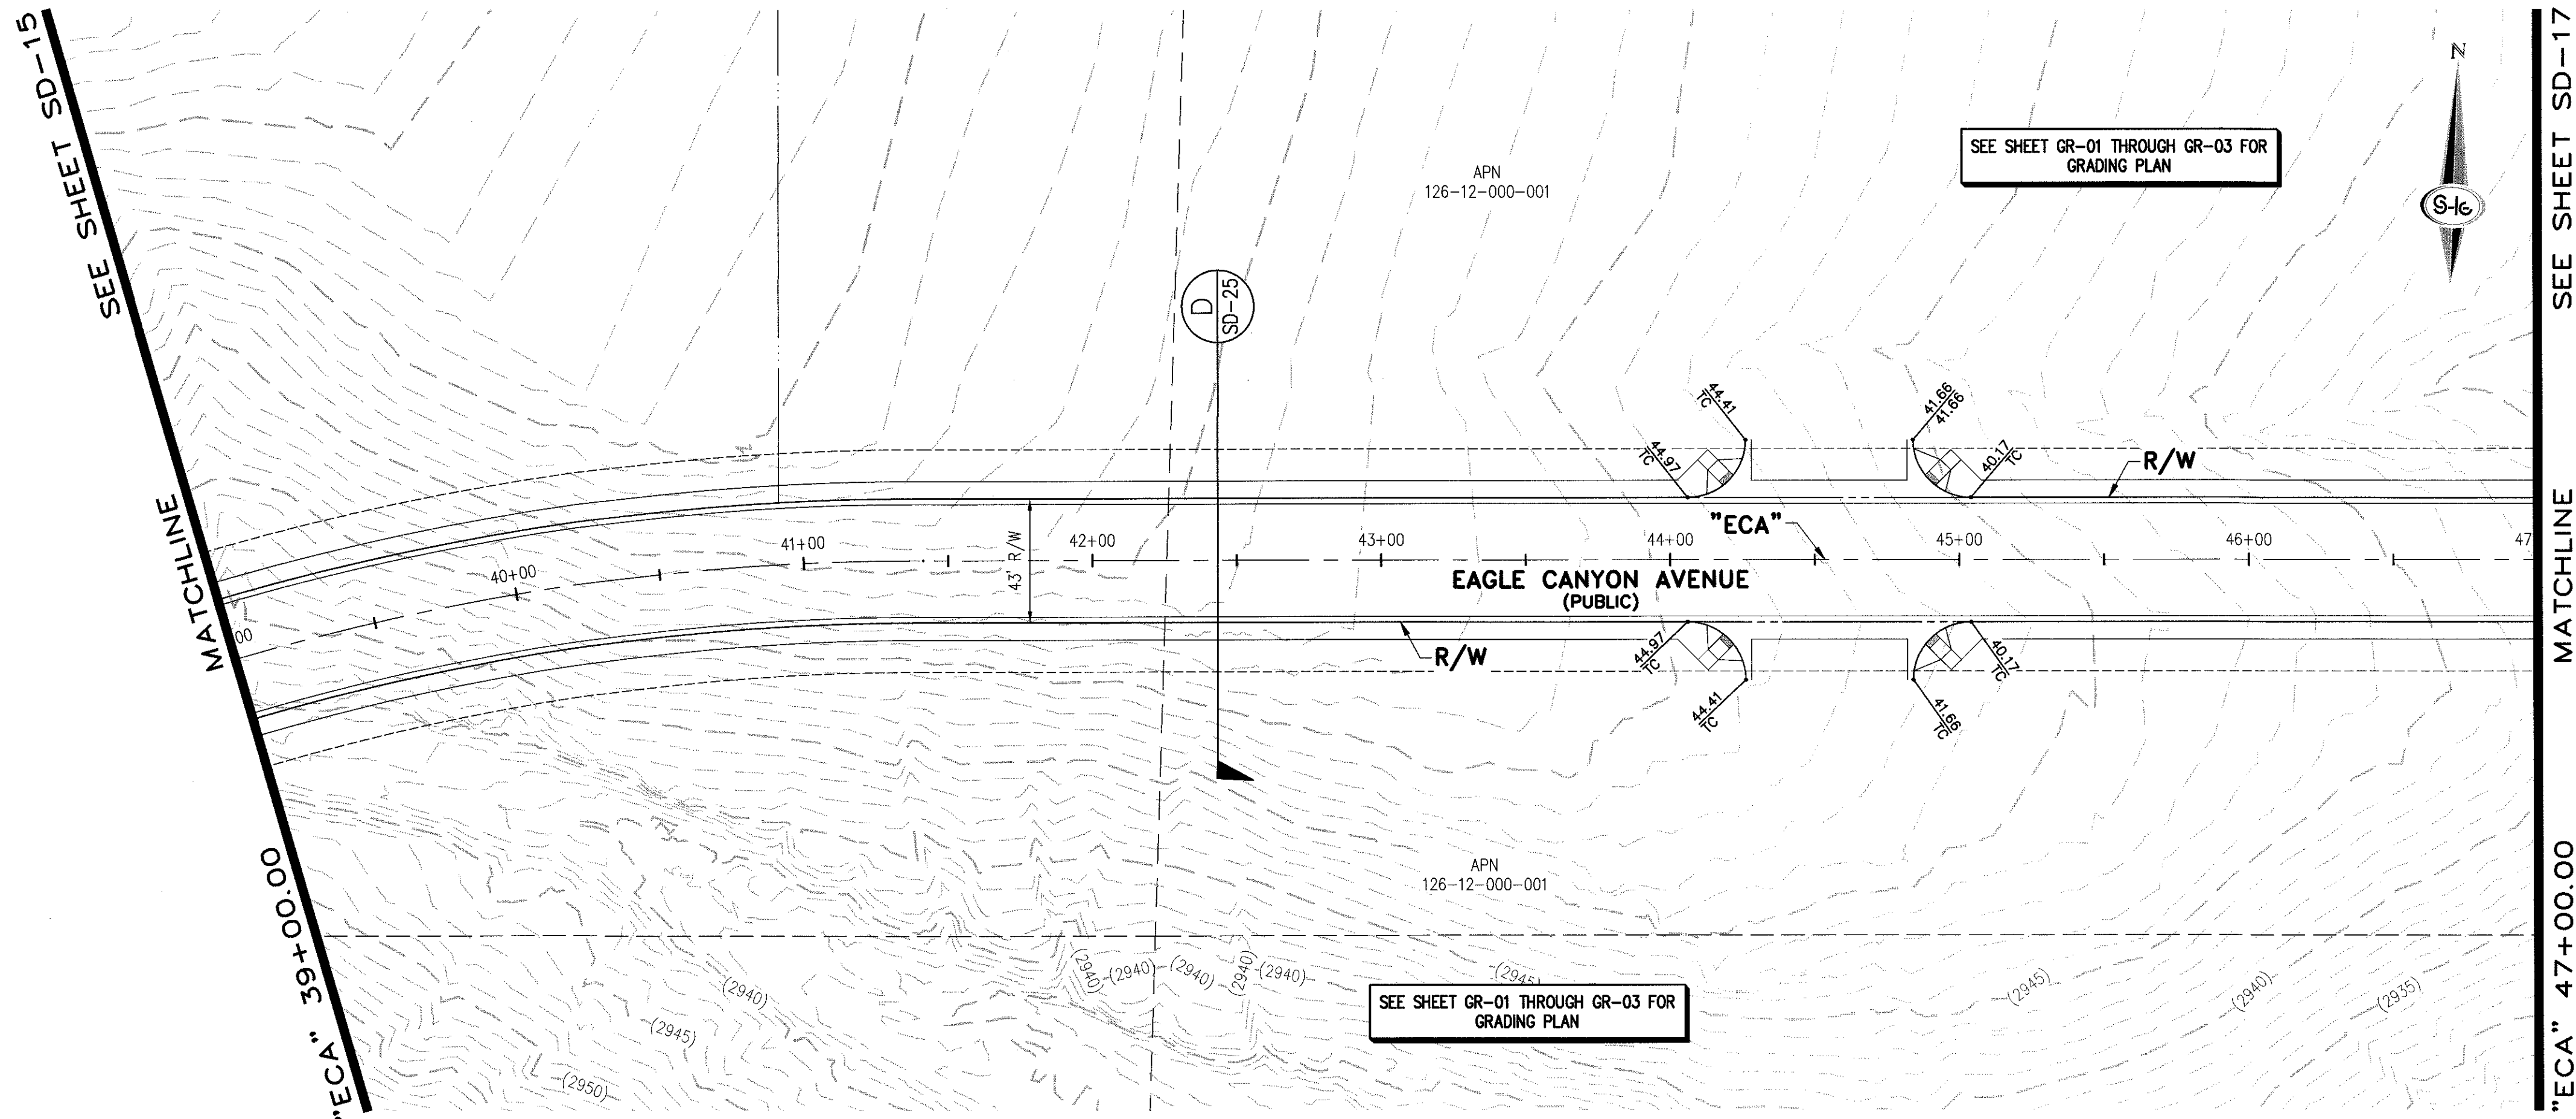

- ### STORM DRAIN NOTES
1. CONSTRUCT TYPE "CM2" DROP INLET (USDCCA STD. DWG. NO. 412.1)
 2. REMOVE EXISTING LATERAL STUB AND CONSTRUCT RCB PLUG (SEE DETAIL 5, DRAWING SD-26)
 3. CONSTRUCT 60" TYPE I MANHOLE (USDCCA STD. DWG. NO. 403.1)
 4. CONSTRUCT 60" TYPE III MANHOLE (USDCCA STD. DWG. NO. 406.1)
 5. CONSTRUCT 60" TYPE III MANHOLE WITH TYPE IA RISER (USDCCA STD. DWG. NO. 404.1 AND 406.1)
 6. CONSTRUCT NDOT TYPE 4 MANHOLE (NDOT STD. PLAN R-4.3.2)
 7. INSTALL 18" RCP (USDCCA STD. DWG. NO. 503.2)
 8. INSTALL 24" RCP (USDCCA STD. DWG. NO. 503.2)
 9. INSTALL 30" RCP (USDCCA STD. DWG. NO. 503.2)
 10. INSTALL 36" RCP (USDCCA STD. DWG. NO. 503.2)
 11. INSTALL 42" RCP (USDCCA STD. DWG. NO. 503.2)
 12. INSTALL 54" RCP (USDCCA STD. DWG. NO. 503.2)
 13. INSTALL 60" RCP (USDCCA STD. DWG. NO. 503.2)
 14. INSTALL 66" RCP (USDCCA STD. DWG. NO. 503.2)
 15. INSTALL 18" RCP END SECTION (NDOT STD. PLAN R-2.3.1)
 16. INSTALL 24" RCP END SECTION (NDOT STD. PLAN R-2.3.1)
 17. INSTALL 30" RCP END SECTION (NDOT STD. PLAN R-2.3.1)
 18. INSTALL 36" RCP END SECTION (NDOT STD. PLAN R-2.3.1)
 19. INSTALL 42" RCP END SECTION (NDOT STD. PLAN R-2.3.1)
 20. PIPE PENETRATION (SEE DETAIL 4, DRAWING SD-26)
 21. CONSTRUCT CONCRETE COLLAR (SEE DETAIL 2, DRAWING SD-26)
 22. CONSTRUCT BRICK AND MORTAR PLUG (SEE DETAIL 1, DRAWING SD-26)
 23. INSTALL 48" RCP (USDCCA STD. DWG. NO. 503.2)
 24. INSTALL 48" RCP END SECTION (NDOT STD. PLAN R-2.3.1)
 25. INSTALL DRIVEWAY (USDCCA STD. DWG. NO. 224)
 26. CONSTRUCT TYPE "CM" DROP INLET (USDCCA STD. DWG. NO. 422)

- ### NOTES
1. ALL RCP SHALL BE CLASS III UNLESS OTHERWISE SHOWN.
 2. ALL PIPE LENGTHS ARE MEASURED ALONG PIPE CENTERLINE TO CENTER OF MANHOLE OR INSIDE EDGE OF DI OR RCB/RCA.
 3. ALL DROP INLETS SHALL INCLUDE STORM WATER MANAGEMENT STAMP AND DETAIL PER USDCCA STD. DWG. NO. 421.
 4. SEE STRUCTURAL PLANS FOR ADDITIONAL STRUCTURAL DETAILS AND CONNECTIONS.
 5. ALL PIPES ARE PUBLICLY MAINTAINED.
 6. ADD SPECIAL INSPECTION REQUIRED FOR PIPE SEGMENTS WITH SACRIFICIAL CONCRETE.

DROP INLET NOTE

WHERE 10 FEET PARALLEL SEPARATION IS NOT PRACTICABLE:
CAST-IN-PLACE MONOLITHIC POUR WITH WATERSTOP BETWEEN SLAB AND WALLS.
BASE, WALLS AND TOP TO BE CONSTRUCTED WITH WATERSTOPS, CENTER BULB,
OR FLAT STRIP (VINYLEX, GREENSTREAK PLASTIC PRODUCTS OR APPROVED EQUAL).

LEGEND

1 STORM DRAIN LATERAL # (SEE SHEETS SD-20 THRU SD-24)

I CERTIFY THAT THIS GRADING PLAN IS IN CONFORMANCE WITH THE APPROVED TECHNICAL DRAINAGE STUDY DS-4759A ON FILE AT THE CITY OF LAS VEGAS FOR THE SUBJECT PROJECT.


JERRY SLATER P.E. 14167 DATE 3/22/24

FLOOD ZONE

THE PROJECT SITE IS LOCATED WITHIN A FEMA DESIGNATED ZONE "X" (OUTSIDE THE 500-YEAR FLOOD PLAIN) ON THE FLOOD INSURANCE RATE MAP (FIRM) PANEL:32003C1750E, DATED SEPTEMBER 27, 2002

NOTE:

PROPERTY OWNER IS RESPONSIBLE TO MAINTAIN THE BEST MANAGEMENT PRACTICES, SUCH AS BUT NOT LIMITED TO, THE REMOVAL OF ACCUMULATED SEDIMENT AND DEBRIS AND CARE OF VEGETATION.

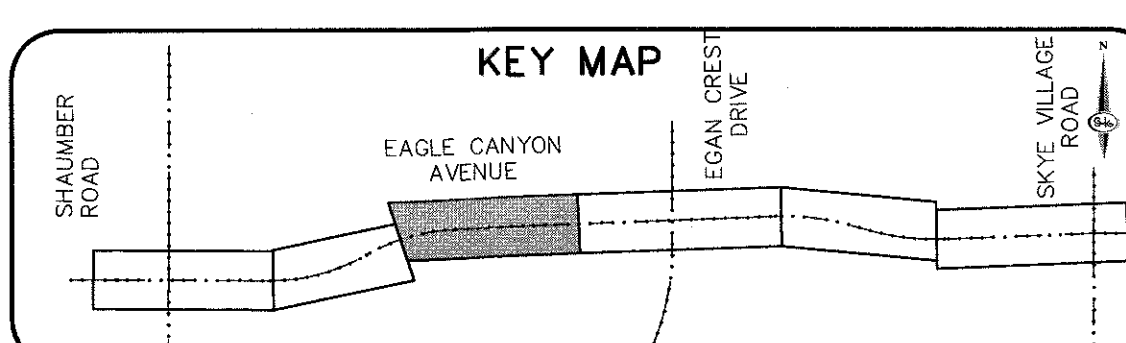



SLATER HANFAN GROUP
CONSULTING ENGINEERS & PLANNERS
5740 S. ARVILLE STREET #216, LAS VEGAS, NV 89118
PHONE (702) 284-5300 FAX (702) 284-5399

NINETY-FIVE MANAGEMENT LLC

SKYE CANYON PHASE 2
EAGLE CANYON AVENUE PLAN AND PROFILE
"ECA" 39+00.00 TO "ECA" 47+00.00

DATE: 11/19/15
DRAFTER: JAS
DESIGNER: DAM
CHECKED: JSR
PROJECT NO.
OLY1501-001

SD-16
SHEET 19 OF 33

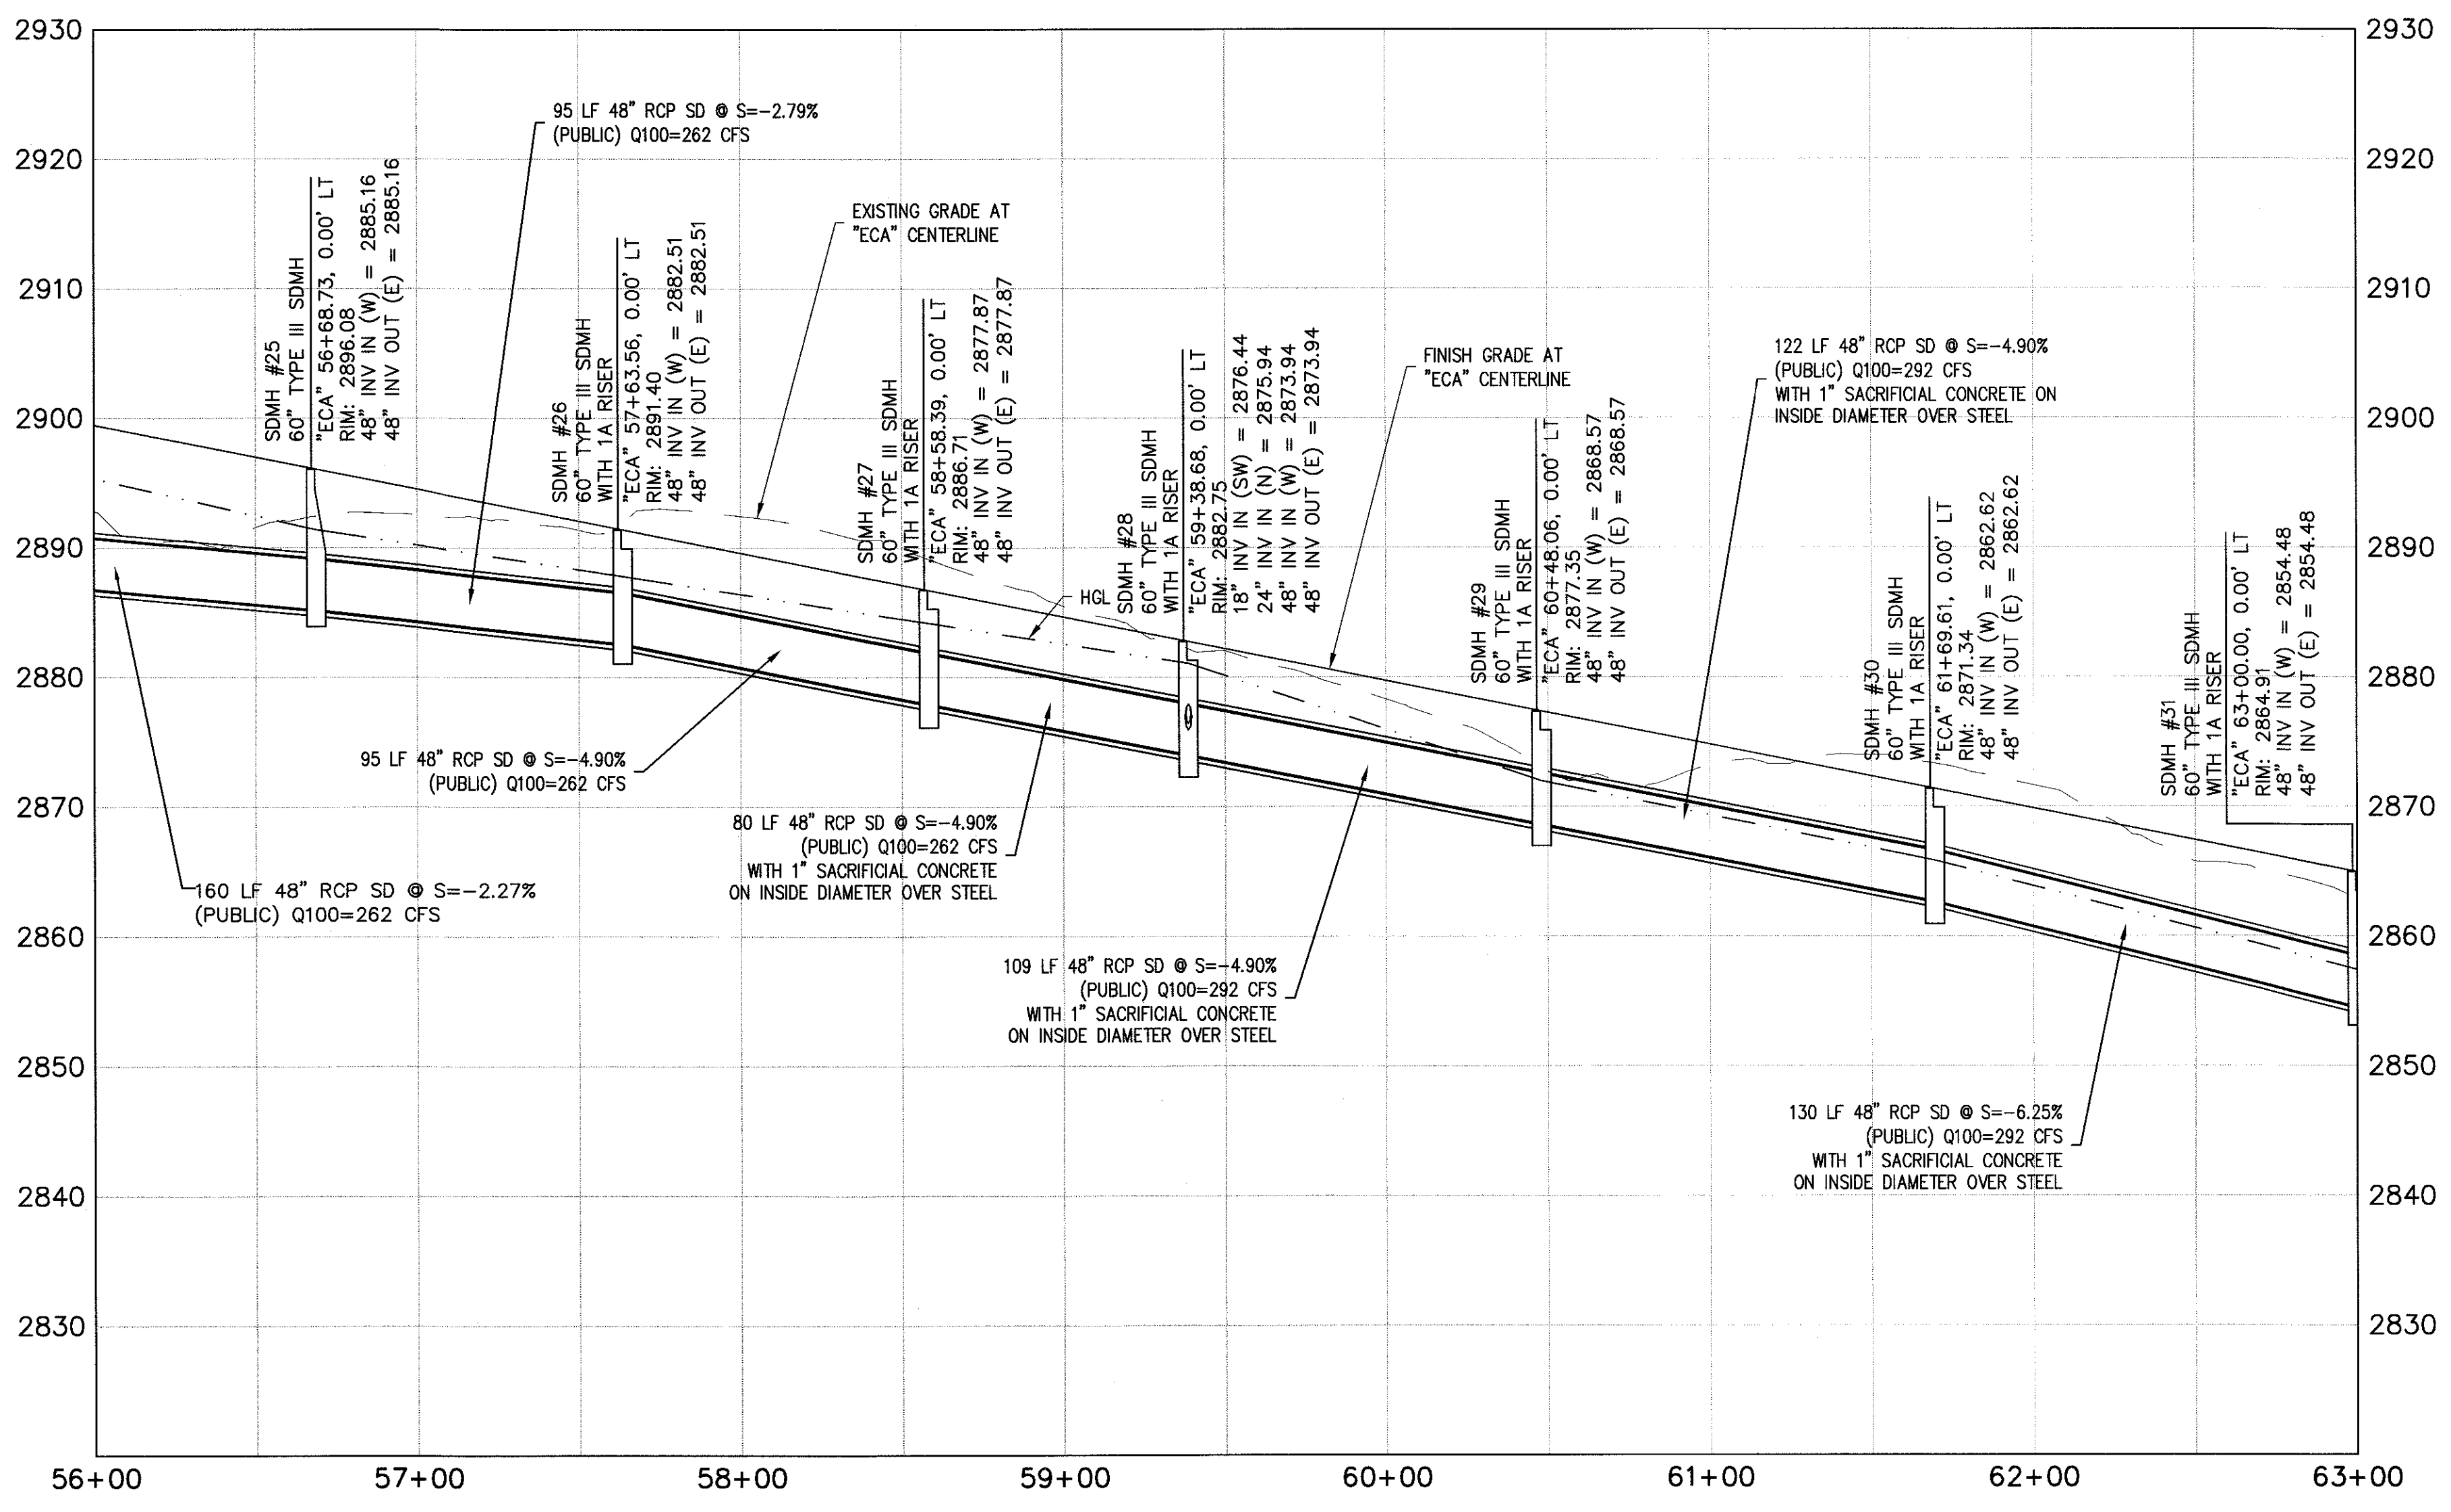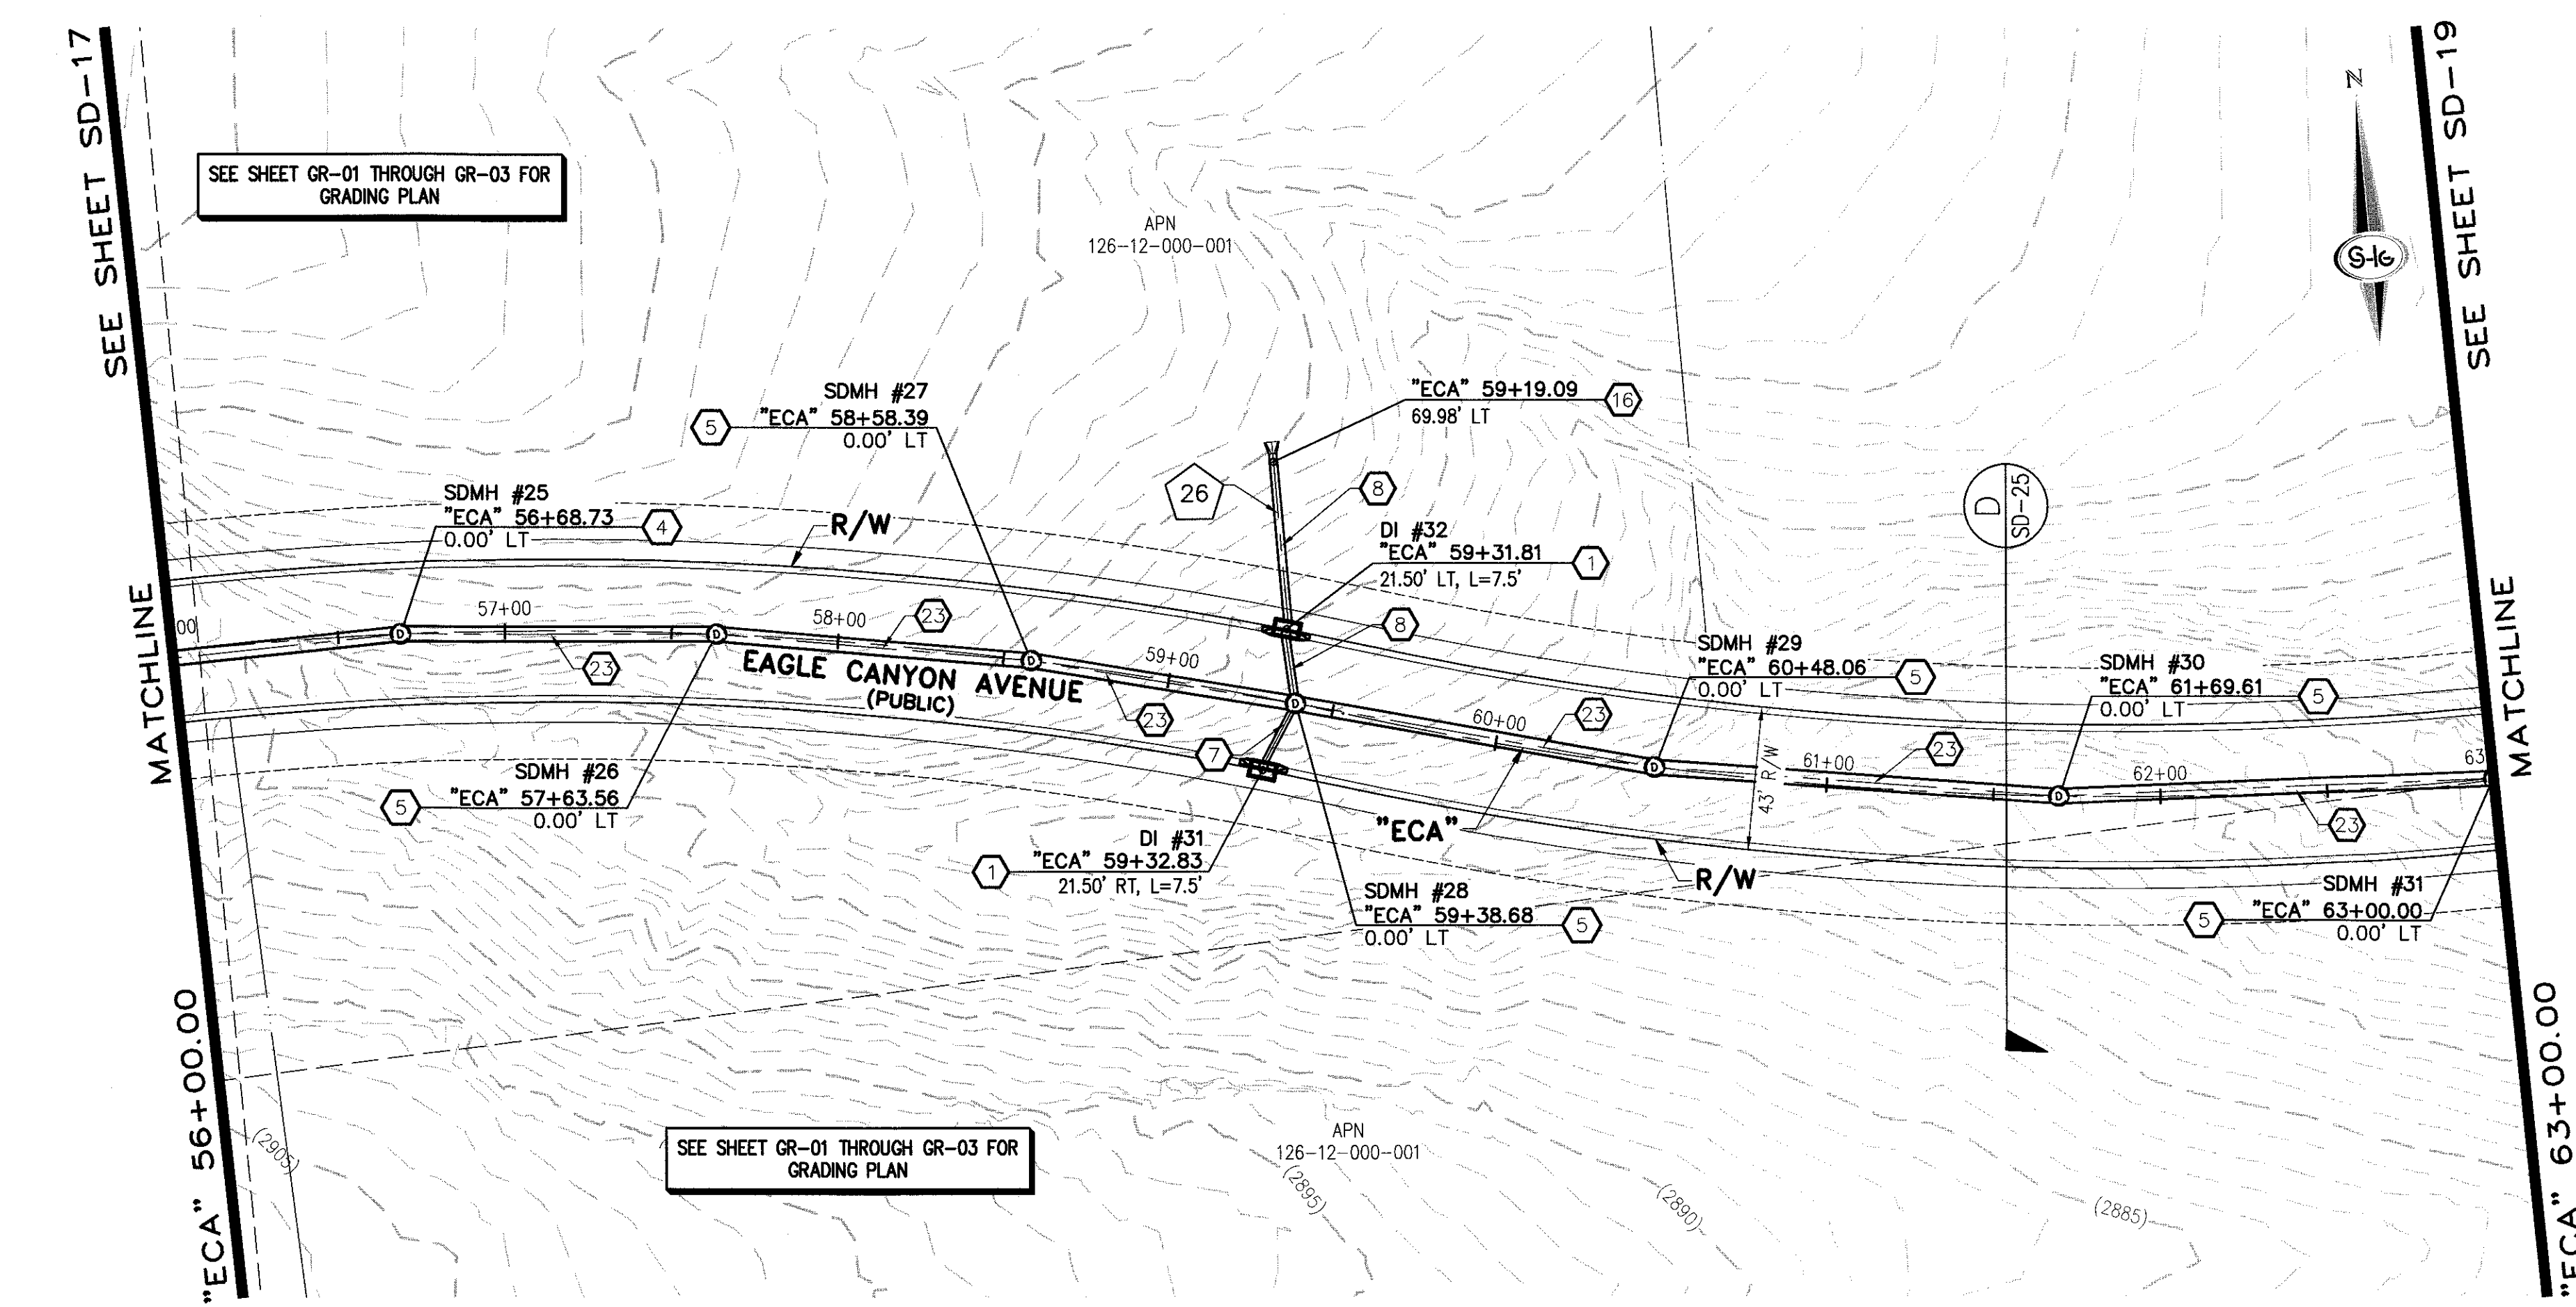

STORM DRAIN NOTES

1. CONSTRUCT TYPE "CM2" DROP INLET (USDCCA STD. DWG. NO. 412.1)
2. REMOVE EXISTING LATERAL STUB AND CONSTRUCT RCB PLUG (SEE DETAIL 5, DRAWING SD-26)
3. CONSTRUCT 60" TYPE I MANHOLE (USDCCA STD. DWG. NO. 403.1)
4. CONSTRUCT 60" TYPE III MANHOLE (USDCCA STD. DWG. NO. 406.1)
5. CONSTRUCT 60" TYPE III MANHOLE WITH TYPE IA RISER (USDCCA STD. DWG. NO. 404.1 AND 406.1)
6. CONSTRUCT NDOT TYPE 4 MANHOLE (NDOT STD. PLAN R-4.3.2)
7. INSTALL 18" RCP (USDCCA STD. DWG. NO. 503.2)
8. INSTALL 24" RCP (USDCCA STD. DWG. NO. 503.2)
9. INSTALL 30" RCP (USDCCA STD. DWG. NO. 503.2)
10. INSTALL 36" RCP (USDCCA STD. DWG. NO. 503.2)
11. INSTALL 42" RCP (USDCCA STD. DWG. NO. 503.2)
12. INSTALL 54" RCP (USDCCA STD. DWG. NO. 503.2)
13. INSTALL 60" RCP (USDCCA STD. DWG. NO. 503.2)
14. INSTALL 66" RCP (USDCCA STD. DWG. NO. 503.2)
15. INSTALL 18" RCP END SECTION (NDOT STD. PLAN R-2.3.1)
16. INSTALL 24" RCP END SECTION (NDOT STD. PLAN R-2.3.1)
17. INSTALL 30" RCP END SECTION (NDOT STD. PLAN R-2.3.1)
18. INSTALL 36" RCP END SECTION (NDOT STD. PLAN R-2.3.1)
19. INSTALL 42" RCP END SECTION (NDOT STD. PLAN R-2.3.1)
20. PIPE PENETRATION (SEE DETAIL 4, DRAWING SD-26)
21. CONSTRUCT CONCRETE COLLAR (SEE DETAIL 2, DRAWING SD-26)
22. CONSTRUCT BRICK AND MORTAR PLUG (SEE DETAIL 1, DRAWING SD-26)
23. INSTALL 48" RCP (USDCCA STD. DWG. NO. 503.2)
24. INSTALL 48" RCP END SECTION (NDOT STD. PLAN R-2.3.1)
25. INSTALL DRIVEWAY (USDCCA STD. DWG. NO. 224)
26. CONSTRUCT TYPE "CM" DROP INLET (USDCCA STD. DWG. NO. 422)

NOTES

1. ALL RCP SHALL BE CLASS III UNLESS OTHERWISE SHOWN.
2. ALL PIPE LENGTHS ARE MEASURED ALONG PIPE CENTERLINE TO CENTER OF MANHOLE OR INSIDE EDGE OF DI OR RCB/RCA.
3. ALL DROP INLETS SHALL INCLUDE STORM WATER MANAGEMENT STAMP AND DETAIL PER USDCCA STD. DWG. NO. 421.
4. SEE STRUCTURAL PLANS FOR ADDITIONAL STRUCTURAL DETAILS AND CONNECTIONS.
5. ALL PIPES ARE PUBLICLY MAINTAINED.
6. ADD SPECIAL INSPECTION REQUIRED FOR PIPE SEGMENTS WITH SACRIFICIAL CONCRETE.

DROP INLET NOTE

WHERE 10 FEET PARALLEL SEPARATION IS NOT PRACTICABLE, CAST-IN-PLACE MONOLITHIC POUR WITH WATERSTOP BETWEEN SLAB AND WALLS. BASE, WALLS AND TOP TO BE CONSTRUCTED WITH WATERSTOPS, CENTER BULB, OR FLAT STRIP (VINYLEX, GREENSTREAK PLASTIC PRODUCTS OR APPROVED EQUAL).

LEGEND

- 1 STORM DRAIN LATERAL # (SEE SHEETS SD-20 THRU SD-24)


FLOOD ZONE

I CERTIFY THAT THIS GRADING PLAN IS IN CONFORMANCE WITH THE APPROVED TECHNICAL DRAINAGE STUDY DS-4739A ON FILE AT THE CITY OF LAS VEGAS FOR THE SUBJECT PROJECT.

JERRY SLATER, P.E. 44167 DATE 3/22/14

THE PROJECT SITE IS LOCATED WITHIN A FEMA DESIGNATED ZONE "X" (OUTSIDE THE 500-YEAR FLOOD PLAIN) ON THE FLOOD INSURANCE RATE MAP (FIRM) PANEL: 32003C1750E, DATED SEPTEMBER 27, 2002.

NOTE:
PROPERTY OWNER IS RESPONSIBLE TO MAINTAIN THE BEST MANAGEMENT PRACTICES, SUCH AS BUT NOT LIMITED TO, THE REMOVAL OF ACCUMULATED SEDIMENT AND DEBRIS AND CARE OF VEGETATION.

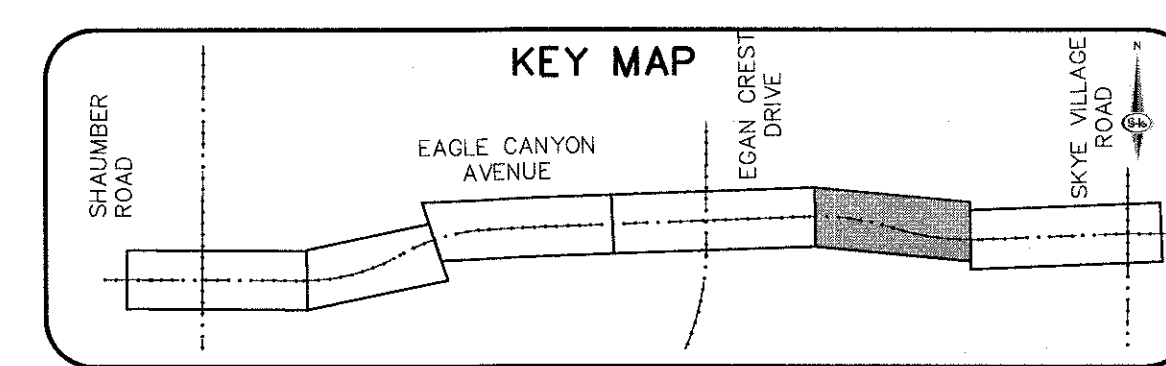

AVOID HITTING OVERHEAD POWER LINES. IT'S YOUR RESPONSIBILITY TO KNOW WHERE THEY ARE.

CALL BEFORE YOU DIG

1-702-227-2929

FAST

Call before you Dig

1-702-432-5300

FAST

Call before you Dig

811

1-800-227-2600

SLATER HANIFAN GROUP

CONSULTING ENGINEERS & PLANNERS

5740 S. ARVILLE STREET #216, LAS VEGAS, NV 89118

PHONE (702) 284-5300 FAX (702) 284-5398

NINETY-FIVE MANAGEMENT LLC

SKYE CANYON PHASE 2

EAGLE CANYON AVENUE PLAN AND PROFILE

"ECA" 56+00.00 TO "ECA" 63+00.00

DATE: 11/19/15

DRAFTER: JAS

DESIGNER: DAM







CHECKED: JSR







PROJECT NO.







OLY1501-001






SD-18







SHEET 21 OF 33

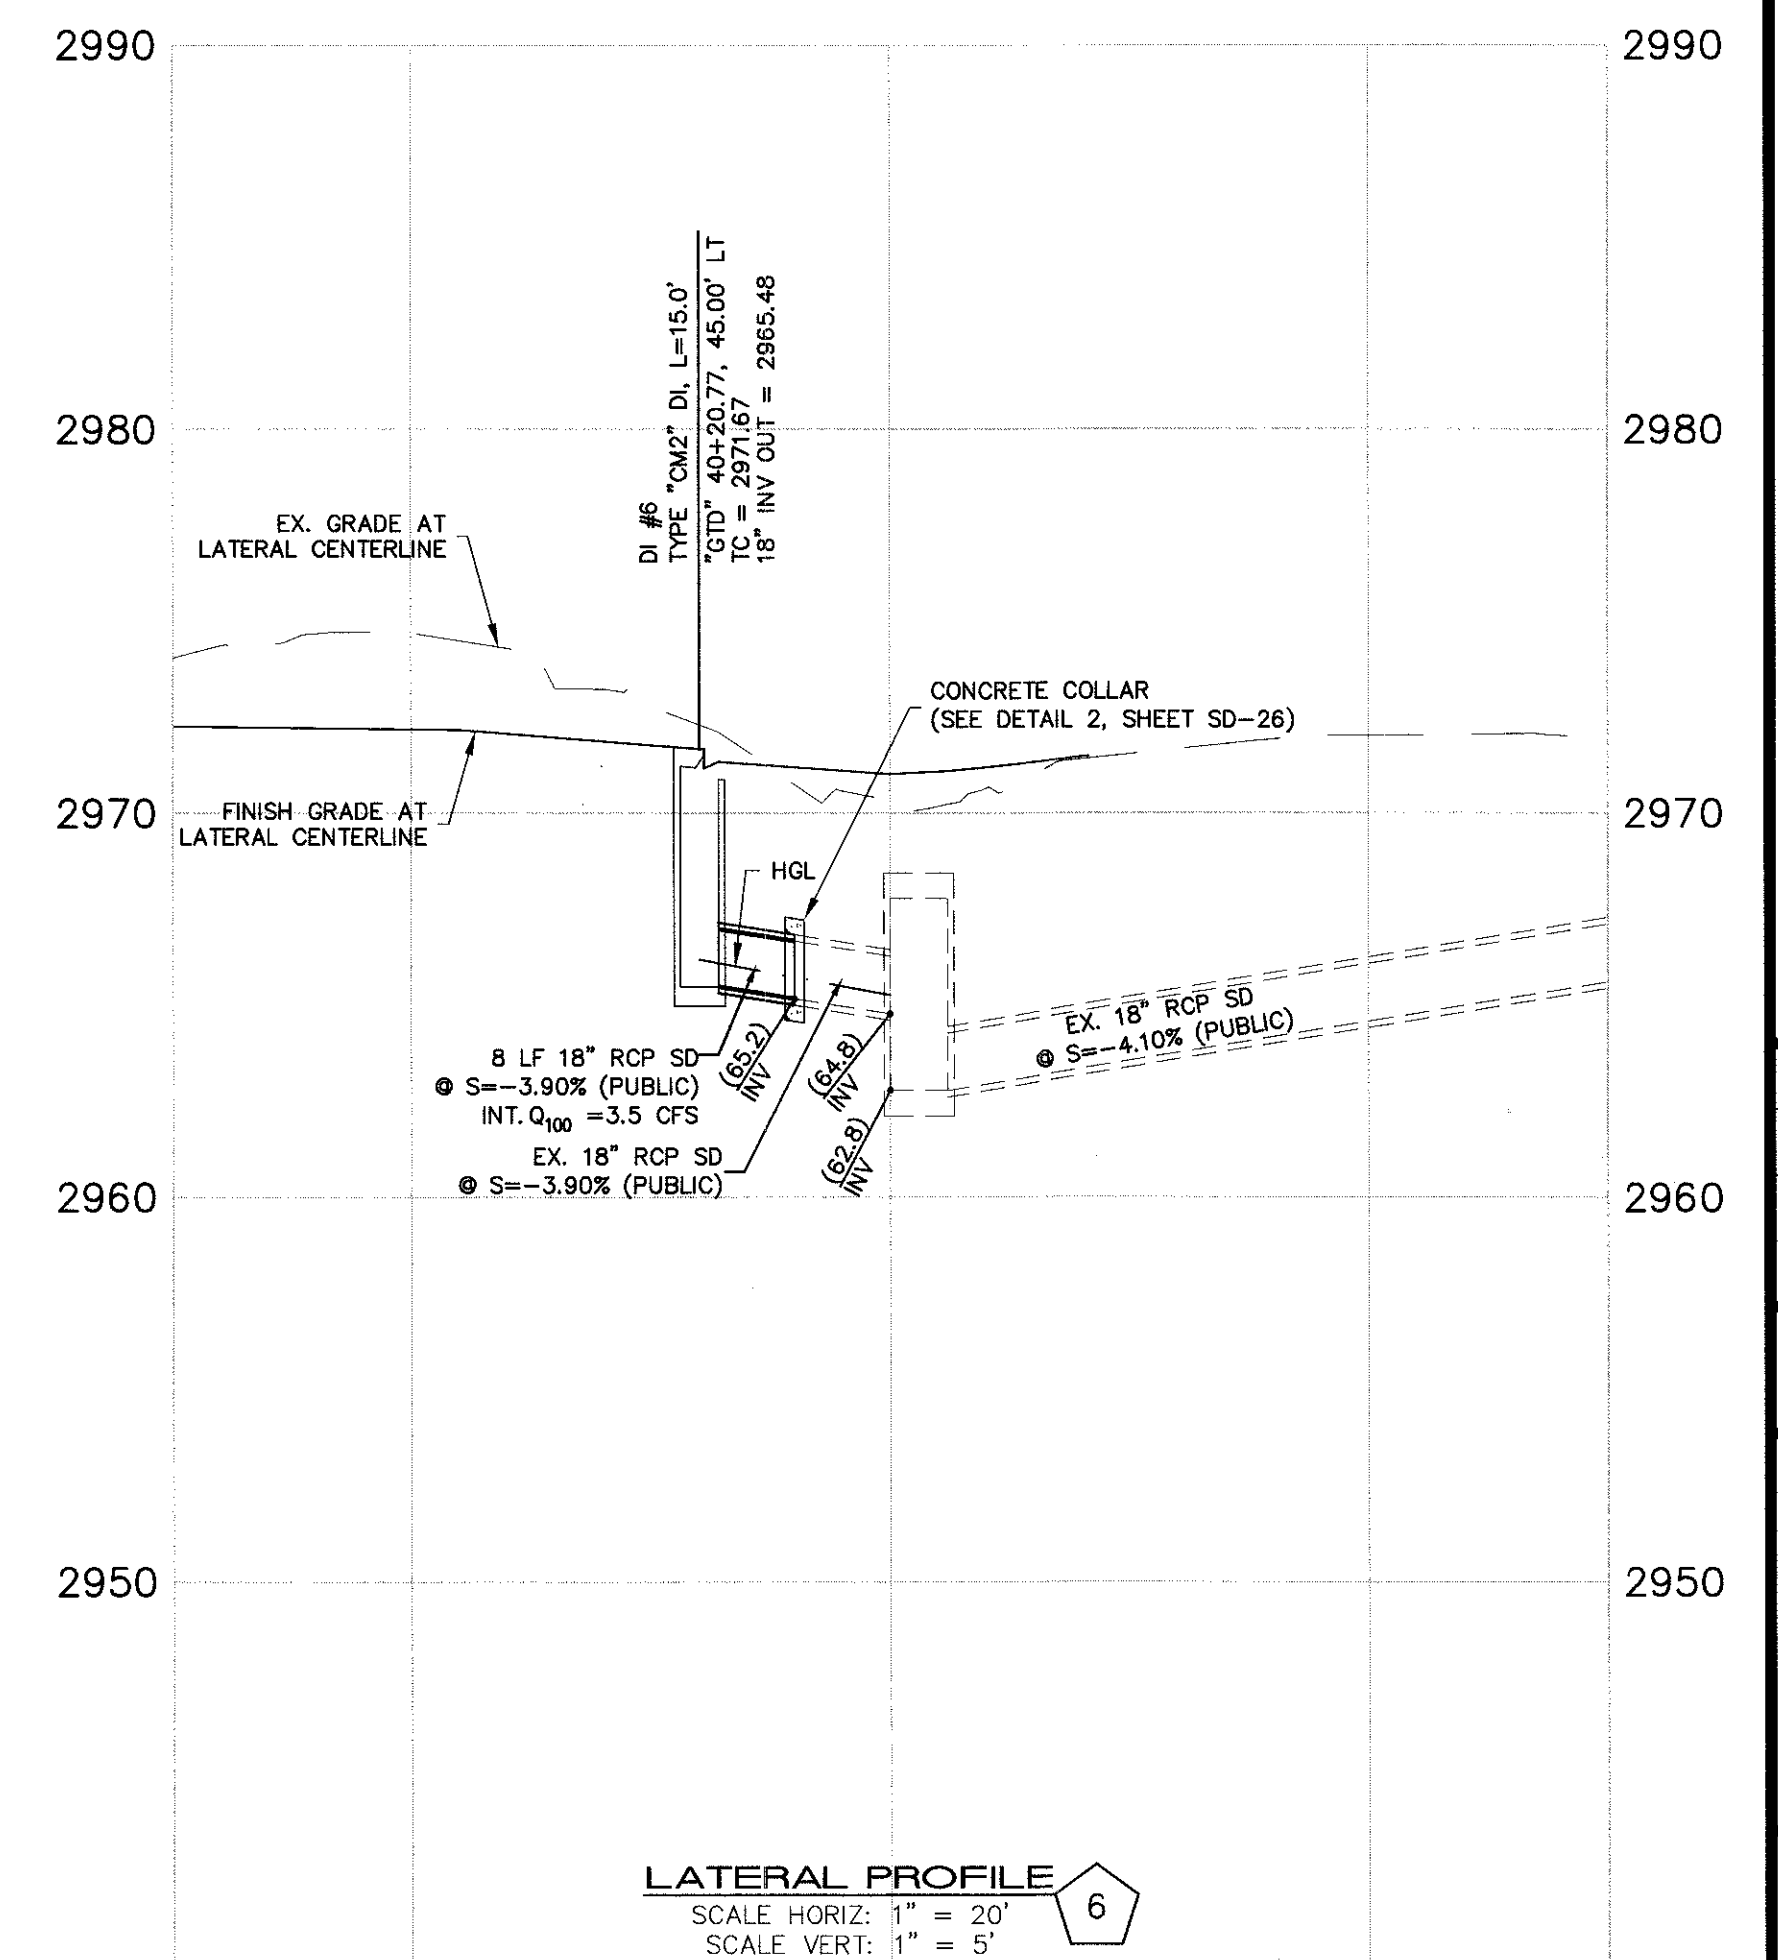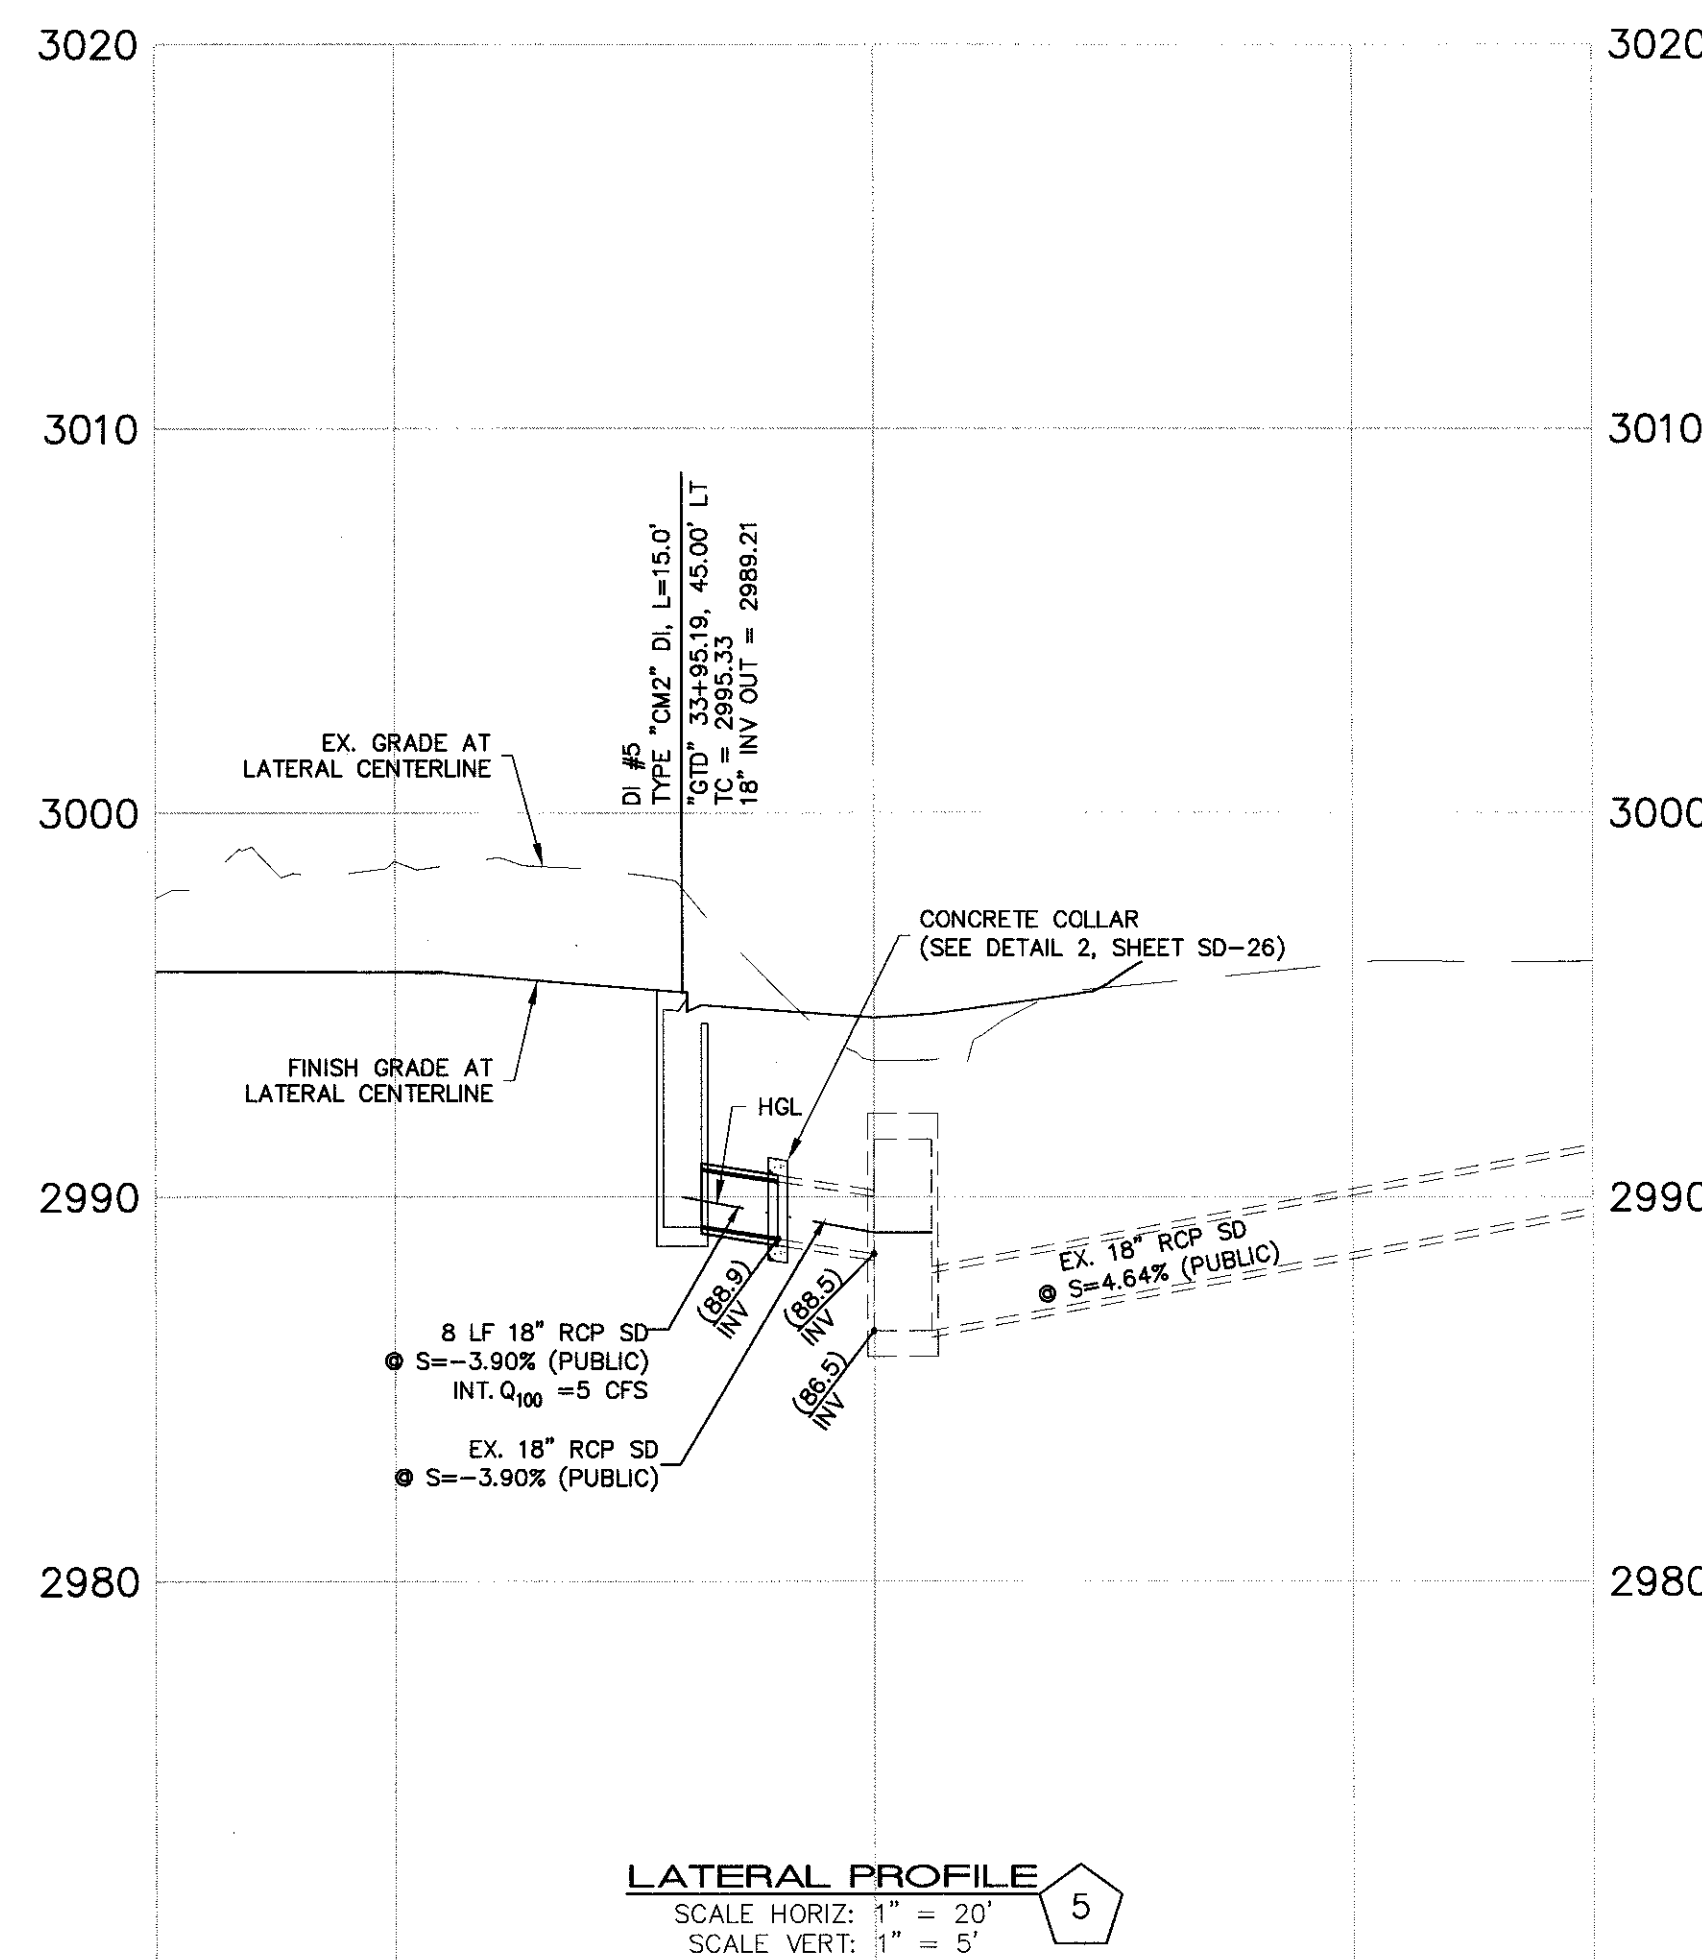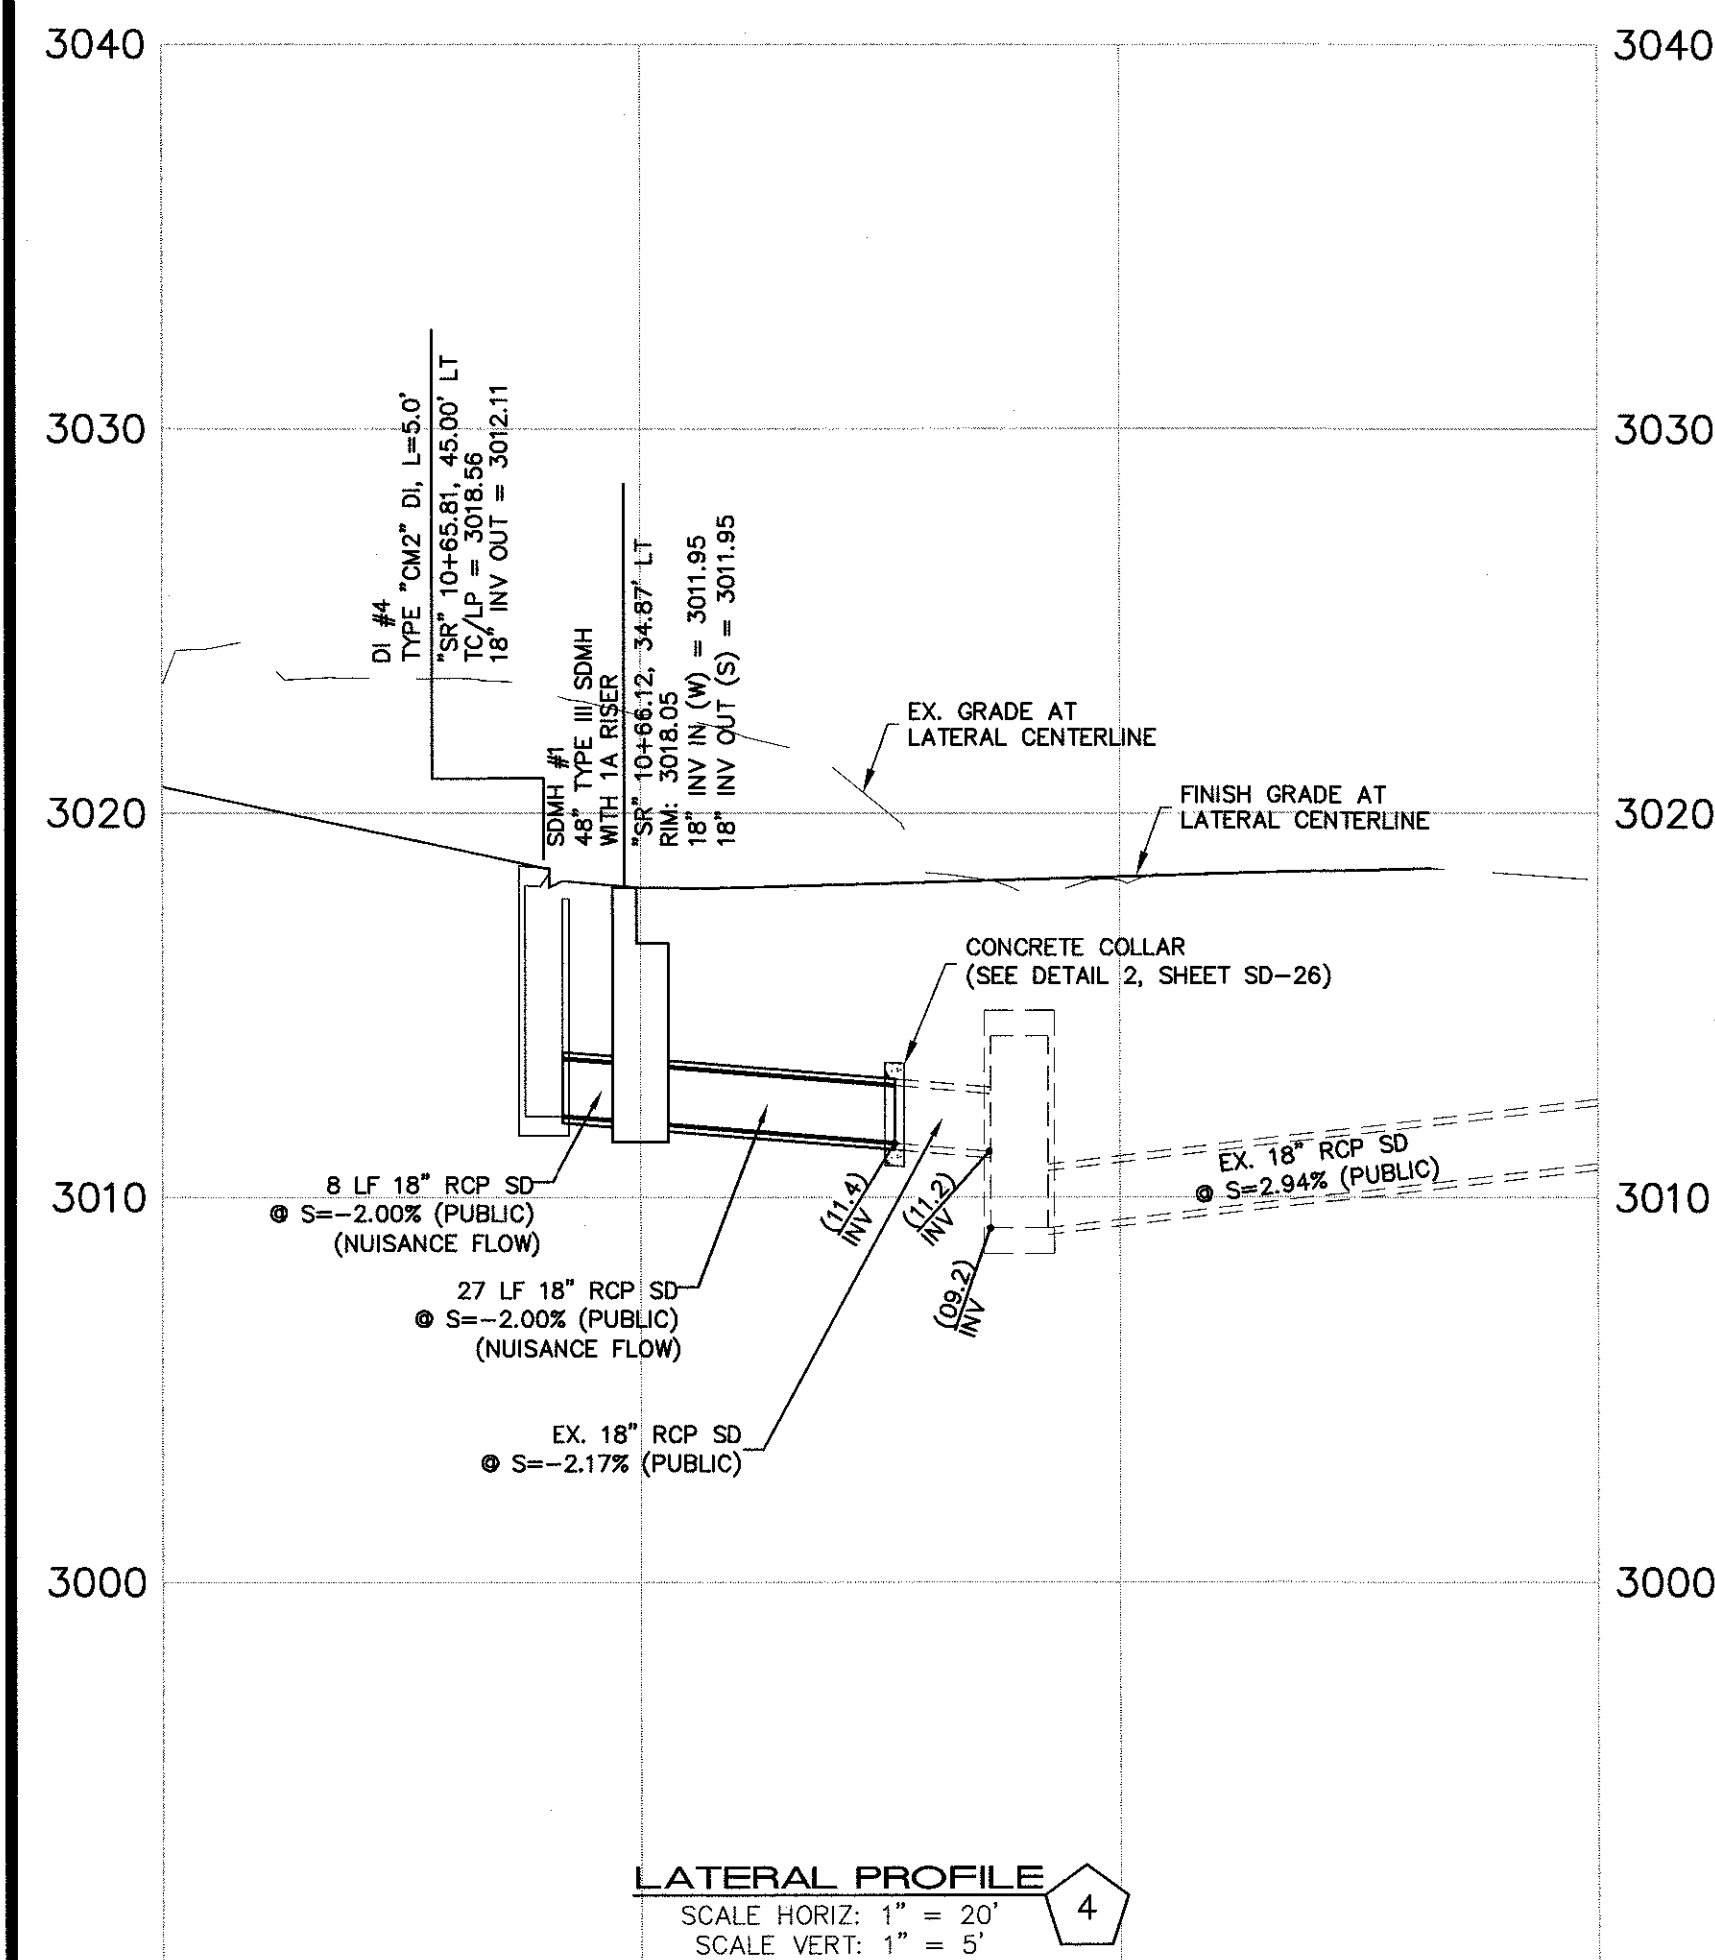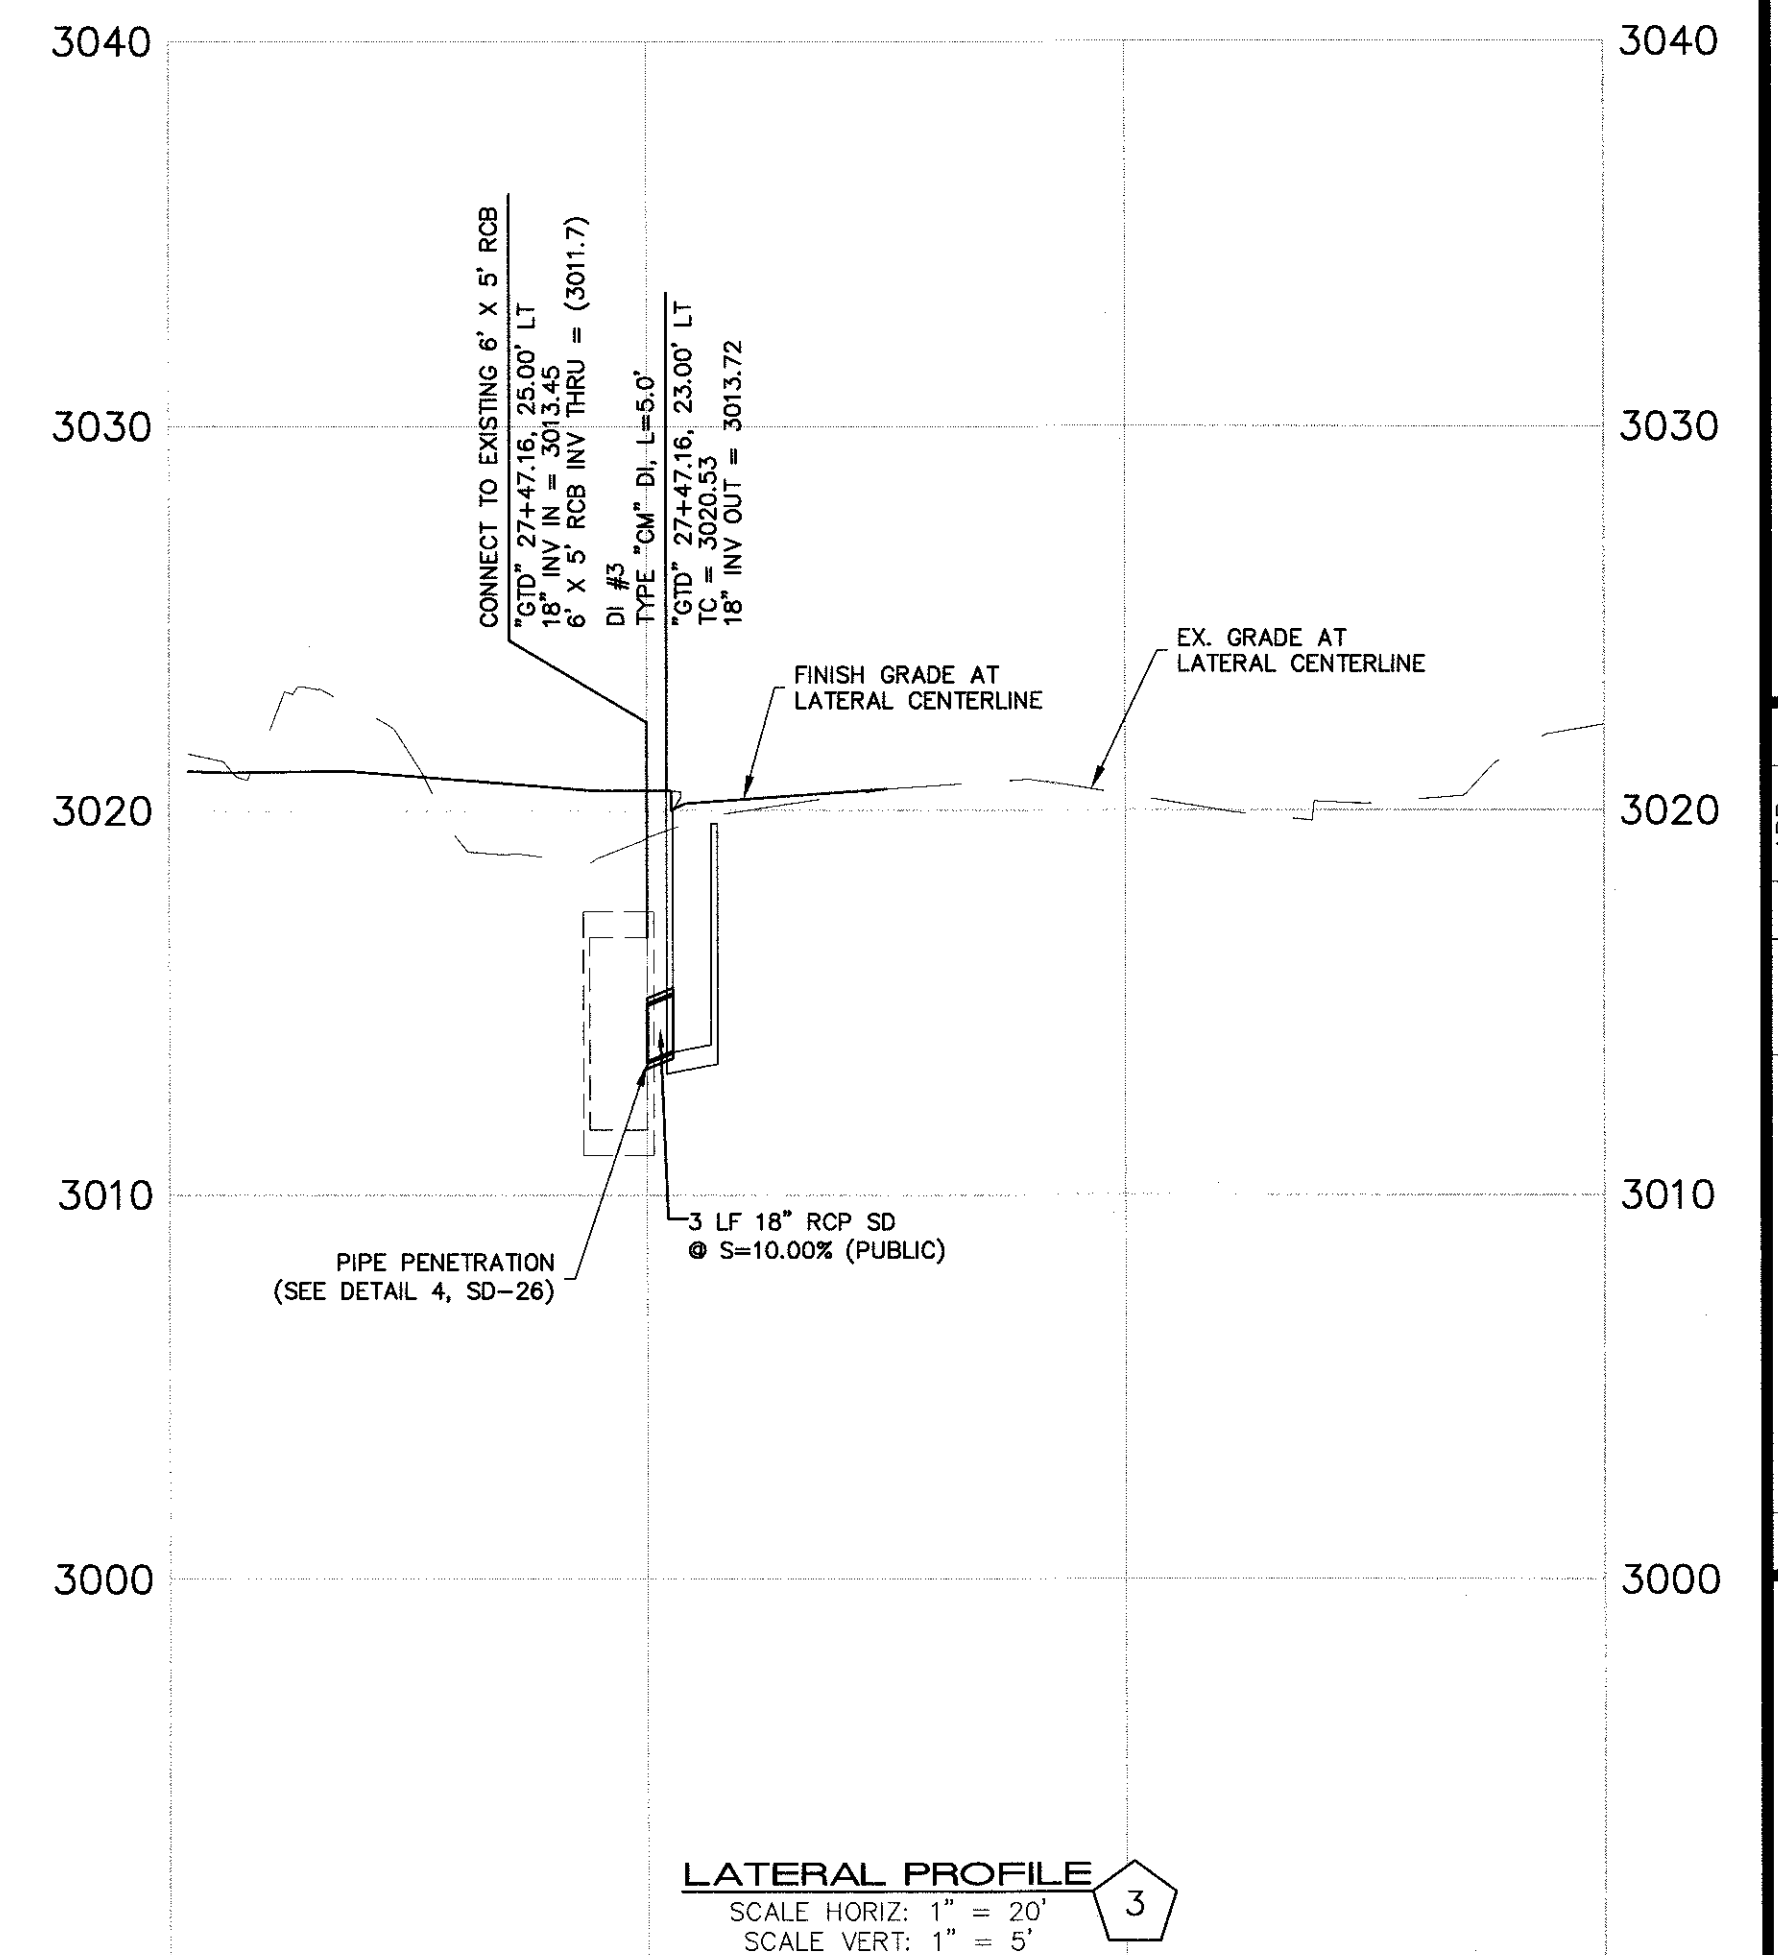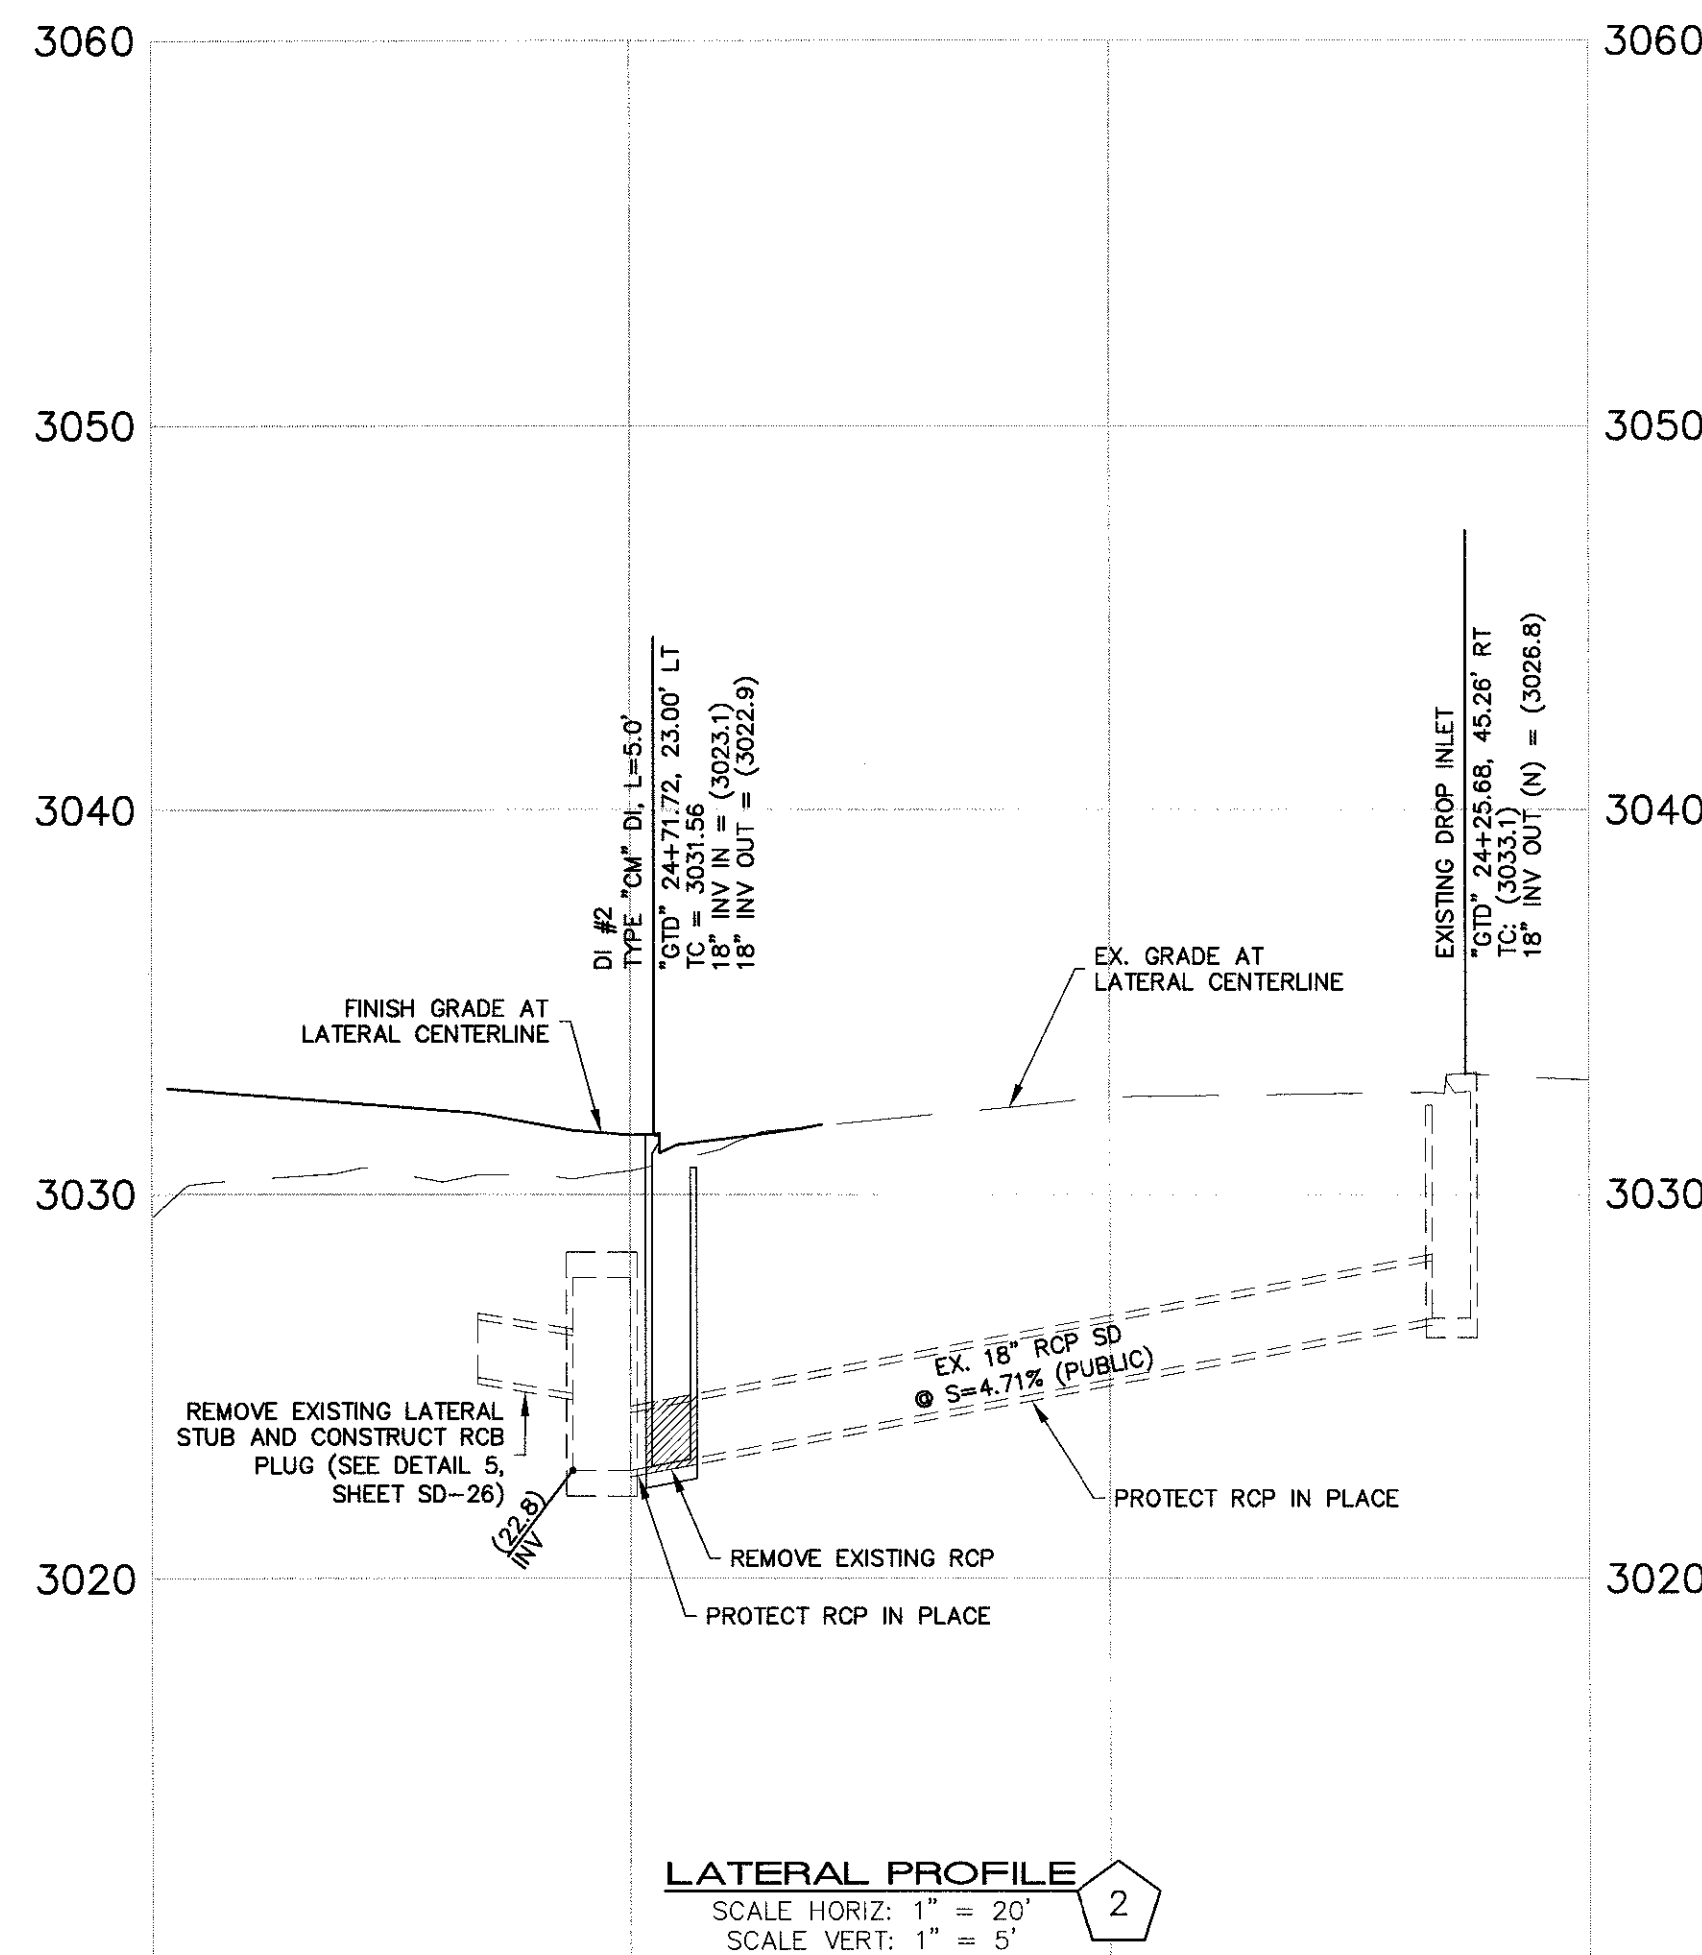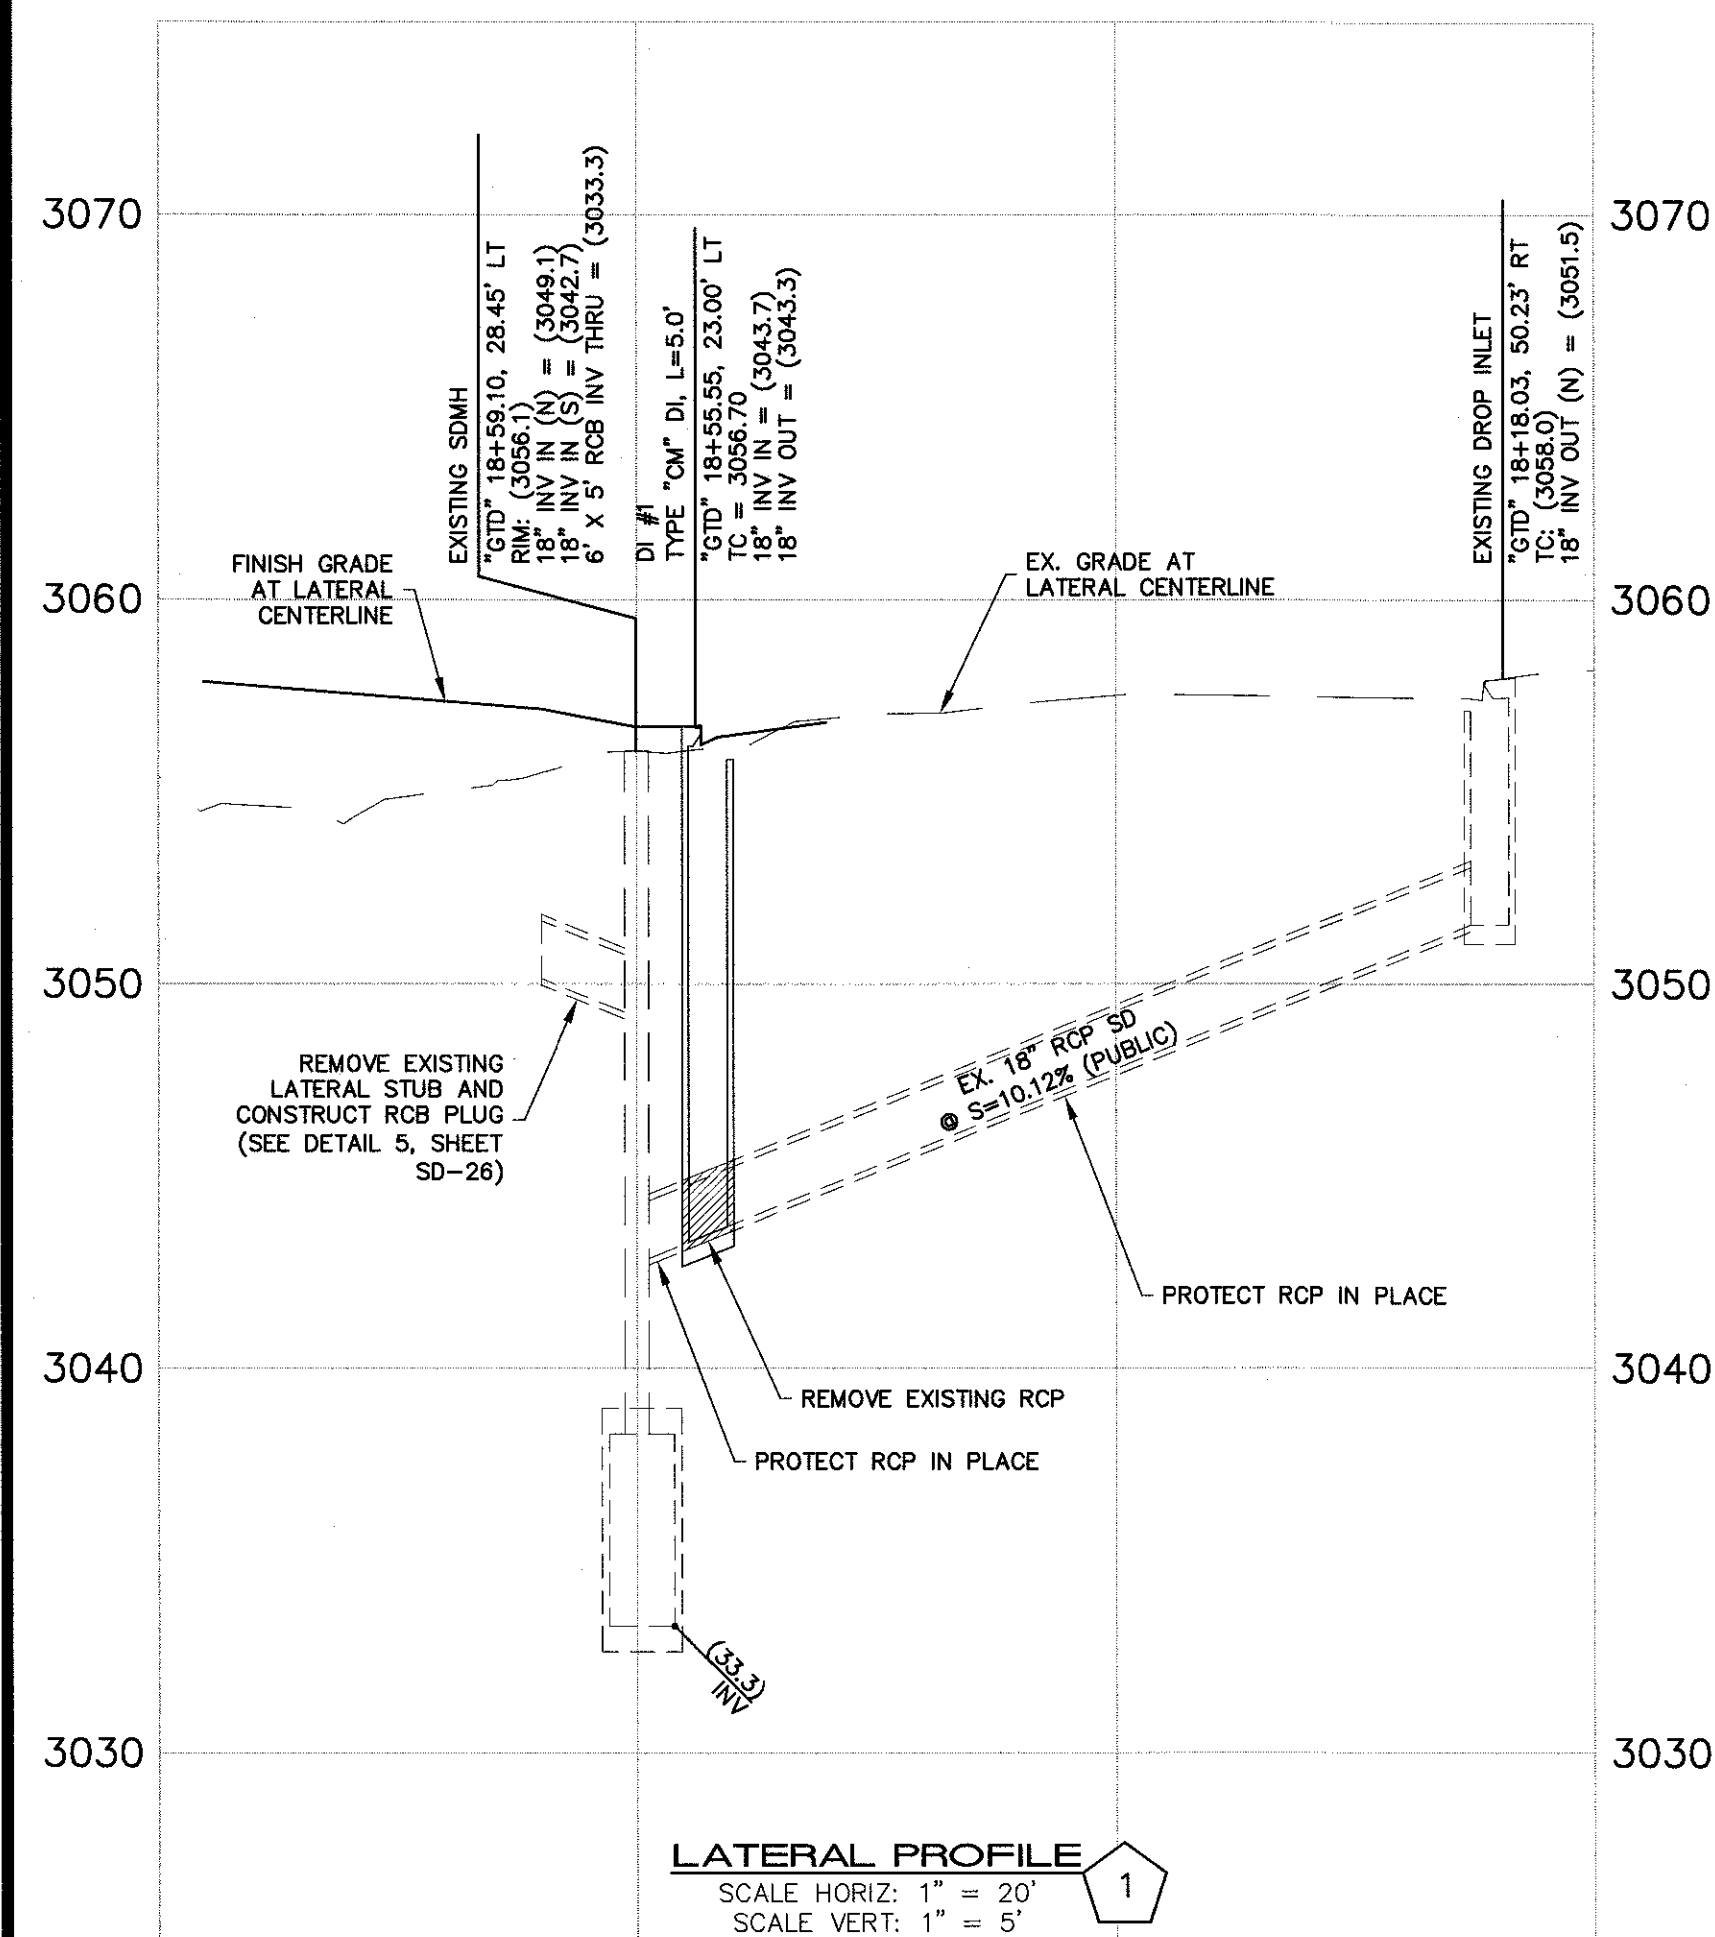

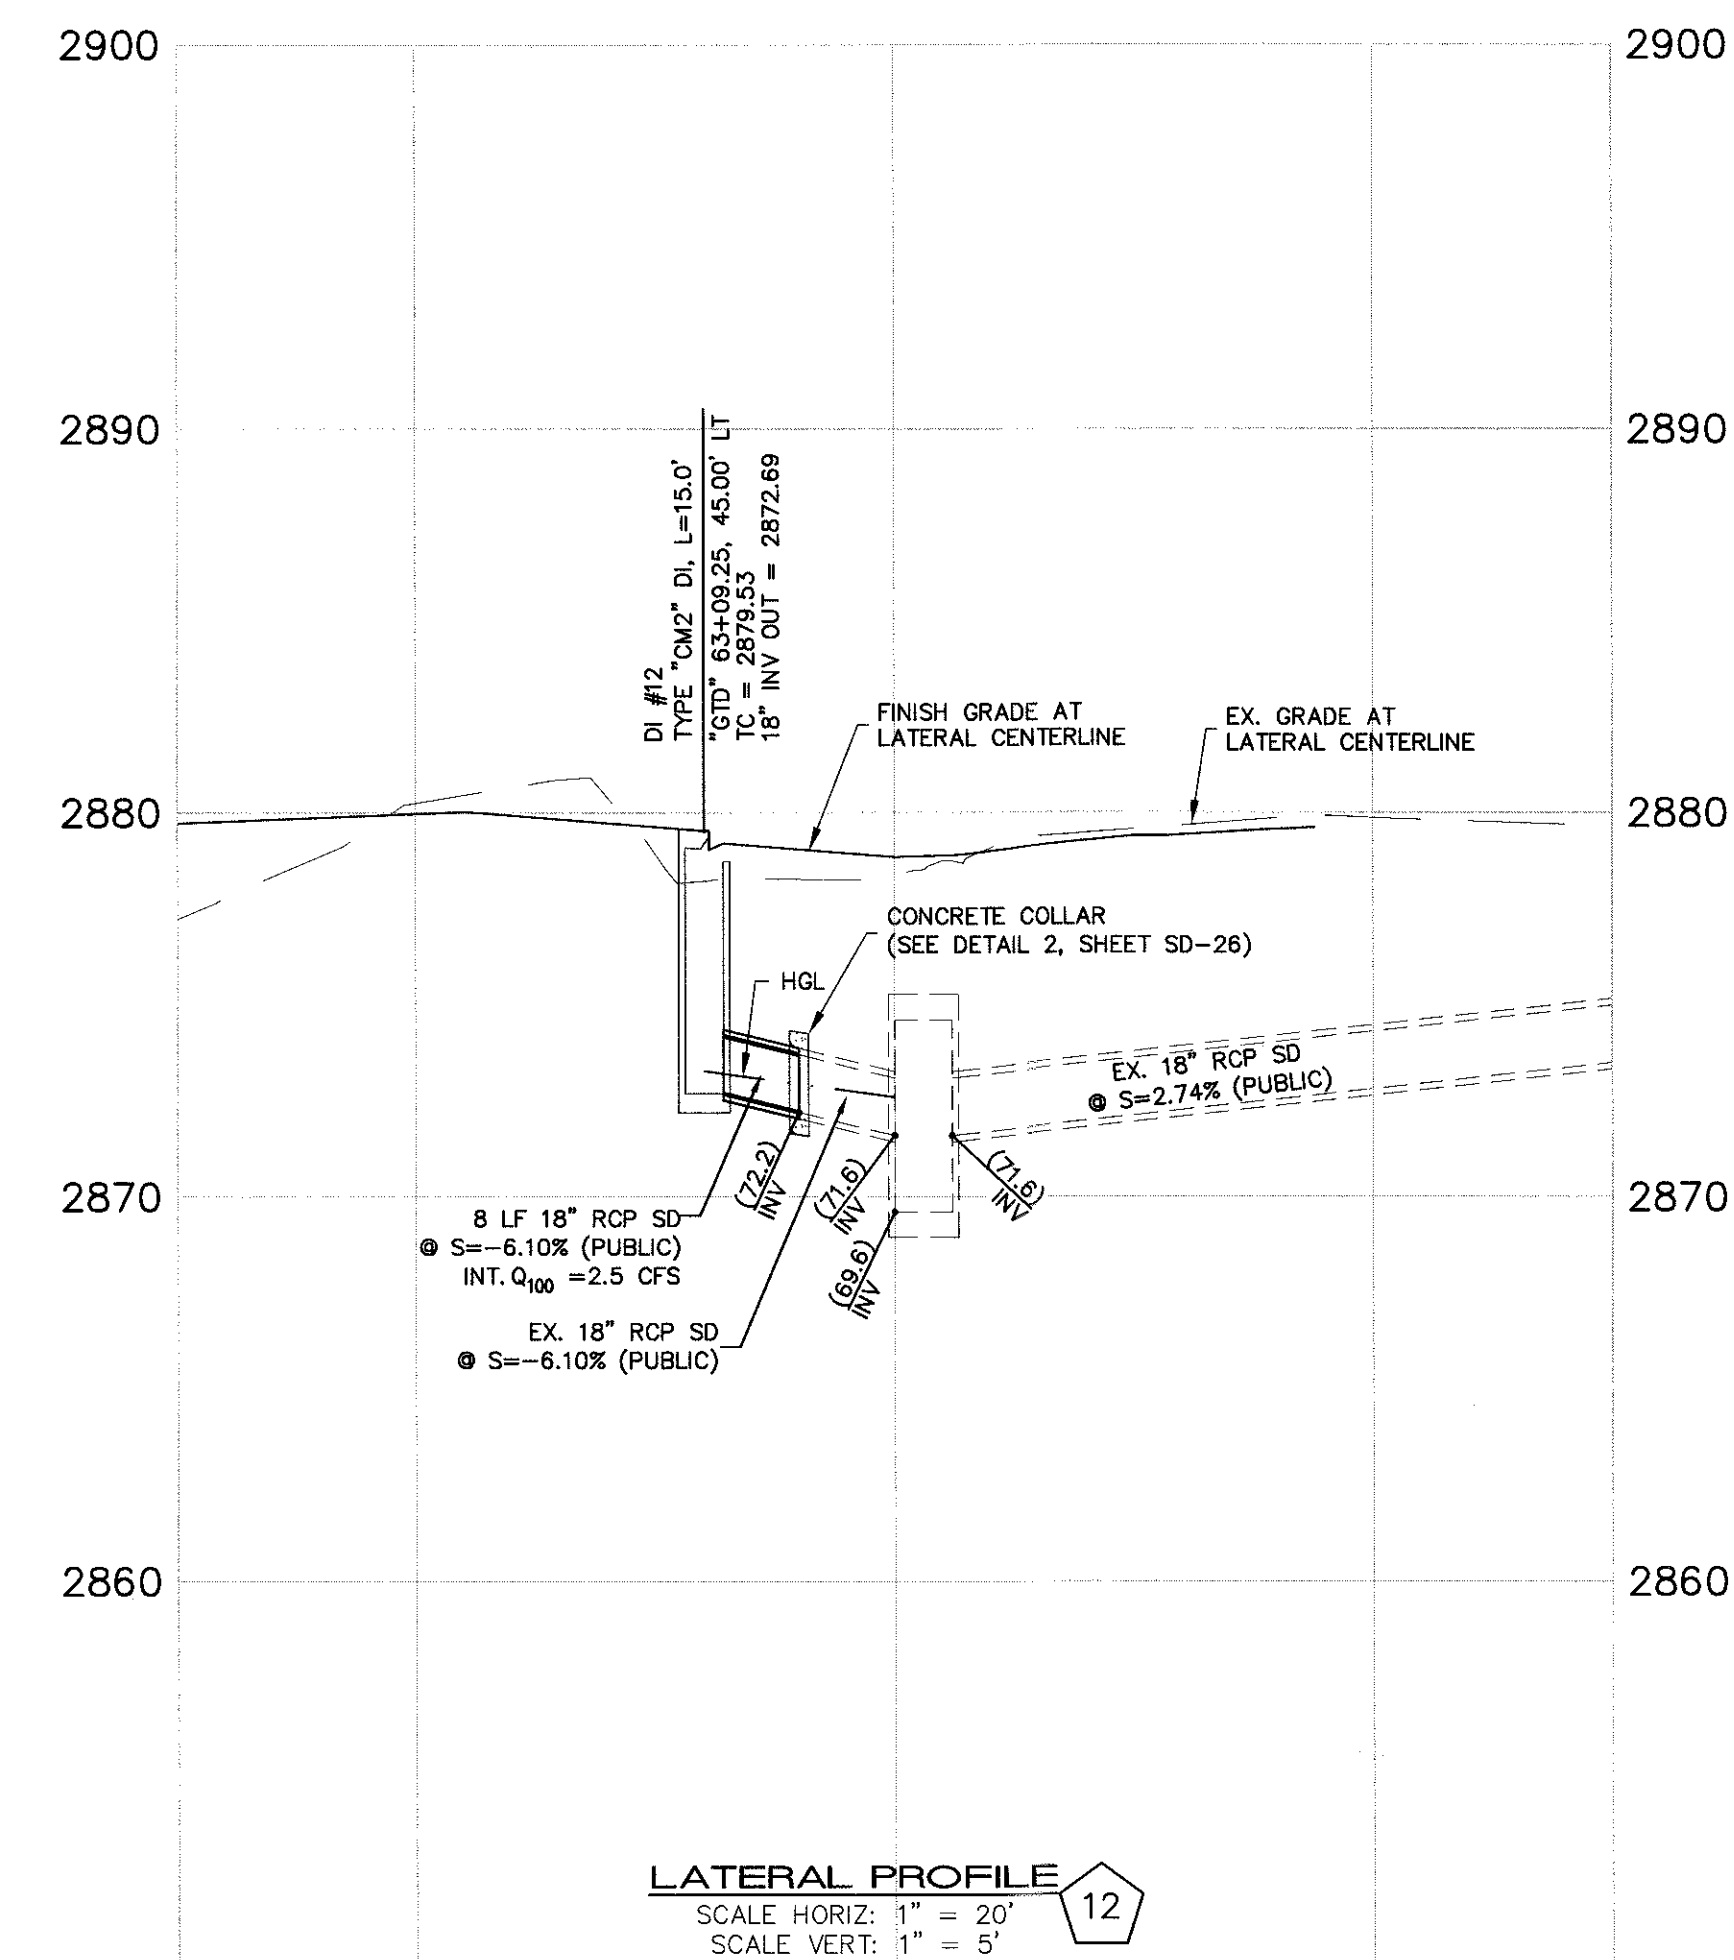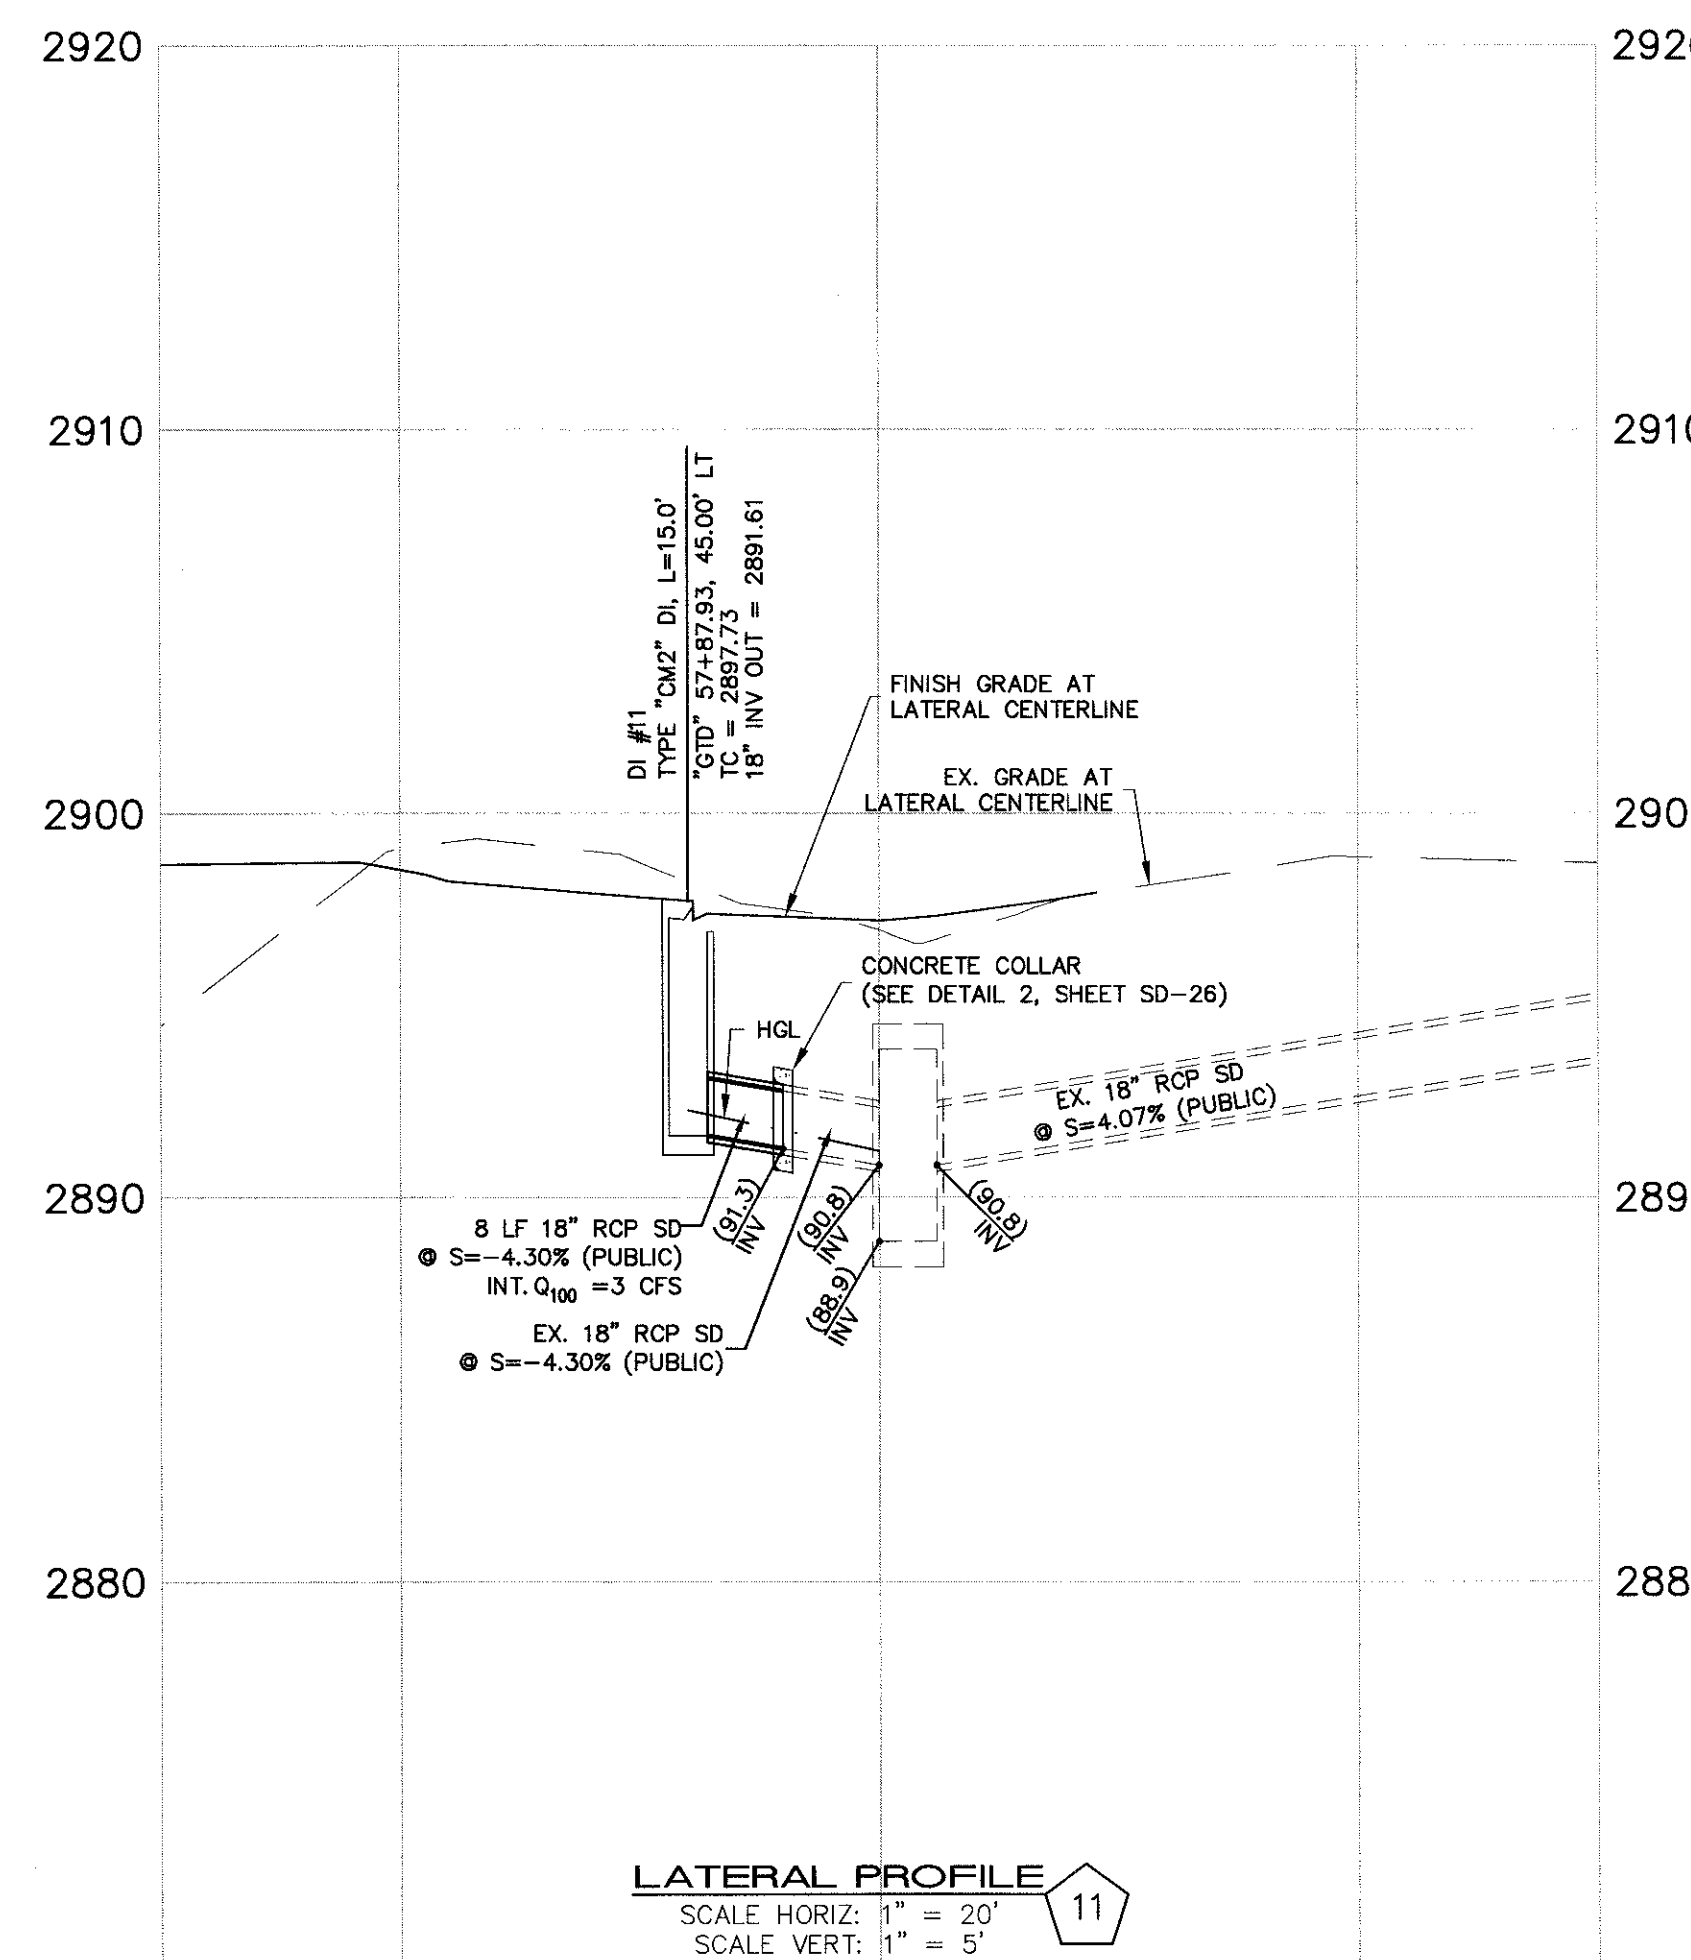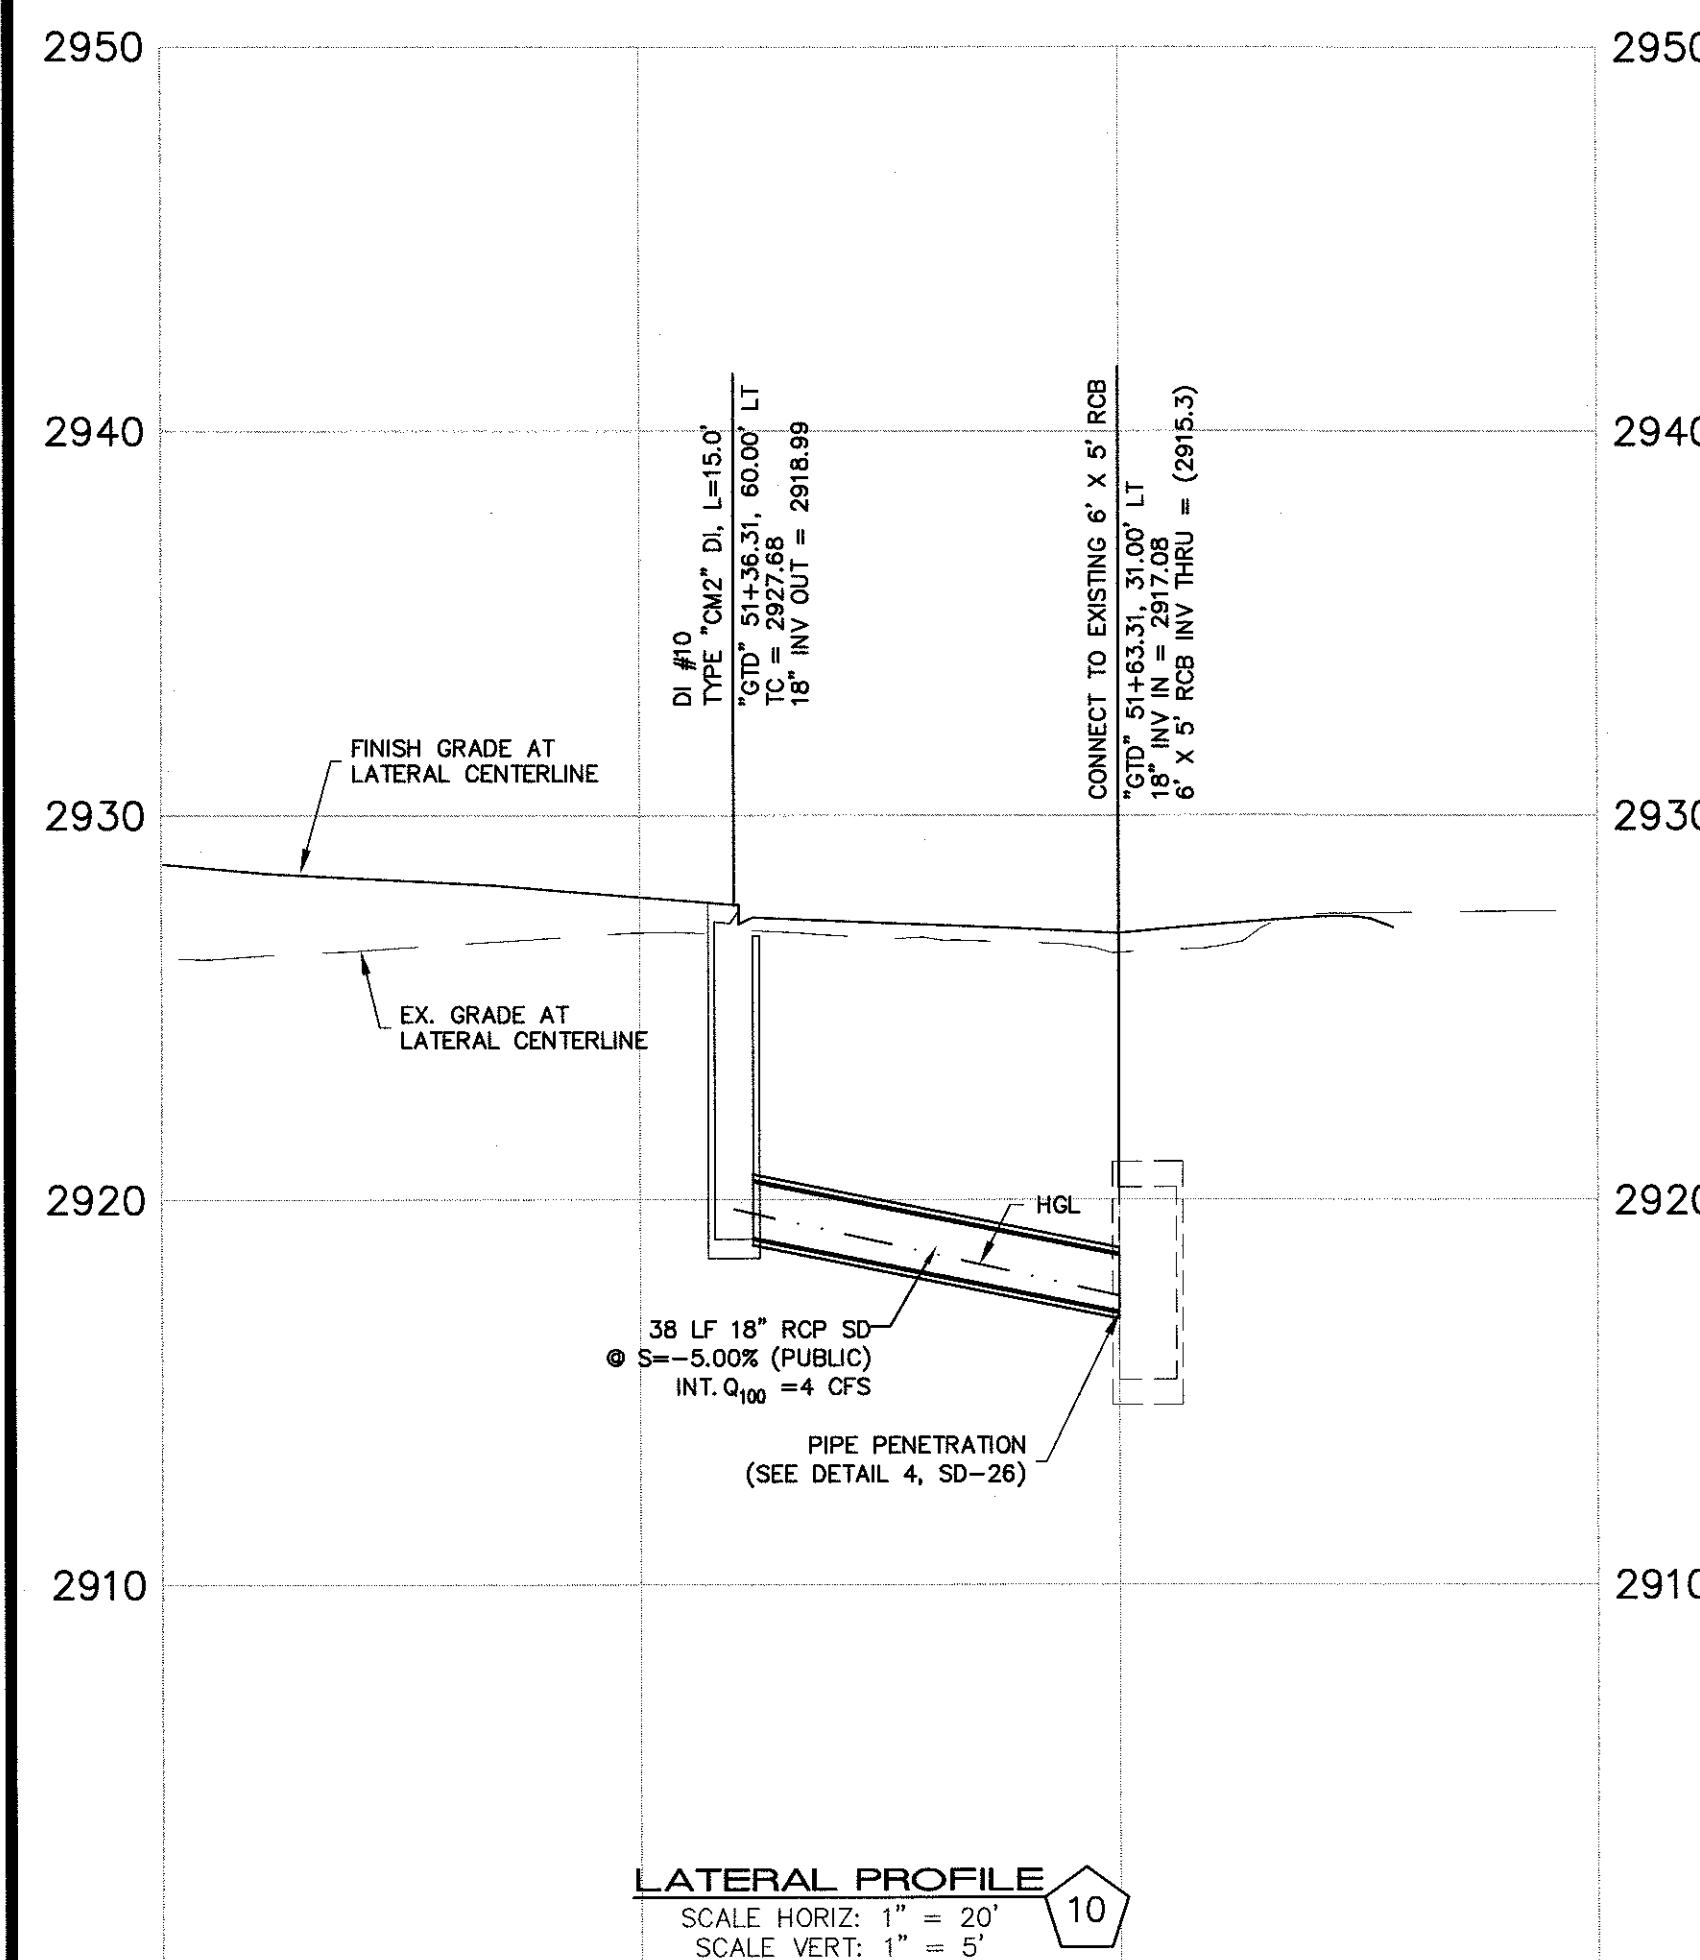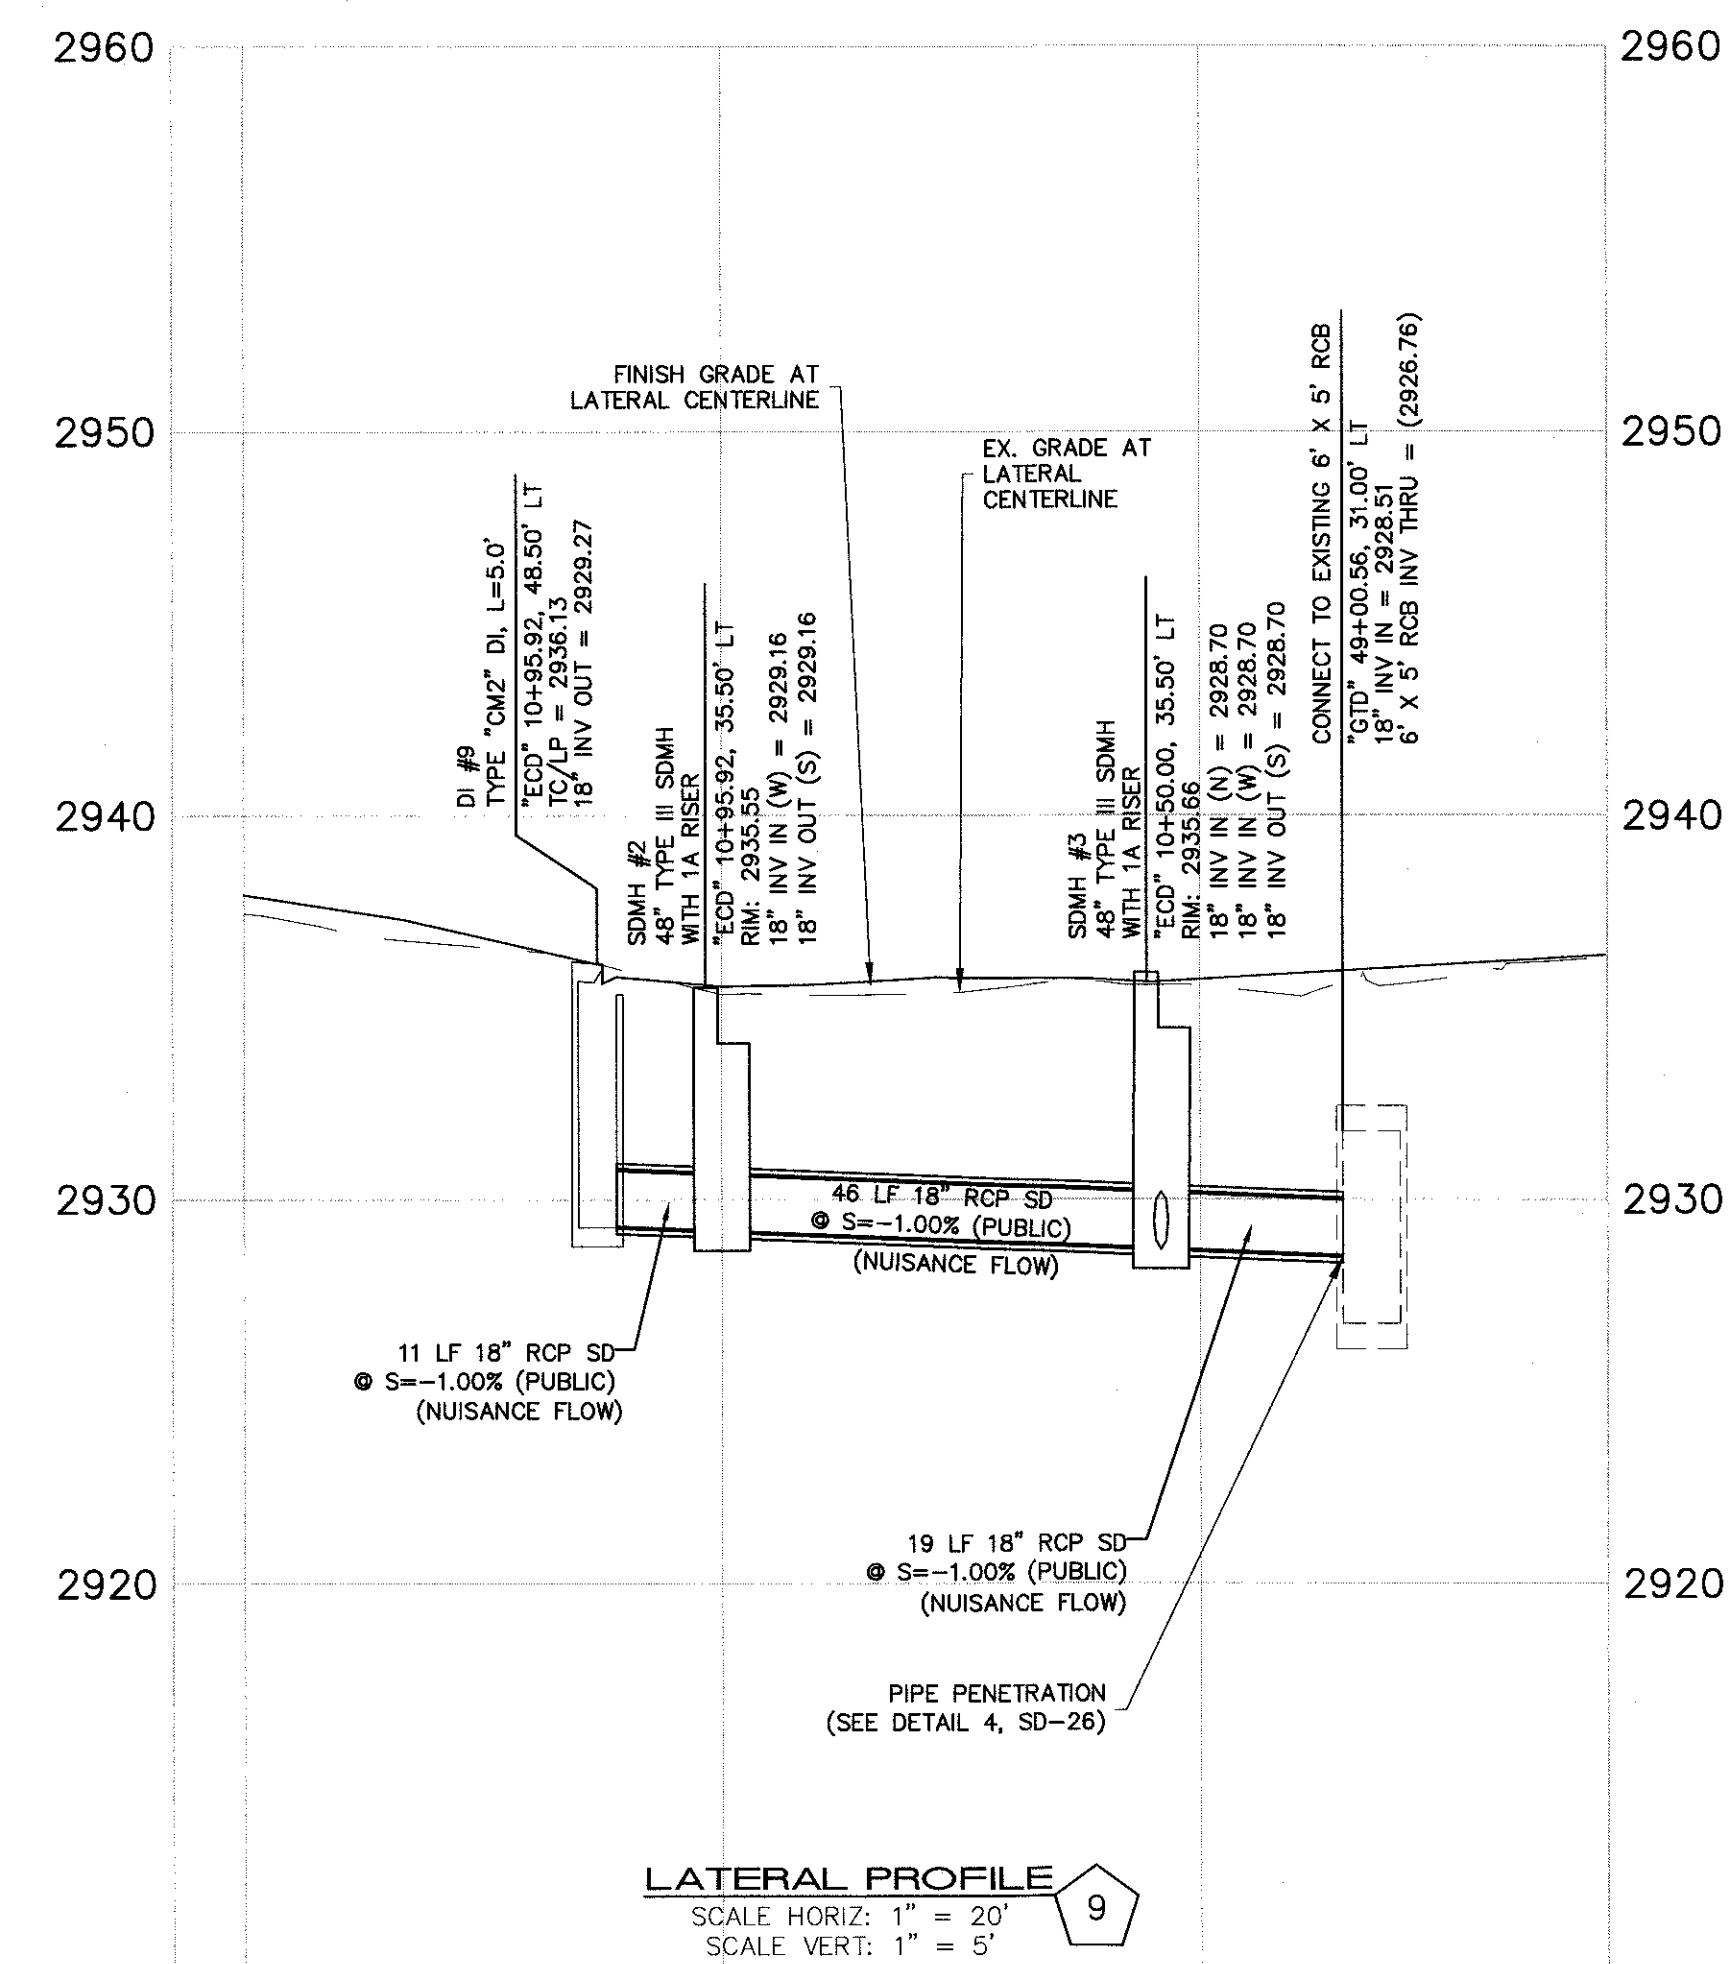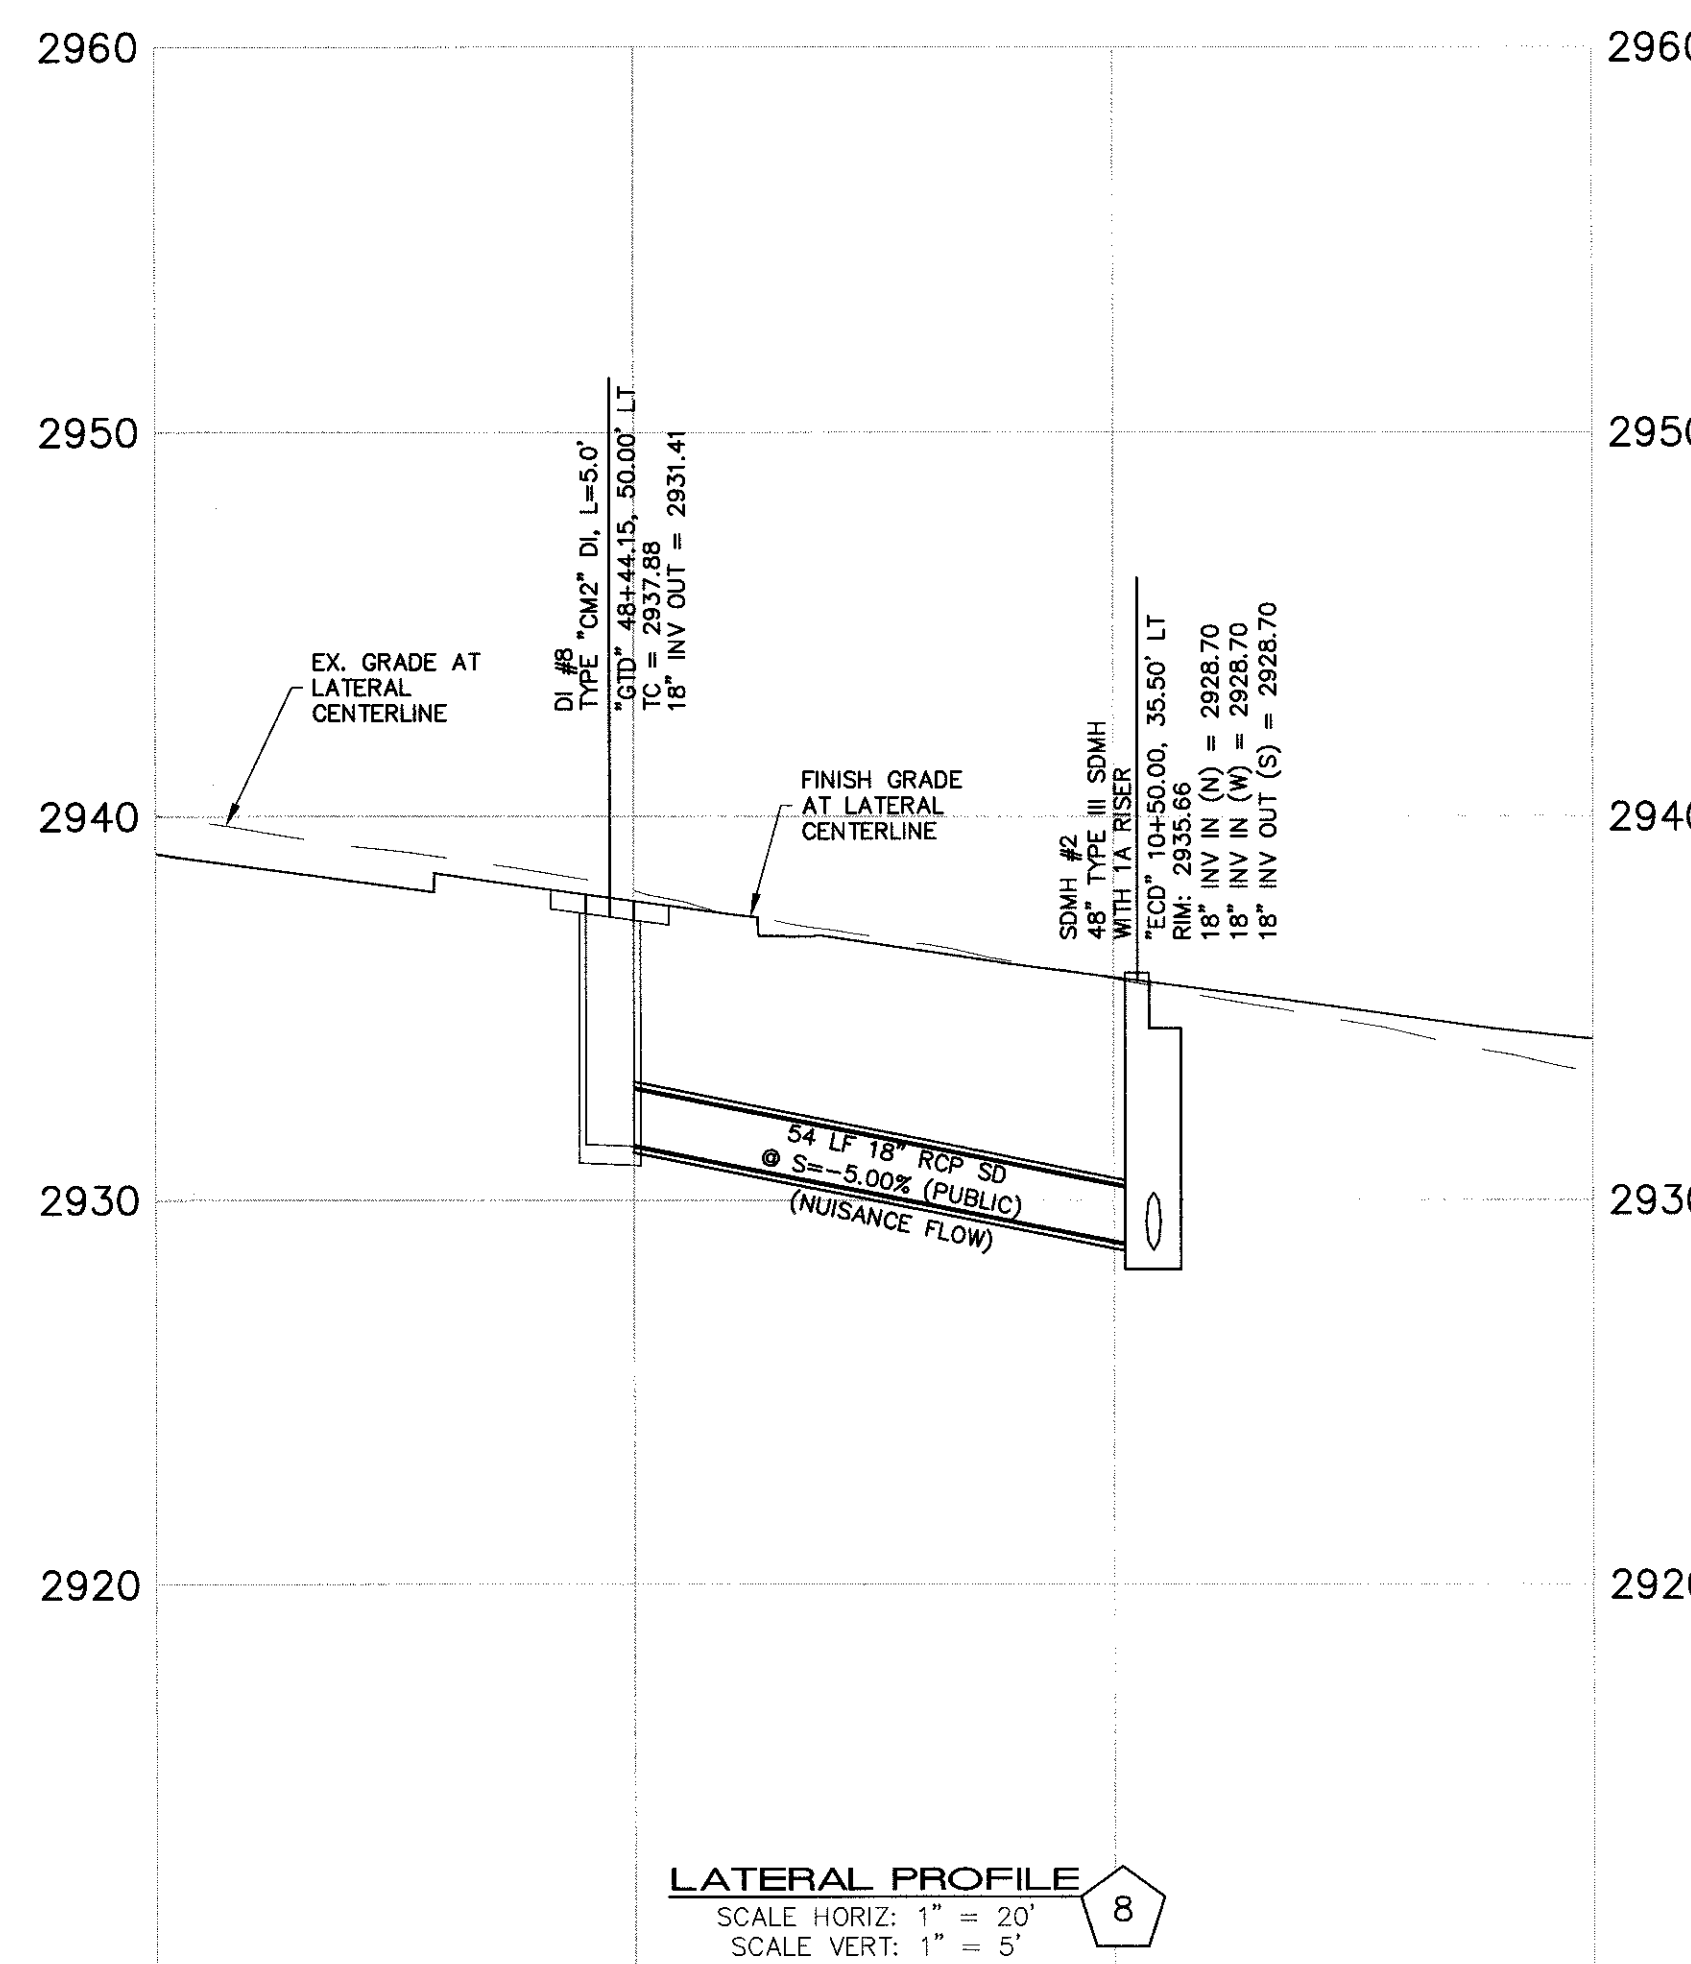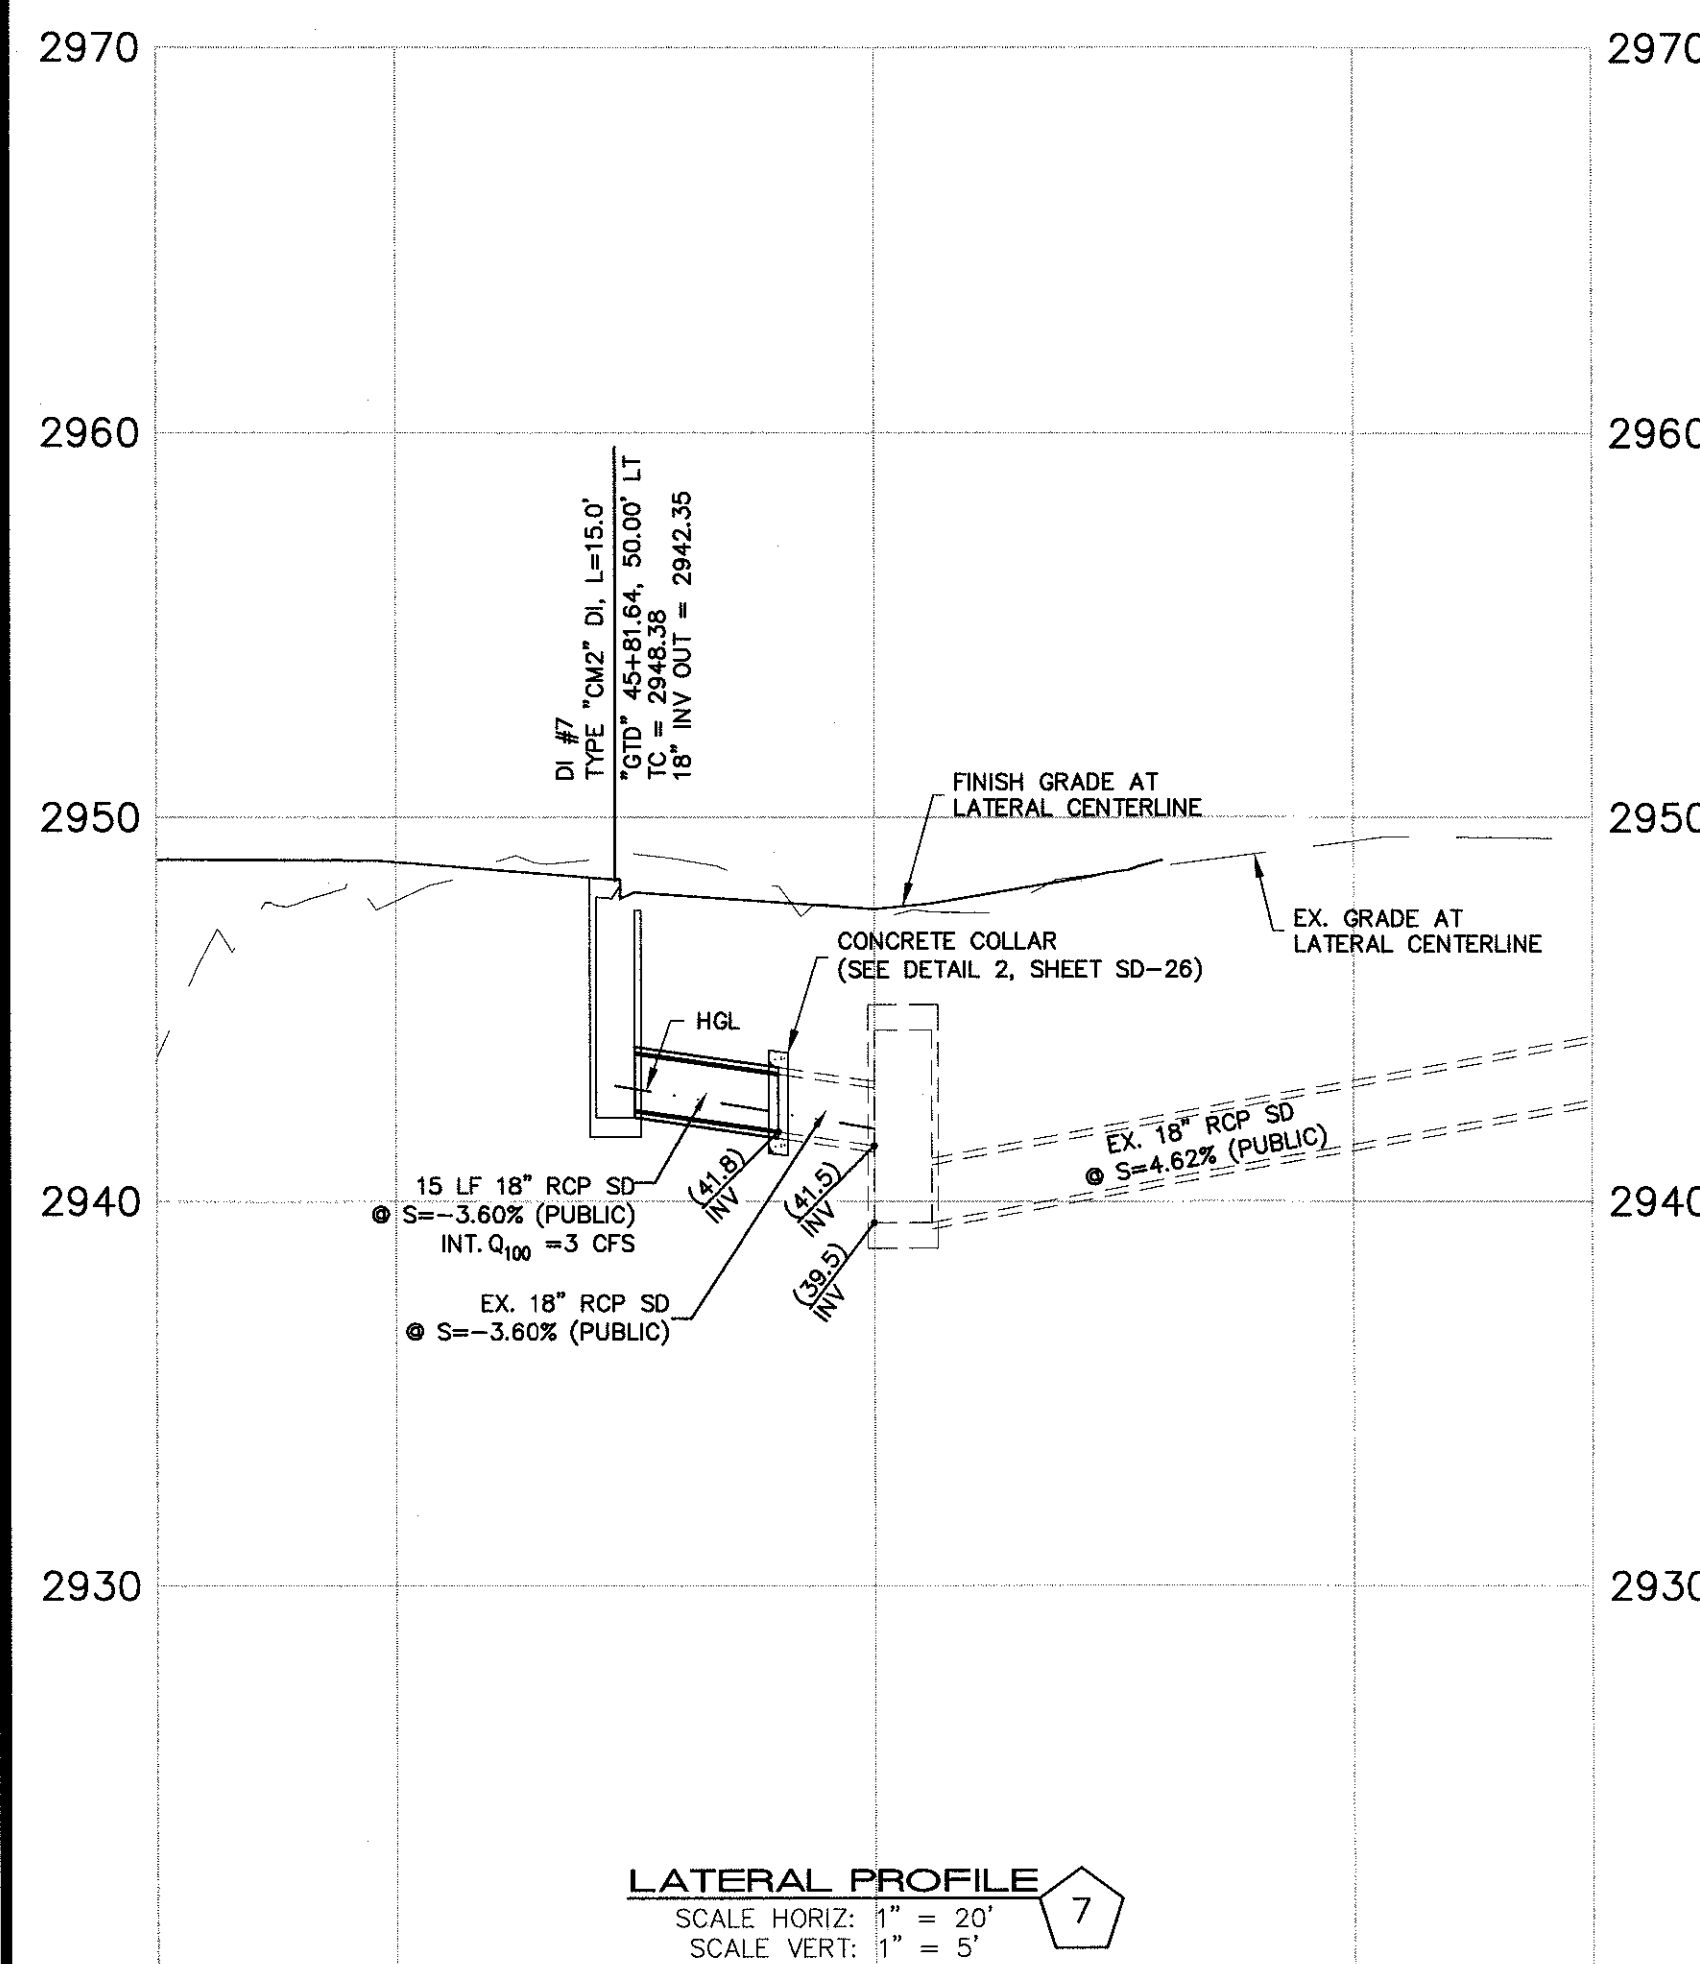[illegible]

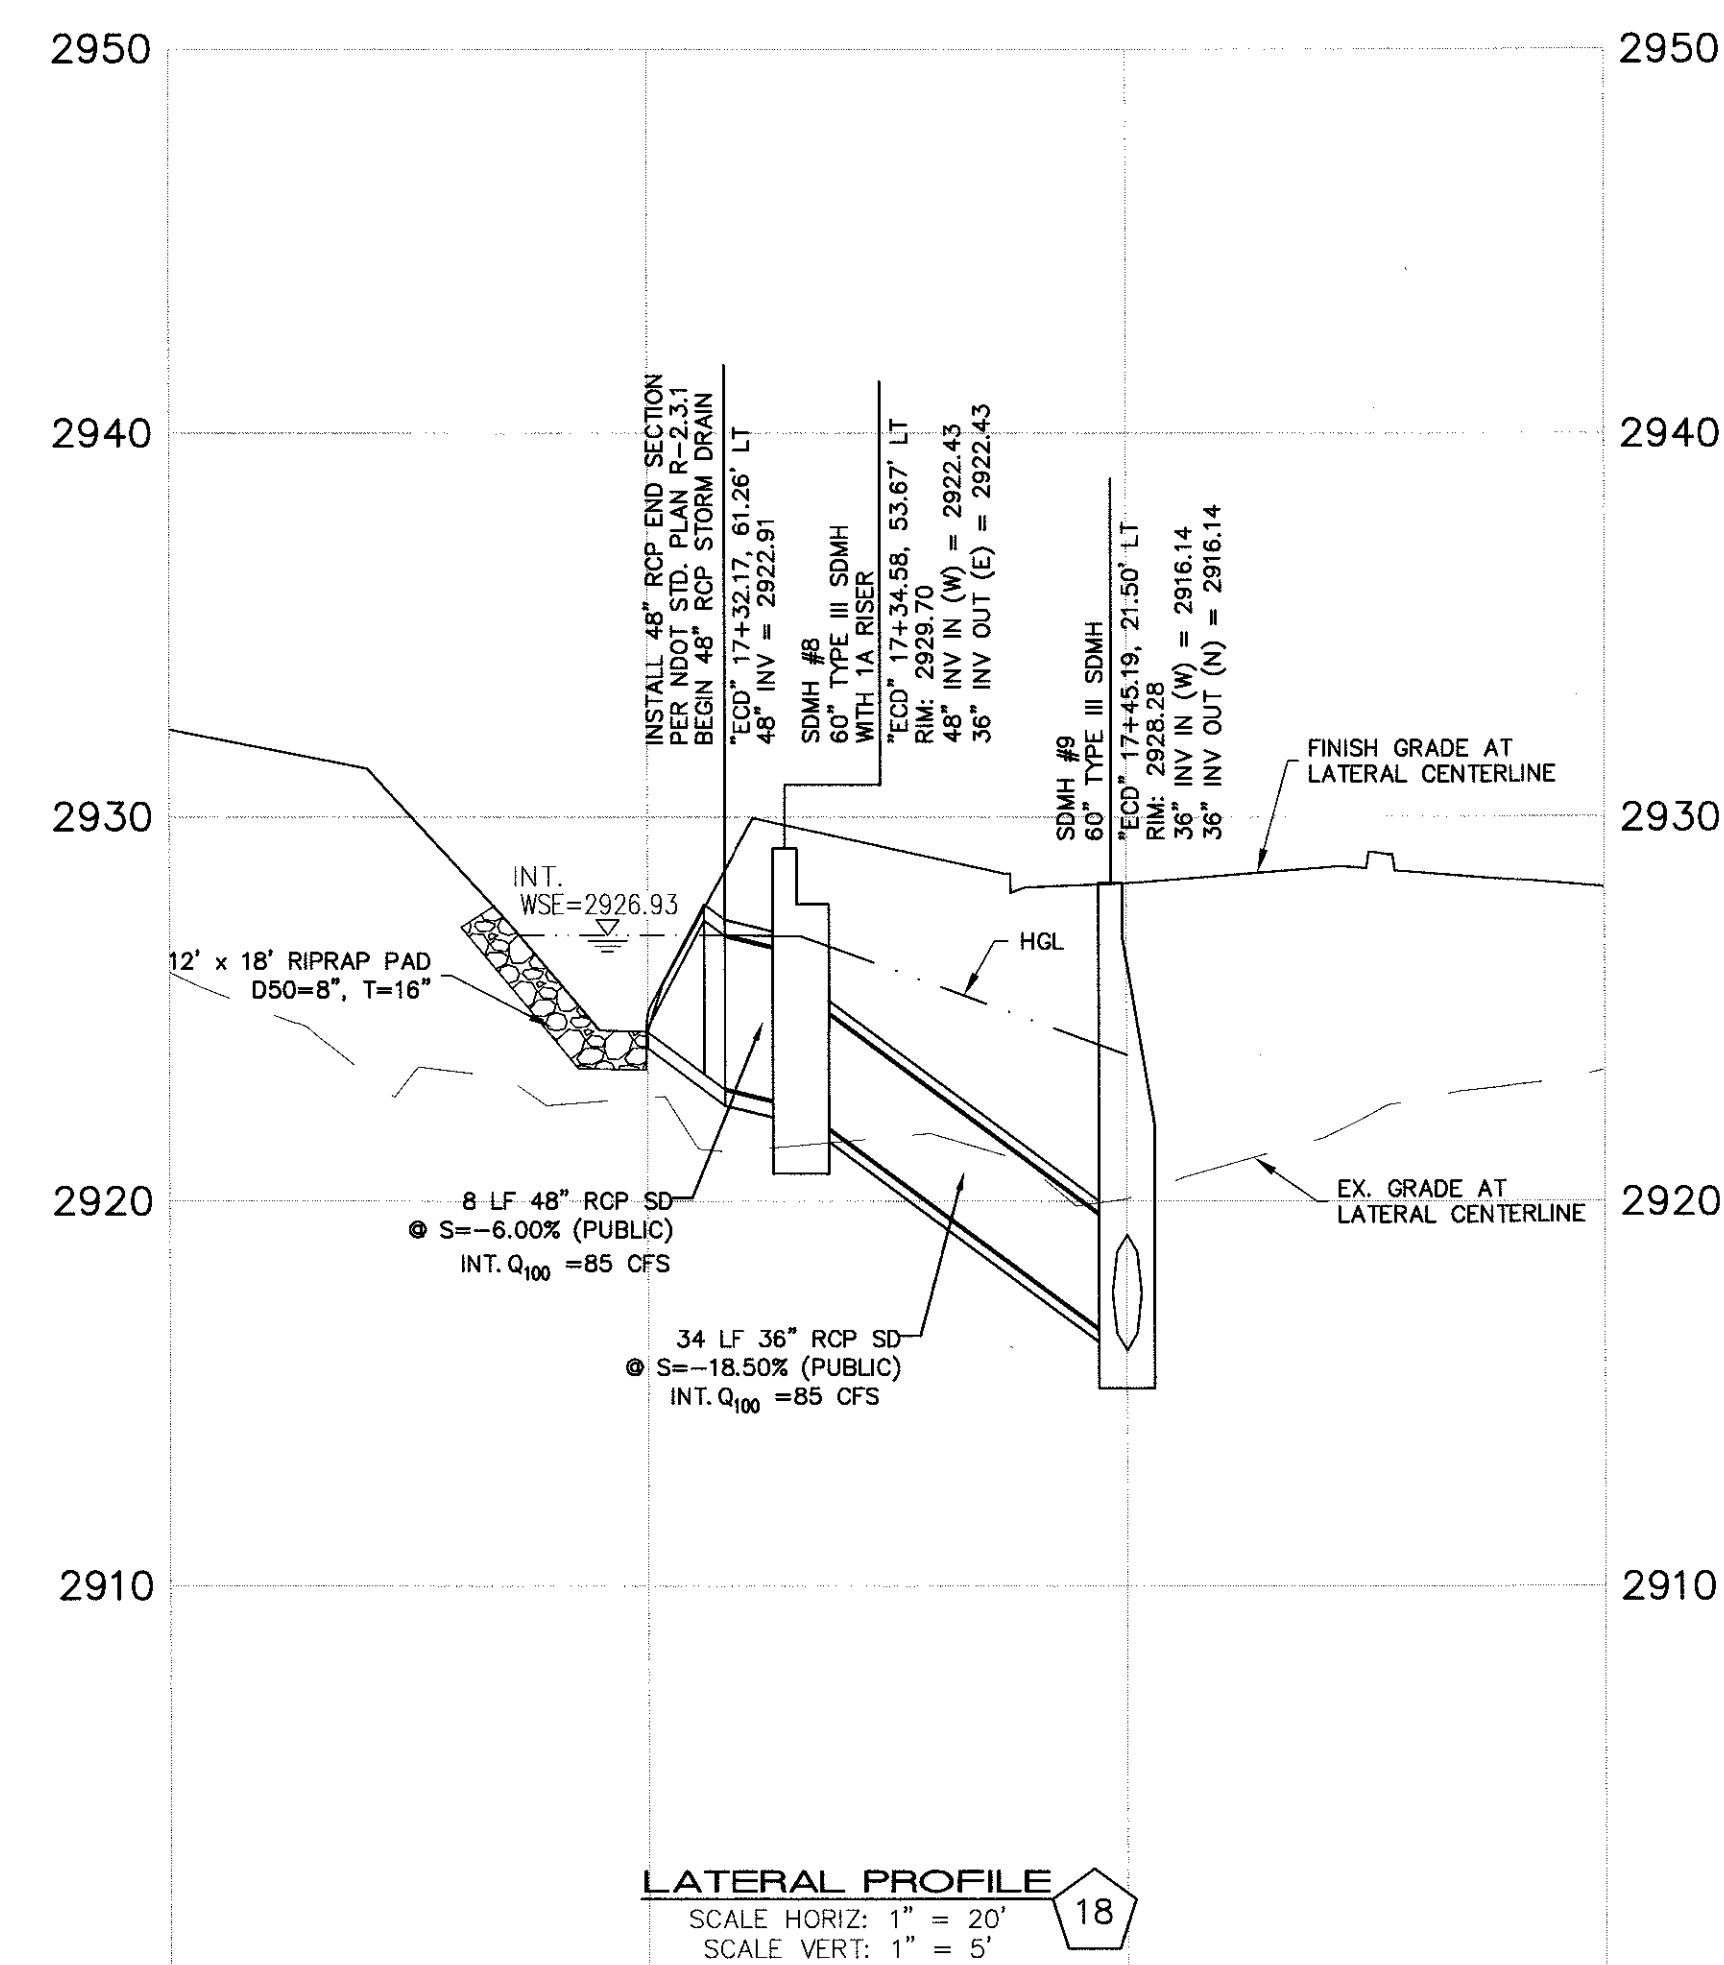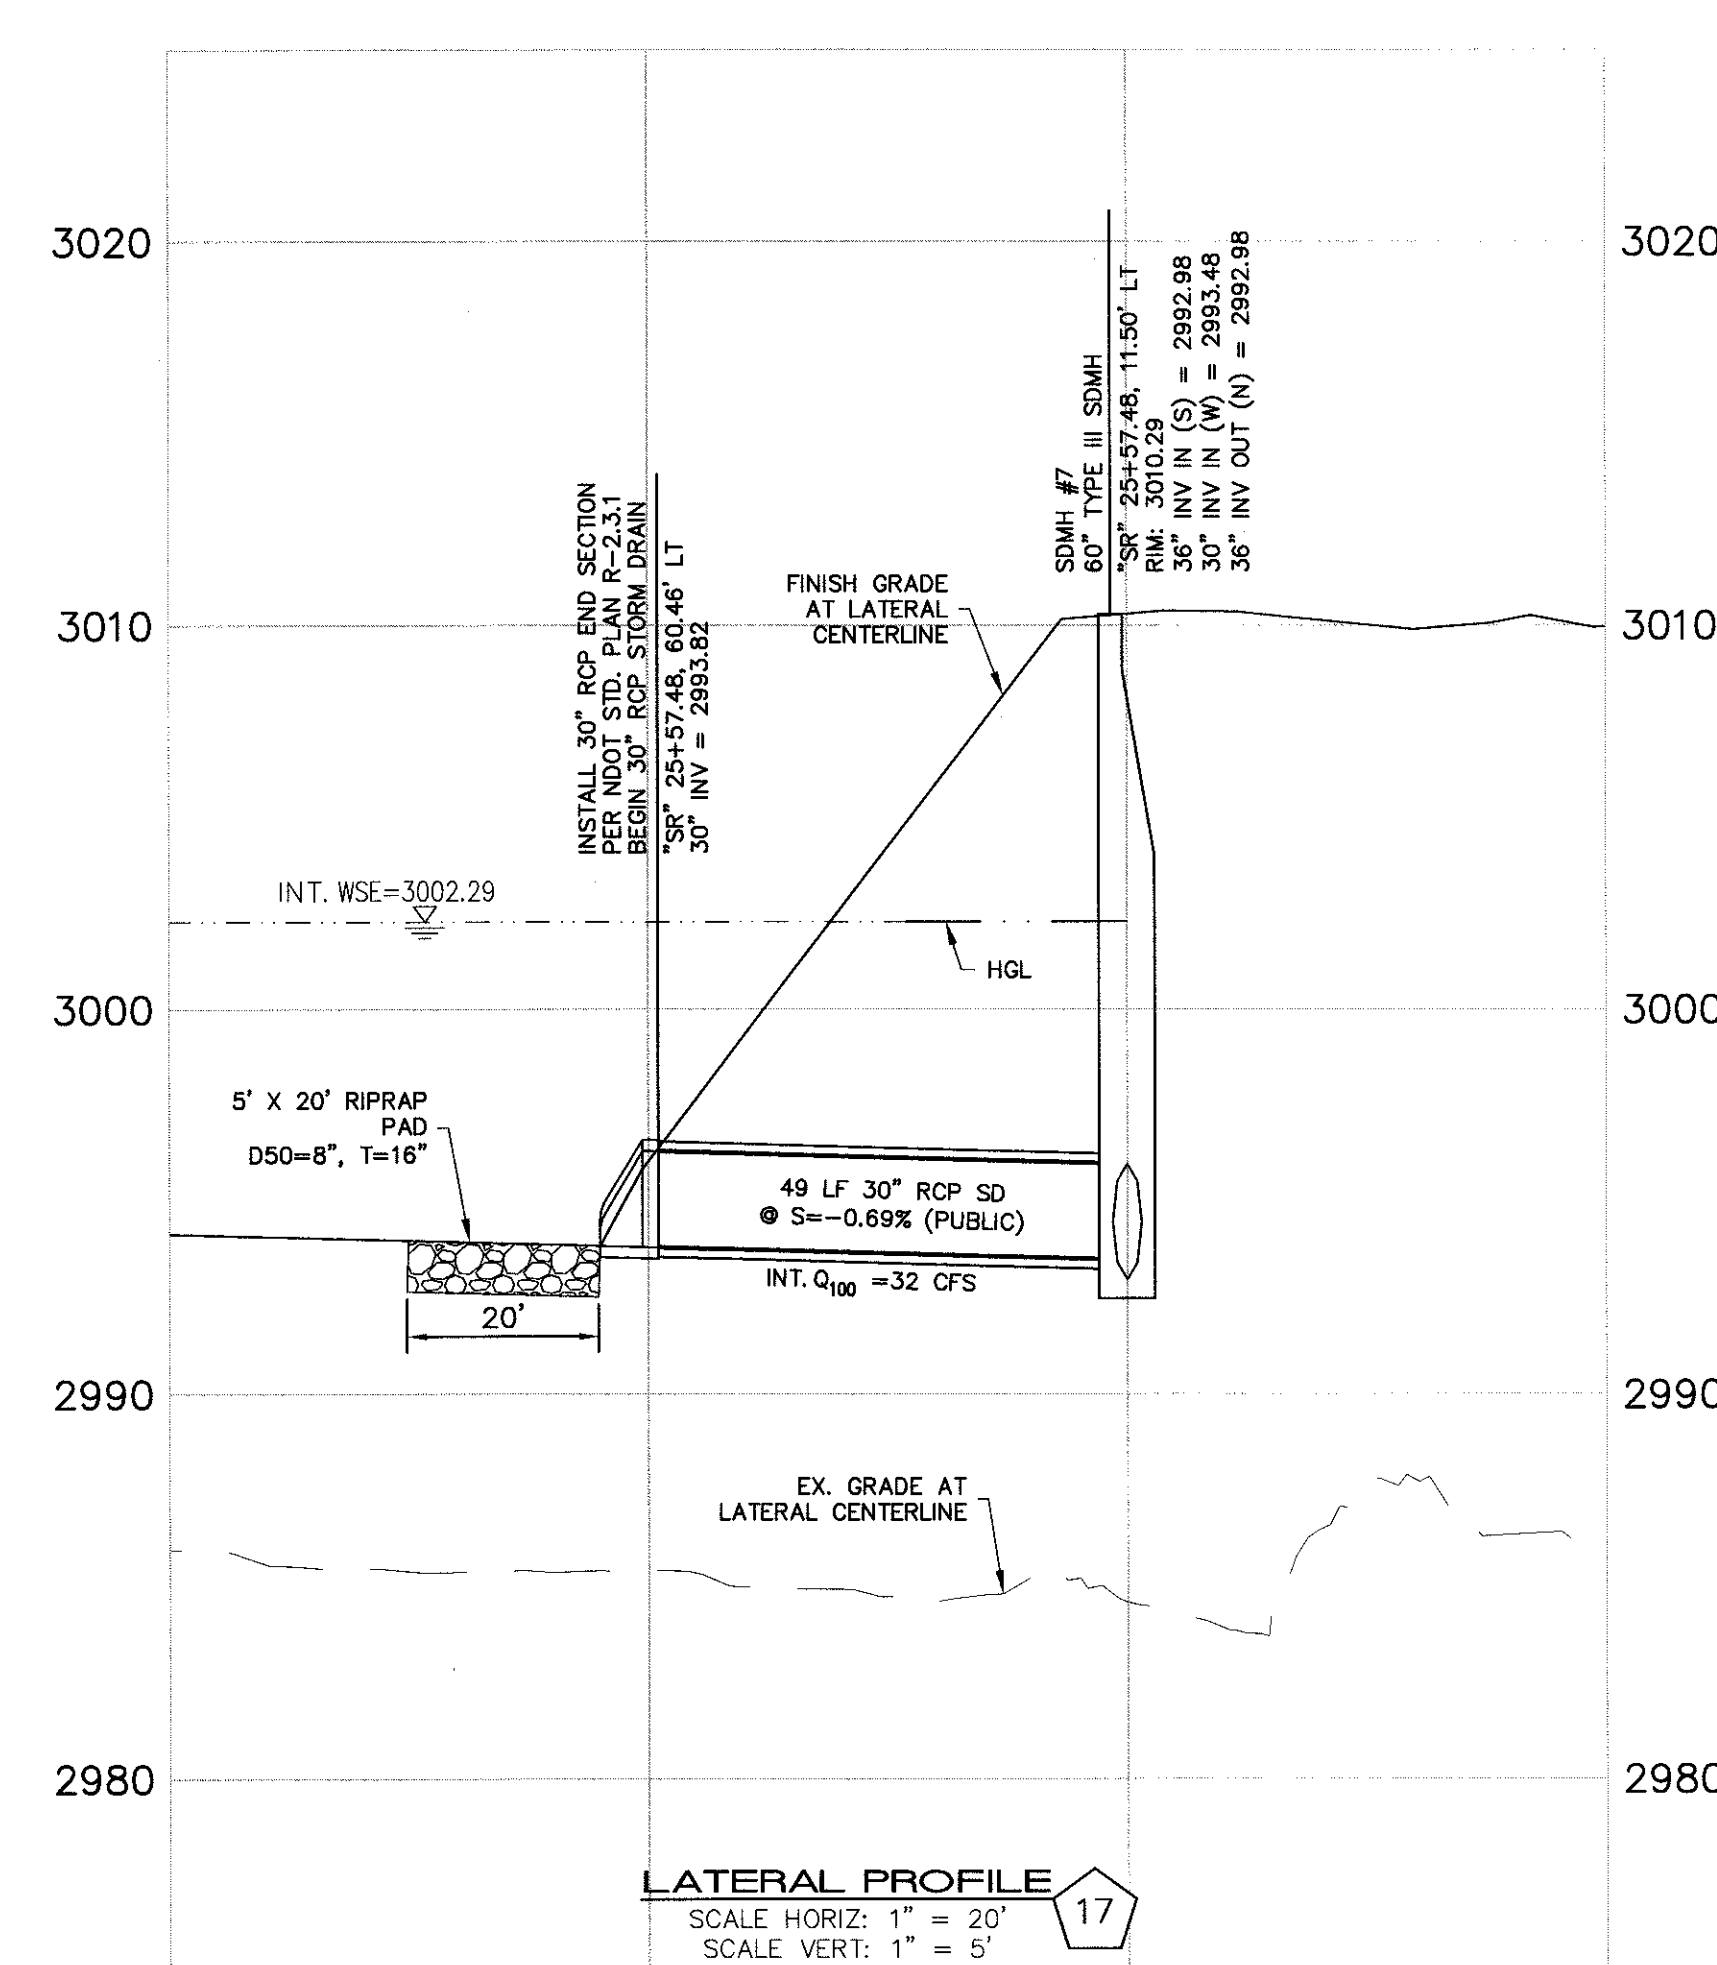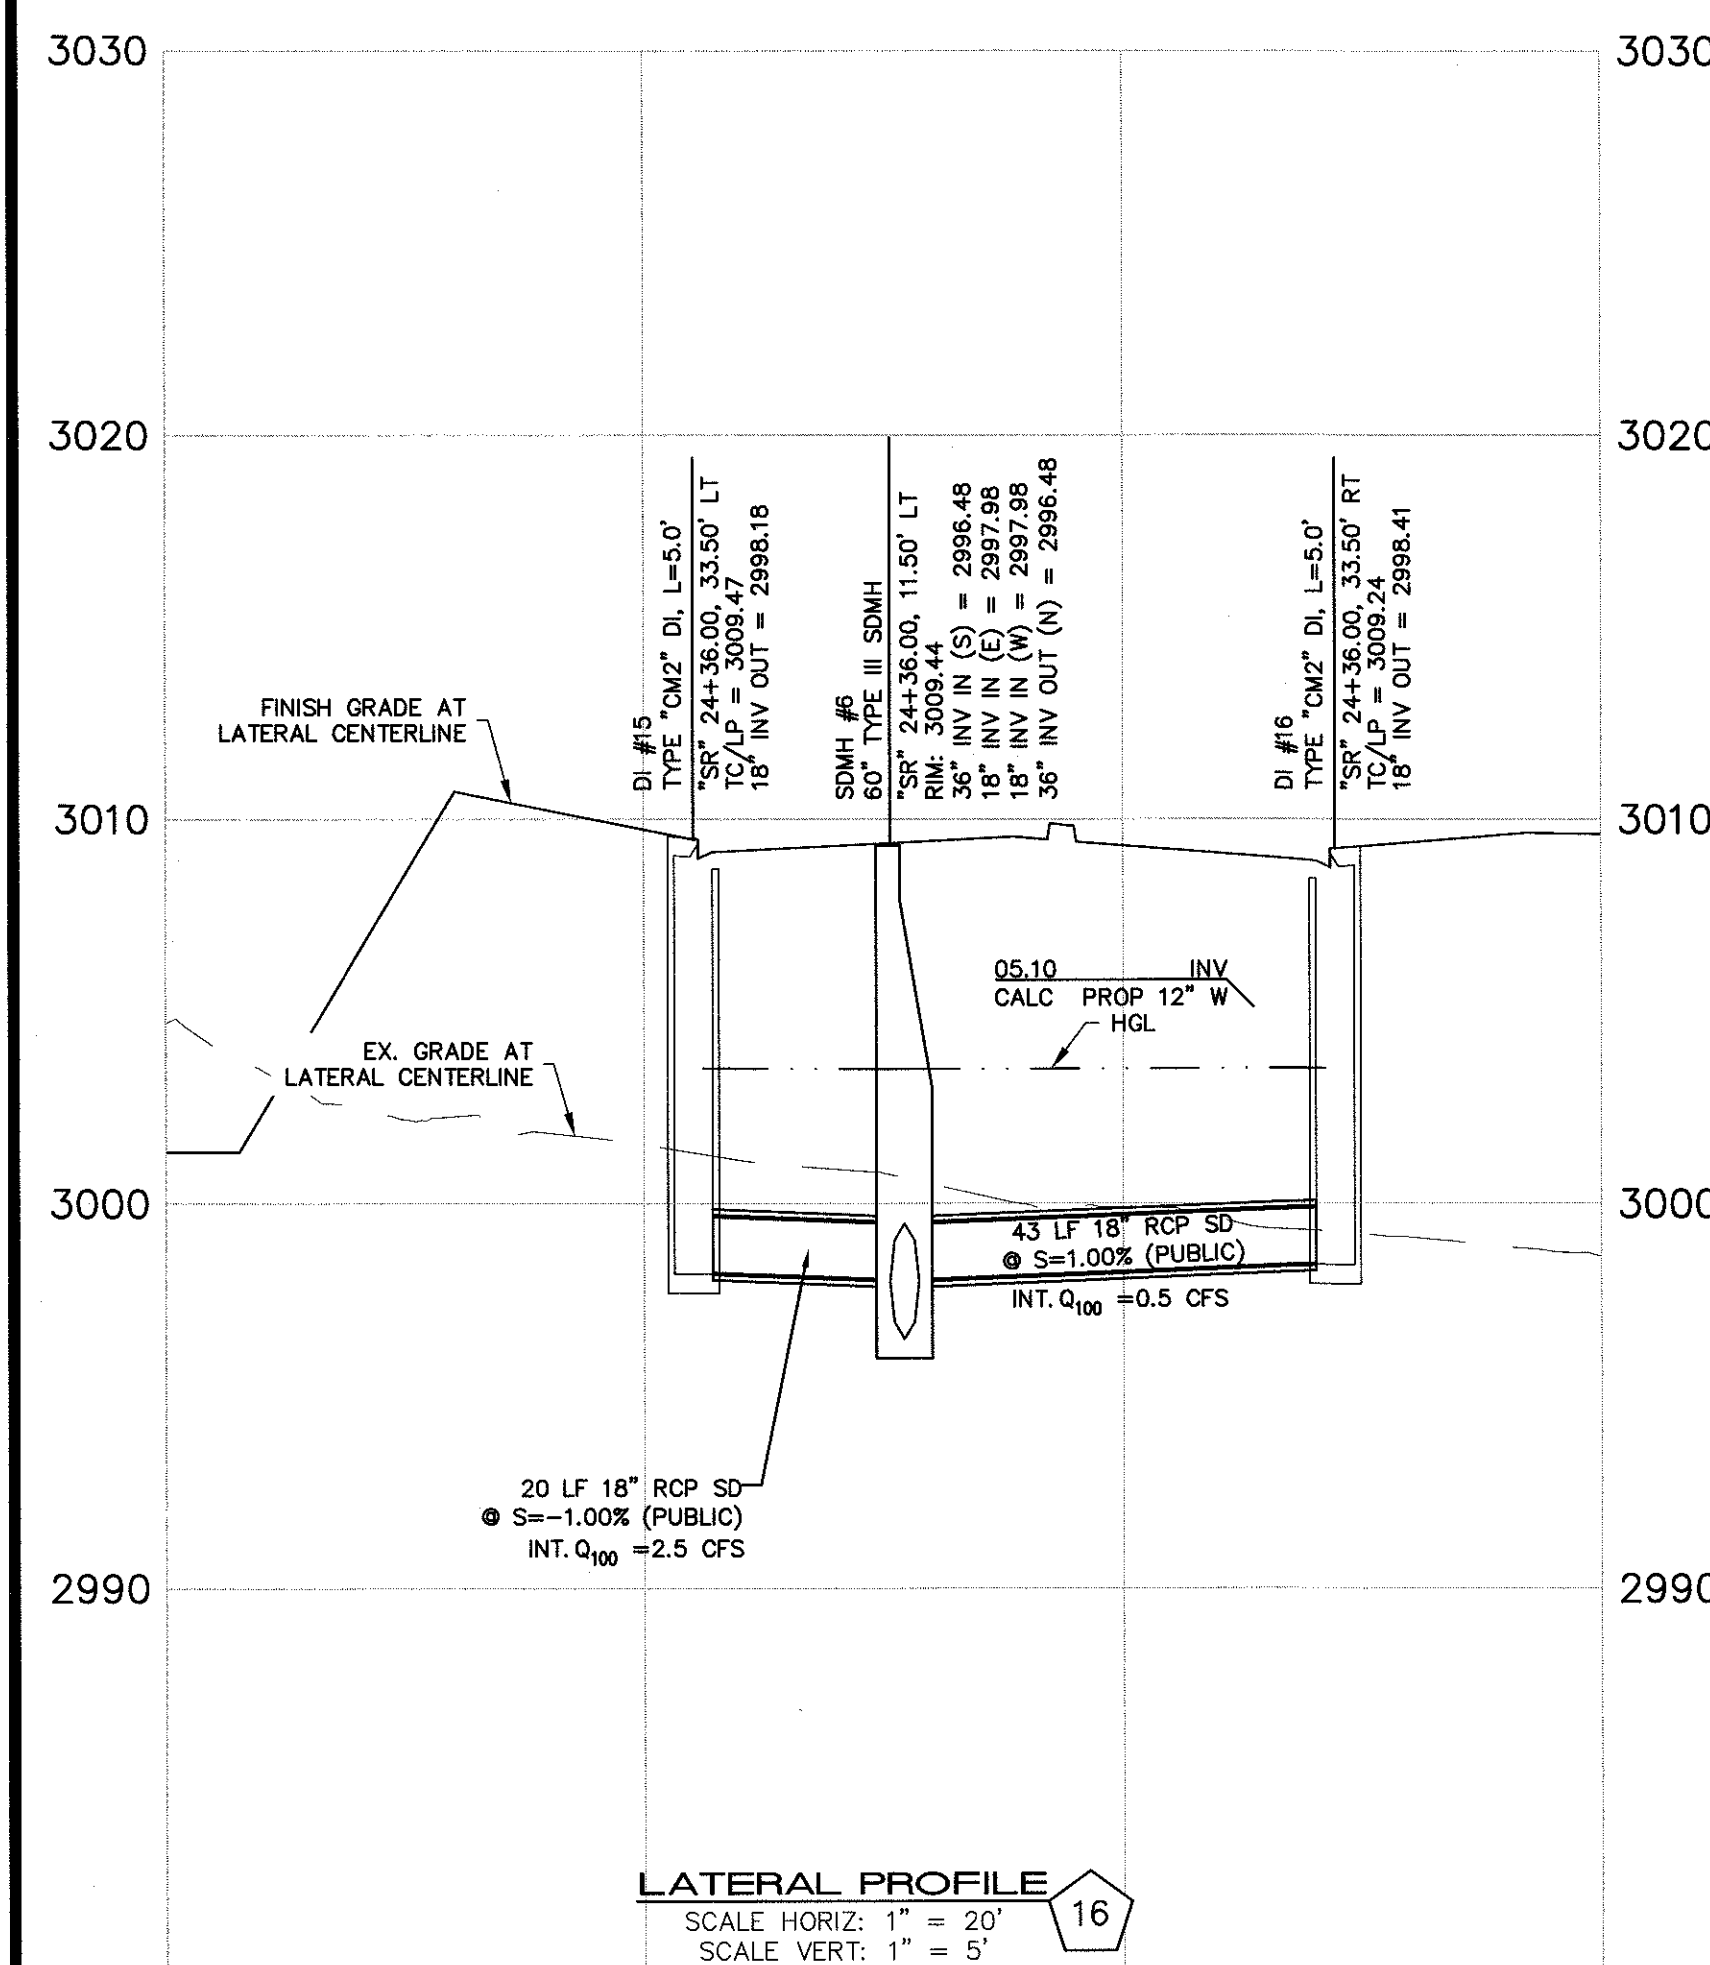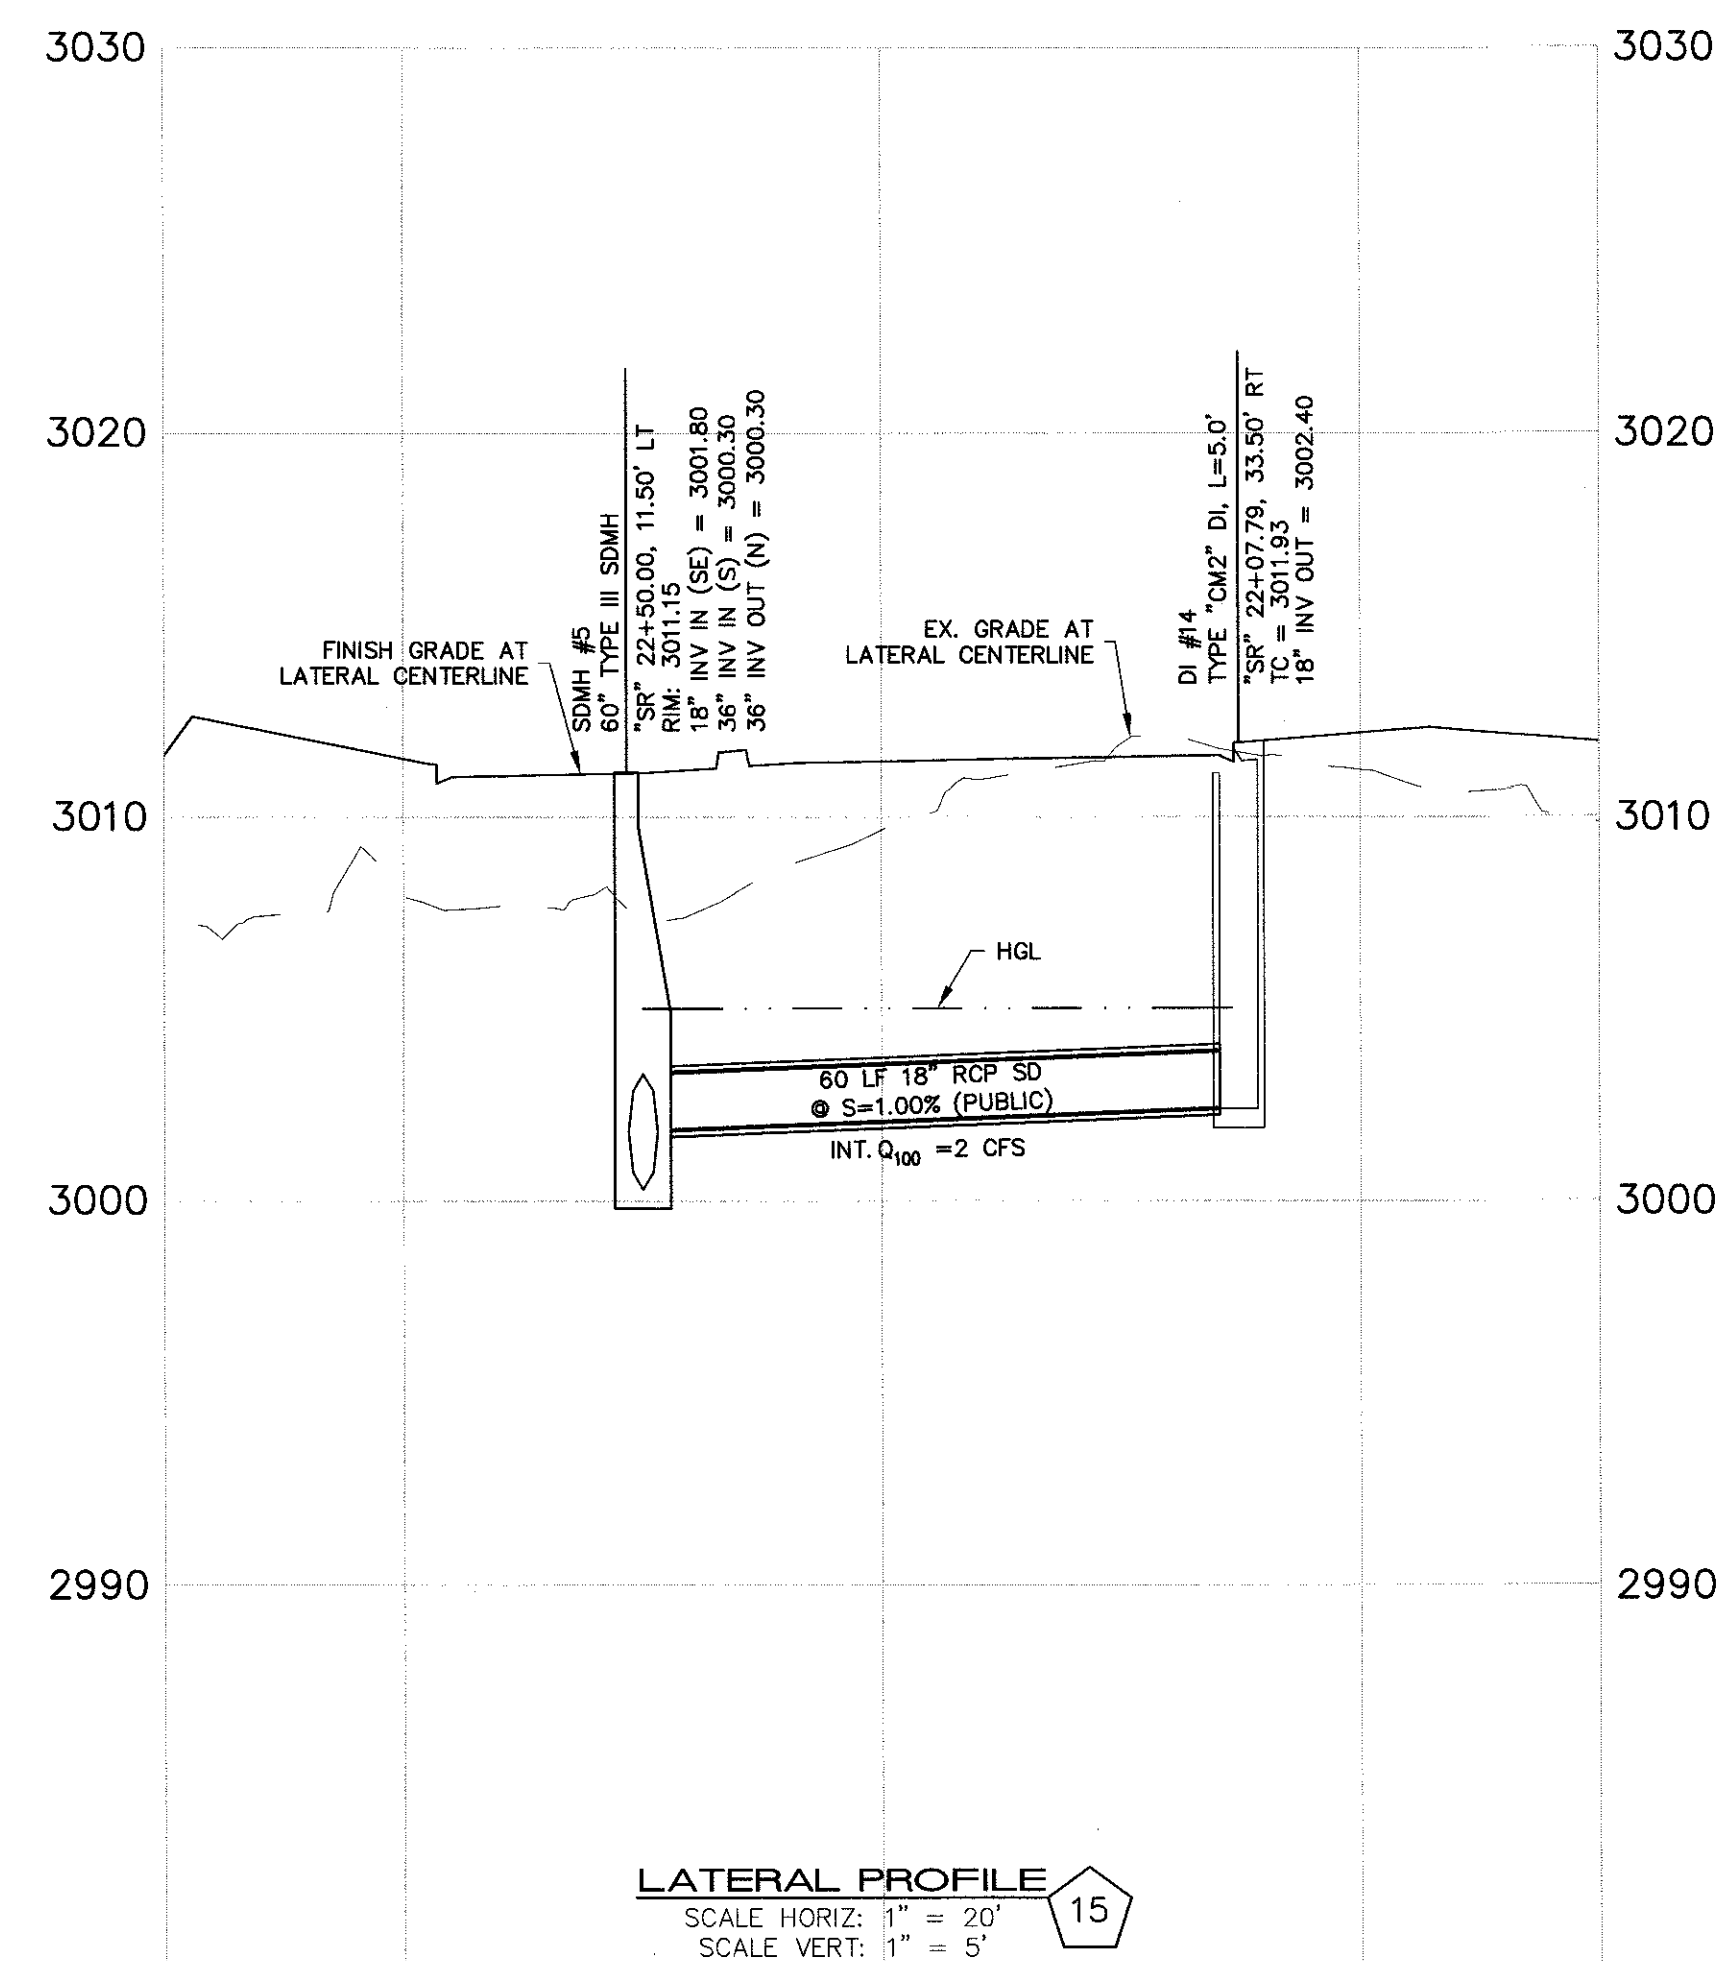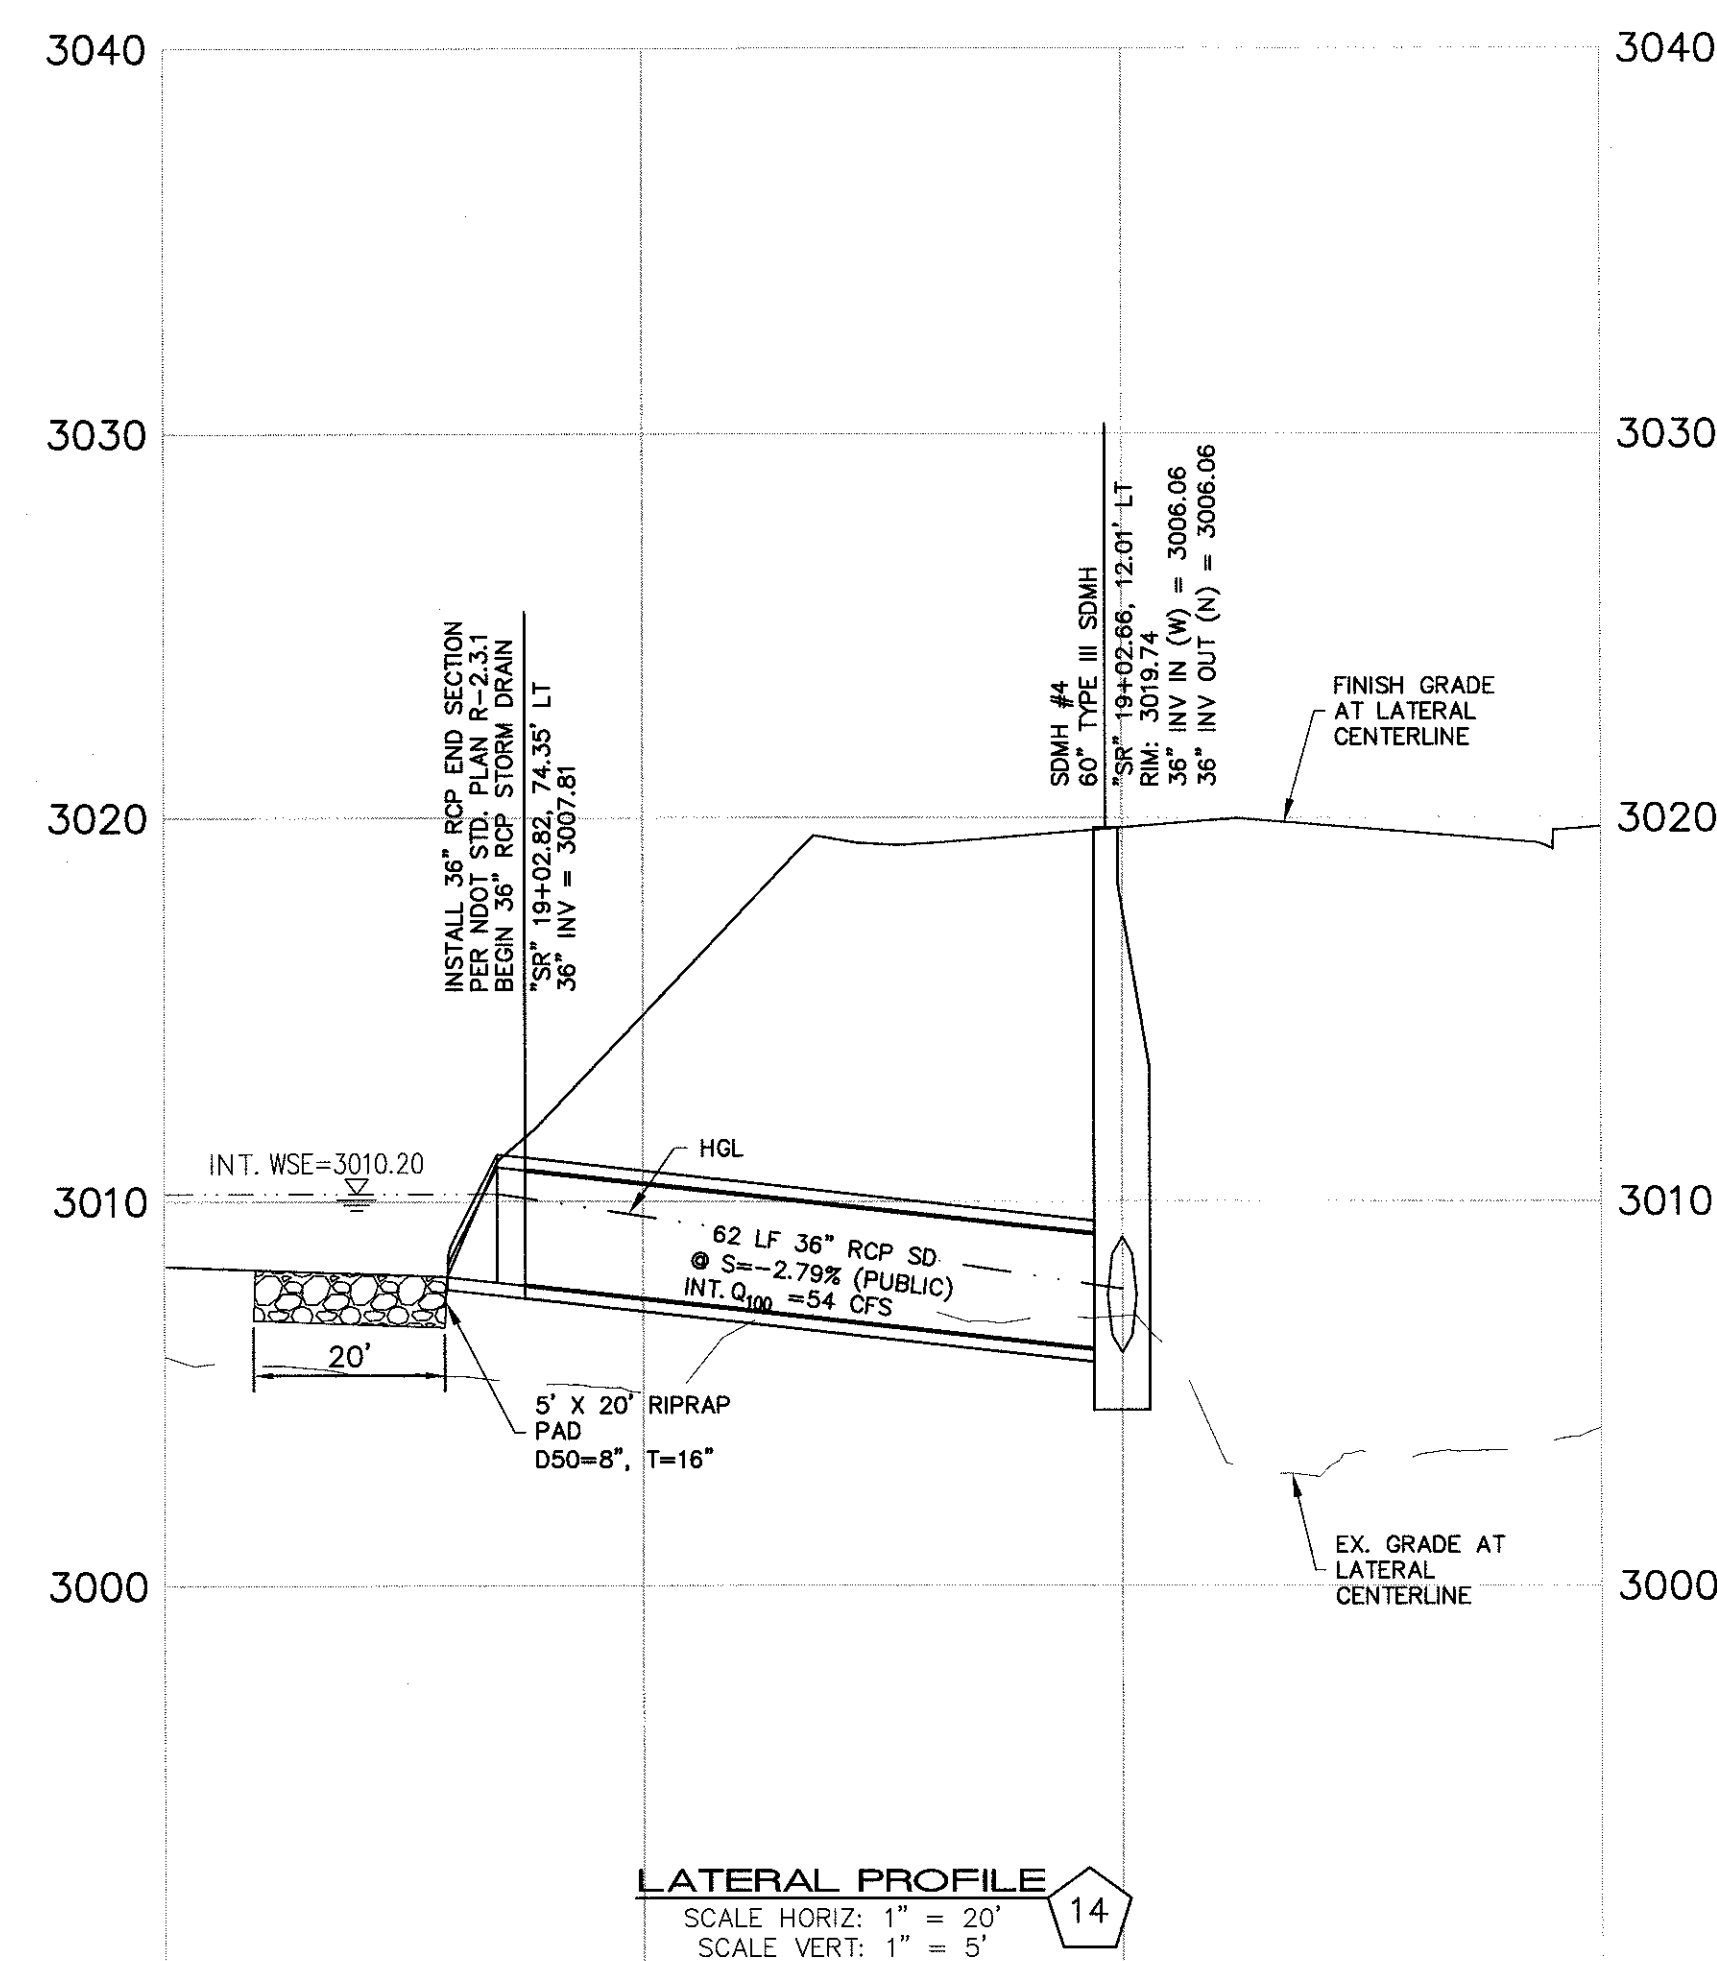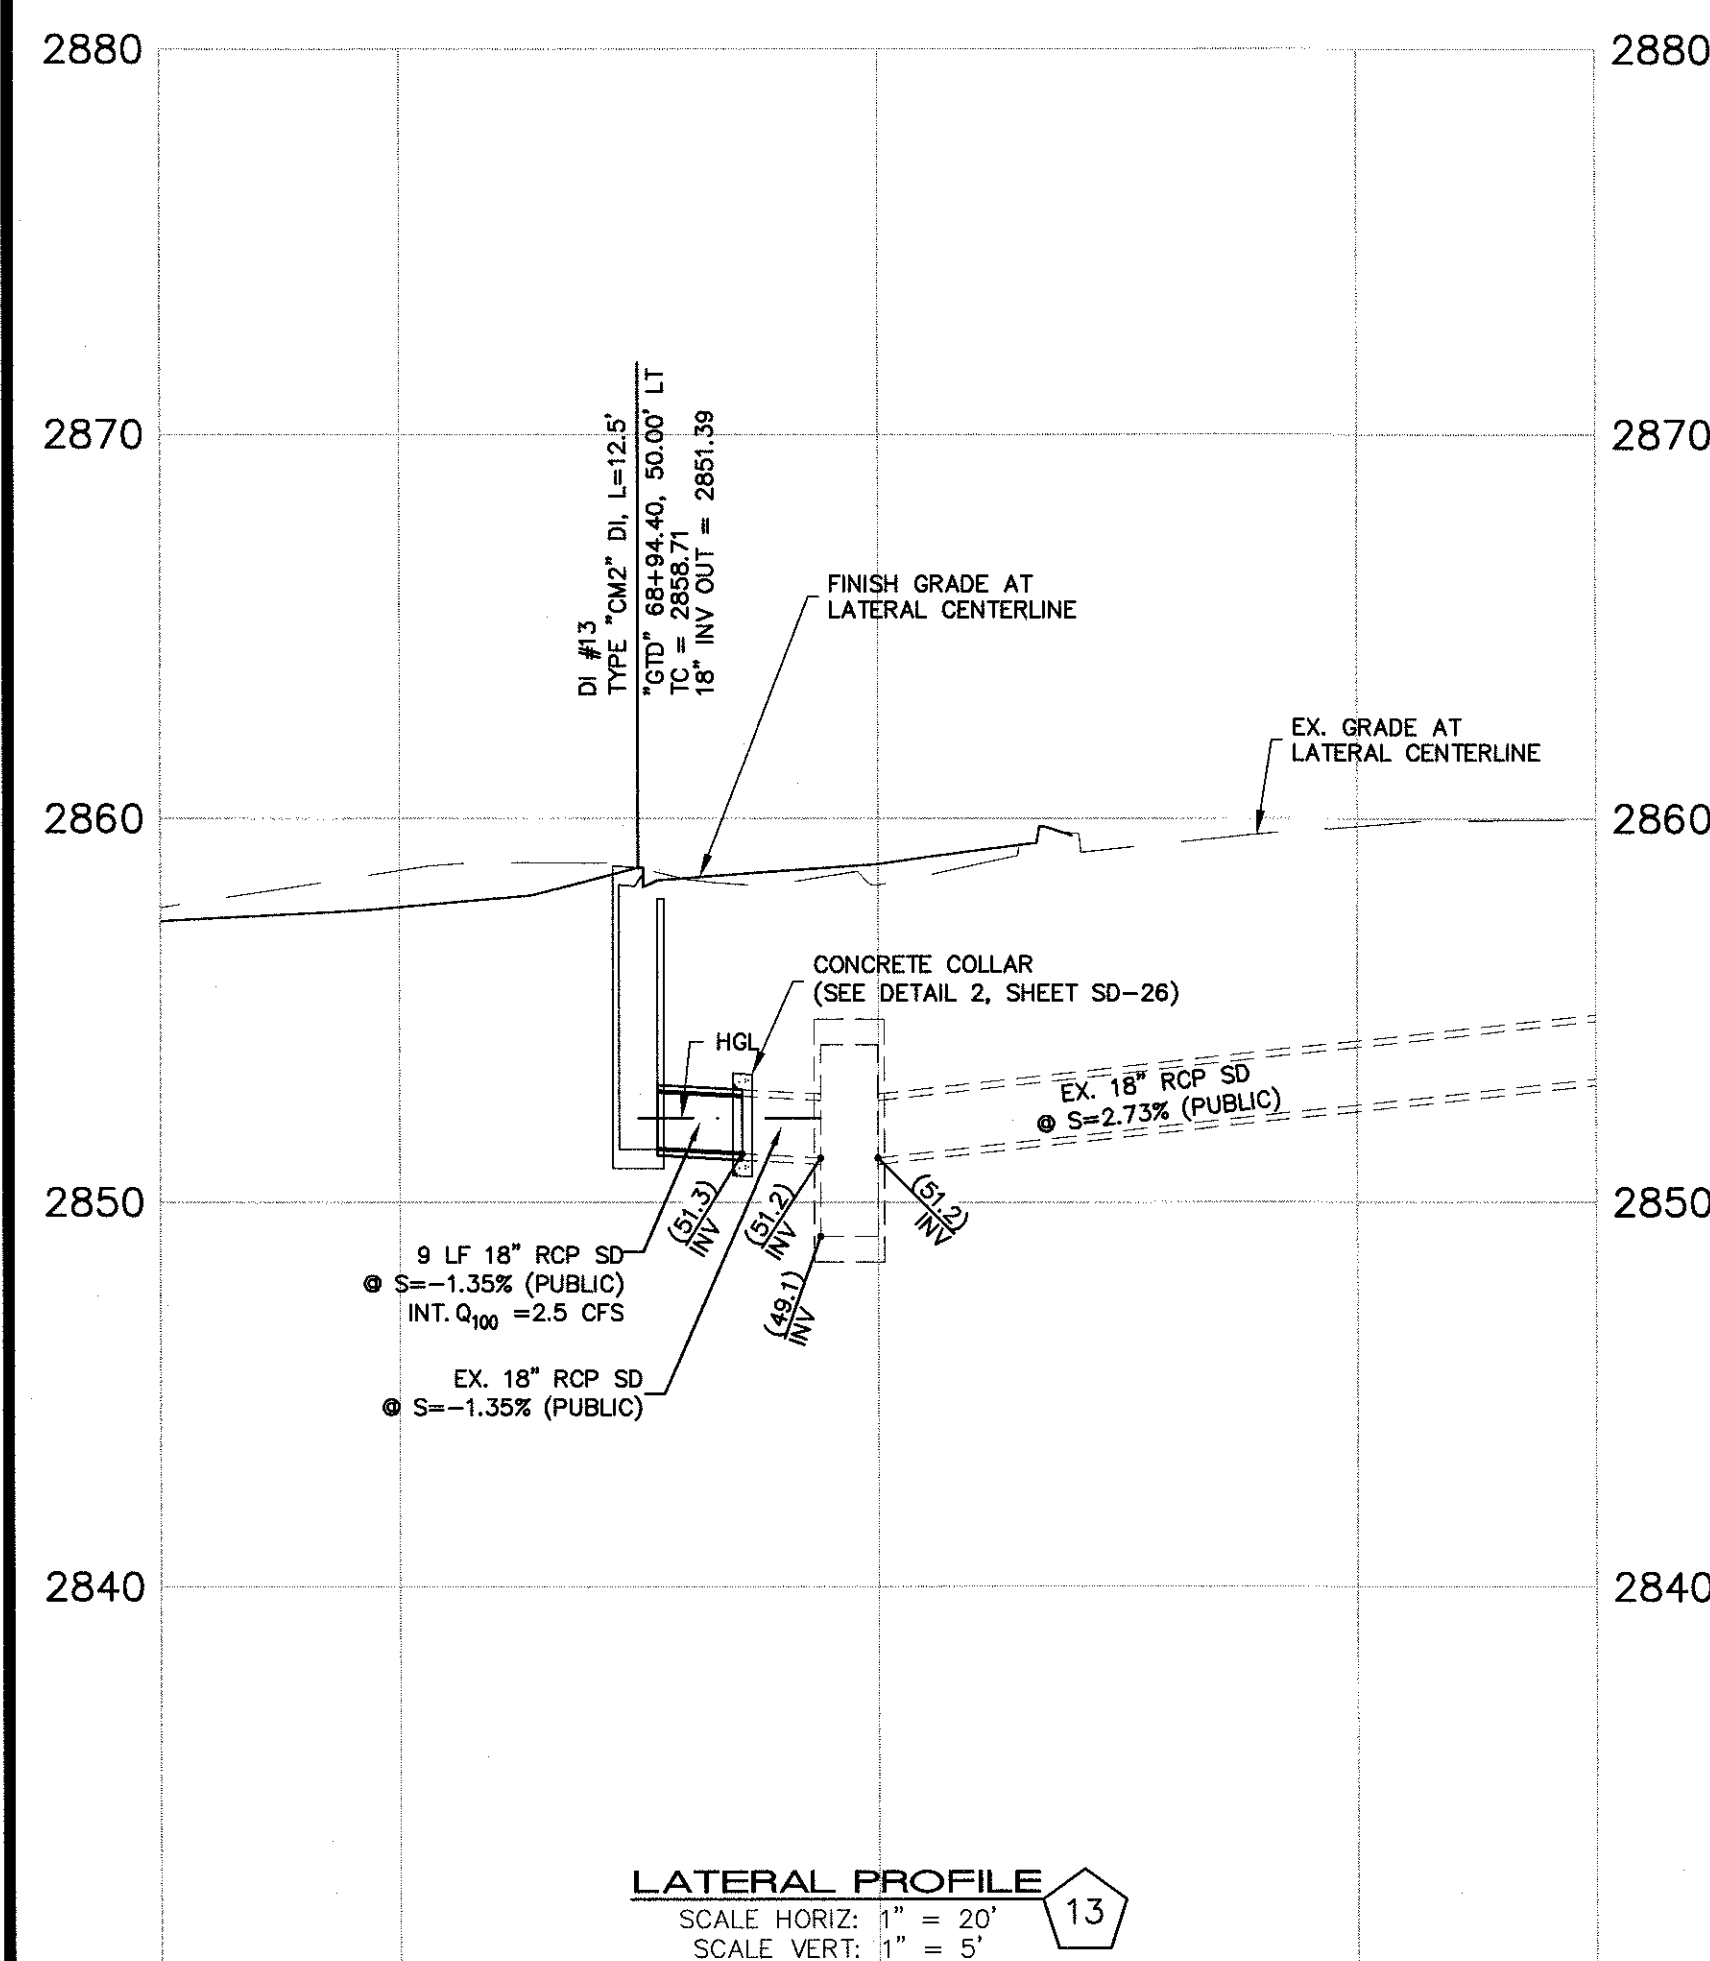

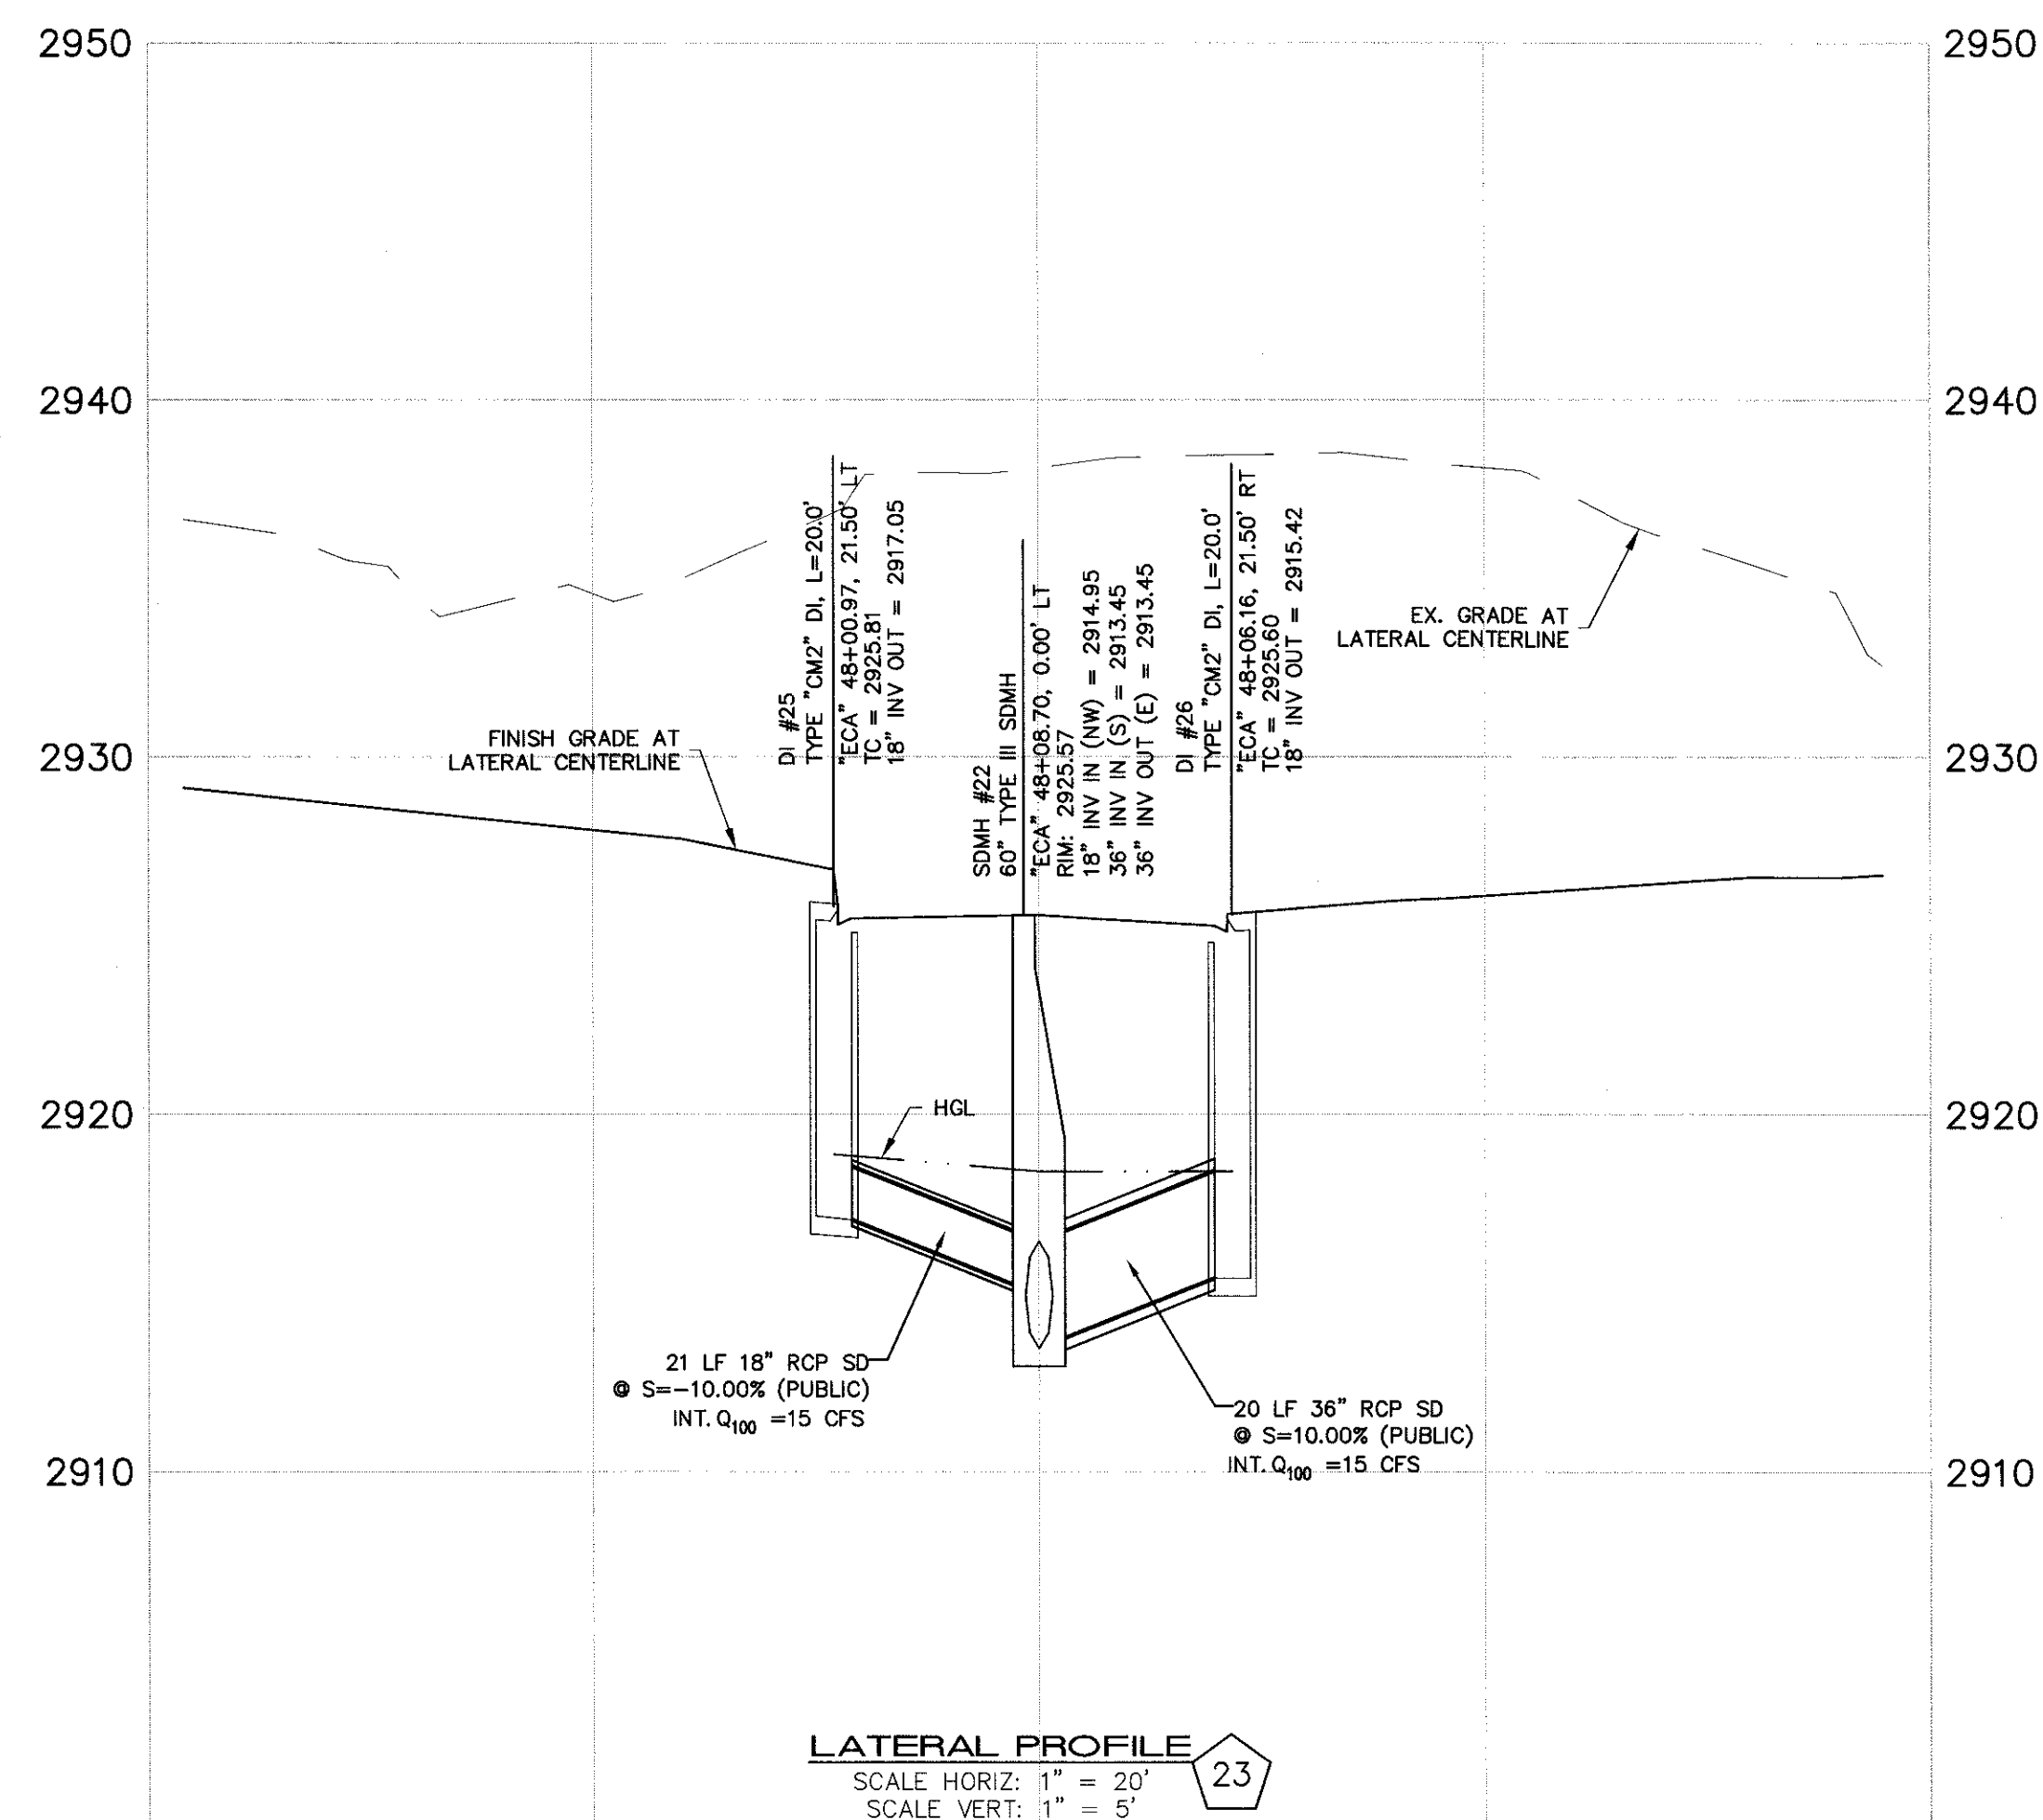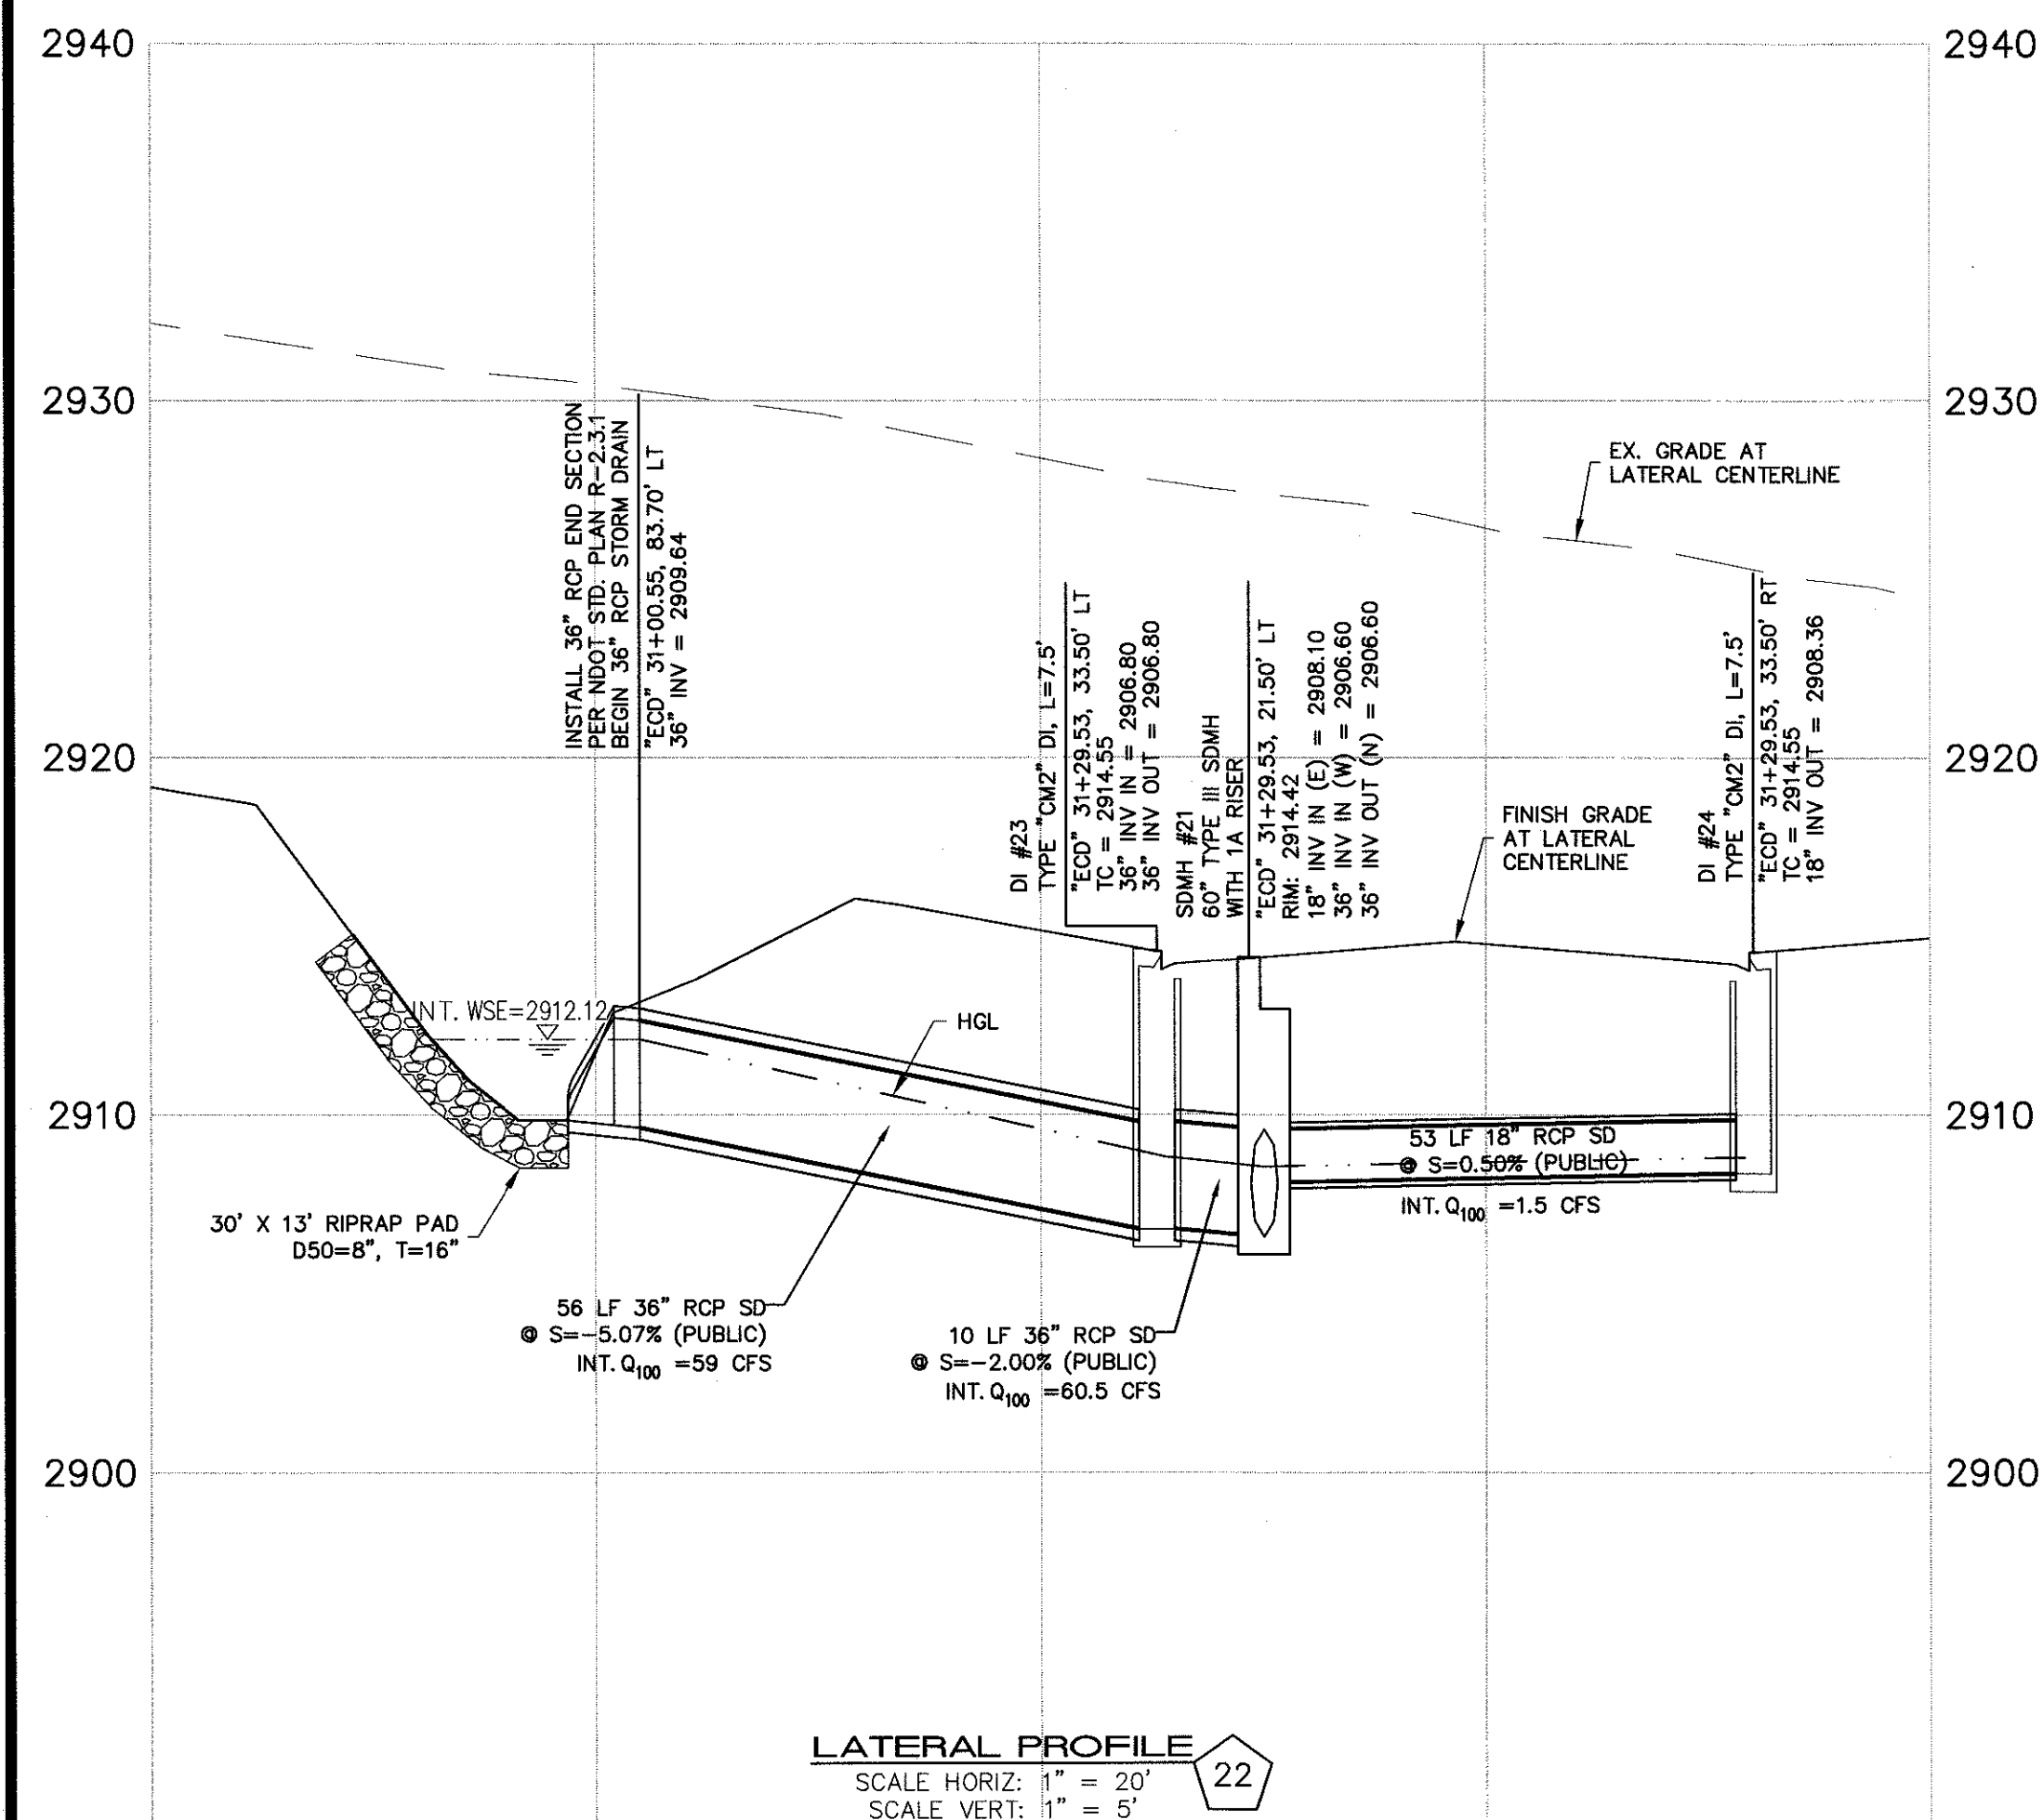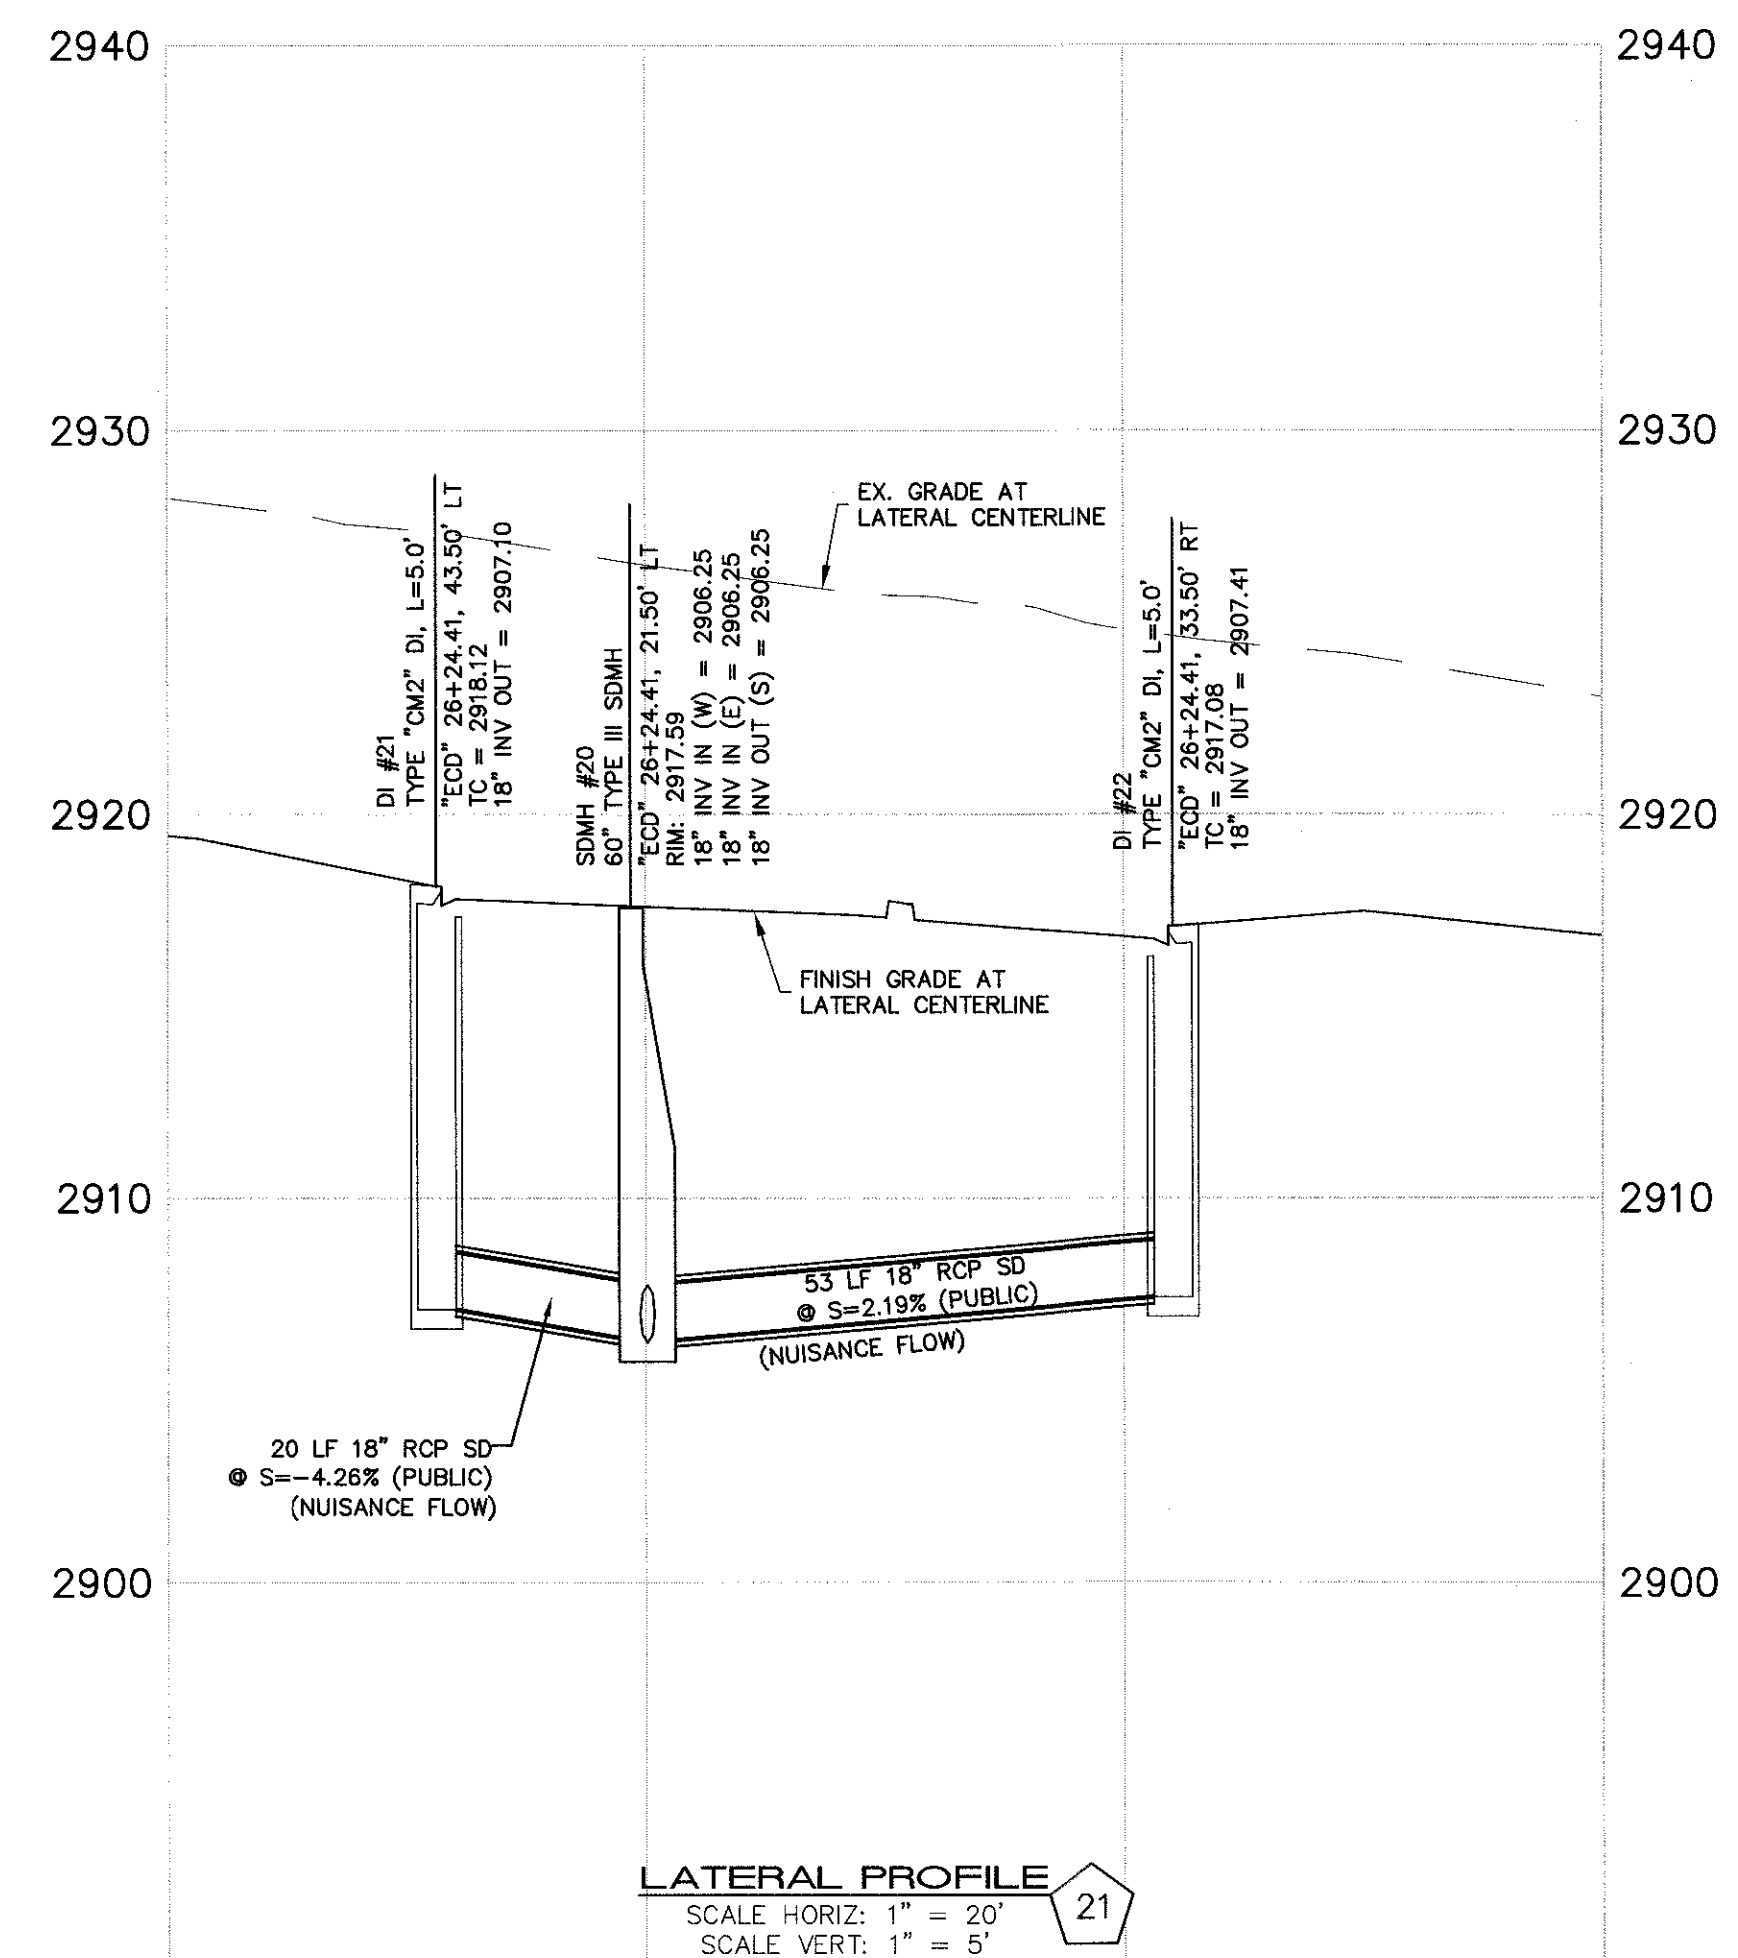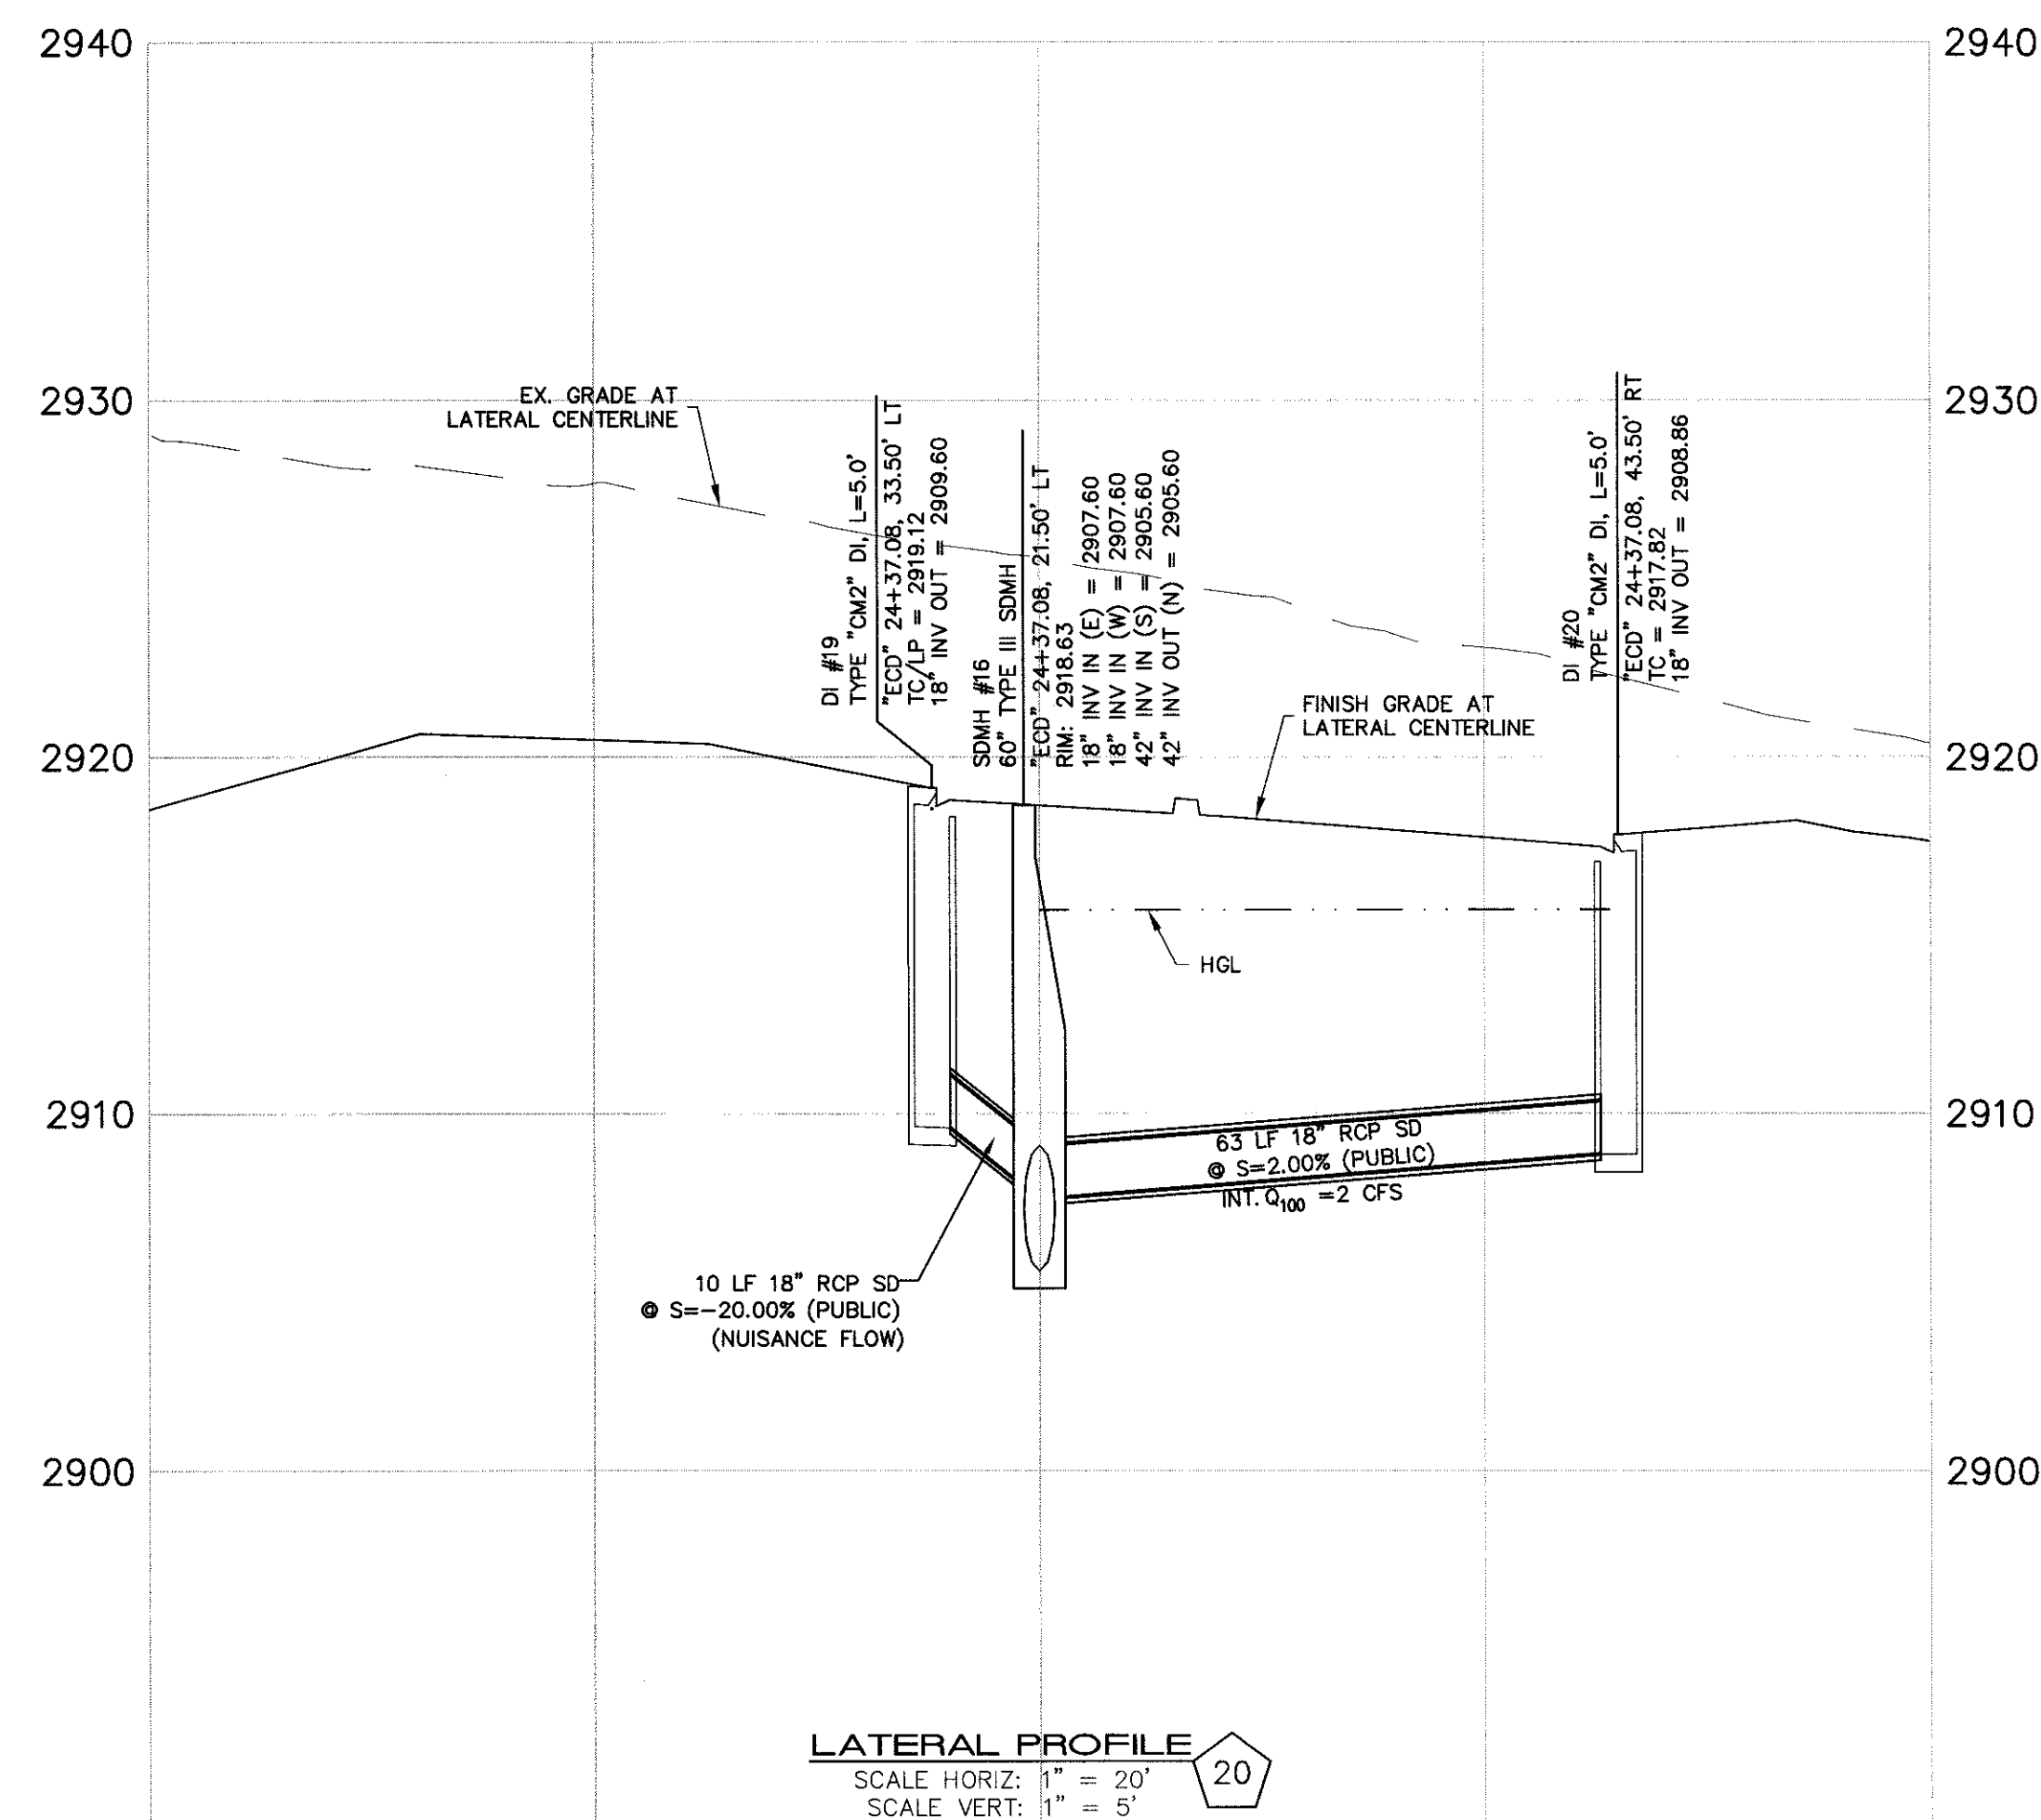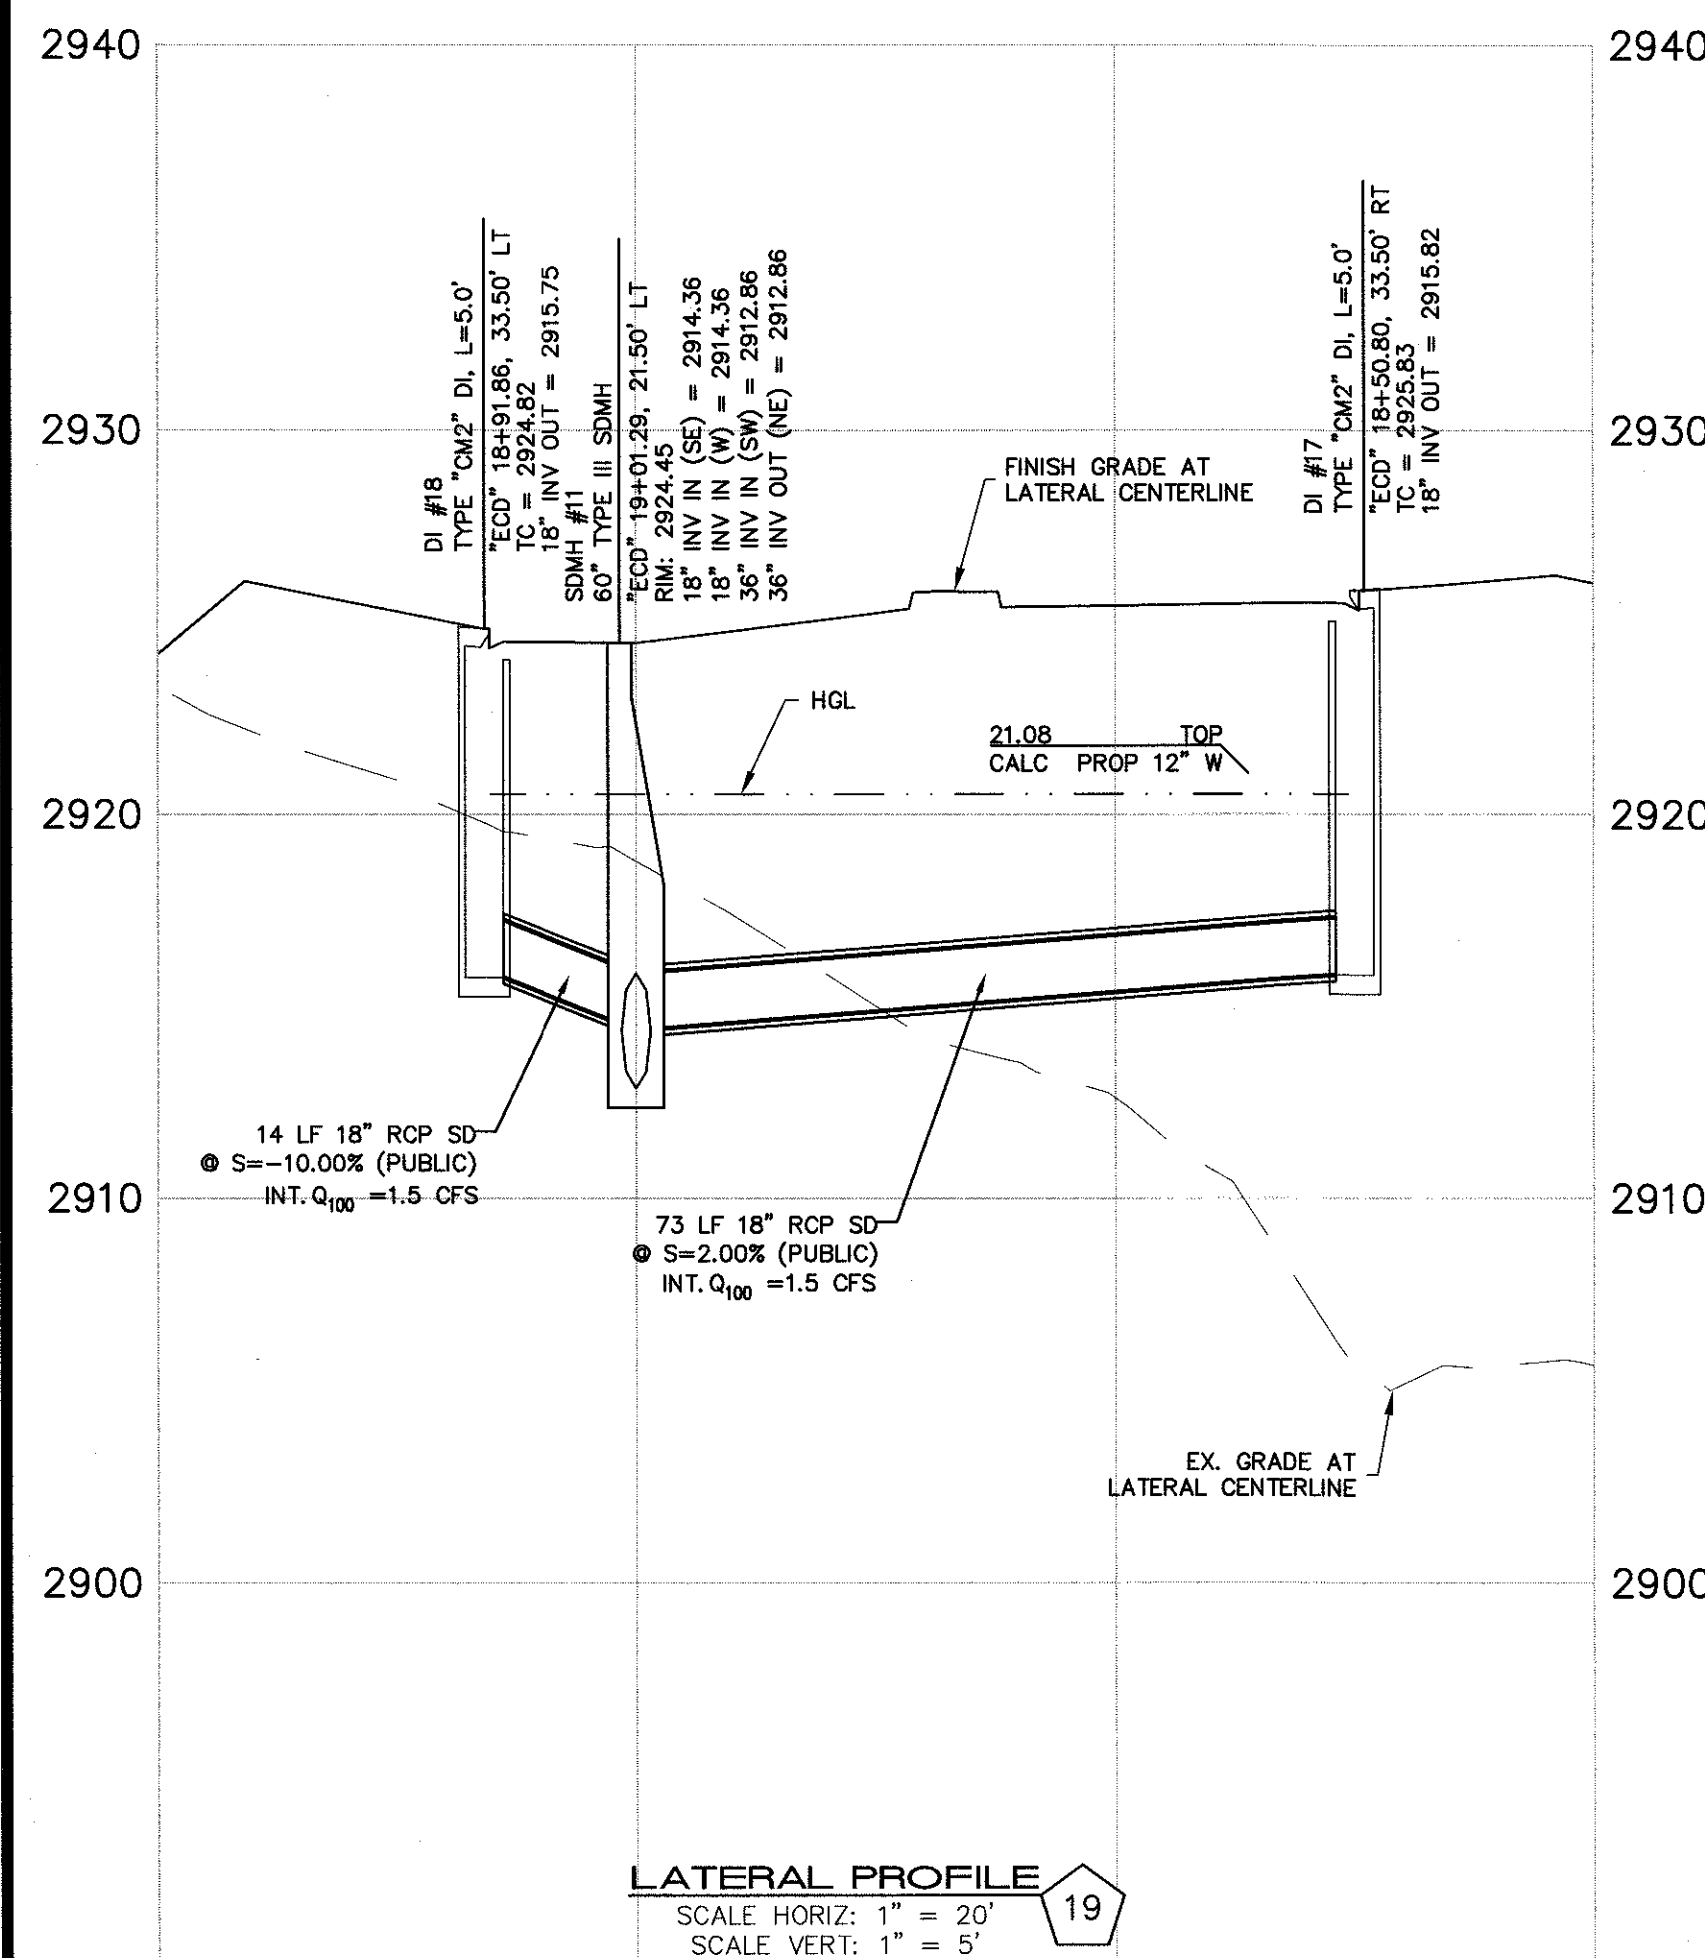[illegible]

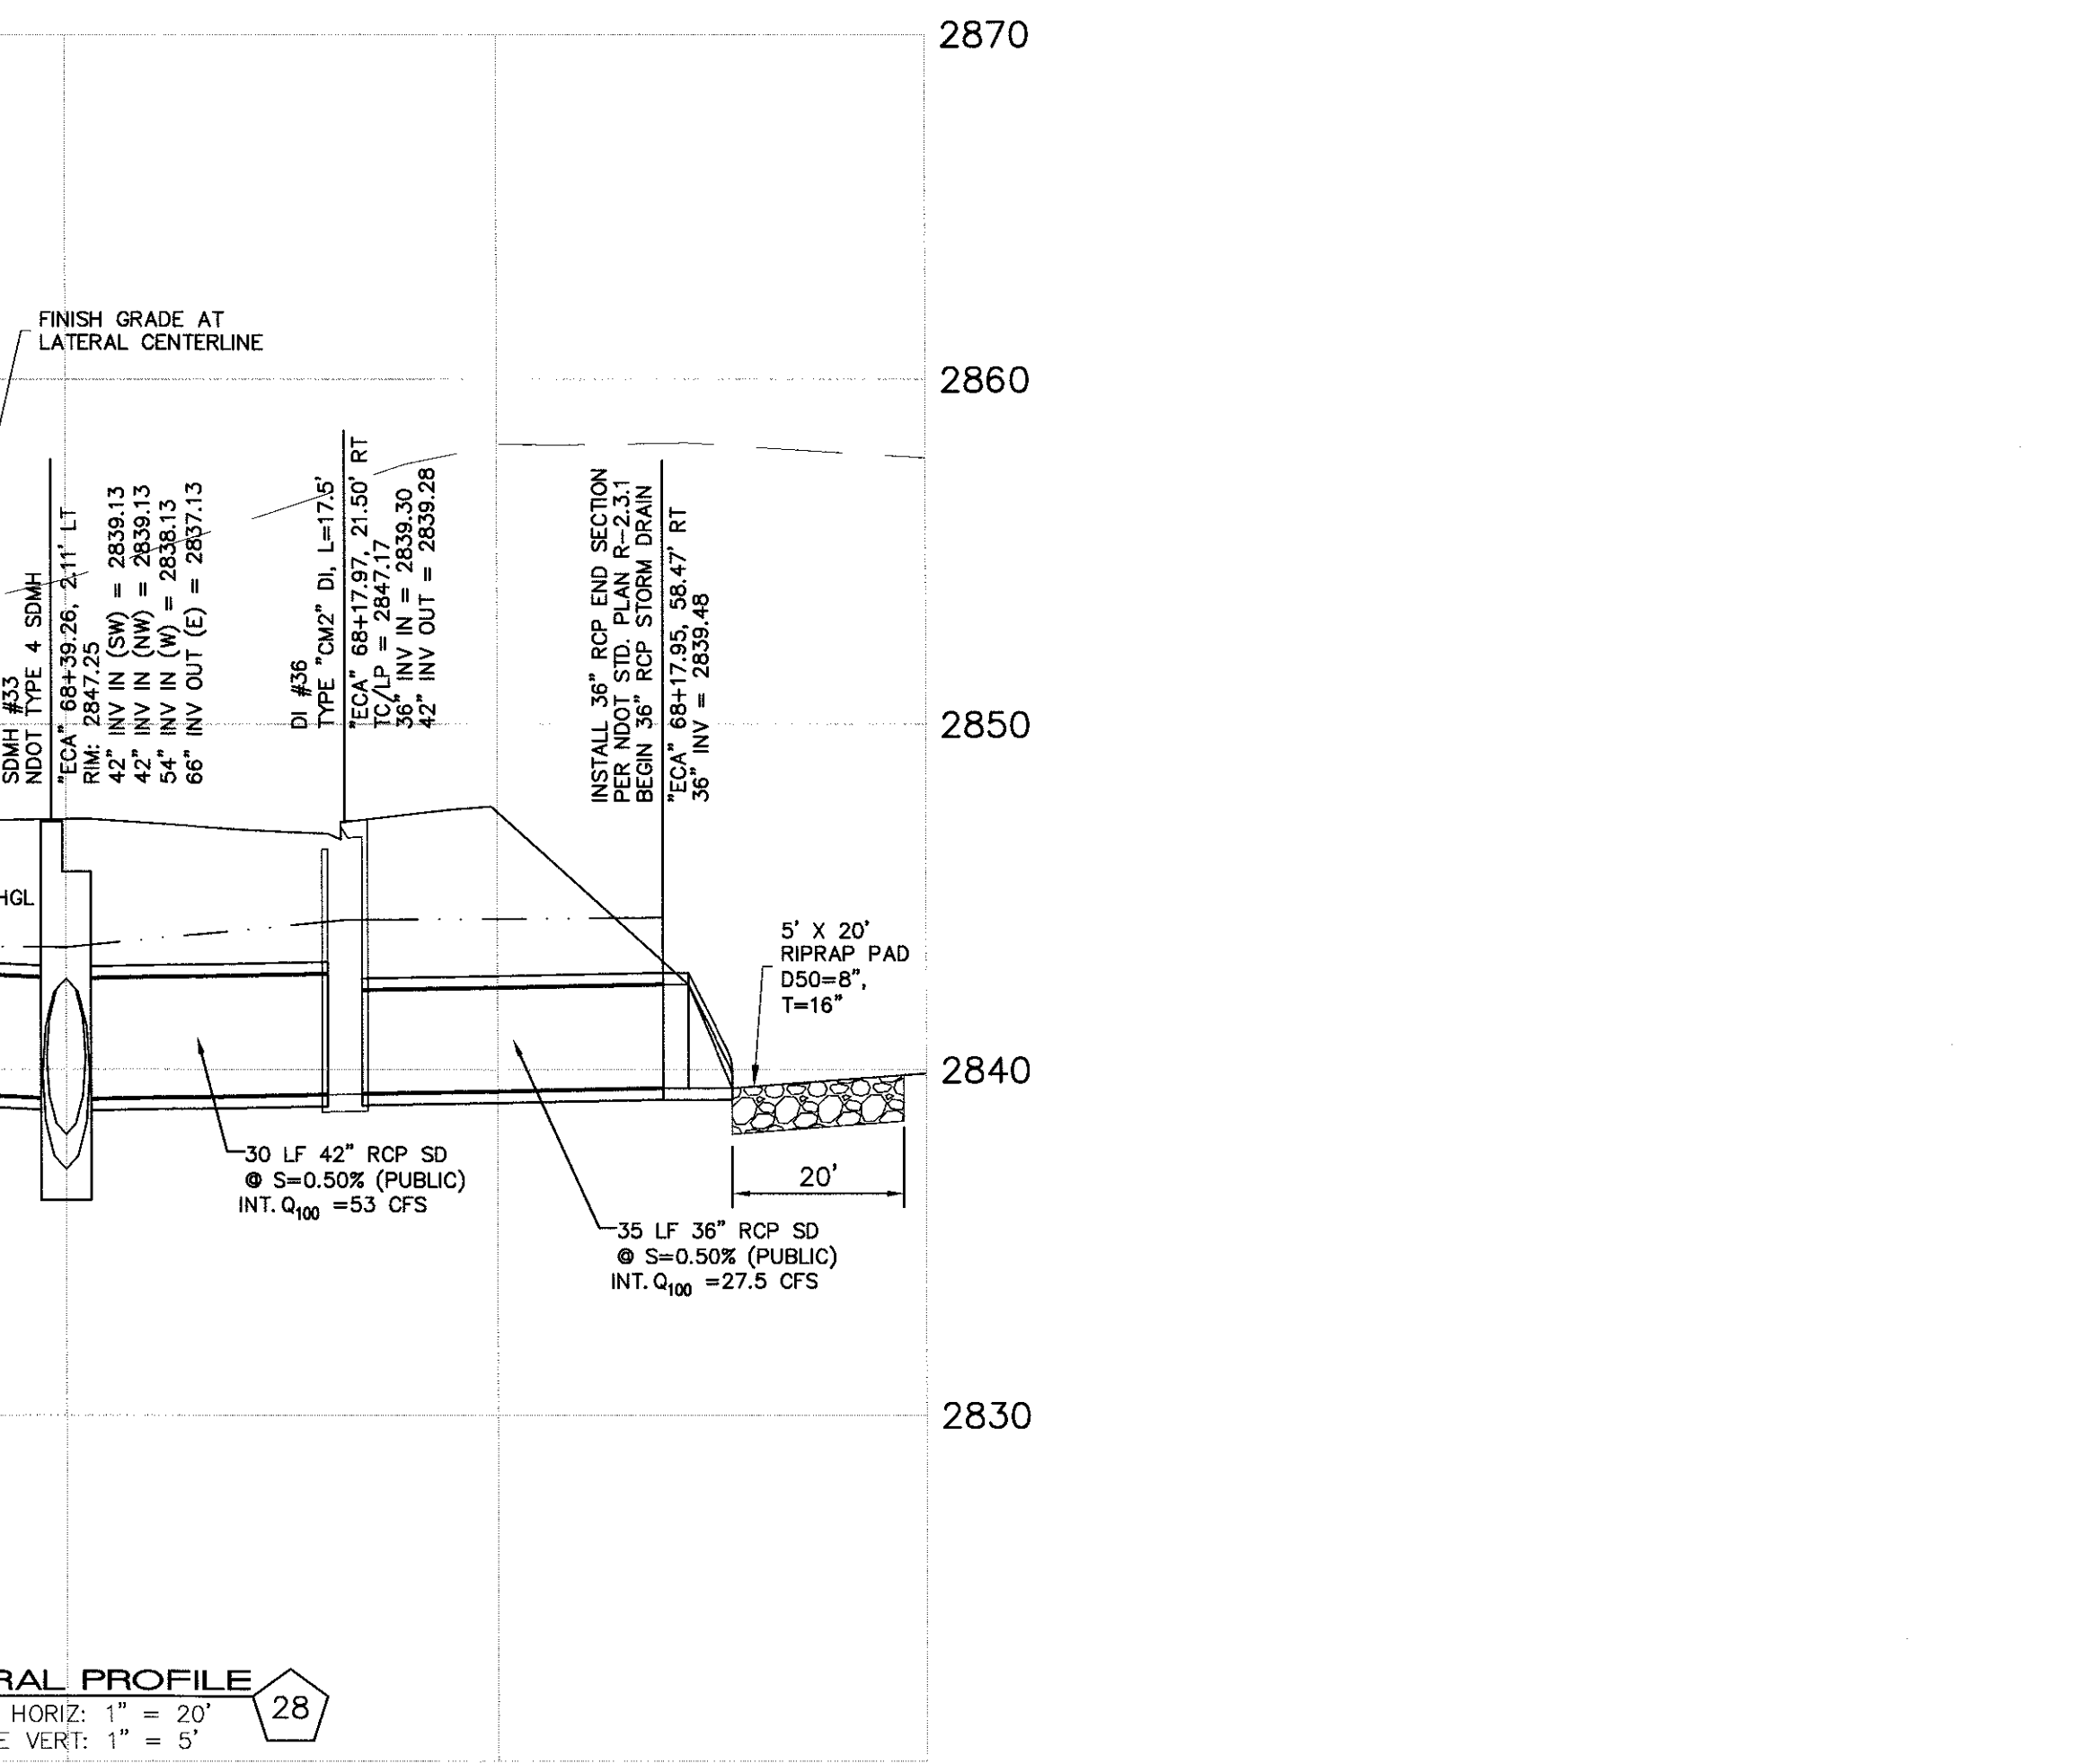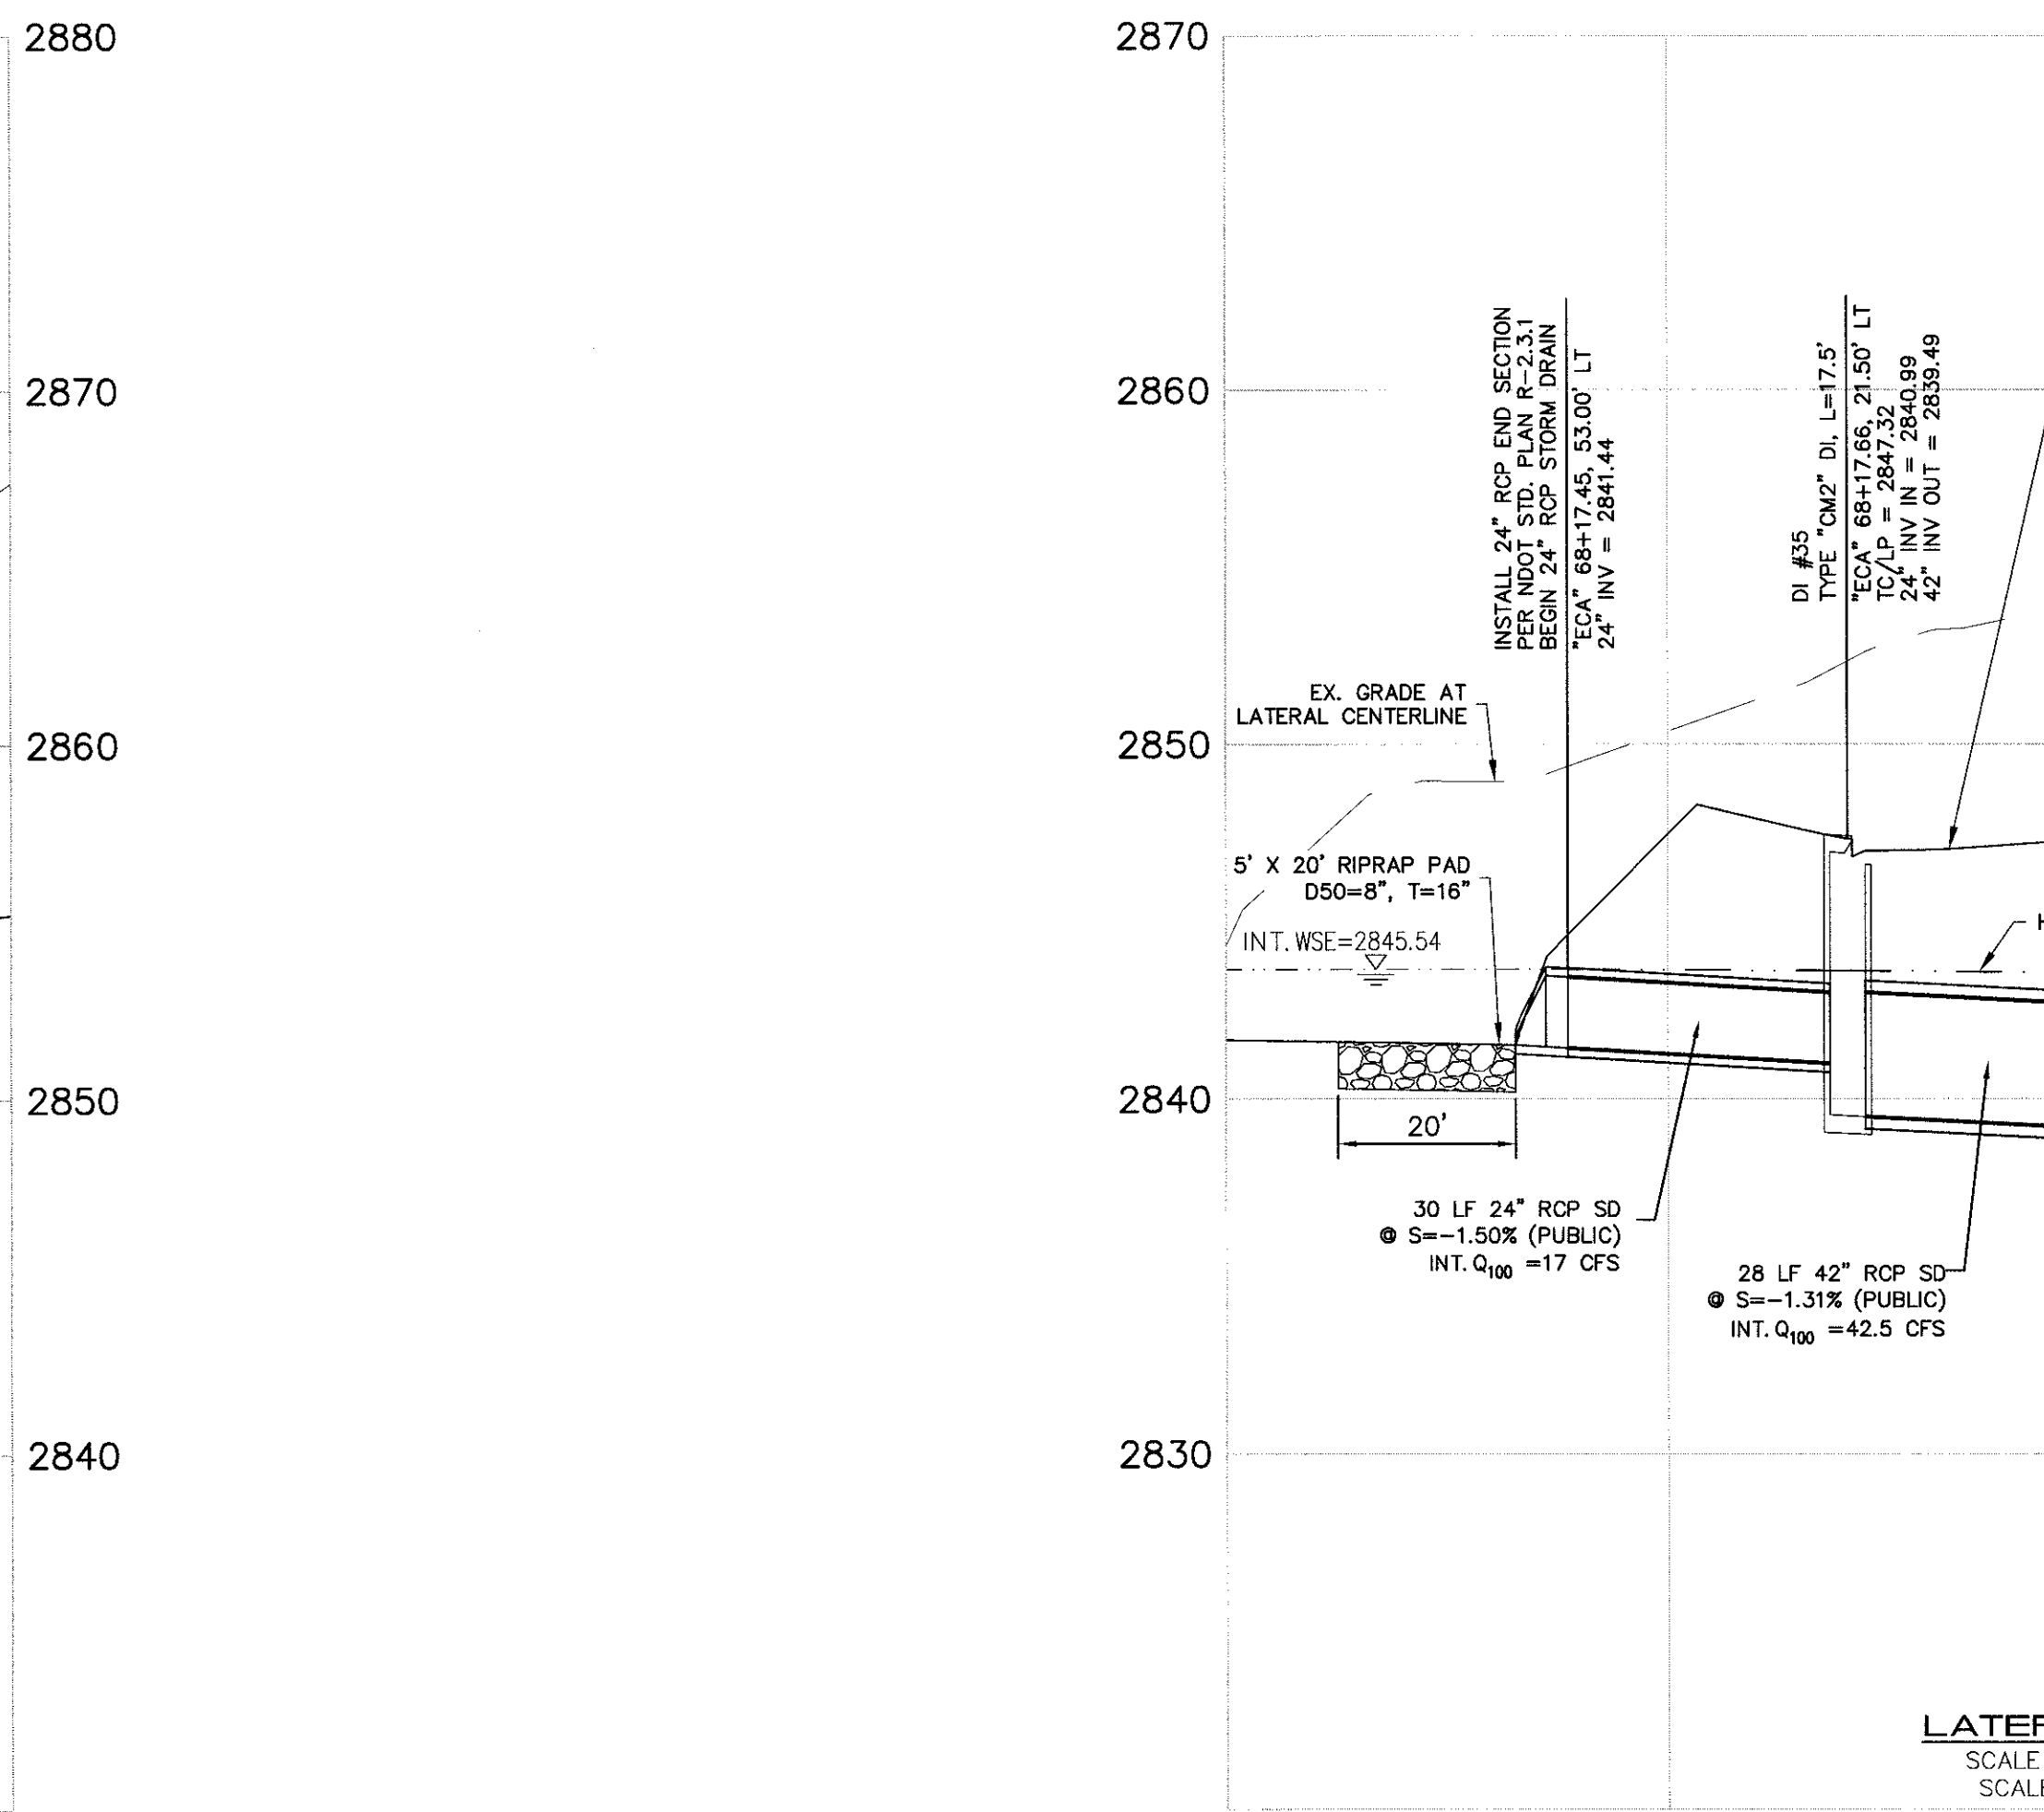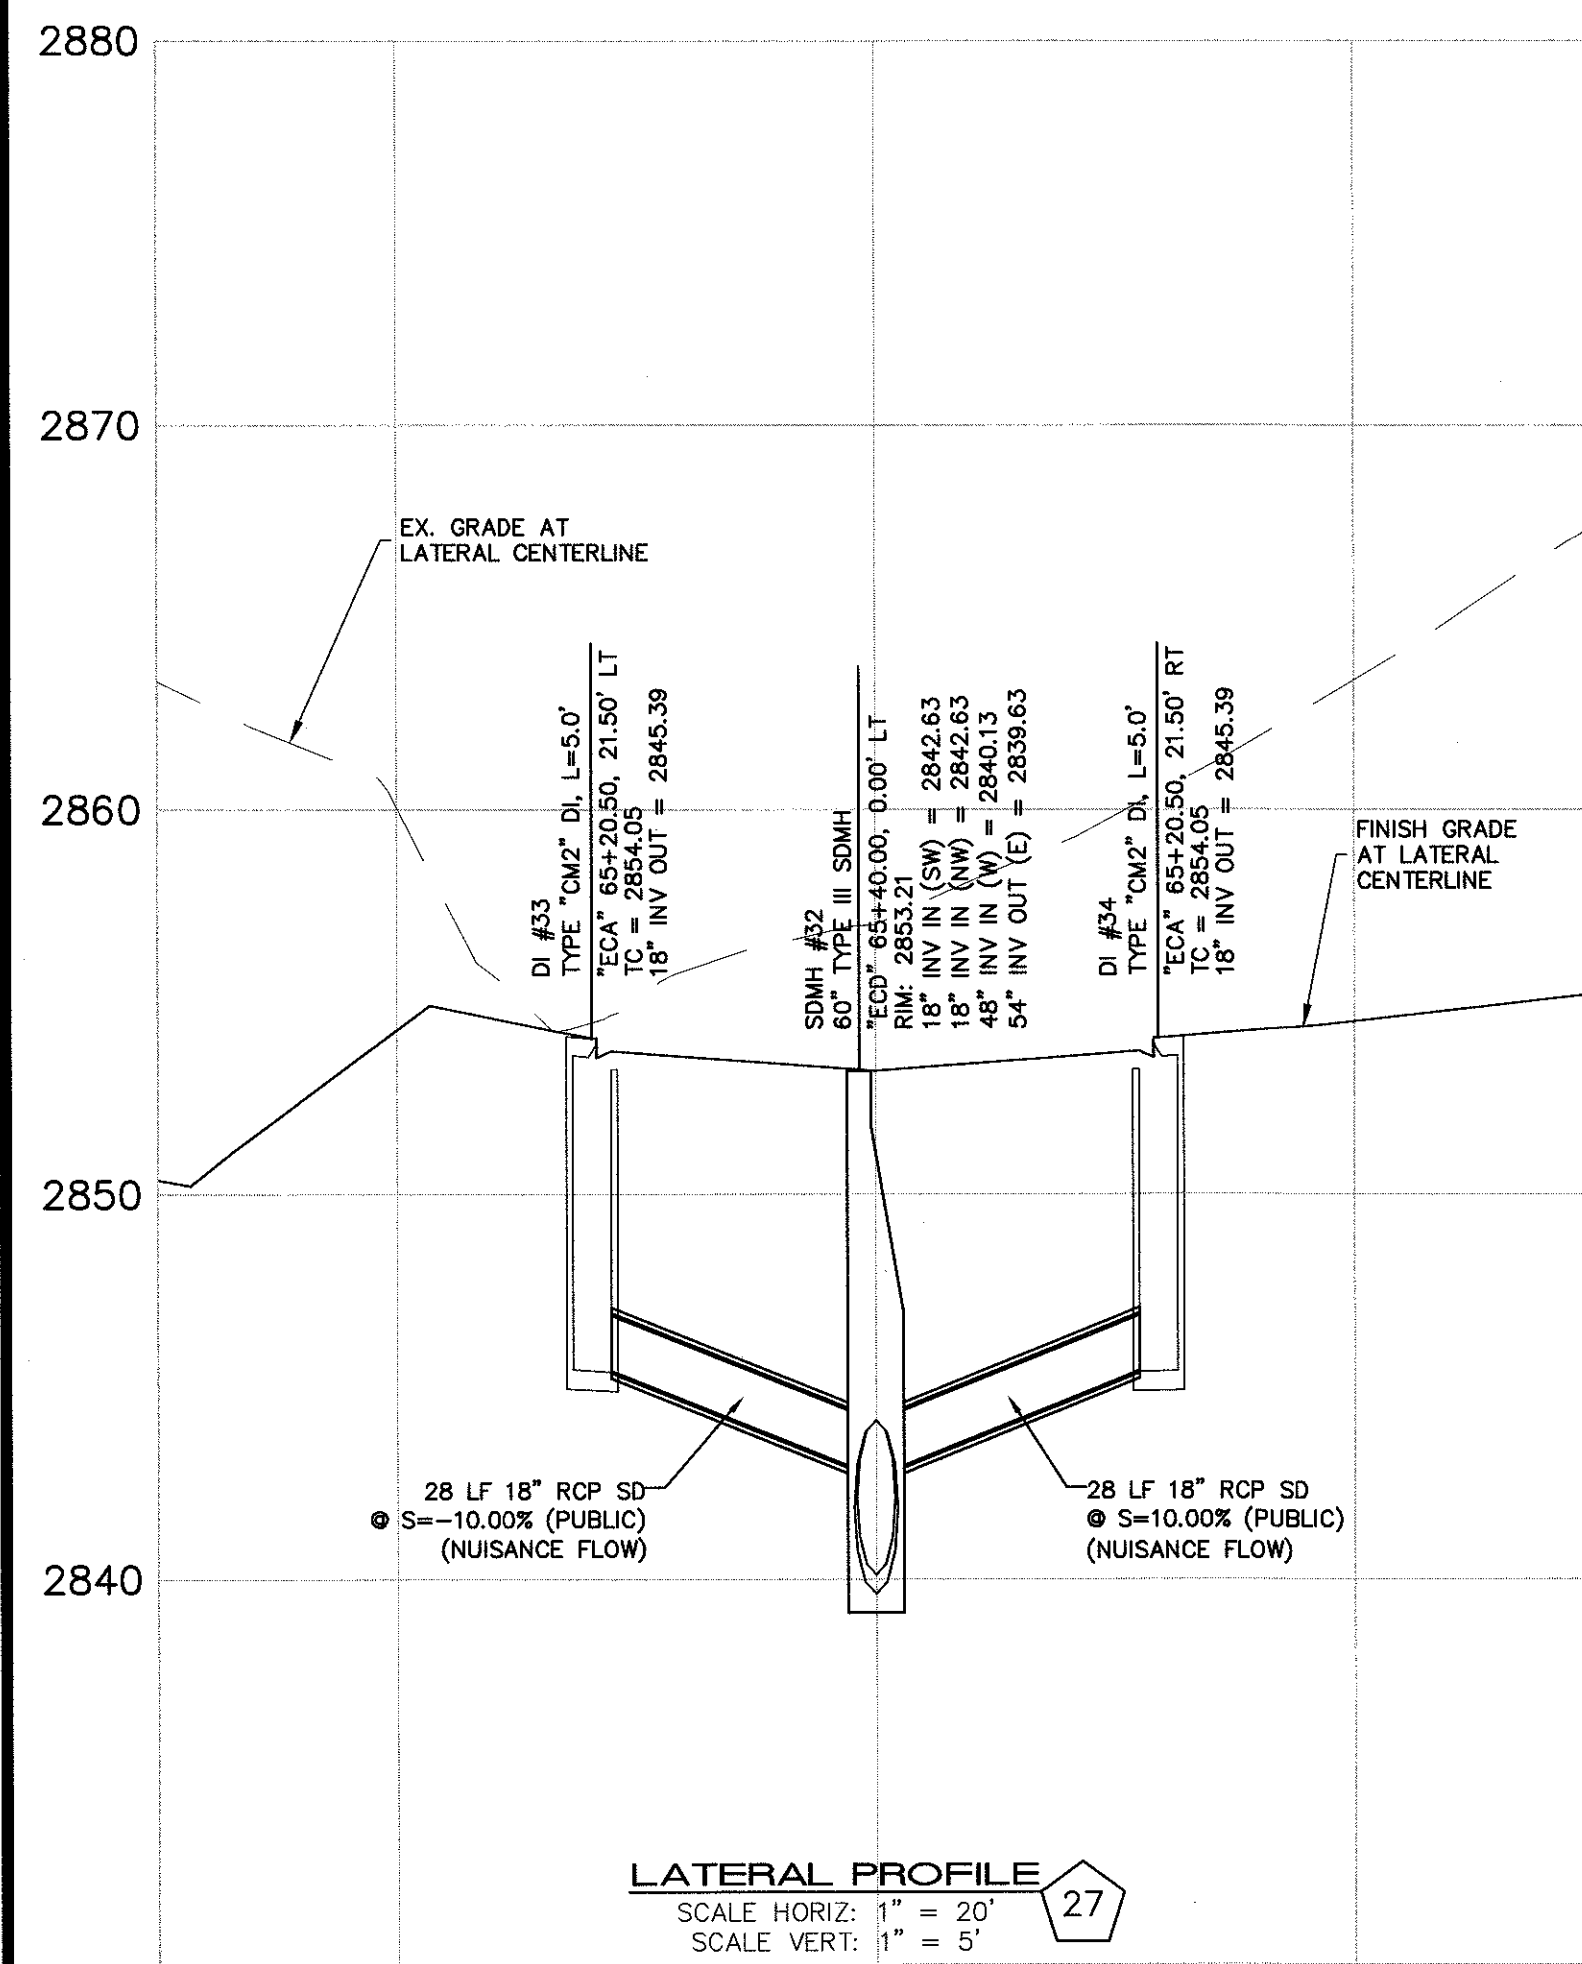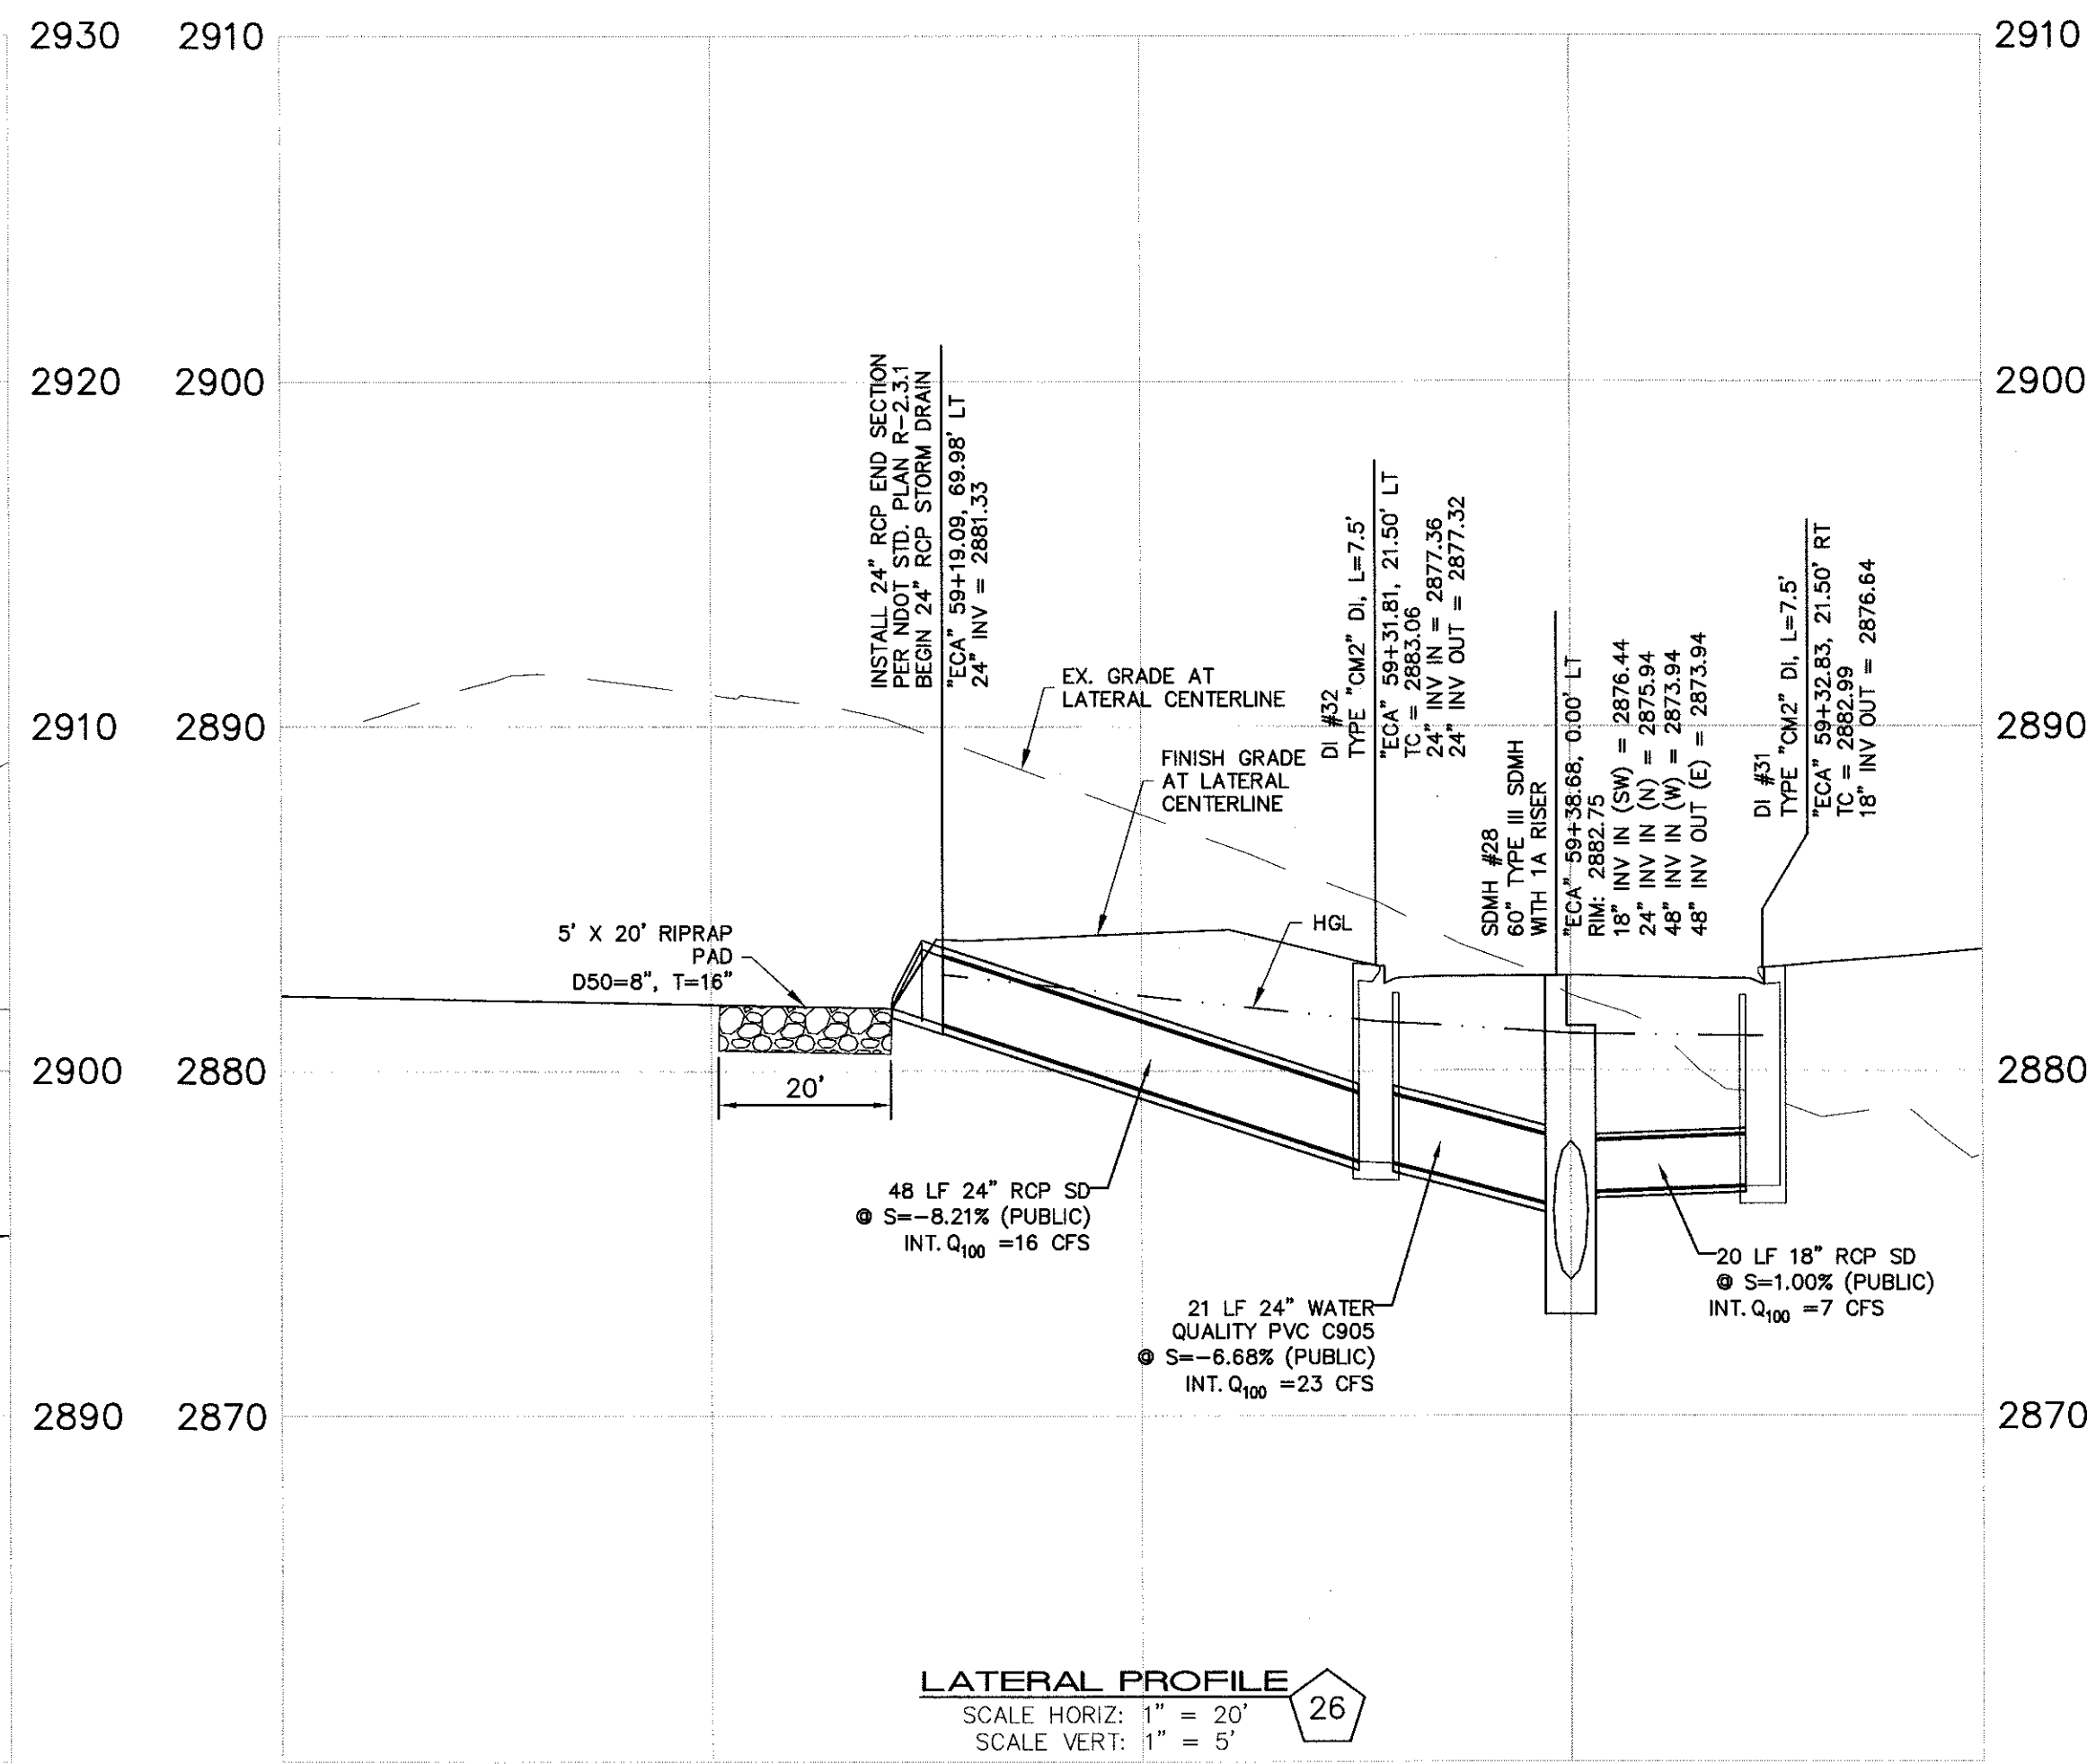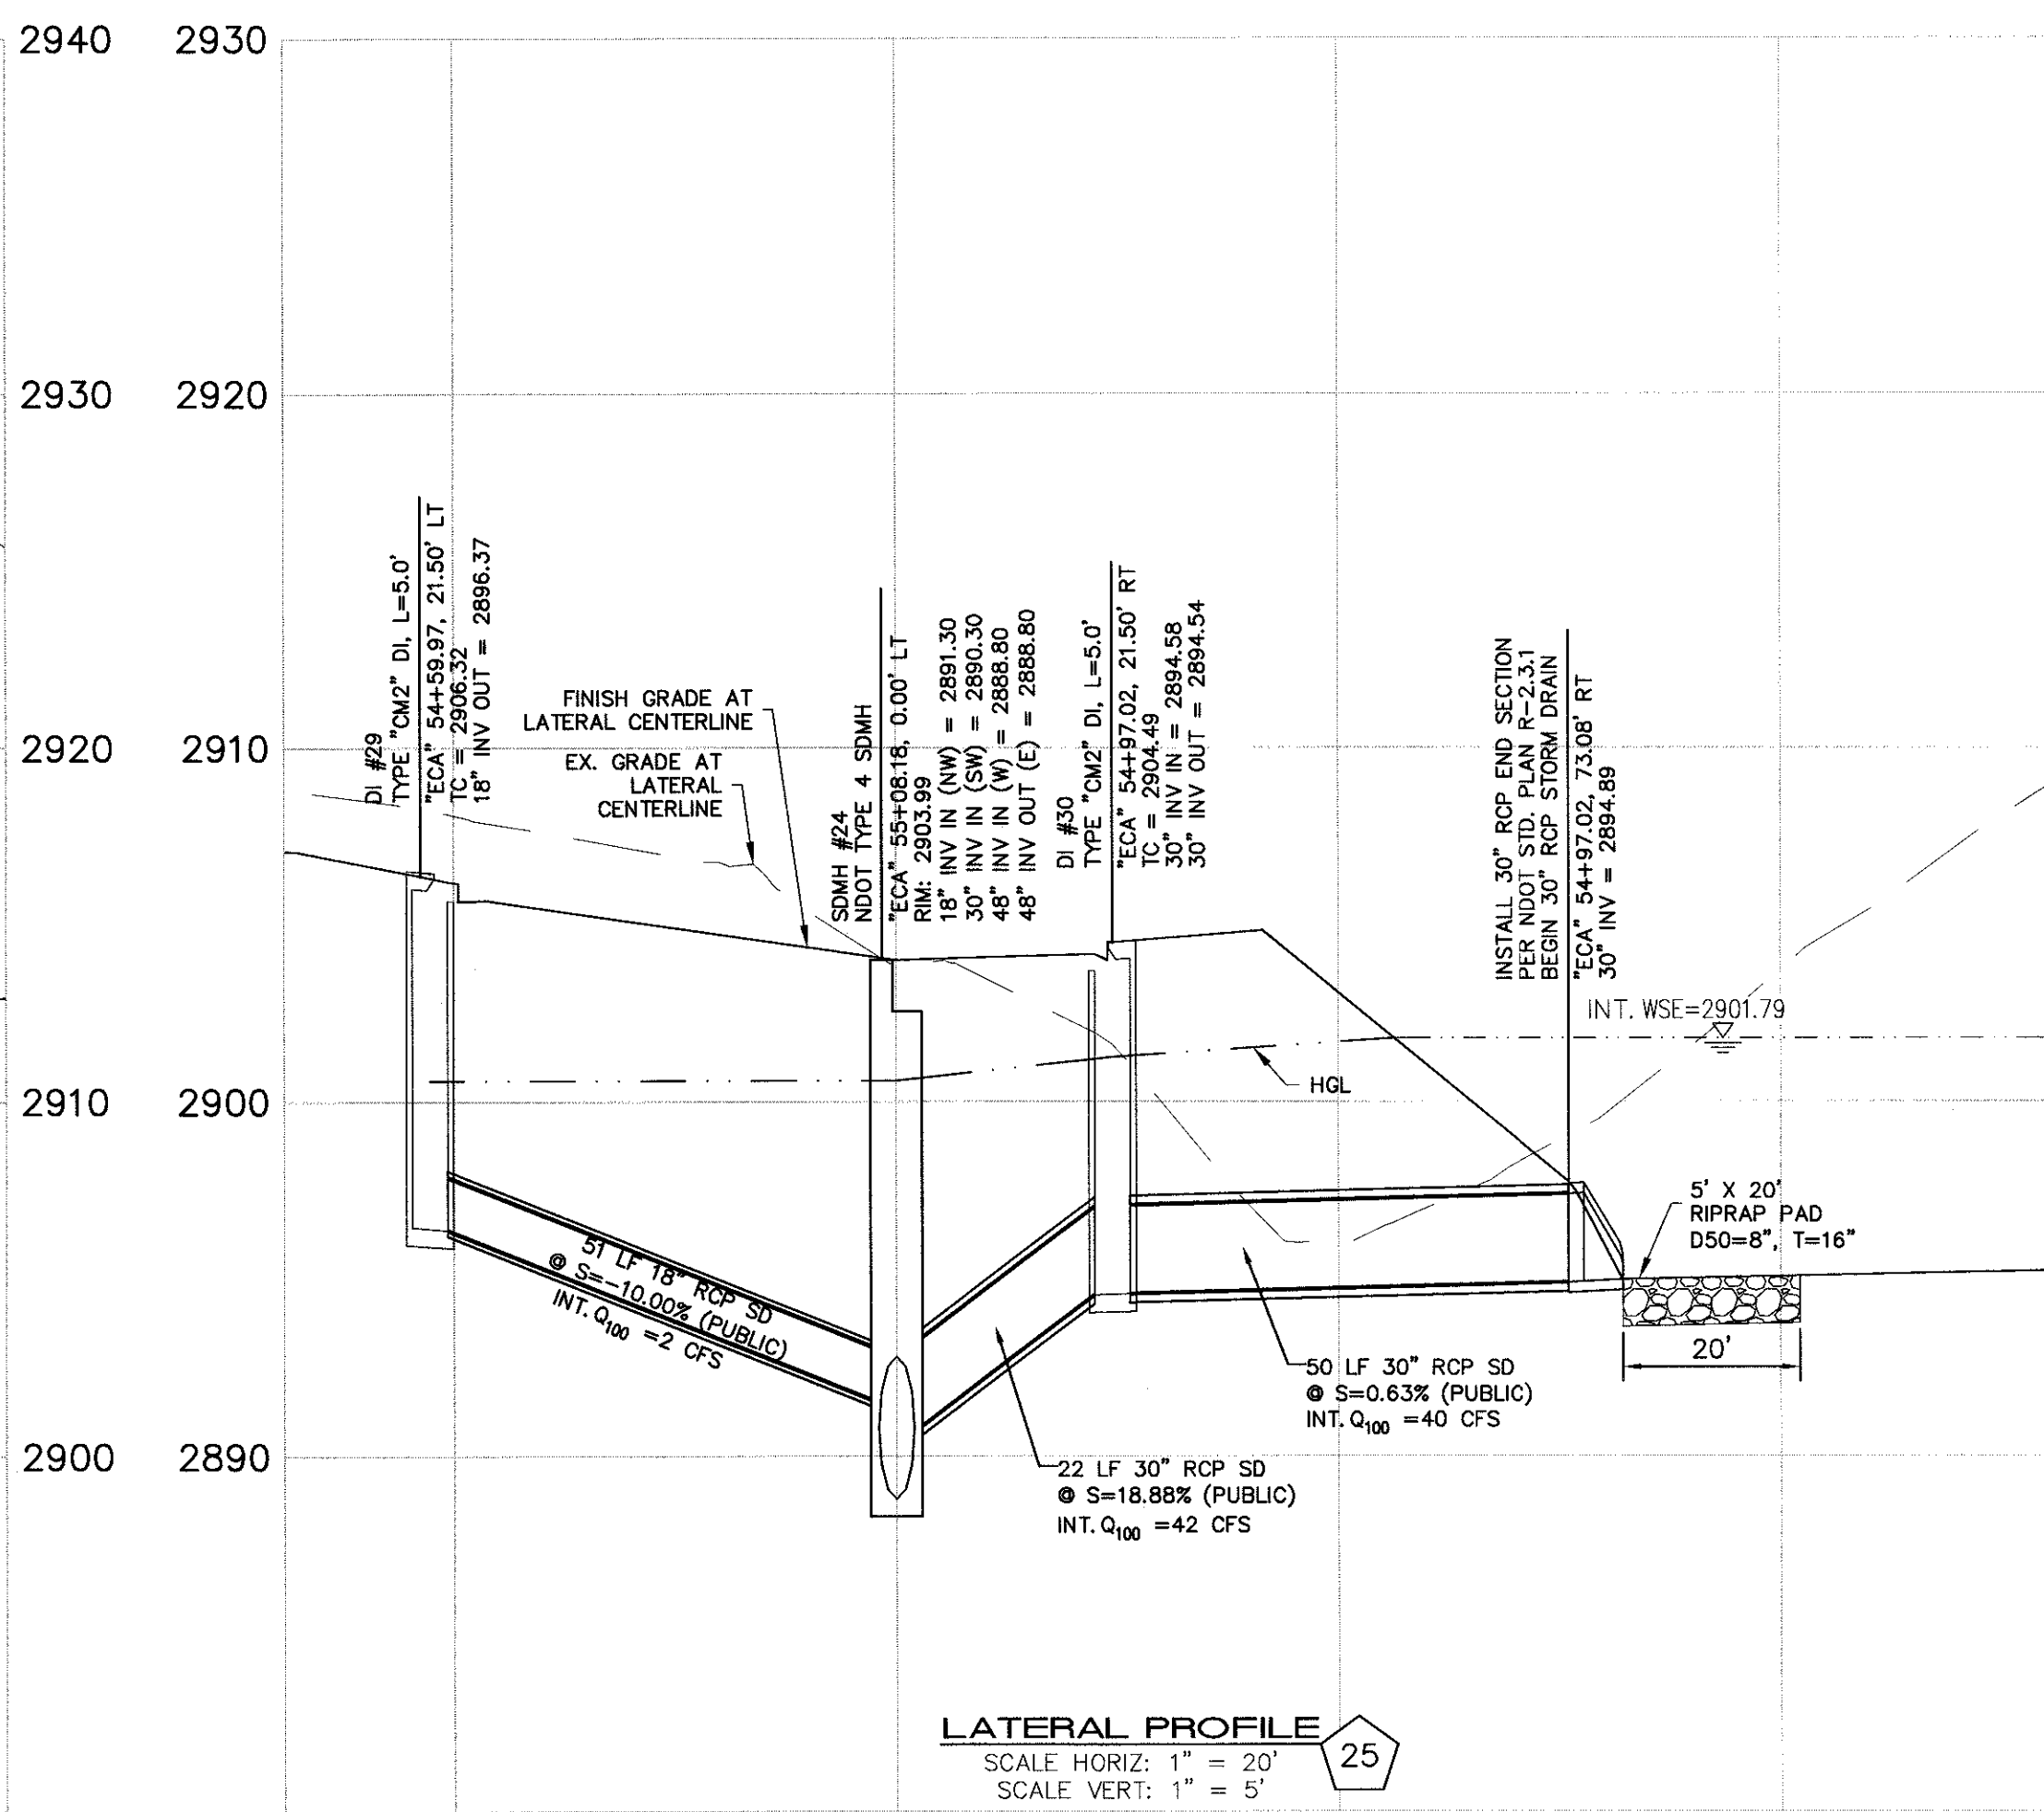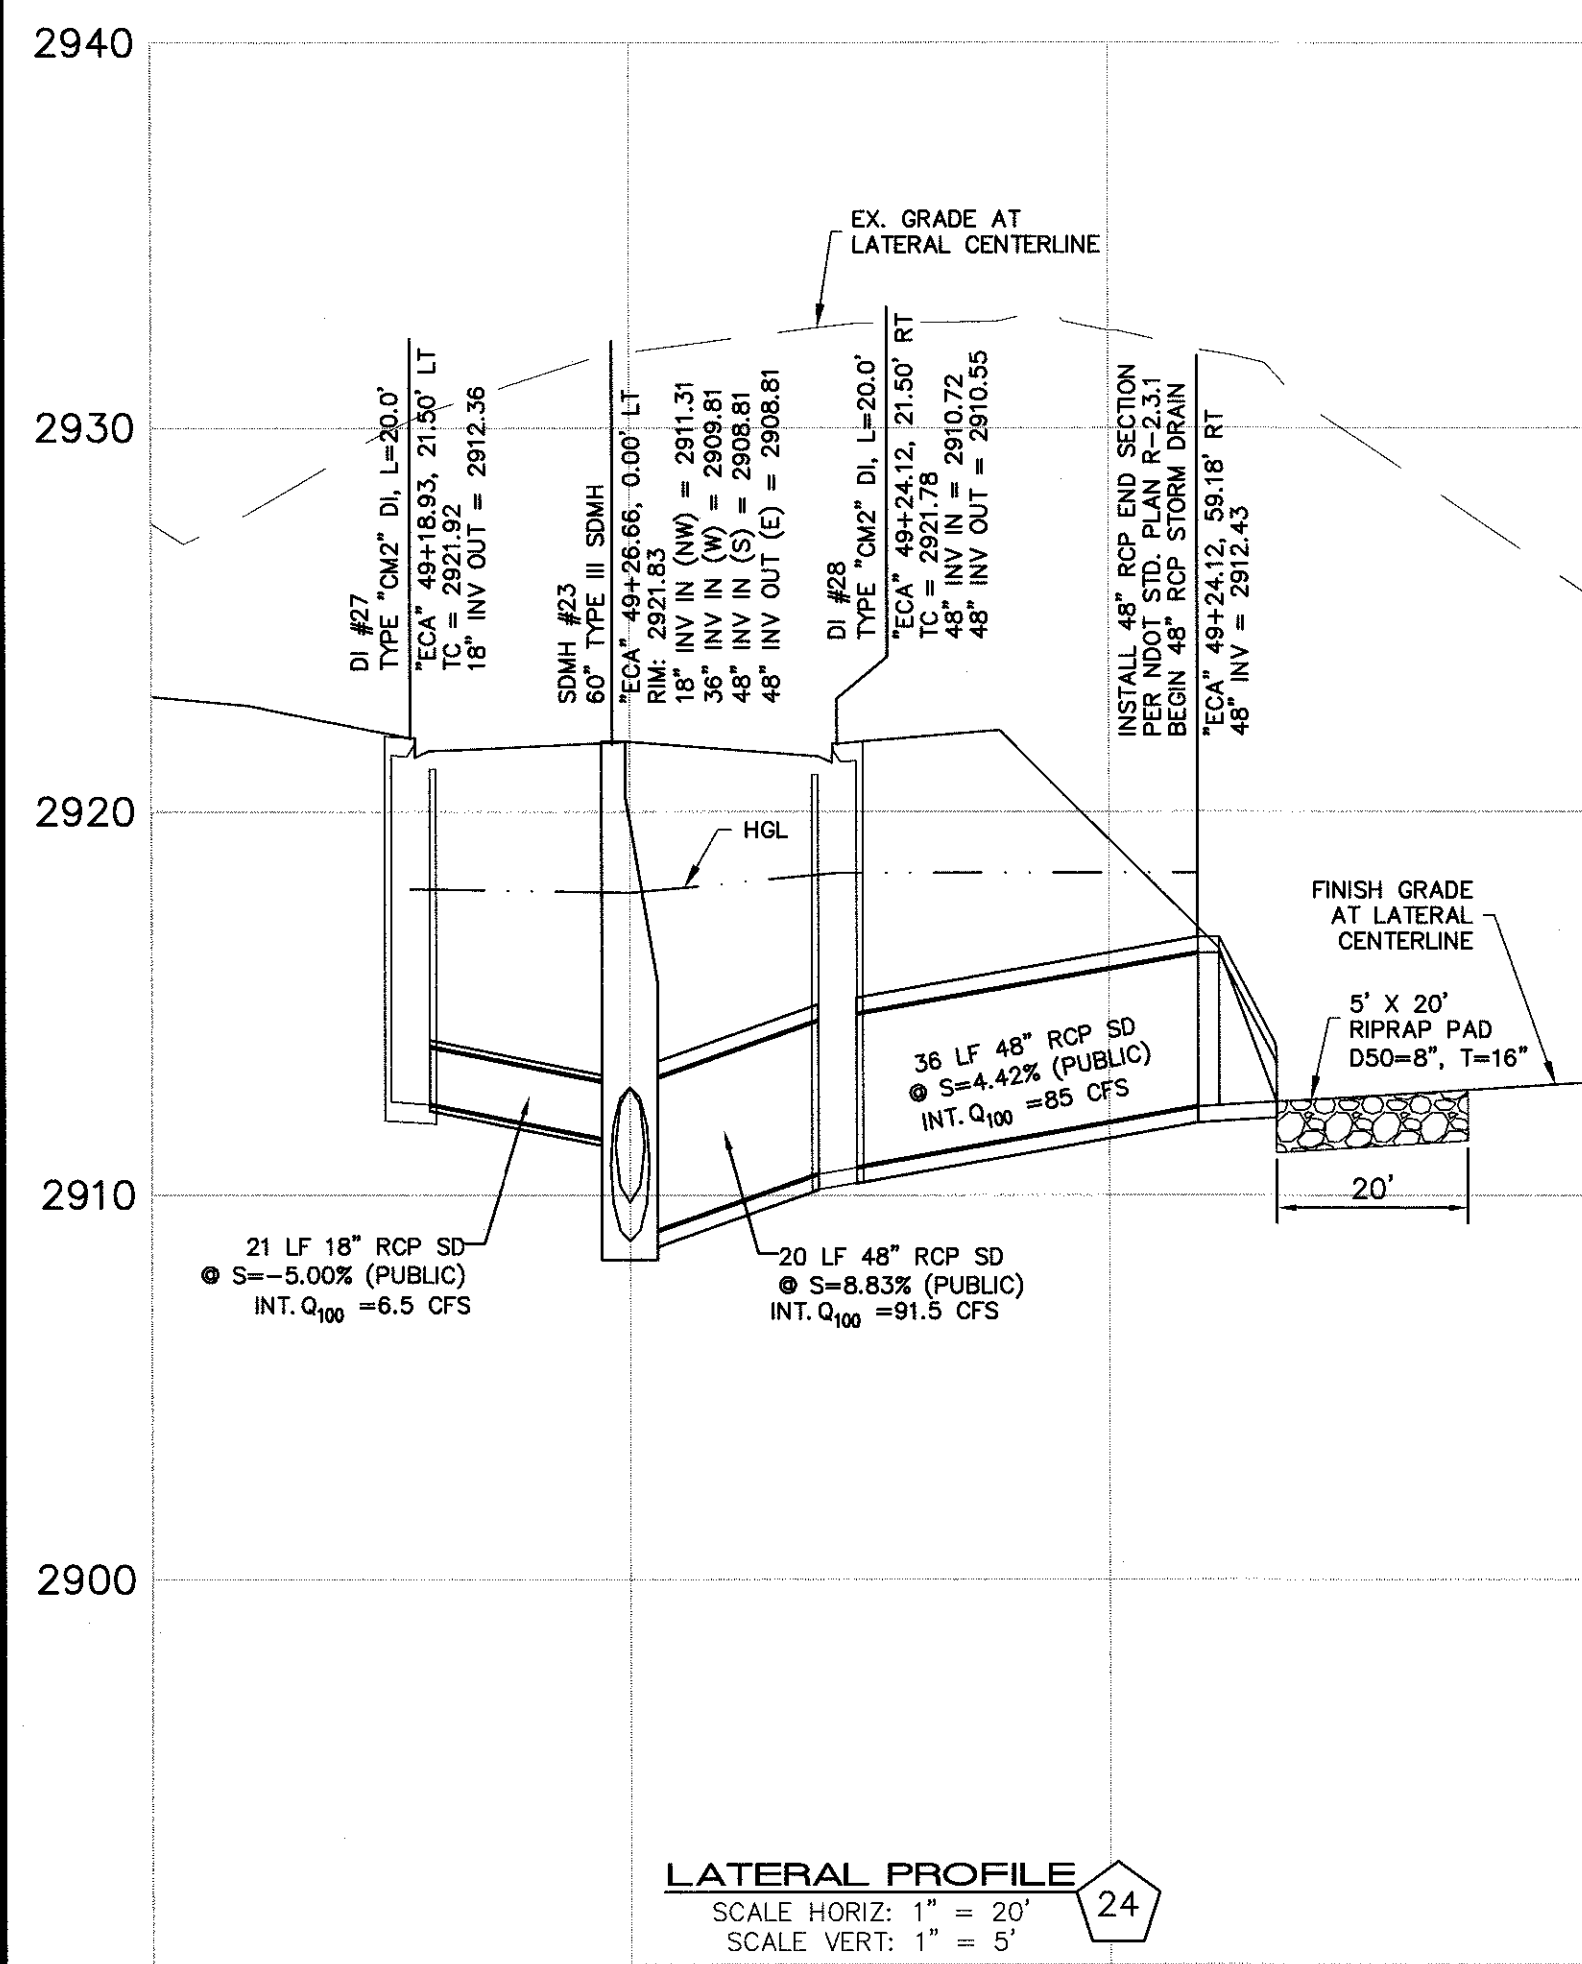


NO.	DESCRIPTION	DATE	BY	APP.

NINETY-FIVE MANAGEMENT LLC
SKYE CANYON PHASE 2
STORM DRAIN LATERAL PROFILES

DATE: 11/19/15
DRAFTER: JAS
DESIGNER: DAM
CHECKED: JSR
PROJECT NO.
OLY1501-001

PROFESSIONAL ENGINEER - STATE OF NEVADA
JERRY J. SLATER
No. 14161
CIVIL
3/22/2016

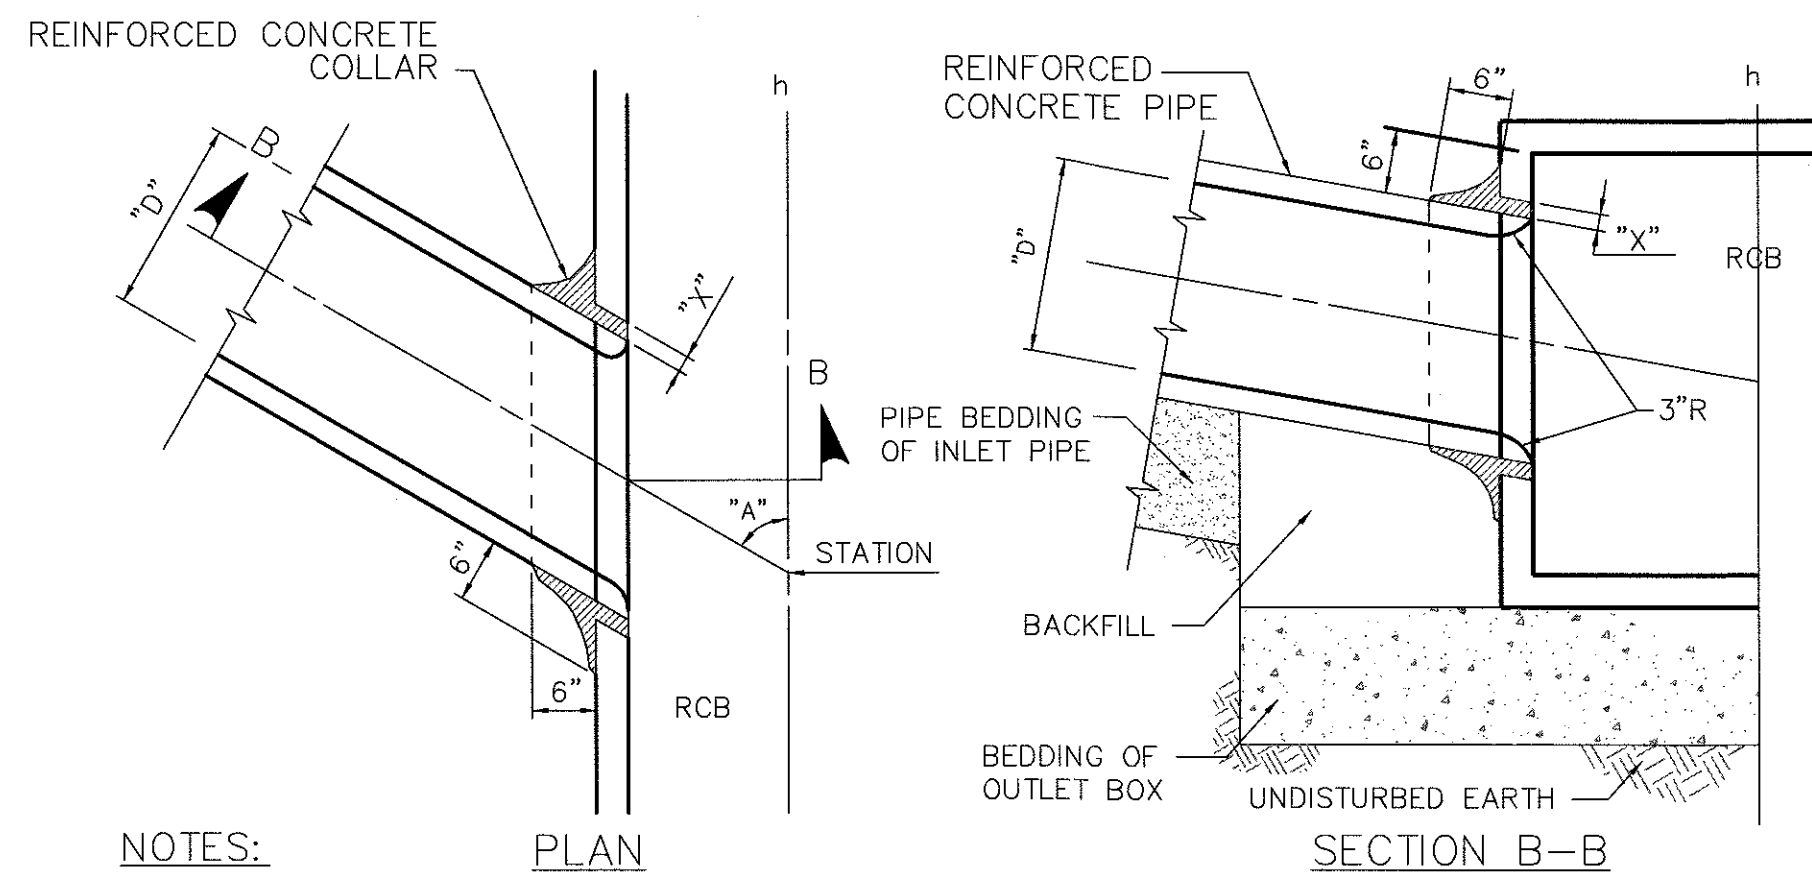


NOTES:

1. ANGLE "A" SHALL BE BETWEEN 45° AND 90°.
2. DIMENSION "D" SHALL BE EQUAL TO OR LESS THAN 1/2 THE INSIDE DIMENSION OF THE MAINLINE BOX.
3. DIMENSION "X" SHALL BE 1" MINIMUM AND 3" MAXIMUM.
4. SAWCUT END OF INLET PIPE FLUSH WITH INNER SURFACE OF MAINLINE. ROUND EDGES OF MAINLINE AND INLET PIPE.

RCP TO RCB PIPE PENETRATION DETAIL (TO BE STRUCTURALLY DESIGNED)

NOT TO SCALE

4
SD-26

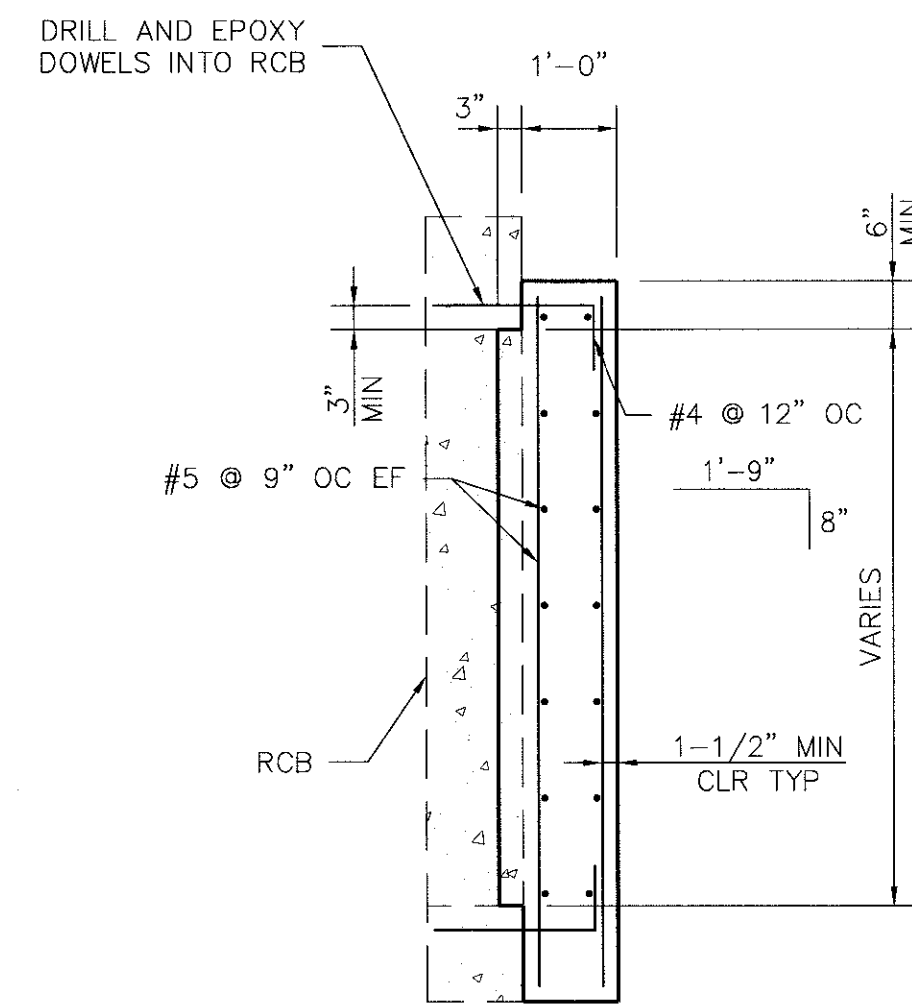


NOTES:

1. PRECAST RCB PLUG IS AN ACCEPTABLE ALTERNATIVE TO A CAST-IN-PLACE PLUG. PRECAST PLUG SHALL BE APPROVED BY ENGINEER PRIOR TO INSTALLATION.
2. EPOXY SHALL BE SIMPSON SET ANCHORING ADHESIVE PER ICC ESR-1772 OR EQUAL.

RCB PLUG

NOT TO SCALE

5
SD-26

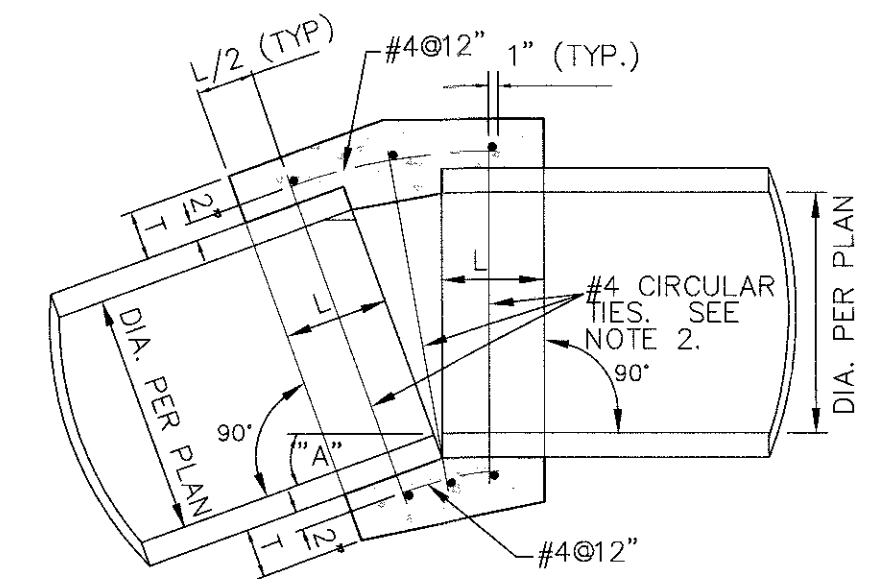

PLAN

NOTES:

1. WHERE THE SLOPE OF THE UPSTREAM PIPE IS GREATER THAN THE SLOPE OF THE DOWNSTREAM PIPE, JOIN SOFFITS. WHERE THE SLOPE OF THE UPSTREAM PIPE IS LESS THAN THE SLOPE OF THE DOWNSTREAM PIPE, JOIN INVERTS.
2. WHERE THE SPACE BETWEEN THE PIPE EXTREMITIES EXCEEDS 2 1/2 INCHES, THE NUMBER OF CIRCULAR TIES SHALL BE INCREASED TO MAINTAIN A MAXIMUM SPACING OF 6 INCHES CENTER TO CENTER. CIRCULAR TIES SHALL HAVE A DIAMETER 5 INCHES GREATER THAN THE OUTSIDE DIAMETER OF THE LARGER PIPE.

CIRCULAR TIES

PIPE DIAMETER	SPACE BETWEEN PIPE EXTREMITIES	NO. OF CIRCULAR TIES	L	T
18"	2 1/2"	3	12"	5"
24"	2 1/2"	3	12"	6"
30"	2 1/2"	3	12"	7"
36"	2 1/2" or less	4	18"	9"
60"	2 1/2" or less	5	21"	11"


CONCRETE COLLAR

NOT TO SCALE

2
SD-26


DIAMETER	WEIGHT	A	B	C *	L	W
18"	670	9"	2'-1"	2'-1"	4'-2"	3'
24"	1300	9 1/2"	3'-6"	2'-6"	6'	4'
30"	1850	1'	4'-5"	1'-8"	6'-1"	5'
36"	3500	1'-3"	5'-2"	2'-11"	8'-1"	6'
42"	4930	1'-9"	5'-3"	2'-11"	8'-2"	6'-2"
48"	6700	2'	6'	2'-2"	8'-2"	7'
54"	7150	2'-3"	5'-6"	2'-9"	8'-3"	6'-10"

* For Reference Only

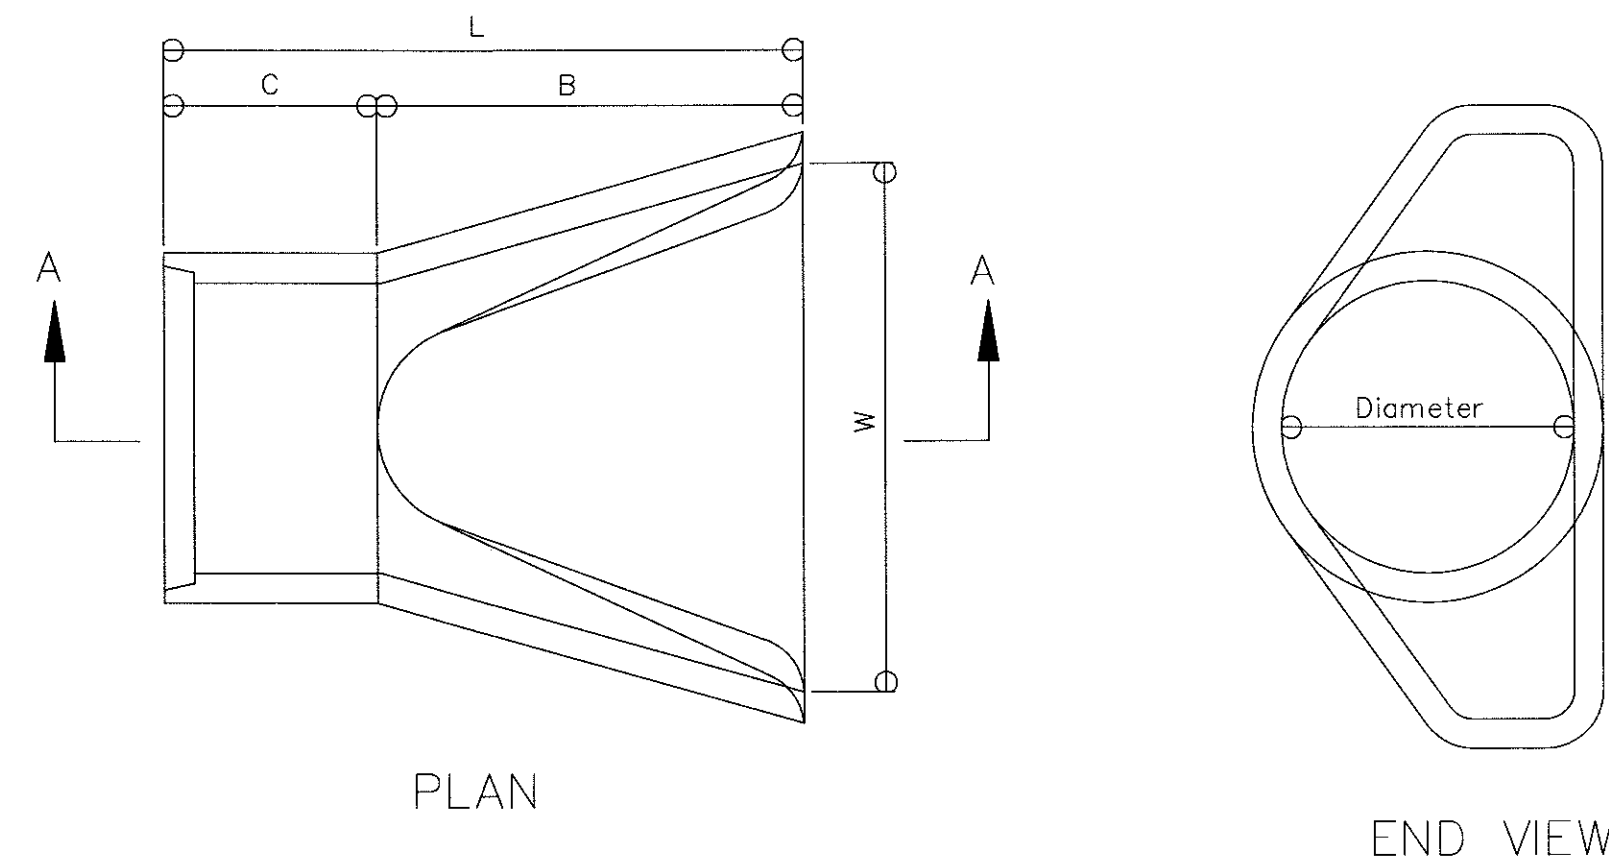


PLAN

END VIEW

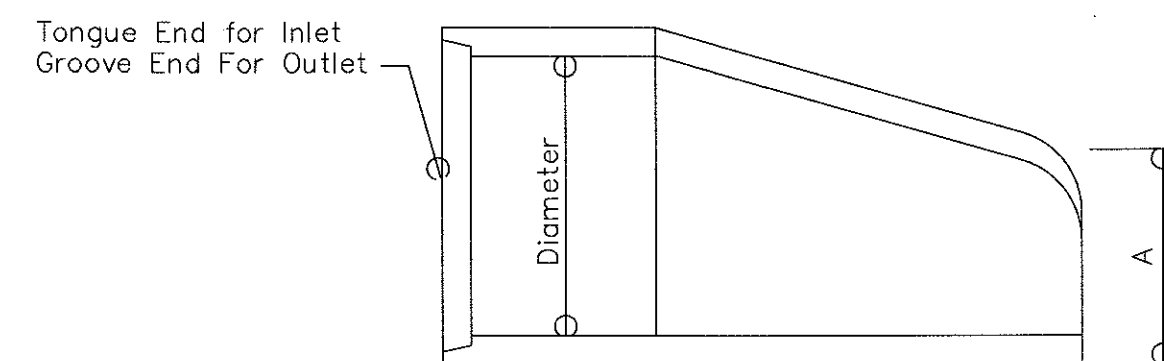

SECTION A-A

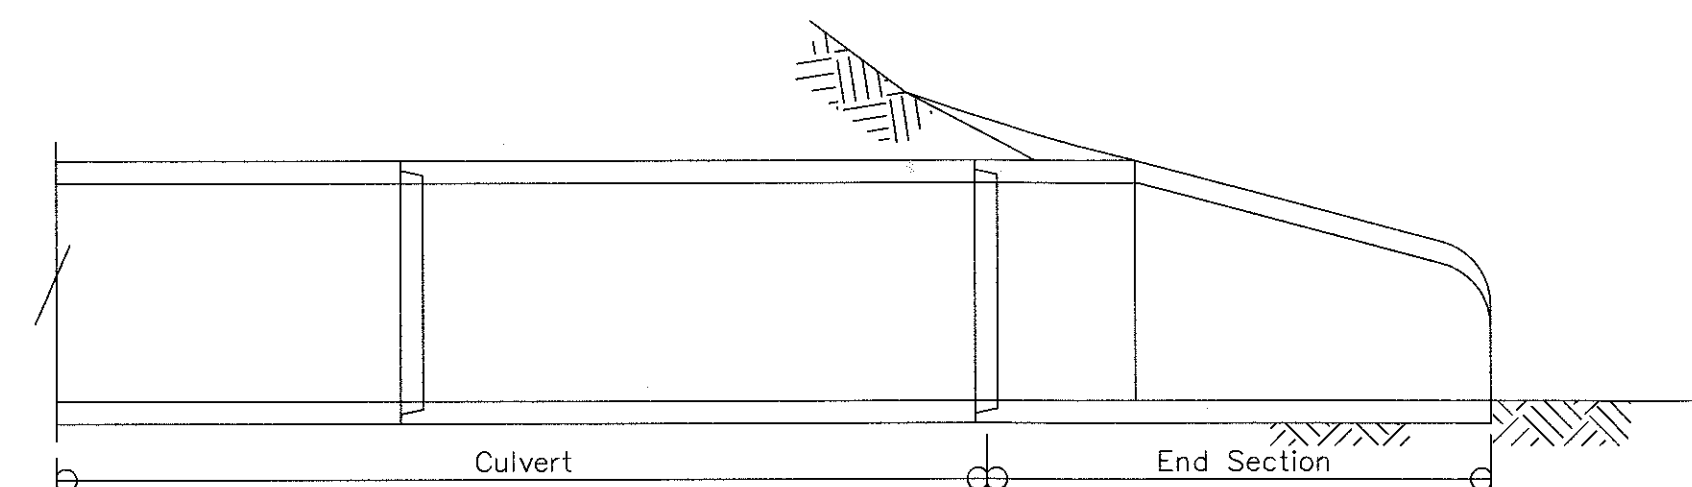

CROSS SECTION, VIEW
18" RCP TO 54" RCP


NOTES:

1. CLASS AND TYPE OF CONCRETE SHALL BE AS SPECIFIED FOR REINFORCED CONCRETE PIPE.
2. STRUCTURAL DESIGN OF END SECTION SHALL CONFORM TO THAT OF STANDARD REINFORCED CONCRETE CULVERT PIPE.
3. LENGTH OF PIPE SHOWN ON THE DESIGN PLANS DOES NOT INCLUDE CONNECTOR SECTION (LENGTH C).
4. CONTACT HYDRAULICS ENGINEER FOR SIZES NOT LISTED.
5. ACTUAL DIMENSIONS OF END SECTIONS MAY VARY BY MANUFACTURER. ADJUST PIPE LENGTHS AS NECESSARY TO ACCOMMODATE PRECAST END SECTIONS USED. SEE SHEETS R-1.1.2 AND R-2.1.4 FOR EXTENSION BEYOND FILL SLOPE AND PIPE PAY LENGTHS.

NDOT RCP END SECTION (NDOT R-2.3.1)

NOT TO SCALE

3
SD-26

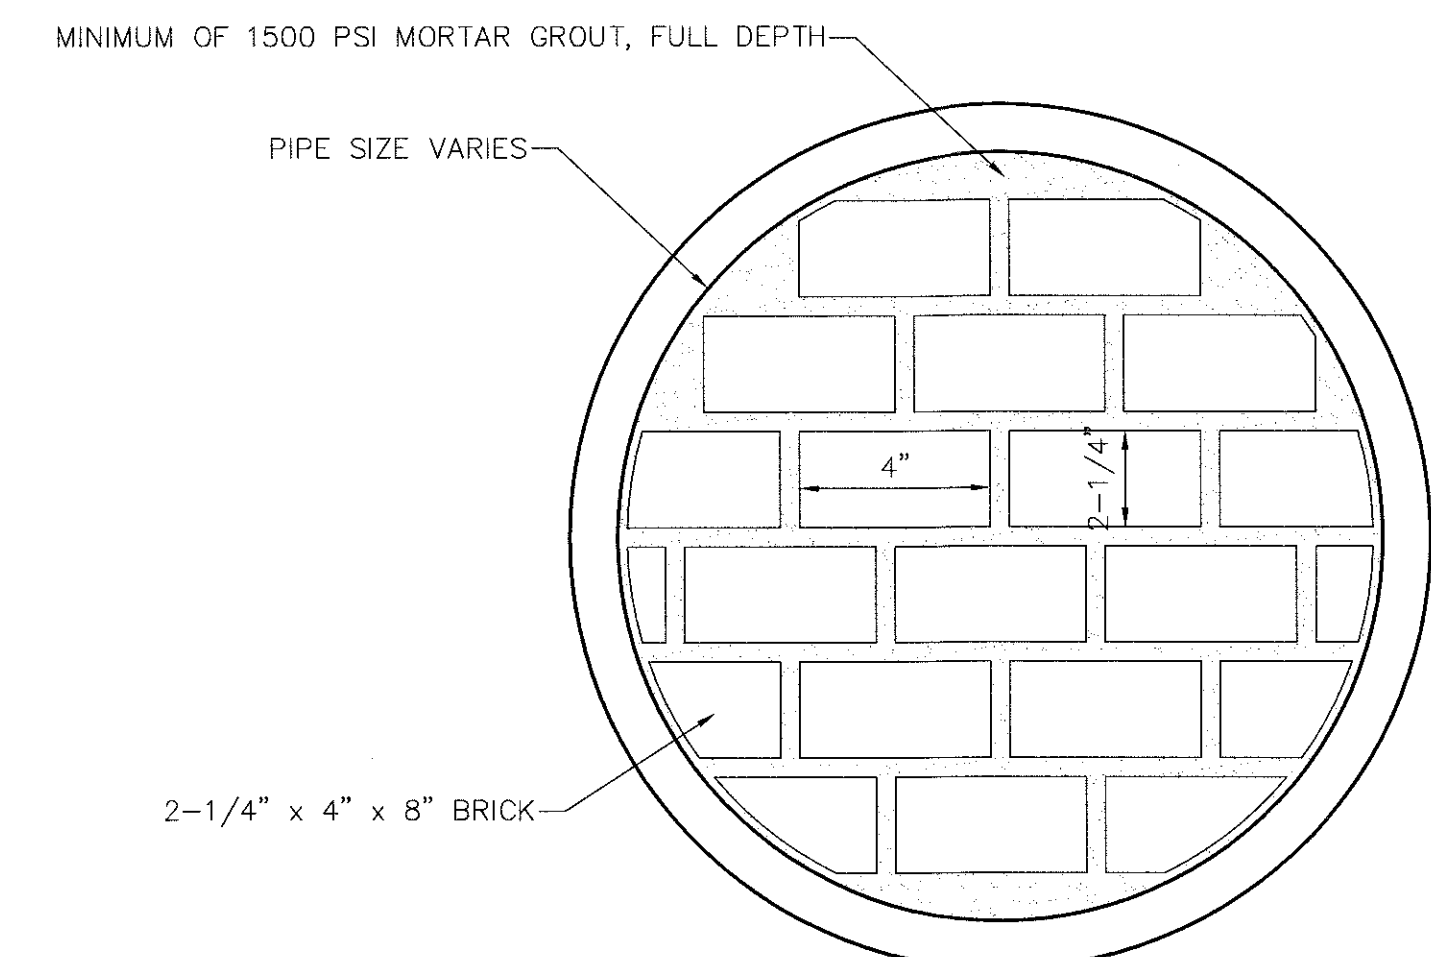

BRICK AND MORTAR PLUG

NOT TO SCALE

1
SD-26




3
SD-27



1
SD-27



2
SD-27

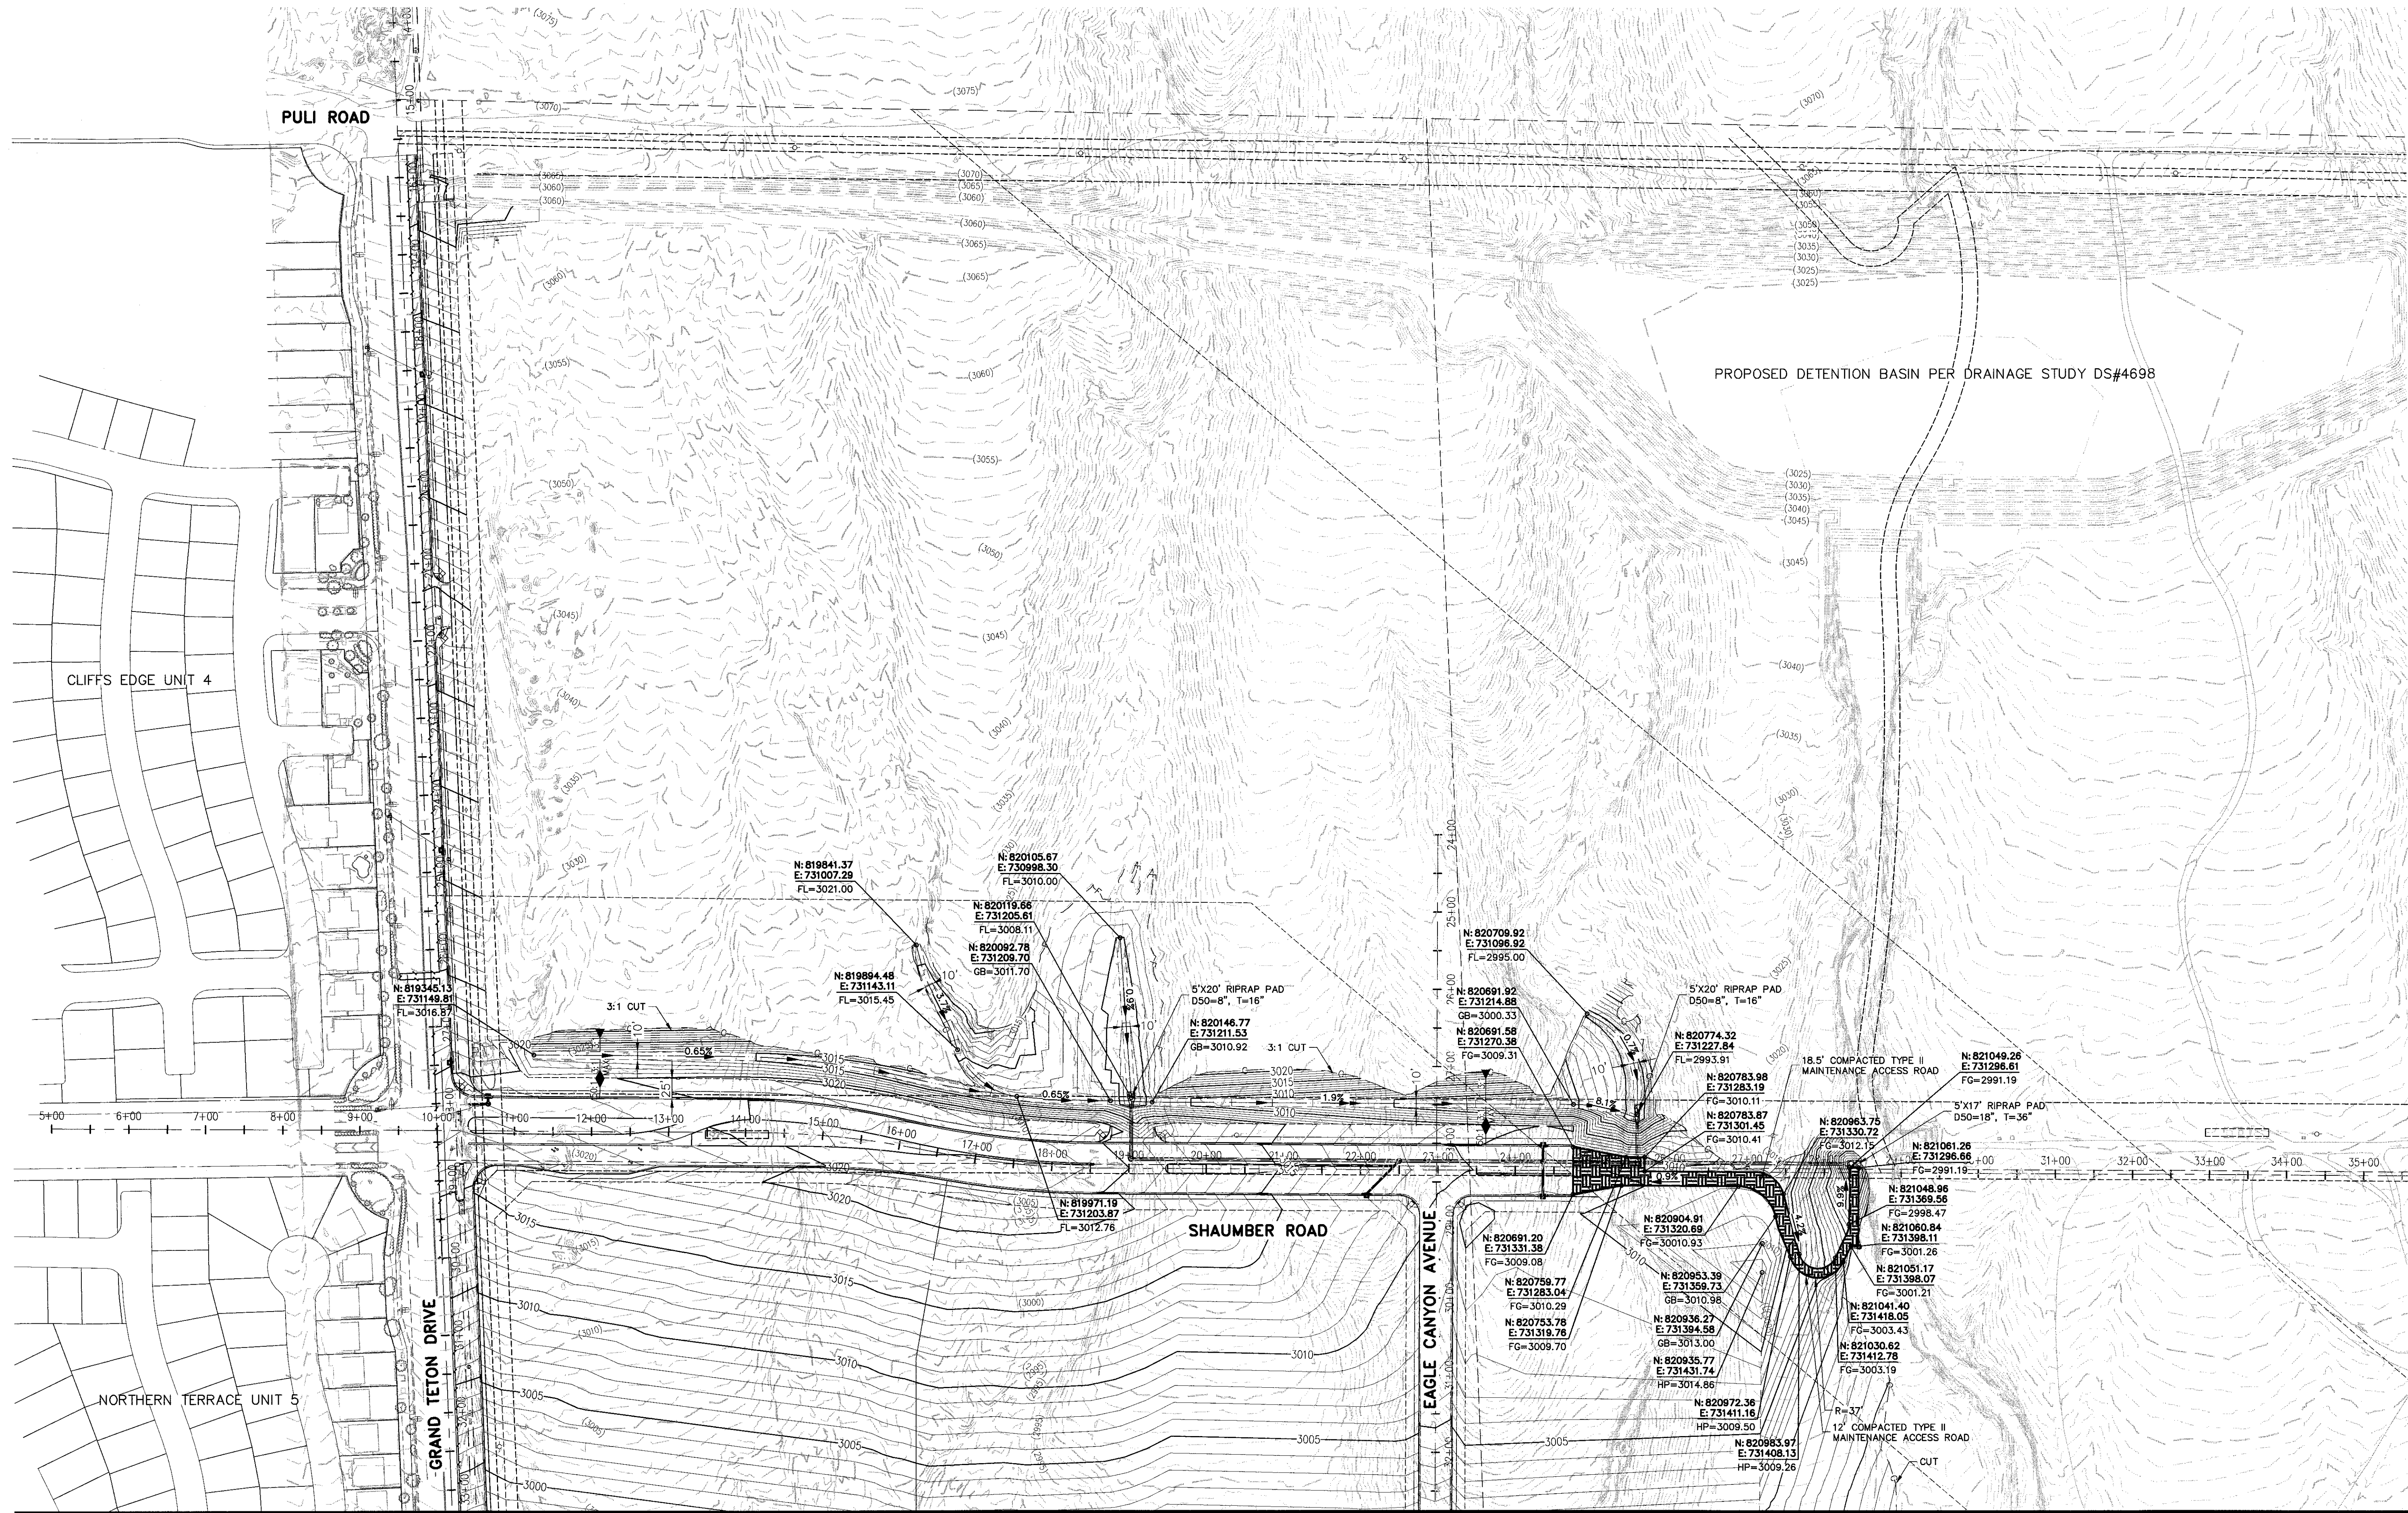

MATCHLINE SEE SHEET GR-02




NOTE:
PROPERTY OWNER IS RESPONSIBLE TO MAINTAIN THE BEST MANAGEMENT PRACTICES, SUCH AS BUT NOT LIMITED TO, THE REMOVAL OF ACCUMULATED SEDIMENT AND DEBRIS AND CARE OF VEGETATION.



NO.	DESCRIPTION	DATE	BY	APP.	DATE


NINETY-FIVE MANAGEMENT LLC
SKYE CANYON PHASE 2
GRADING PLAN 1

DATE: 11/19/15
DRAFTER: JAS
DESIGNER: DAM
CHECKED: JSR
PROJECT NO.
OLY1501-001

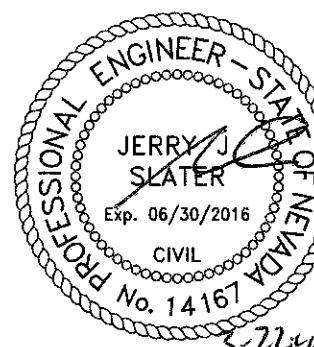

GR-01
SHEET 31 OF 33

MATCHLINE SEE SHEET GR-03

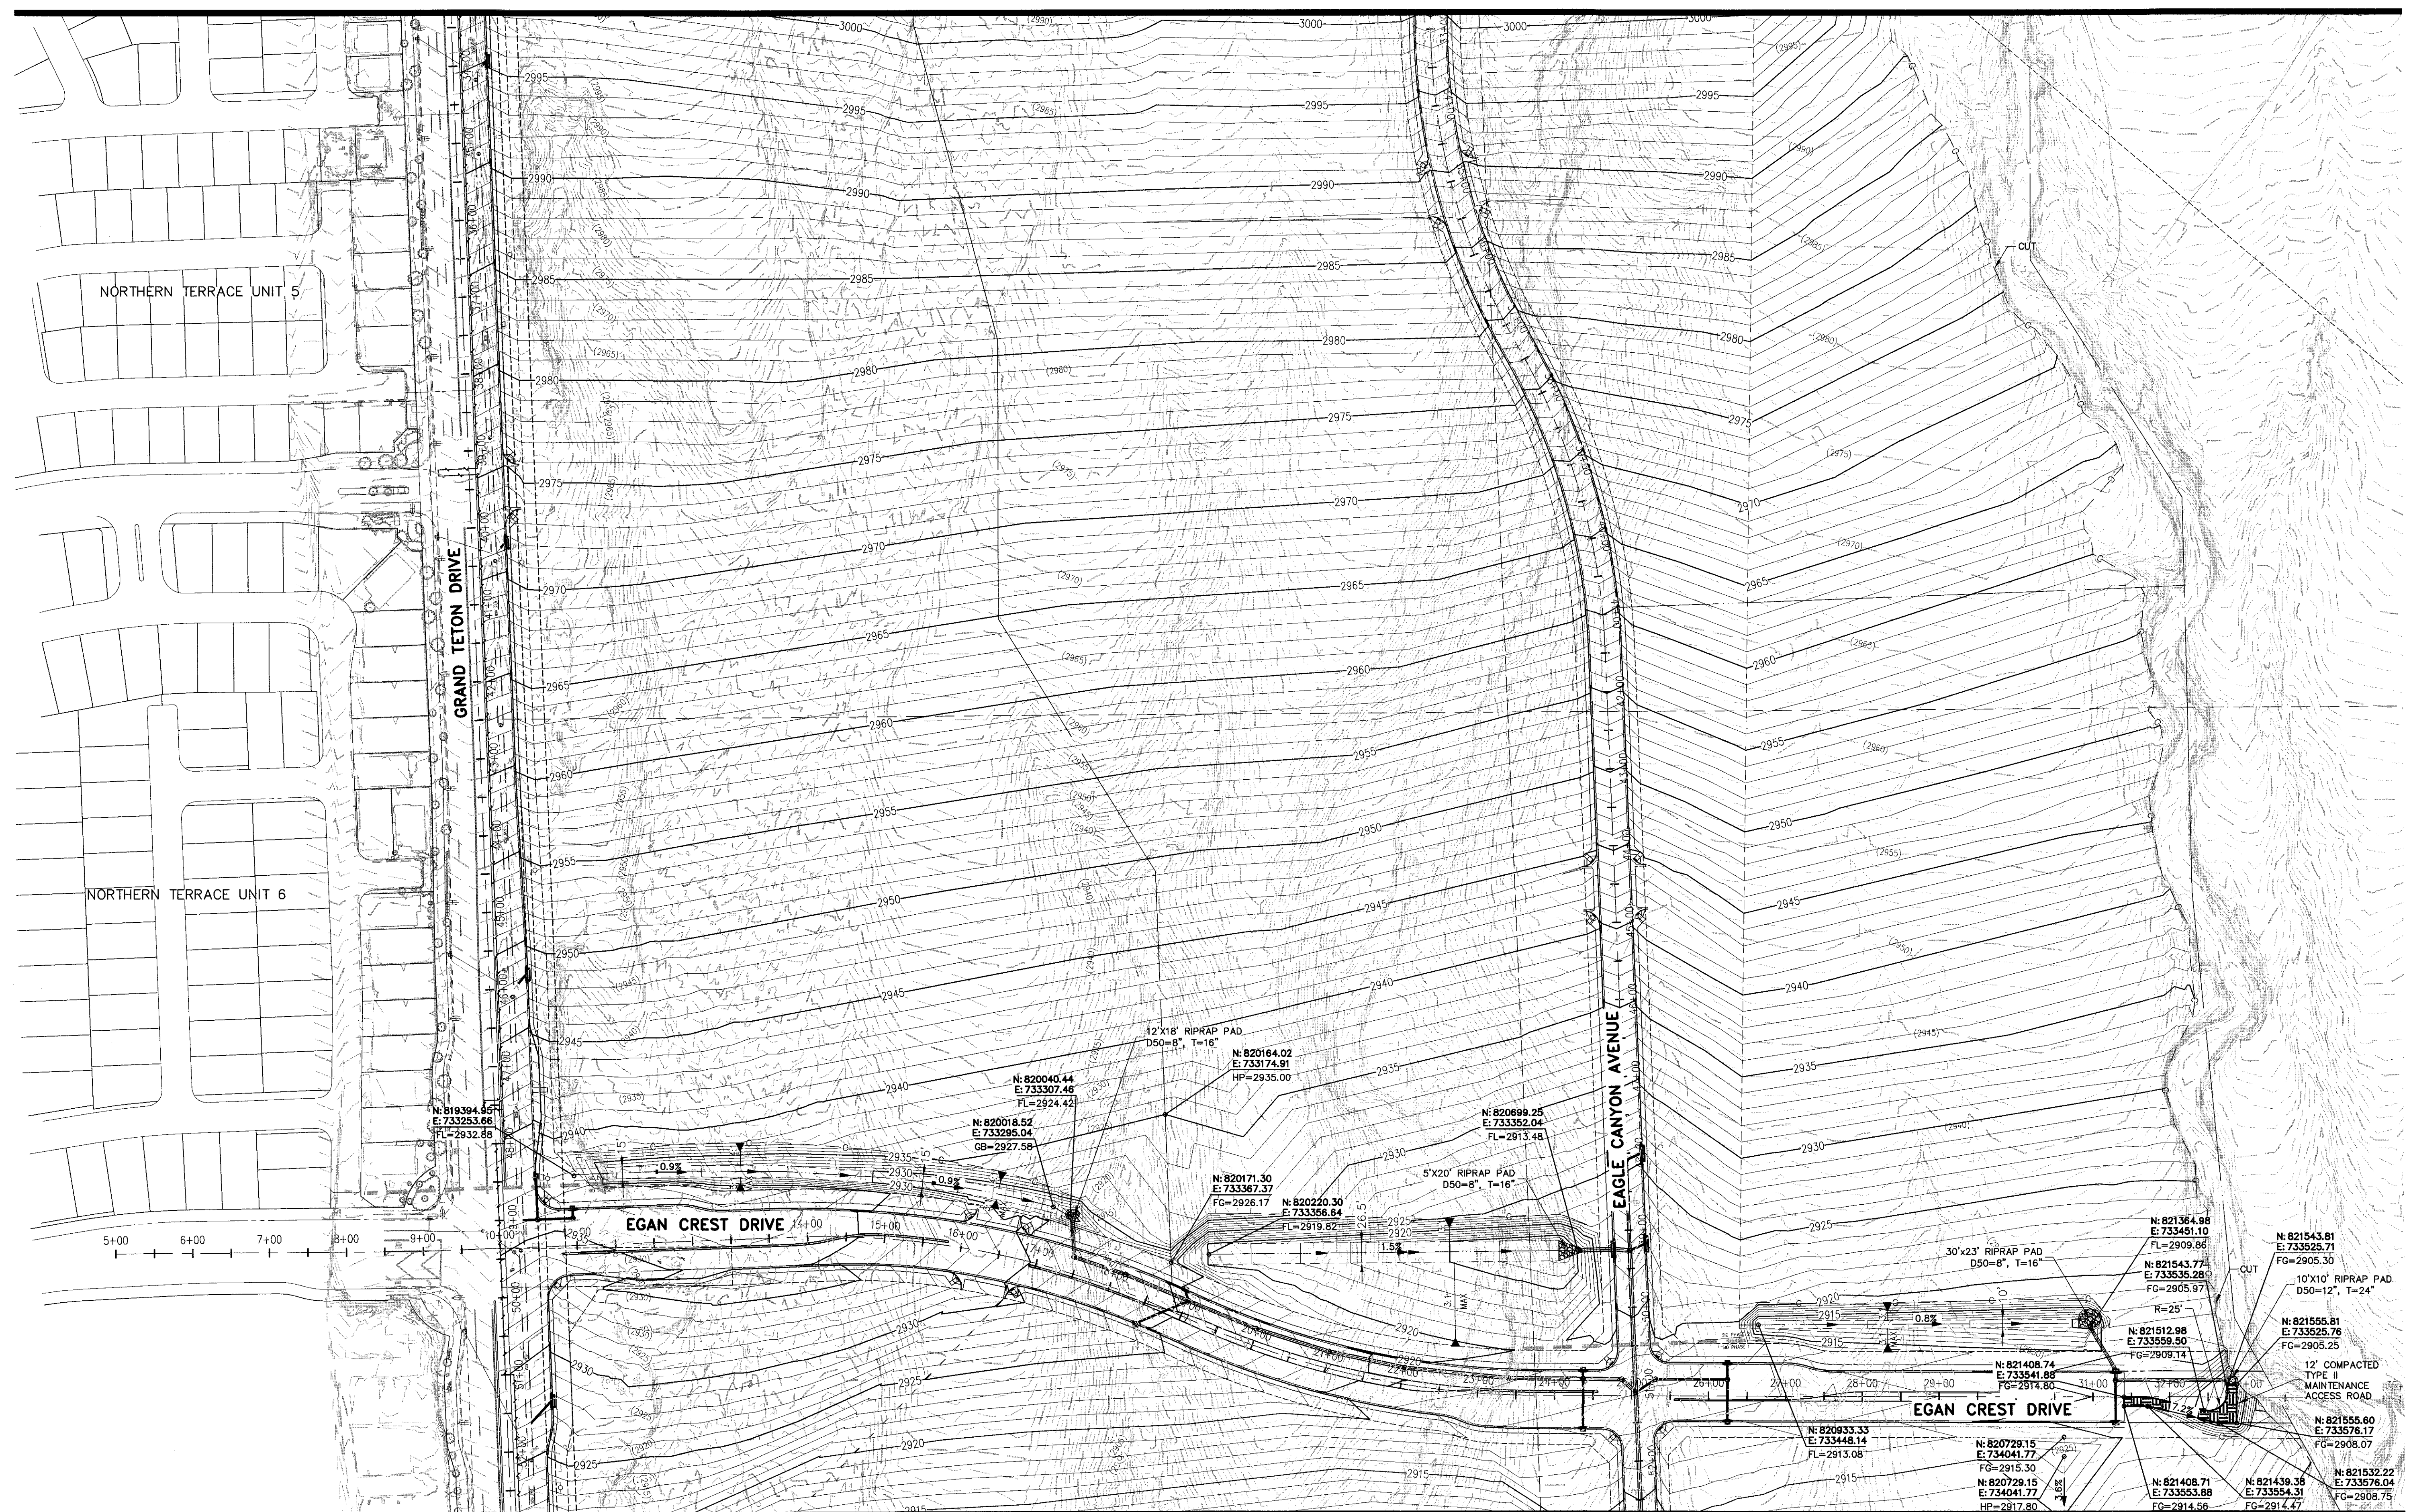

PROPERTY OWNER IS RESPONSIBLE TO MAINTAIN THE BEST MANAGEMENT PRACTICES, SUCH AS BUT NOT LIMITED TO, THE REMOVAL OF ACCUMULATED SEDIMENT AND DEBRIS AND CARE OF VEGETATION.



S-I-G
SLATER
HANIFAN
GROUP
CONSULTING ENGINEERS & PLANNERS
5740 S. ARVILLE STREET #216, LAS VEGAS, NV 89118
PHONE (702) 284-5300 FAX (702) 284-5399


[illegible]

NINETY-FIVE MANAGEMENT LLC


SKYE CANYON PHASE 2

GRADING PLAN 2


DATE: 11/19/15
DRAFTER: JAS
DESIGNER: DAM
CHECKED: JSR
PROJECT NO.
OLY1501-001

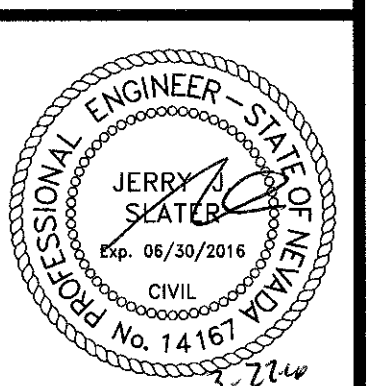

GR-02
SHEET 32 OF 33

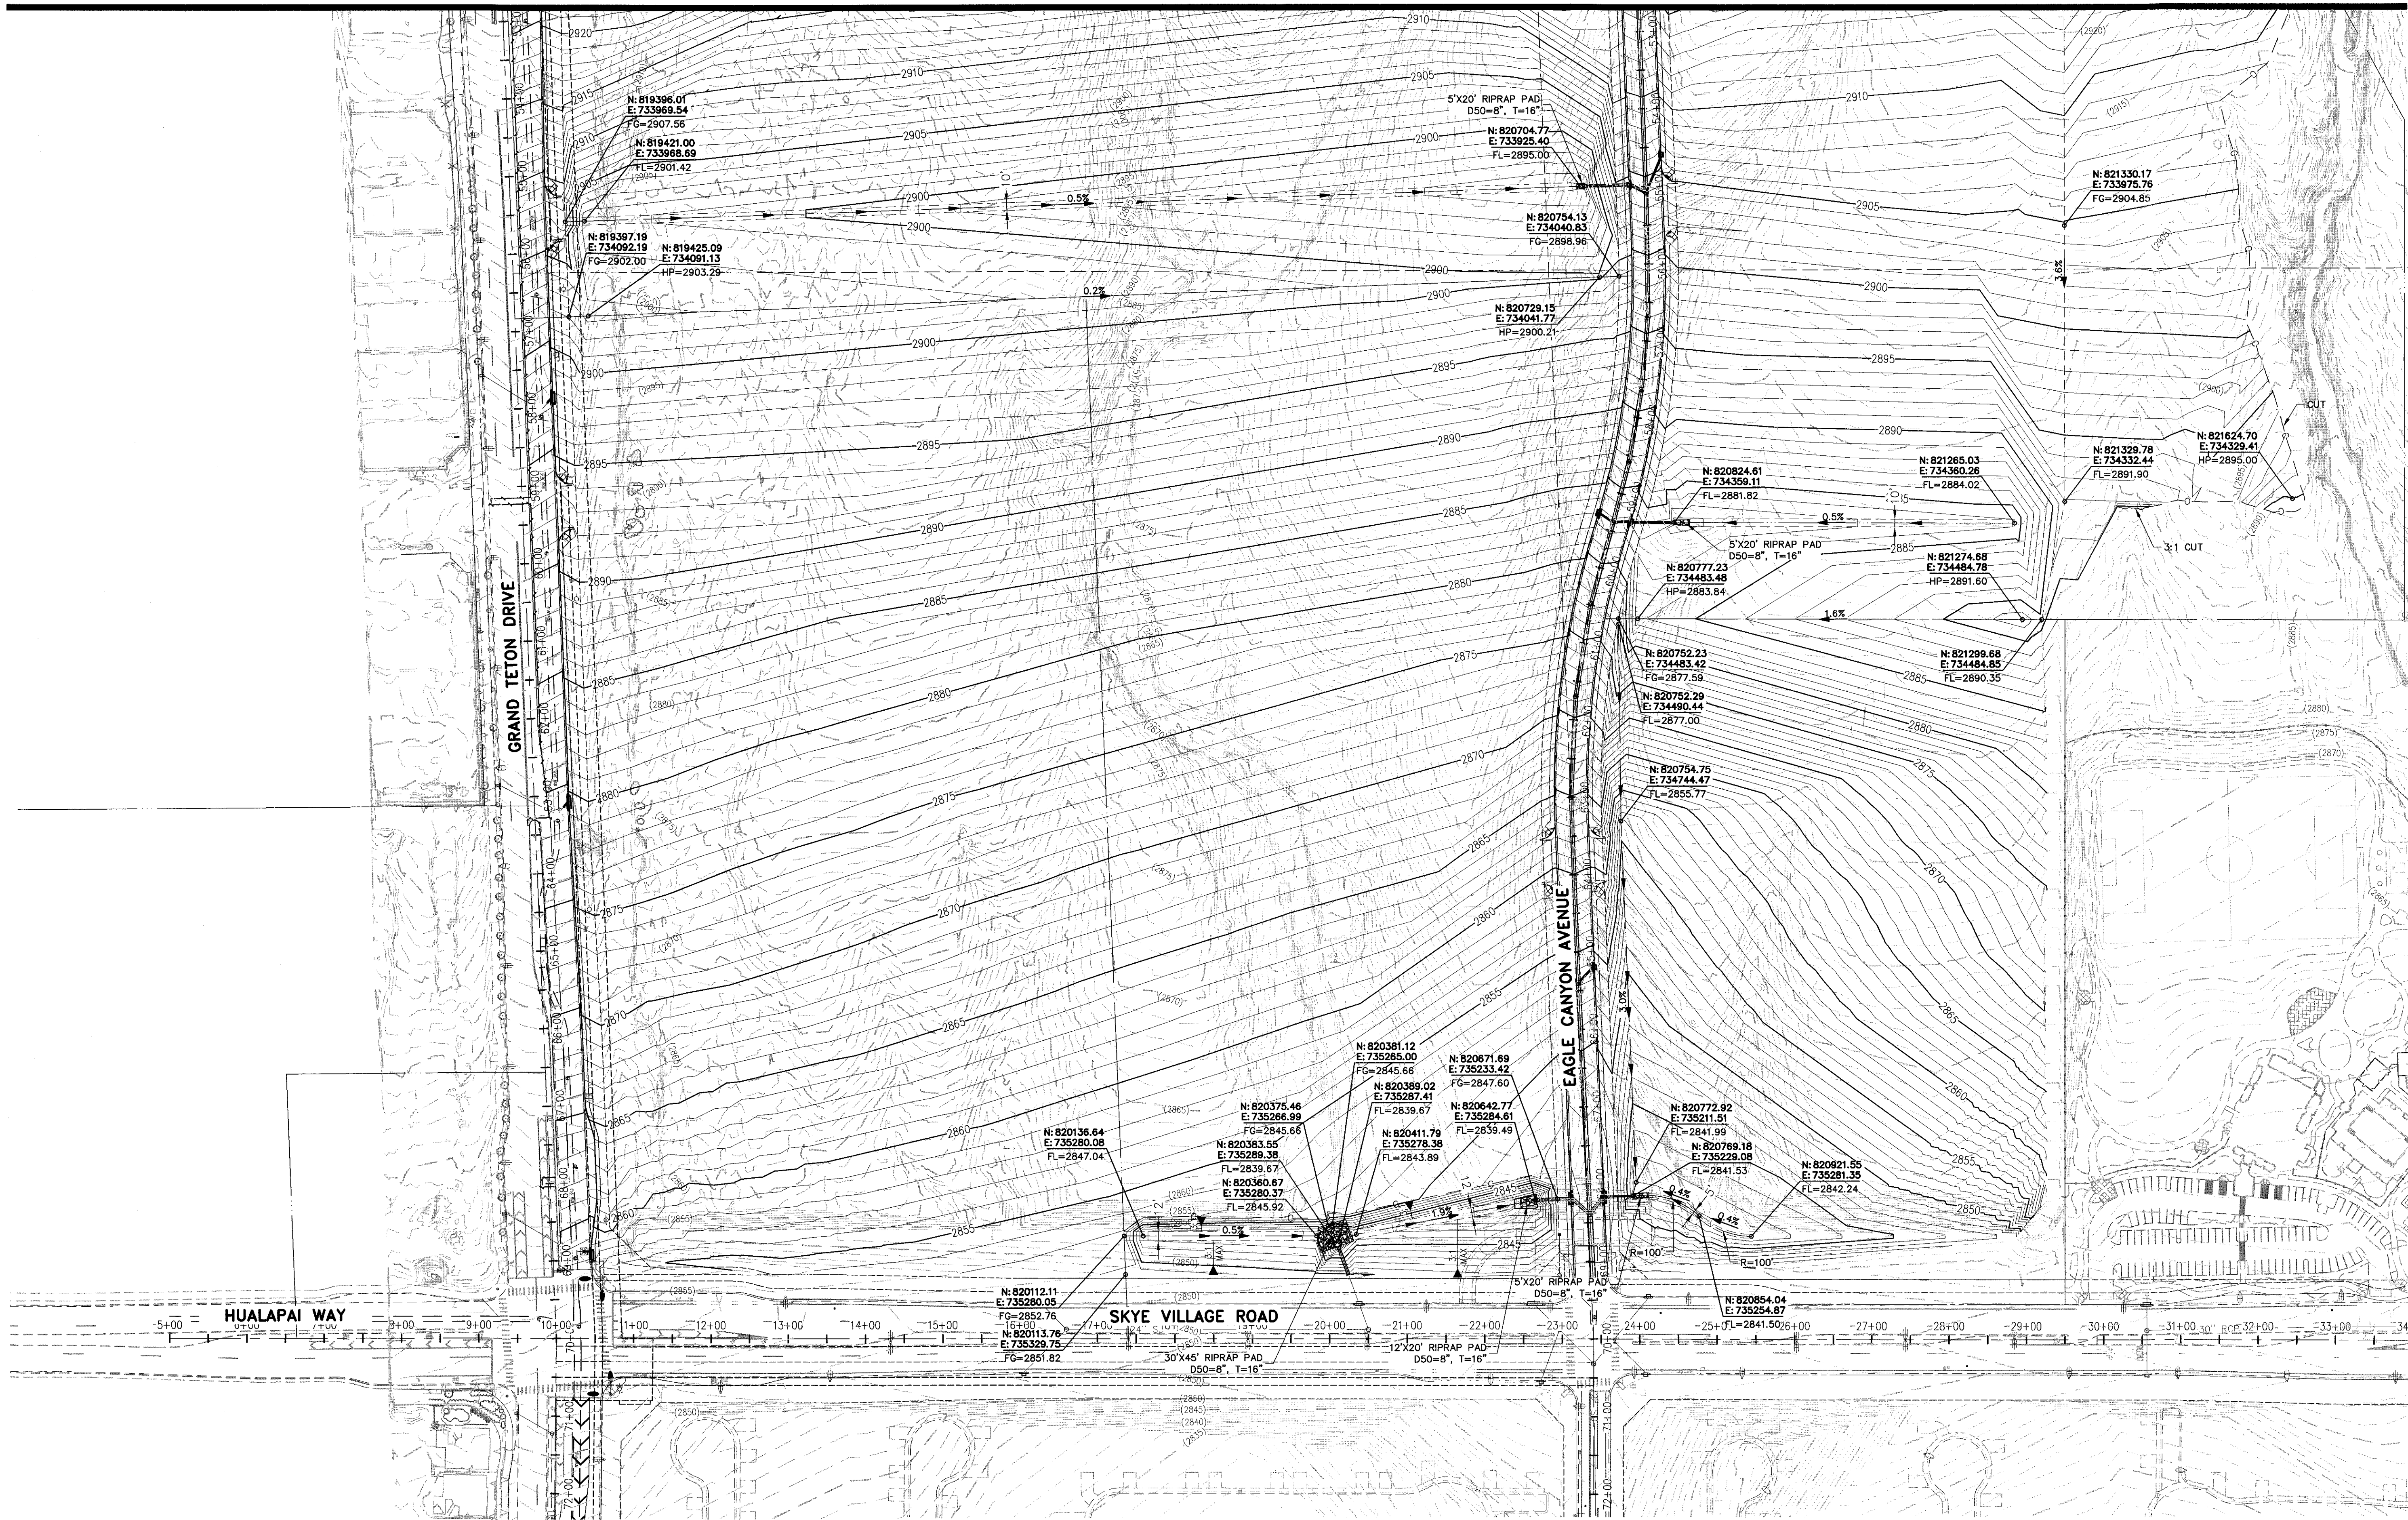

NOTE:
PROPERTY OWNER IS RESPONSIBLE TO MAINTAIN THE BEST MANAGEMENT PRACTICES, SUCH AS BUT NOT LIMITED TO, THE REMOVAL OF ACCUMULATED SEDIMENT AND DEBRIS AND CARE OF VEGETATION.

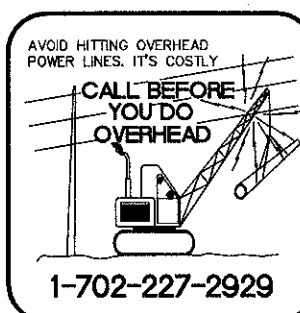

NO.	DESCRIPTION	DATE	BY	APP.

NINETY-FIVE MANAGEMENT LLC
SKYE CANYON PHASE 2
GRADING PLAN 3

DATE: 11/19/15
DRAFTER: JAS
DESIGNER: DAM
CHECKED: JSR
PROJECT NO.
OLY1501-001

