
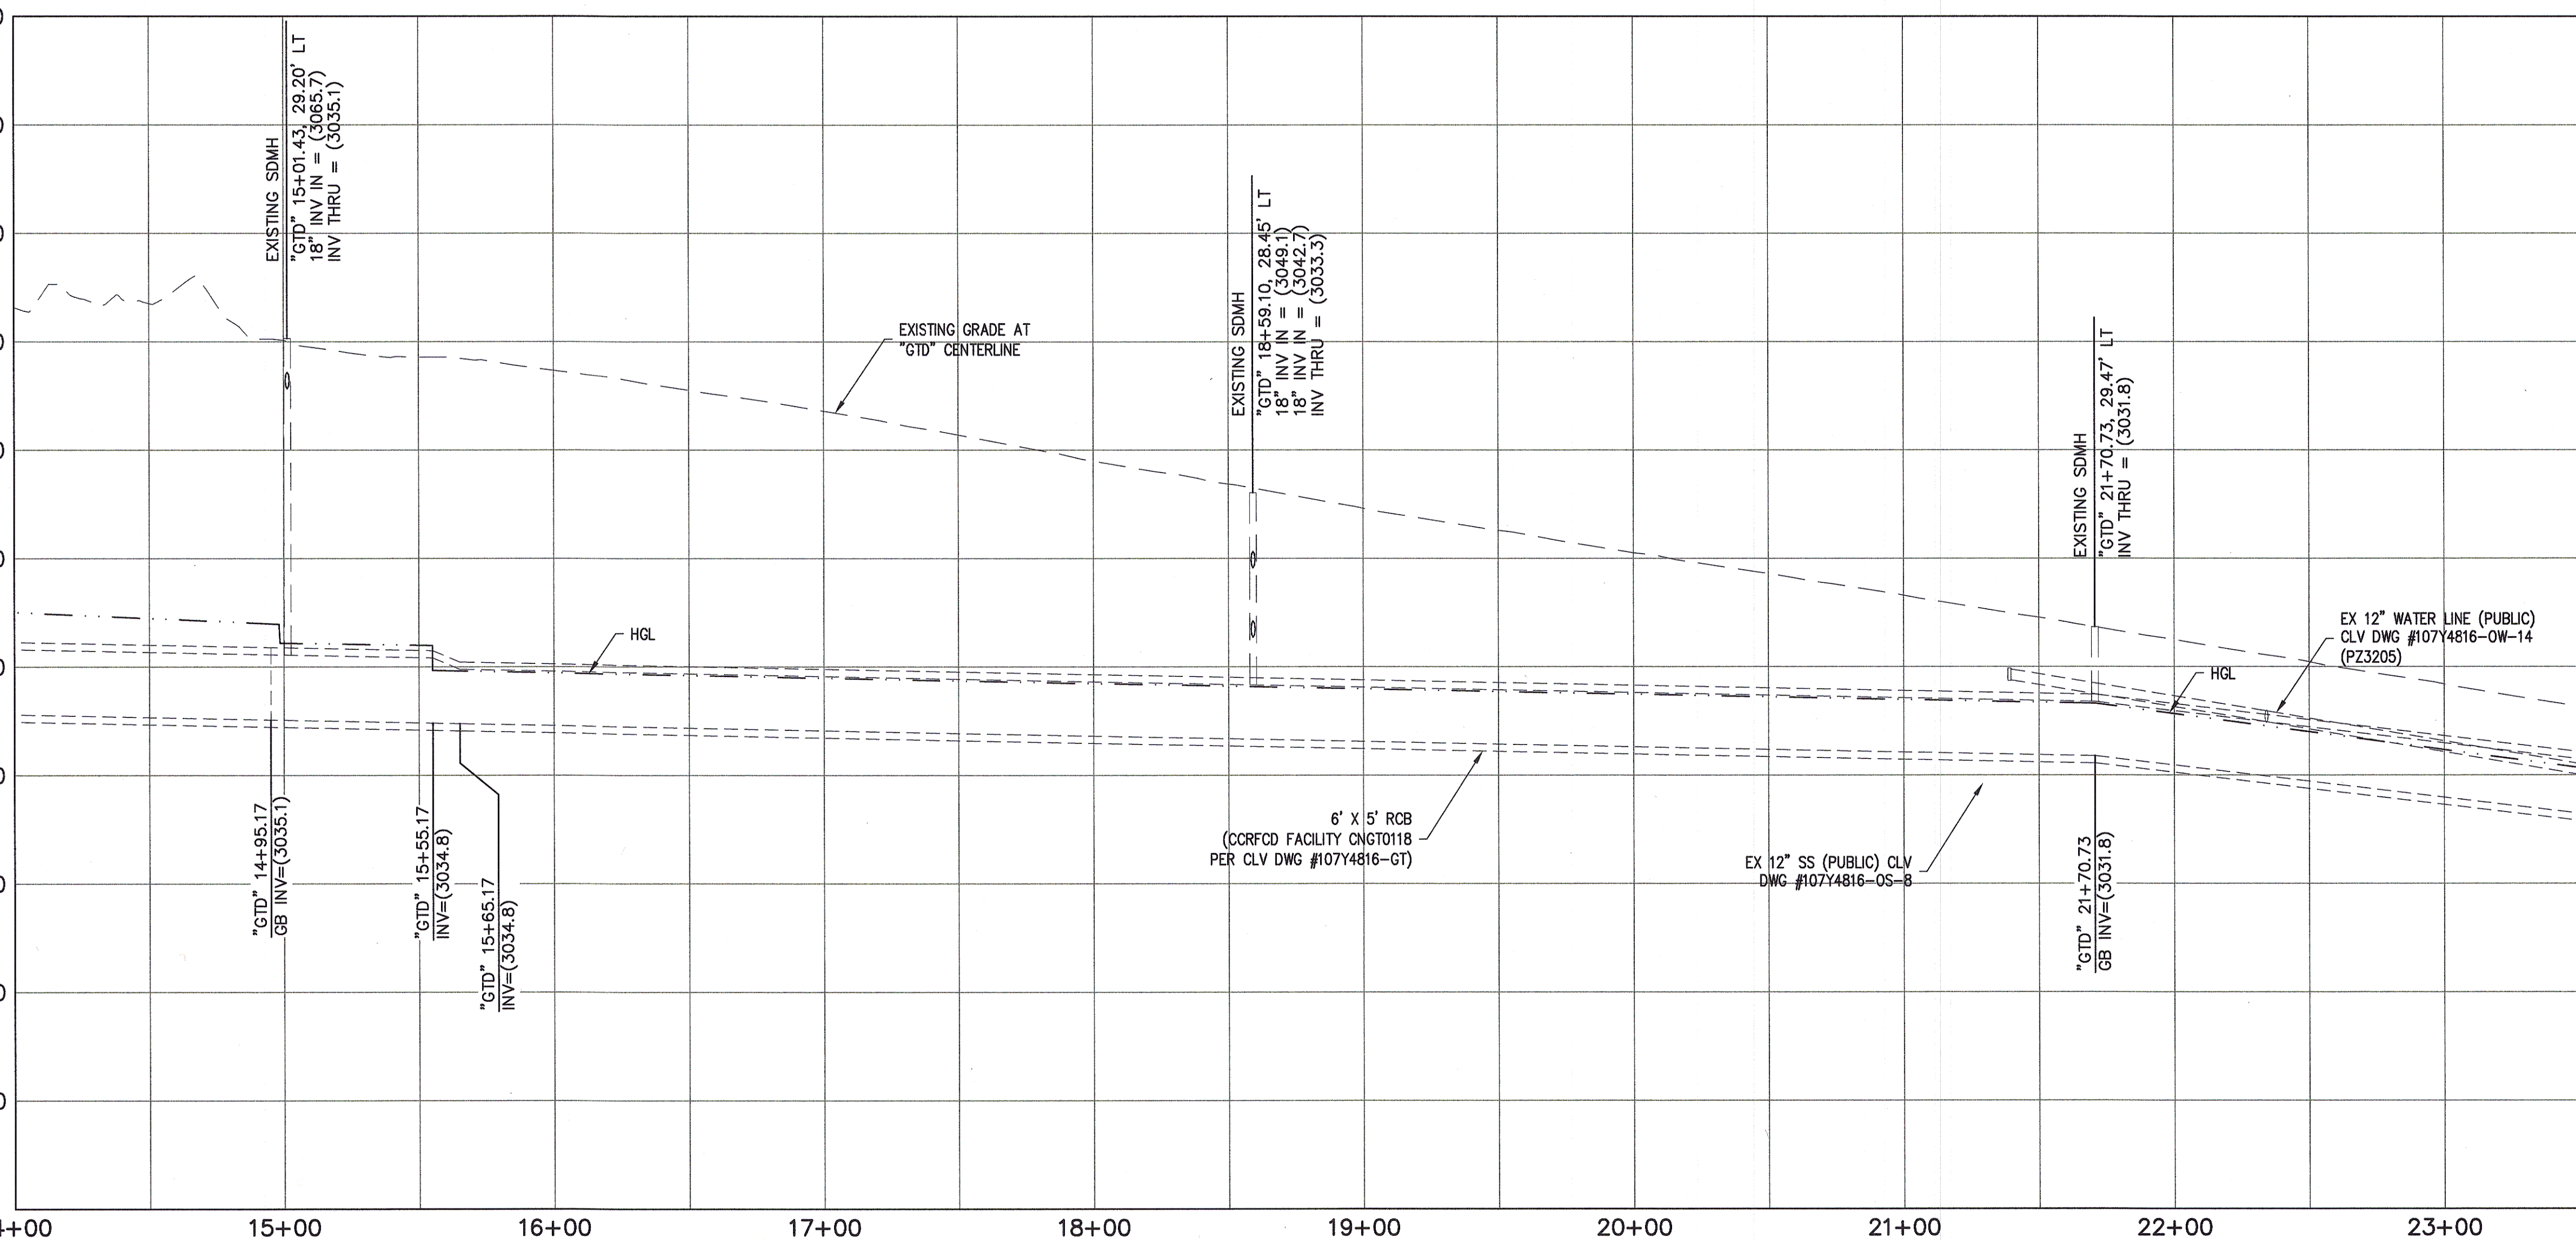


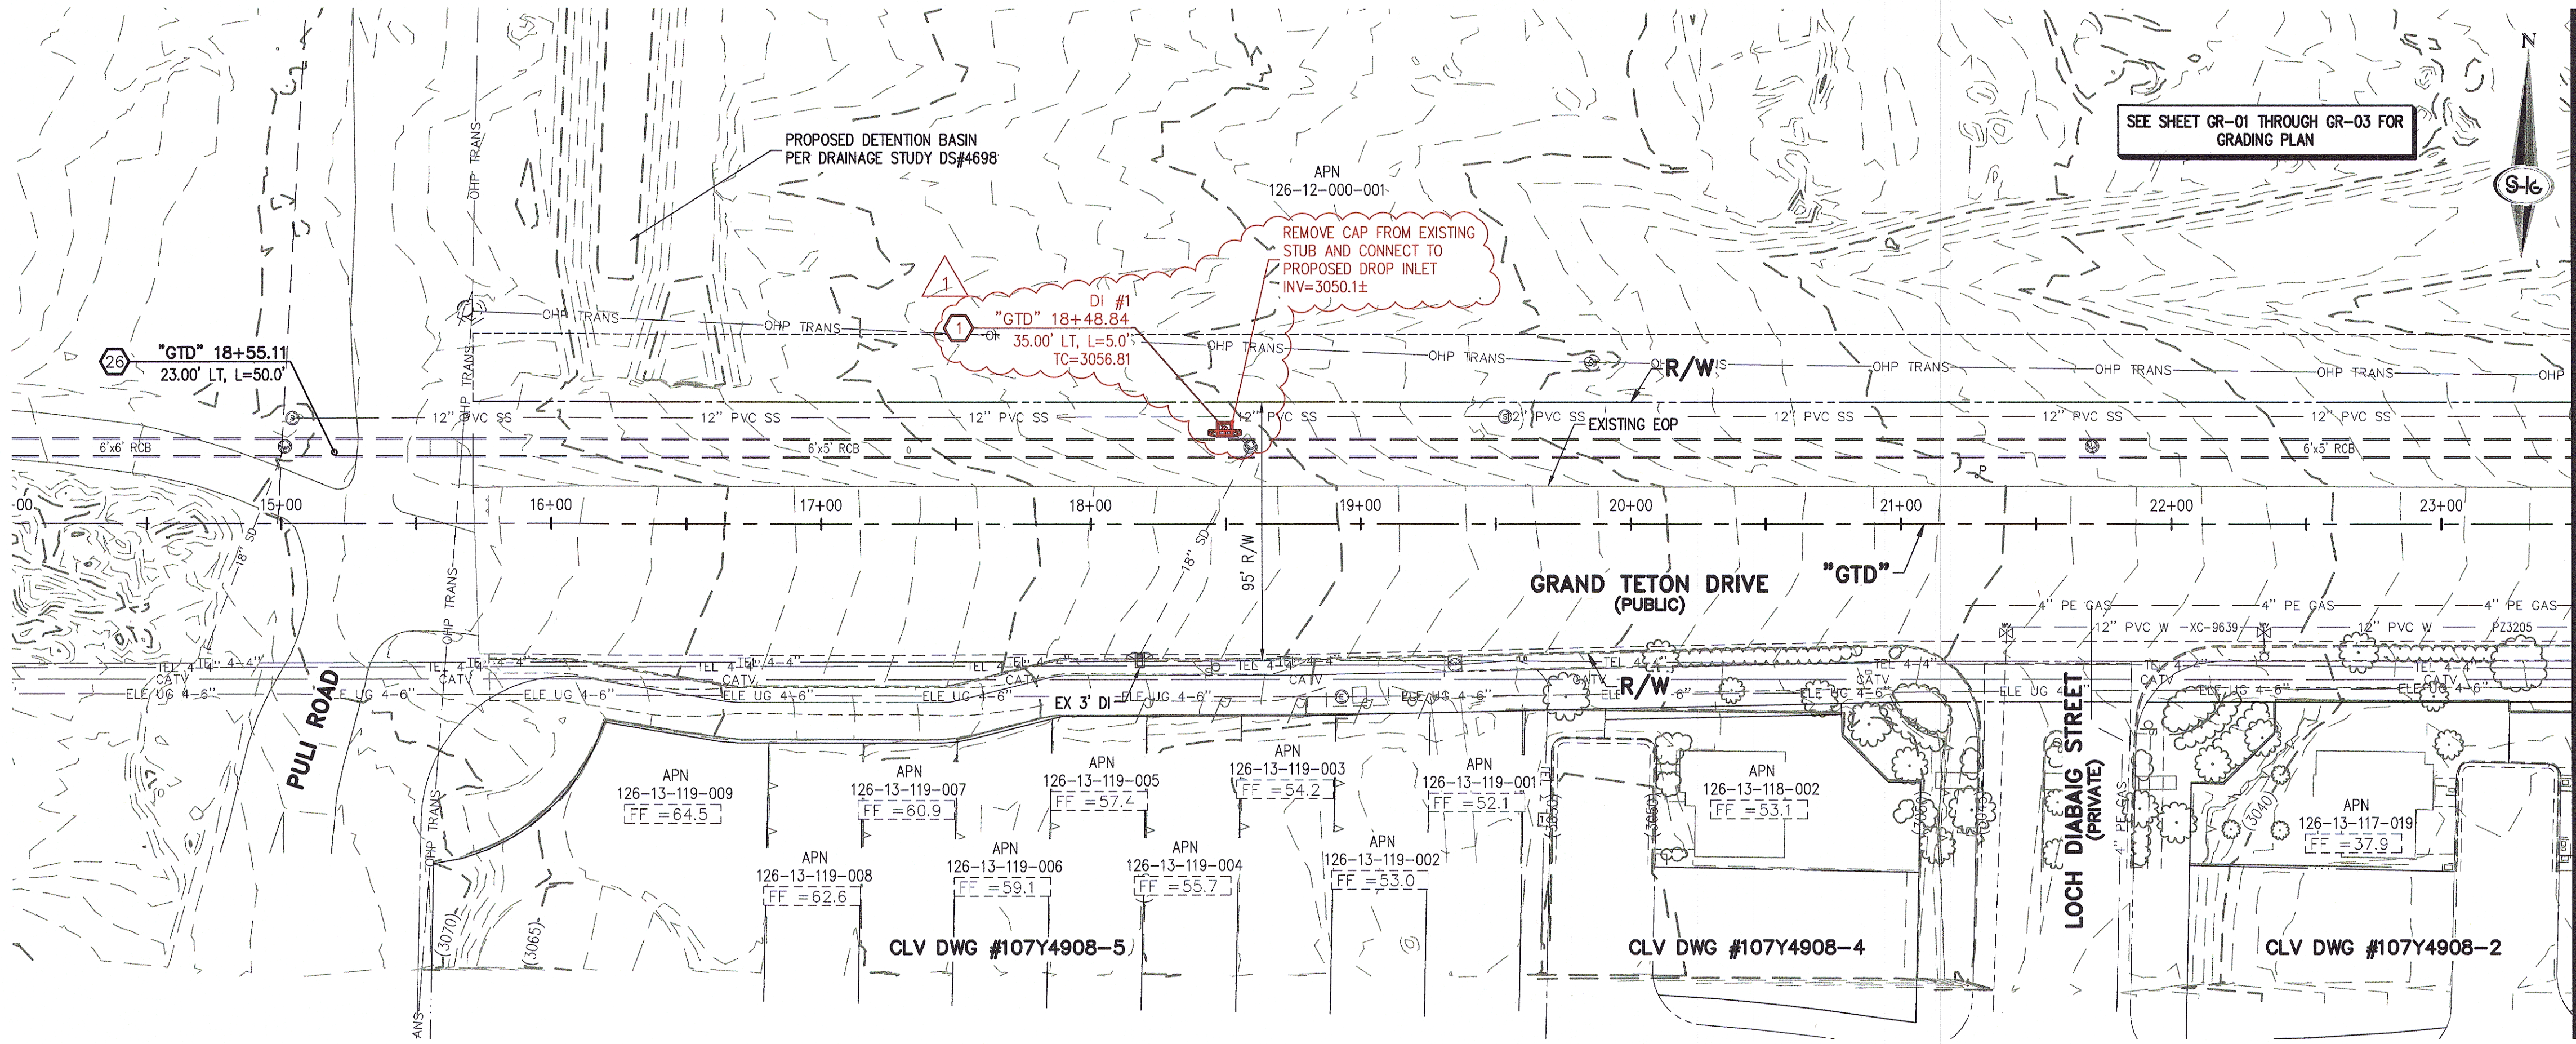

- ### STORM DRAIN NOTES
- CONSTRUCT TYPE "CM2" DROP INLET (USDCCA STD. DWG. NO. 412.1)
 - REMOVE EXISTING LATERAL STUB AND CONSTRUCT RCB PLUG (SEE DETAIL 5, DRAWING SD-25)
 - CONSTRUCT 60" TYPE I MANHOLE (USDCCA STD. DWG. NO. 403.1)
 - CONSTRUCT 60" TYPE III MANHOLE (USDCCA STD. DWG. NO. 406.1)
 - CONSTRUCT 60" TYPE III MANHOLE WITH TYPE IA RISER (USDCCA STD. DWG. NO. 404.1 AND 406.1)
 - CONSTRUCT NDOT TYPE 4 MANHOLE (NDOT STD. PLAN R-4.3.2)
 - INSTALL 18" RCP OR WATER QUALITY C905 AS SHOWN ON PROFILES (USDCCA STD. DWG. NO. 503.2)
 - INSTALL 24" RCP OR WATER QUALITY C905 AS SHOWN ON PROFILES (USDCCA STD. DWG. NO. 503.2)
 - INSTALL 30" RCP (USDCCA STD. DWG. NO. 503.2)
 - INSTALL 36" RCP (USDCCA STD. DWG. NO. 503.2)
 - INSTALL 42" RCP (USDCCA STD. DWG. NO. 503.2)
 - INSTALL 54" RCP (USDCCA STD. DWG. NO. 503.2)
 - INSTALL 60" RCP (USDCCA STD. DWG. NO. 503.2)
 - INSTALL 18" RCP END SECTION (NDOT STD. PLAN R-2.3.1)
 - INSTALL 24" RCP END SECTION (NDOT STD. PLAN R-2.3.1)
 - INSTALL 30" RCP END SECTION (NDOT STD. PLAN R-2.3.1)
 - INSTALL 36" RCP END SECTION (NDOT STD. PLAN R-2.3.1)
 - INSTALL 42" RCP END SECTION (NDOT STD. PLAN R-2.3.1)
 - PIPE PENETRATION (SEE DETAIL 4, DRAWING SD-25)
 - CONSTRUCT CONCRETE COLLAR (SEE DETAIL 2, DRAWING SD-25)
 - CONSTRUCT BRICK AND MORTAR PLUG (SEE DETAIL 1, DRAWING SD-25)
 - INSTALL 48" RCP (USDCCA STD. DWG. NO. 503.2)
 - INSTALL 48" RCP END SECTION (NDOT STD. PLAN R-2.3.1)
 - INSTALL DRIVEWAY (USDCCA STD. DWG. NO. 224)
 - CONSTRUCT TYPE "CM" DROP INLET (USDCCA STD. DWG. NO. 422)

- ### NOTES
- ALL RCP SHALL BE CLASS III UNLESS OTHERWISE SHOWN.
 - ALL PIPE LENGTHS ARE MEASURED ALONG PIPE CENTERLINE TO CENTER OF MANHOLE OR INSIDE EDGE OF DI OR RCB/RCA.
 - ALL DROP INLETS SHALL INCLUDE STORM WATER MANAGEMENT STAMP AND DETAIL PER USDCCA STD. DWG. NO. 421.
 - SEE STRUCTURAL PLANS FOR ADDITIONAL STRUCTURAL DETAILS AND CONNECTIONS.
 - ALL PIPES ARE PUBLICLY MAINTAINED.
 - ADD SPECIAL INSPECTION REQUIRED FOR PIPE SEGMENTS WITH SACRIFICIAL CONCRETE.

APPROVED FOR CONSTRUCTION
LVVWD WILL HAVE TO BE PRESENT AND VIEW INSTALLATION OF STORM DRAIN THAT WILL BE INSTALLED THAT MAY AFFECT THE WATER MAINS

LVVWD ENGINEERING SERVICES MANAGER DATE
PROJECT NO. 124568

DROP INLET NOTE
WHERE 10 FEET PARALLEL SEPARATION IS NOT PRACTICABLE:
CAST-IN-PLACE MONOLITHIC POUR WITH WATERSTOP BETWEEN SLAB AND WALLS. BASE, WALLS AND TOP TO BE CONSTRUCTED WITH WATERSTOPS, CENTER BULB, OR FLAT STRIP (VINYLEX, GREENSTREAK PLASTIC PRODUCTS OR APPROVED EQUAL).


LEGEND
1 STORM DRAIN LATERAL # (SEE SHEETS SD-20 THRU SD-24)

I CERTIFY THAT THIS GRADING PLAN IS IN CONFORMANCE WITH THE APPROVED TECHNICAL DRAINAGE STUDY DS-4738A ON FILE AT THE CITY OF LAS VEGAS FOR THE SUBJECT PROJECT

JERRY SLATER, P.E. 14167 DATE

FLOOD ZONE
THE PROJECT SITE IS LOCATED WITHIN A FEMA DESIGNATED ZONE "X" (OUTSIDE THE 500-YEAR FLOOD PLAIN) ON THE FLOOD INSURANCE RATE MAP (FIRM) PANEL:32003C1750E, DATED SEPTEMBER 27, 2002

NOTE:
PROPERTY OWNER IS RESPONSIBLE TO MAINTAIN THE BEST MANAGEMENT PRACTICES, SUCH AS BUT NOT LIMITED TO, THE REMOVAL OF ACCUMULATED SEDIMENT AND DEBRIS AND CARE OF VEGETATION.

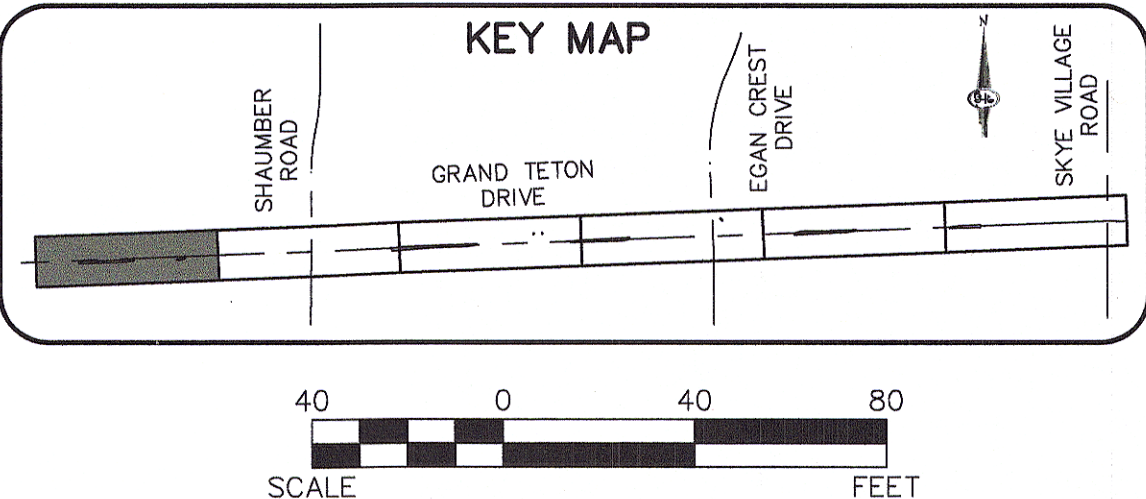

FAST
Call before you Dig
1-702-432-5300
SAFETY OF THE COMMUNITY



Call before you Dig
1-800-227-2800

SLATER HANIFAN GROUP
CONSULTING ENGINEERS & PLANNERS
5740 S. ARVILLE STREET #216, LAS VEGAS, NV 89118
PHONE (702) 284-5300 FAX (702) 284-5399

NINETY-FIVE MANAGEMENT LLC
SKYE CANYON II PHASE 2 MASS GRADING
GRAND TETON DRIVE STORM DRAIN PLAN AND PROFILE
"GTD" 14+00.00 TO "GTD" 23+50.00

DATE: 8/3/16
DRAFTER: JAS
DESIGNER: DAM
CHECKED: JSR
PROJECT NO. OLY1501-001

SD-01
SHEET 4 OF 32

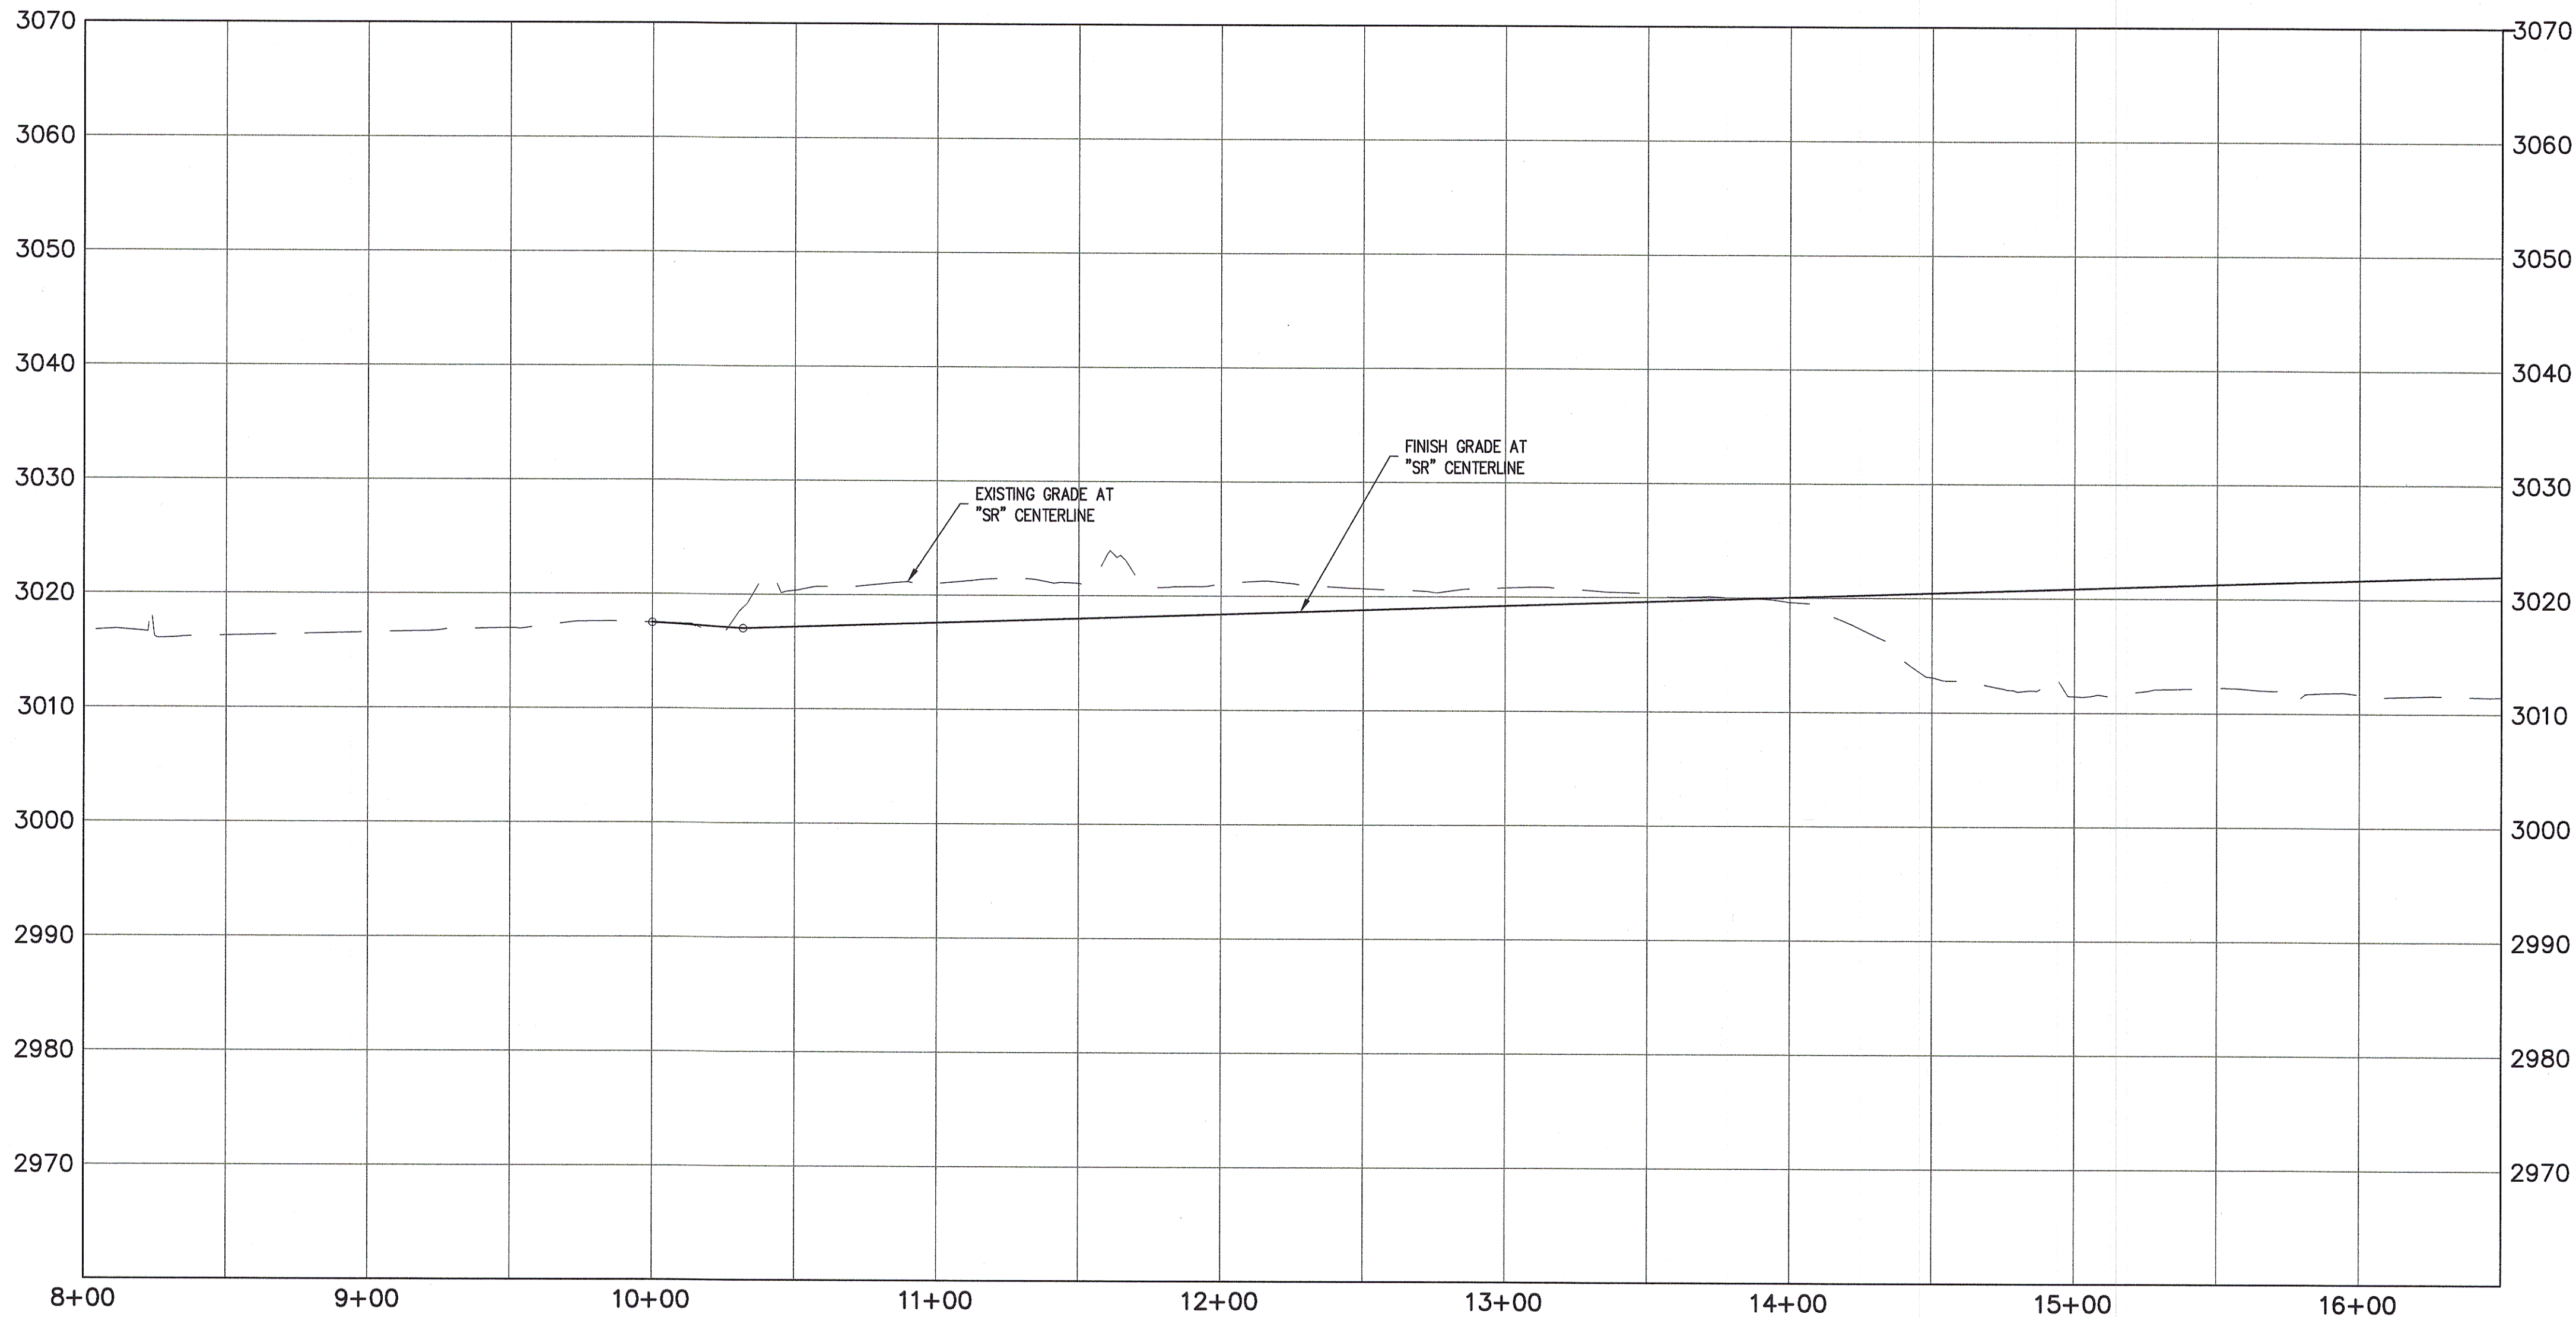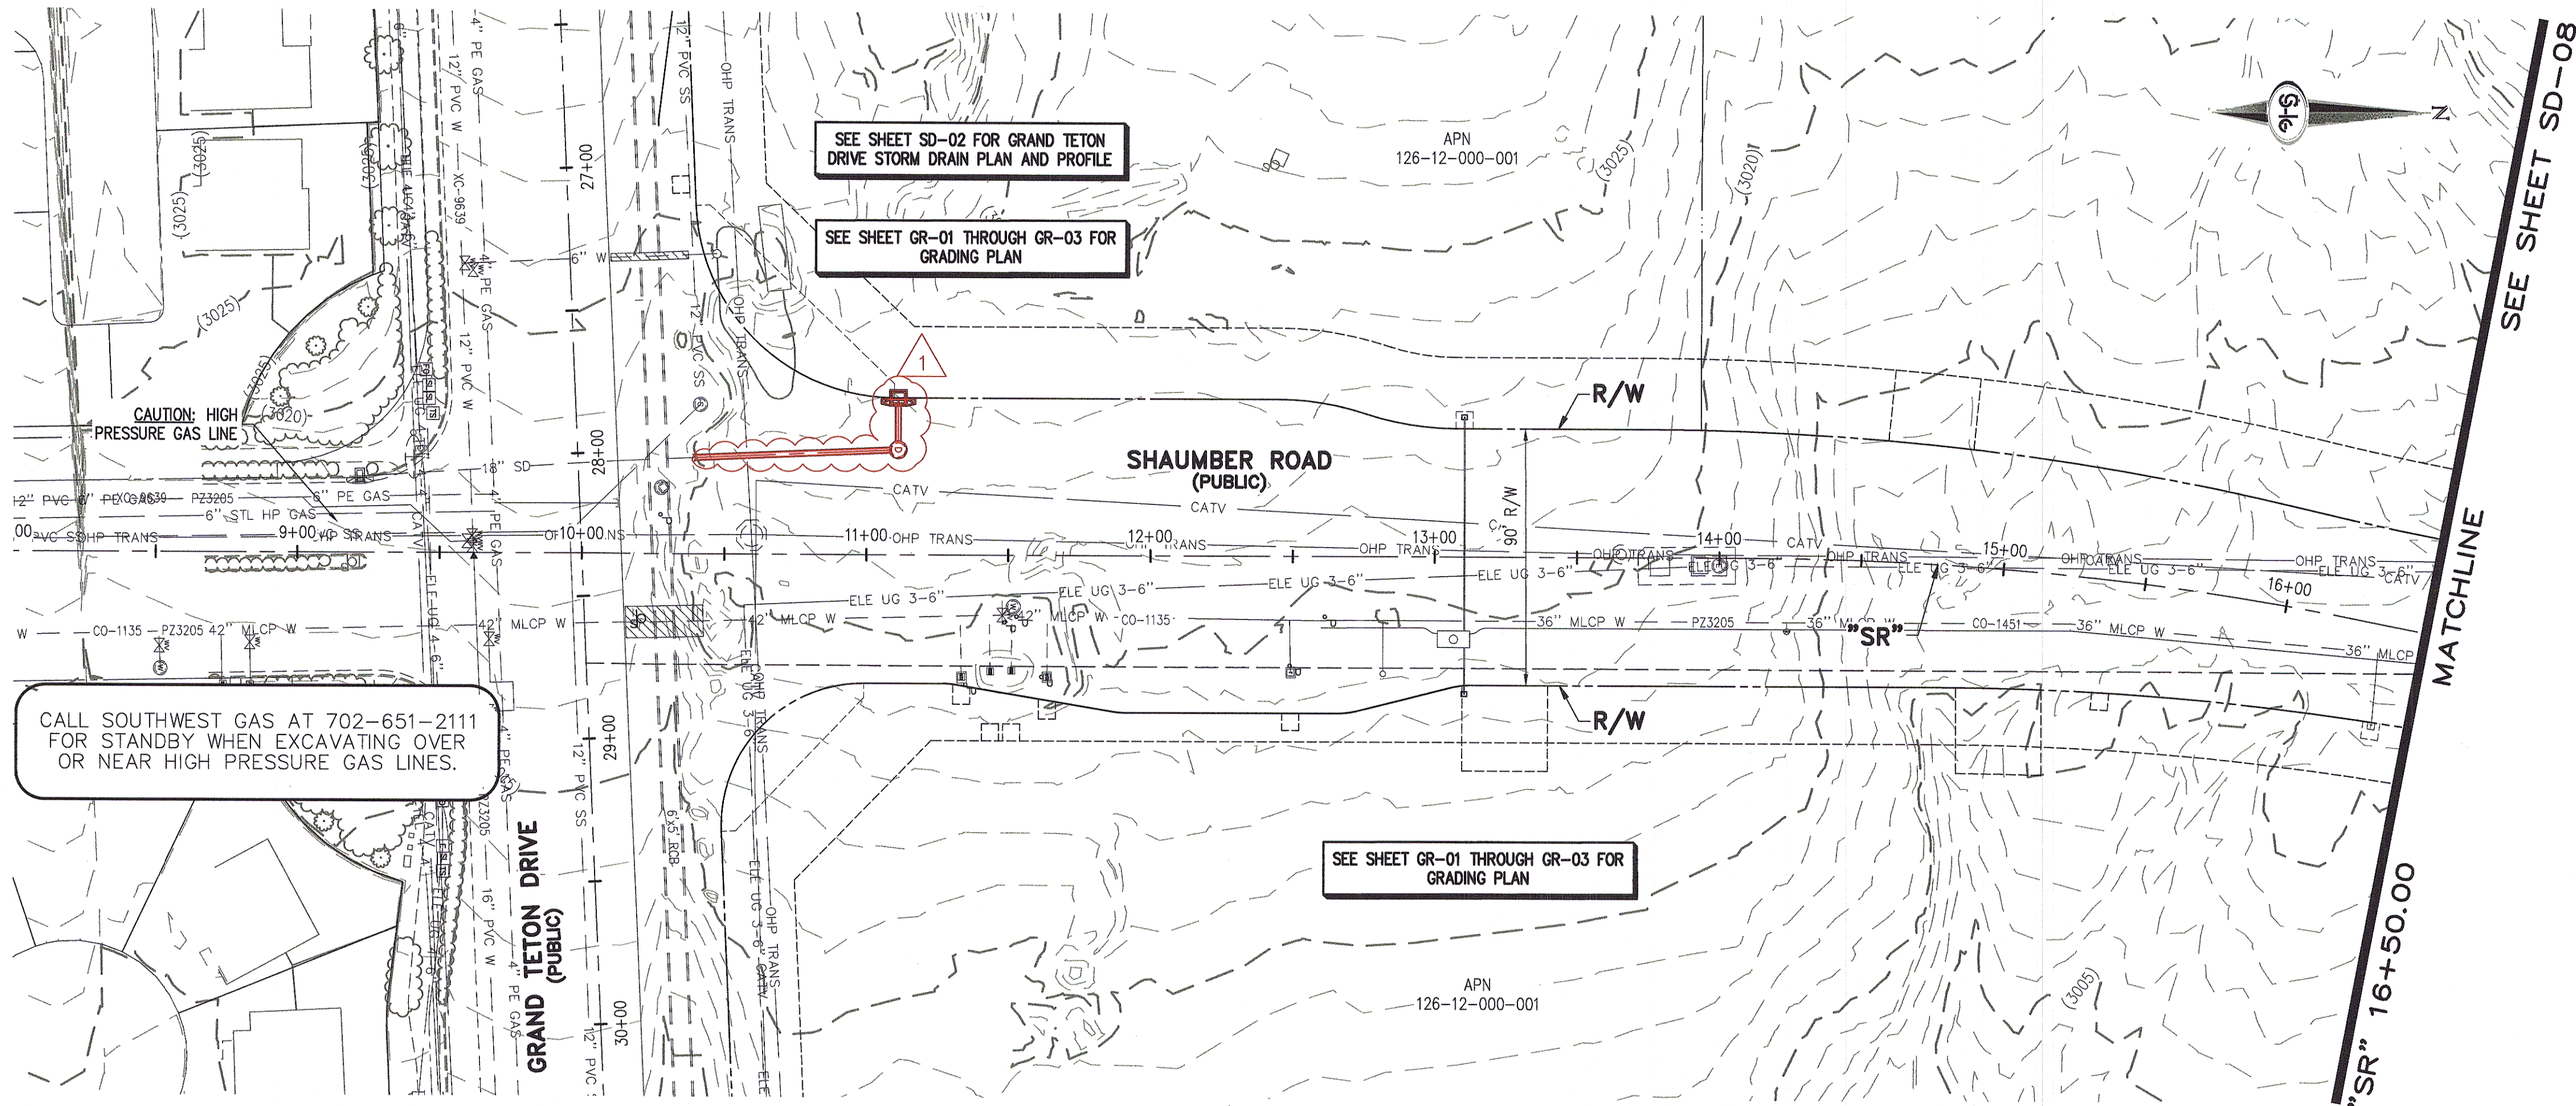

- ### STORM DRAIN NOTES
1. CONSTRUCT TYPE "CM2" DROP INLET (USDCCA STD. DWG. NO. 412.1)
 2. REMOVE EXISTING LATERAL STUB AND CONSTRUCT ROB PLUG (SEE DETAIL 5, DRAWING SD-25)
 3. CONSTRUCT 60" TYPE I MANHOLE (USDCCA STD. DWG. NO. 403.1)
 4. CONSTRUCT 60" TYPE III MANHOLE (USDCCA STD. DWG. NO. 406.1)
 5. CONSTRUCT 60" TYPE III MANHOLE WITH TYPE IA RISER (USDCCA STD. DWG. NO. 404.1 AND 406.1)
 6. CONSTRUCT NDOT TYPE 4 MANHOLE (NDOT STD. PLAN R-4.3.2)
 7. INSTALL 18" RCP OR WATER QUALITY C905 AS SHOWN ON PROFILES (USDCCA STD. DWG. NO. 503.2)
 8. INSTALL 24" RCP OR WATER QUALITY C905 AS SHOWN ON PROFILES (USDCCA STD. DWG. NO. 503.2)
 9. INSTALL 30" RCP (USDCCA STD. DWG. NO. 503.2)
 10. INSTALL 36" RCP (USDCCA STD. DWG. NO. 503.2)
 11. INSTALL 42" RCP (USDCCA STD. DWG. NO. 503.2)
 12. INSTALL 54" RCP (USDCCA STD. DWG. NO. 503.2)
 13. INSTALL 60" RCP (USDCCA STD. DWG. NO. 503.2)
 14. INSTALL 66" RCP (USDCCA STD. DWG. NO. 503.2)
 15. INSTALL 18" RCP END SECTION (NDOT STD. PLAN R-2.3.1)
 16. INSTALL 24" RCP END SECTION (NDOT STD. PLAN R-2.3.1)
 17. INSTALL 30" RCP END SECTION (NDOT STD. PLAN R-2.3.1)
 18. INSTALL 36" RCP END SECTION (NDOT STD. PLAN R-2.3.1)
 19. INSTALL 42" RCP END SECTION (NDOT STD. PLAN R-2.3.1)
 20. PIPE PENETRATION (SEE DETAIL 4, DRAWING SD-25)
 21. CONSTRUCT CONCRETE COLLAR (SEE DETAIL 2, DRAWING SD-25)
 22. CONSTRUCT BRICK AND MORTAR PLUG (SEE DETAIL 1, DRAWING SD-25)
 23. INSTALL 48" RCP (USDCCA STD. DWG. NO. 503.2)
 24. INSTALL 48" RCP END SECTION (NDOT STD. PLAN R-2.3.1)
 25. INSTALL DRIVEWAY (USDCCA STD. DWG. NO. 224)
 26. CONSTRUCT TYPE "CM" DROP INLET (USDCCA STD. DWG. NO. 422)

- ### NOTES
1. ALL RCP SHALL BE CLASS III UNLESS OTHERWISE SHOWN.
 2. ALL PIPE LENGTHS ARE MEASURED ALONG PIPE CENTERLINE TO CENTER OF MANHOLE OR INSIDE EDGE OF DI OR RCB/RCA.
 3. ALL DROP INLETS SHALL INCLUDE STORM WATER MANAGEMENT STAMP AND DETAIL PER USDCCA STD. DWG. NO. 421.
 4. SEE STRUCTURAL PLANS FOR ADDITIONAL STRUCTURAL DETAILS AND CONNECTIONS.
 5. ALL PIPES ARE PUBLICLY MAINTAINED.
 6. ADD SPECIAL INSPECTION REQUIRED FOR PIPE SEGMENTS WITH SACRIFICIAL CONCRETE.

APPROVED FOR CONSTRUCTION
LVVMD WILL HAVE TO BE PRESENT AND VIEW INSTALLATION OF STORM DRAIN THAT WILL BE INSTALLED THAT MAY AFFECT THE WATER MAINS

LVVMD ENGINEERING SERVICES MANAGER
PROJECT NO. 124568

DATE

DROP INLET NOTE
WHERE 10 FEET PARALLEL SEPARATION IS NOT PRACTICABLE:
CAST-IN-PLACE MONOLITHIC POUR WITH WATERSTOP BETWEEN SLAB AND WALLS. BASE, WALLS AND TOP TO BE CONSTRUCTED WITH WATERSTOPS, CENTER BULB, OR FLAT STRIP (VINYLEX, GREENSTREAK PLASTIC PRODUCTS OR APPROVED EQUAL).

LEGEND


1 STORM DRAIN LATERAL # (SEE SHEETS SD-20 THRU SD-24)

I CERTIFY THAT THIS GRADING PLAN IS IN CONFORMANCE WITH THE APPROVED TECHNICAL DRAINAGE STUDY DS-4739A ON FILE AT THE CITY OF LAS VEGAS FOR THE SUBJECT PROJECT

JERRY SLATER, P.E. 14167 DATE _____

FLOOD ZONE
THE PROJECT SITE IS LOCATED WITHIN A FEMA DESIGNATED ZONE "X" (OUTSIDE THE 500-YEAR FLOOD PLAIN) ON THE FLOOD INSURANCE RATE MAP (FIRM) PANEL: 32003C1750E, DATED SEPTEMBER 27, 2002

NOTE:
PROPERTY OWNER IS RESPONSIBLE TO MAINTAIN THE BEST MANAGEMENT PRACTICES, SUCH AS BUT NOT LIMITED TO, THE REMOVAL OF ACCUMULATED SEDIMENT AND DEBRIS AND CARE OF VEGETATION.

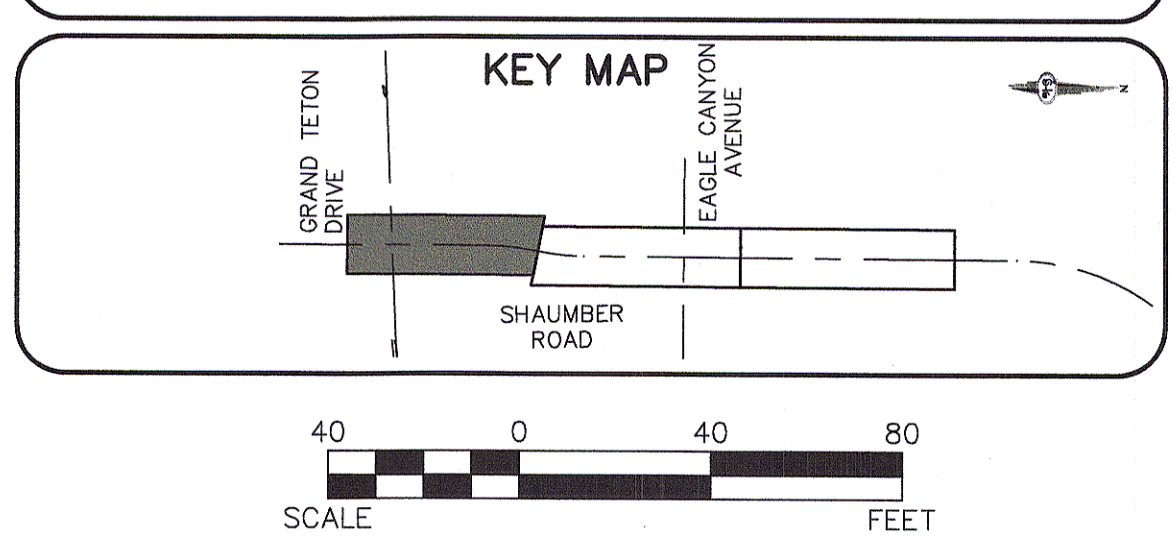



SLATER HANIFAN GROUP
CONSULTING ENGINEERS & PLANNERS
5740 S. ARVILLE STREET #216, LAS VEGAS, NV 89118
PHONE (702) 284-5390 FAX (702) 284-5399

NINETY-FIVE MANAGEMENT LLC

SKYE CANYON II PHASE 2 MASS GRADING
SHAUMBER ROAD STORM DRAIN PLAN AND PROFILE
"SR" 8+00.00 TO "SR" 16+50.00

DATE: 8/3/16
DRAFTER: JAS
DESIGNER: DAM
CHECKED: JSR
PROJECT NO.
OLY1501-001

SD-07
SHEET 10 OF 32

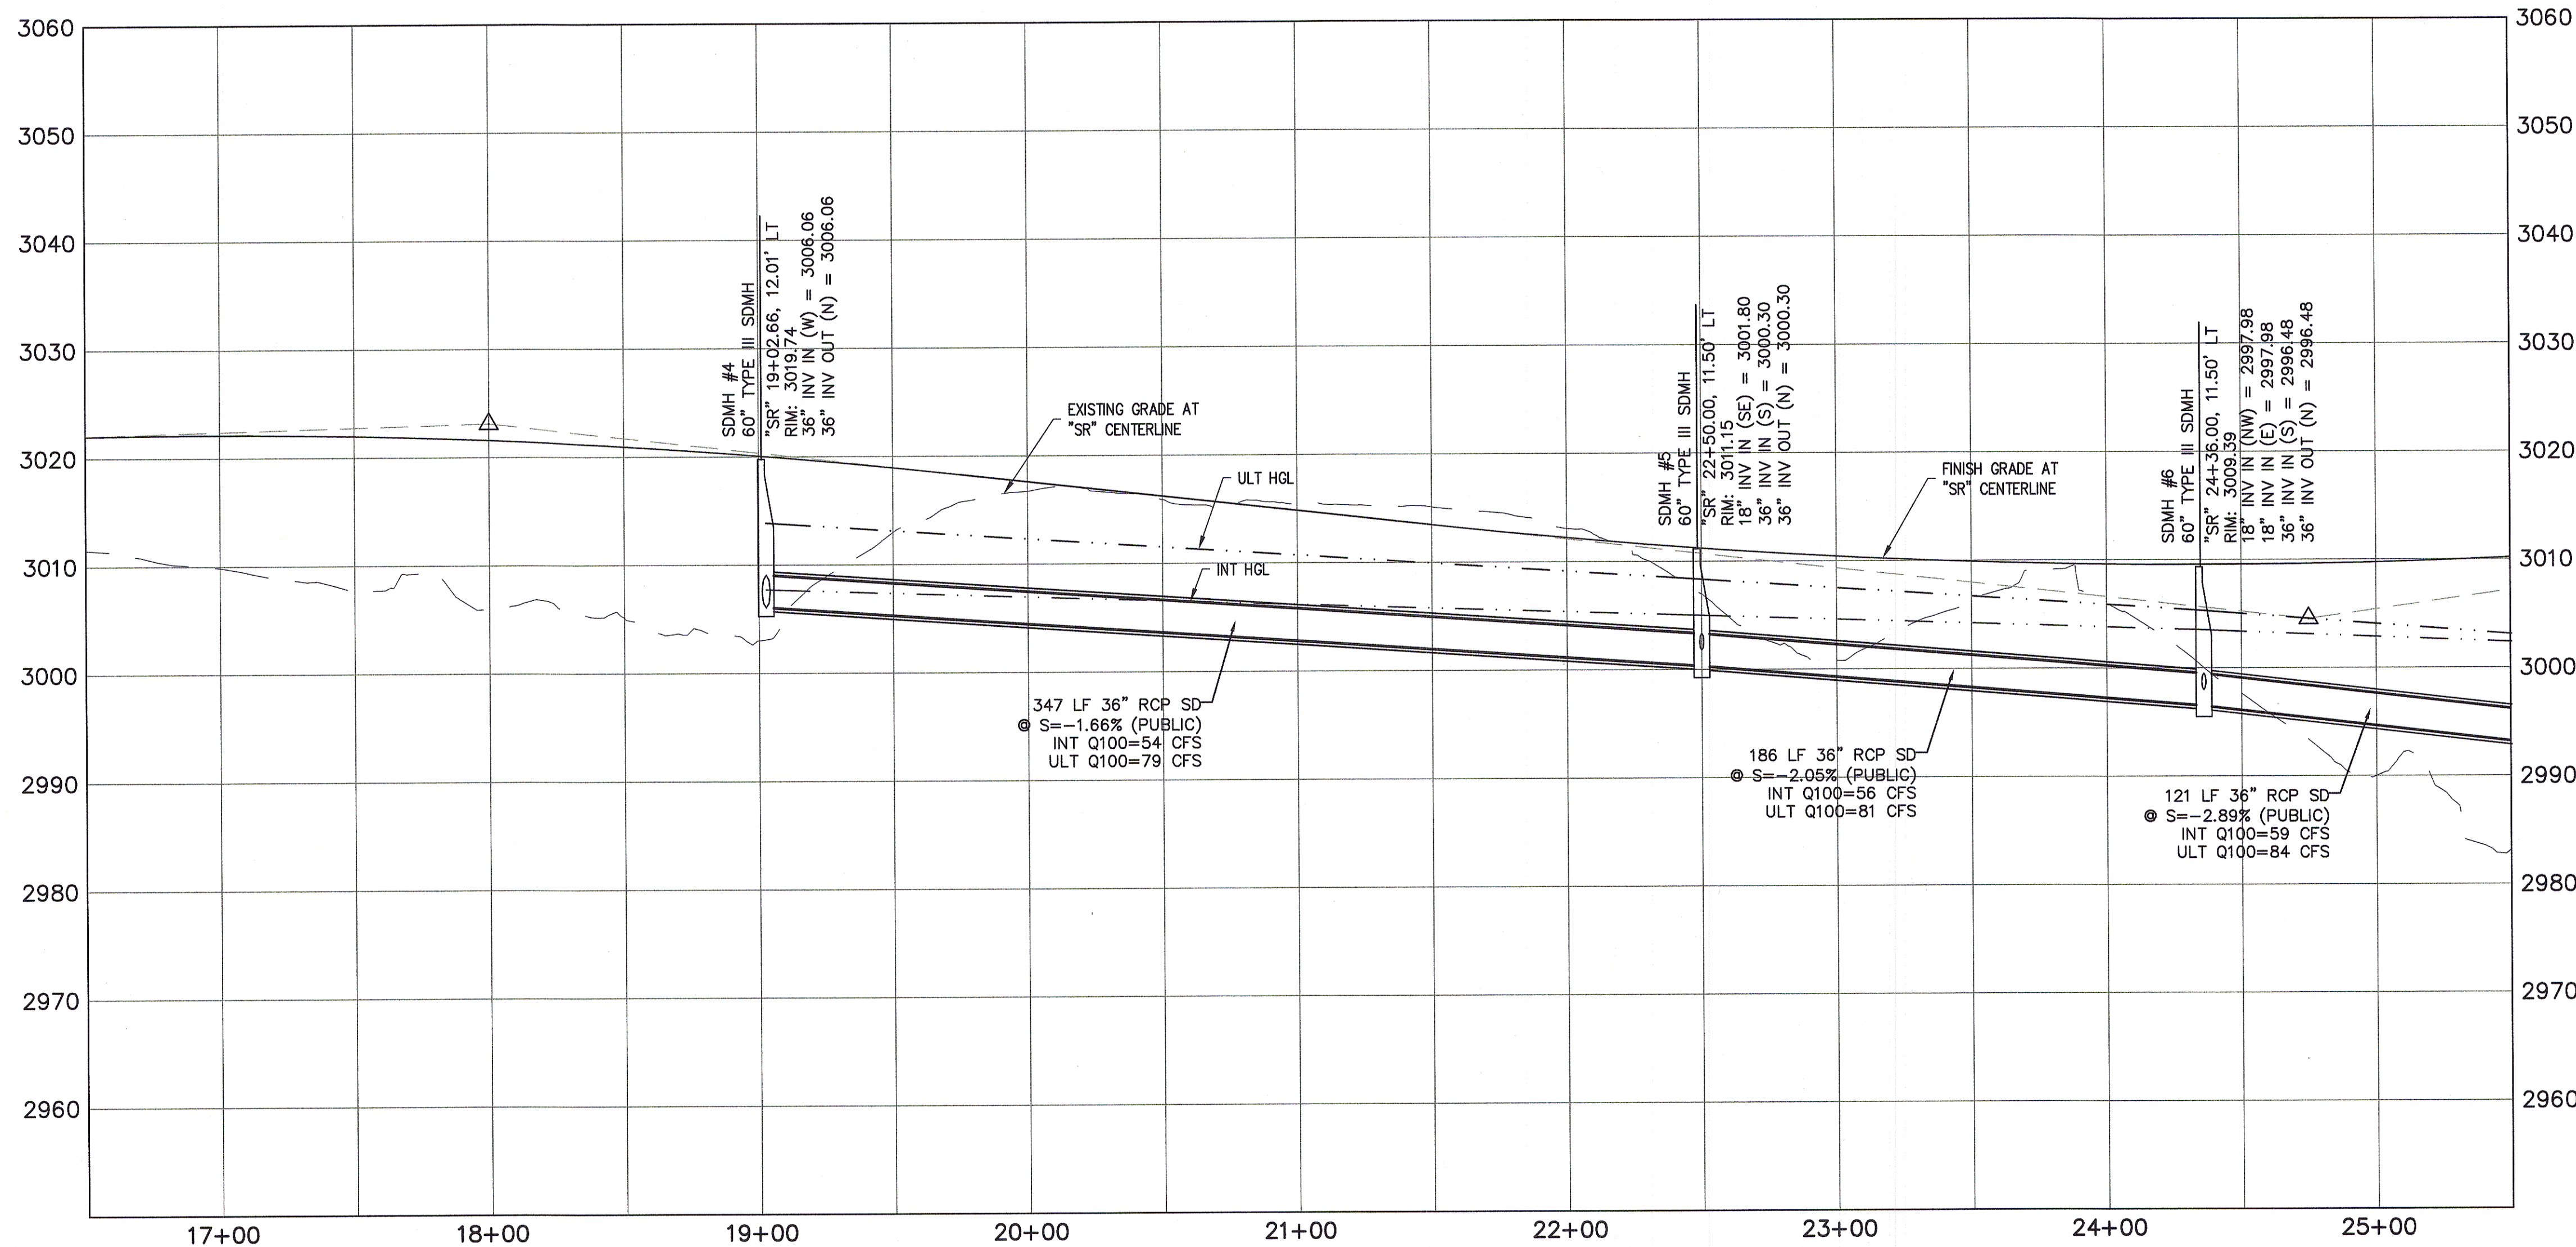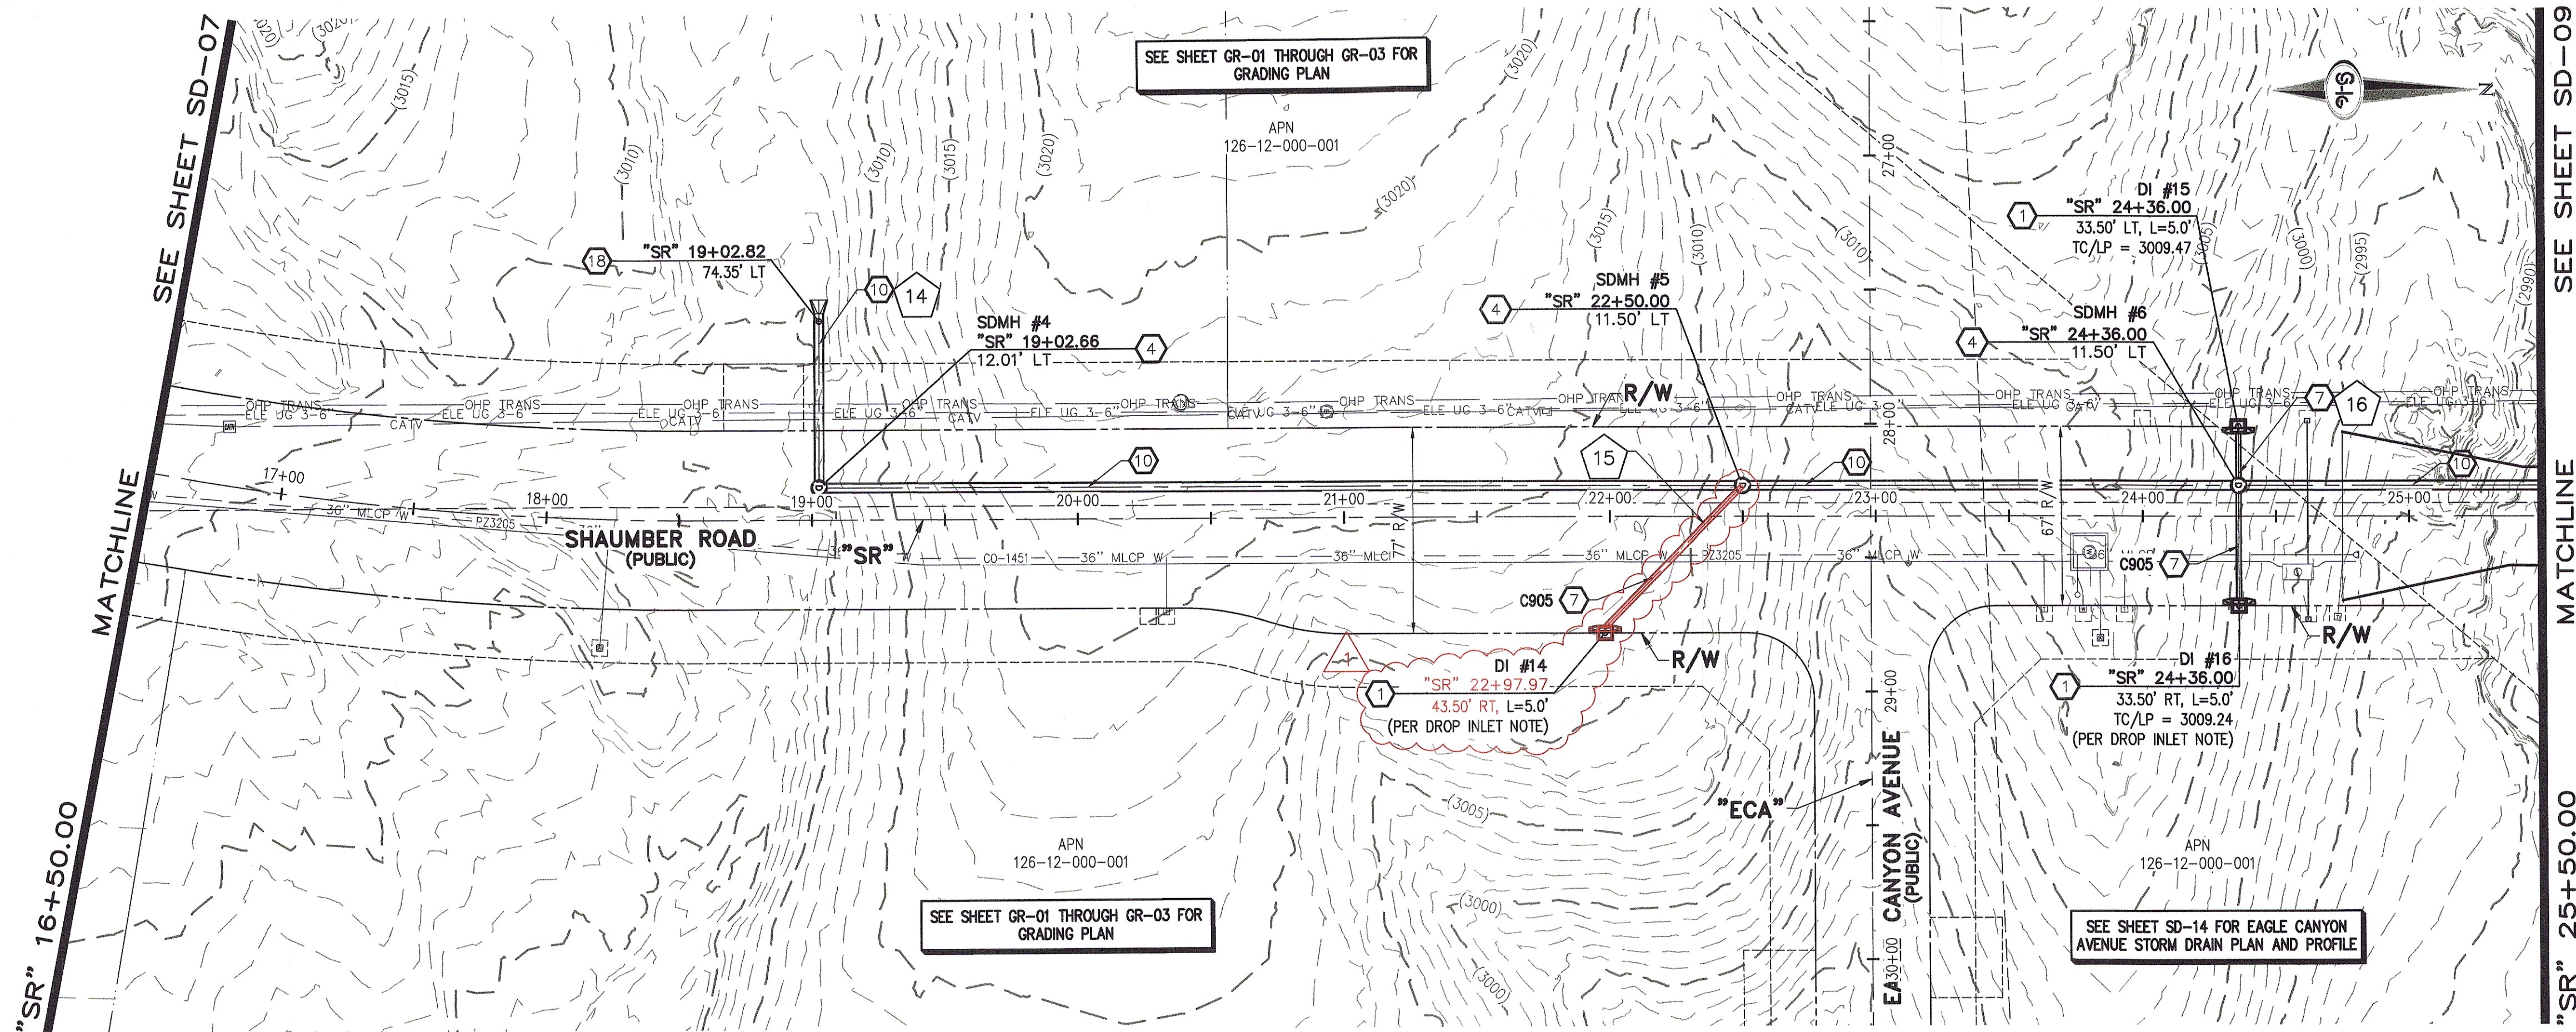

STORM DRAIN NOTES

- CONSTRUCT TYPE "CM2" DROP INLET (USDCCA STD. DWG. NO. 412.1)
- REMOVE EXISTING LATERAL STUB AND CONSTRUCT RCB PLUG (SEE DETAIL 5, DRAWING SD-25)
- CONSTRUCT 60" TYPE I MANHOLE (USDCCA STD. DWG. NO. 403.1)
- CONSTRUCT 60" TYPE III MANHOLE (USDCCA STD. DWG. NO. 406.1)
- CONSTRUCT 60" TYPE III MANHOLE WITH TYPE IA RISER (USDCCA STD. DWG. NO. 404.1 AND 406.1)
- CONSTRUCT NDOT TYPE 4 MANHOLE (NDOT STD. PLAN R-4.3.2)
- INSTALL 18" RCP OR WATER QUALITY C905 AS SHOWN ON PROFILES (USDCCA STD. DWG. NO. 503.2)
- INSTALL 24" RCP OR WATER QUALITY C905 AS SHOWN ON PROFILES (USDCCA STD. DWG. NO. 503.2)
- INSTALL 30" RCP (USDCCA STD. DWG. NO. 503.2)
- INSTALL 36" RCP (USDCCA STD. DWG. NO. 503.2)
- INSTALL 42" RCP (USDCCA STD. DWG. NO. 503.2)
- INSTALL 54" RCP (USDCCA STD. DWG. NO. 503.2)
- INSTALL 60" RCP (USDCCA STD. DWG. NO. 503.2)
- INSTALL 66" RCP (USDCCA STD. DWG. NO. 503.2)
- INSTALL 18" RCP END SECTION (NDOT STD. PLAN R-2.3.1)
- INSTALL 24" RCP END SECTION (NDOT STD. PLAN R-2.3.1)
- INSTALL 30" RCP END SECTION (NDOT STD. PLAN R-2.3.1)
- INSTALL 36" RCP END SECTION (NDOT STD. PLAN R-2.3.1)
- INSTALL 42" RCP END SECTION (NDOT STD. PLAN R-2.3.1)
- PIPE PENETRATION (SEE DETAIL 4, DRAWING SD-25)
- CONSTRUCT CONCRETE COLLAR (SEE DETAIL 2, DRAWING SD-25)
- CONSTRUCT BRICK AND MORTAR PLUG (SEE DETAIL 1, DRAWING SD-25)
- INSTALL 48" RCP (USDCCA STD. DWG. NO. 503.2)
- INSTALL 48" RCP END SECTION (NDOT STD. PLAN R-2.3.1)
- INSTALL DRIVEWAY (USDCCA STD. DWG. NO. 224)
- CONSTRUCT TYPE "CM" DROP INLET (USDCCA STD. DWG. NO. 422)

NOTES

- ALL RCP SHALL BE CLASS III UNLESS OTHERWISE SHOWN.
- ALL PIPE LENGTHS ARE MEASURED ALONG PIPE CENTERLINE TO CENTER OF MANHOLE OR INSIDE EDGE OF DI OR RCB/RCA.
- ALL DROP INLETS SHALL INCLUDE STORM WATER MANAGEMENT STAMP AND DETAIL PER USDCCA STD. DWG. NO. 421.
- SEE STRUCTURAL PLANS FOR ADDITIONAL STRUCTURAL DETAILS AND CONNECTIONS.
- ALL PIPES ARE PUBLICLY MAINTAINED.
- ADD SPECIAL INSPECTION REQUIRED FOR PIPE SEGMENTS WITH SACRIFICIAL CONCRETE.

APPROVED FOR CONSTRUCTION

LYVWD WILL HAVE TO BE PRESENT AND VIEW INSTALLATION OF STORM DRAIN THAT WILL BE INSTALLED THAT MAY AFFECT THE WATER MAINS

LYVWD ENGINEERING SERVICES MANAGER
PROJECT NO. 124568

DATE

DROP INLET NOTE

WHERE 10 FEET PARALLEL SEPARATION IS NOT PRACTICABLE:

CAST-IN-PLACE MONOLITHIC POUR WITH WATERSTOP BETWEEN SLAB AND WALLS. BASE, WALLS AND TOP TO BE CONSTRUCTED WITH WATERSTOPS, CENTER BULB, OR FLAT STRIP (VINYLEX, GREENSTREAK PLASTIC PRODUCTS OR APPROVED EQUAL).

LEGEND



STORM DRAIN LATERAL # (SEE SHEETS SD-20 THRU SD-24)

I CERTIFY THAT THIS GRADING PLAN IS IN CONFORMANCE WITH THE APPROVED TECHNICAL DRAINAGE STUDY DS-4758A ON FILE AT THE CITY OF LAS VEGAS FOR THE SUBJECT PROJECT

JERRY SLATER, P.E. 14167

DATE


FLOOD ZONE

THE PROJECT SITE IS LOCATED WITHIN A FEMA DESIGNATED ZONE "X" (OUTSIDE THE 500-YEAR FLOOD PLAIN) ON THE FLOOD INSURANCE RATE MAP (FIRM) PANEL: 32003C1750E, DATED SEPTEMBER 27, 2002


NOTE:

PROPERTY OWNER IS RESPONSIBLE TO MAINTAIN THE BEST MANAGEMENT PRACTICES, SUCH AS BUT NOT LIMITED TO, THE REMOVAL OF ACCUMULATED SEDIMENT AND DEBRIS AND CARE OF VEGETATION.

KEY MAP

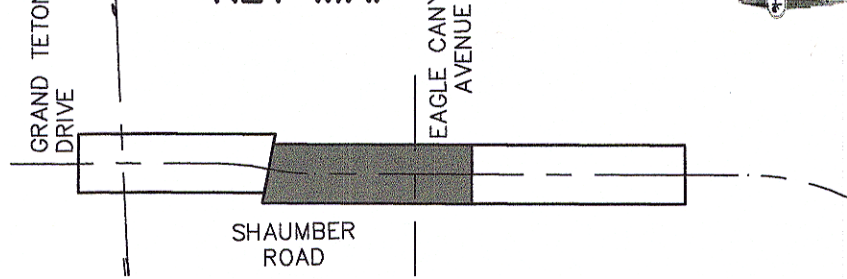

40 0 40 80
SCALE FEET

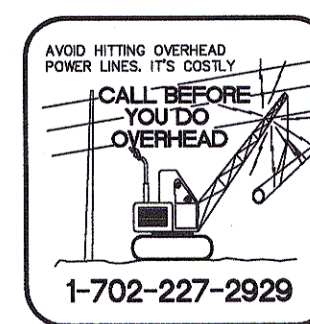

DATE: 8/3/16


DRAFTER: JAS

DESIGNER: DAM

CHECKED: JSR



PROJECT NO.

OLY1501-001

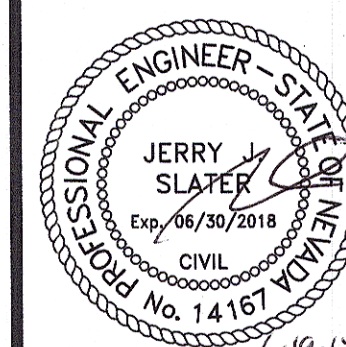

SD-08

SHEET 11 OF 32

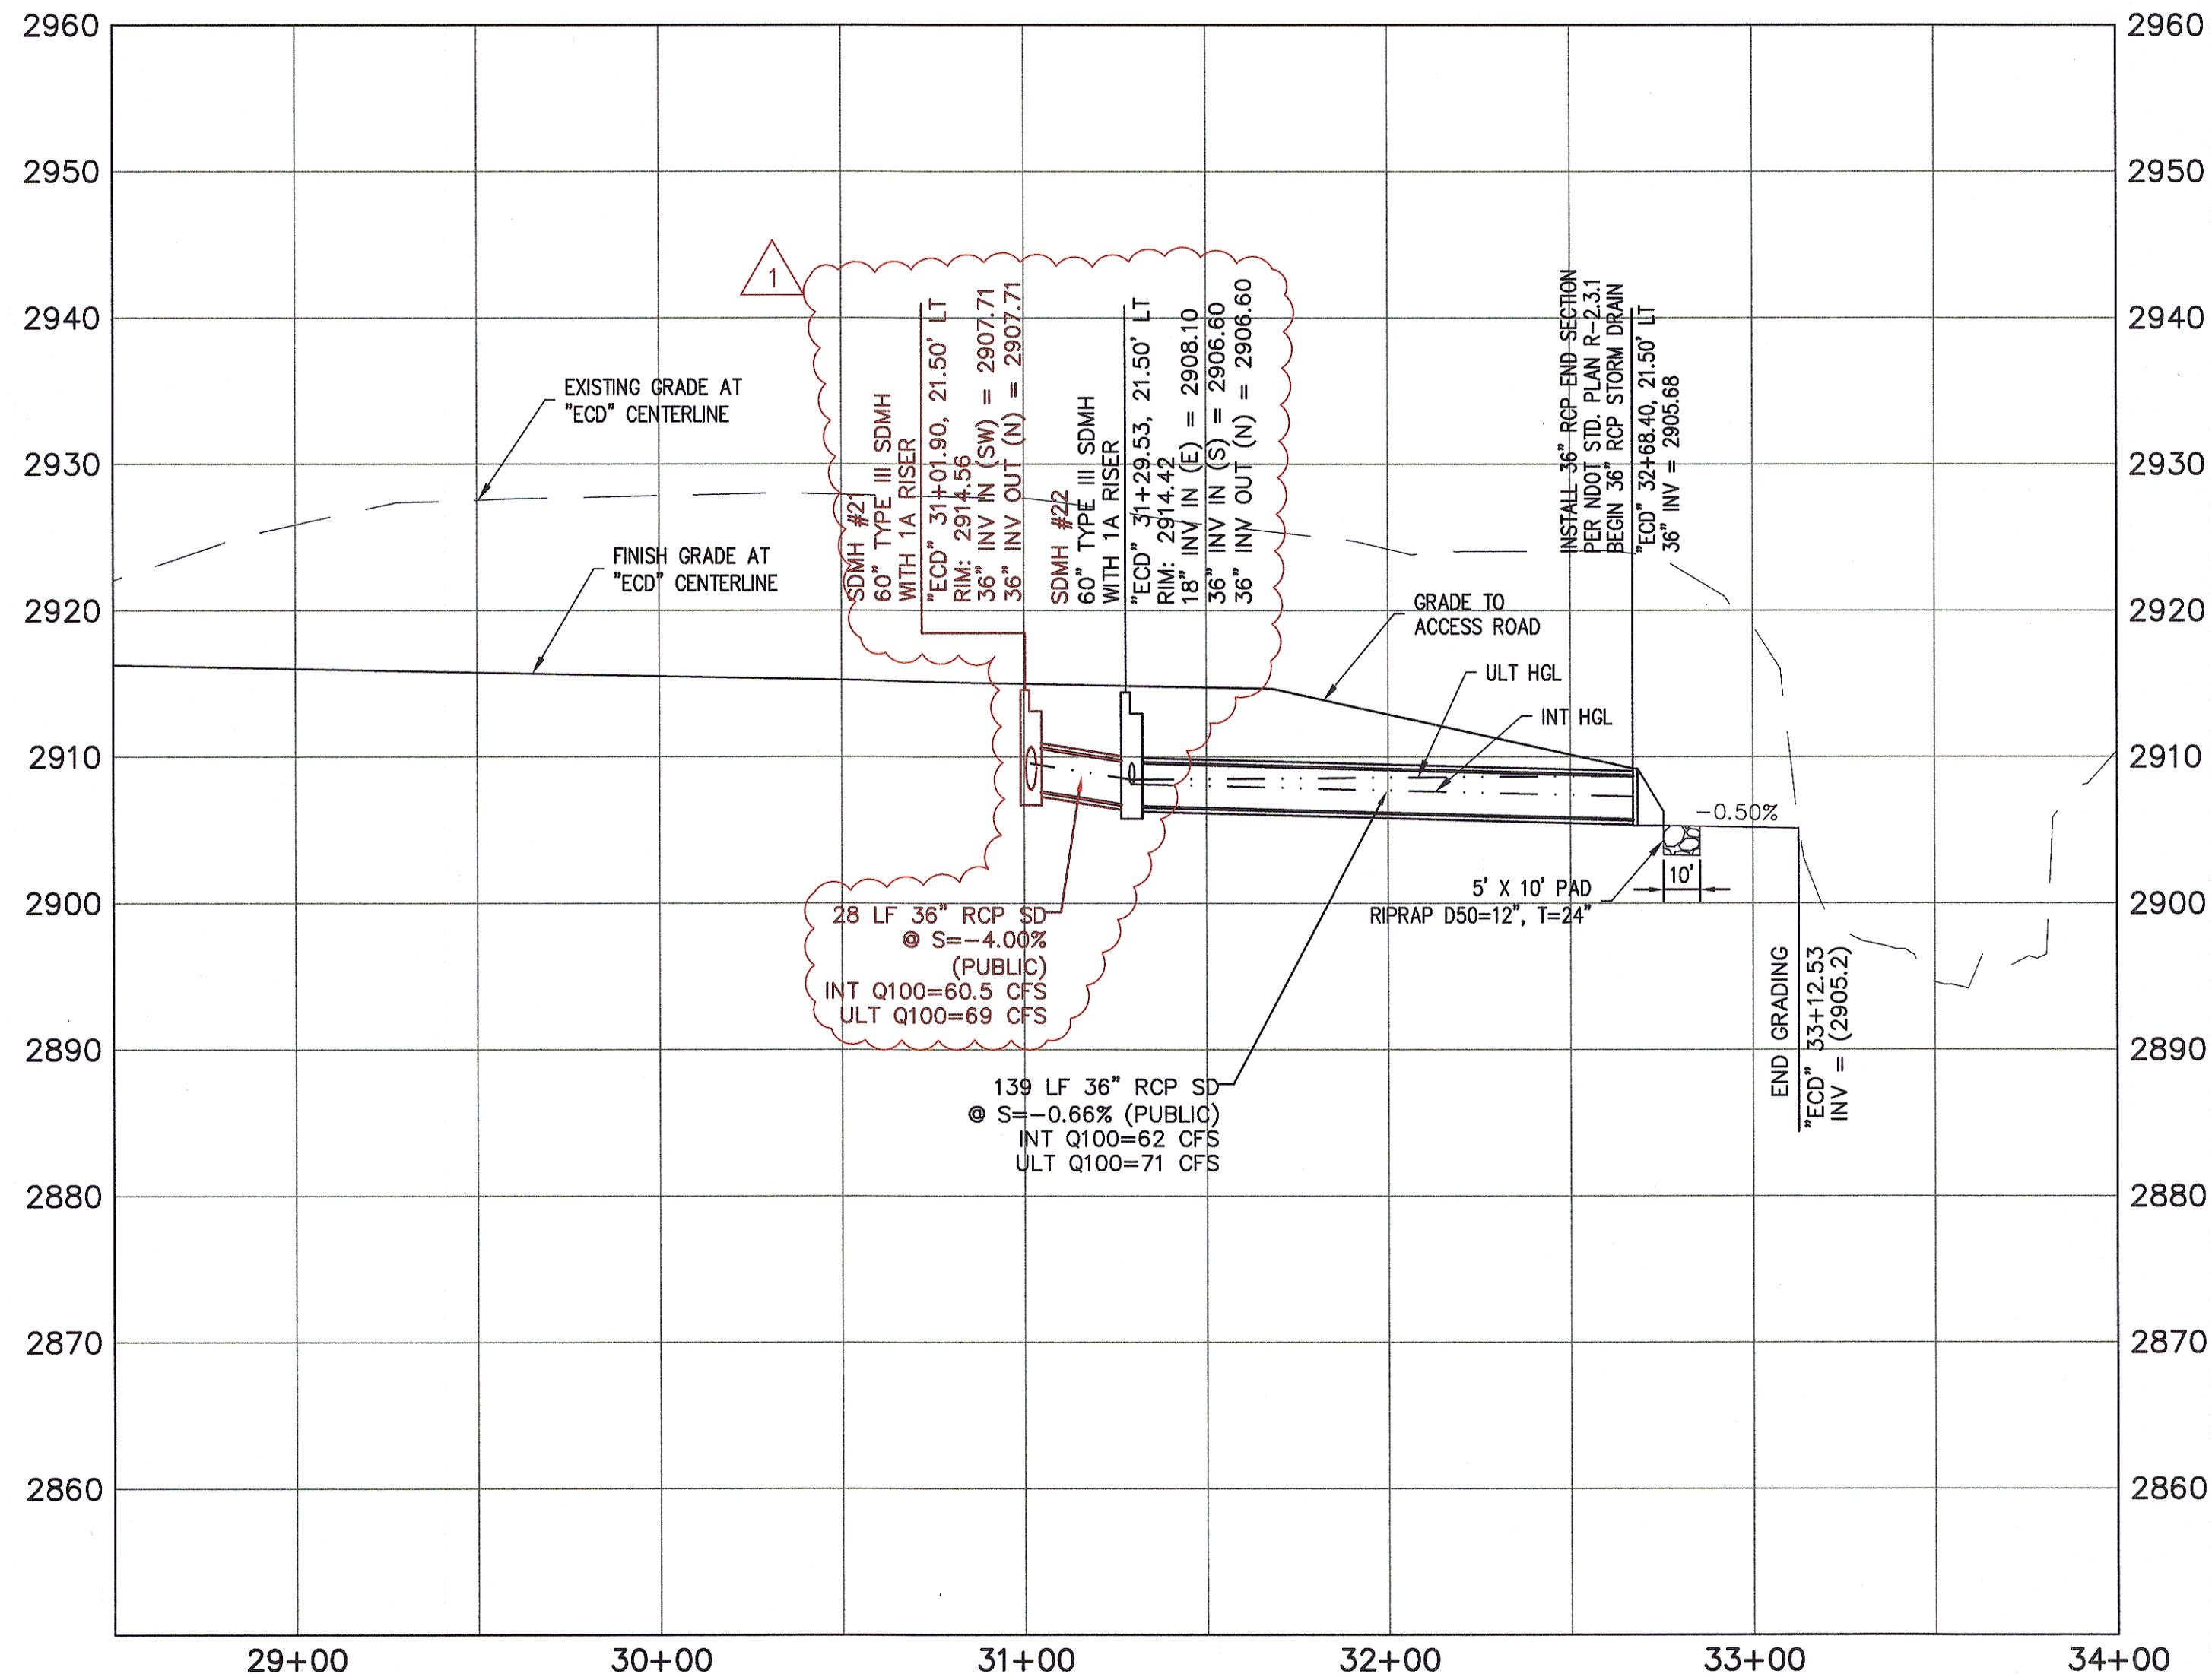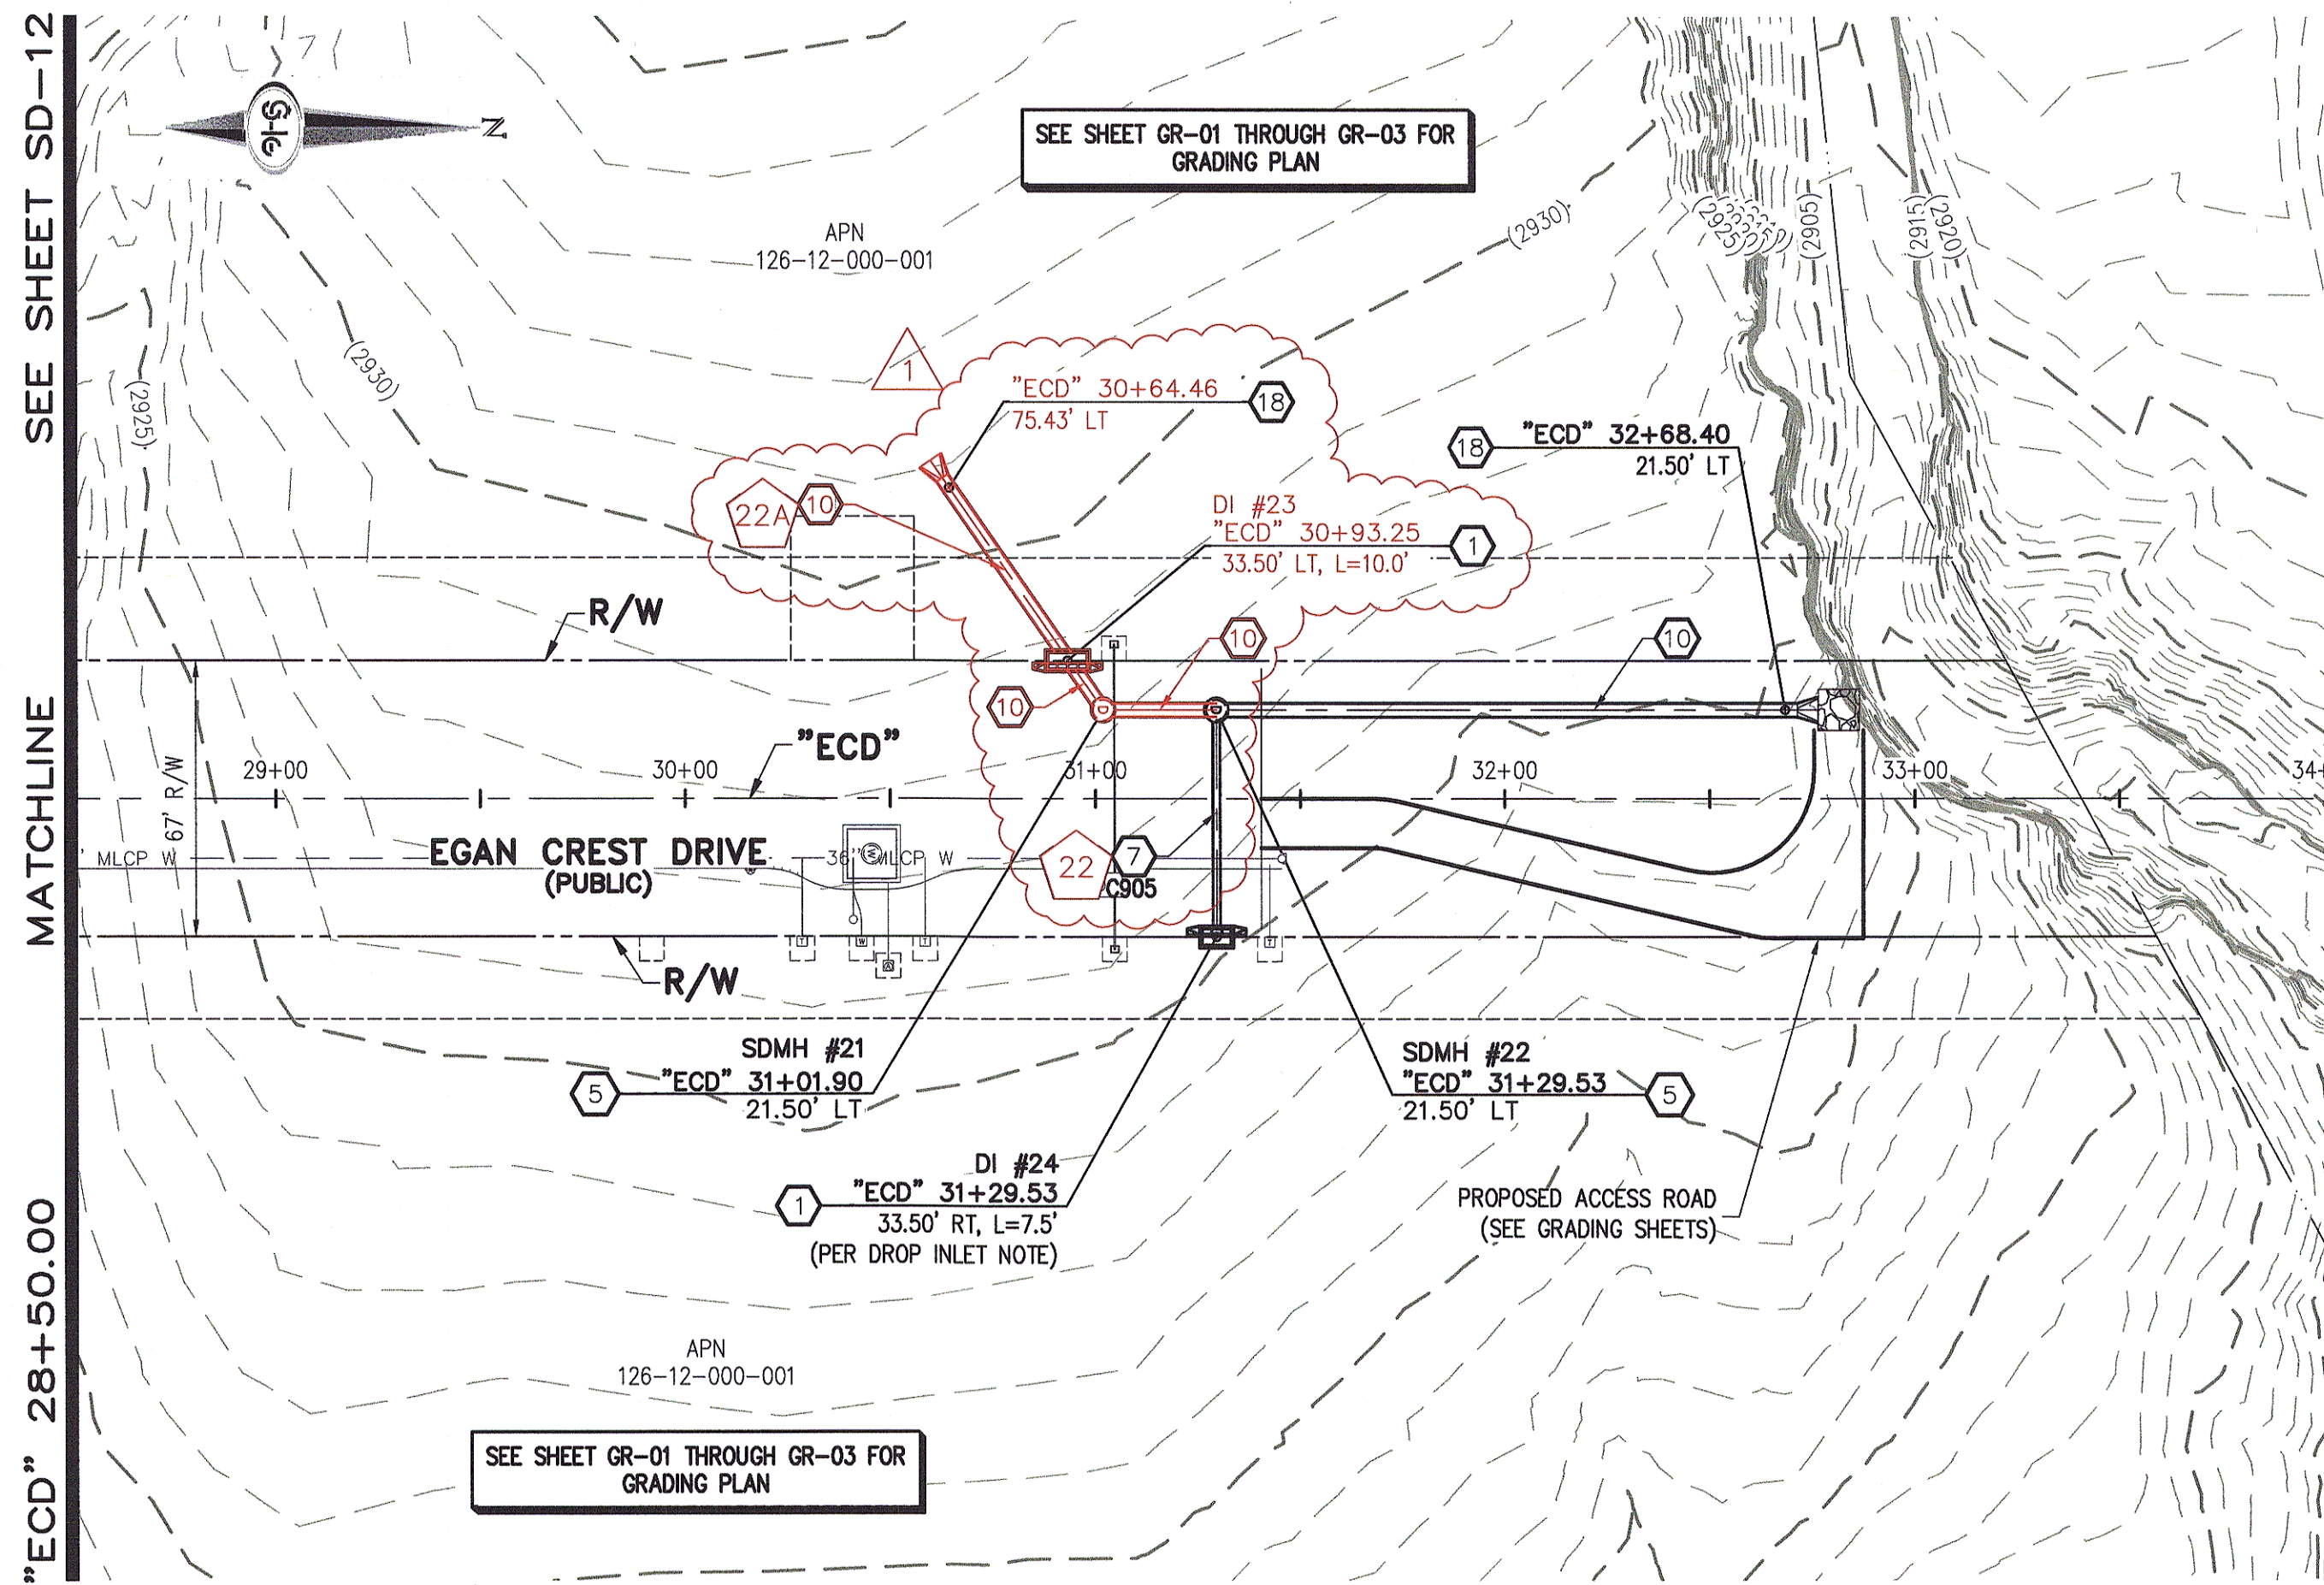

STORM DRAIN NOTES

1. CONSTRUCT TYPE "CM2" DROP INLET (USDCCA STD. DWG. NO. 412.1)
2. REMOVE EXISTING LATERAL STUB AND CONSTRUCT RCB PLUG (SEE DETAIL 5, DRAWING SD-25)
3. CONSTRUCT 60" TYPE I MANHOLE (USDCCA STD. DWG. NO. 403.1)
4. CONSTRUCT 60" TYPE III MANHOLE (USDCCA STD. DWG. NO. 406.1)
5. CONSTRUCT 60" TYPE III MANHOLE WITH TYPE IA RISER (USDCCA STD. DWG. NO. 404.1 AND 406.1)
6. CONSTRUCT NDOT TYPE 4 MANHOLE (NDOT STD. PLAN R-4.3.2)
7. INSTALL 18" RCP OR WATER QUALITY C905 AS SHOWN ON PROFILES (USDCCA STD. DWG. NO. 503.2)
8. INSTALL 24" RCP OR WATER QUALITY C905 AS SHOWN ON PROFILES (USDCCA STD. DWG. NO. 503.2)
9. INSTALL 30" RCP (USDCCA STD. DWG. NO. 503.2)
10. INSTALL 36" RCP (USDCCA STD. DWG. NO. 503.2)
11. INSTALL 42" RCP (USDCCA STD. DWG. NO. 503.2)
12. INSTALL 54" RCP (USDCCA STD. DWG. NO. 503.2)
13. INSTALL 60" RCP (USDCCA STD. DWG. NO. 503.2)
14. INSTALL 66" RCP (USDCCA STD. DWG. NO. 503.2)
15. INSTALL 18" RCP END SECTION (NDOT STD. PLAN R-2.3.1)
16. INSTALL 24" RCP END SECTION (NDOT STD. PLAN R-2.3.1)
17. INSTALL 30" RCP END SECTION (NDOT STD. PLAN R-2.3.1)
18. INSTALL 36" RCP END SECTION (NDOT STD. PLAN R-2.3.1)
19. INSTALL 42" RCP END SECTION (NDOT STD. PLAN R-2.3.1)
20. PIPE PENETRATION (SEE DETAIL 4, DRAWING SD-25)
21. CONSTRUCT CONCRETE COLLAR (SEE DETAIL 2, DRAWING SD-25)
22. CONSTRUCT BRICK AND MORTAR PLUG (SEE DETAIL 1, DRAWING SD-25)
23. INSTALL 48" RCP (USDCCA STD. DWG. NO. 503.2)
24. INSTALL 48" RCP END SECTION (NDOT STD. PLAN R-2.3.1)
25. INSTALL DRIVEWAY (USDCCA STD. DWG. NO. 224)
26. CONSTRUCT TYPE "CM" DROP INLET (USDCCA STD. DWG. NO. 422)

NOTES

1. ALL RCP SHALL BE CLASS III UNLESS OTHERWISE SHOWN.
2. ALL PIPE LENGTHS ARE MEASURED ALONG PIPE CENTERLINE TO CENTER OF MANHOLE OR INSIDE EDGE OF DI OR RCB/RCA.
3. ALL DROP INLETS SHALL INCLUDE STORM WATER MANAGEMENT STAMP AND DETAIL PER USDCCA STD. DWG. NO. 421.
4. SEE STRUCTURAL PLANS FOR ADDITIONAL STRUCTURAL DETAILS AND CONNECTIONS.
5. ALL PIPES ARE PUBLICLY MAINTAINED.
6. ADD SPECIAL INSPECTION REQUIRED FOR PIPE SEGMENTS WITH SACRIFICIAL CONCRETE.

APPROVED FOR CONSTRUCTION

LVWD WILL HAVE TO BE PRESENT AND VIEW INSTALLATION OF STORM DRAIN THAT WILL BE INSTALLED THAT MAY AFFECT THE WATER MAINS

LVWD ENGINEERING SERVICES MANAGER
PROJECT NO. 124568

DATE

DROP INLET NOTE

WHERE 10 FEET PARALLEL SEPARATION IS NOT PRACTICABLE:

CAST-IN-PLACE MONOLITHIC POUR WITH WATERSTOP BETWEEN SLAB AND WALLS. BASE, WALLS AND TOP TO BE CONSTRUCTED WITH WATERSTOPS, CENTER BULB, OR FLAT STRIP (VINYLEX, GREENSTREAK PLASTIC PRODUCTS OR APPROVED EQUAL).

LEGEND



STORM DRAIN LATERAL # (SEE SHEETS SD-20 THRU SD-24)

I CERTIFY THAT THIS GRADING PLAN IS IN CONFORMANCE WITH THE APPROVED TECHNICAL DRAINAGE STUDY DS-4758A ON FILE AT THE CITY OF LAS VEGAS FOR THE SUBJECT PROJECT

JERRY SLATER, P.E. 14167

DATE


FLOOD ZONE

THE PROJECT SITE IS LOCATED WITHIN A FEMA DESIGNATED ZONE "X" (OUTSIDE THE 500-YEAR FLOOD PLAIN) ON THE FLOOD INSURANCE RATE MAP (FIRM) PANEL: 32003C1750E, DATED SEPTEMBER 27, 2002


NOTE:

PROPERTY OWNER IS RESPONSIBLE TO MAINTAIN THE BEST MANAGEMENT PRACTICES, SUCH AS BUT NOT LIMITED TO, THE REMOVAL OF ACCUMULATED SEDIMENT AND DEBRIS AND CARE OF VEGETATION.





KEY MAP

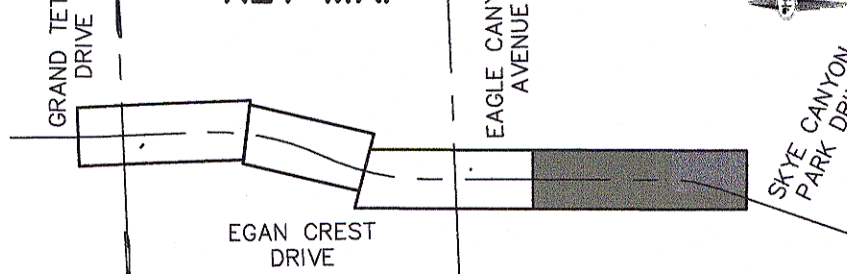

40 0 40 80
SCALE FEET

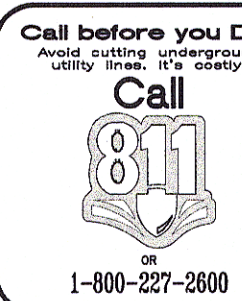

NO.	DESCRIPTION	DATE	BY	APP.
1	REVISED STORM DRAIN	8/20/17	JAS	

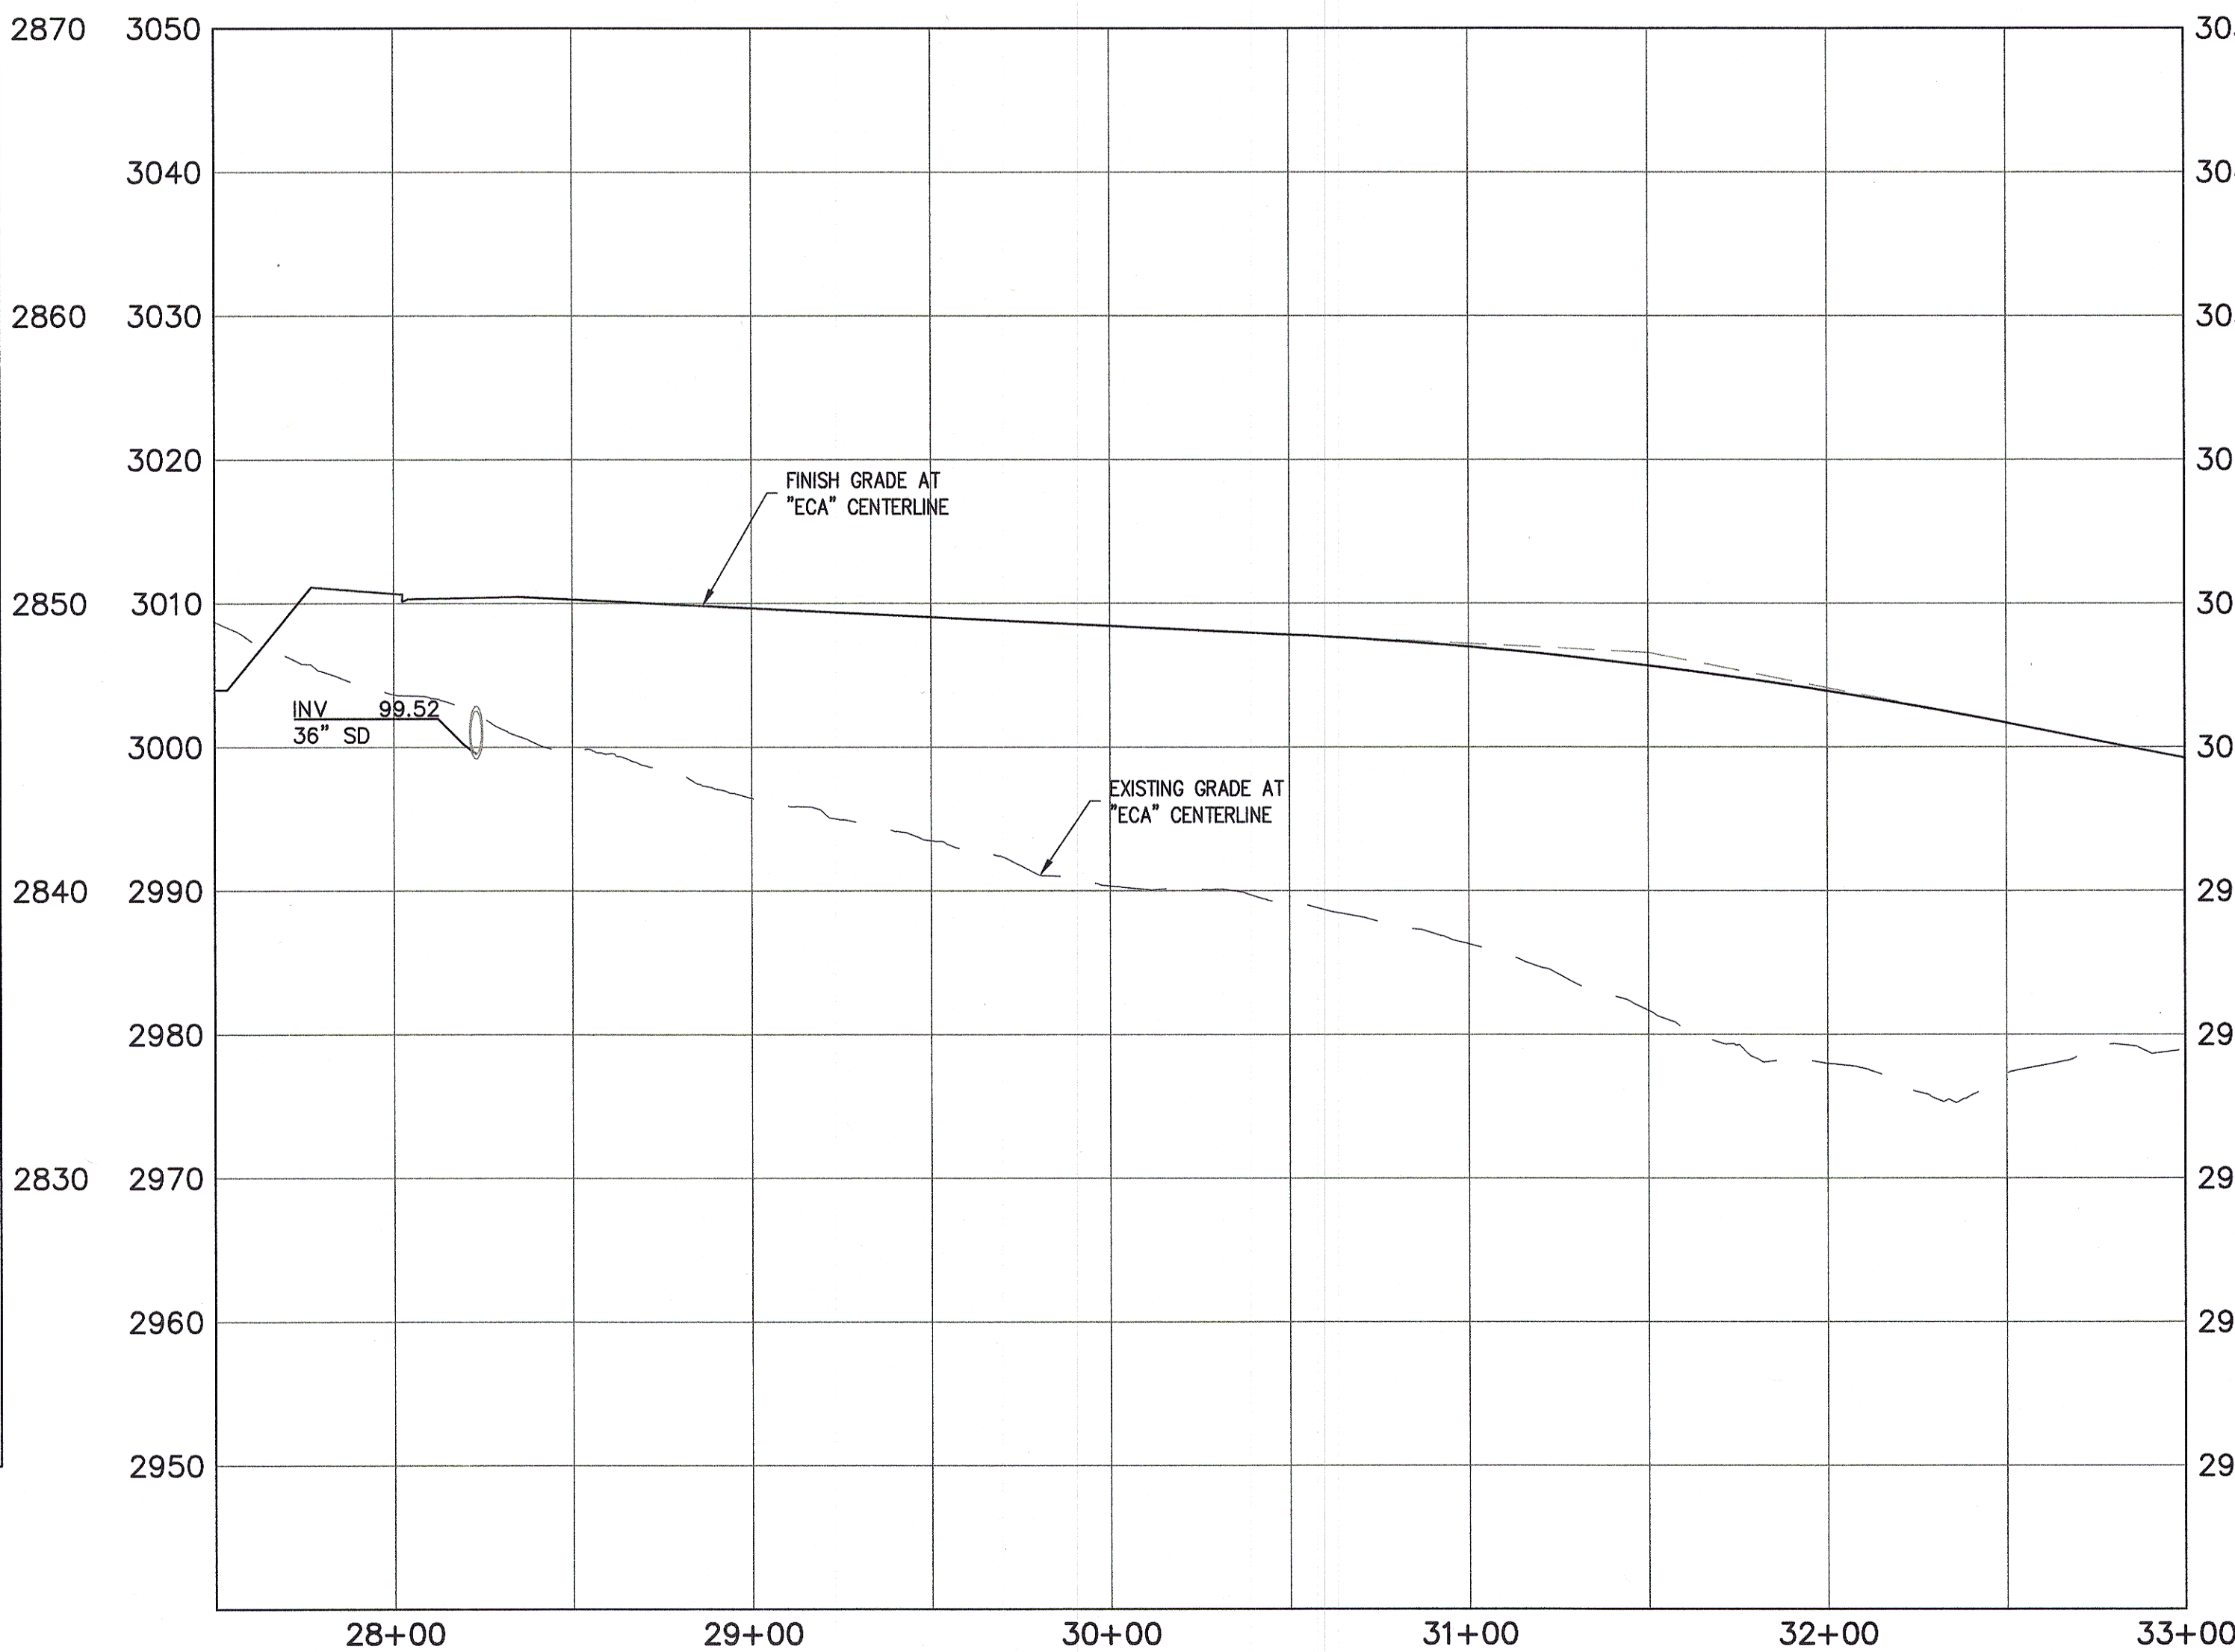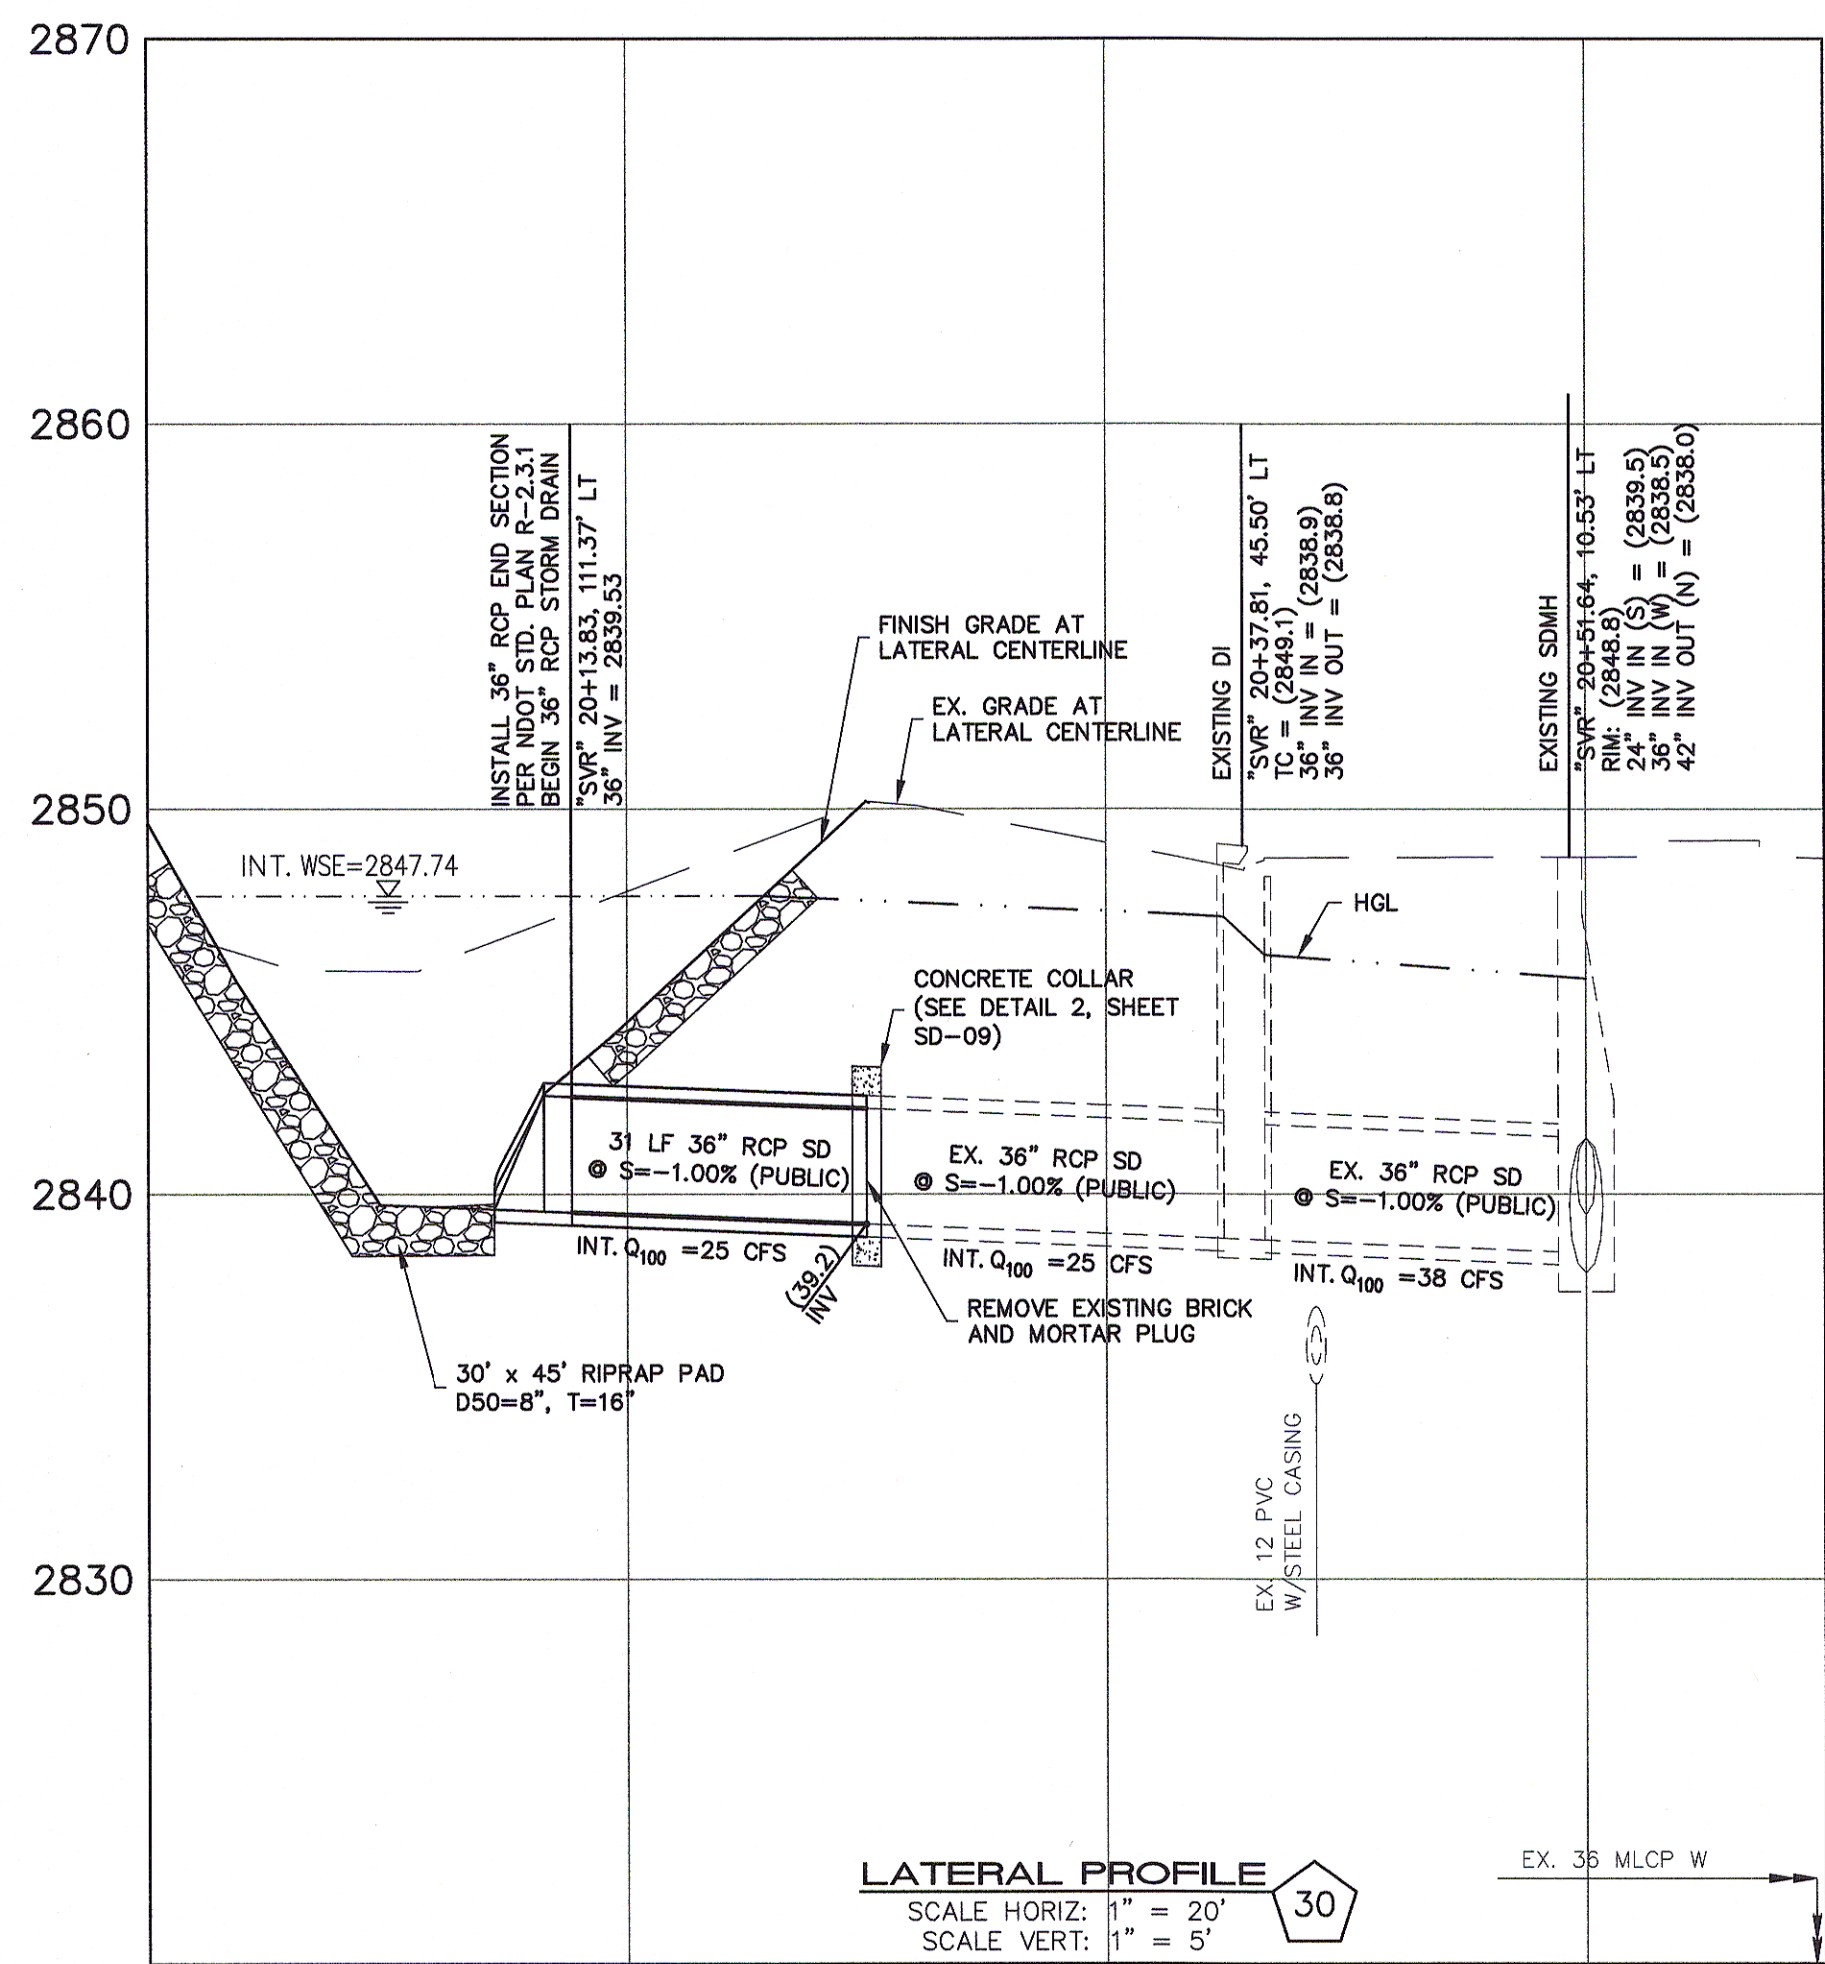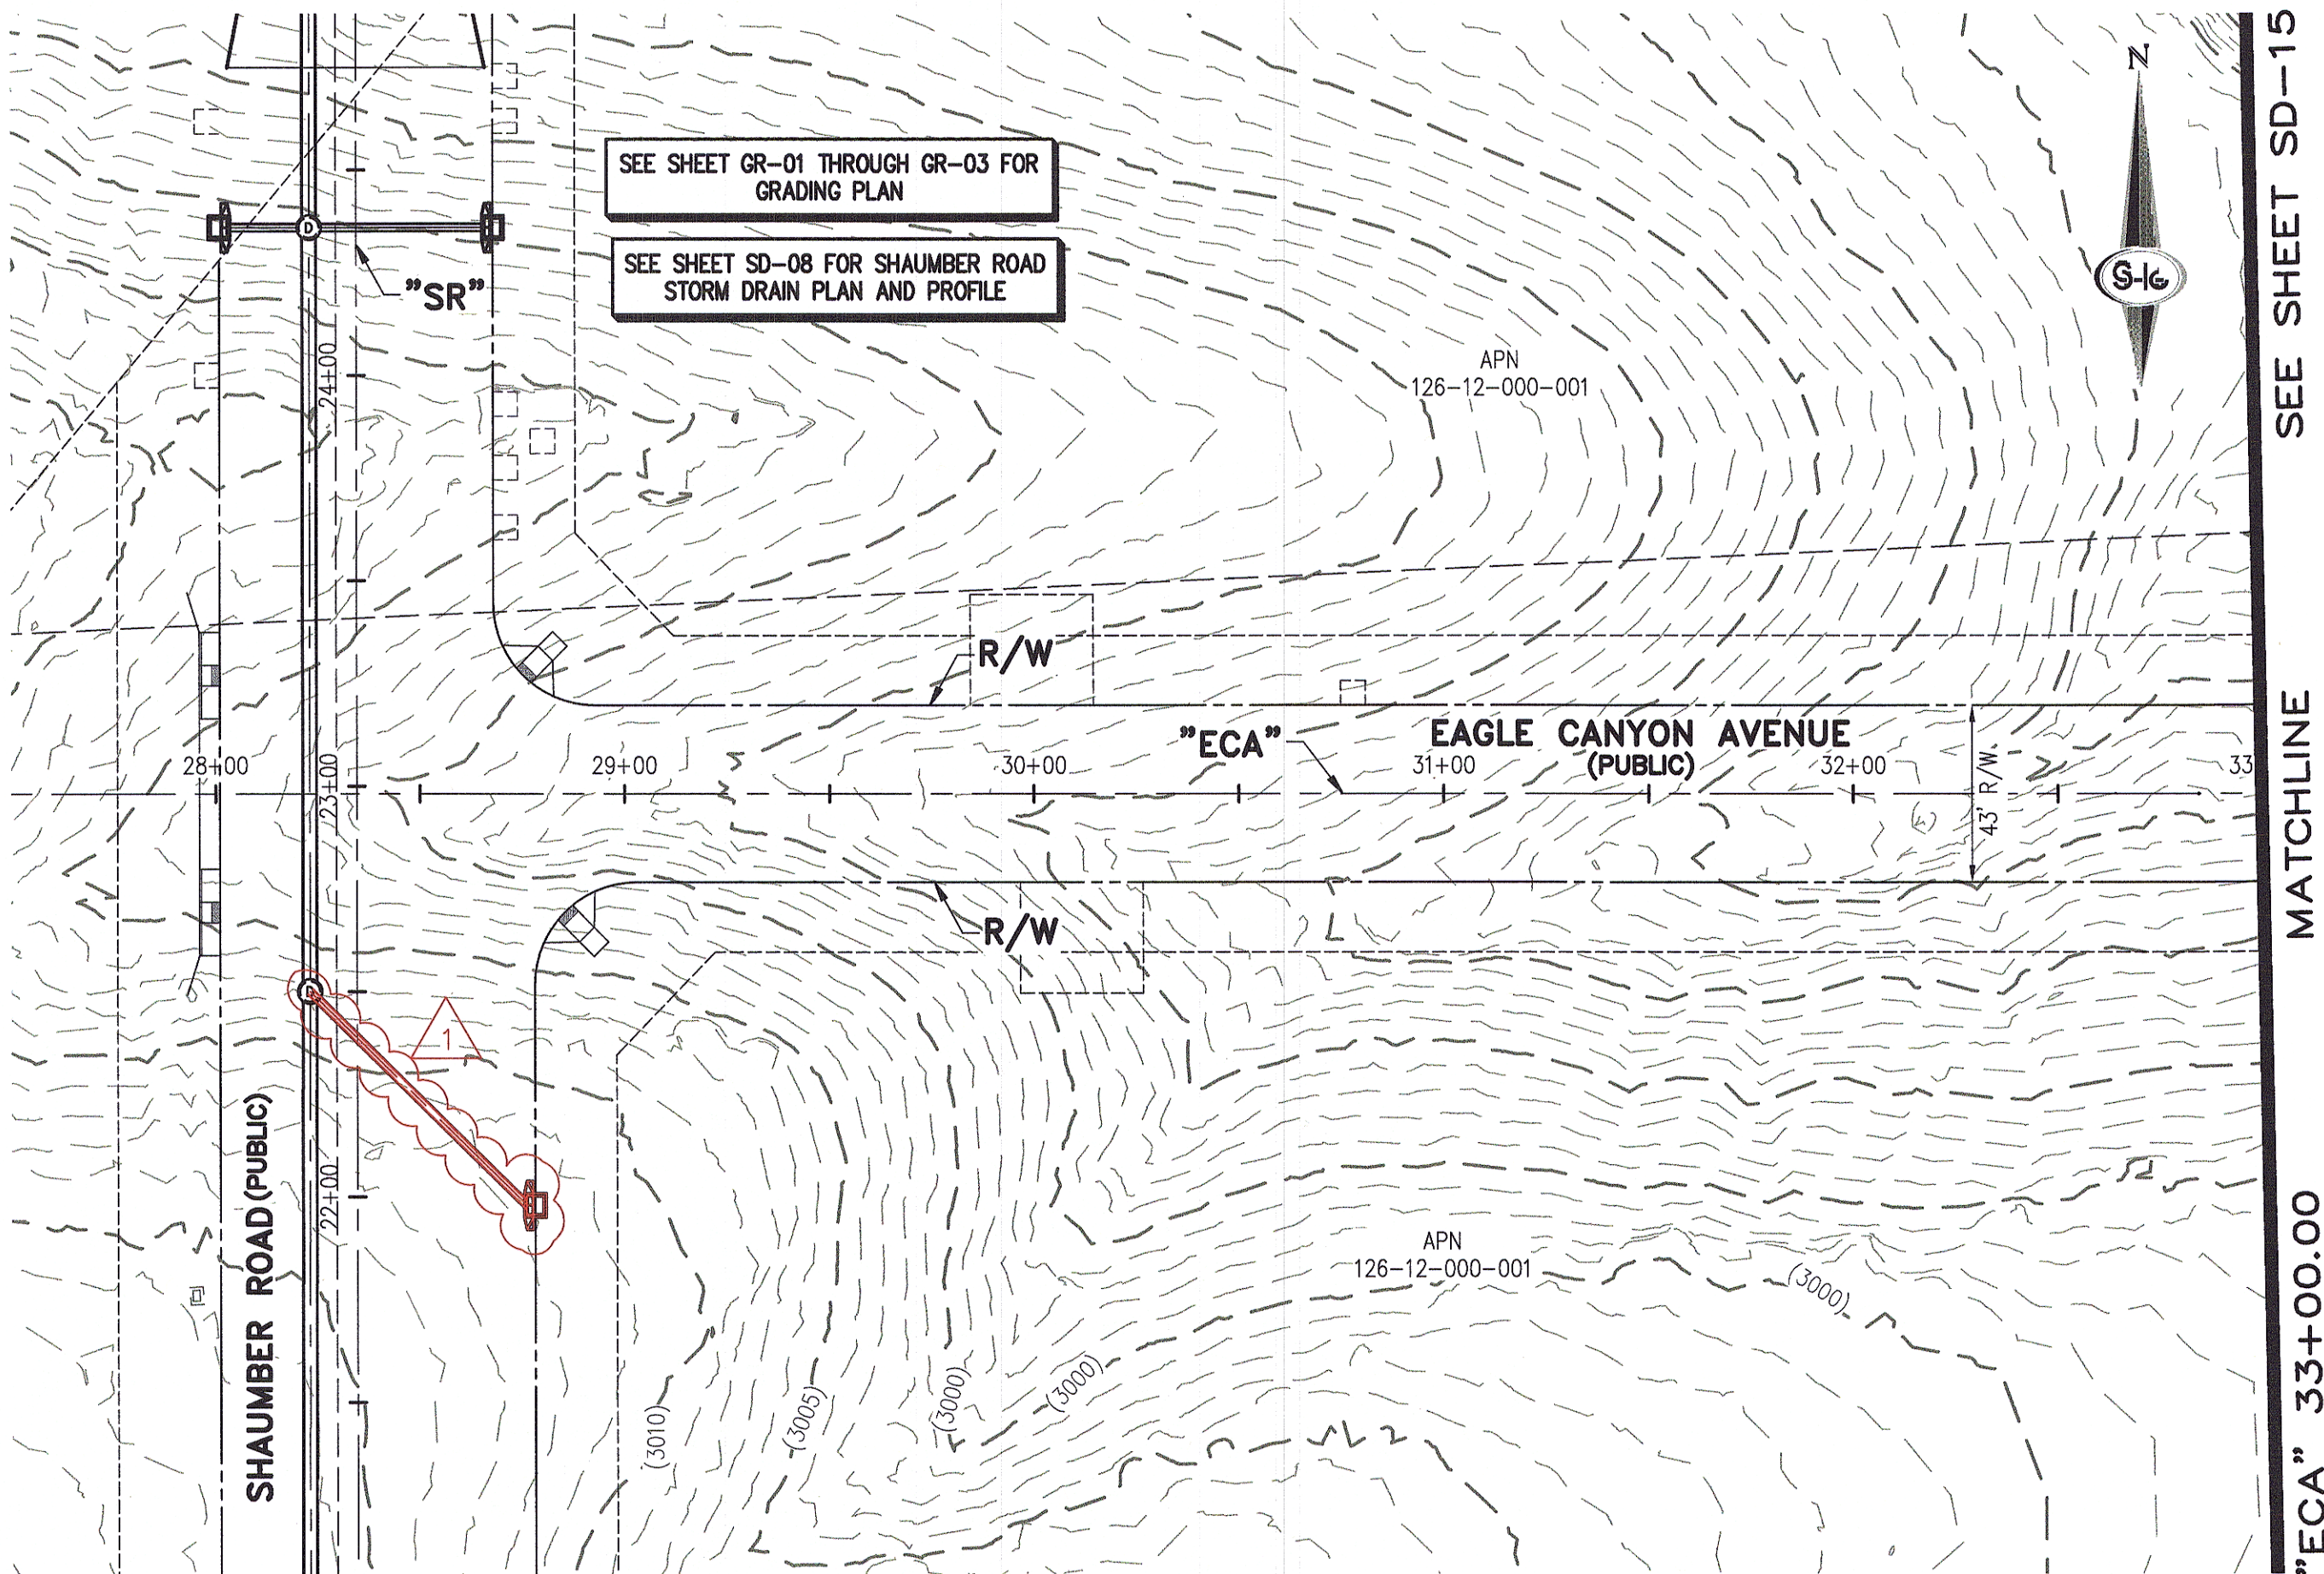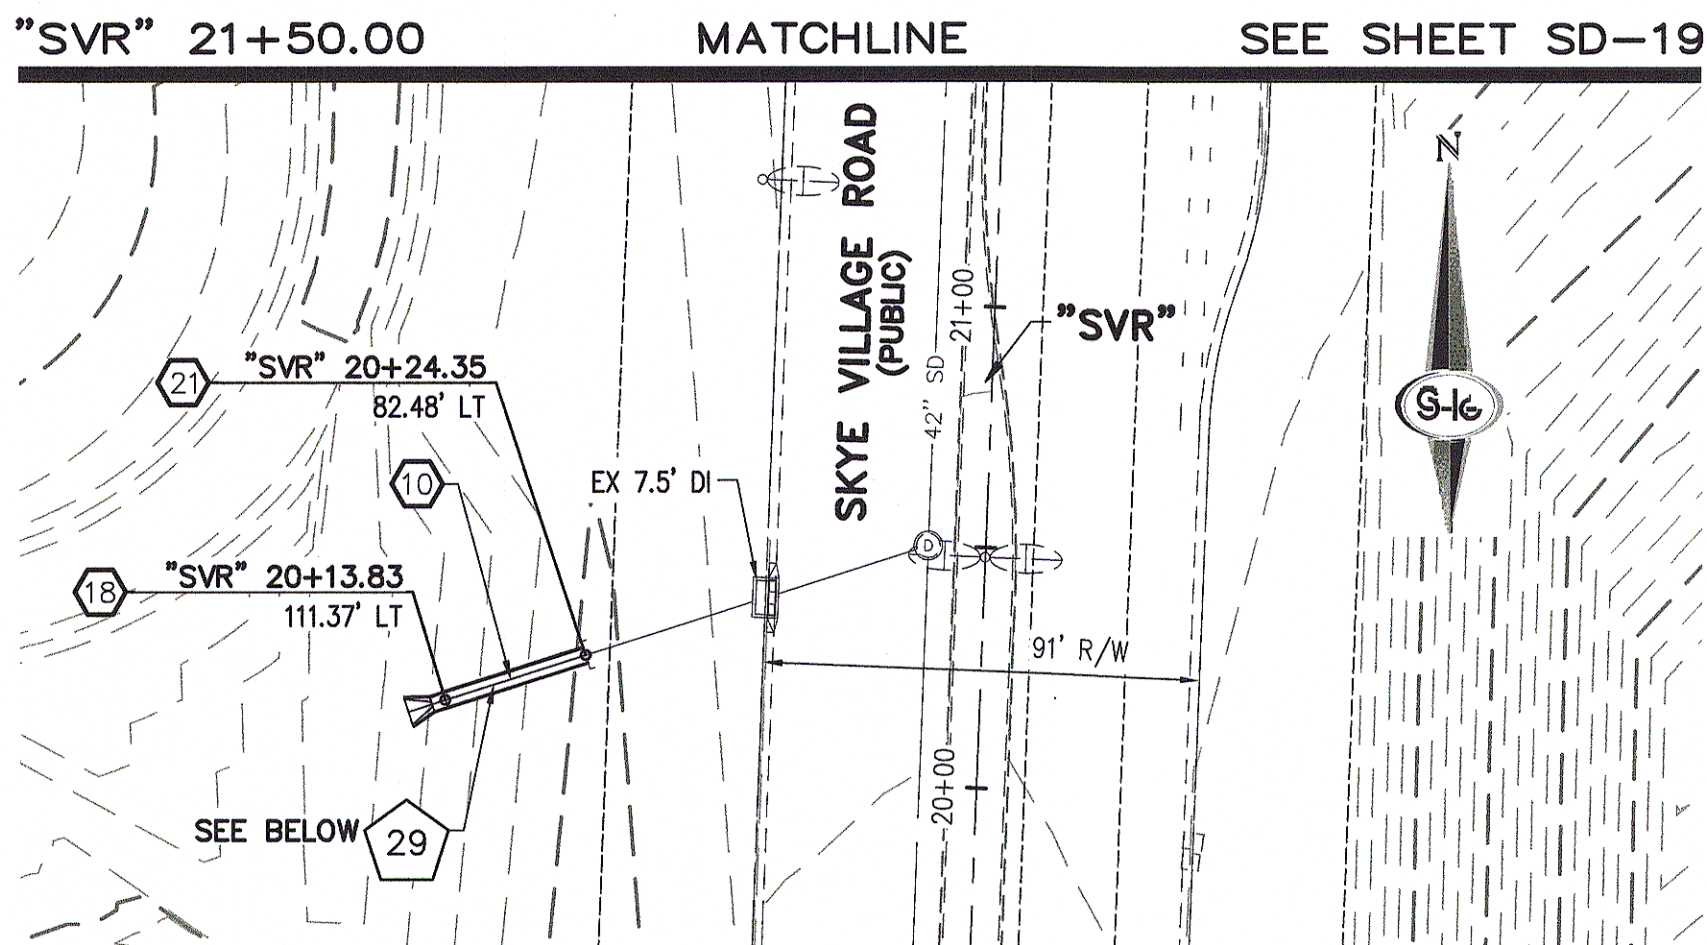

- ### STORM DRAIN NOTES
1. CONSTRUCT TYPE "CM2" DROP INLET (USDCCA STD. DWG. NO. 412.1)
 2. REMOVE EXISTING LATERAL STUB AND CONSTRUCT RCB PLUG (SEE DETAIL 5, DRAWING SD-25)
 3. CONSTRUCT 60" TYPE I MANHOLE (USDCCA STD. DWG. NO. 403.1)
 4. CONSTRUCT 60" TYPE III MANHOLE (USDCCA STD. DWG. NO. 406.1)
 5. CONSTRUCT 60" TYPE III MANHOLE WITH TYPE IA RISER (USDCCA STD. DWG. NO. 404.1 AND 406.1)
 6. CONSTRUCT NDOT TYPE 4 MANHOLE (NDOT STD. PLAN R-4.3.2)
 7. INSTALL 18" RCP OR WATER QUALITY C905 AS SHOWN ON PROFILES (USDCCA STD. DWG. NO. 503.2)
 8. INSTALL 24" RCP OR WATER QUALITY C905 AS SHOWN ON PROFILES (USDCCA STD. DWG. NO. 503.2)
 9. INSTALL 30" RCP (USDCCA STD. DWG. NO. 503.2)
 10. INSTALL 36" RCP (USDCCA STD. DWG. NO. 503.2)
 11. INSTALL 42" RCP (USDCCA STD. DWG. NO. 503.2)
 12. INSTALL 54" RCP (USDCCA STD. DWG. NO. 503.2)
 13. INSTALL 60" RCP (USDCCA STD. DWG. NO. 503.2)
 14. INSTALL 66" RCP (USDCCA STD. DWG. NO. 503.2)
 15. INSTALL 18" RCP END SECTION (NDOT STD. PLAN R-2.3.1)
 16. INSTALL 24" RCP END SECTION (NDOT STD. PLAN R-2.3.1)
 17. INSTALL 30" RCP END SECTION (NDOT STD. PLAN R-2.3.1)
 18. INSTALL 36" RCP END SECTION (NDOT STD. PLAN R-2.3.1)
 19. INSTALL 42" RCP END SECTION (NDOT STD. PLAN R-2.3.1)
 20. PIPE PENETRATION (SEE DETAIL 4, DRAWING SD-25)
 21. CONSTRUCT CONCRETE COLLAR (SEE DETAIL 2, DRAWING SD-25)
 22. CONSTRUCT BRICK AND MORTAR PLUG (SEE DETAIL 1, DRAWING SD-25)
 23. INSTALL 48" RCP (USDCCA STD. DWG. NO. 503.2)
 24. INSTALL 48" RCP END SECTION (NDOT STD. PLAN R-2.3.1)
 25. INSTALL DRIVEWAY (USDCCA STD. DWG. NO. 224)
 26. CONSTRUCT TYPE "CM" DROP INLET (USDCCA STD. DWG. NO. 422)

- ### NOTES
1. ALL RCP SHALL BE CLASS III UNLESS OTHERWISE SHOWN.
 2. ALL PIPE LENGTHS ARE MEASURED ALONG PIPE CENTERLINE TO CENTER OF MANHOLE OR INSIDE EDGE OF DI OR RCB/RCA.
 3. ALL DROP INLETS SHALL INCLUDE STORM WATER MANAGEMENT STAMP AND DETAIL PER USDCCA STD. DWG. NO. 421.
 4. SEE STRUCTURAL PLANS FOR ADDITIONAL STRUCTURAL DETAILS AND CONNECTIONS.
 5. ALL PIPES ARE PUBLICLY MAINTAINED.
 6. ADD SPECIAL INSPECTION REQUIRED FOR PIPE SEGMENTS WITH SACRIFICIAL CONCRETE.

APPROVED FOR CONSTRUCTION

LVVWD ENGINEERING SERVICES MANAGER PROJECT NO. 124568 DATE

DROP INLET NOTE

WHERE 10 FEET PARALLEL SEPARATION IS NOT PRACTICABLE, CAST-IN-PLACE MONOLITHIC POUR WITH WATERSTOP BETWEEN SLAB AND WALLS. BASE, WALLS AND TOP TO BE CONSTRUCTED WITH WATERSTOPS, CENTER BULB, OR FLAT STRIP (VINYLEX, GREENSTREAK PLASTIC PRODUCTS OR APPROVED EQUAL).

LEGEND


1 STORM DRAIN LATERAL # (SEE SHEETS SD-20 THRU SD-24)

FLOOD ZONE

THE PROJECT SITE IS LOCATED WITHIN A FEMA DESIGNATED ZONE "X" (OUTSIDE THE 500-YEAR FLOOD PLAIN) ON THE FLOOD INSURANCE RATE MAP (FIRM) PANEL:32003C1750E, DATED SEPTEMBER 27, 2002

NOTE:

PROPERTY OWNER IS RESPONSIBLE TO MAINTAIN THE BEST MANAGEMENT PRACTICES, SUCH AS BUT NOT LIMITED TO, THE REMOVAL OF ACCUMULATED SEDIMENT AND DEBRIS AND CARE OF VEGETATION.

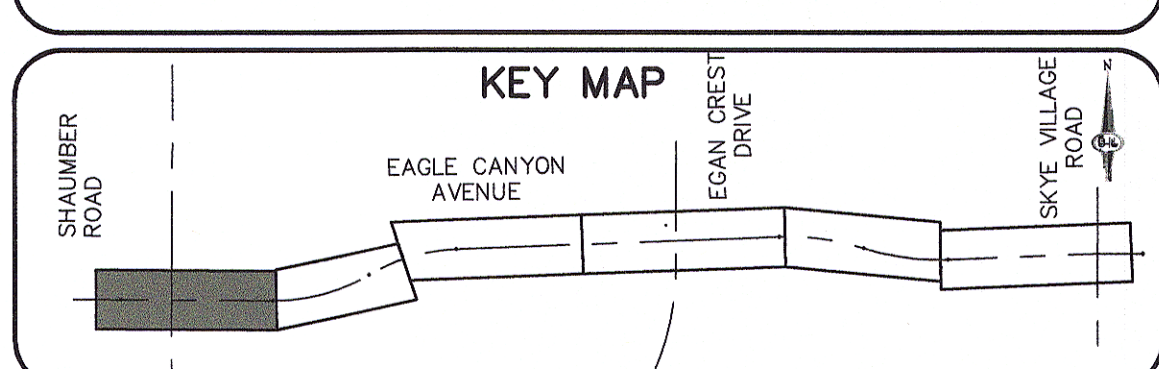

FAST

Call before you Dig

1-702-227-2929

811

Call before you Dig

1-800-227-2800

SLATER HANIFAN GROUP

CONSULTING ENGINEERS & PLANNERS

5740 S. ARVILLE STREET #216, LAS VEGAS, NV 89118

PHONE (702) 284-5300 FAX (702) 284-5399

NO.	DESCRIPTION	DATE	BY	APP.
1	REVISED STORM DRAIN	6/20/17	JAS	

NINETY-FIVE MANAGEMENT LLC

SKYE CANYON II PHASE 2 MASS GRADING

EAGLE CANYON AVENUE STORM DRAIN PLAN AND PROFILE

"ECA" 25+00.00 TO "ECA" 33+00.00

DATE: 8/3/16

DRAFTER: JAS



DESIGNER: DAM

CHECKED: JSR

PROJECT NO. OLY1501-001

SD-14

SHEET 17 OF 32

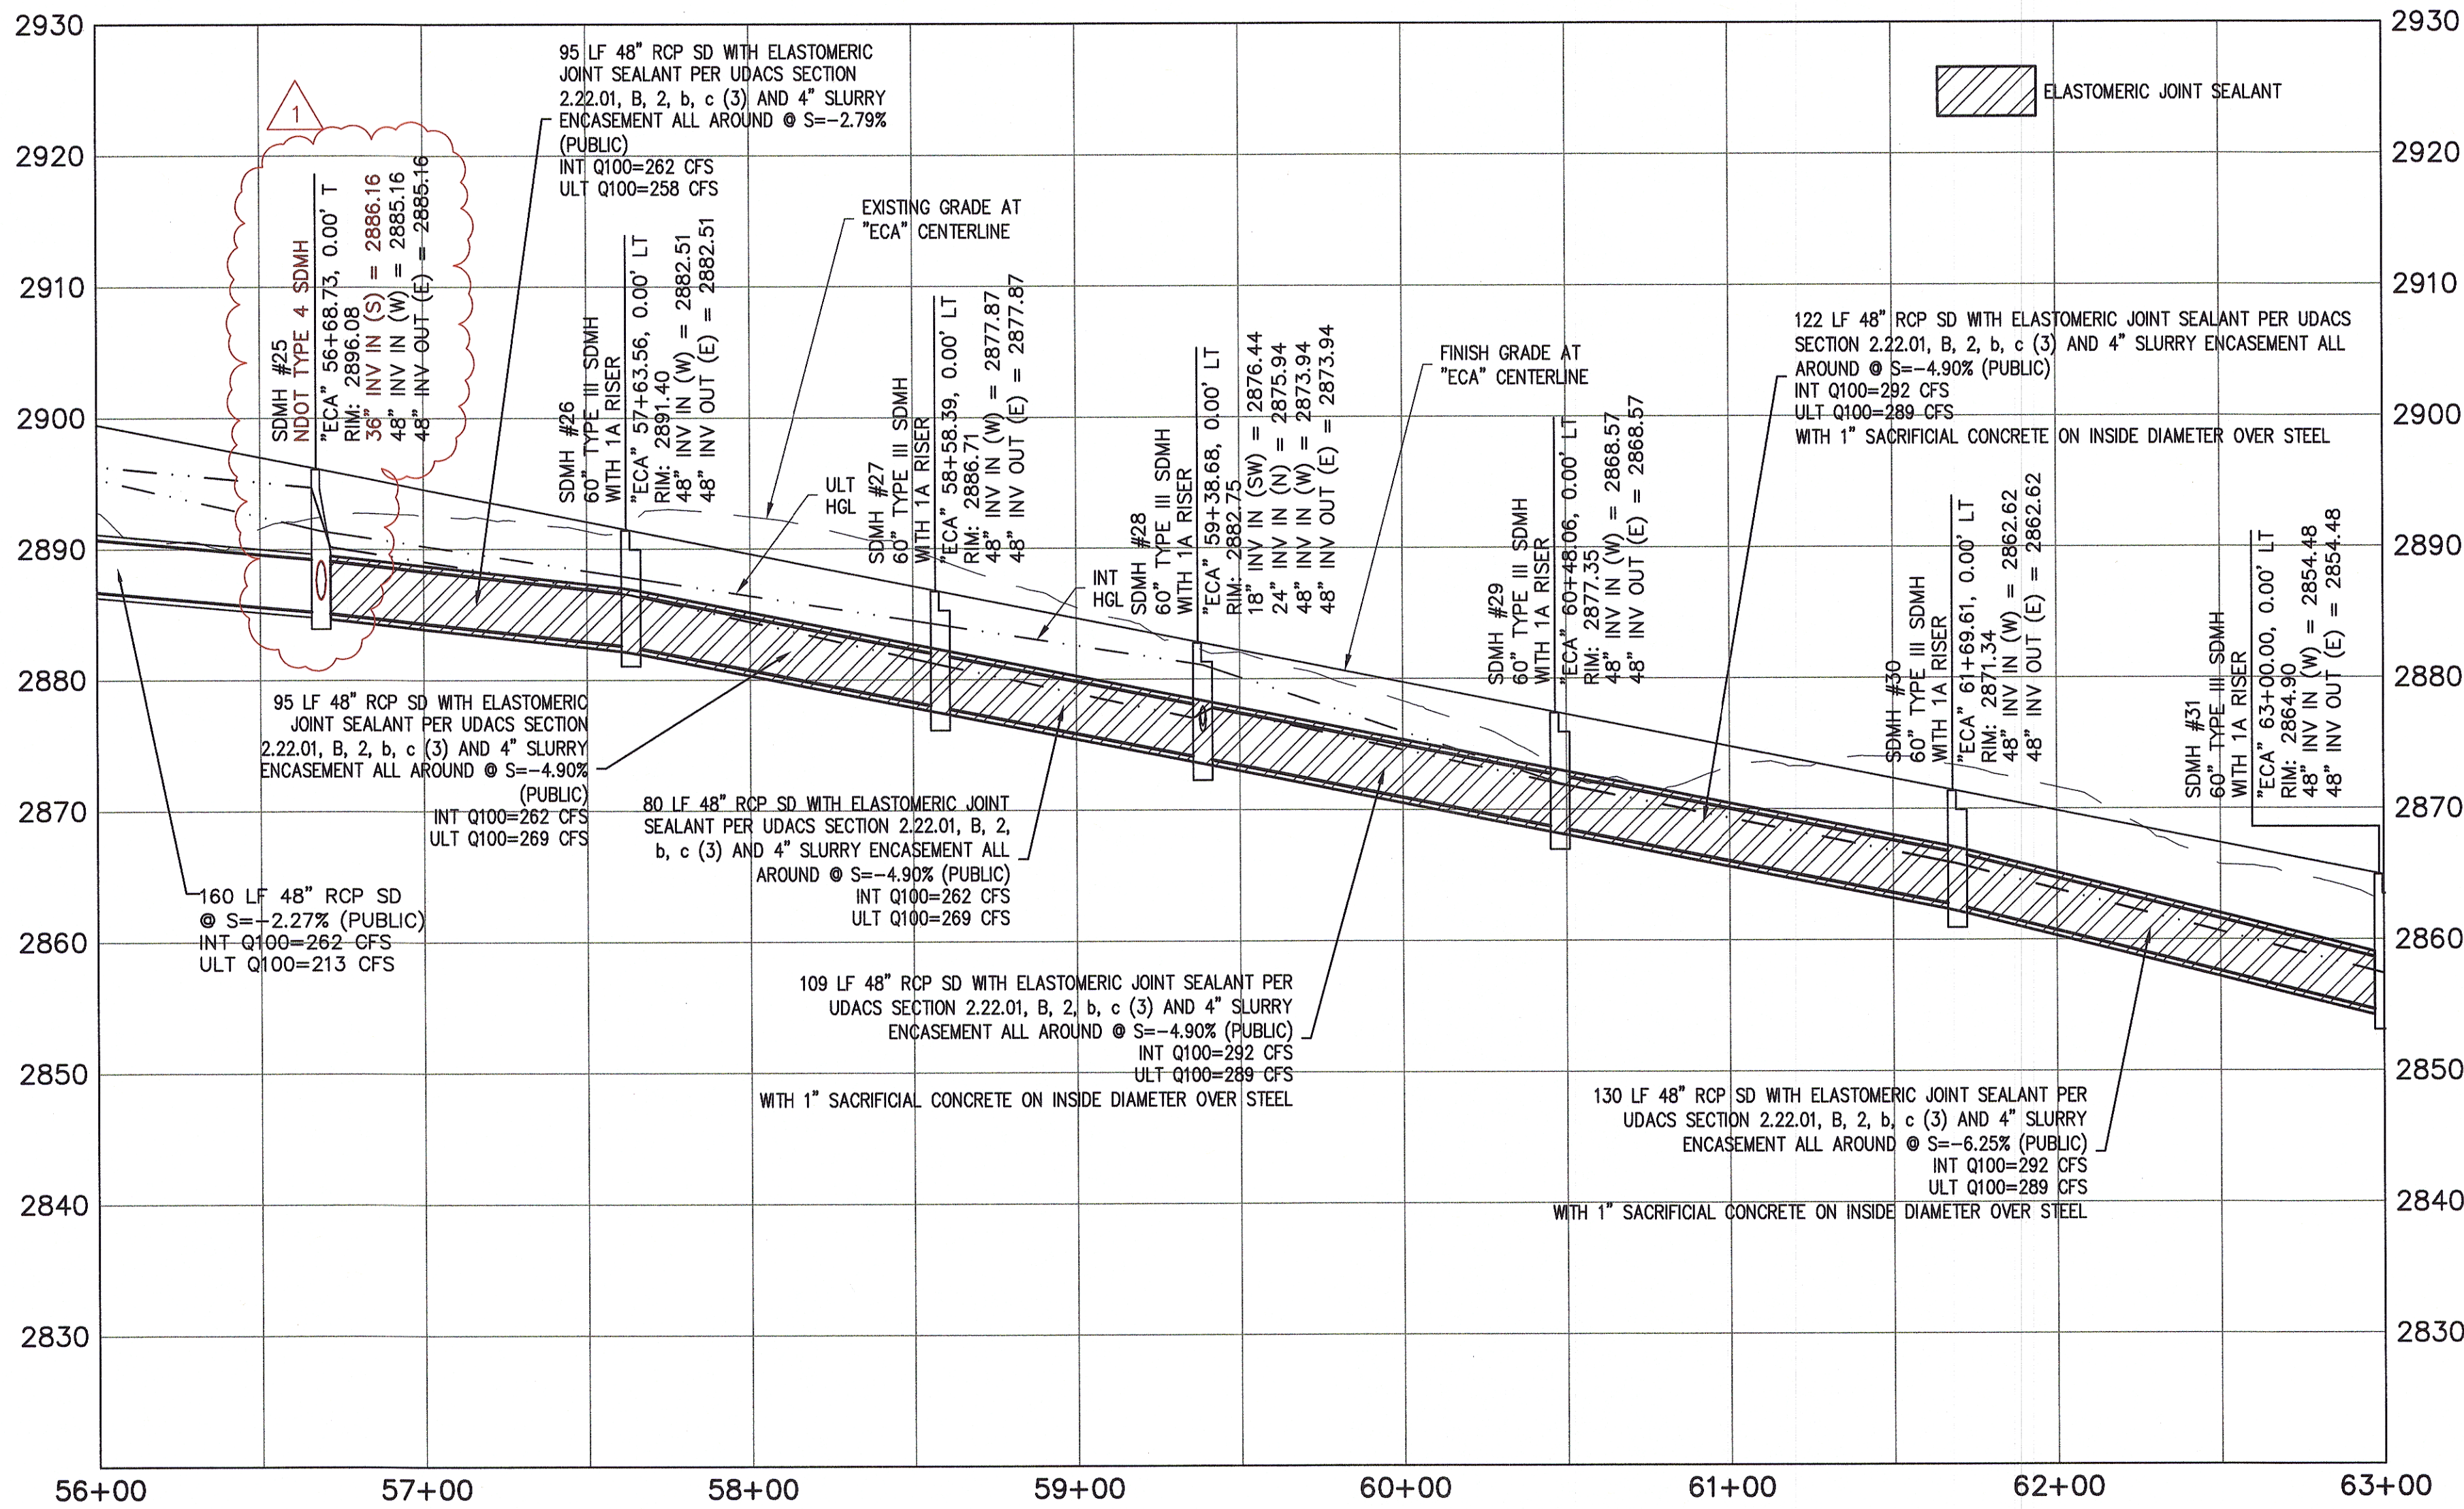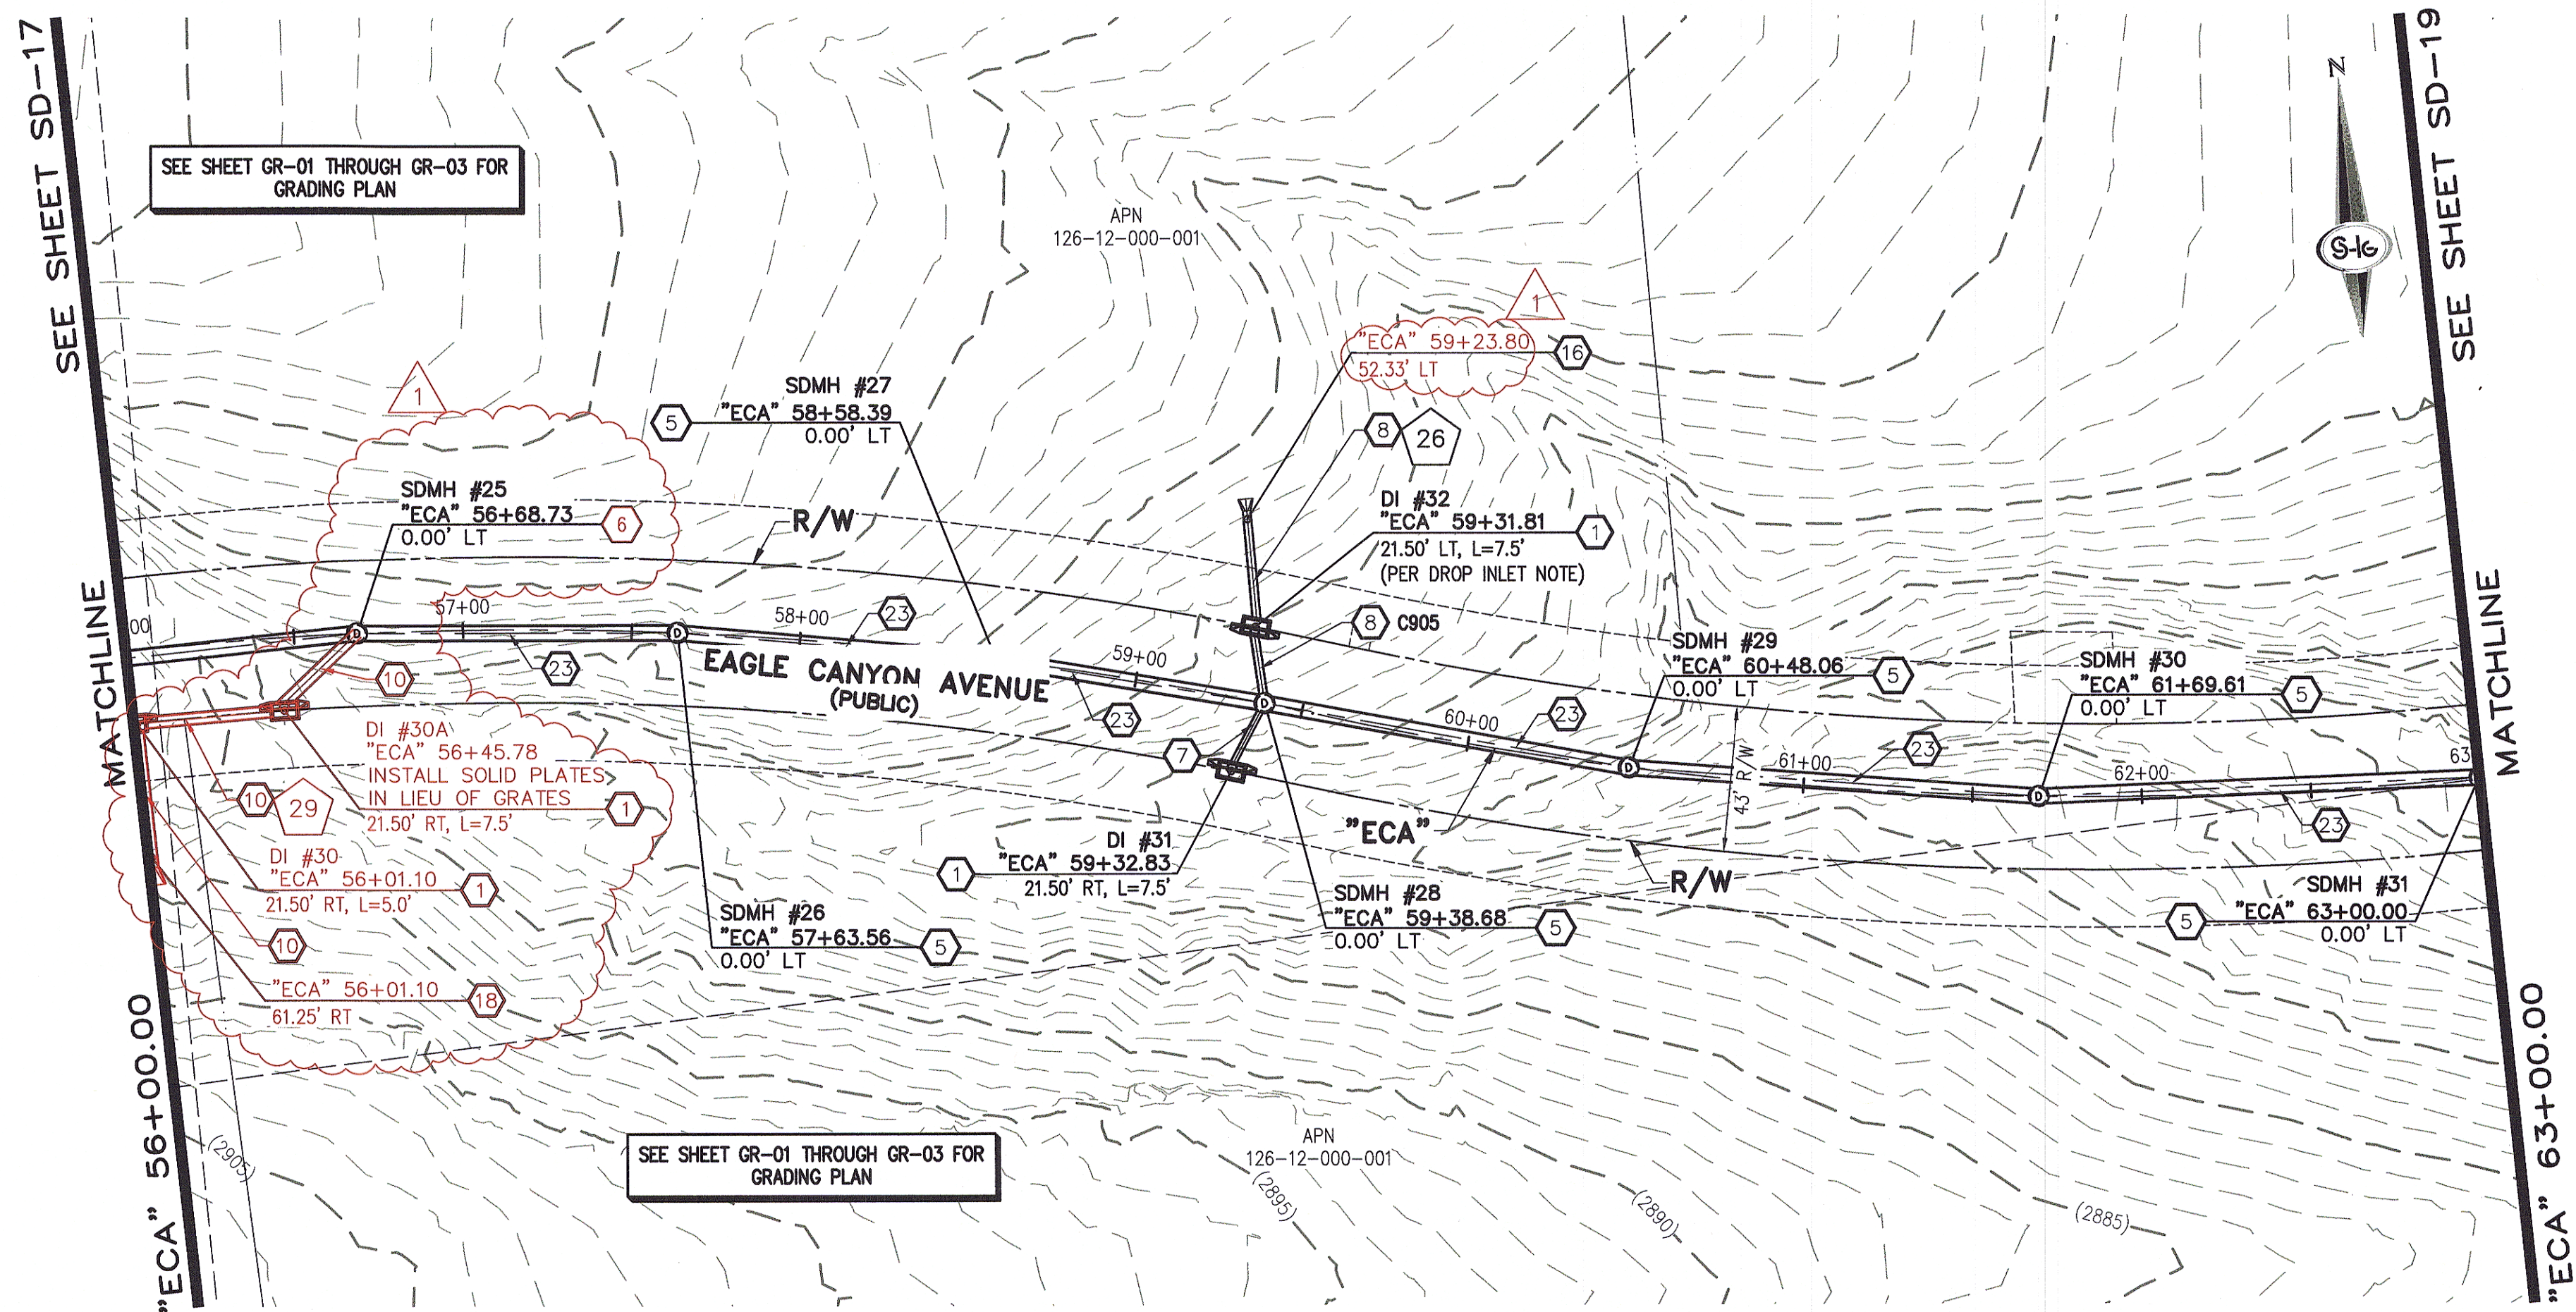

- ### STORM DRAIN NOTES
1. CONSTRUCT TYPE "CM2" DROP INLET (USDCCA STD. DWG. NO. 412.1)
 2. REMOVE EXISTING LATERAL STUB AND CONSTRUCT RCB PLUG (SEE DETAIL 5, DRAWING SD-25)
 3. CONSTRUCT 60" TYPE I MANHOLE (USDCCA STD. DWG. NO. 403.1)
 4. CONSTRUCT 60" TYPE III MANHOLE (USDCCA STD. DWG. NO. 406.1)
 5. CONSTRUCT 60" TYPE III MANHOLE WITH TYPE IA RISER (USDCCA STD. DWG. NO. 404.1 AND 406.1)
 6. CONSTRUCT NDOT TYPE 4 MANHOLE (NDOT STD. PLAN R-4.3.2)
 7. INSTALL 18" RCP OR WATER QUALITY C905 AS SHOWN ON PROFILES (USDCCA STD. DWG. NO. 503.2)
 8. INSTALL 24" RCP OR WATER QUALITY C905 AS SHOWN ON PROFILES (USDCCA STD. DWG. NO. 503.2)
 9. INSTALL 30" RCP (USDCCA STD. DWG. NO. 503.2)
 10. INSTALL 36" RCP (USDCCA STD. DWG. NO. 503.2)
 11. INSTALL 42" RCP (USDCCA STD. DWG. NO. 503.2)
 12. INSTALL 54" RCP (USDCCA STD. DWG. NO. 503.2)
 13. INSTALL 60" RCP (USDCCA STD. DWG. NO. 503.2)
 14. INSTALL 66" RCP (USDCCA STD. DWG. NO. 503.2)
 15. INSTALL 18" RCP END SECTION (NDOT STD. PLAN R-2.3.1)
 16. INSTALL 24" RCP END SECTION (NDOT STD. PLAN R-2.3.1)
 17. INSTALL 30" RCP END SECTION (NDOT STD. PLAN R-2.3.1)
 18. INSTALL 36" RCP END SECTION (NDOT STD. PLAN R-2.3.1)
 19. INSTALL 42" RCP END SECTION (NDOT STD. PLAN R-2.3.1)
 20. PIPE PENETRATION (SEE DETAIL 4, DRAWING SD-25)
 21. CONSTRUCT CONCRETE COLLAR (SEE DETAIL 2, DRAWING SD-25)
 22. CONSTRUCT BRICK AND MORTAR PLUG (SEE DETAIL 1, DRAWING SD-25)
 23. INSTALL 48" RCP (USDCCA STD. DWG. NO. 503.2)
 24. INSTALL 48" RCP END SECTION (NDOT STD. PLAN R-2.3.1)
 25. INSTALL DRIVEWAY (USDCCA STD. DWG. NO. 224)
 26. CONSTRUCT TYPE "CM" DROP INLET (USDCCA STD. DWG. NO. 422)

- ### NOTES
1. ALL RCP SHALL BE CLASS III UNLESS OTHERWISE SHOWN.
 2. ALL PIPE LENGTHS ARE MEASURED ALONG PIPE CENTERLINE TO CENTER OF MANHOLE OR INSIDE EDGE OF DI OR RCB/RCA.
 3. ALL DROP INLETS SHALL INCLUDE STORM WATER MANAGEMENT STAMP AND DETAIL PER USDCCA STD. DWG. NO. 421.
 4. SEE STRUCTURAL PLANS FOR ADDITIONAL STRUCTURAL DETAILS AND CONNECTIONS.
 5. ALL PIPES ARE PUBLICLY MAINTAINED.
 6. ADD SPECIAL INSPECTION REQUIRED FOR PIPE SEGMENTS WITH SACRIFICIAL CONCRETE.

APPROVED FOR CONSTRUCTION
LYVWD WILL HAVE TO BE PRESENT AND VIEW INSTALLATION OF STORM DRAIN THAT WILL BE INSTALLED THAT MAY AFFECT THE WATER MAINS

LYVWD ENGINEERING SERVICES MANAGER _____ DATE _____
PROJECT NO. 124568

DROP INLET NOTE
WHERE 10 FEET PARALLEL SEPARATION IS NOT PRACTICABLE:
CAST-IN-PLACE MONOLITHIC POUR WITH WATERSTOP BETWEEN SLAB AND WALLS. BASE, WALLS AND TOP TO BE CONSTRUCTED WITH WATERSTOPS, CENTER BULB, OR FLAT STRIP (VINYLEX, GREENSTREAK PLASTIC PRODUCTS OR APPROVED EQUAL).

LEGEND


1 STORM DRAIN LATERAL # (SEE SHEETS SD-20 THRU SD-24)

I CERTIFY THAT THIS GRADING PLAN IS IN CONFORMANCE WITH THE APPROVED TECHNICAL DRAINAGE STUDY DS-4739A ON FILE AT THE CITY OF LAS VEGAS FOR THE SUBJECT PROJECT

JERRY SLATER, P.E. 14167 _____ DATE _____

FLOOD ZONE
THE PROJECT SITE IS LOCATED WITHIN A FEMA DESIGNATED ZONE "X" (OUTSIDE THE 500-YEAR FLOOD PLAIN) ON THE FLOOD INSURANCE RATE MAP (FIRM) PANEL 32003C1750C, DATED SEPTEMBER 27, 2002

NOTE:
PROPERTY OWNER IS RESPONSIBLE TO MAINTAIN THE BEST MANAGEMENT PRACTICES, SUCH AS BUT NOT LIMITED TO, THE REMOVAL OF ACCUMULATED SEDIMENT AND DEBRIS AND CARE OF VEGETATION.

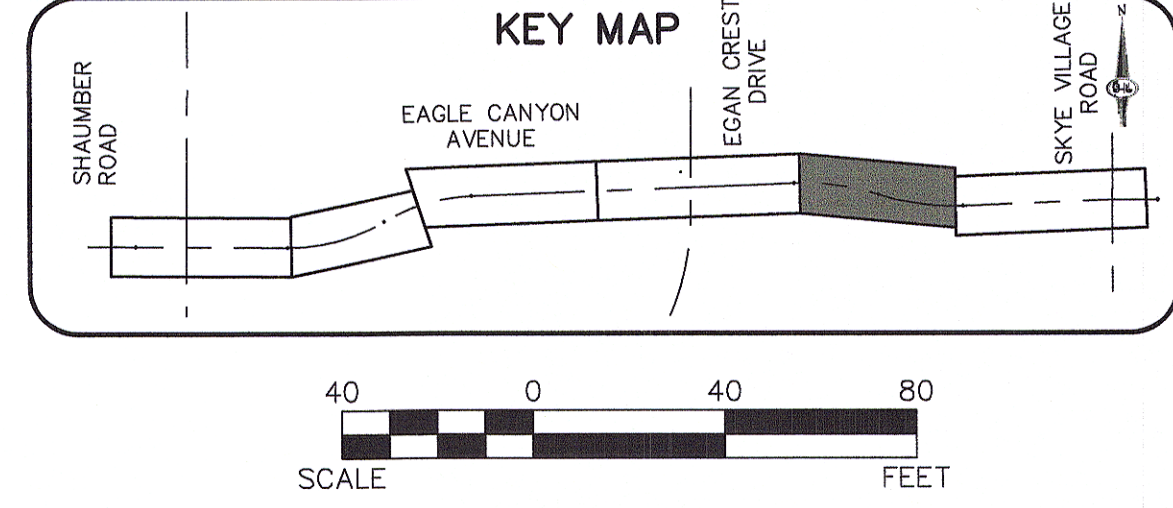

1-702-227-2929

Call before you dig
Underground.
1-702-482-5300

Call before you dig
1-800-227-2800



SLATER HANIFAN GROUP
CONSULTING ENGINEERS & PLANNERS
5740 S. ARVILLE STREET #216, LAS VEGAS, NV 89118
PHONE (702) 284-5300 FAX (702) 284-5399

NINETY-FIVE MANAGEMENT LLC

SKYE CANYON II PHASE 2 MASS GRADING
EAGLE CANYON AVENUE PLAN AND PROFILE
"ECA" 56+00.00 TO "ECA" 63+00.00

DATE: 8/3/16
DRAFTER: JAS
DESIGNER: DAM
CHECKED: JSR
PROJECT NO. **OLY1501-001**

SD-18
SHEET 21 OF 32

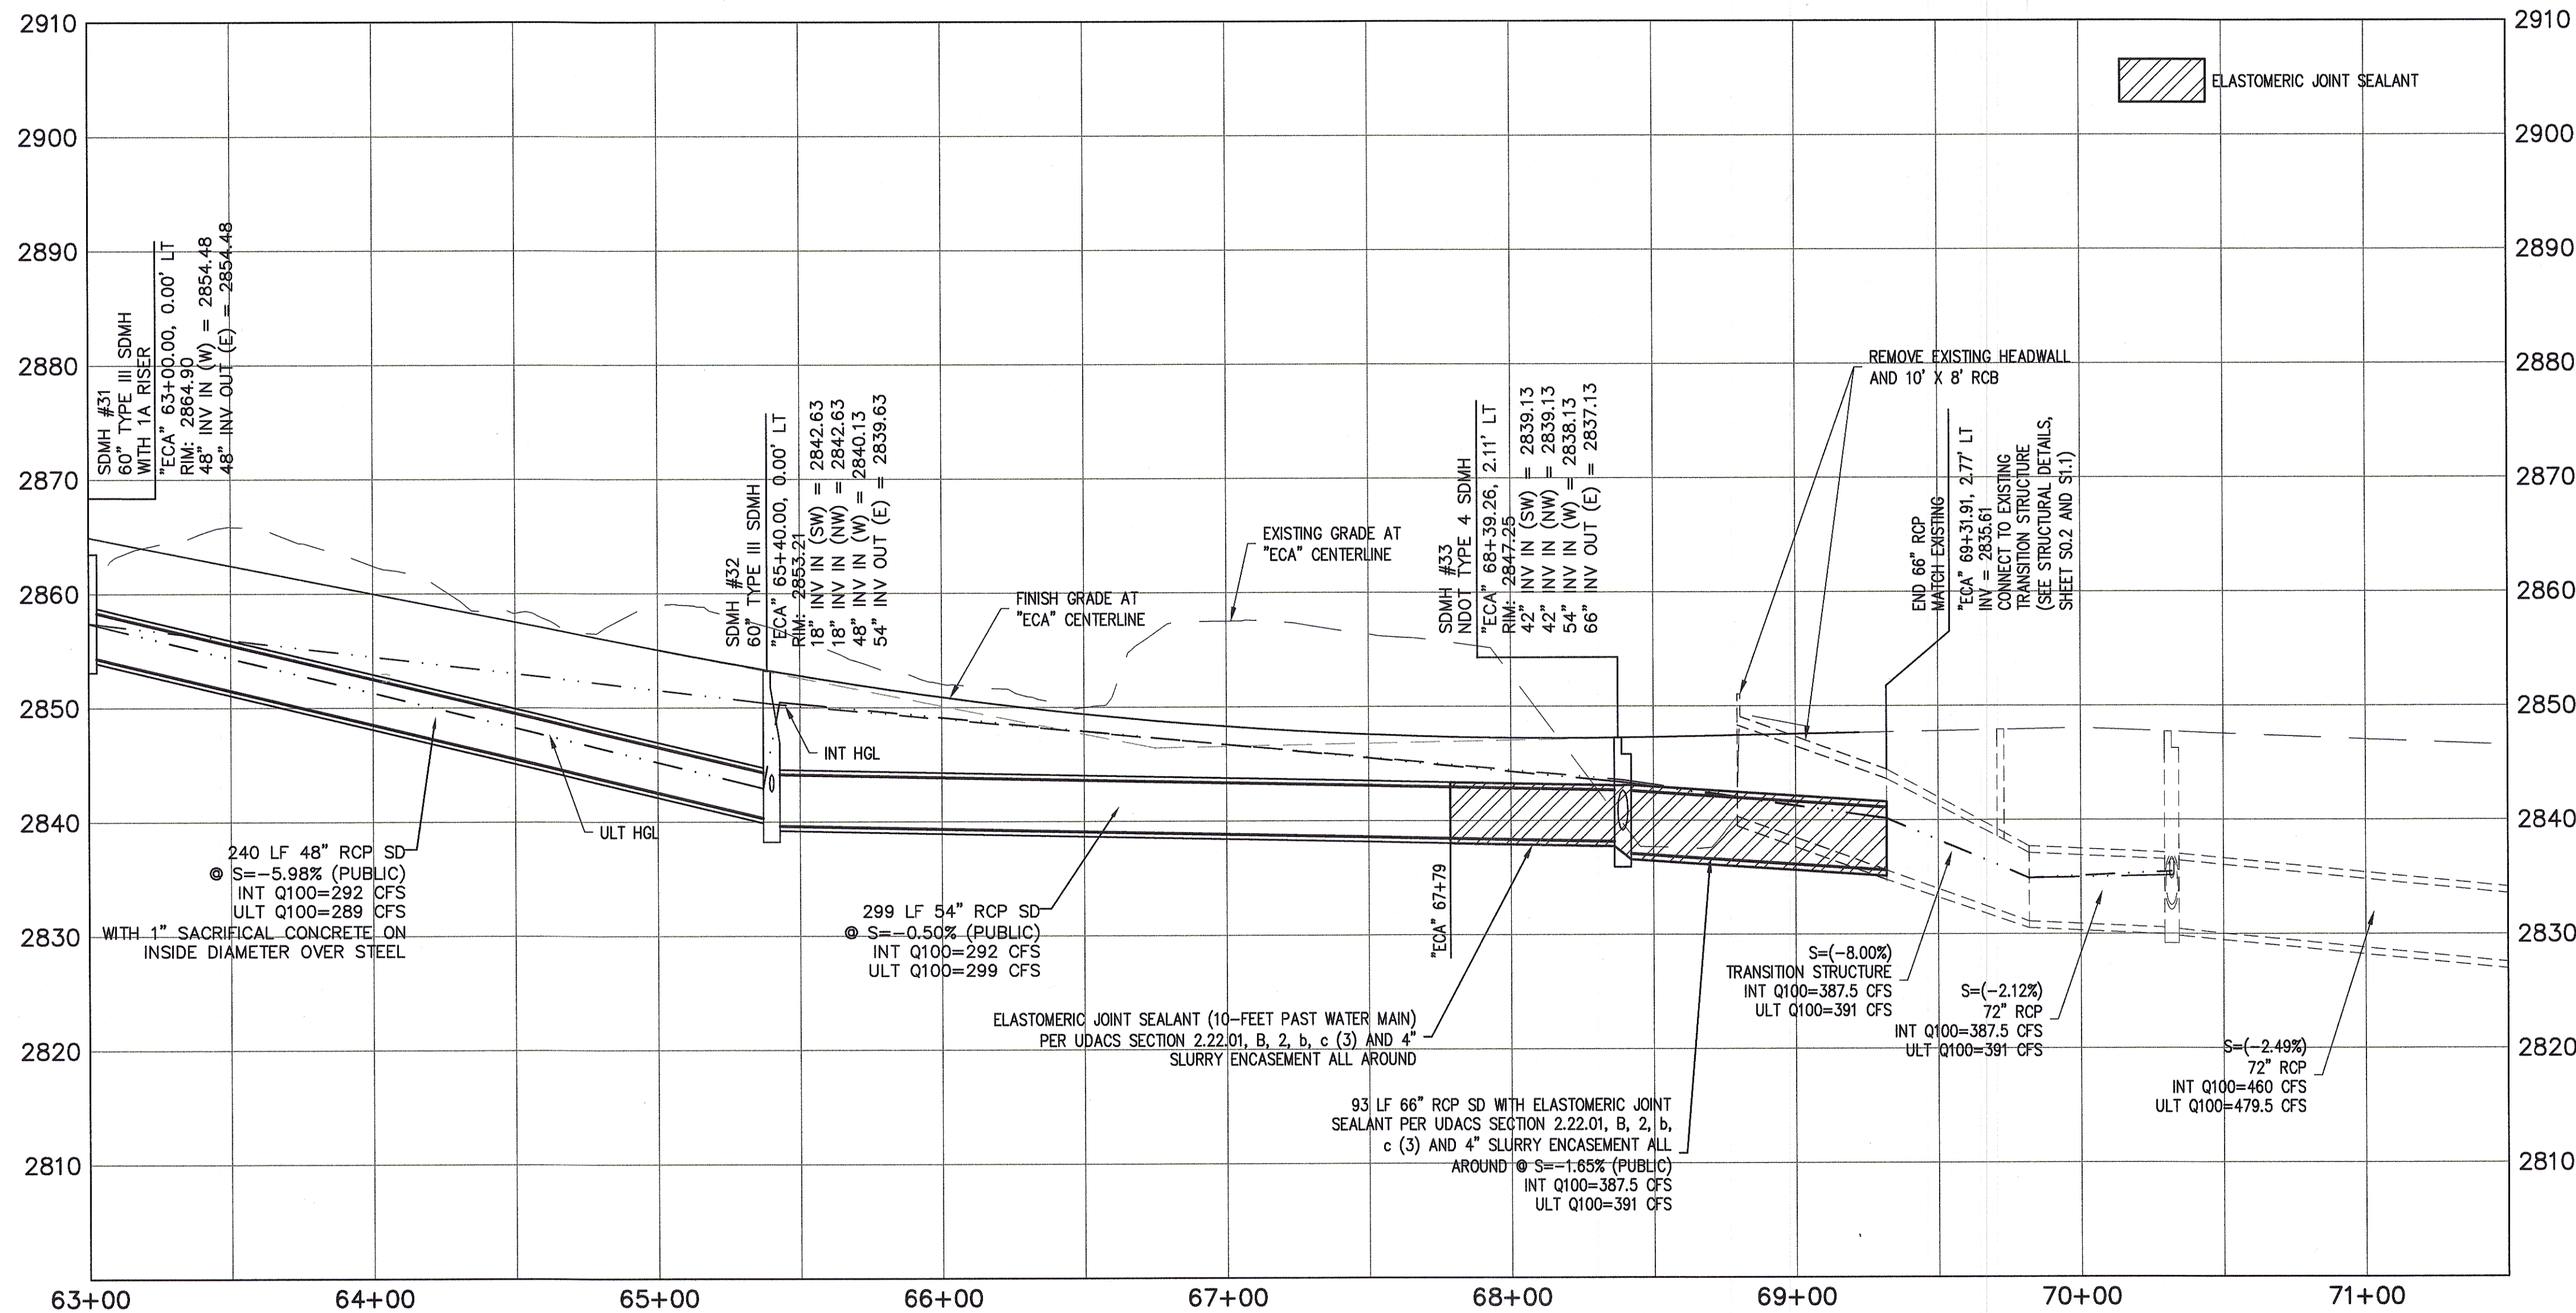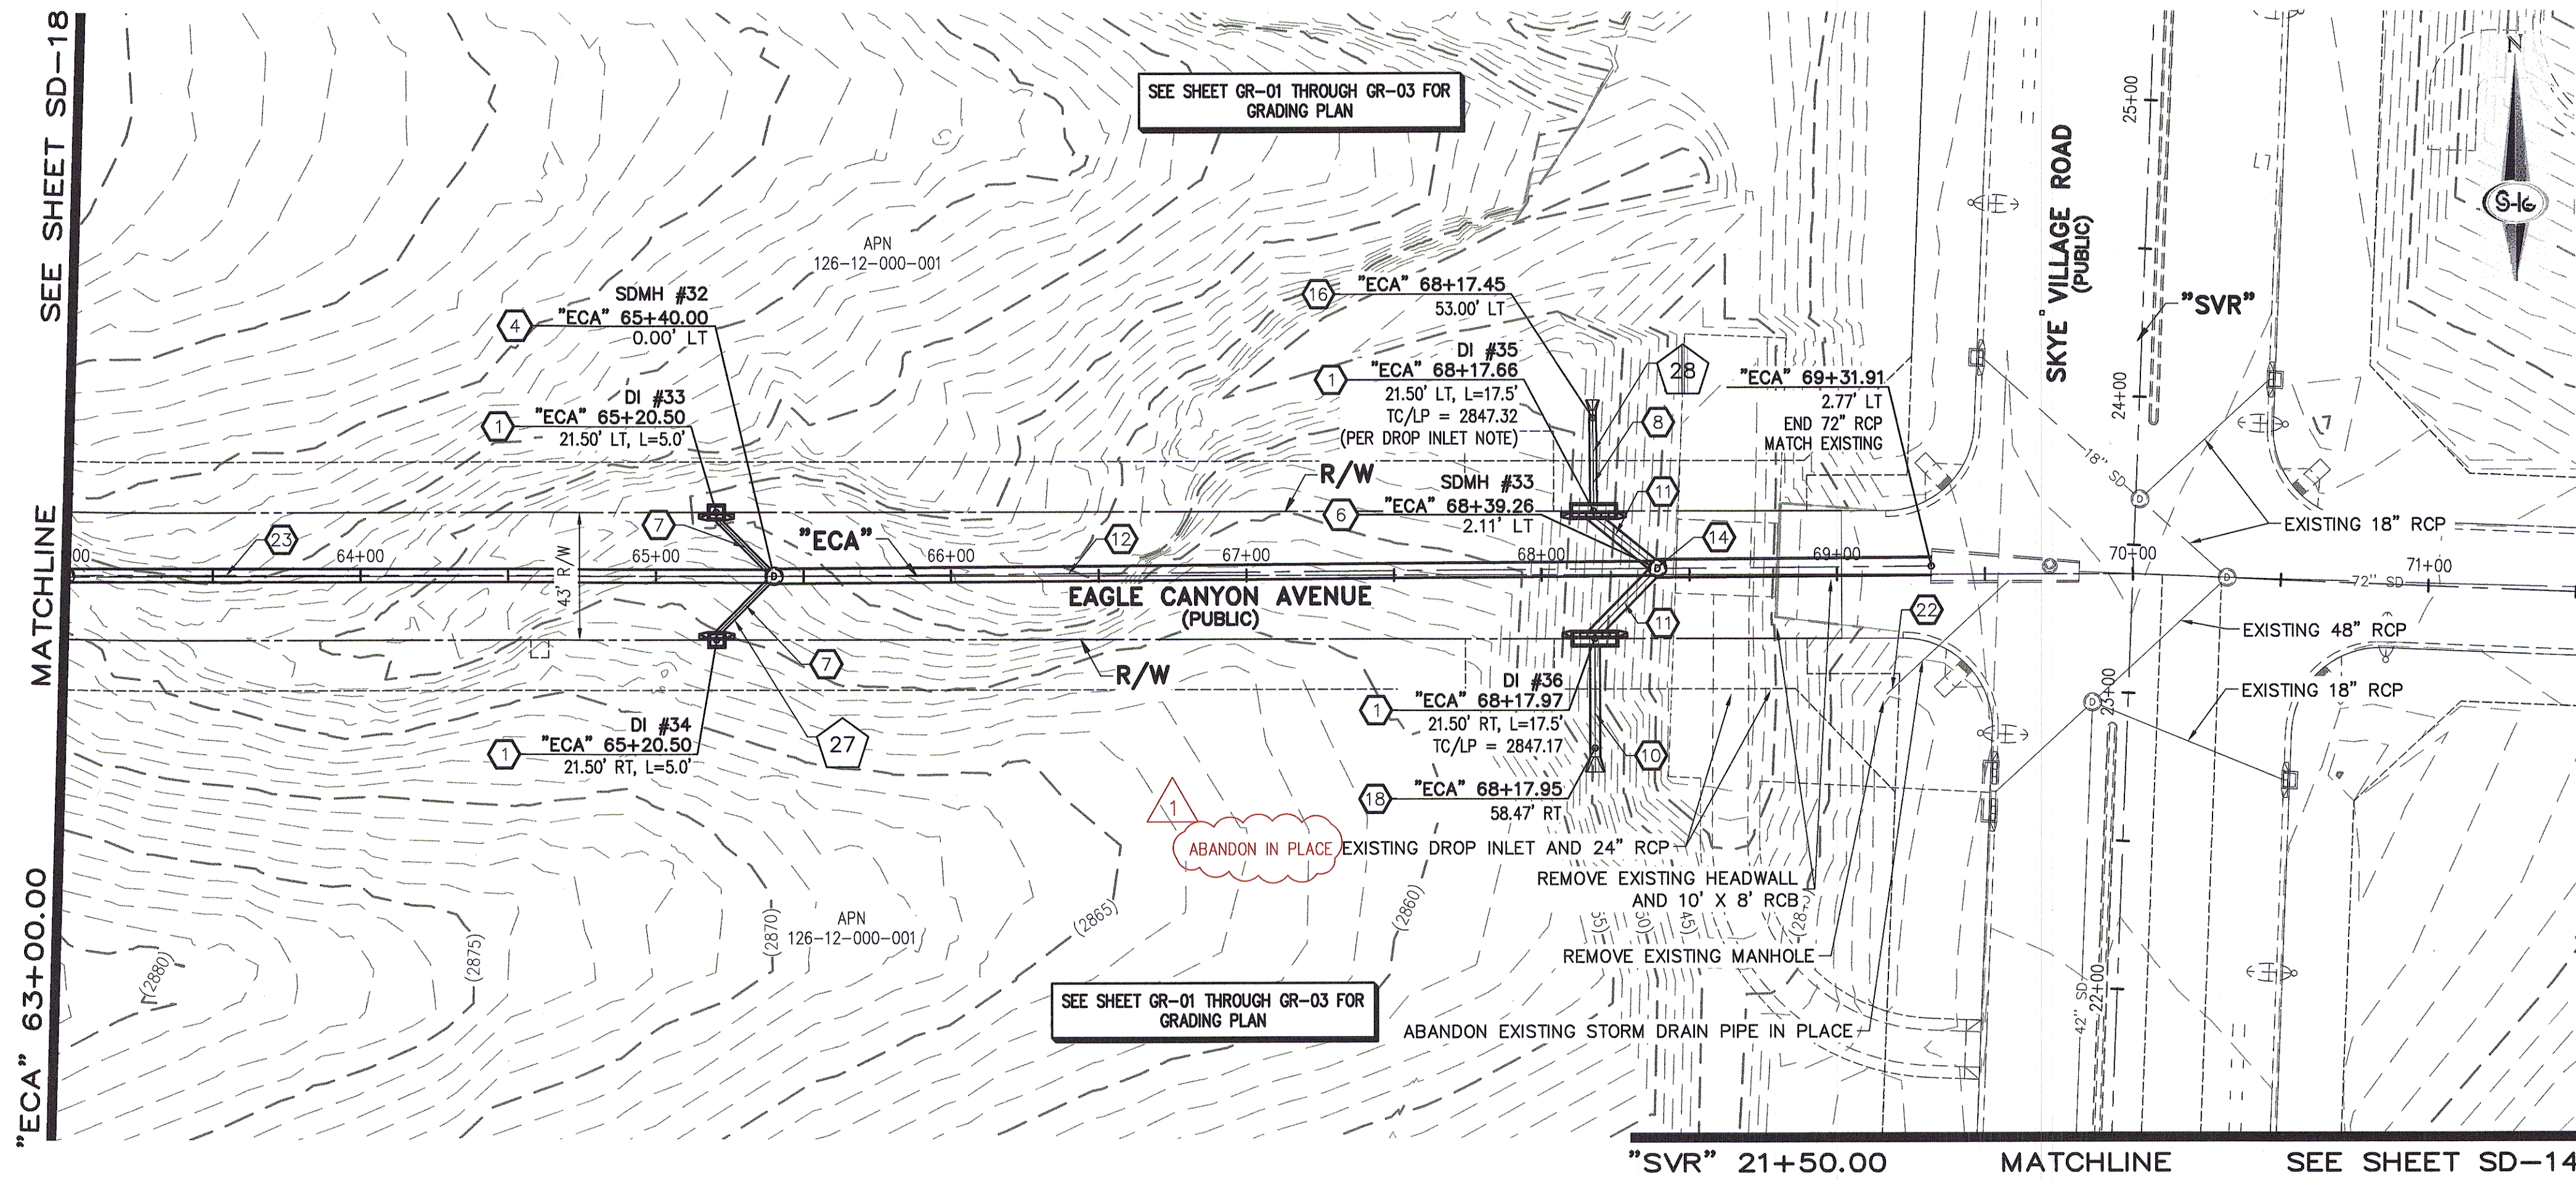

STORM DRAIN NOTES

1. CONSTRUCT TYPE "CM2" DROP INLET (USDCCA STD. DWG. NO. 412.1)
2. REMOVE EXISTING LATERAL STUB AND CONSTRUCT RCB PLUG (SEE DETAIL 5, DRAWING SD-25)
3. CONSTRUCT 60" TYPE I MANHOLE (USDCCA STD. DWG. NO. 403.1)
4. CONSTRUCT 60" TYPE III MANHOLE (USDCCA STD. DWG. NO. 406.1)
5. CONSTRUCT 60" TYPE III MANHOLE WITH TYPE IA RISER (USDCCA STD. DWG. NO. 404.1 AND 406.1)
6. CONSTRUCT NDOT TYPE 4 MANHOLE (NDOT STD. PLAN R-4.3.2)
7. INSTALL 18" RCP OR WATER QUALITY C905 AS SHOWN ON PROFILES (USDCCA STD. DWG. NO. 503.2)
8. INSTALL 24" RCP OR WATER QUALITY C905 AS SHOWN ON PROFILES (USDCCA STD. DWG. NO. 503.2)
9. INSTALL 30" RCP (USDCCA STD. DWG. NO. 503.2)
10. INSTALL 36" RCP (USDCCA STD. DWG. NO. 503.2)
11. INSTALL 42" RCP (USDCCA STD. DWG. NO. 503.2)
12. INSTALL 54" RCP (USDCCA STD. DWG. NO. 503.2)
13. INSTALL 60" RCP (USDCCA STD. DWG. NO. 503.2)
14. INSTALL 66" RCP (USDCCA STD. DWG. NO. 503.2)
15. INSTALL 18" RCP END SECTION (NDOT STD. PLAN R-2.3.1)
16. INSTALL 24" RCP END SECTION (NDOT STD. PLAN R-2.3.1)
17. INSTALL 30" RCP END SECTION (NDOT STD. PLAN R-2.3.1)
18. INSTALL 36" RCP END SECTION (NDOT STD. PLAN R-2.3.1)
19. INSTALL 42" RCP END SECTION (NDOT STD. PLAN R-2.3.1)
20. PIPE PENETRATION (SEE DETAIL 4, DRAWING SD-25)
21. CONSTRUCT CONCRETE COLLAR (SEE DETAIL 2, DRAWING SD-25)
22. CONSTRUCT BRICK AND MORTAR PLUG (SEE DETAIL 1, DRAWING SD-25)
23. INSTALL 48" RCP (USDCCA STD. DWG. NO. 503.2)
24. INSTALL 48" RCP END SECTION (NDOT STD. PLAN R-2.3.1)
25. INSTALL DRIVEWAY (USDCCA STD. DWG. NO. 224)
26. CONSTRUCT TYPE "CM" DROP INLET (USDCCA STD. DWG. NO. 422)

NOTES

1. ALL RCP SHALL BE CLASS III UNLESS OTHERWISE SHOWN.
2. ALL PIPE LENGTHS ARE MEASURED ALONG PIPE CENTERLINE TO CENTER OF MANHOLE OR INSIDE EDGE OF DI OR RCB/RCA.
3. ALL DROP INLETS SHALL INCLUDE STORM WATER MANAGEMENT STAMP AND DETAIL PER USDCCA STD. DWG. NO. 421.
4. SEE STRUCTURAL PLANS FOR ADDITIONAL STRUCTURAL DETAILS AND CONNECTIONS.
5. ALL PIPES ARE PUBLICLY MAINTAINED.
6. ADD SPECIAL INSPECTION REQUIRED FOR PIPE SEGMENTS WITH SACRIFICIAL CONCRETE.

APPROVED FOR CONSTRUCTION

LYVMD WILL HAVE TO BE PRESENT AND VIEW INSTALLATION OF STORM DRAIN THAT WILL BE INSTALLED THAT MAY AFFECT THE WATER MAINS

LYVMD ENGINEERING SERVICES MANAGER
PROJECT NO. 124568

DATE

DROP INLET NOTE

WHERE 10 FEET PARALLEL SEPARATION IS NOT PRACTICABLE:
CAST-IN-PLACE MONOLITHIC POUR WITH WATERSTOP BETWEEN SLAB AND WALLS. BASE, WALLS AND TOP TO BE CONSTRUCTED WITH WATERSTOPS, CENTER BULB, OR FLAT STRIP (VINYLEX, GREENSTREAK PLASTIC PRODUCTS OR APPROVED EQUAL).

LEGEND



STORM DRAIN LATERAL # (SEE SHEETS SD-20 THRU SD-24)

I CERTIFY THAT THIS GRADING PLAN IS IN CONFORMANCE WITH THE APPROVED TECHNICAL DRAINAGE STUDY DS-4739A ON FILE AT THE CITY OF LAS VEGAS FOR THE SUBJECT PROJECT.

JERRY SLATER, P.E. 14187

DATE


FLOOD ZONE



THE PROJECT SITE IS LOCATED WITHIN A FEMA DESIGNATED ZONE "X" (OUTSIDE THE 500-YEAR FLOOD PLAIN) ON THE FLOOD INSURANCE RATE MAP (FIRM) PANEL 32003C1750E, DATED SEPTEMBER 27, 2002.

NOTE:







PROPERTY OWNER IS RESPONSIBLE TO MAINTAIN THE BEST MANAGEMENT PRACTICES, SUCH AS BUT NOT LIMITED TO, THE REMOVAL OF ACCUMULATED SEDIMENT AND DEBRIS AND CARE OF VEGETATION.

KEY MAP

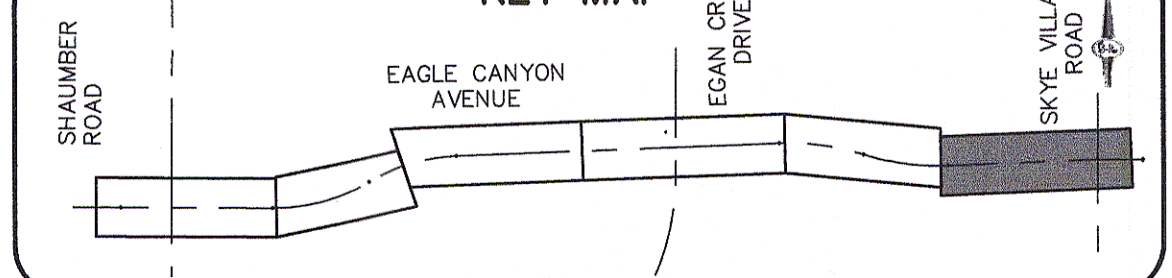

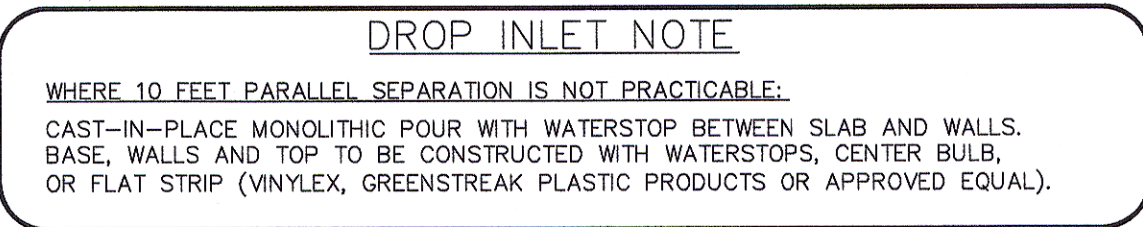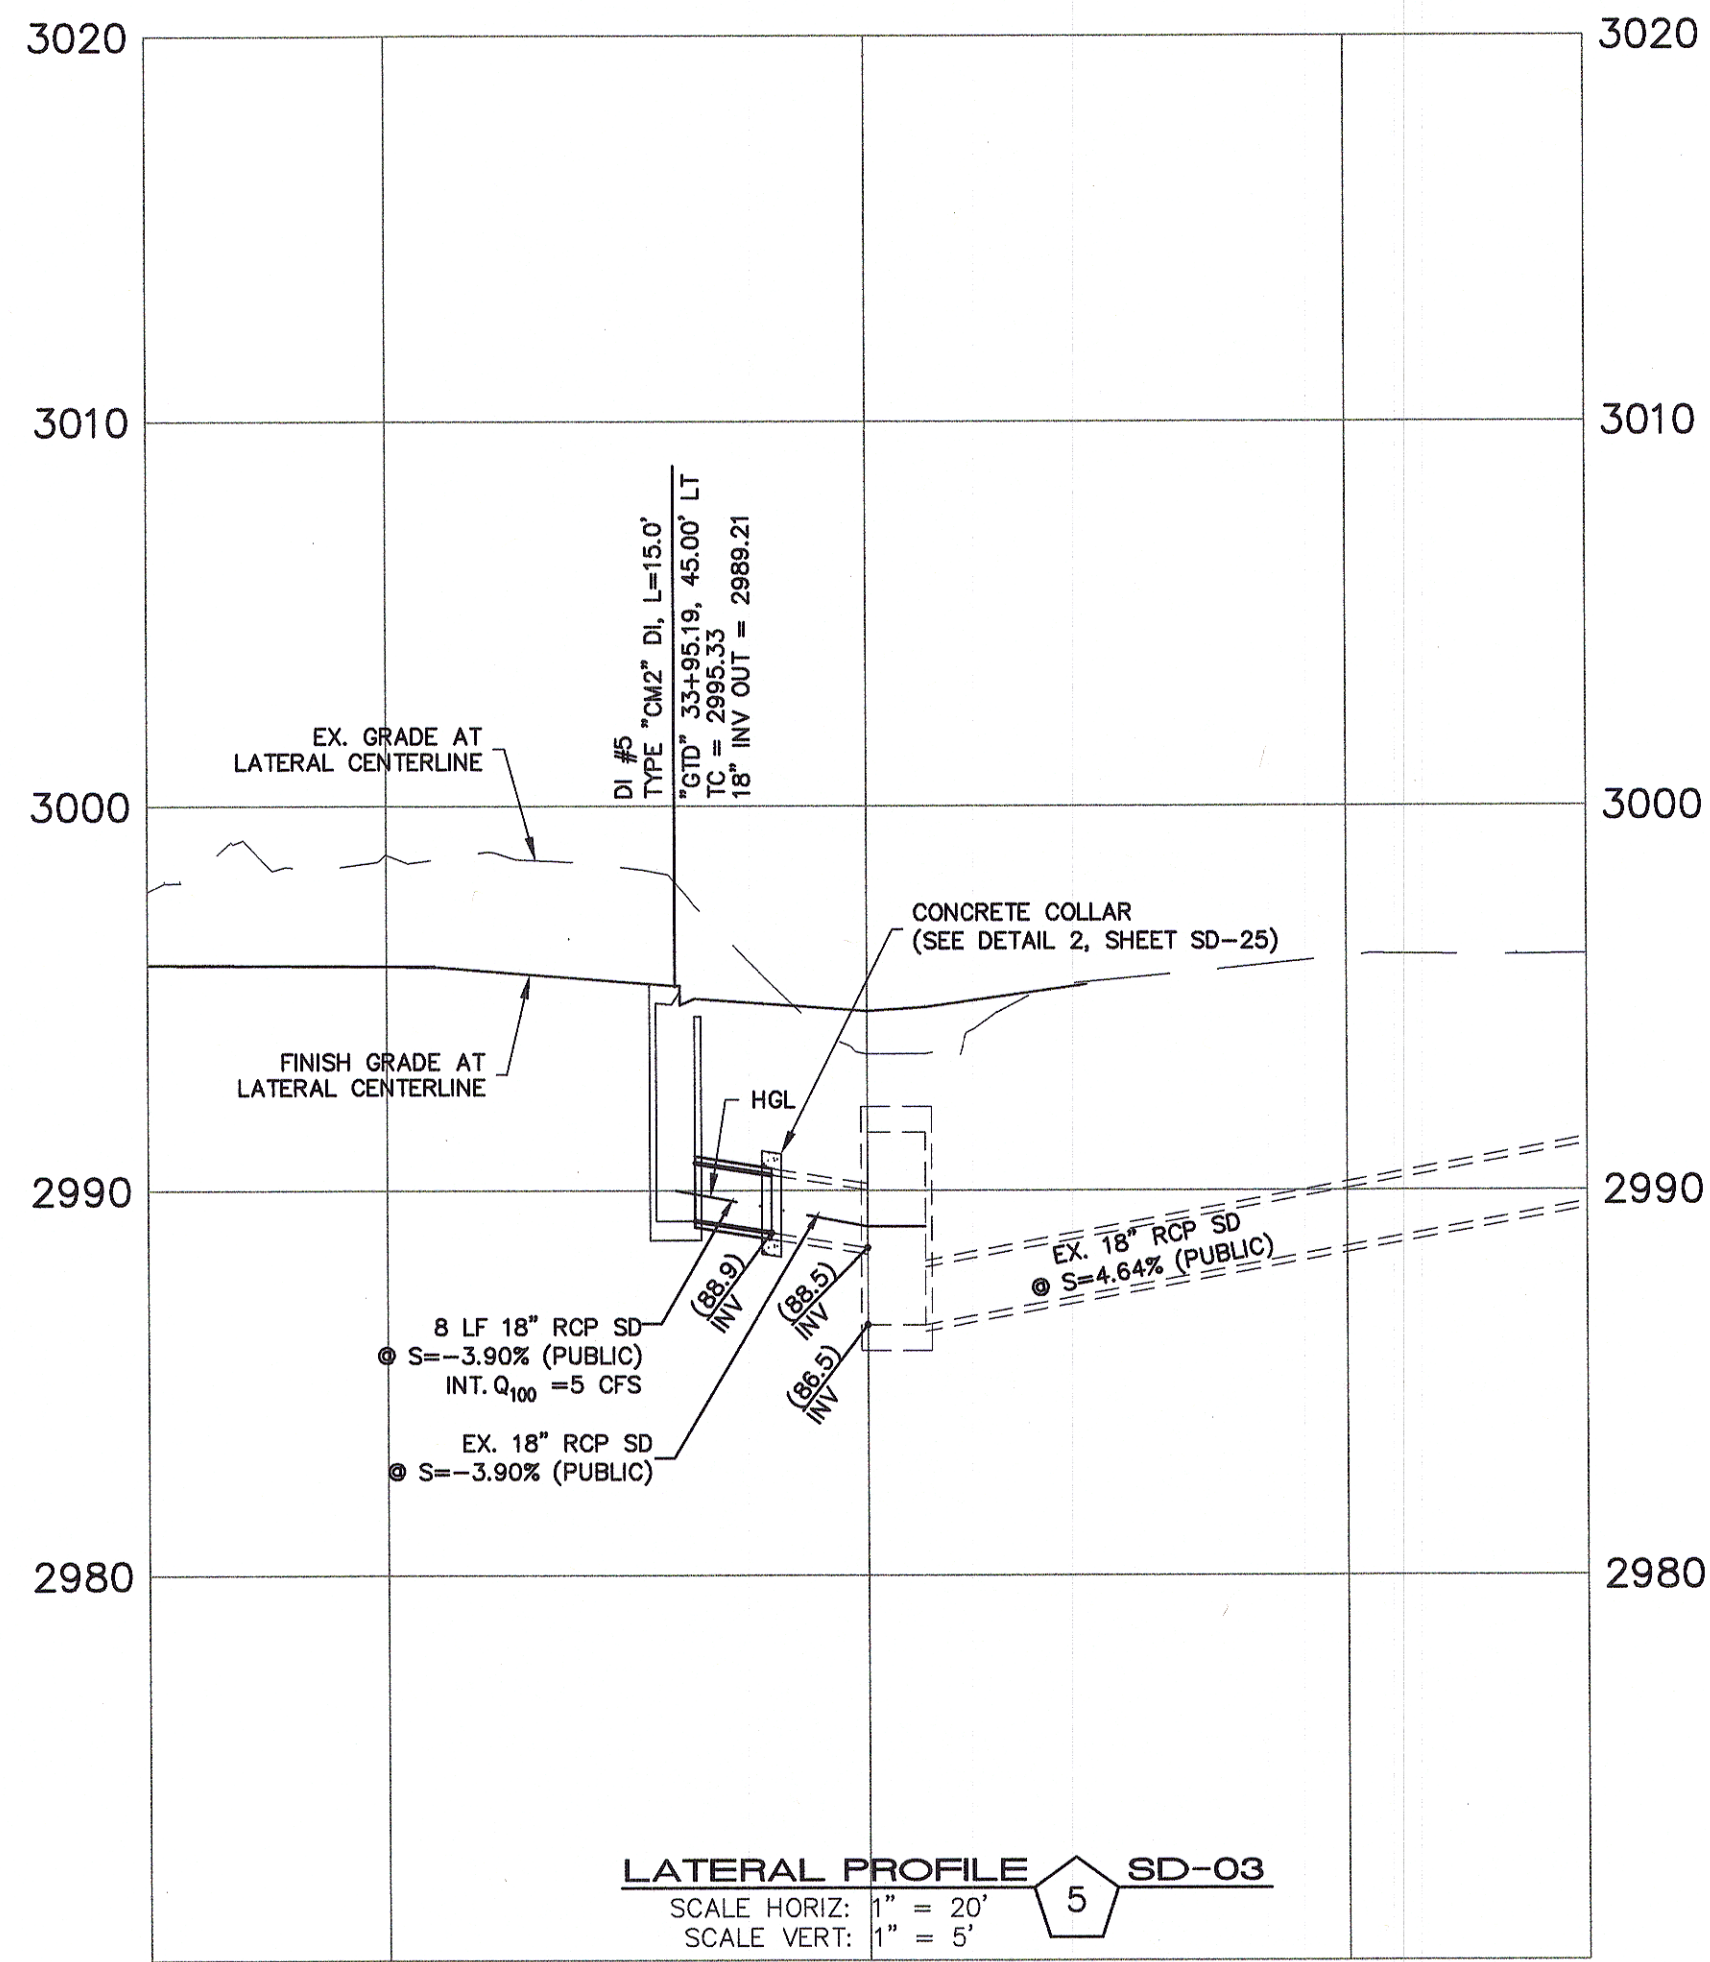

NINETY-FIVE MANAGEMENT LLC		SLATER HANIFAN G-E GROUP
SKYE CANYON II PHASE 2 MASS GRADING STORM DRAIN LATERAL PROFILES		CONSULTING ENGINEERS & PLANNERS 5740 S. ARVILLE STREET #216, LAS VEGAS, NV 89118 PHONE (702) 284-5300 FAX (702) 284-5399
DATE:	8/3/16	
DRAFTER:	JAS	
DESIGNER:	DAM	
CHECKED:	JSR	
PROJECT NO.	OLY1501-001	
		
SD-20		
SHEET 23 OF 32		

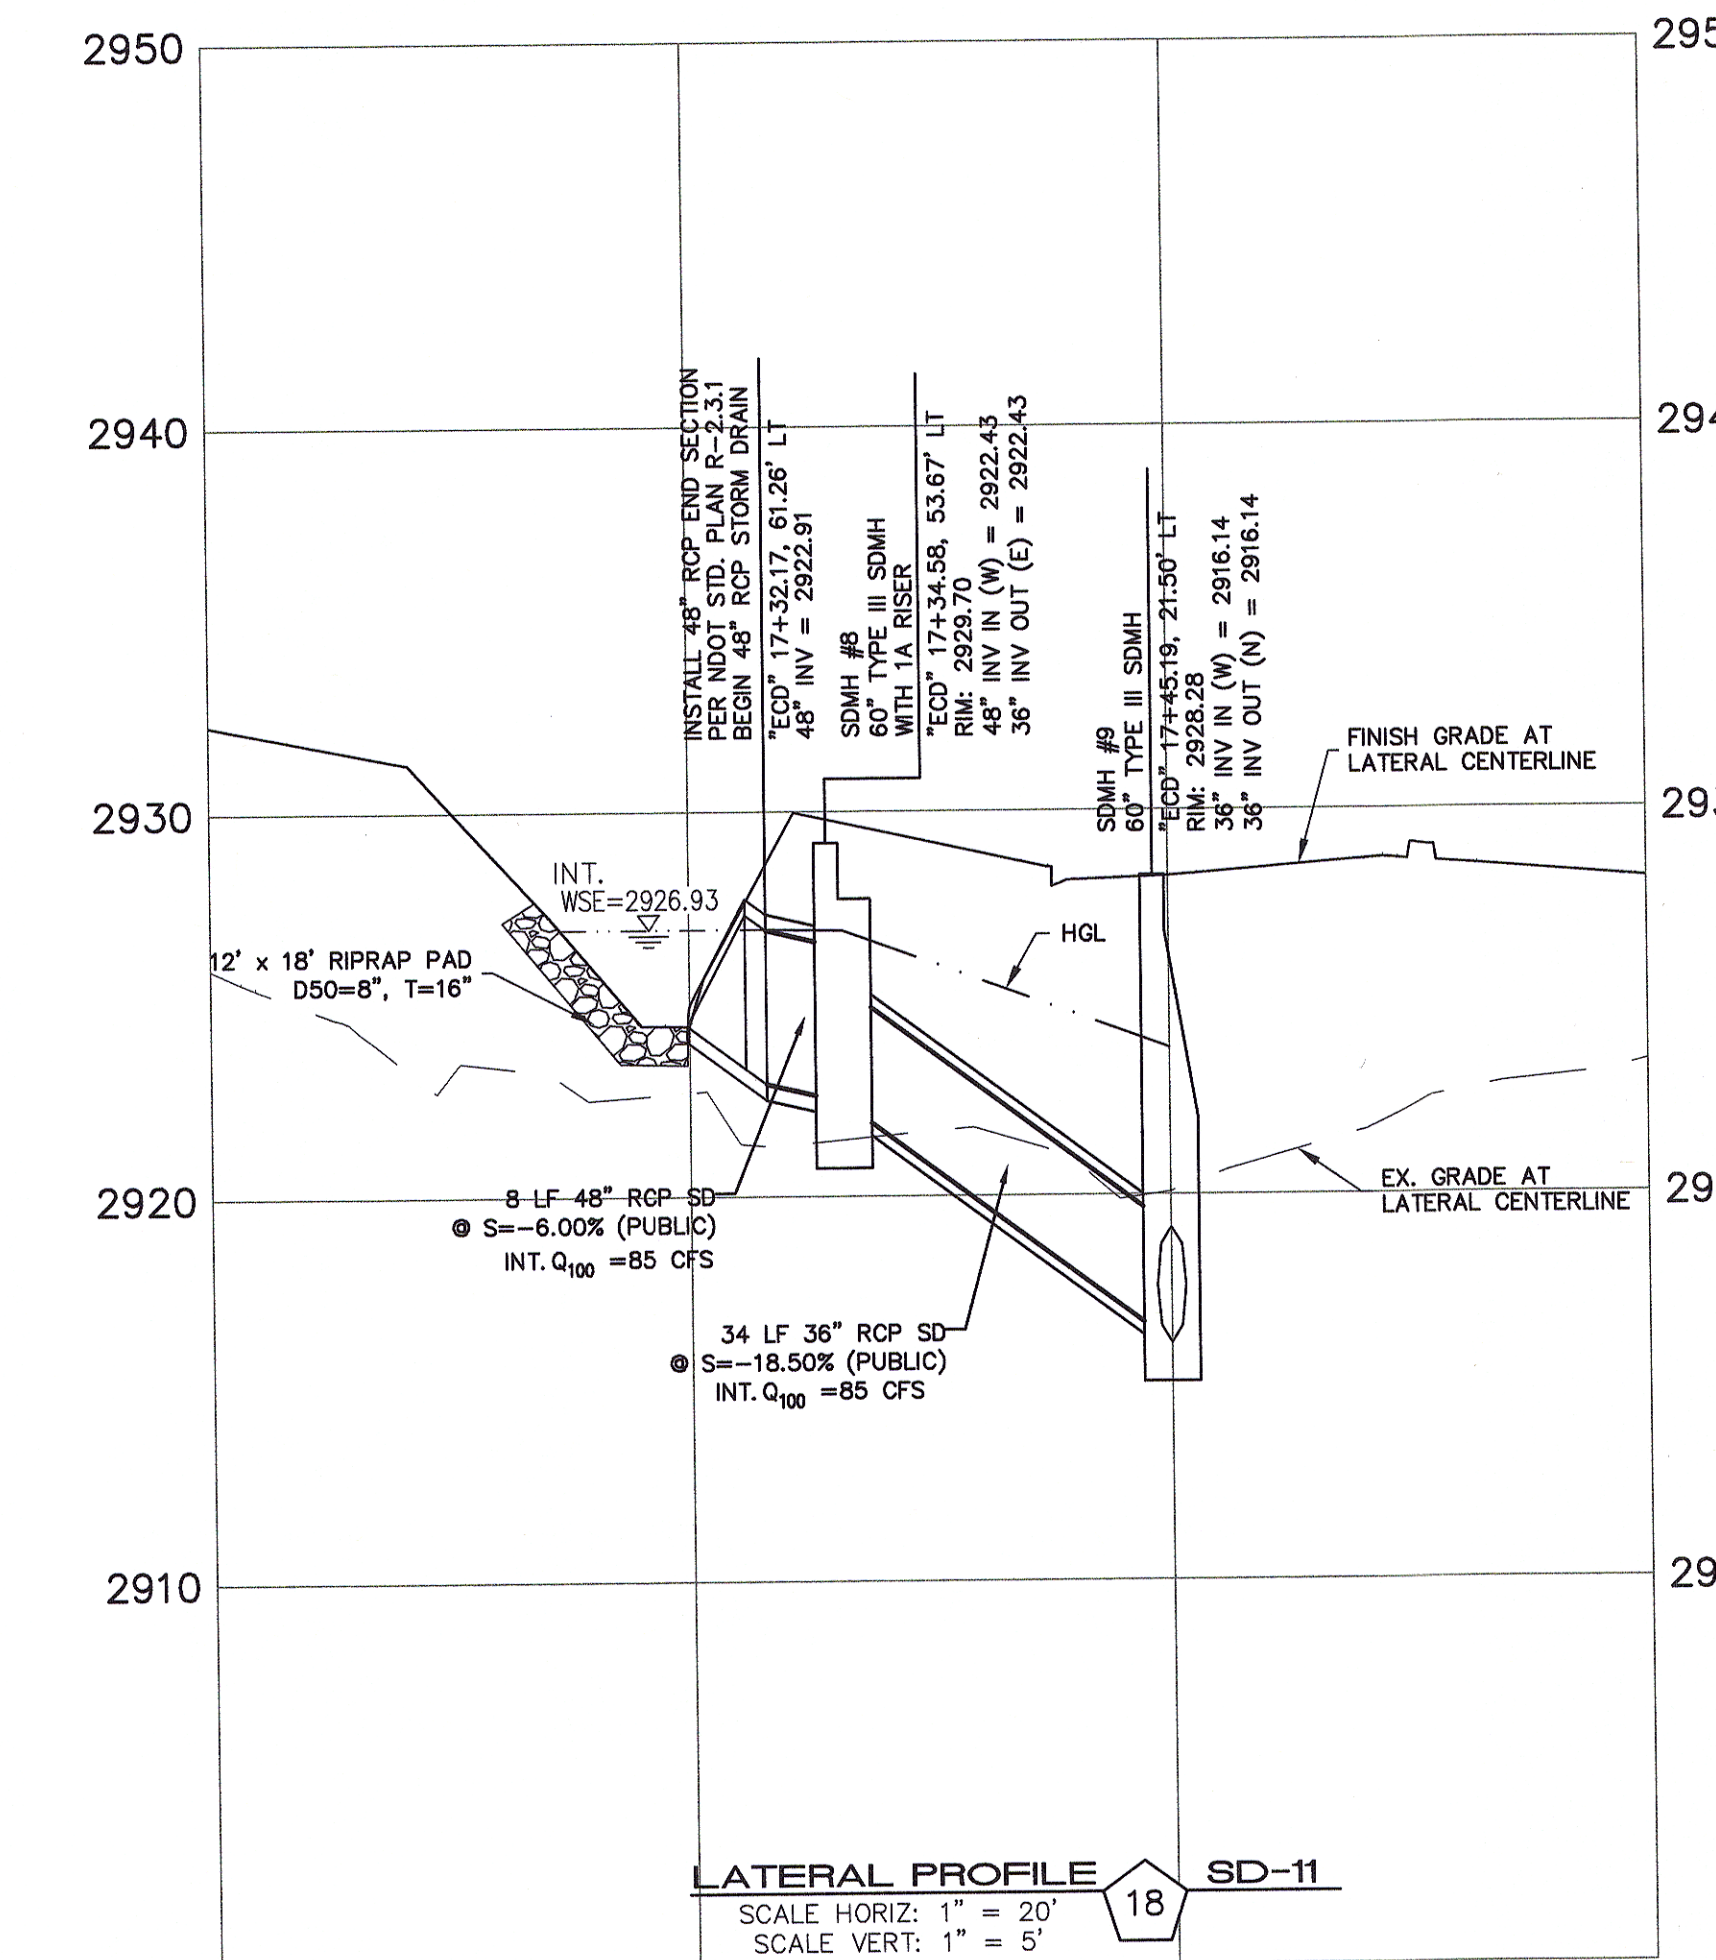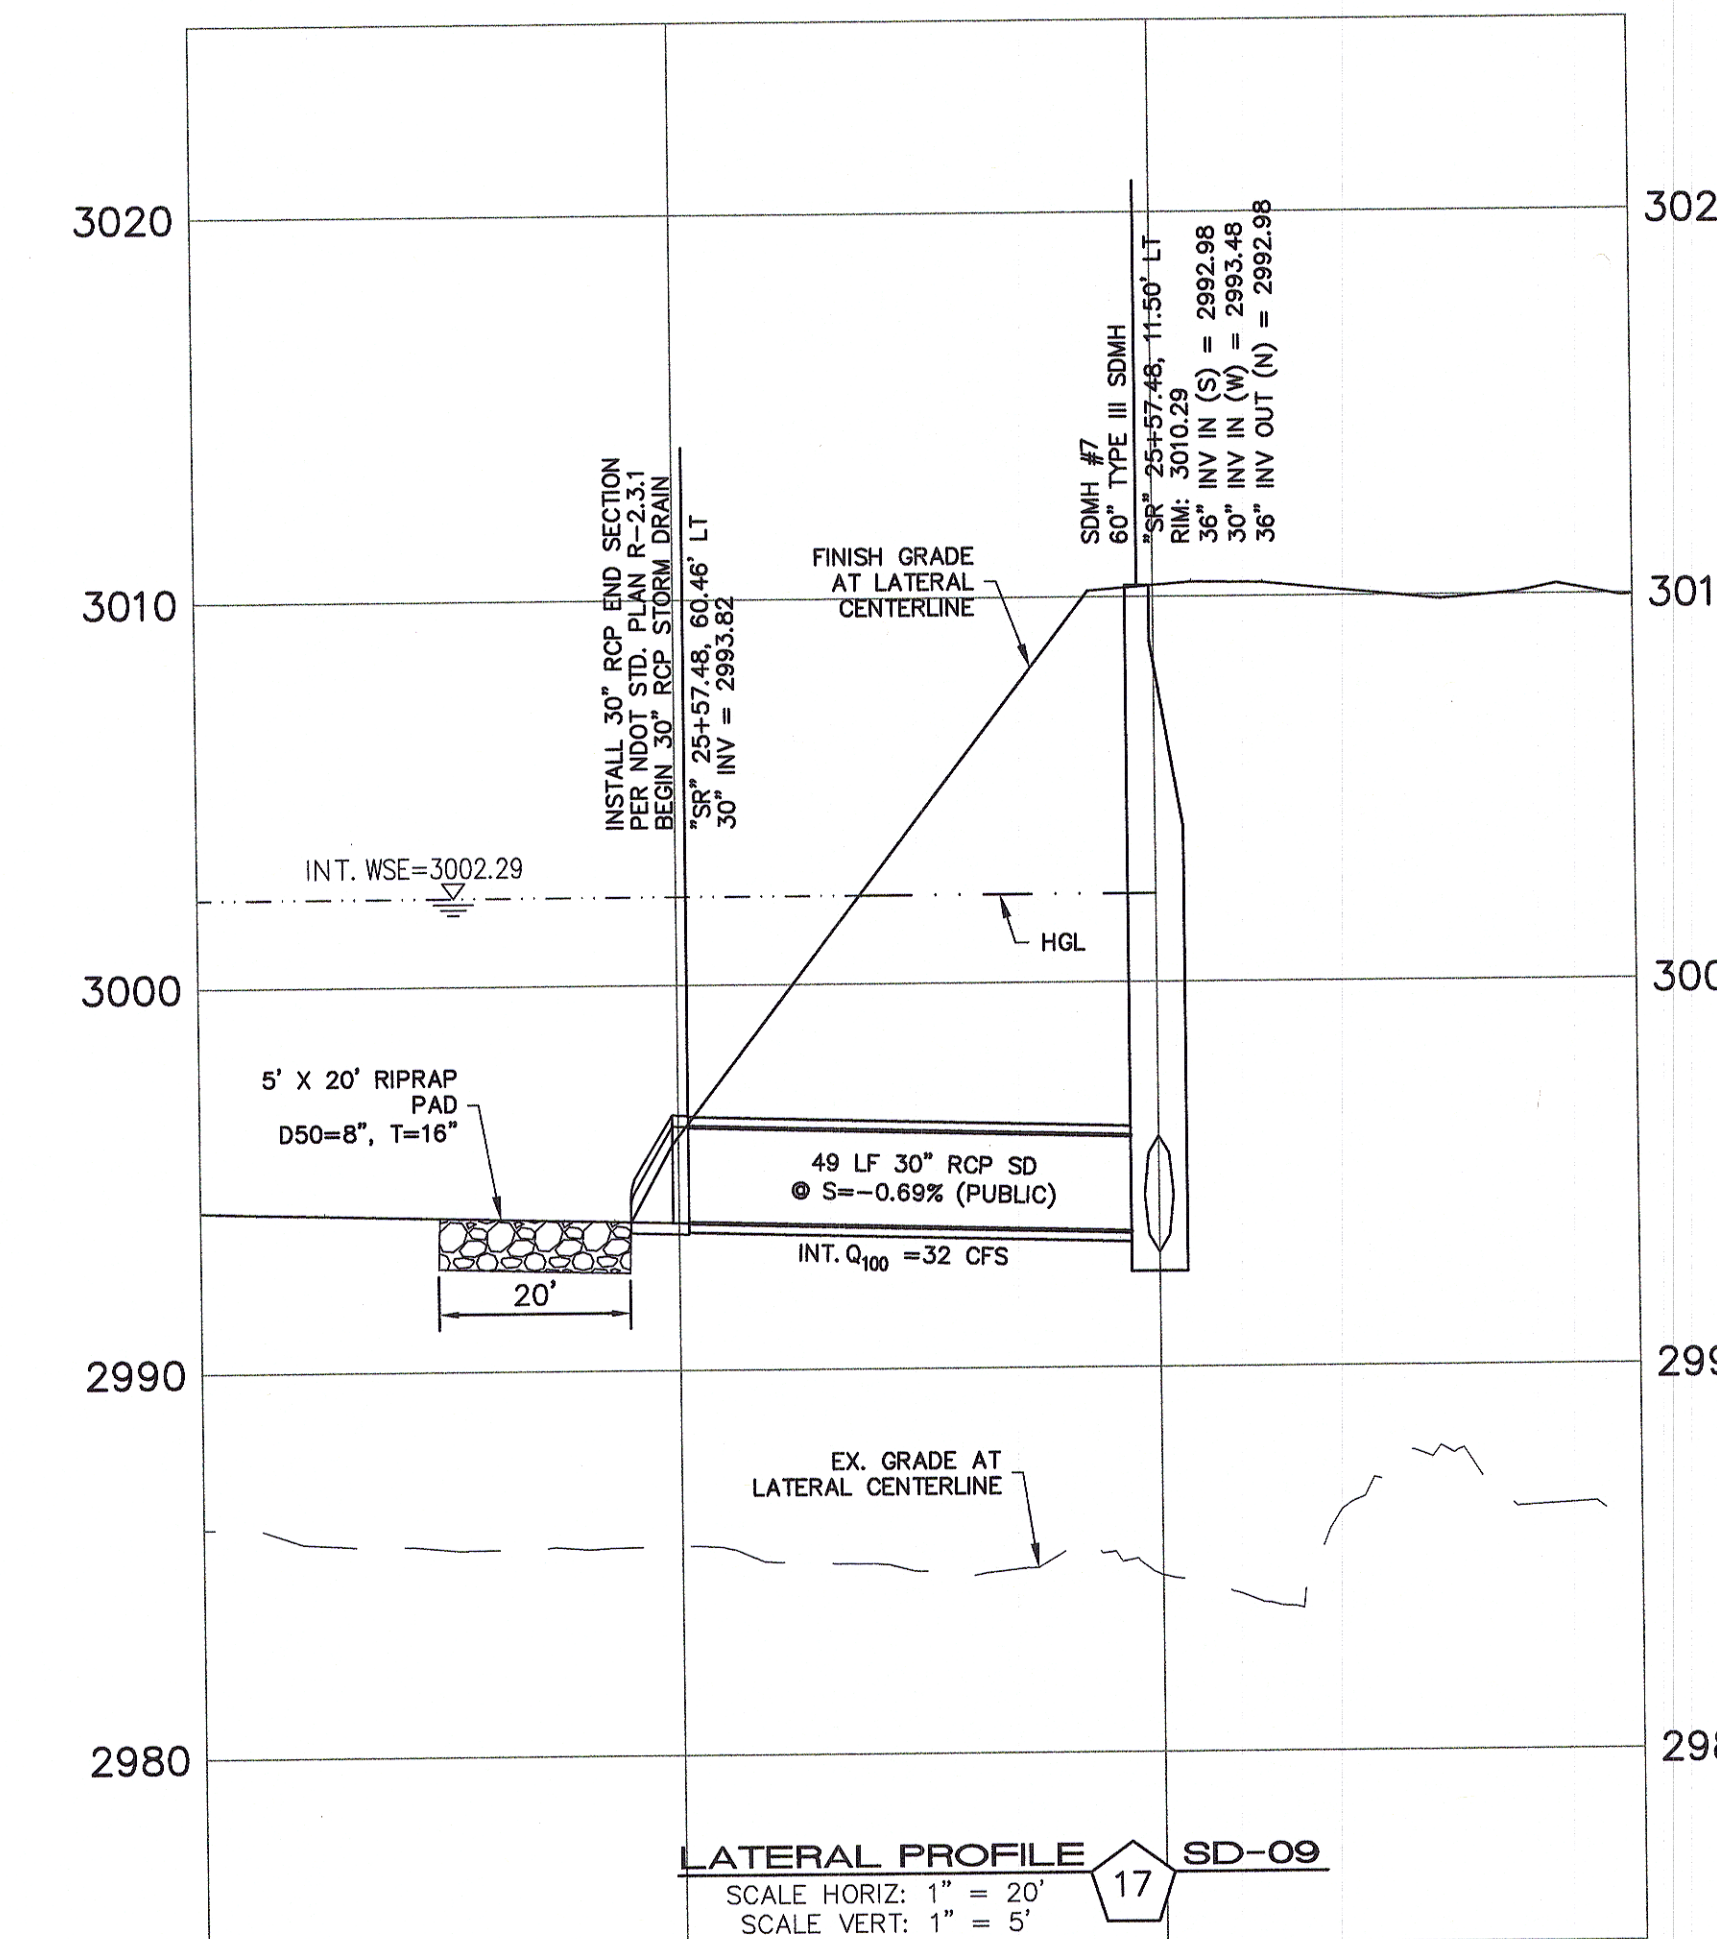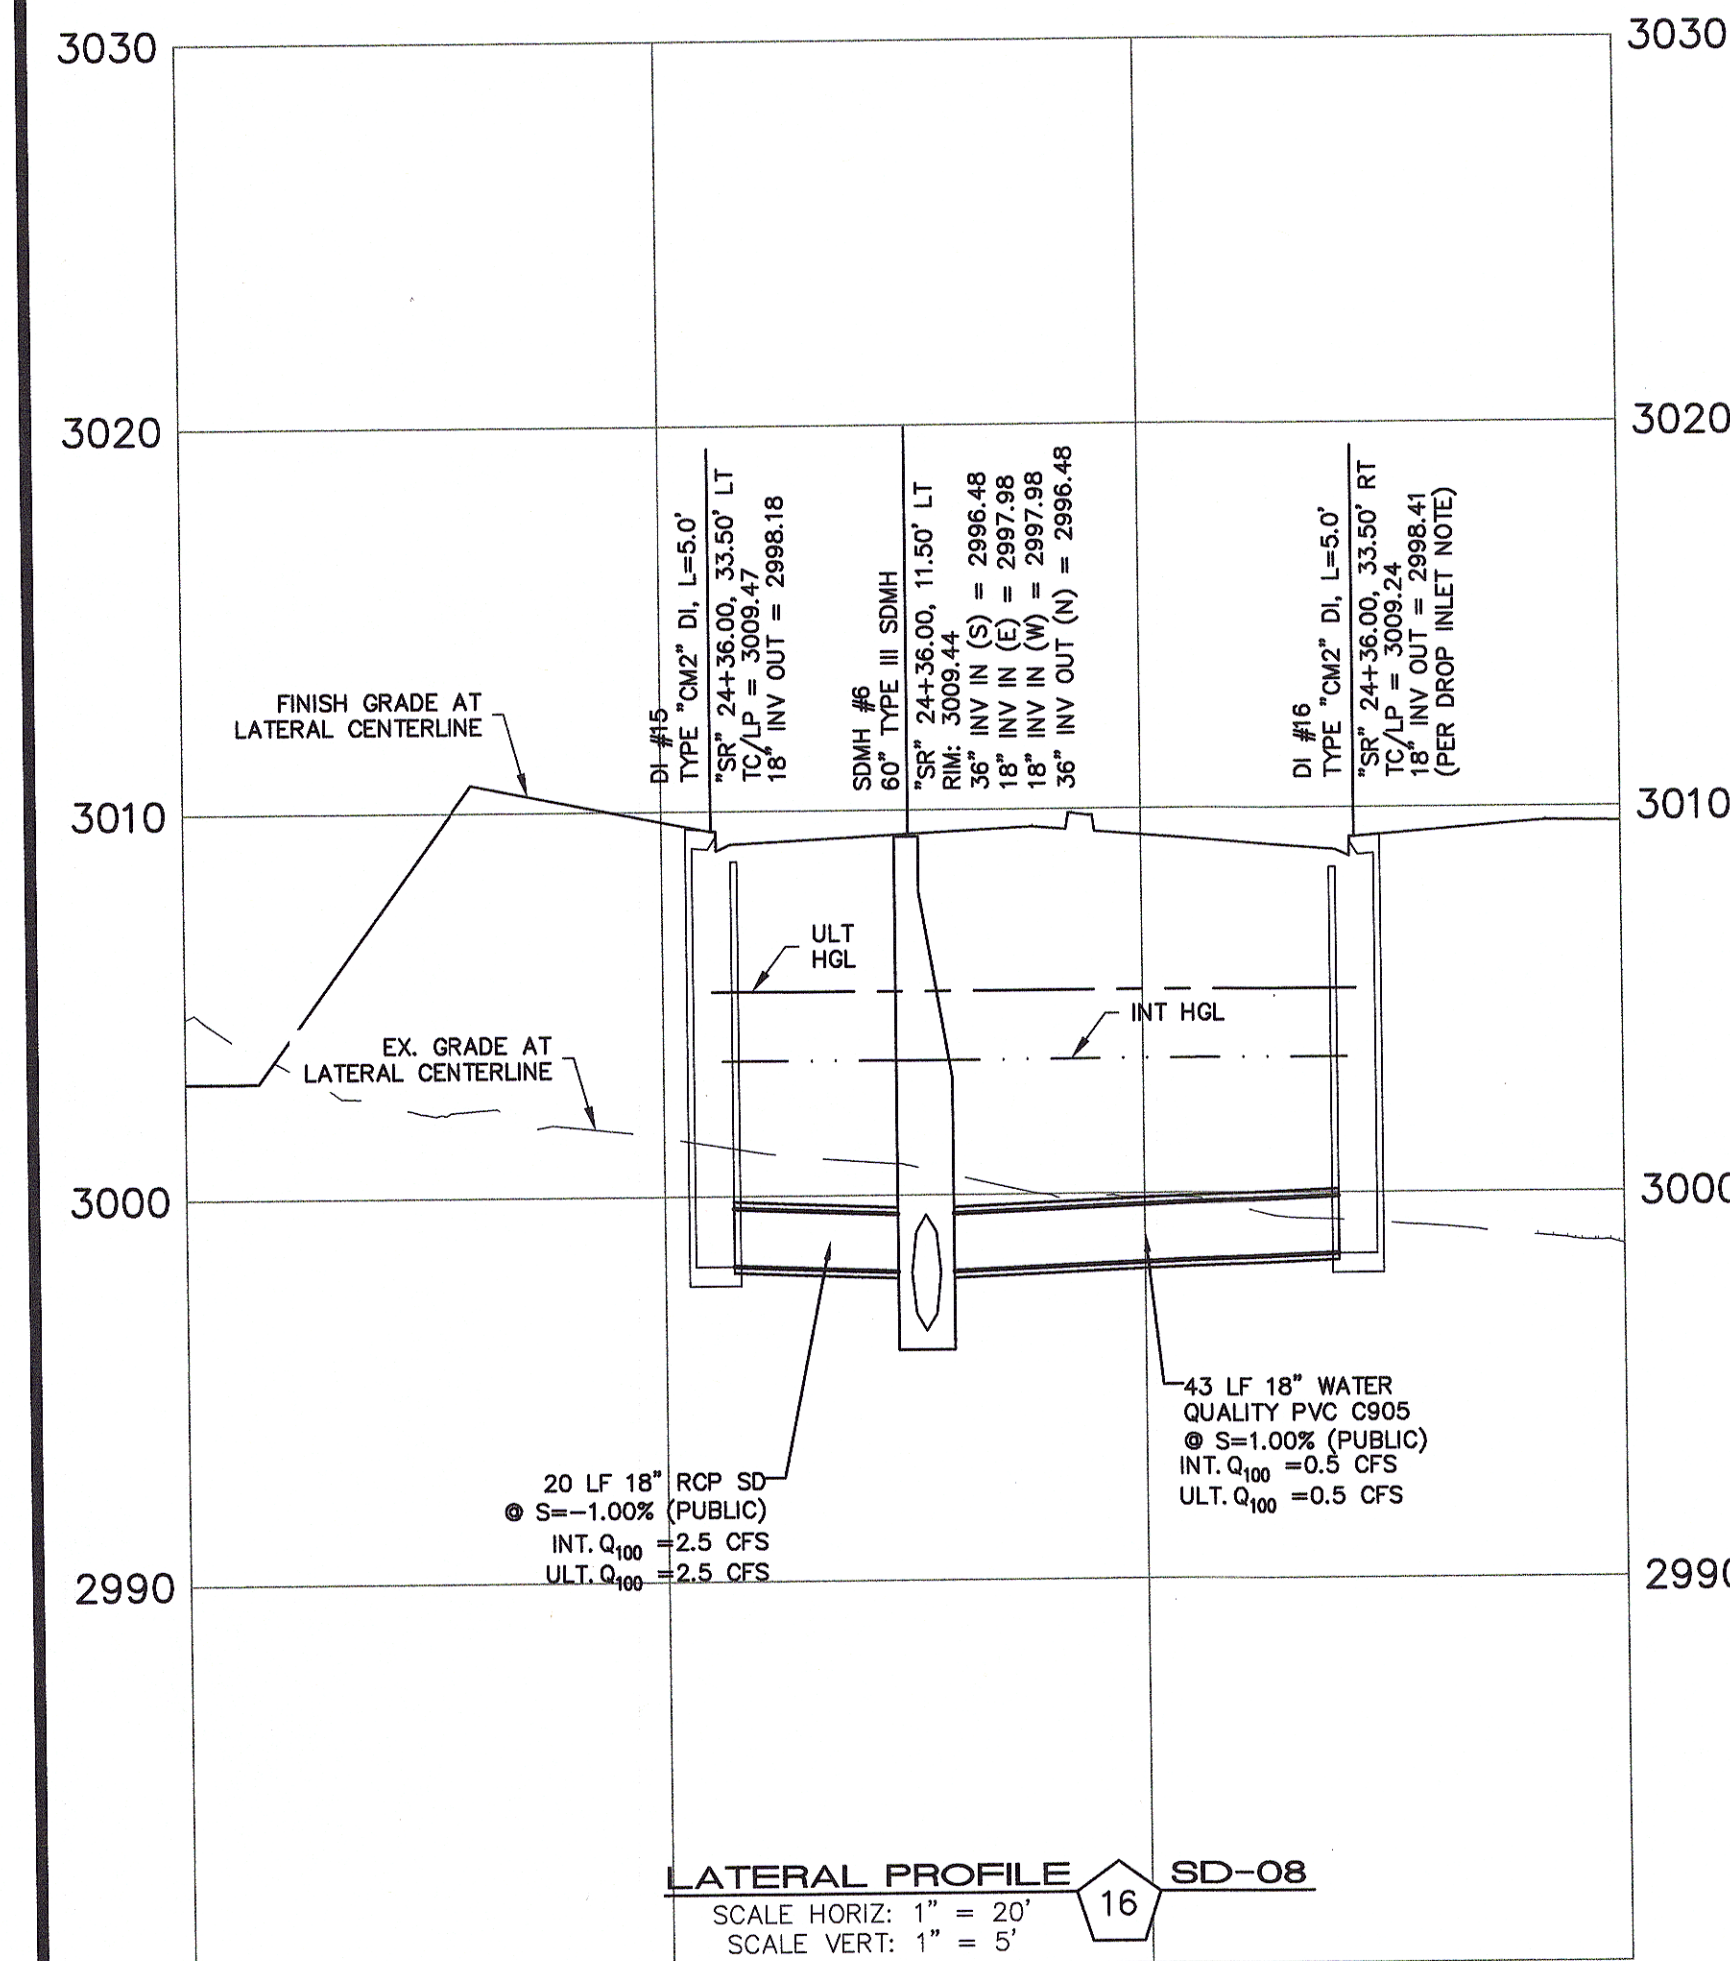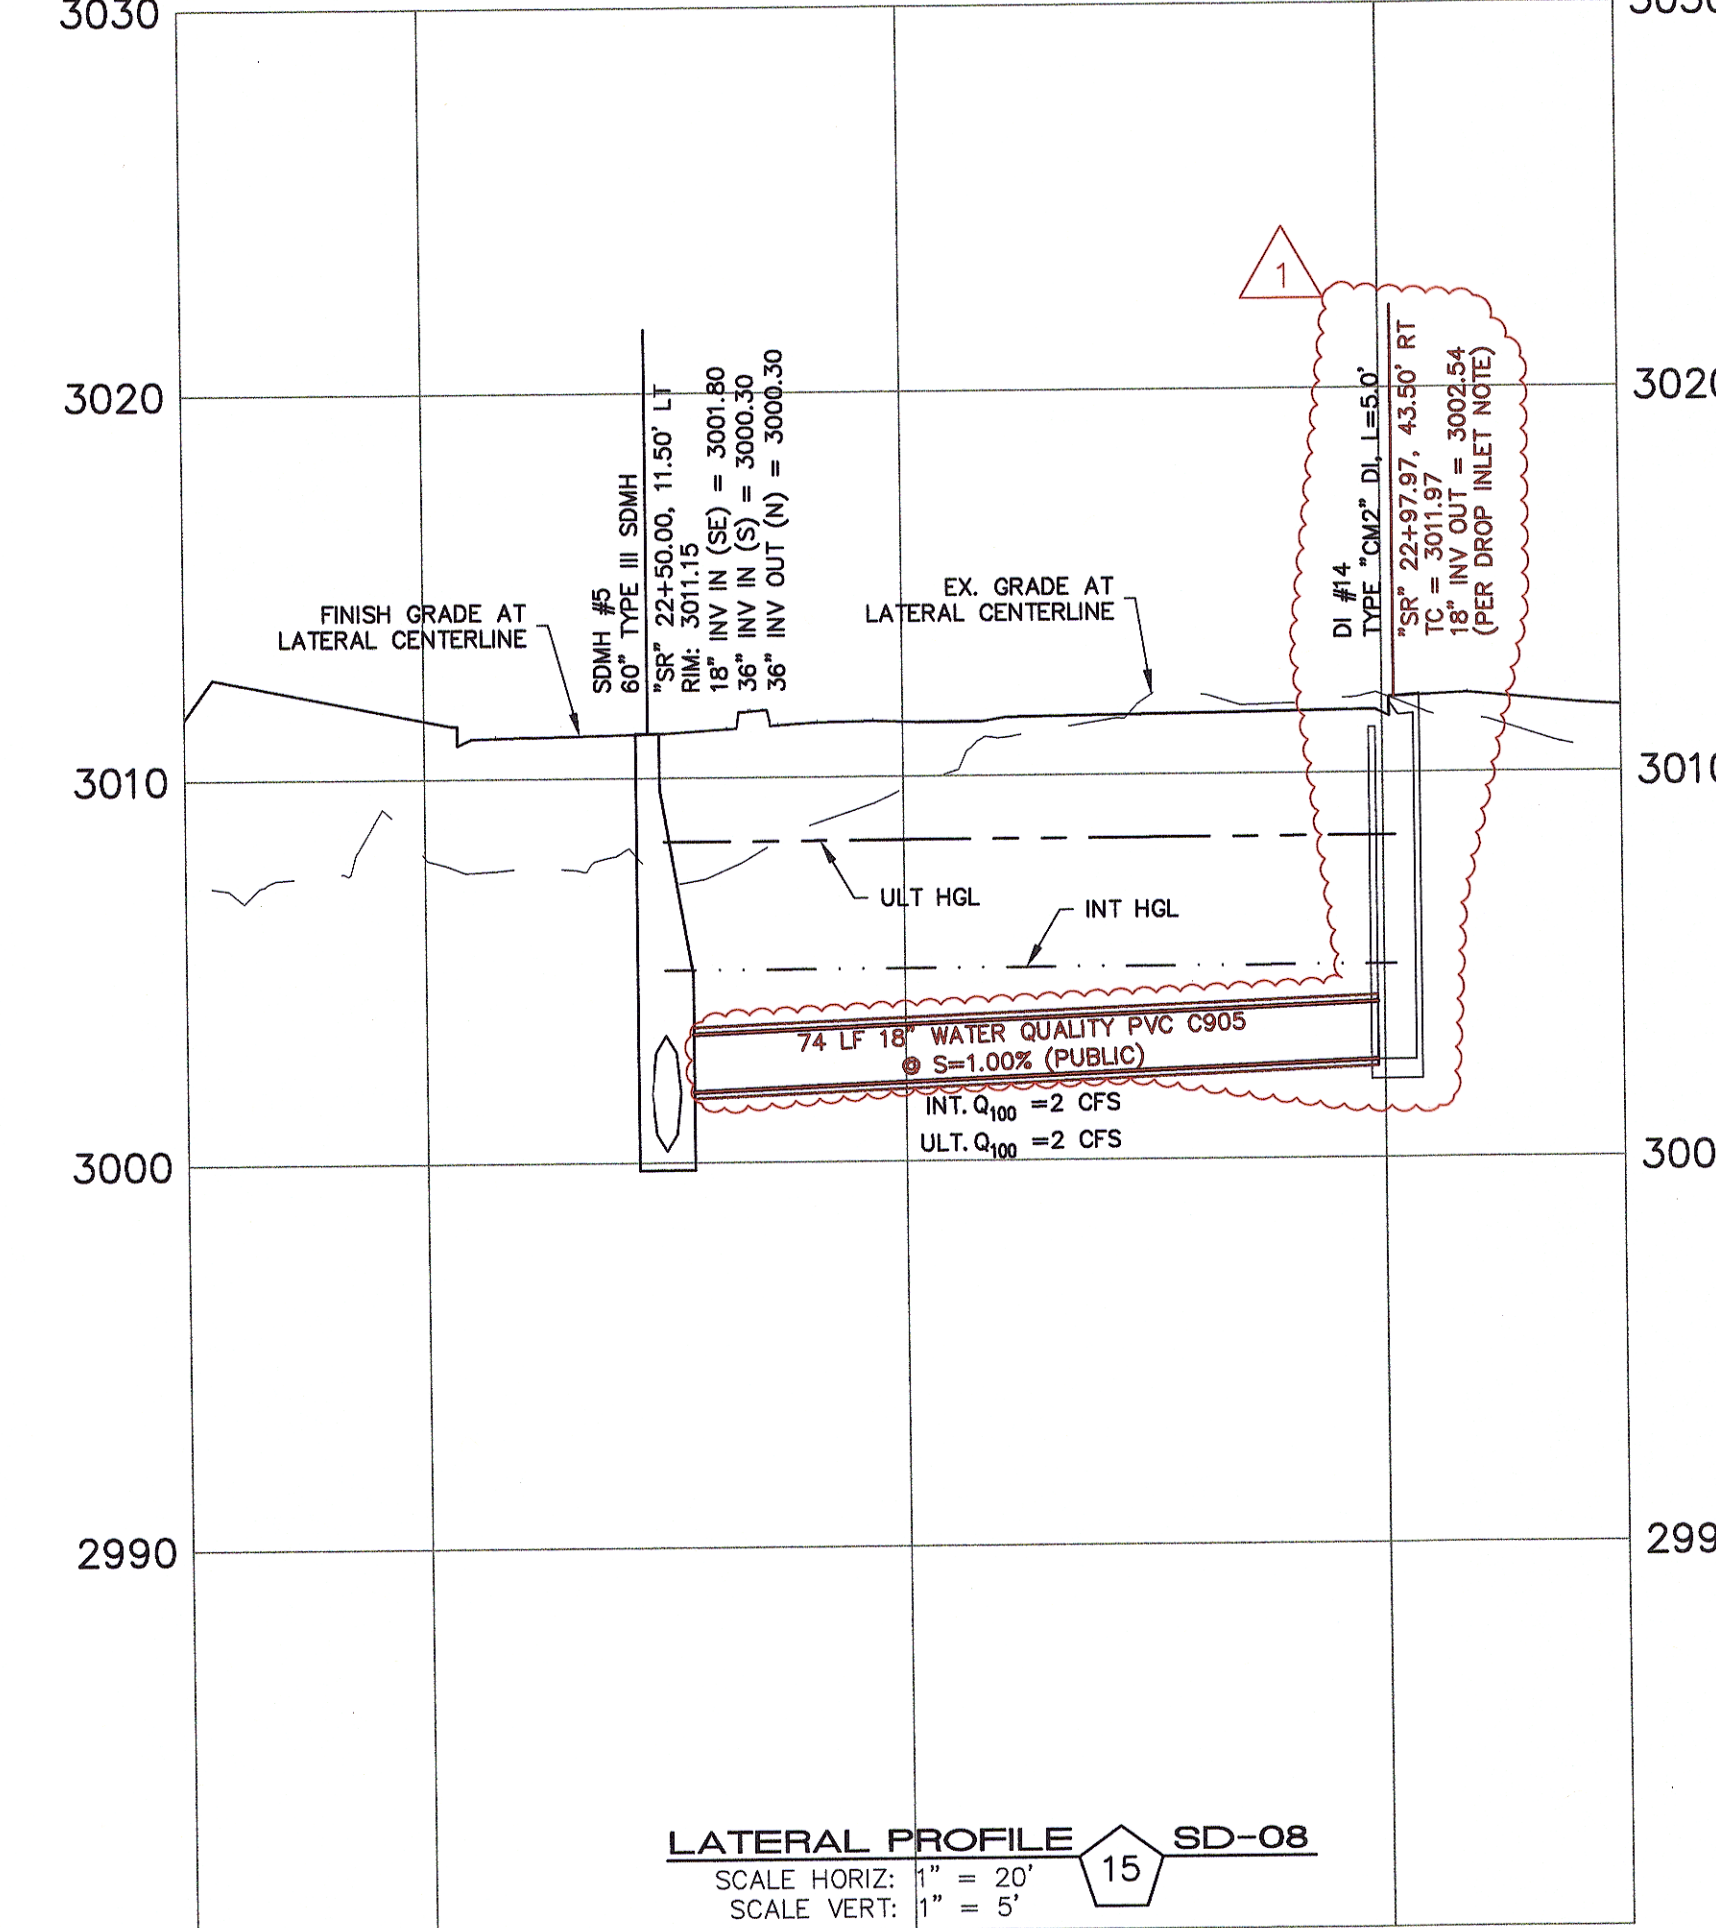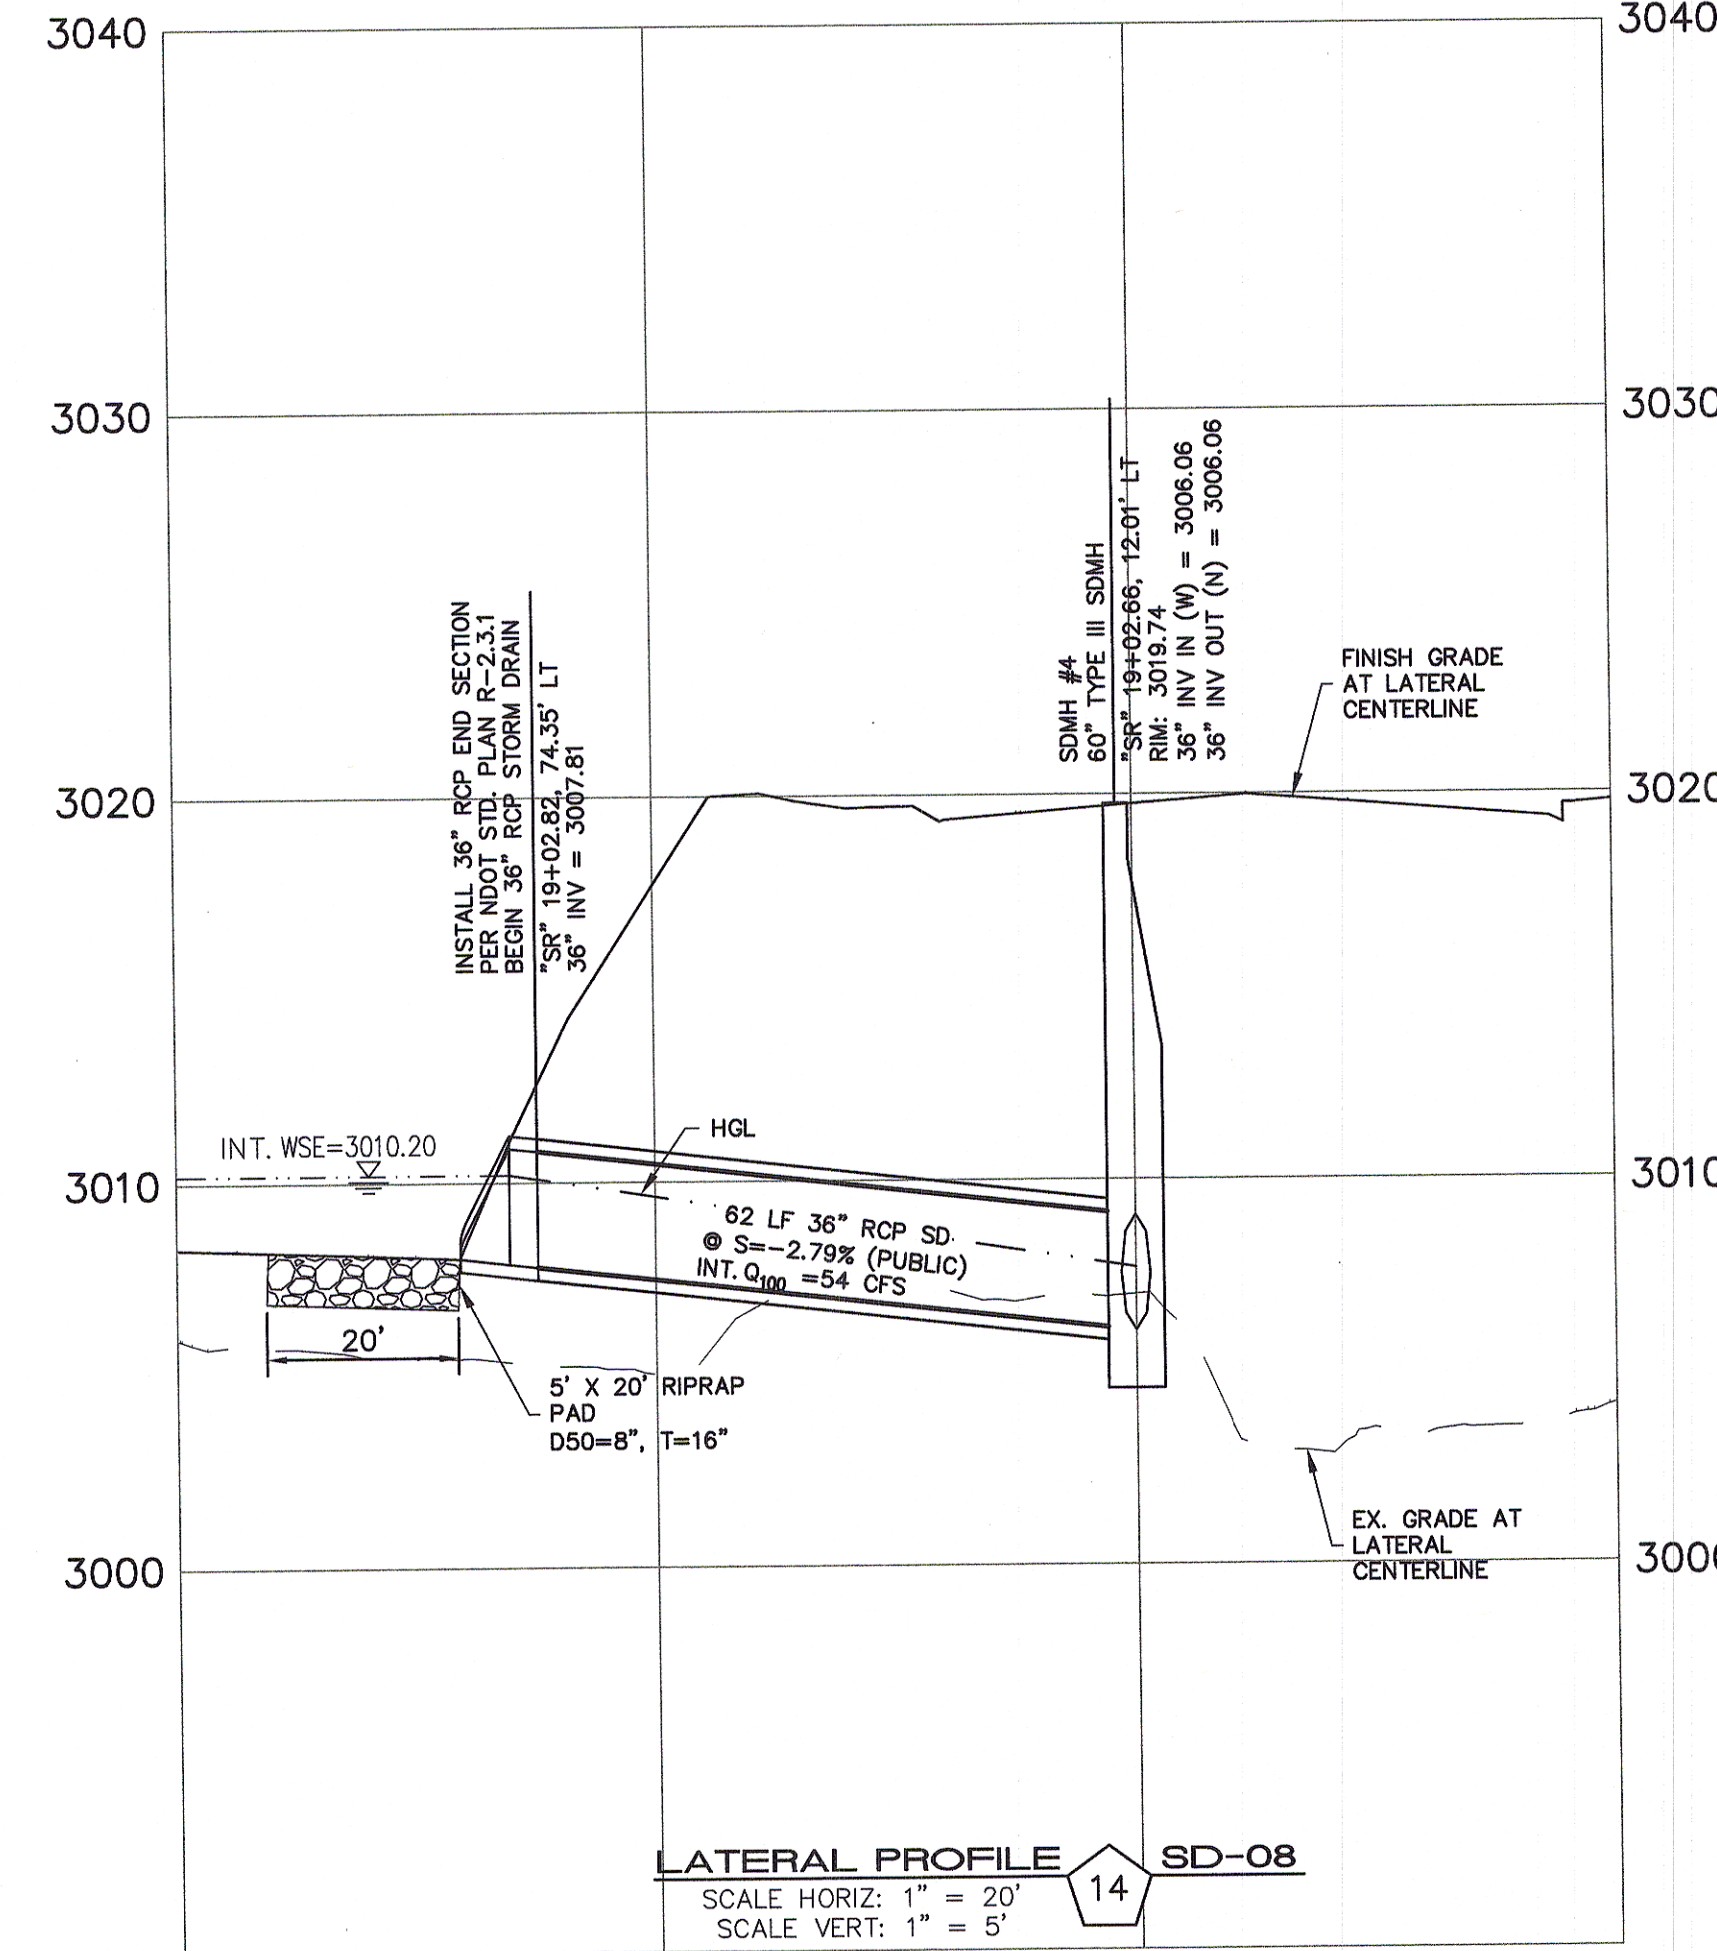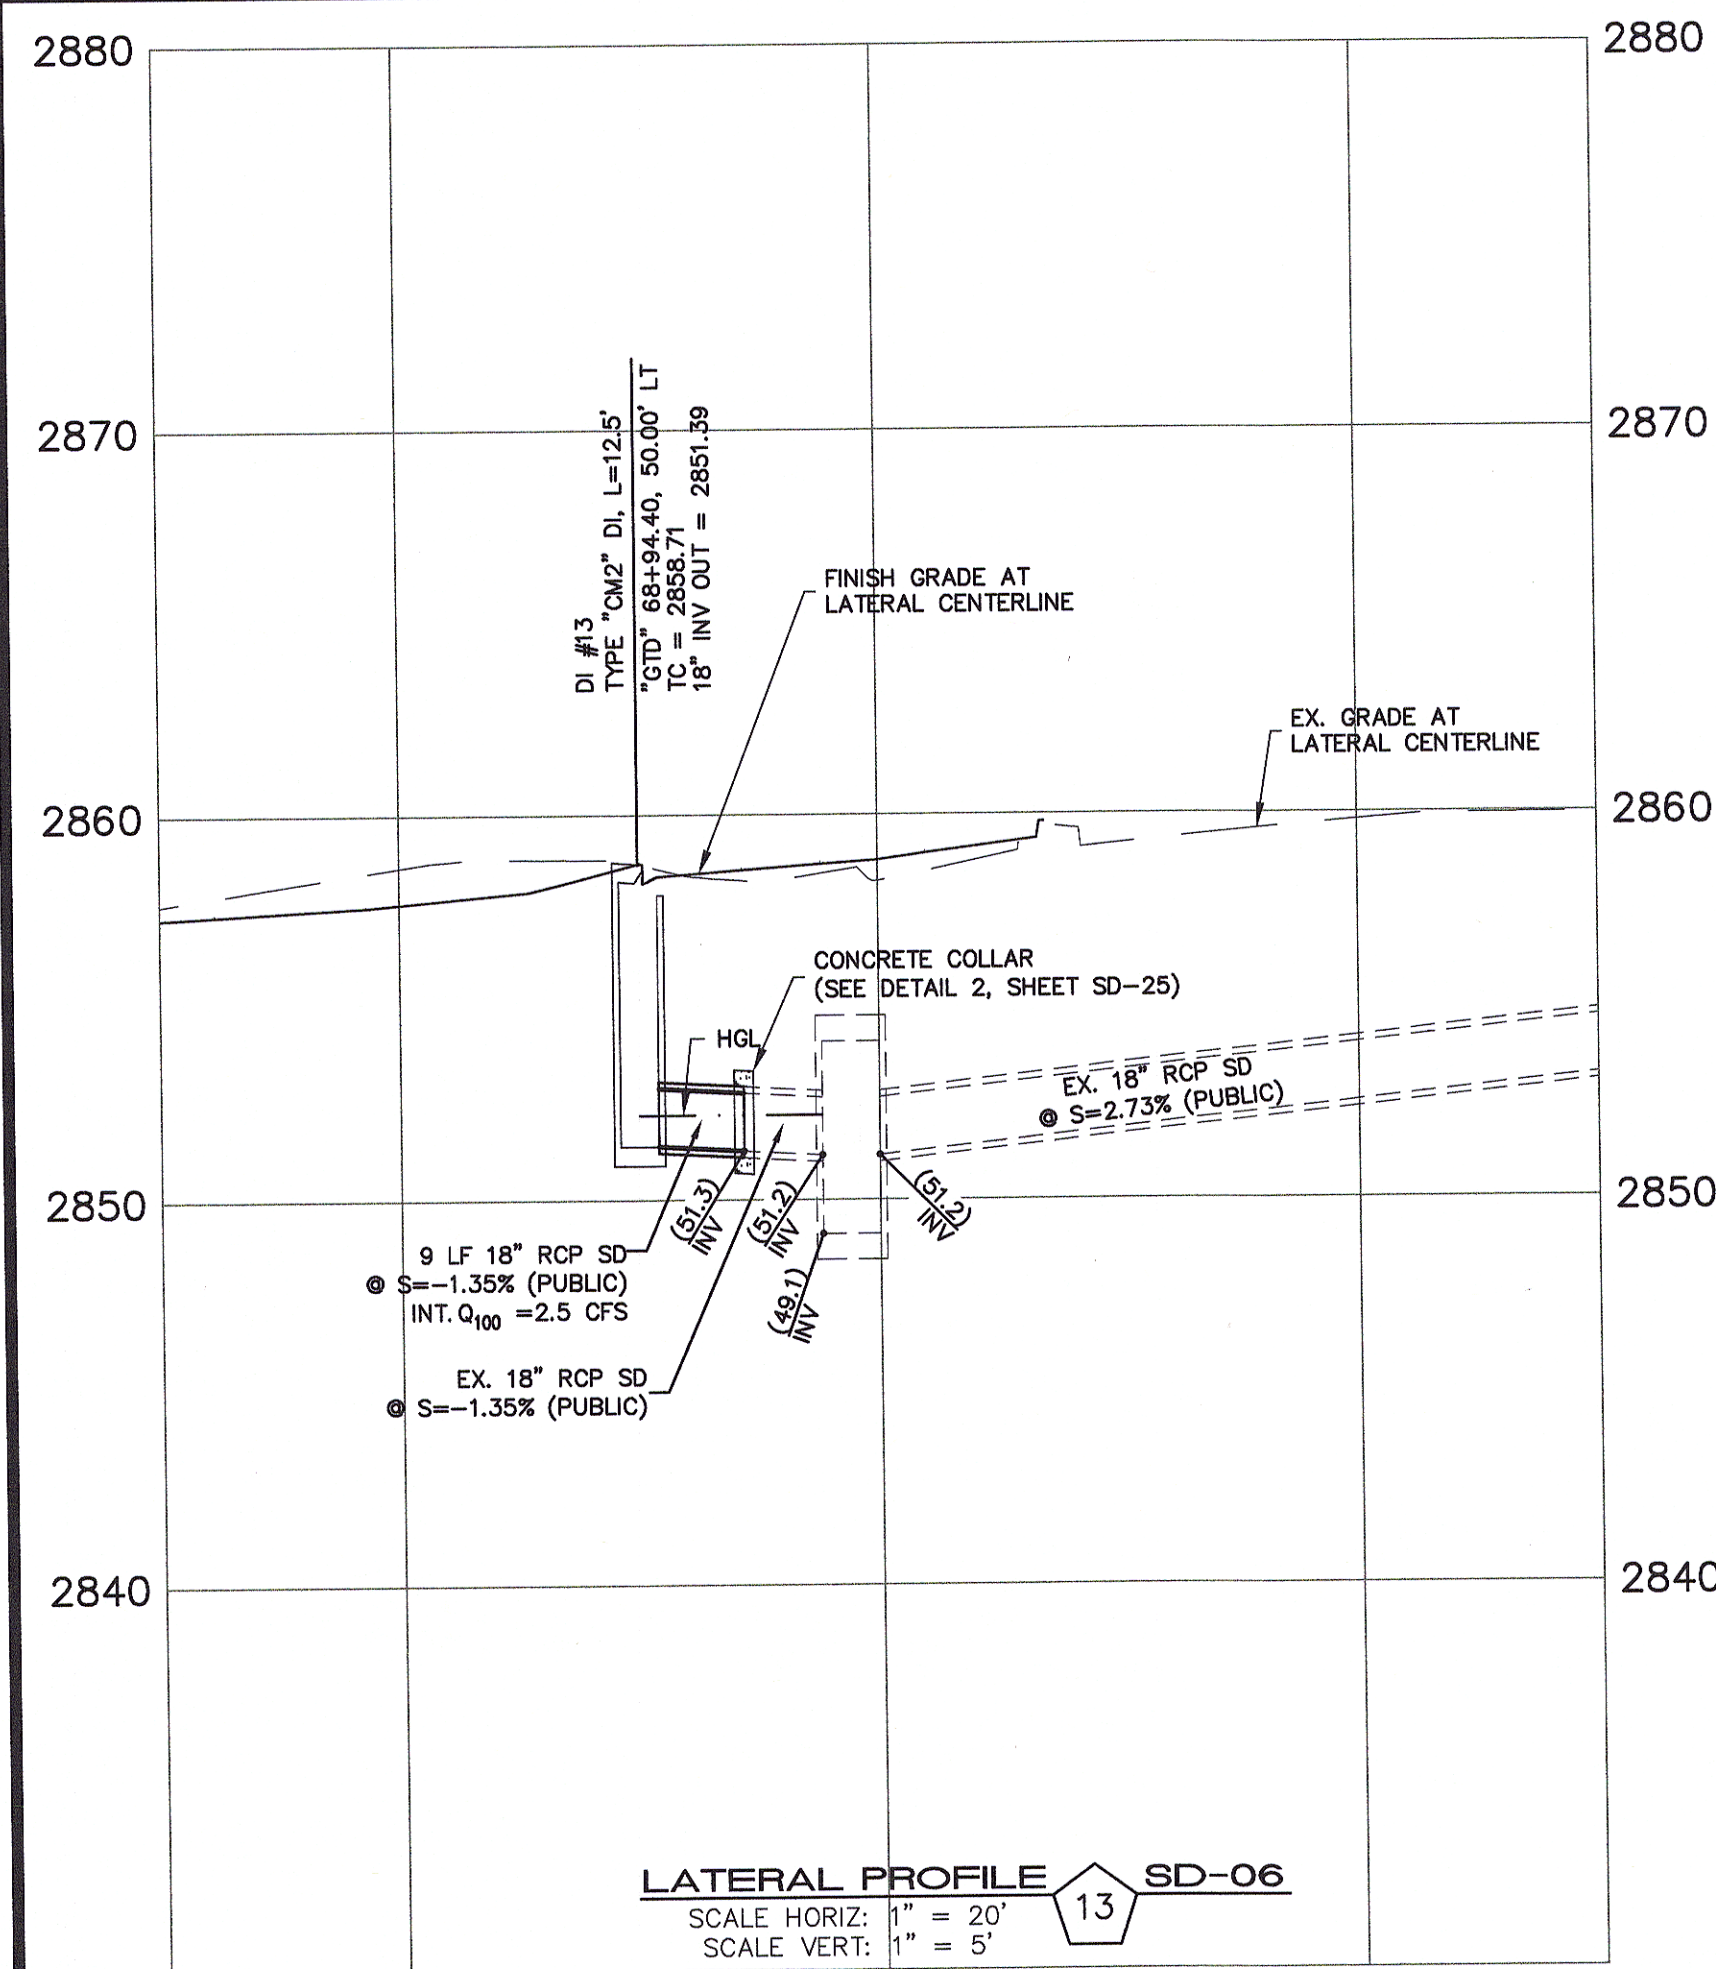

DROP INLET NOTE

WHERE 10 FEET PARALLEL SEPARATION IS NOT PRACTICABLE:
CAST-IN-PLACE MONOLITHIC POUR WITH WATERTOP BETWEEN SLAB AND WALLS.
BASE, WALLS AND TOP TO BE CONSTRUCTED WITH WATERSTOPS, CENTER BULB,
OR FLAT STRIP (VINYLEX, GREENSTREAK PLASTIC PRODUCTS OR APPROVED EQUAL).

APPROVED FOR CONSTRUCTION

LVVWD WILL HAVE TO BE PRESENT AND VIEW INSTALLATION OF STORM DRAIN THAT WILL BE INSTALLED THAT MAY AFFECT THE WATER MAINS

LVVWD ENGINEERING SERVICES MANAGER
PROJECT NO. 124568

DATE


NO.	DESCRIPTION	DATE	BY	APP. DATE
1	REVISED STORM DRAIN	6/20/17	JUS	







NINETY-FIVE MANAGEMENT LLC

SKYE CANYON II PHASE 2 MASS GRADING

STORM DRAIN LATERAL PROFILES

DATE: 8/3/16
DRAFTER: JAS
DESIGNER: DAM
CHECKED: JSR
PROJECT NO.
OLY1501-001

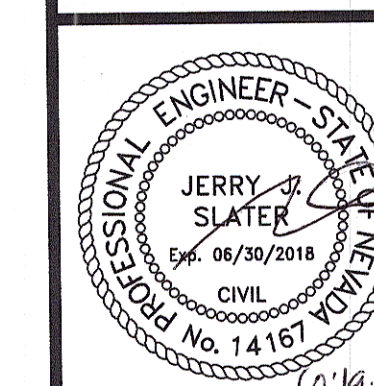

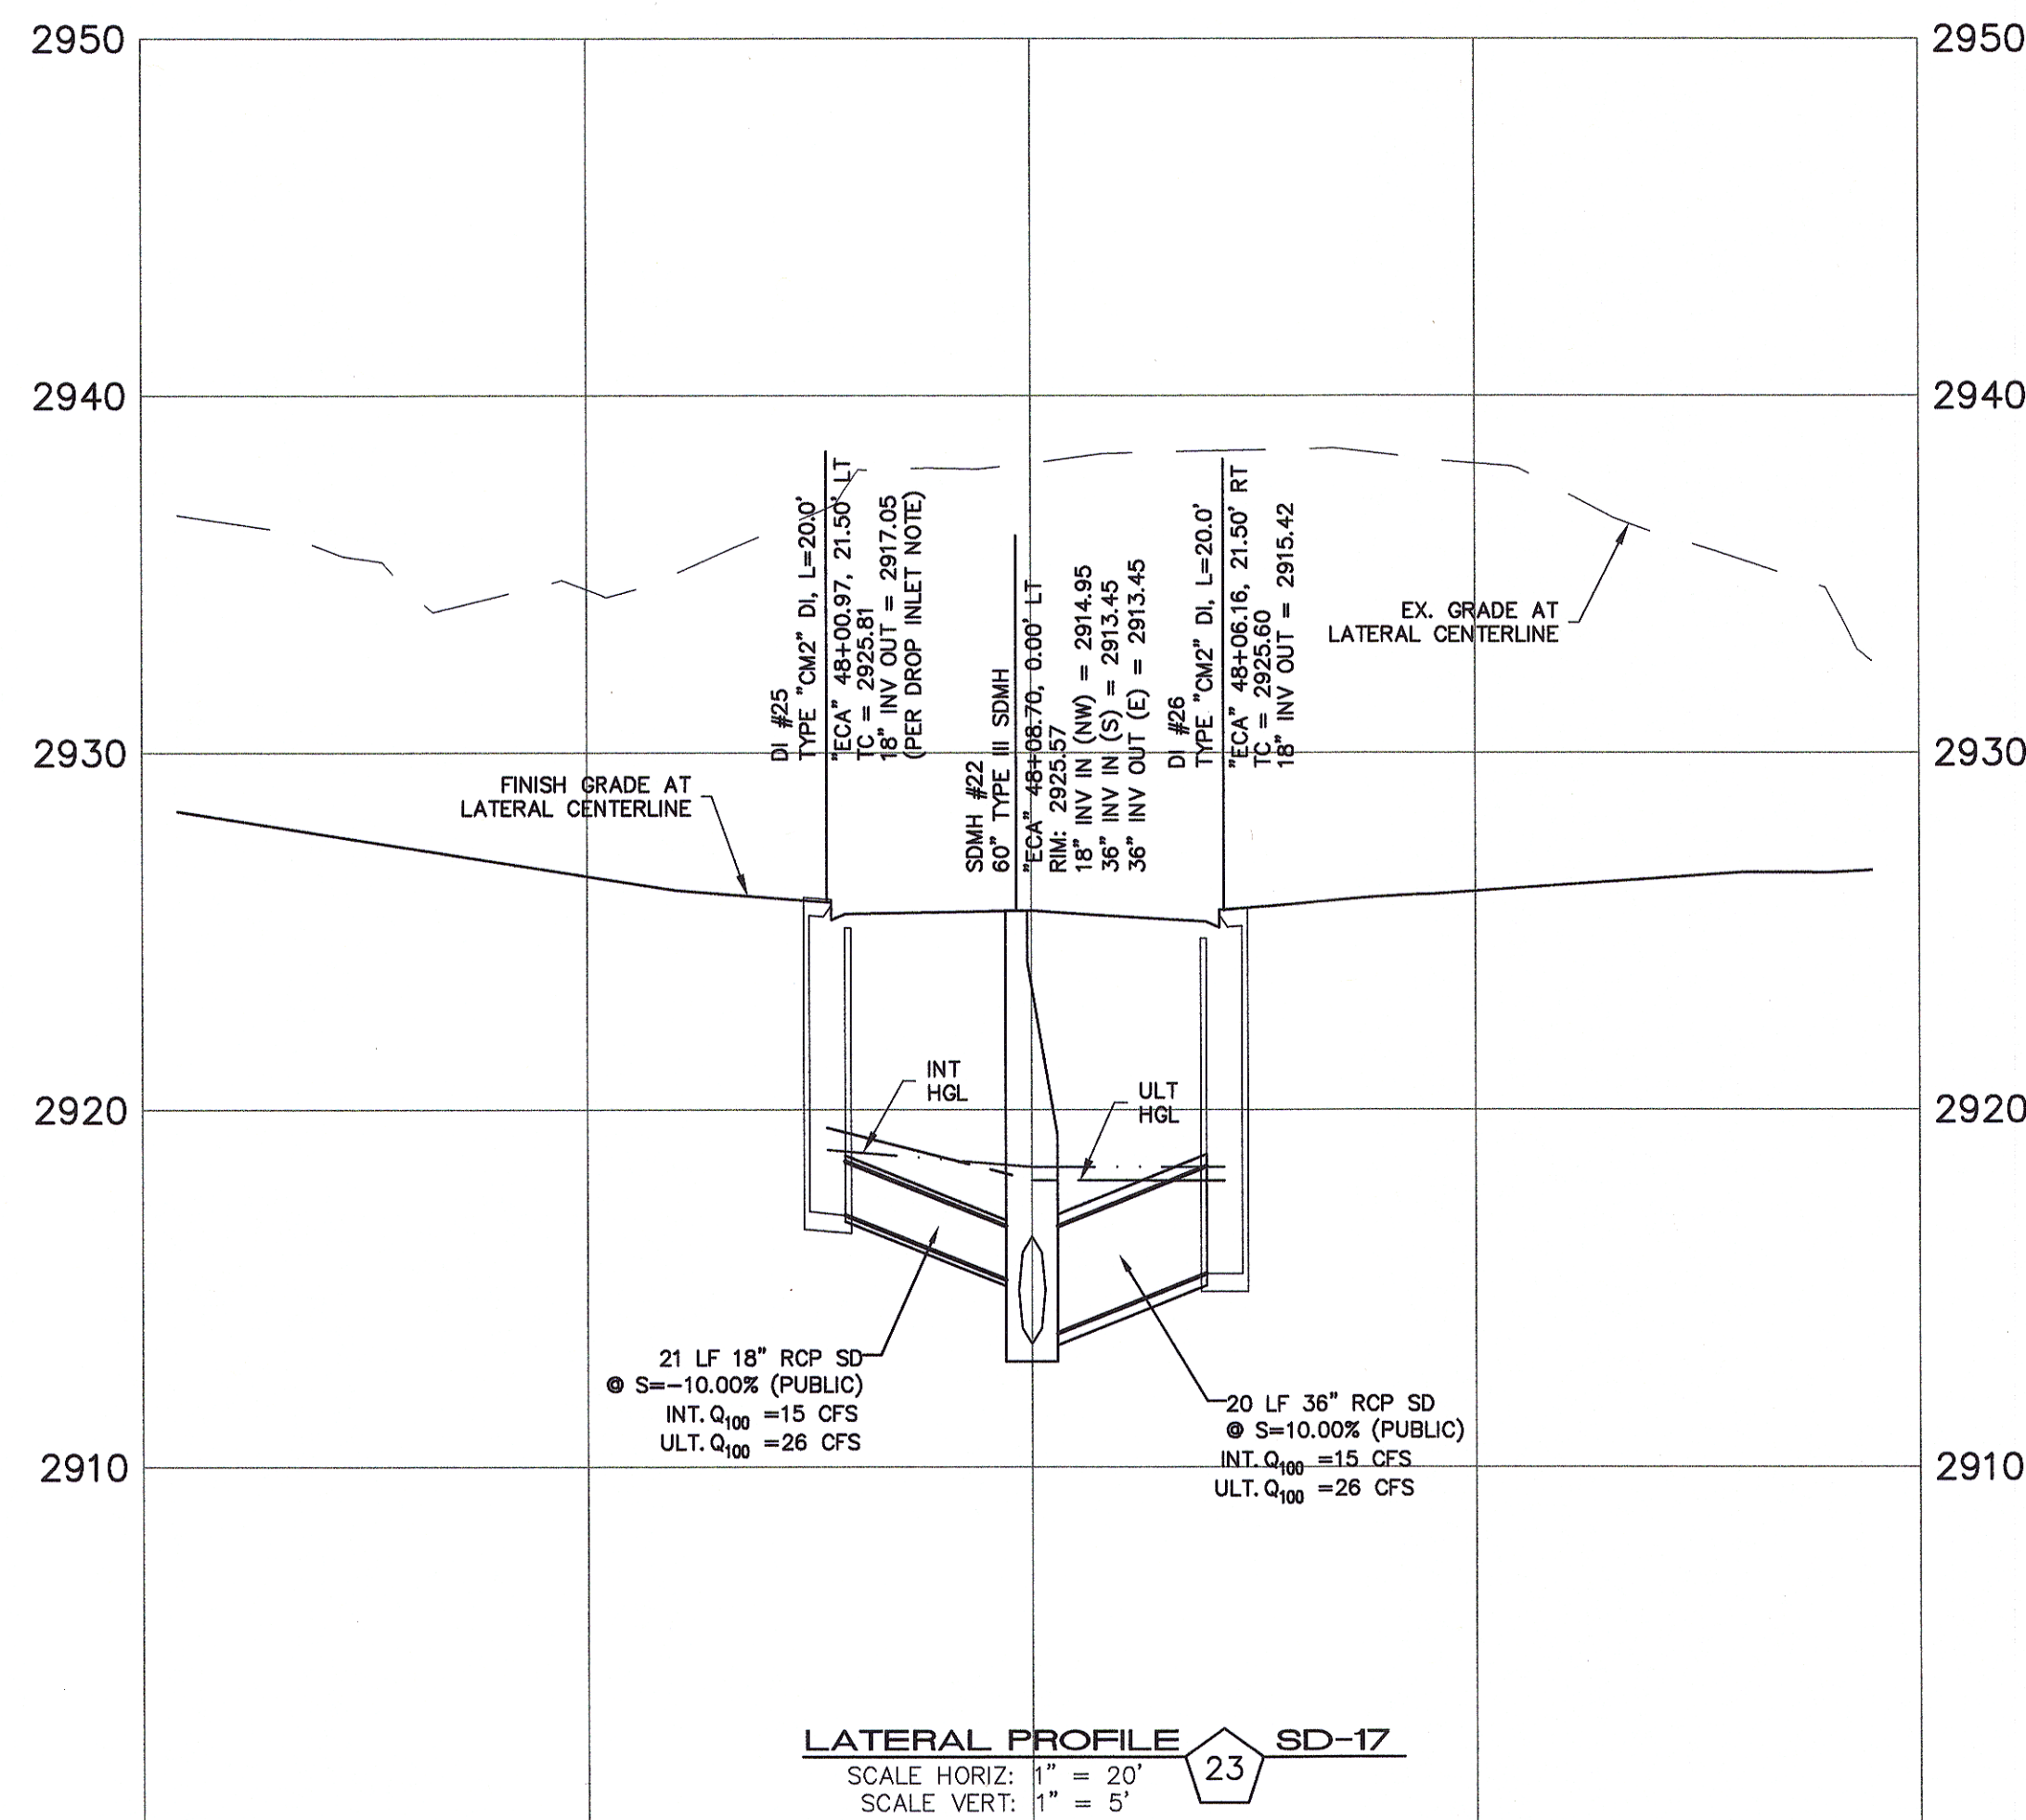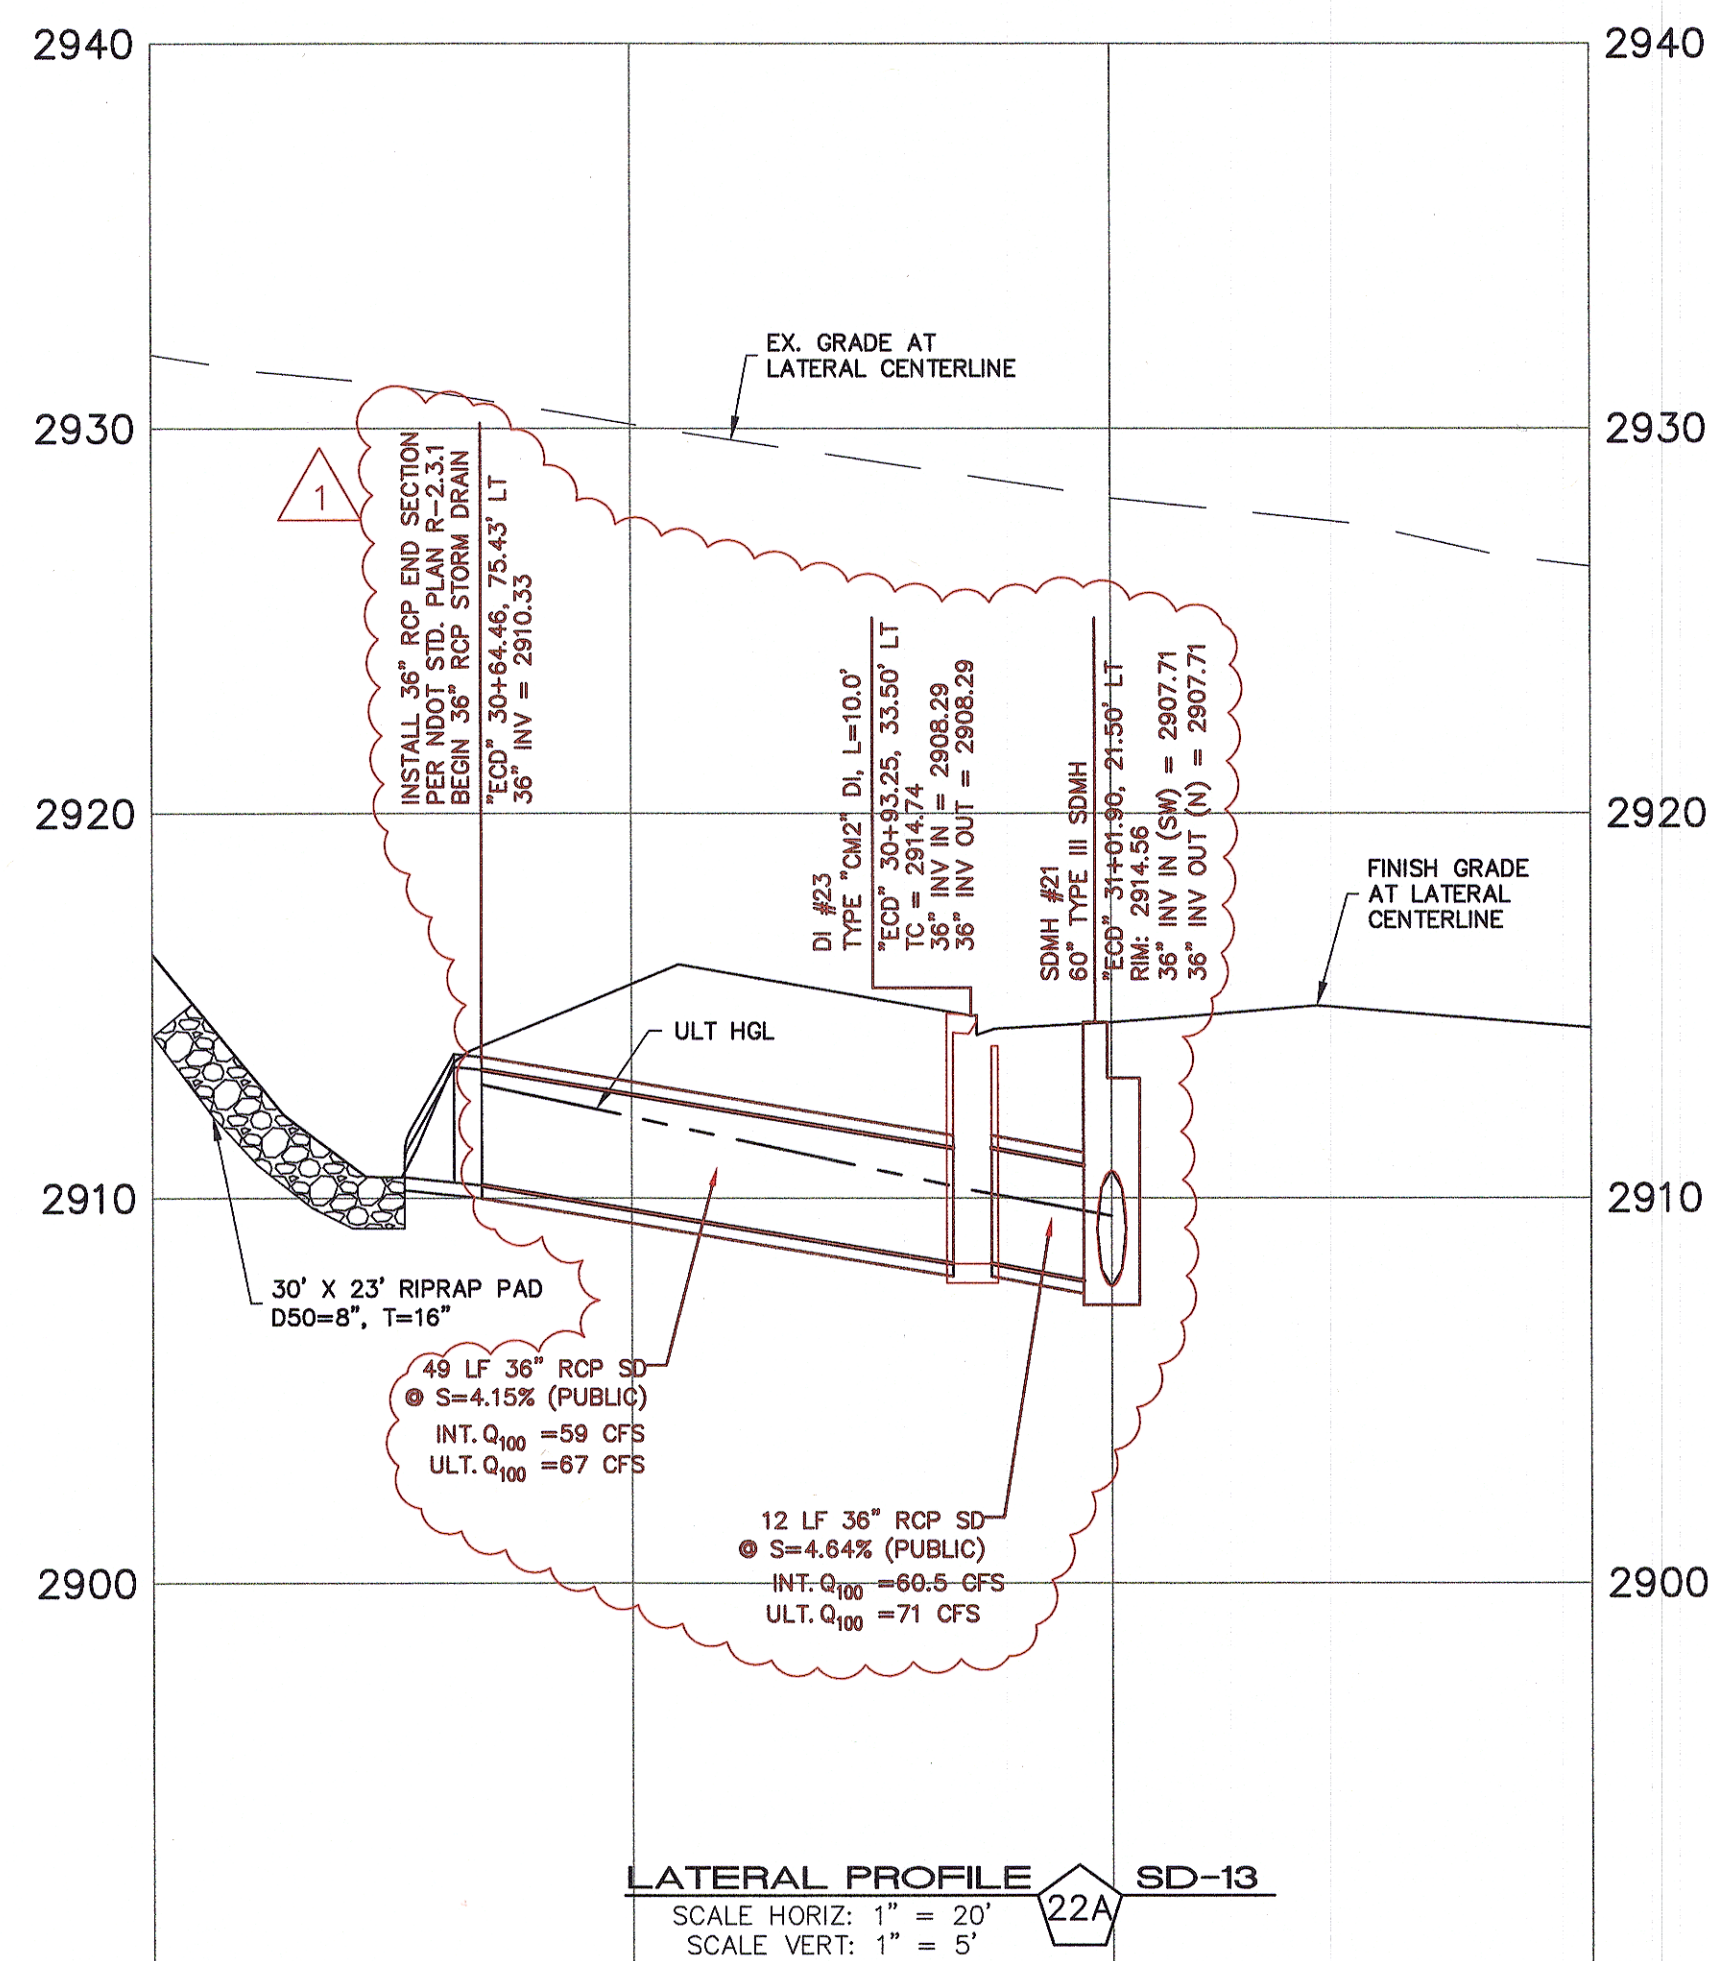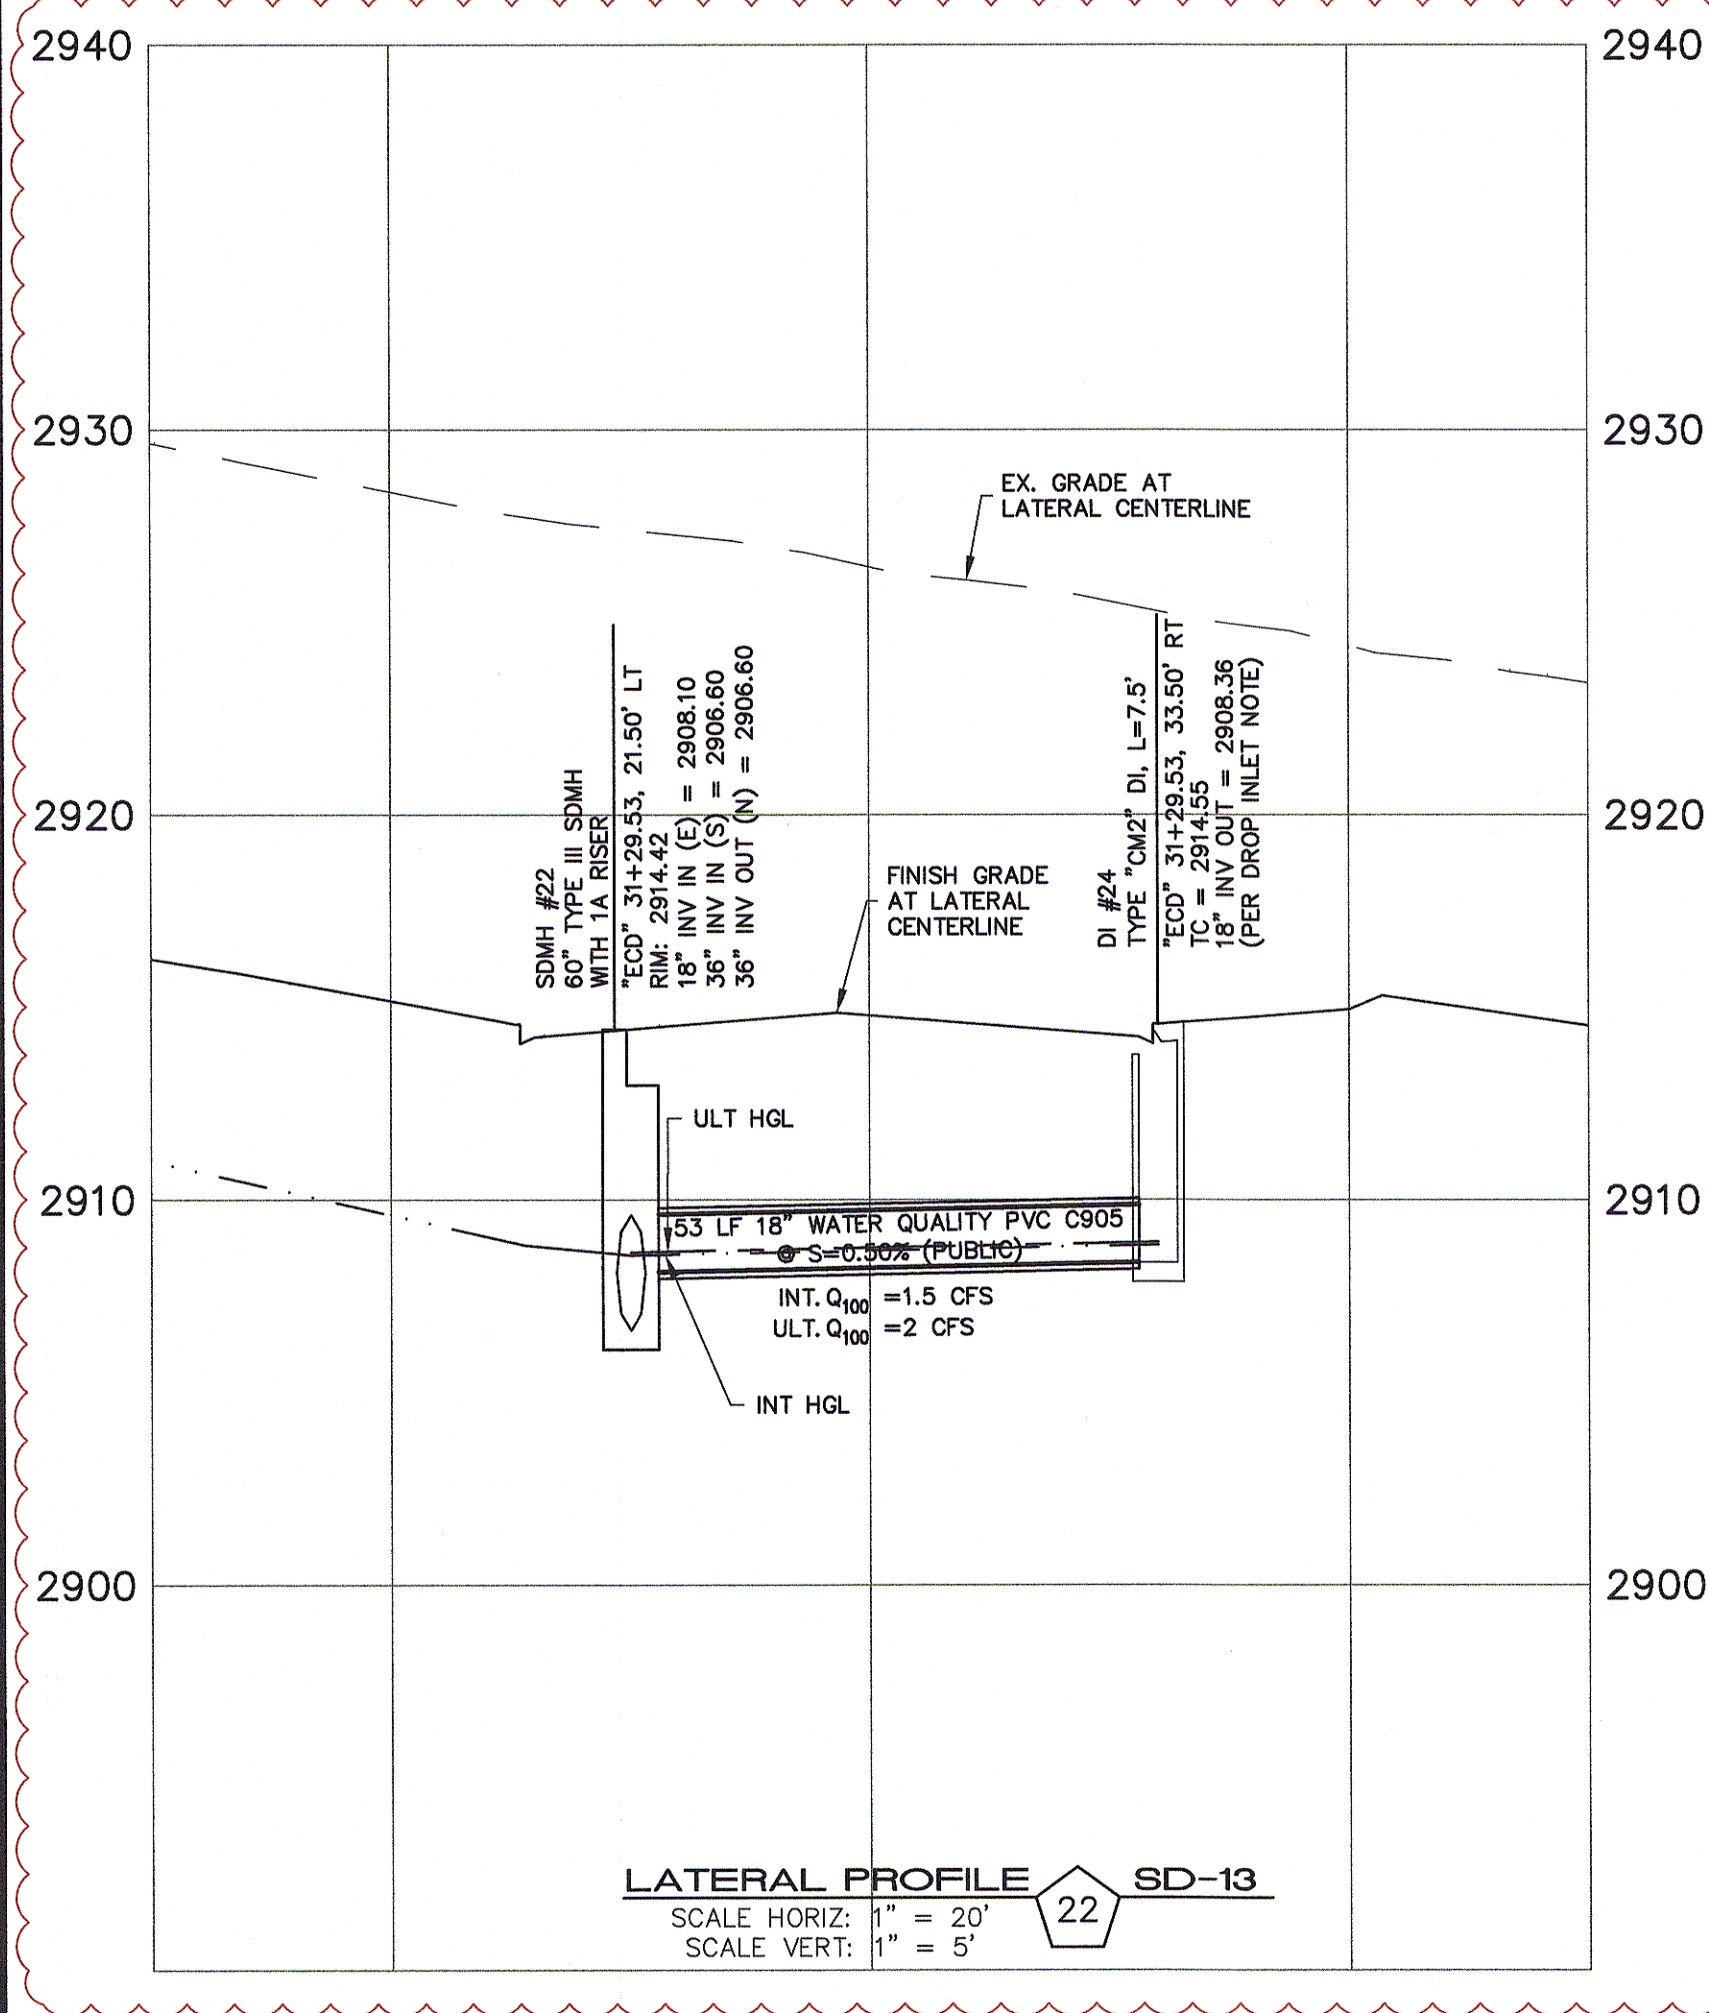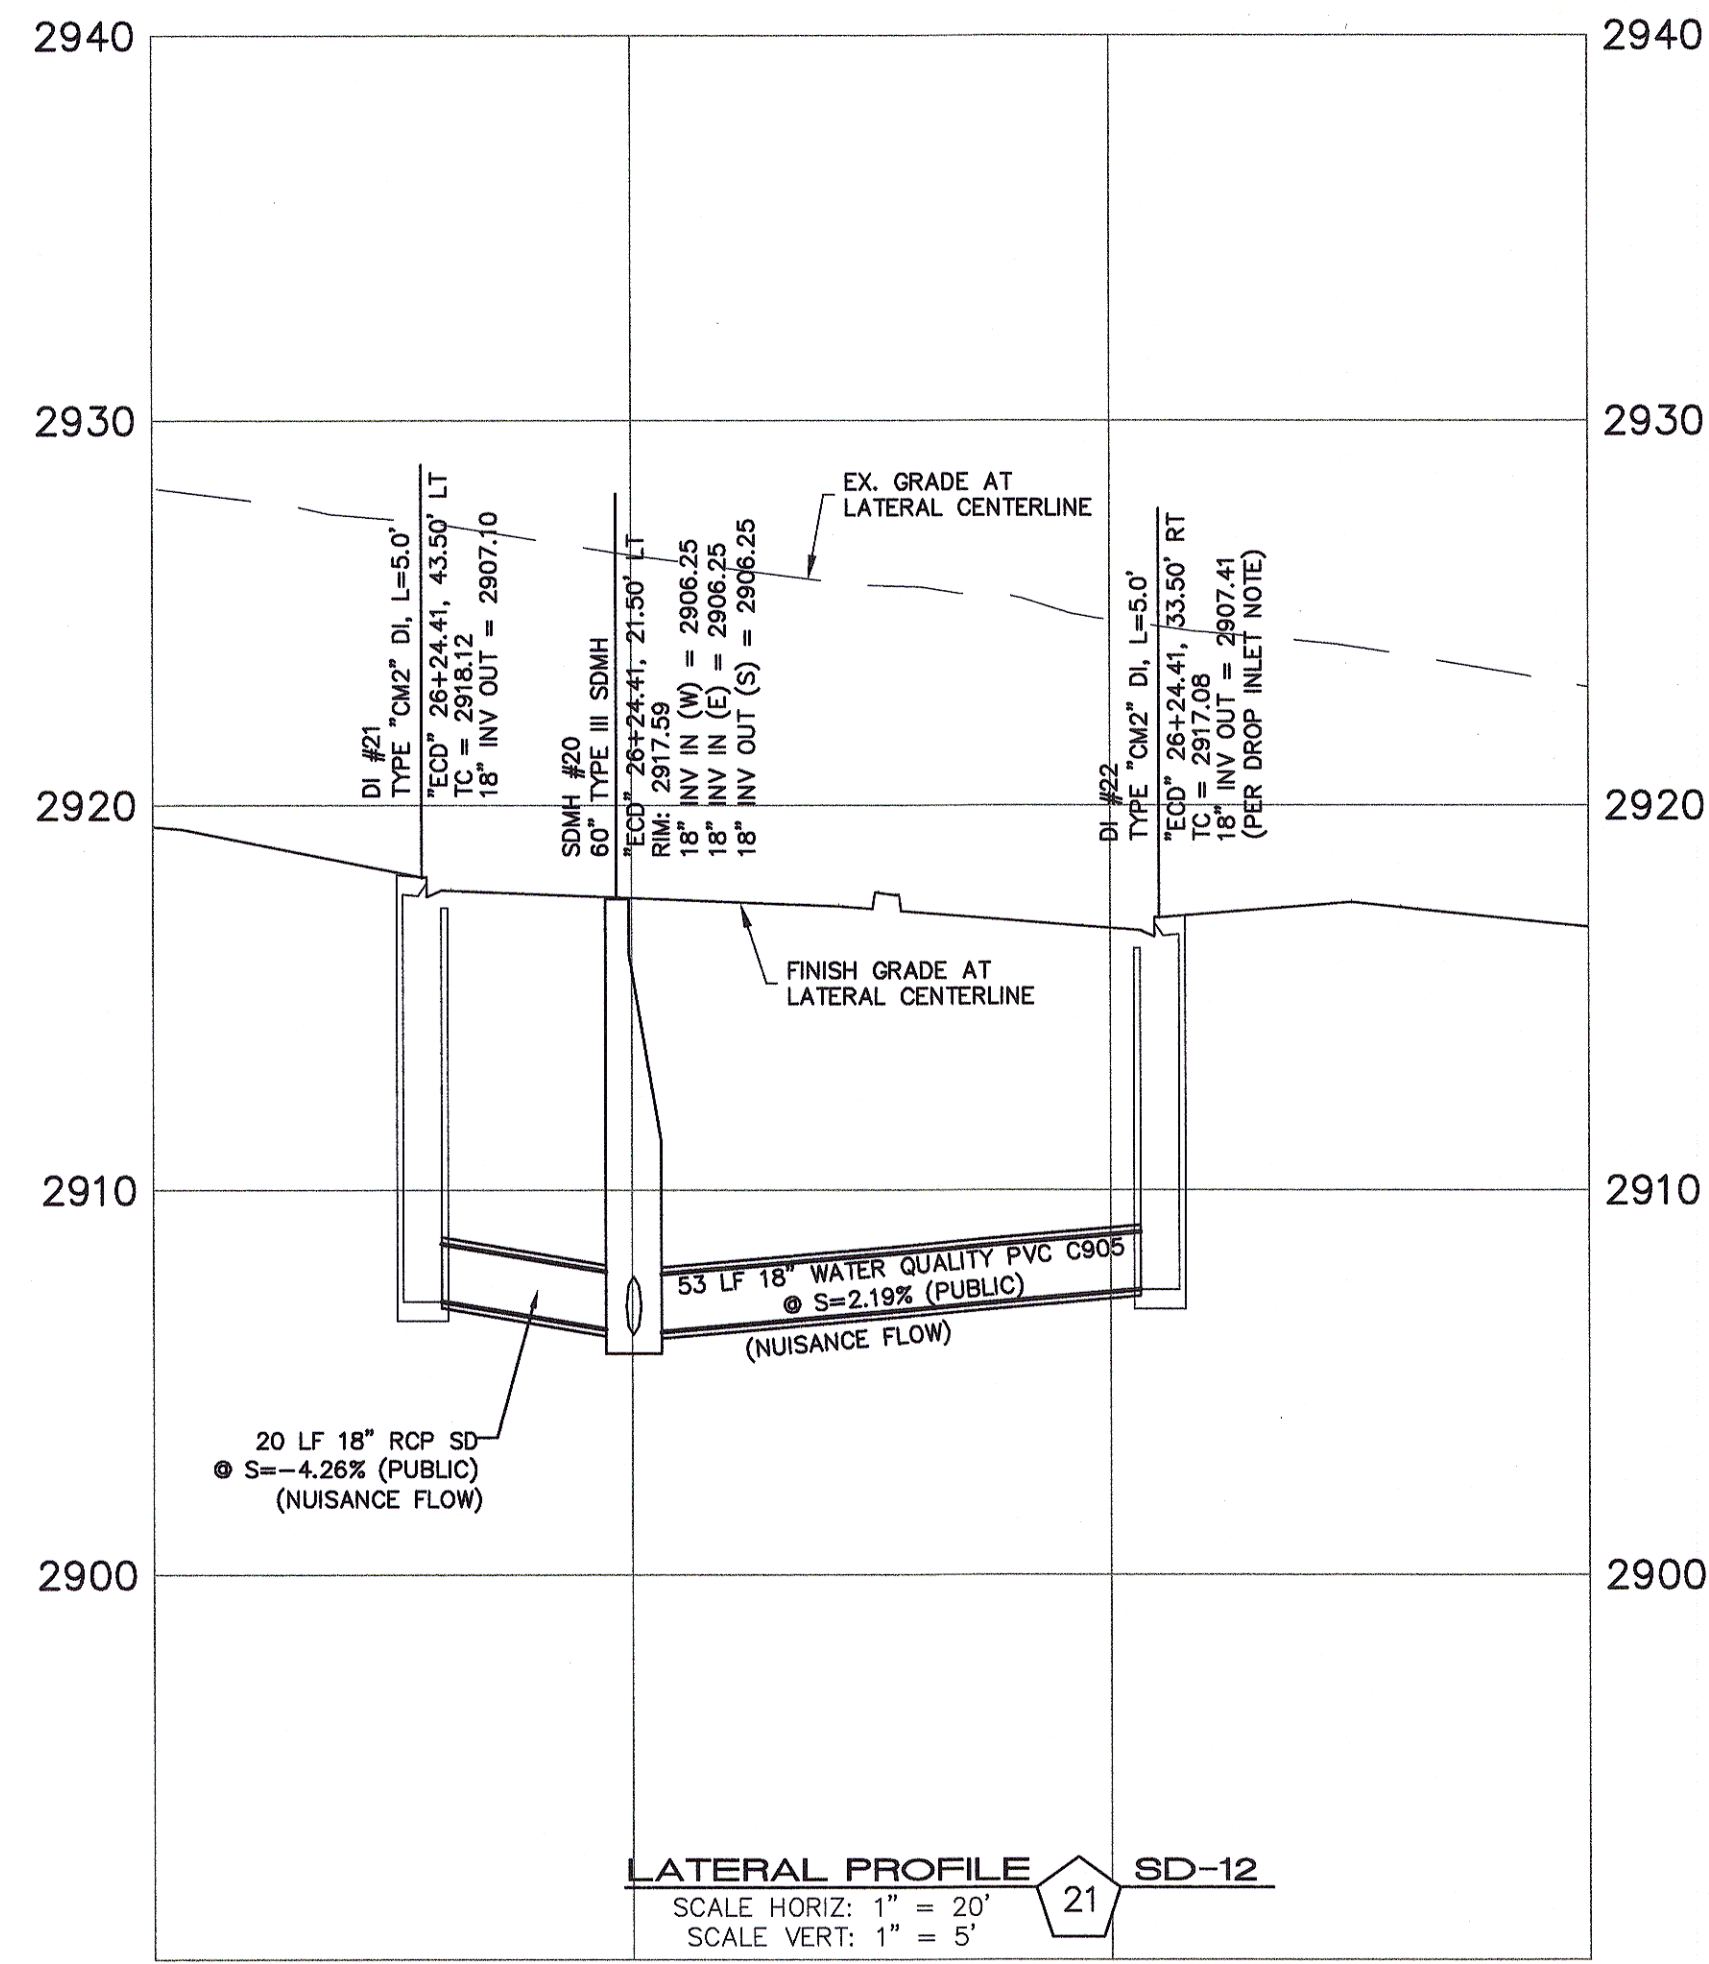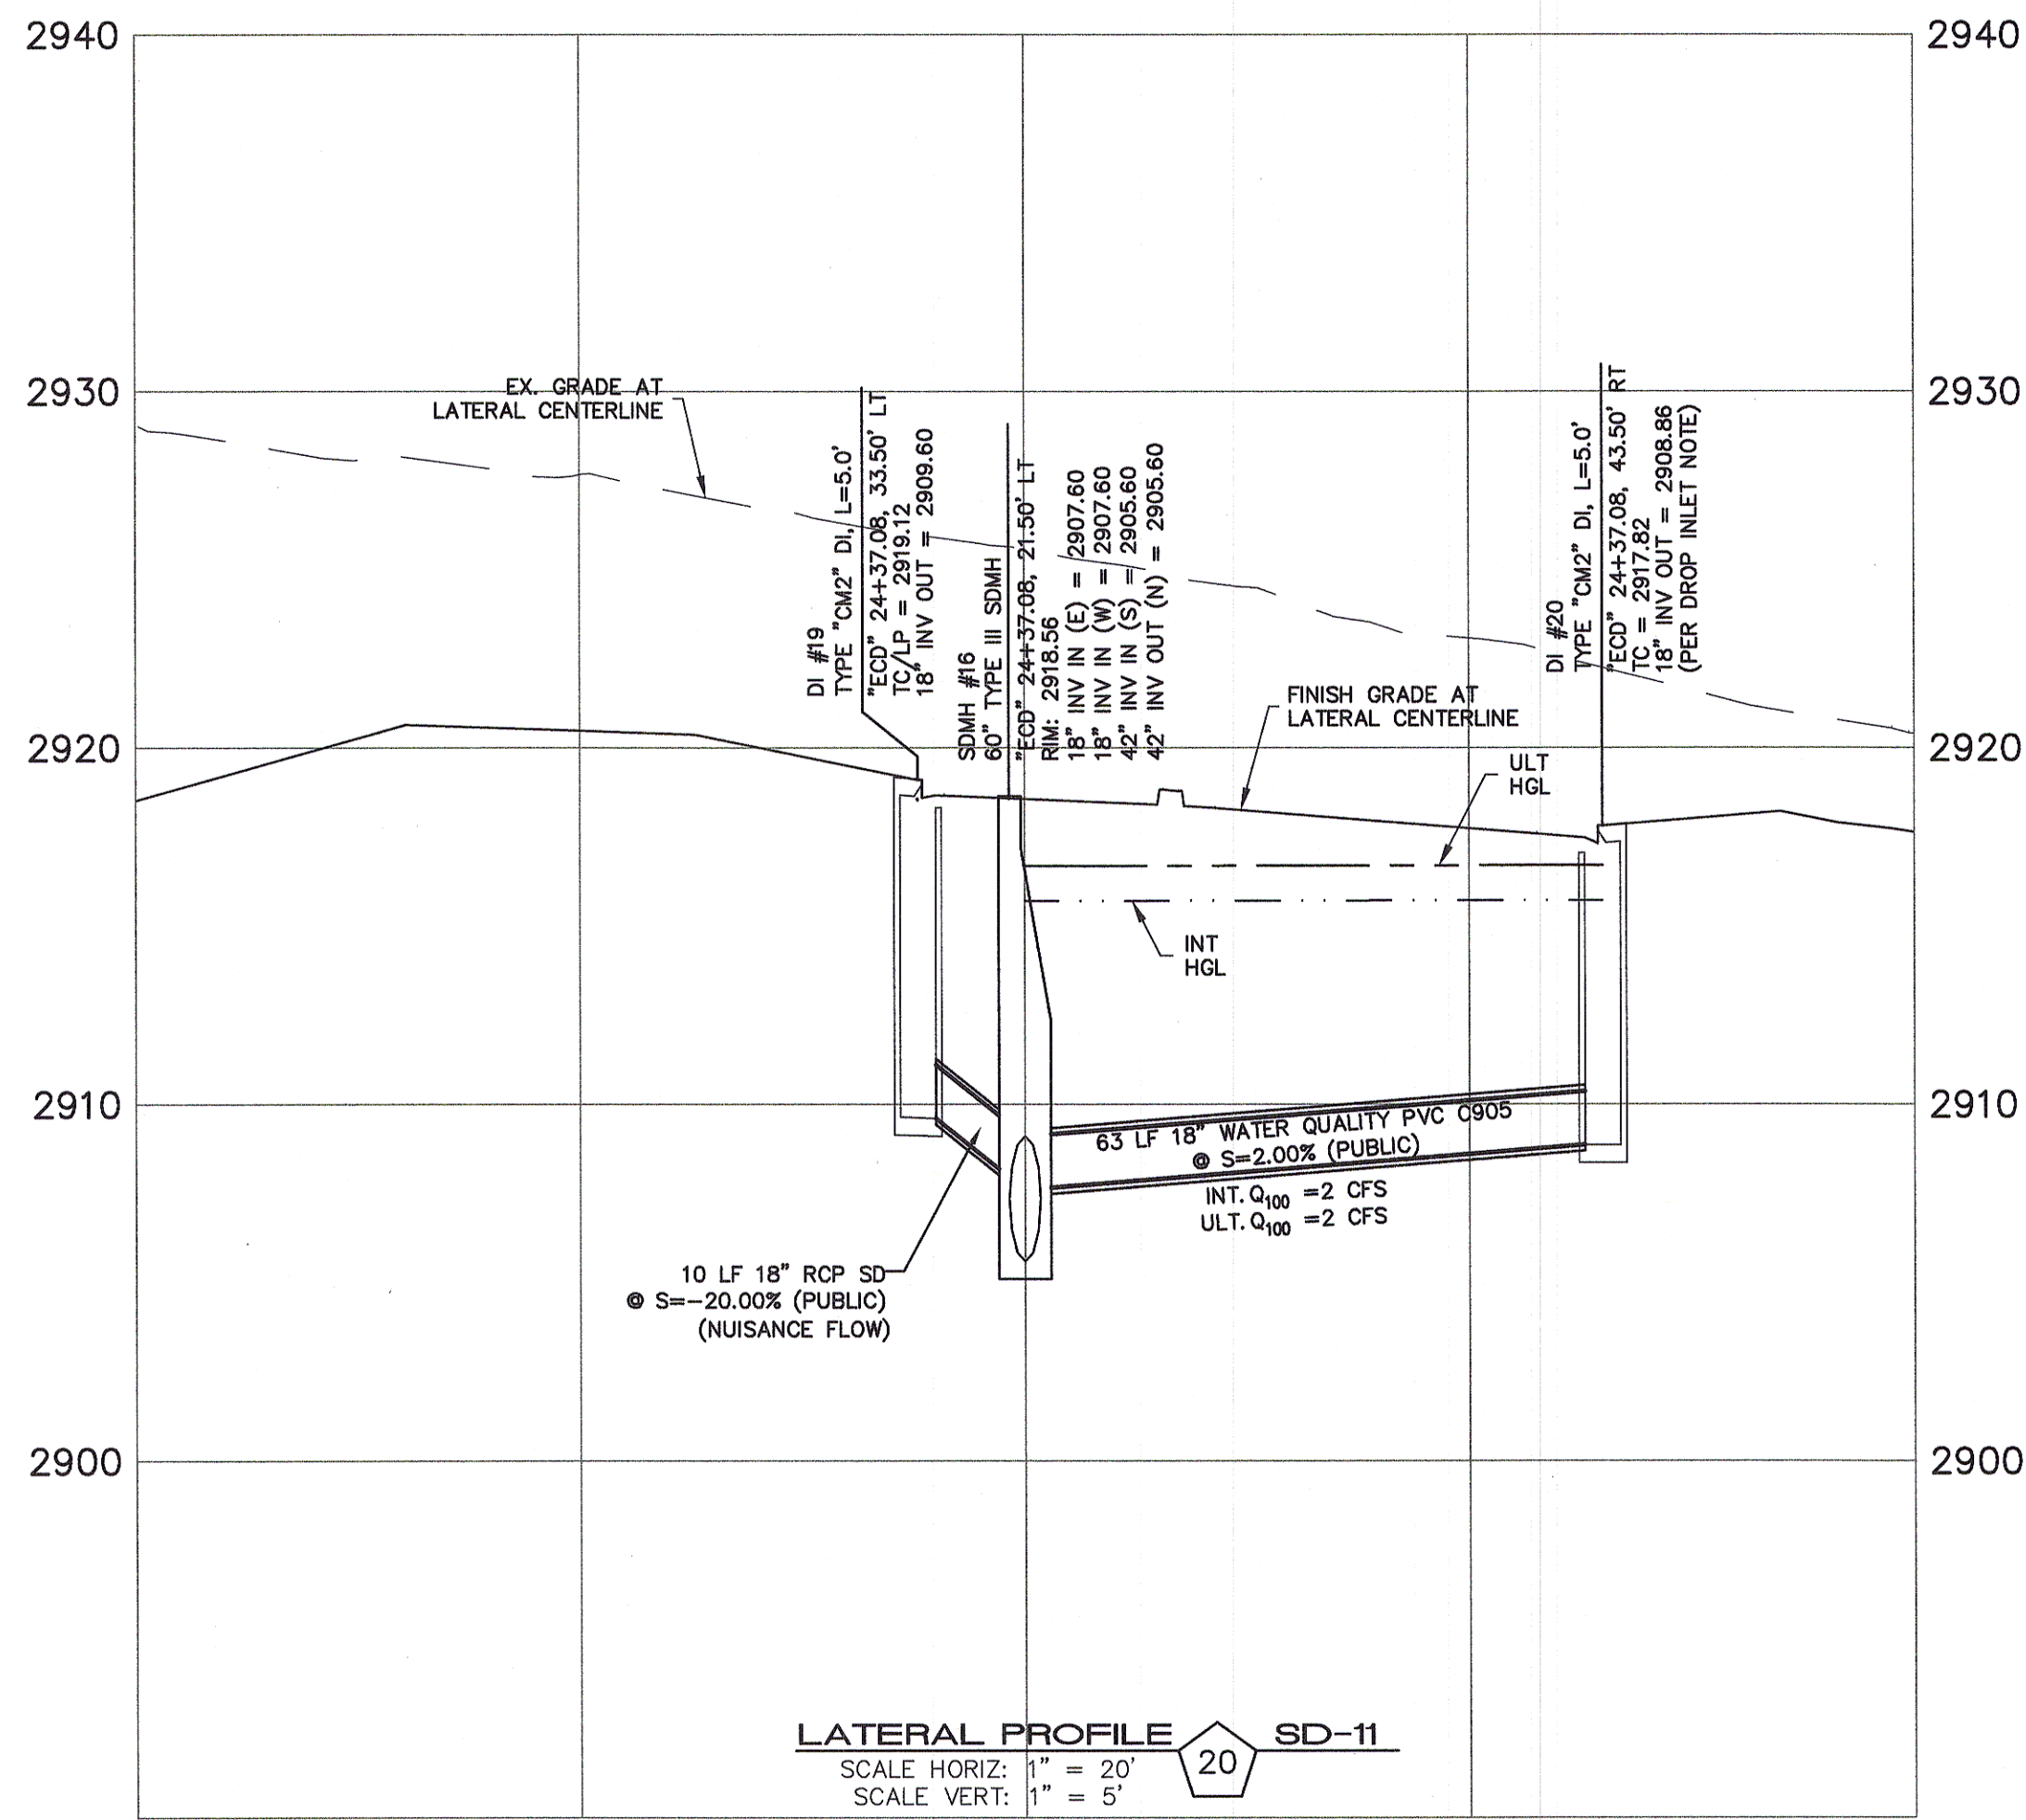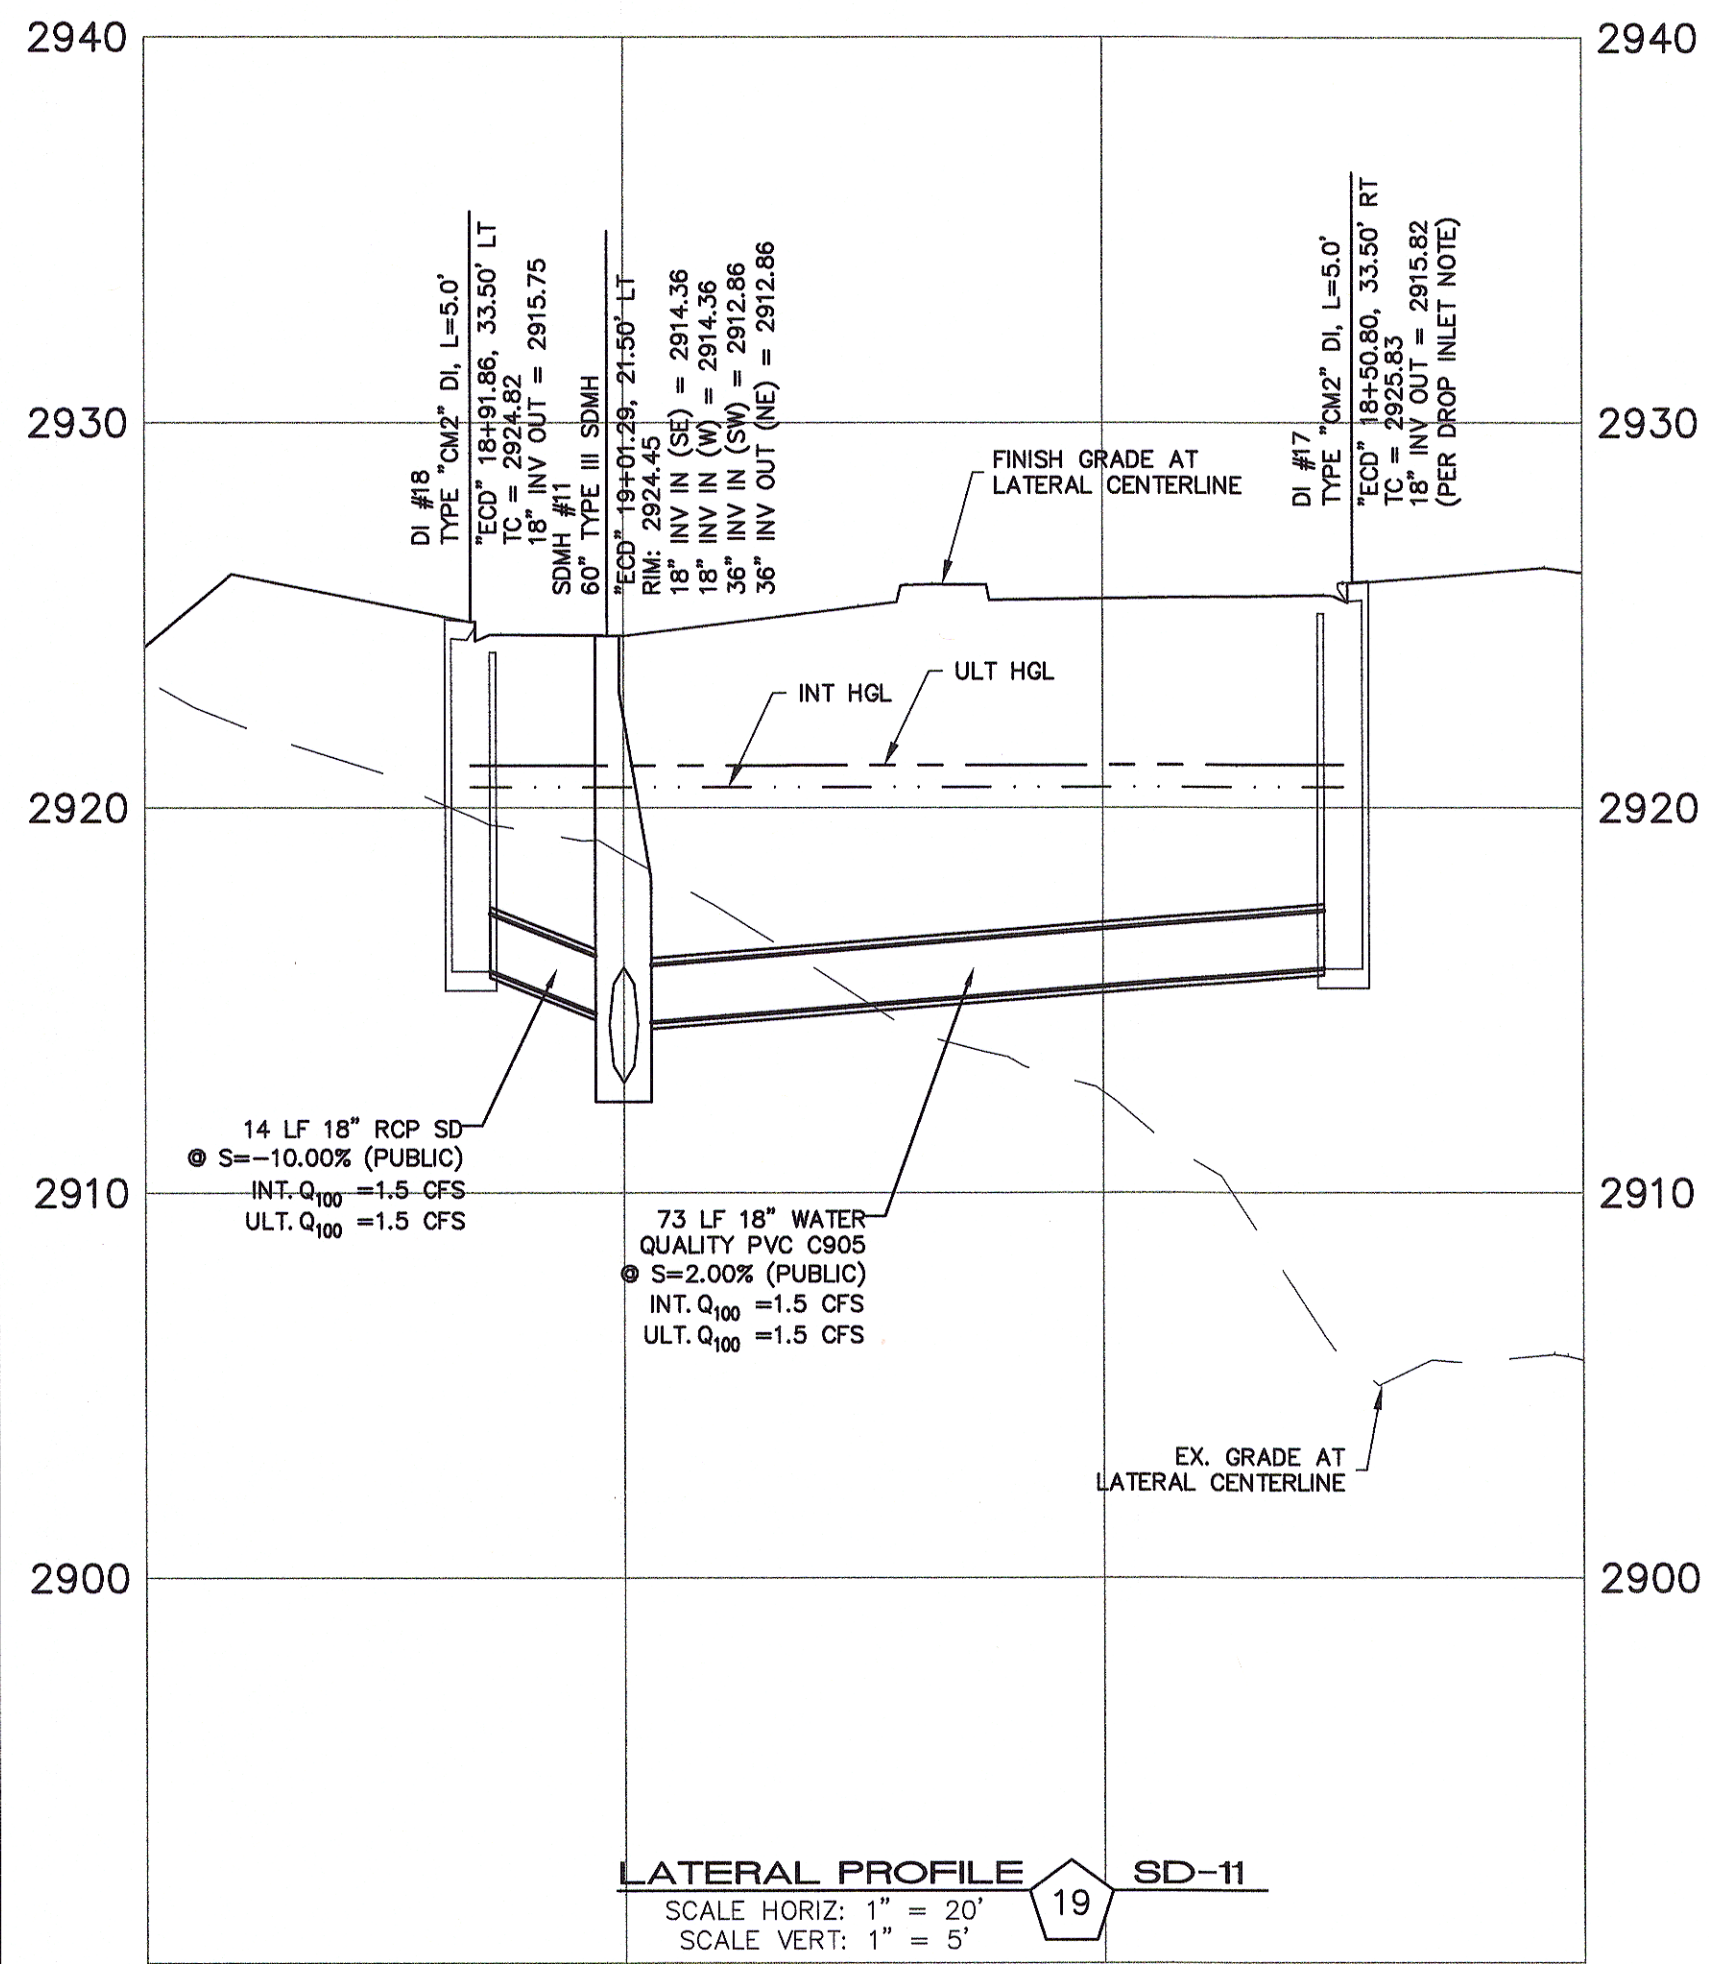

DROP INLET NOTE
WHERE 10 FEET PARALLEL SEPARATION IS NOT PRACTICABLE:
CAST-IN-PLACE MONOLITHIC POUR WITH WATERSTOP BETWEEN SLAB AND WALLS.
BASE, WALLS AND TOP TO BE CONSTRUCTED WITH WATERSTOPS, CENTER BULB,
OR FLAT STRIP (VINYLEX, GREENSTREAK PLASTIC PRODUCTS OR APPROVED EQUAL).

APPROVED FOR CONSTRUCTION
LVVWD WILL HAVE TO BE PRESENT AND VIEW INSTALLATION OF STORM
DRAIN THAT WILL BE INSTALLED THAT MAY AFFECT THE WATER MAINS
DATE
LVVWD ENGINEERING SERVICES MANAGER
PROJECT NO. 124568

SLATER
HANIFAN
GROUP

CONSULTING ENGINEERS & PLANNERS

5740 S. ARVILLE STREET #216, LAS VEGAS, NV 89118
PHONE (702) 284-5300 FAX (702) 284-5399

NO.	DESCRIPTION	DATE	BY	APP.
1	REVISED STORM DRAIN	6/20/17	JJS	

NINETY-FIVE MANAGEMENT LLC

SKYE CANYON II PHASE 2 MASS GRADING

STORM DRAIN LATERAL PROFILES

DATE: 8/3/16

DRAFTER: JAS







DESIGNER: DAM

CHECKED: JSR

PROJECT NO.
OLY1501-001

PROFESSIONAL ENGINEER STATE OF NEVADA
JERRY SLATER
Exp. 06/30/2018
CIVIL
No. 14167

SD-23
SHEET 26 OF 32

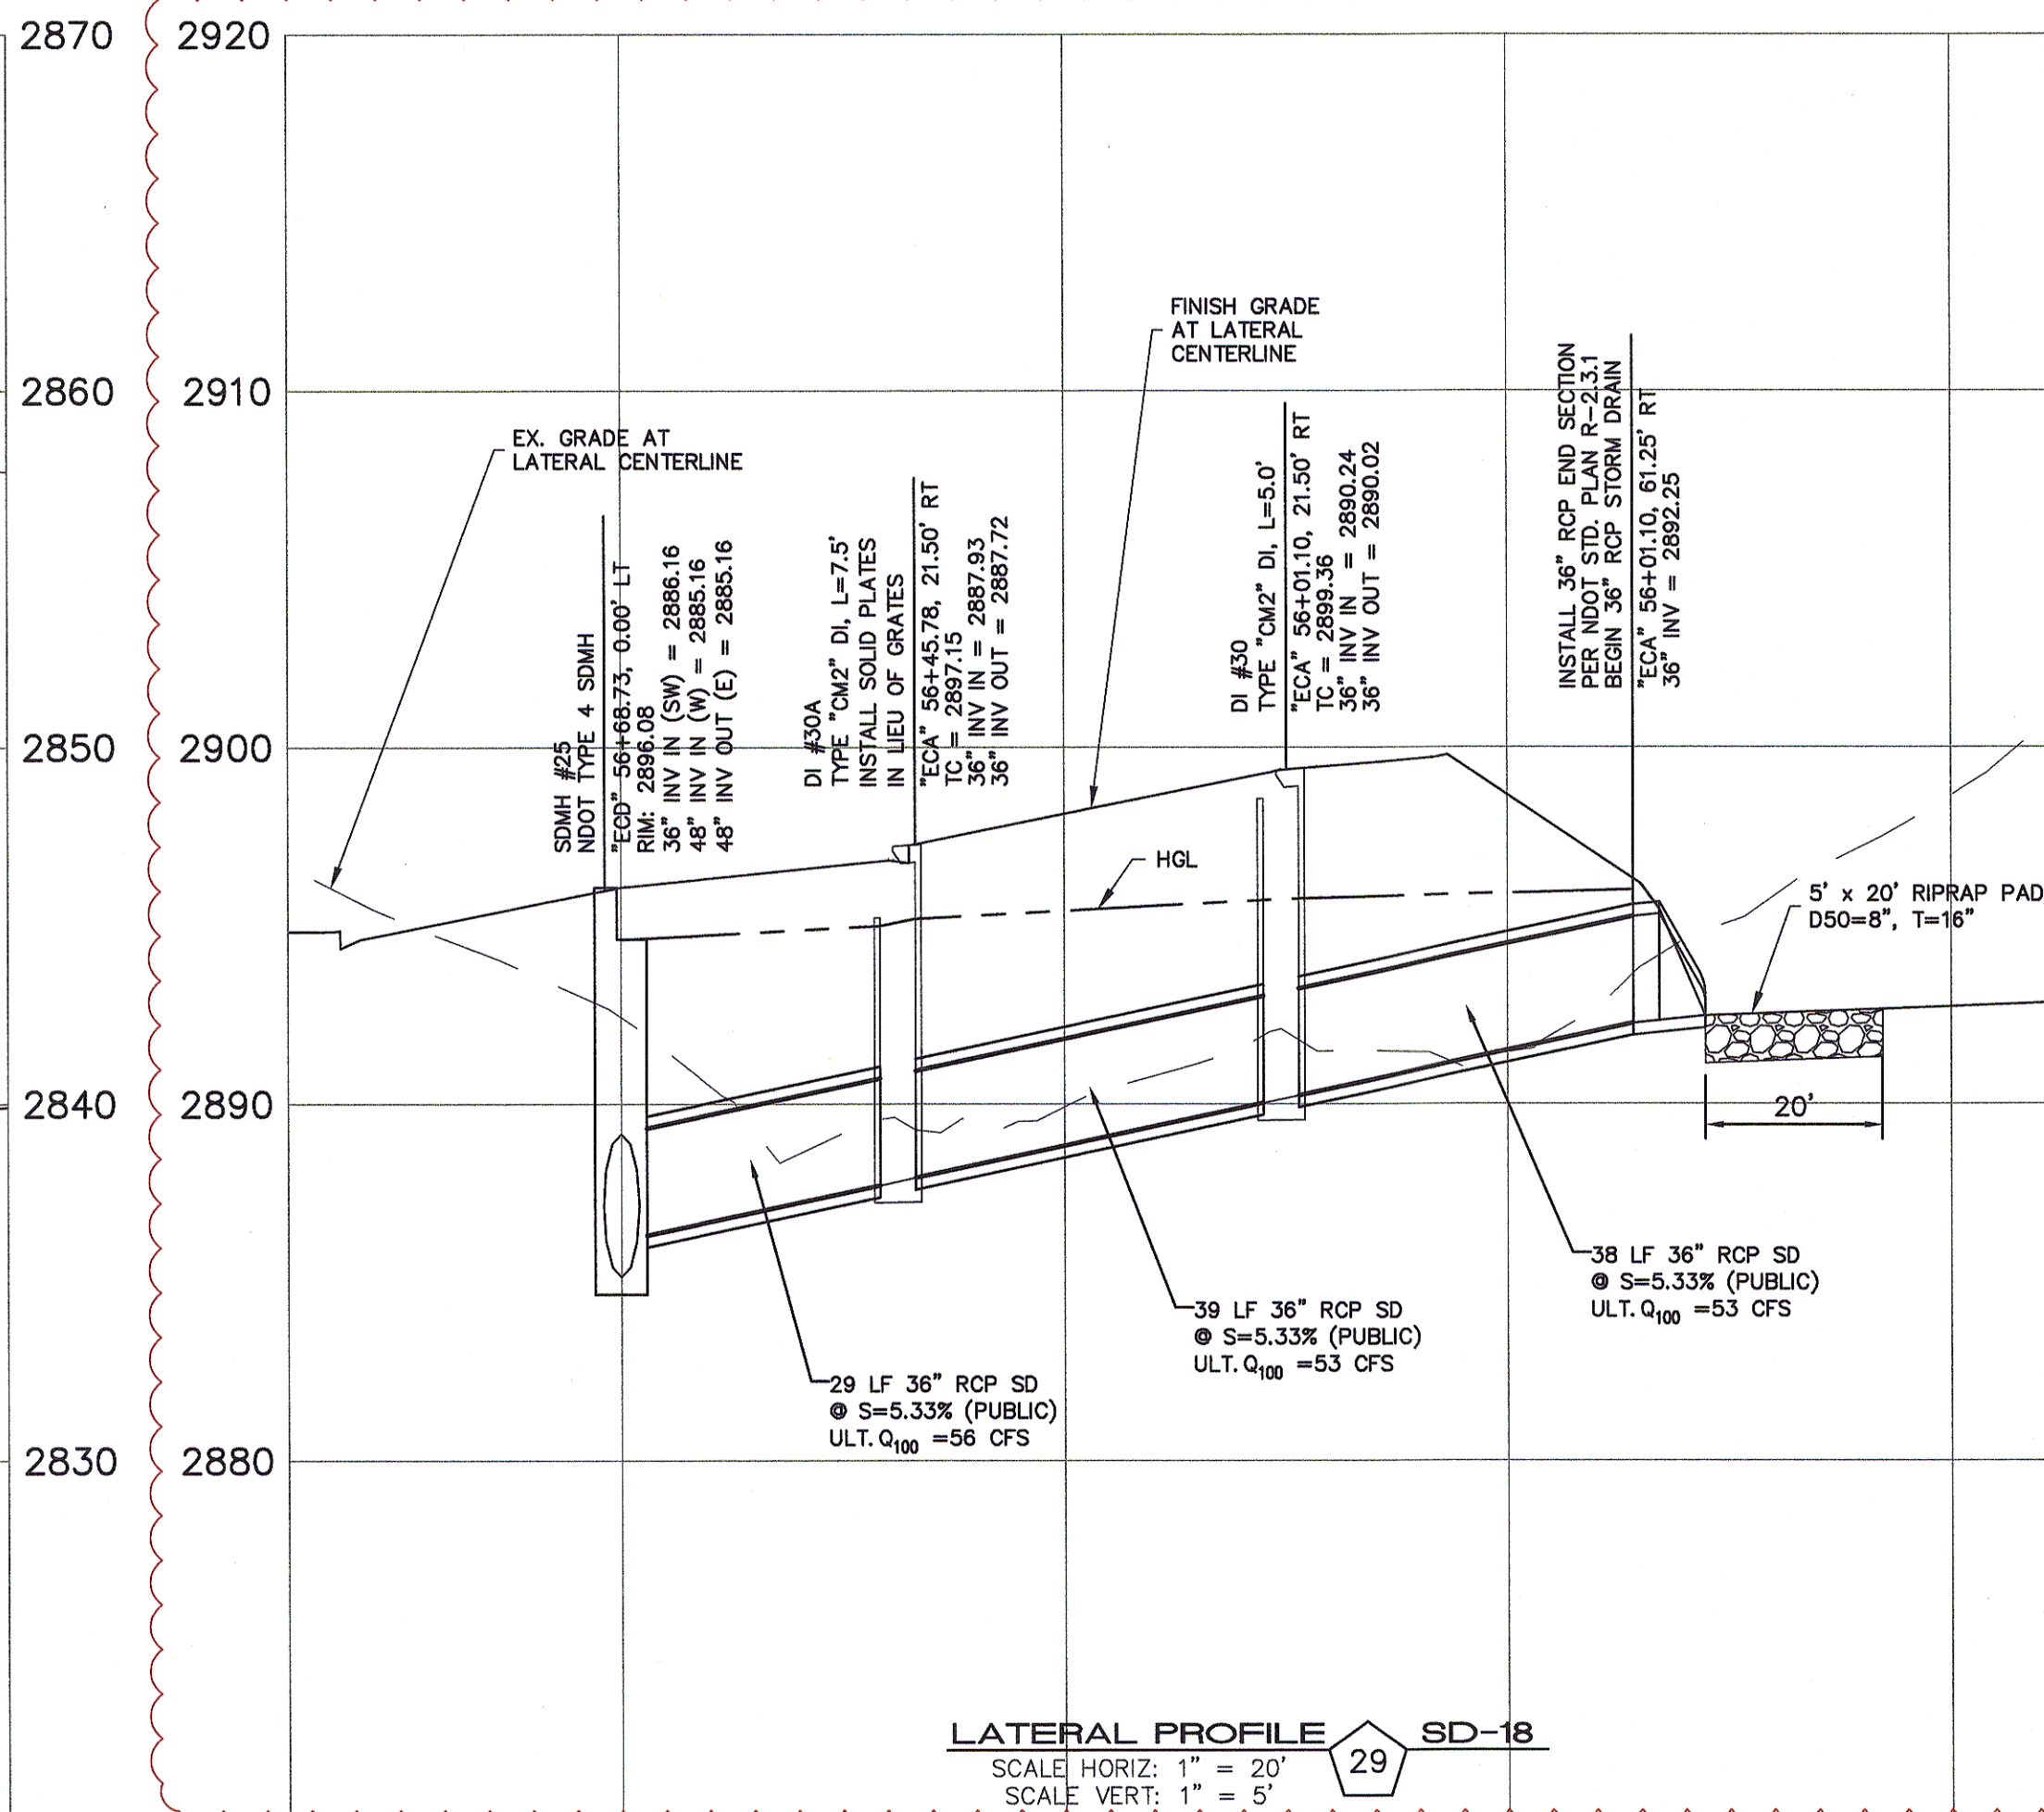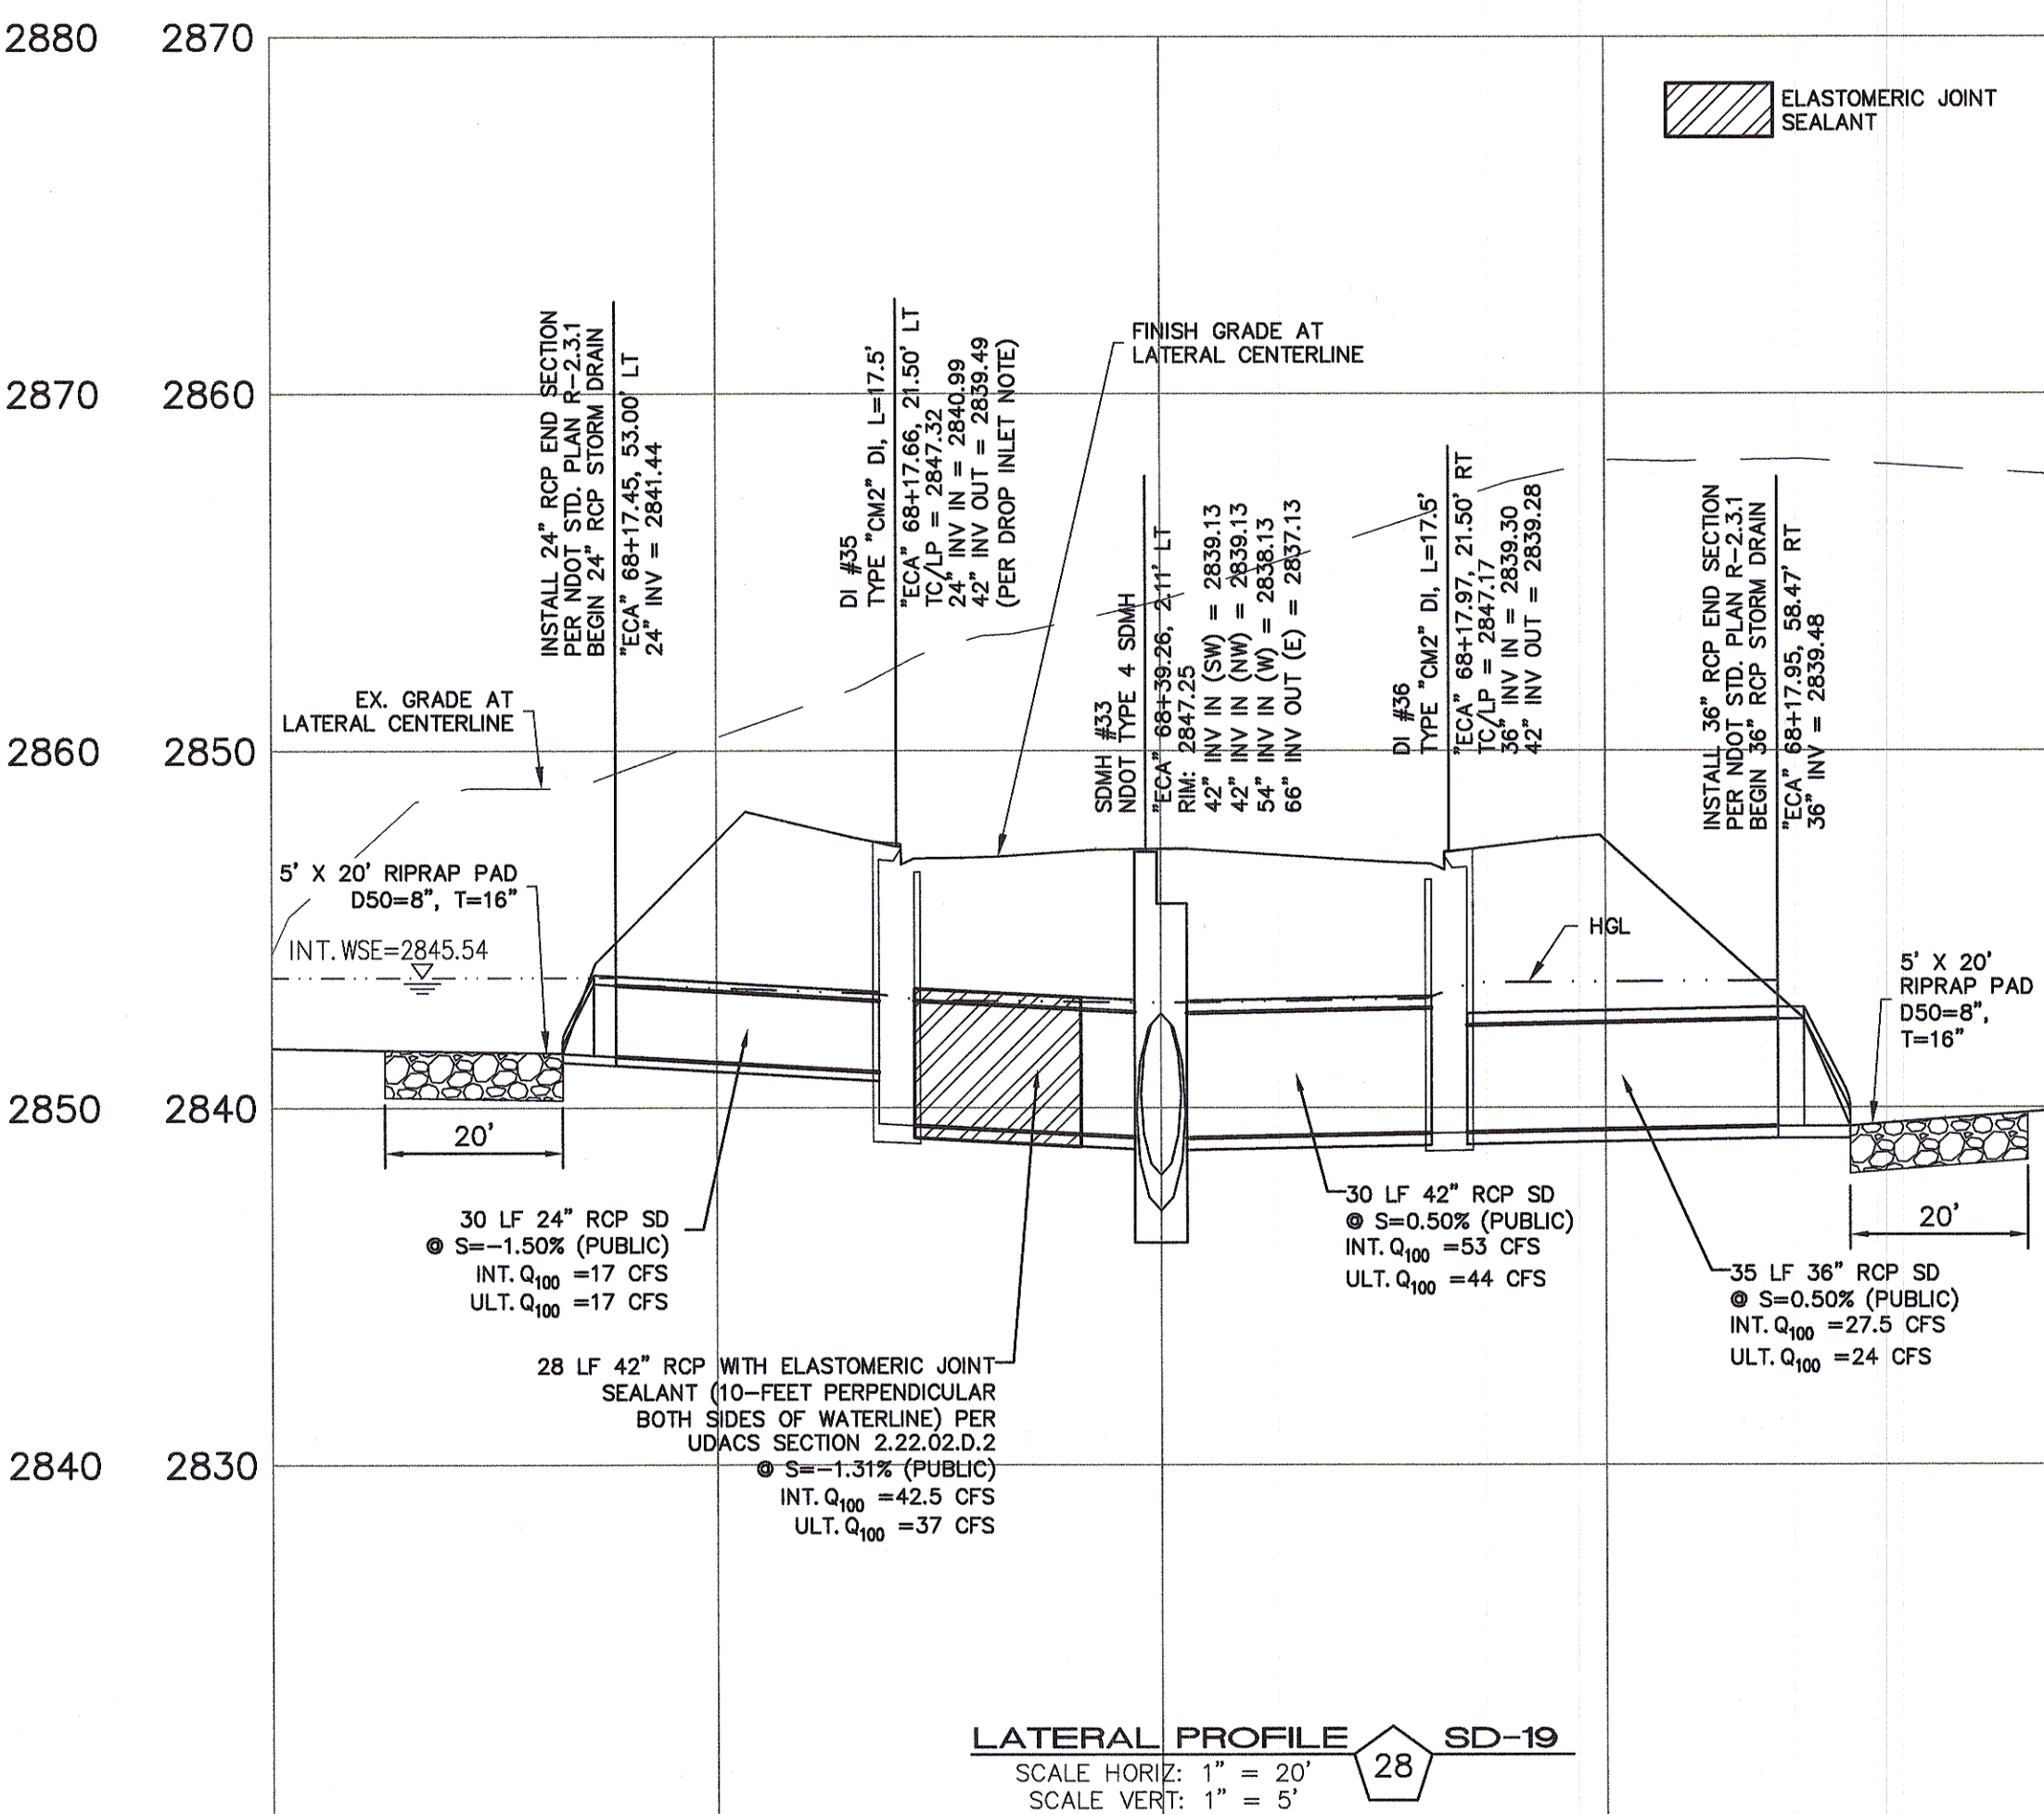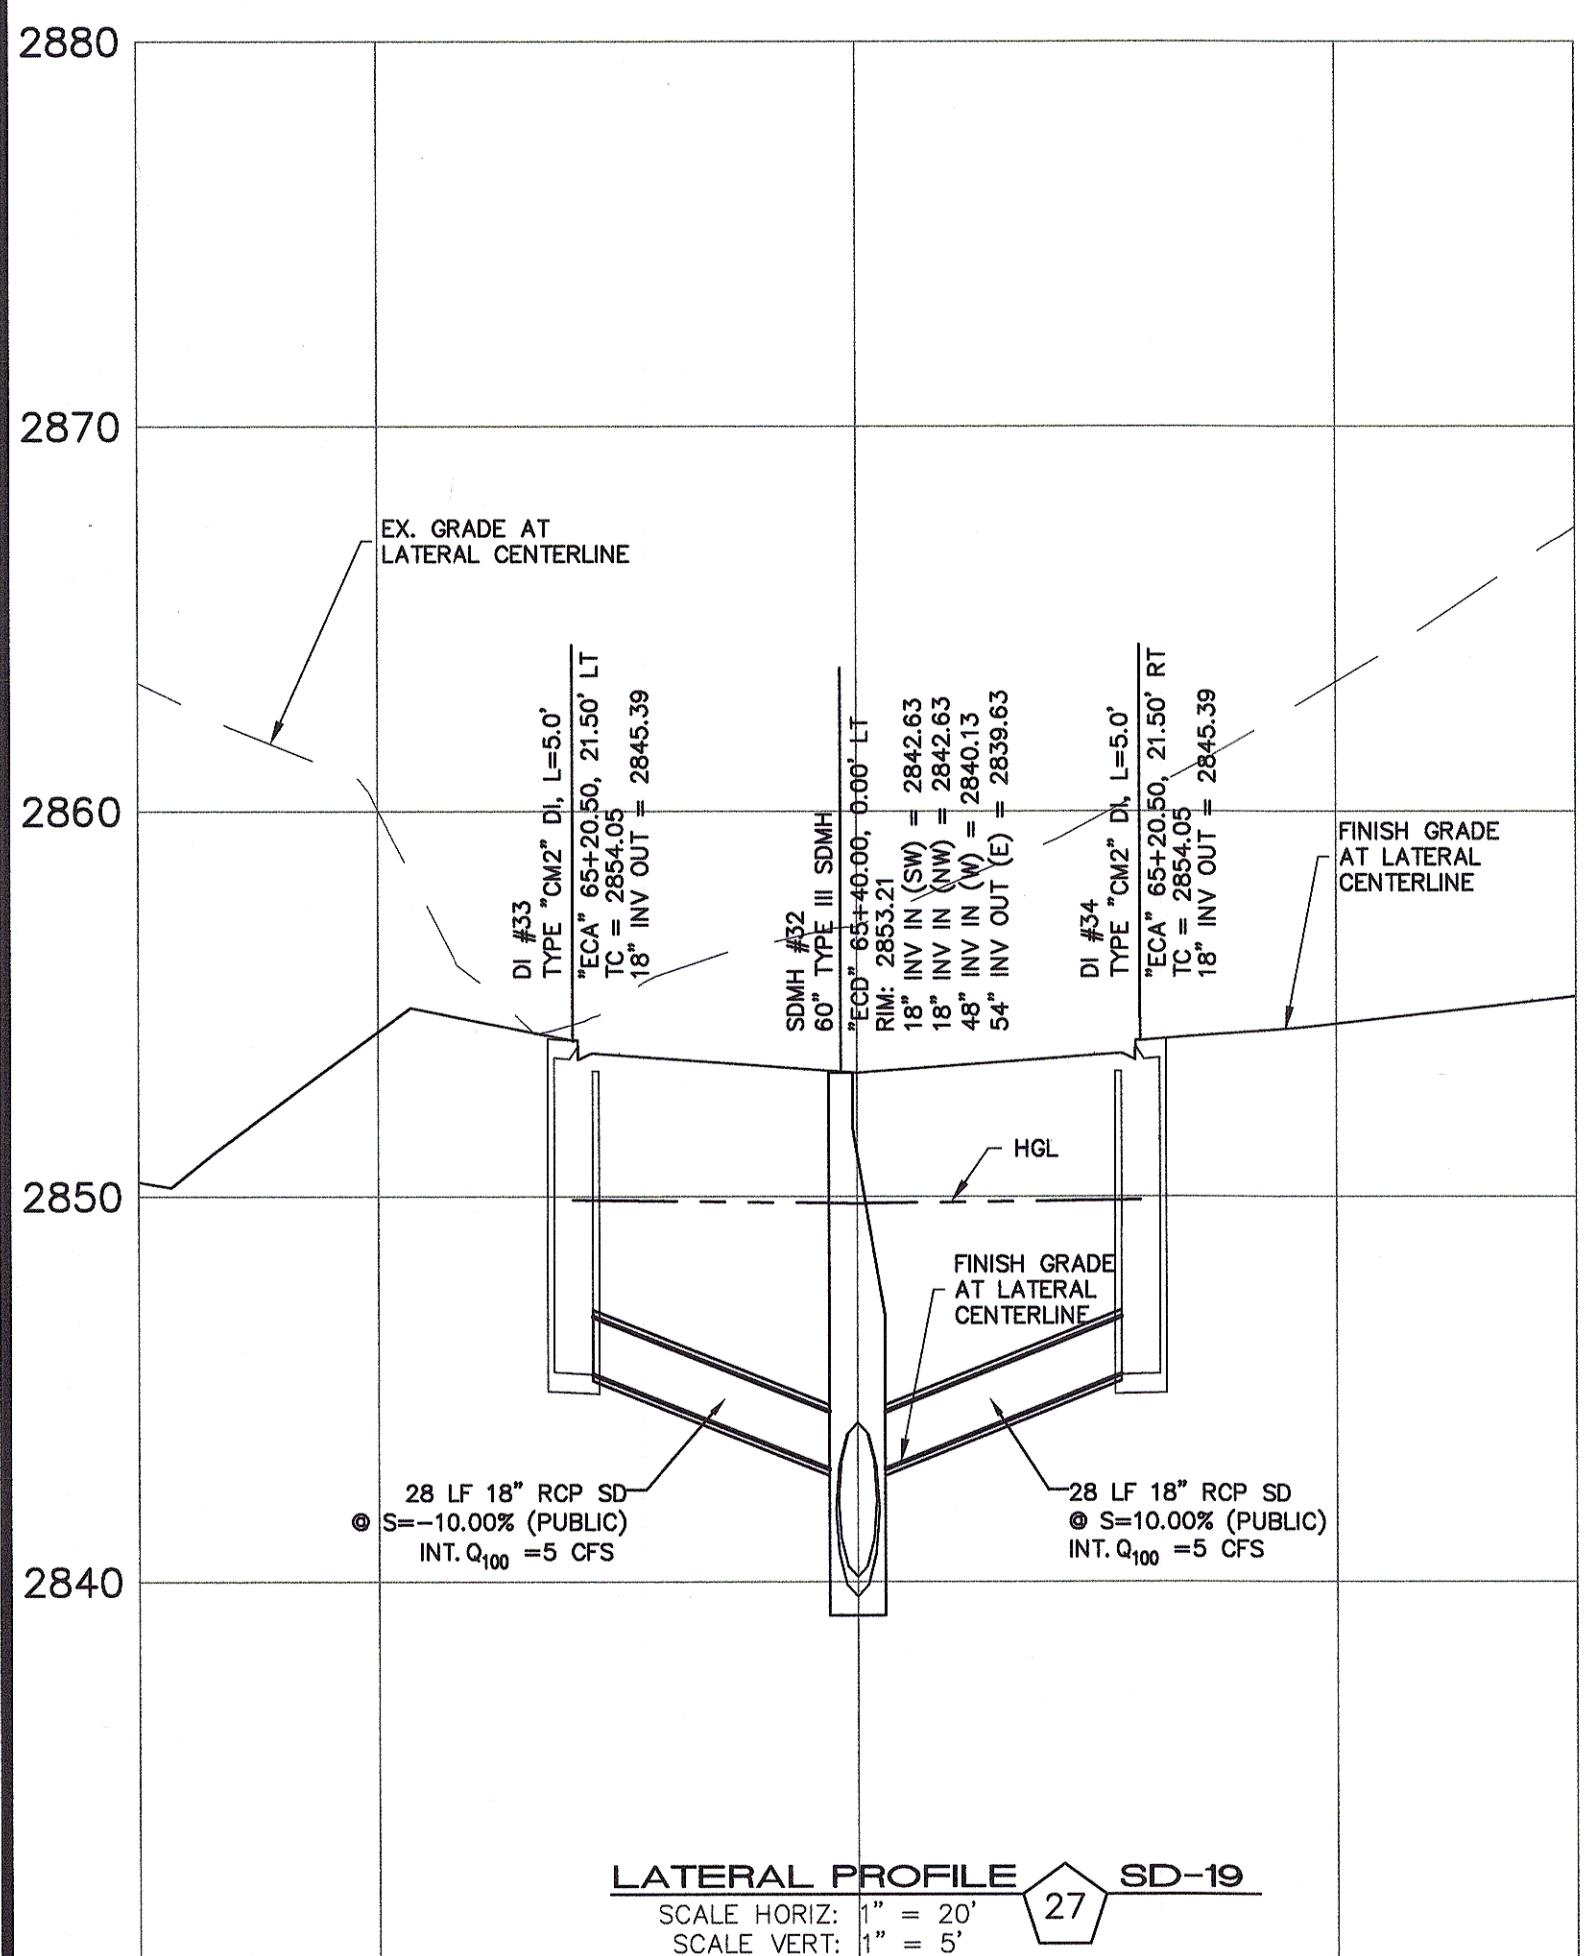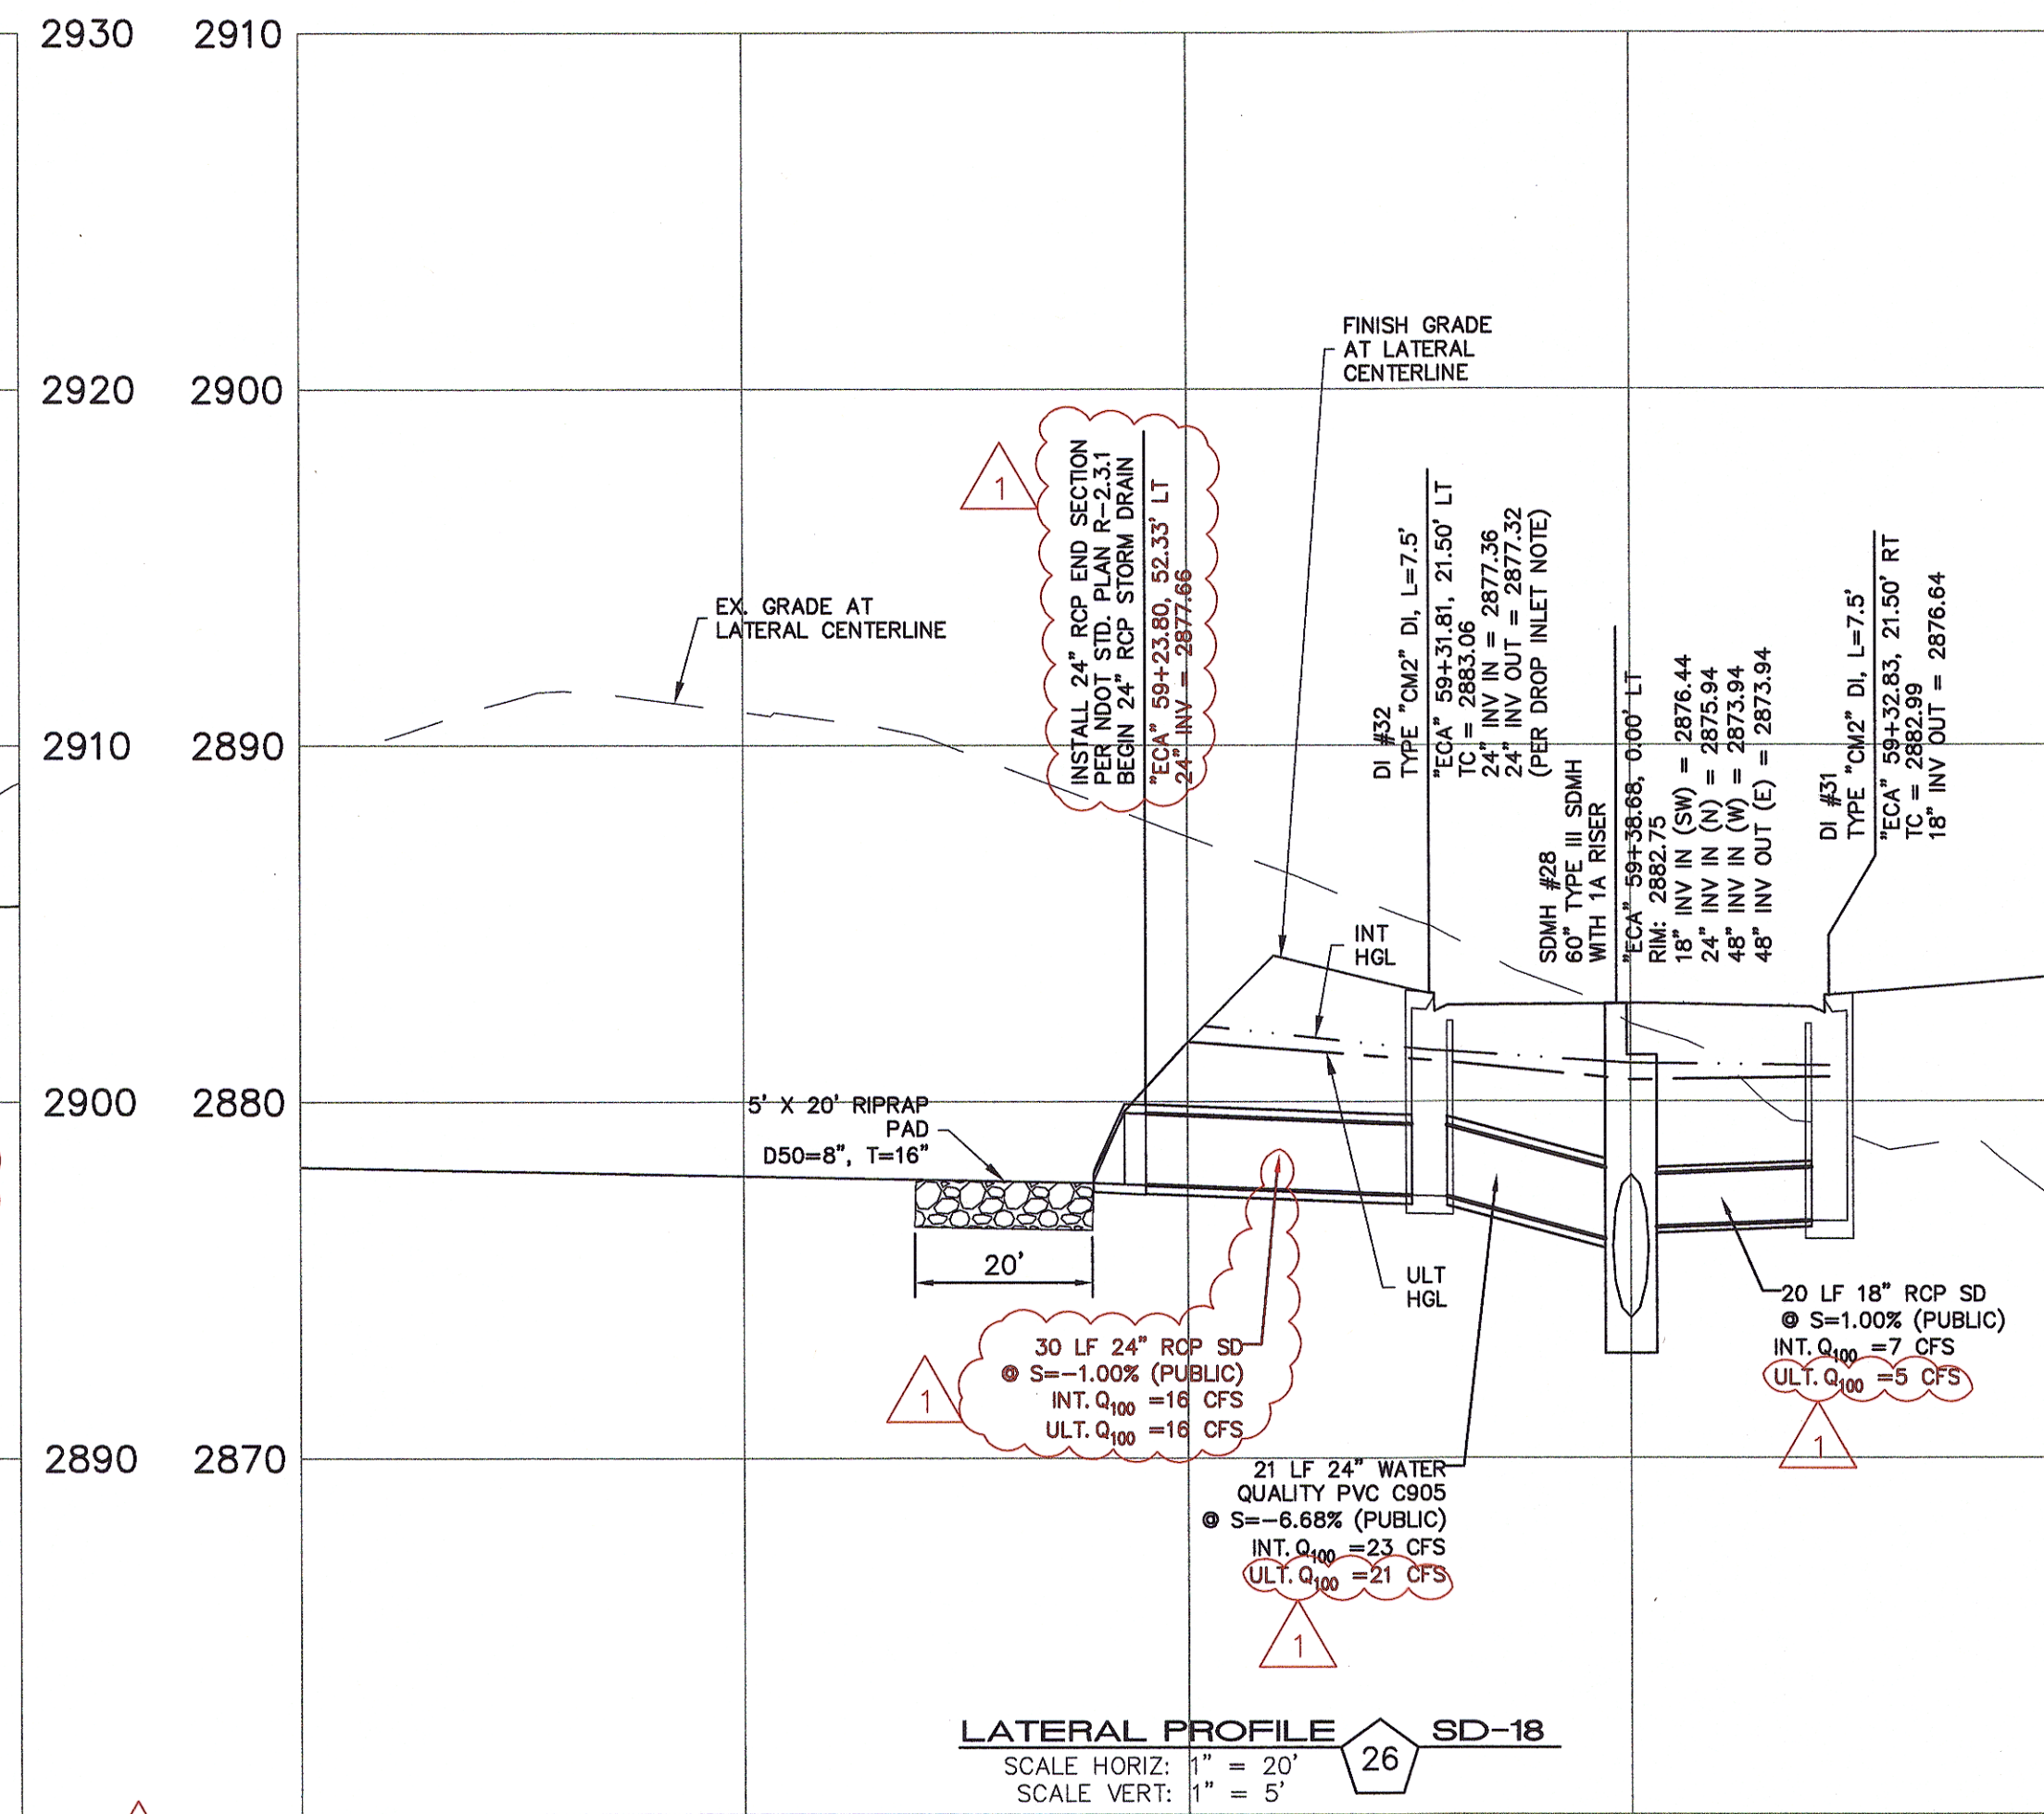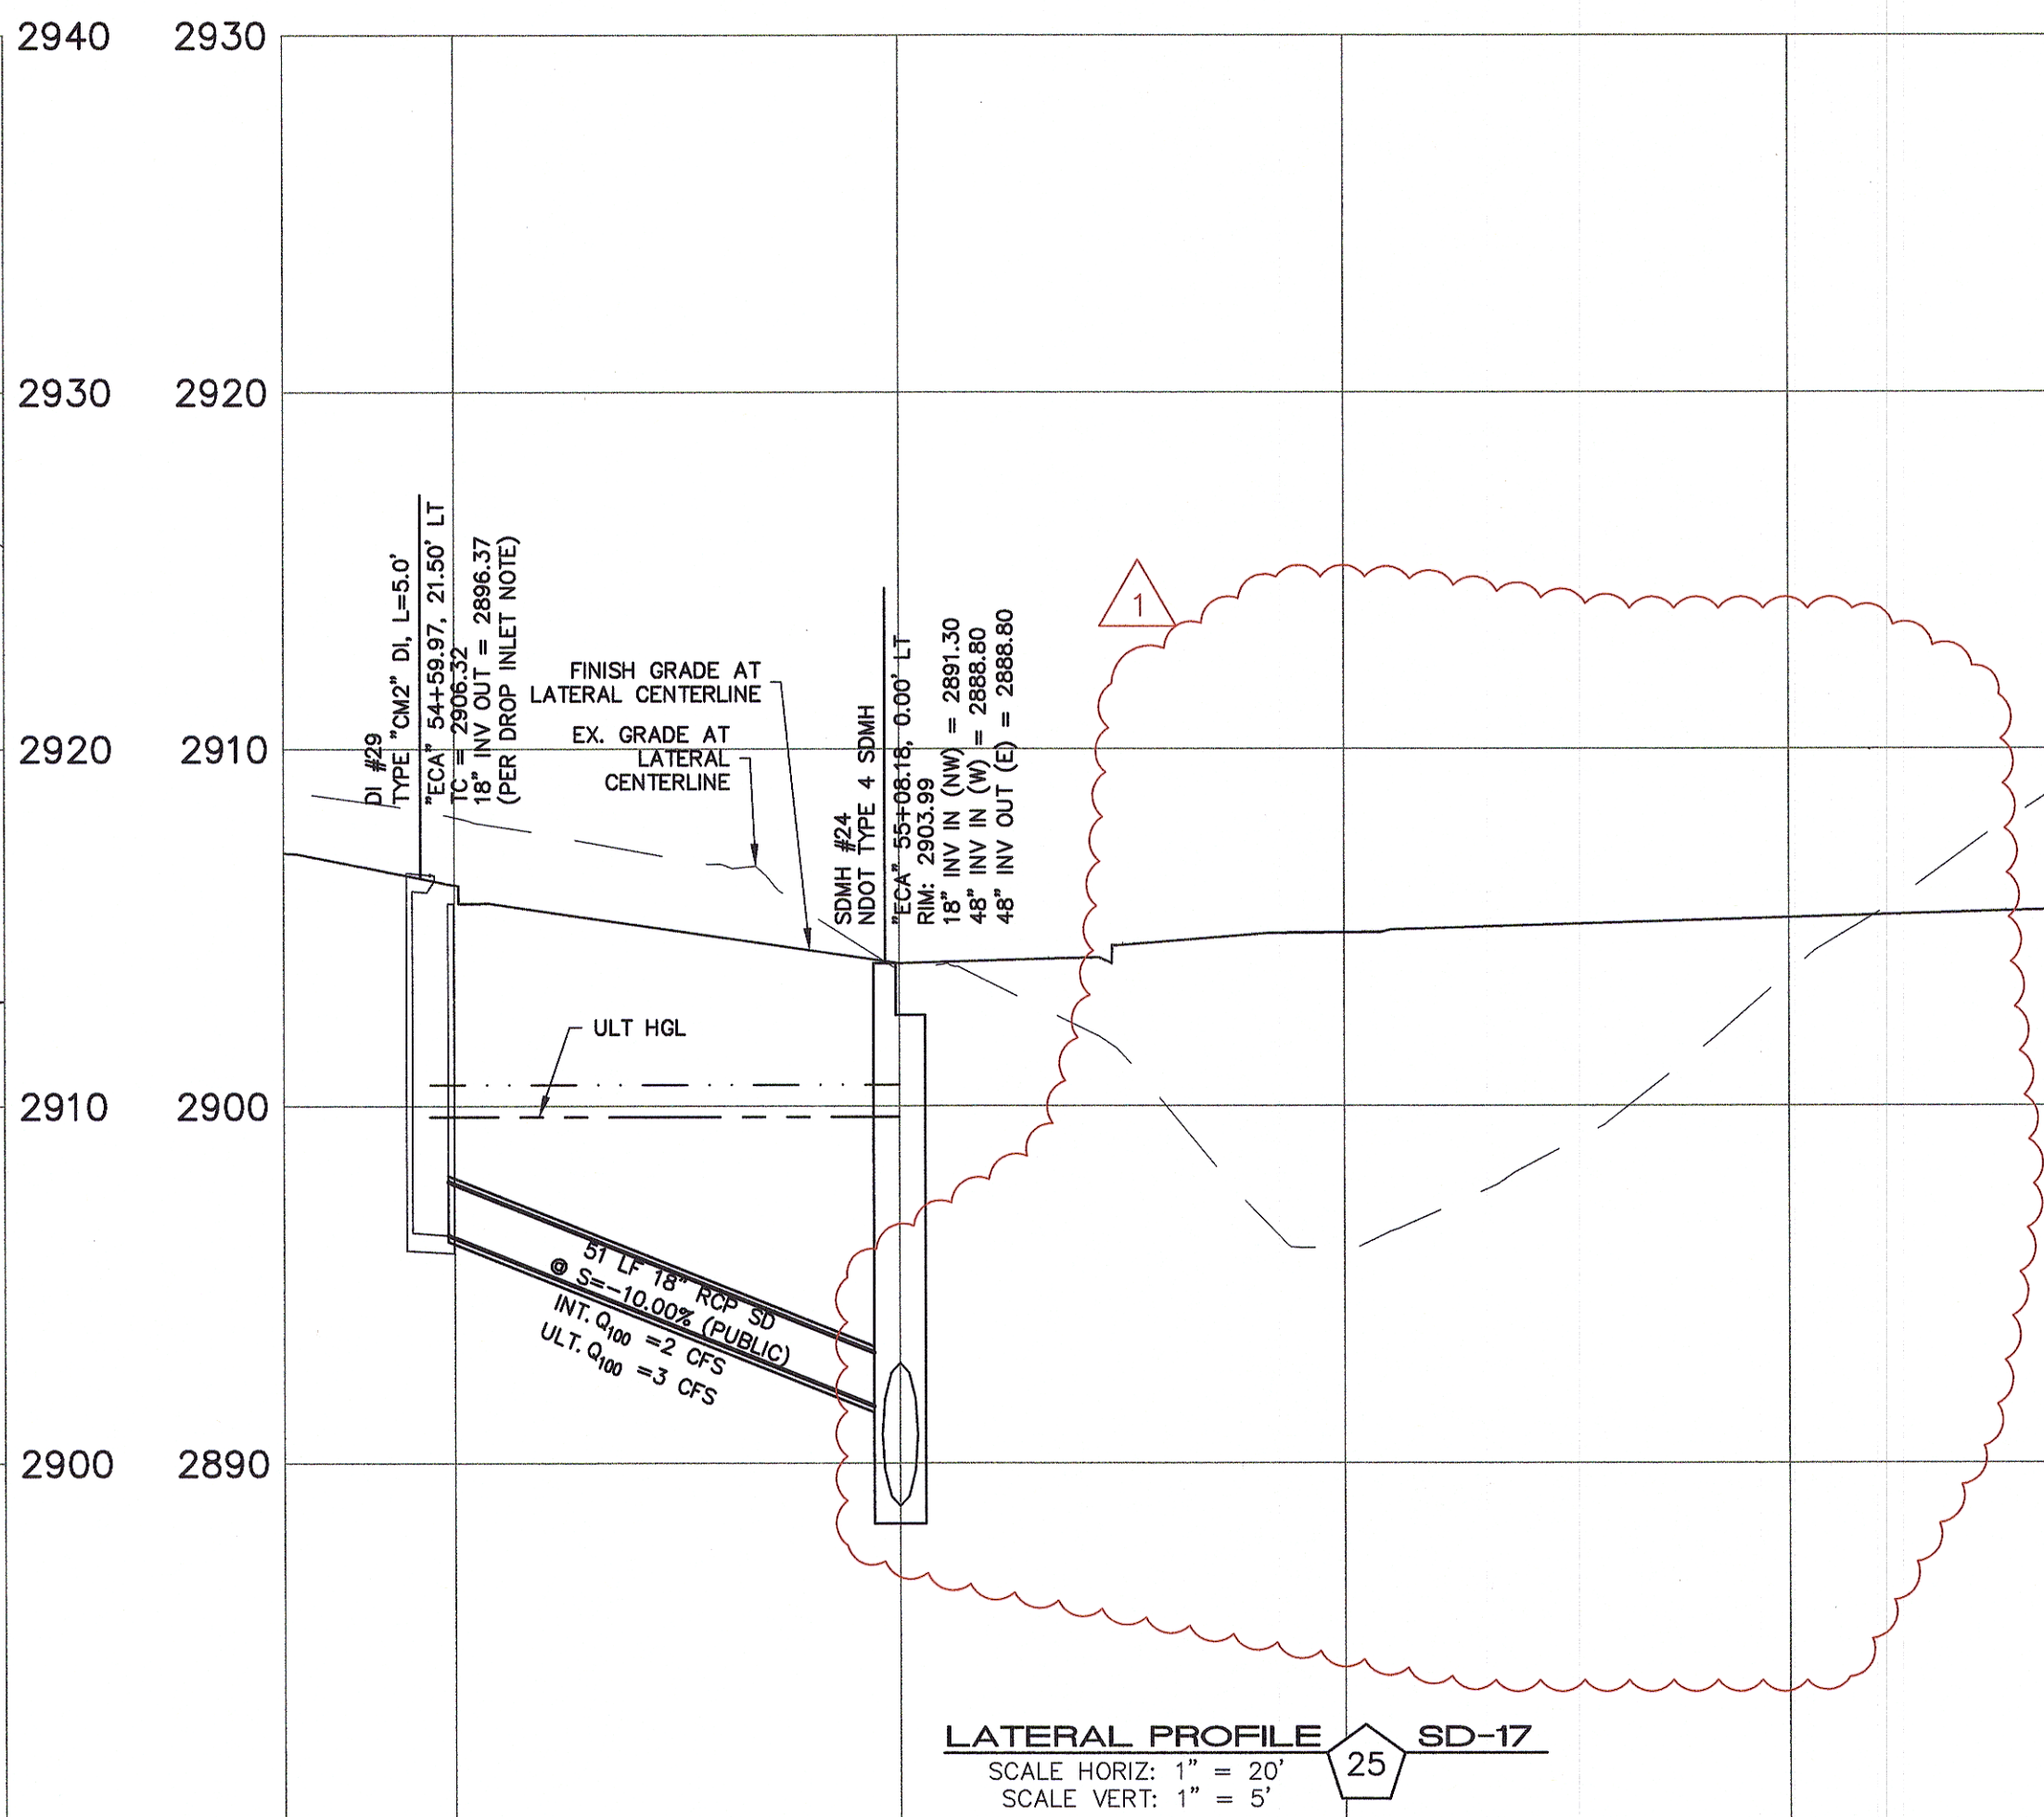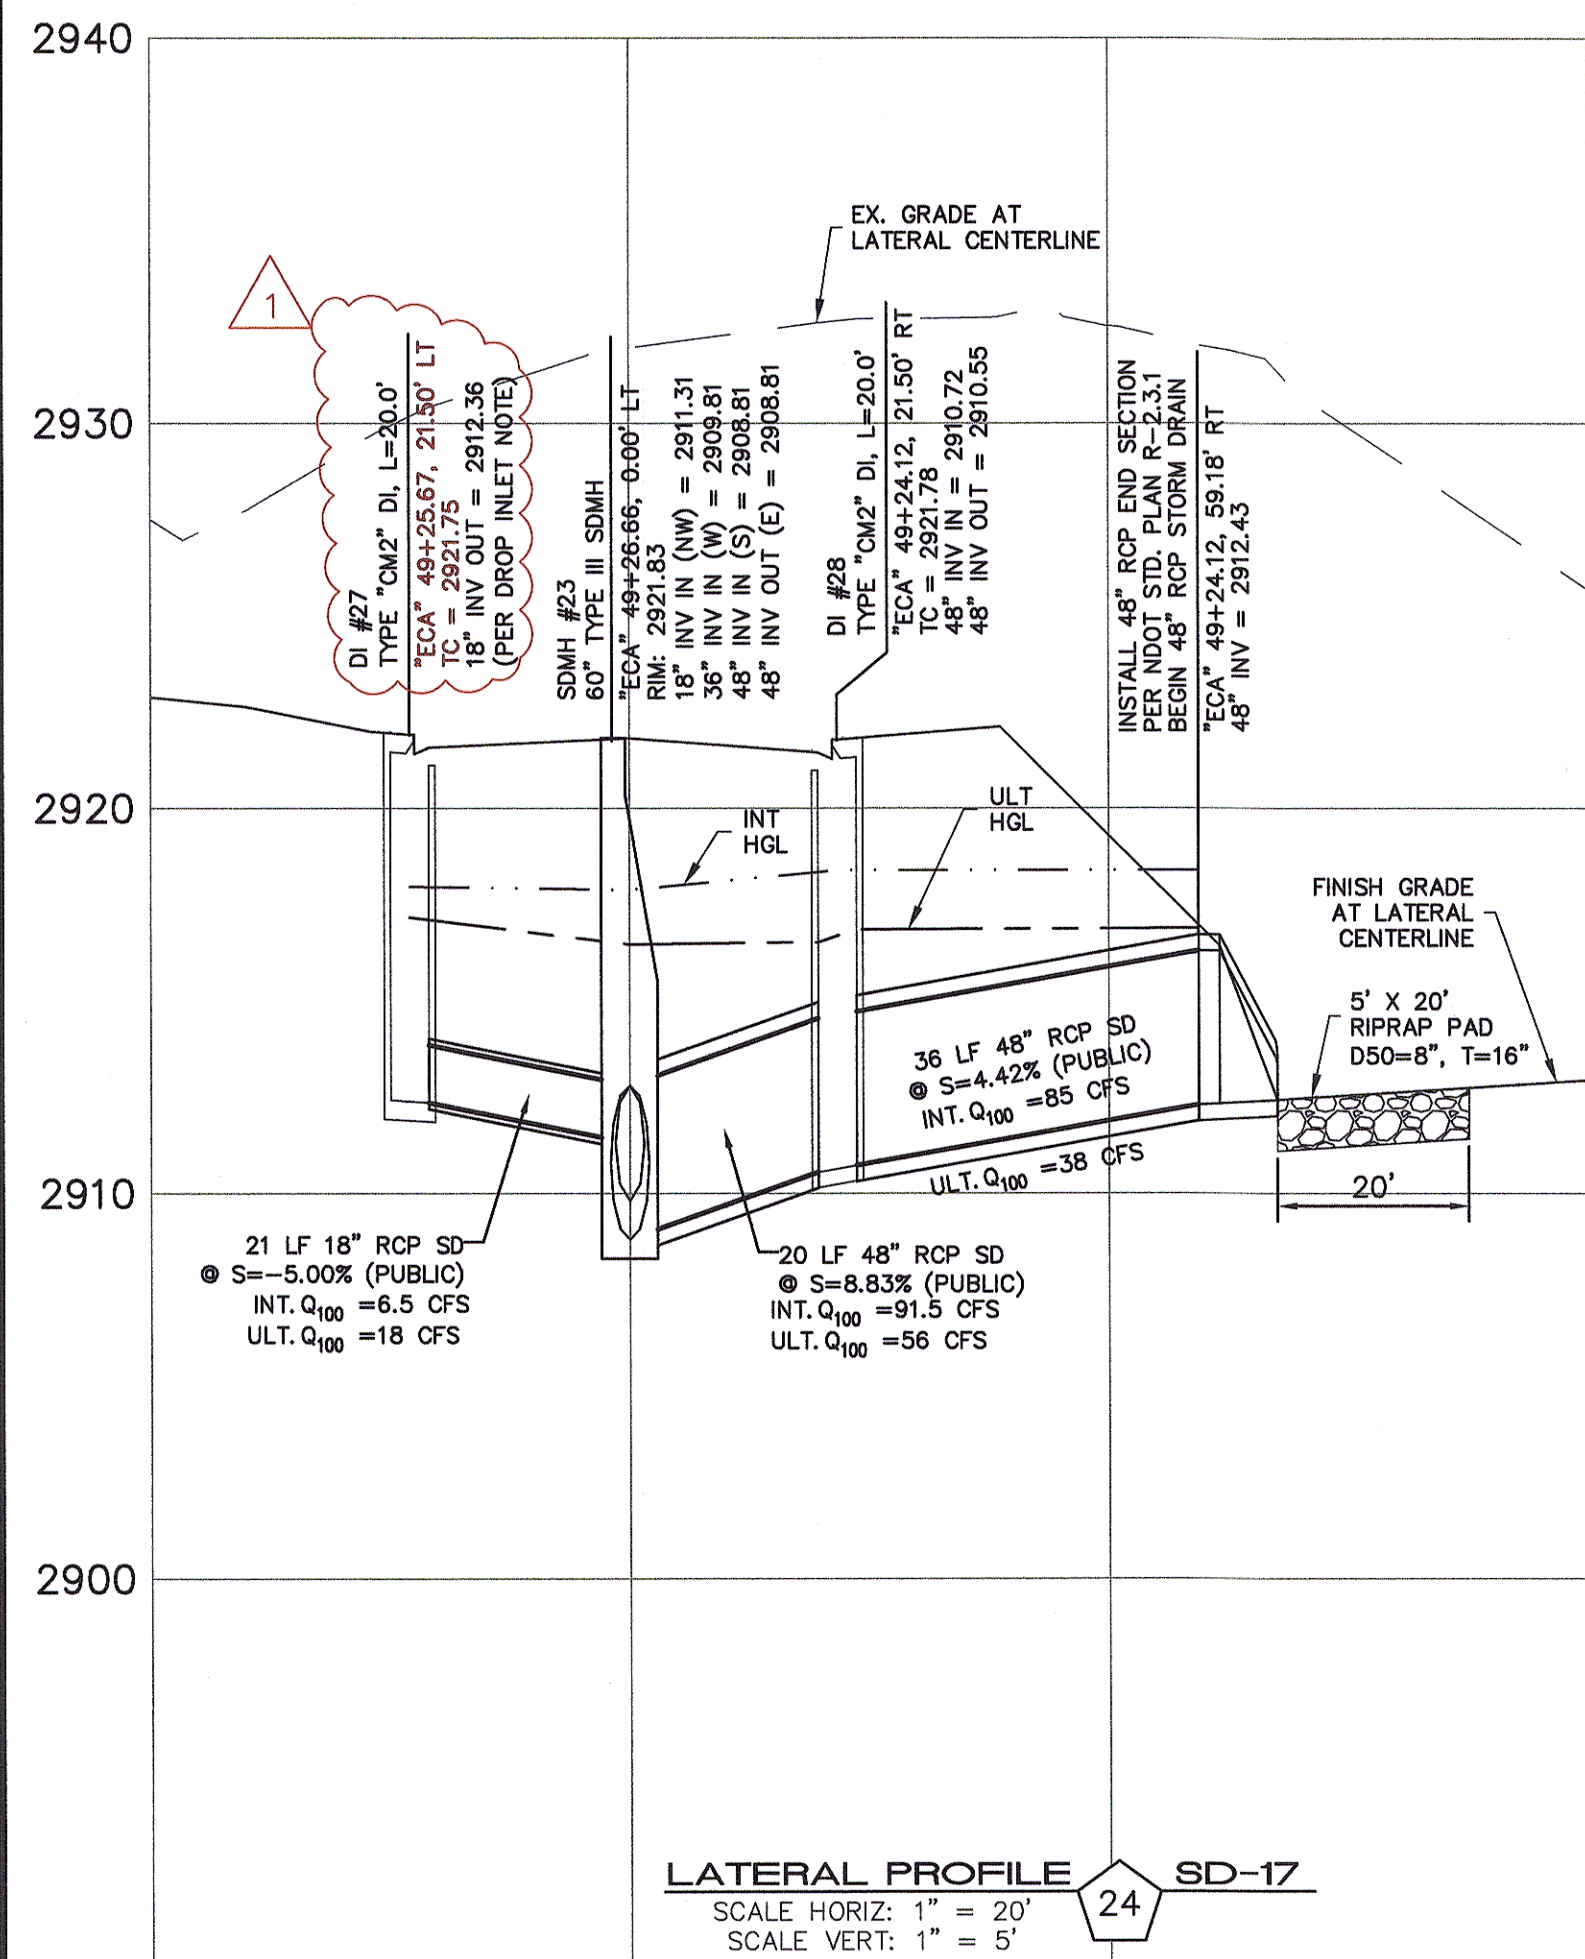

DROP INLET NOTE
WHERE 10 FEET PARALLEL SEPARATION IS NOT PRACTICABLE:
CAST-IN-PLACE MONOLITHIC POUR WITH WATERSTOP BETWEEN SLAB AND WALLS.
BASE, WALLS AND TOP TO BE CONSTRUCTED WITH WATERSTOPS, CENTER BULB,
OR FLAT STRIP (VINYLEX, GREENSTREAK PLASTIC PRODUCTS OR APPROVED EQUAL).

APPROVED FOR CONSTRUCTION
LVVMD WILL HAVE TO BE PRESENT AND VIEW INSTALLATION OF STORM DRAIN THAT WILL BE INSTALLED THAT MAY AFFECT THE WATER MAINS
DATE _____
LVVMD ENGINEERING SERVICES MANAGER

NO.	DESCRIPTION	DATE	BY	APP. DATE
1	REVISED STORM DRAIN	8/20/17	JAS	

NINETY-FIVE MANAGEMENT LLC
SKYE CANYON II PHASE 2 MASS GRADING
STORM DRAIN LATERAL PROFILES

DATE: 8/3/16
DRAFTER: JAS
DESIGNER: DAM
CHECKED: JSR
PROJECT NO. OLY1501-001

Professional Engineer Seal for Jerry J. Slater, License No. 14167, State of Nevada, Exp. 06/30/2018.

SD-24
SHEET 27 OF 32



NOTE:
PROPERTY OWNER IS RESPONSIBLE TO MAINTAIN THE BEST MANAGEMENT PRACTICES, SUCH AS BUT NOT LIMITED TO, THE REMOVAL OF ACCUMULATED SEDIMENT AND DEBRIS AND CARE OF VEGETATION.



NO.	DESCRIPTION	DATE	BY	APP.
1	REVISED STORM DRAIN	5/20/17	JAS	

NINETY-FIVE MANAGEMENT LLC
SKYE CANYON II PHASE 2 MASS GRADING
GRADING PLAN 3

DATE: 8/3/16
DRAFTER: JAS
DESIGNER: DAM
CHECKED: JSR
PROJECT NO.
OLY1501-001

